


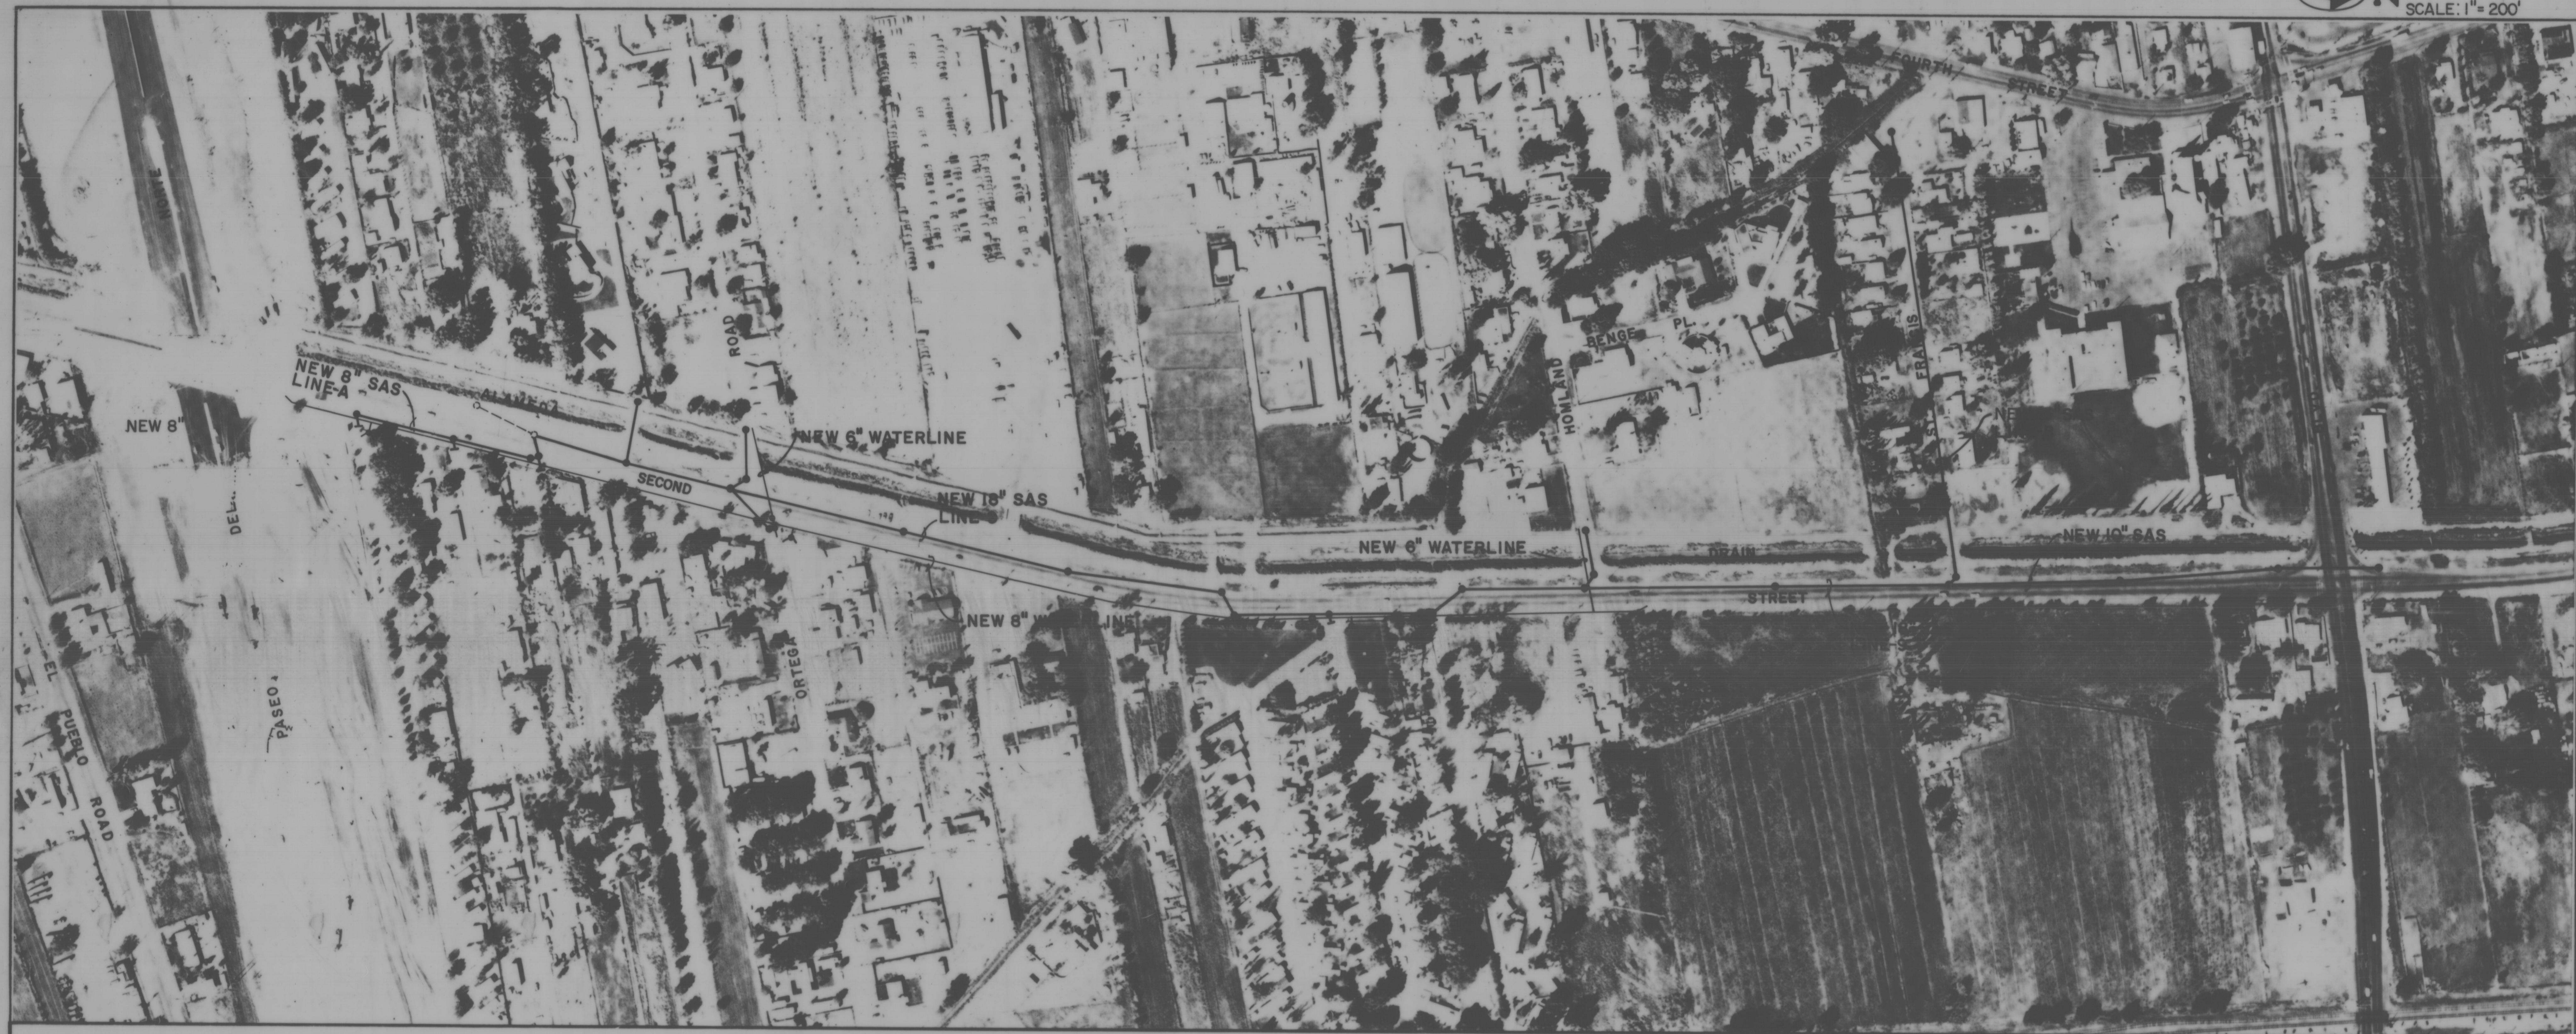

SCALE: 1"=200'

SUMMARY OF QUANTITIES

ITEM NO.	DESCRIPTION	UNIT	QUANTITY	
			ESTIMATE	FINAL
207001	SUBGRADE PREPARATION	SY.	3906	
304018	BASE COURSE - 6"	SY.	3906	
401234	PLANT MIX BITUMINOUS PAVEMENT TYPE II GRADE B - 2 1/2"	SY.	3472	
GG0002	TRENCH AND BACKFILL, 6'-10' DEPTH	LIN. FT.	367	
GG0003	TRENCH AND BACKFILL, 10'-14' DEPTH	LIN. FT.	1346	
GG0004	TRENCH AND BACKFILL, 14'-18' DEPTH	LIN. FT.	4055	
GG0005	TRENCH AND BACKFILL, OVER 18' DEPTH	LIN. FT.	70	
GG2041	MANHOLE TYPE "E" 4' DIA. 5'-6' DEPTH	EACH	1	
GG2042	MANHOLE TYPE "E" 4' DIA. 6'-10' DEPTH	EACH	1	
GG2043	MANHOLE TYPE "E" 4' DIA. 10'-14' DEPTH	EACH	8	
GG2044	MANHOLE TYPE "E" 4' DIA. 14'-18' DEPTH	EACH	18	
GG2051	MANHOLE TYPE "E" 6' DIA. 14'-18' DEPTH	EACH	1	
GG2076	VERTICAL DROP AT MANHOLE	LIN. FT.	10	
GG2090	TIE TO EXISTING MANHOLE	EACH	2	
GG3101	NEW FIRE HYDRANT	EACH	1	
GG3102	REMOVE & RESET EXISTING FIRE HYDRANT	EACH	2	
GG3103	ADJUST EXISTING FIRE HYDRANT TO GRADE	EACH	2	
GG3220	WATER SERVICE LINE, REPLACE & TRANSFER	EACH	21	

SANITARY SEWER MANHOLE SCHEDULE

ITEM NO.	DESCRIPTION	UNIT	QUANTITY	
			ESTIMATE	FINAL
GG3353	TIE TO EXISTING 6" WATERLINE	EACH	4	
GG3356	TIE TO EXISTING 8" WATERLINE	EACH	1	
GG3415	GATE VALVE - 6"	EACH	2	
GG3417	GATE VALVE - 8"	EACH	2	
GG3456	VALVE BOX W/COVER TYPE "A"	EACH	5	
GG3846	6" WATERLINE	LIN. FT.	410	
GG3848	8" WATERLINE	LIN. FT.	2850	
GG4211	18" CASING BORE & JACK	LIN. FT.	160	
GG4406	SANITARY SEWER LINE - 8"	LIN. FT.	1037	
GG4407	SANITARY SEWER LINE - 10"	LIN. FT.	694	
GG4415	SANITARY SEWER LINE - 15"	LIN. FT.	966	
GG4418	SANITARY SEWER LINE - 18"	LIN. FT.	3086	
GG4444	SANITARY SEWER SERVICE LATERAL - 4"	EACH	58	
GG4505	SANITARY SEWER LINE - 10" D.I.P.	LIN. FT.	215	
GG4465	FORCE MAIN CONNECTION AT M.H. L9-52	L.S.	1	

LOCATION	STATION	M.H. NO.	DIA.	DEPTH	
				ESTIMATE	FINAL
SECOND ST.	10+43.50	LA-1	4'	11.0	
SECOND ST.	10+72.50	LA-2	4'	10.9	
SECOND ST.	12+46.35	LA-3	4'	8.4	
SECOND ST.	14+59.13	LA-4	4'	5.9	
SECOND ST.	12+02.58	L9-38	4'	16.2	
PR DRIVE	11+23.80	L9-38A	4'	14.1	
SECOND ST.	14+51.96	L9-39	4'	16.2	
ORTEGA RD.	14+63.34	L9-39A	4'	16.0	
ORTEGA RD.	14+30.80	L9-39B	4'	14.0	
ORTEGA RD.	15+28.91	L9-39C	4'	14.1	
SECOND ST.	18+08.44	L9-40	4'	14.7	
SECOND ST.	21+66.71	L9-41	4'	15.6	
SECOND ST.	24+97.88	L9-42	4'	17.1	
SECOND ST.	25+55.77	L9-43	4'	16.7	
SECOND ST.	27+57.39	L9-44	4'	16.0	
SECOND ST.	29+77.94	L9-45	4'	14.7	
SECOND ST.	30+53.48	L9-46	4'	14.8	
SECOND ST.	33+20.10	L9-47	4'	14.5	
SECOND ST.	33+32.94	L9-47A	4'	14.7	
SECOND ST.	33+12.85	L9-47B	4'	14.2	
SECOND ST.	37+15.26	L9-48	4'	16.1	
SECOND ST.	40+85.95	L9-49	6'	15.5	
SECOND ST.	44+43.84	L9-50	4'	12.9	
SECOND ST.	47+79.62	L9-51	4'	13.0	
SECOND ST.	49+24.23	L9-52	4'	12.4	
ST. FRANCIS	10+10.00	L9-1	4'	15.8	
ST. FRANCIS	12+70.00	L9-2	4'	13.2	
ST. FRANCIS	15+43.36	L9-3	4'	13.0	
ST. FRANCIS	19+68.38	L9-4	4'	13.4	

C of A PWD Maps & Records
1 2 3 4 5 6 7 8 9 10 11 12
26 34 73 11 9 1

RECORD DRAWING
DATE 2-4-84
Slin J. Mito

CITY OF ALBUQUERQUE
MUNICIPAL DEVELOPMENT DEPARTMENT
ENGINEERING DIVISION

TITLE:
VICINITY MAP & SUMMARY OF QUANTITIES

APPROVALS	ENGINEER	DATE	APPROVALS	ENGINEER	DATE
City Engineer	NA		Liquid Waste	NA	3/24/88
A.C.E. - Design	NA		Traffic	NA	
A.C.E. - Hydrology	NA		Water	NA	5/24/88

DRAWING NO. MAP NO. C-16 SHEET 12-1 OF

1 ALL WORK DETAILED ON THESE UTILITY PLANS TO BE PERFORMED UNDER CONTRACT SHALL, EXCEPT AS OTHERWISE STATED OR PROVIDED FOR HEREON, BE CONSTRUCTED IN ACCORDANCE WITH CITY OF ALBUQUERQUE STANDARD SPECIFICATIONS FOR PUBLIC WORKS CONSTRUCTION, 1986 EDITION.

- 2 ALL WORK WHICH IS PERFORMED FOR THE CITY OF ALBUQUERQUE SHALL CONFORM TO THE LATEST REVISION OF ALL ORDINANCES, INCLUDING THE BUILDING CODE. THE REQUIREMENTS OF THESE ORDINANCES ARE MANDATORY, INCLUDING ALL NECESSARY LICENSING. THE FOLLOWING ORDINANCES, ALTHOUGH ONLY A PARTIAL LIST, ARE PARTICULARLY IMPORTANT FOR CONTRACTS WITHIN THE PUBLIC RIGHT-OF-WAY:

REVISED ORDINANCES OF ALBUQUERQUE, NEW MEXICO, 1974

CHAPTER 6 - HEALTH, SAFETY, AND SANITATION

ARTICLE III - REFUSE COLLECTION
ARTICLE XXII - NOISE CONTROL

CHAPTER 8 - WATER, SEWER, AND STREETS

ARTICLE VI - SIDEWALKS
ARTICLE VII - STREET EXCAVATIONS
ARTICLE XVI - WATER WASTE

- 3 ALL PERMITS REQUIRED FOR CONSTRUCTION AND COMPLETION OF THIS PROJECT WHICH INCLUDE, BUT ARE NOT LIMITED TO, EXCAVATION PERMITS FOR ALL SEWER LINES, WATER LINES, AND WATER SERVICE LINE CONSTRUCTION SHALL BE OBTAINED BY THE CONTRACTOR. NO REIMBURSEMENT TO THE CONTRACTOR WILL BE MADE FOR ANY PERMIT FEES OR COSTS. ALL COSTS AND FEES FOR PERMITS SHALL BE PAID BY THE CONTRACTOR AND SHALL BE CONSIDERED INCIDENTAL TO THE COMPLETION OF THE WORK.

- 4 EXCAVATION PERMITS FOR EACH NEW SANITARY SEWER HOUSE SERVICE LATERAL SHALL BE OBTAINED FROM THE CITY, AS SPECIFIED IN THE STREET EXCAVATION ORDINANCE, CHAPTER 8, ARTICLE VII, REVISED ORDINANCE OF ALBUQUERQUE, NEW MEXICO, 1974, BY THE PLUMBING CONTRACTOR DOING THE WORK FOR THE PRIME CONTRACTOR.

- 5 A TOPSOIL DISTURBANCE PERMIT IS REQUIRED. IT MAY BE OBTAINED BY THE CONTRACTOR FROM THE OFFICES OF THE ENVIRONMENTAL HEALTH GROUP, 1 CIVIL PLAZA, S.W. THERE IS NO CHARGE.

- 6 THE CONTRACTOR SHALL PROVIDE CONSTRUCTION STAKING AND SURVEYING FROM BASELINES, GRADES, AND BENCH MARKS SHOWN ON THE PLANS, OR MODIFIED IN THE FIELD BY THE ENGINEER, FOR ALL ITEMS OF WORK WHICH REQUIRE CONSTRUCTION STAKING AND SURVEYING. NOTE THAT THE UTILITY SURVEY CONTROL POINTS SHOWN ON THE UTILITY DRAWINGS ARE INDEPENDENT OF THE ROADWAY SURVEY CONTROL POINTS. THIS WORK SHALL INCLUDE, BUT NOT BE LIMITED TO, ALL SEWER LINES, WATER LINES, AND SERVICE LINES. ALL COSTS INCURRED IN PROVIDING SUCH CONSTRUCTION STAKING AND SURVEYING WORK SHALL BE CONSIDERED INCIDENTAL TO THE PROJECT.

- 7 THE CONTRACTOR SHALL BE RESPONSIBLE FOR ADJUSTING ALL NEW MANHOLES TO THE NEW FINISH GRADE. THE NEW MANHOLES DETAILED ON THESE UTILITY PLANS HAVE BEEN SHOWN TO THE EXISTING SURFACE AND NOT TO THE NEW PROFILE GRADE. FOR THE CONTRACTOR'S CONVENIENCE, A SANITARY SEWER MANHOLE SCHEDULE HAS BEEN PROVIDED ON SHEET 10 OF THIS DRAWING. THE CONTRACTOR SHALL VERIFY THE SANITARY SEWER MANHOLES IN RELATION TO THE NEW PROFILE GRADE. THESE DEPTHS SCHEDULED ARE FROM INVERT TO RIM ELEVATION. ANY FIELD CHANGE OR MINOR DEVIATION FROM THE ROADWAY PLANS WILL AFFECT THESE DIMENSIONS. THEREFORE, THE CONTRACTOR SHALL USE THESE MEASUREMENTS AS A GUIDE, BUT SHOULD ALLOW FOR MINOR ADJUSTMENTS.

- 8 ANY EXISTING DRAINAGE STRUCTURES, CULVERTS, ETC., DAMAGED OR REMOVED BY THE CONTRACTOR DURING CONSTRUCTION ACTIVITIES SHALL BE REINSTALLED OR REPLACED TO PROVIDE AN EQUAL OR BETTER STRUCTURE AT NO ADDITIONAL COST TO THE OWNER.

- 9 IT IS POSSIBLE THAT FIELD CONDITIONS MAY REQUIRE CHANGES TO SOME OF THE NEW
SEWER SERVICE LINES SHOWN ON THE DRAWINGS. THE OWNER RESERVES THE RIGHT TO
DIRECT THE CONTRACTOR TO REVISE THE LOCATION OF SUCH SEWER SERVICE LINES AT
NO ADDITIONAL COST TO THE OWNER.

- 10 THE CONTRACTOR SHALL BE RESPONSIBLE FOR DETERMINING, IN ADVANCE OF HIS
CONSTRUCTION OPERATIONS, IF OVERHEAD UTILITY LINES, SUPPORT STRUCTURES,
POLES, GUYS, ETC., ARE AN OBSTRUCTION TO CONSTRUCTION OPERATIONS. IF ANY
OBSTRUCTION TO CONSTRUCTION OPERATIONS IS EVIDENT, THE CONTRACTOR SHALL BE
RESPONSIBLE FOR COORDINATING WITH THE APPROPRIATE UTILITY COMPANY TO
SUPPORT, REMOVE, OR RELOCATE THE UTILITY OBSTRUCTION.

- 11 GAS, ELECTRIC, AND TELEPHONE UNDERGROUND UTILITIES: THE CONTRACTOR SHALL BE RESPONSIBLE FOR MAINTAINING THE INTEGRITY OF ALL UNDERGROUND UTILITIES AND FOR COORDINATING WITH THE APPROPRIATE UTILITY COMPANY TO COMPLY WITH ANY SPECIAL REQUIREMENTS IMPOSED DURING THE CONSTRUCTION OF THESE UTILITY IMPROVEMENTS. IT WILL BE NECESSARY AT TIMES TO SUPPORT EXISTING UNDERGROUND UTILITIES DURING TRENCHING OPERATIONS. THE CONTRACTOR SHALL TAKE THE NECESSARY MEASURES TO PROTECT AND SUPPORT THESE EXISTING UTILITIES. DAMAGES ASSOCIATED WITH THIS WORK SHALL BE CONSID-
12 ERED INCIDENTAL TO THE TRENCHING AND BACKFILLING WORK ITEMS OF THE BID PROPOSAL. THE CONTRACTOR SHALL EXERCISE SPECIAL CARE WHEN WORKING NEAR THE TELEPHONE FIBER-OPTIC CABLE.

- 22 THE CONNECTION THE EXISTING 6" SANITARY SEWER FORCEMAIN TO MANHOLE 19-52 SHALL BE COMPLETED ONLY AFTER ALL OF LINE 9 SANITARY SEWER HAS BEEN TESTED AND ACCEPTED BY THE CITY OF ALBUQUERQUE. BEFORE INTERRUPTION OF THE LIFT STATION OPERATION, THE CONTRACTOR SHALL BE COMPLETELY PREPARED TO MAKE THE CONNECTION IN ORDER TO MAINTAIN THE LIFT STATION OPERATION. THE CONTRACTOR SHALL PERFORM THIS CONNECTION DURING "OFF-PEAK" OPERATION OF THE STATION TO ALLOW AS MUCH TIME AS POSSIBLE FOR THE CONNECTION; HOWEVER, IF THE LIFT STATION WELL WELL REQUIRES EVACUATION WHILE WORK IS BEING PERFORMED ON THE CONNECTION, THE CONTRACTOR SHALL BE HELD RESPONSIBLE TO TAKE NECESSARY MEASURES THE PUMP THE SEWAGE FROM THE LIFT STATION WELL.

- 13 DURING TRENCHING OPERATIONS ON ORTEGA ROAD, HOMLAND ROAD, AND ST. FRANCIS ROAD, THE FULL WIDTH OF EXISTING ASPHALT PAVEMENT SHALL BE REMOVED. NO SEPARATE MEASUREMENT OR PAYMENT SHALL BE MADE FOR THIS REMOVAL. PAYMENT SHALL BE INCLUDED IN THE APPLICABLE TRENCHING AND BACKFILLING ITEM DEFINED IN THE BID PROPOSAL.

- 14 STREET CENTERLINE GRADES ON ORTEGA ROAD, HOWLAND ROAD, AND ST. FRANCIS ROAD SHALL BE RESTORED BY THE CONTRACTOR TO THE EXISTING CENTERLINE GRADES UNLESS OTHERWISE DIRECTED BY THE ENGINEER. INTERSECTIONS, CURBS, AND OTHER SURFACE IMPROVEMENTS SHALL BE RESTORED BY THE CONTRACTOR TO THE EXISTING LOCATIONS AND GRADES. EXISTING IRREGULARITIES SUCH AS BUMPS AND DIPS IN THE PAVING SHALL NOT BE RESTORED AND SMOOTH TRANSITIONS SHALL BE MADE BETWEEN EXISTING PAVEMENT WHICH REMAINS IN PLACE AND PAVEMENT WHICH IS BEING REPLACED.



- 15 THE TYPICAL ROADWAY REPLACEMENT SECTION SHOWN ON SHEET 12-7 OF THESE UTILITY DRAWINGS SHALL BE UTILIZED FOR THE PAVEMENT REPLACEMENT ON ORTEGA ROAD, HOMLAND ROAD, AND ST. FRANCIS ROAD ONLY, AND DOES NOT APPLY TO ANY WORK PERFORMED IN SECOND STREET RIGHT-OF-WAY.

- 16 ALL TEMPORARY WATERLINE AND TEMPORARY CAPPING AND BLOCKING OF EXISTING
WATERLINE REQUIRED FOR THE INSTALLATION OF THE NEW WATERLINE SHALL BE
CONSIDERED INCIDENTAL TO THE PROJECT.

NOTE:
ALL REFERENCE TO "ENGINEER" ON
THESE UTILITY PLANS MEANS PROJECT MANAGER

— 1 —	CENTER LINE OF SURVEY
— Z'NFG —	EXISTING GAS LINE
— FOUGT —	EXISTING FIBER-OPTICS TELEPHONE LINE
— G"AC — W —	EXISTING WATER LINE
— UST —	EXISTING UNDERGROUND TELEPHONE LINE
— — —	PROPERTY OR RIGHT-OF-WAY LINE
	NEW SEWER AND SERVICE LINE
	WATER VALVE
	FIRE HYDRANT
	POWER POLE
	TELEPHONE MANHOLE
	EXISTING MANHOLE
	NEW MANHOLE
	NAIL AND SHINER
	REFERENCE POINT
	CORRUGATED METAL PIPE
	MONUMENT
	PAVEMENT
	MANHOLE
	RIGHT-OF-WAY
	WATER METER

4#T	HUB AND TACK
PI.	POINT OF INTERSECTION
MRSQD	MIDDLE RO GRANDE CONSERVANCY DISTRICT
SHTS	SHEETS
COMP	COMPACTED
BIT.	BITUMINOUS
IN.	INCH
DIA.	DIAMETER
MIN.	MINIMUM
M.J.	MECHANICAL JOINT
RCP	REINFORCED CONCRETE PIPE
STA.	STATION
INV EL.	INVERT ELEVATION
DIP	DUCTILE IRON PIPE
MAX.	MAXIMUM

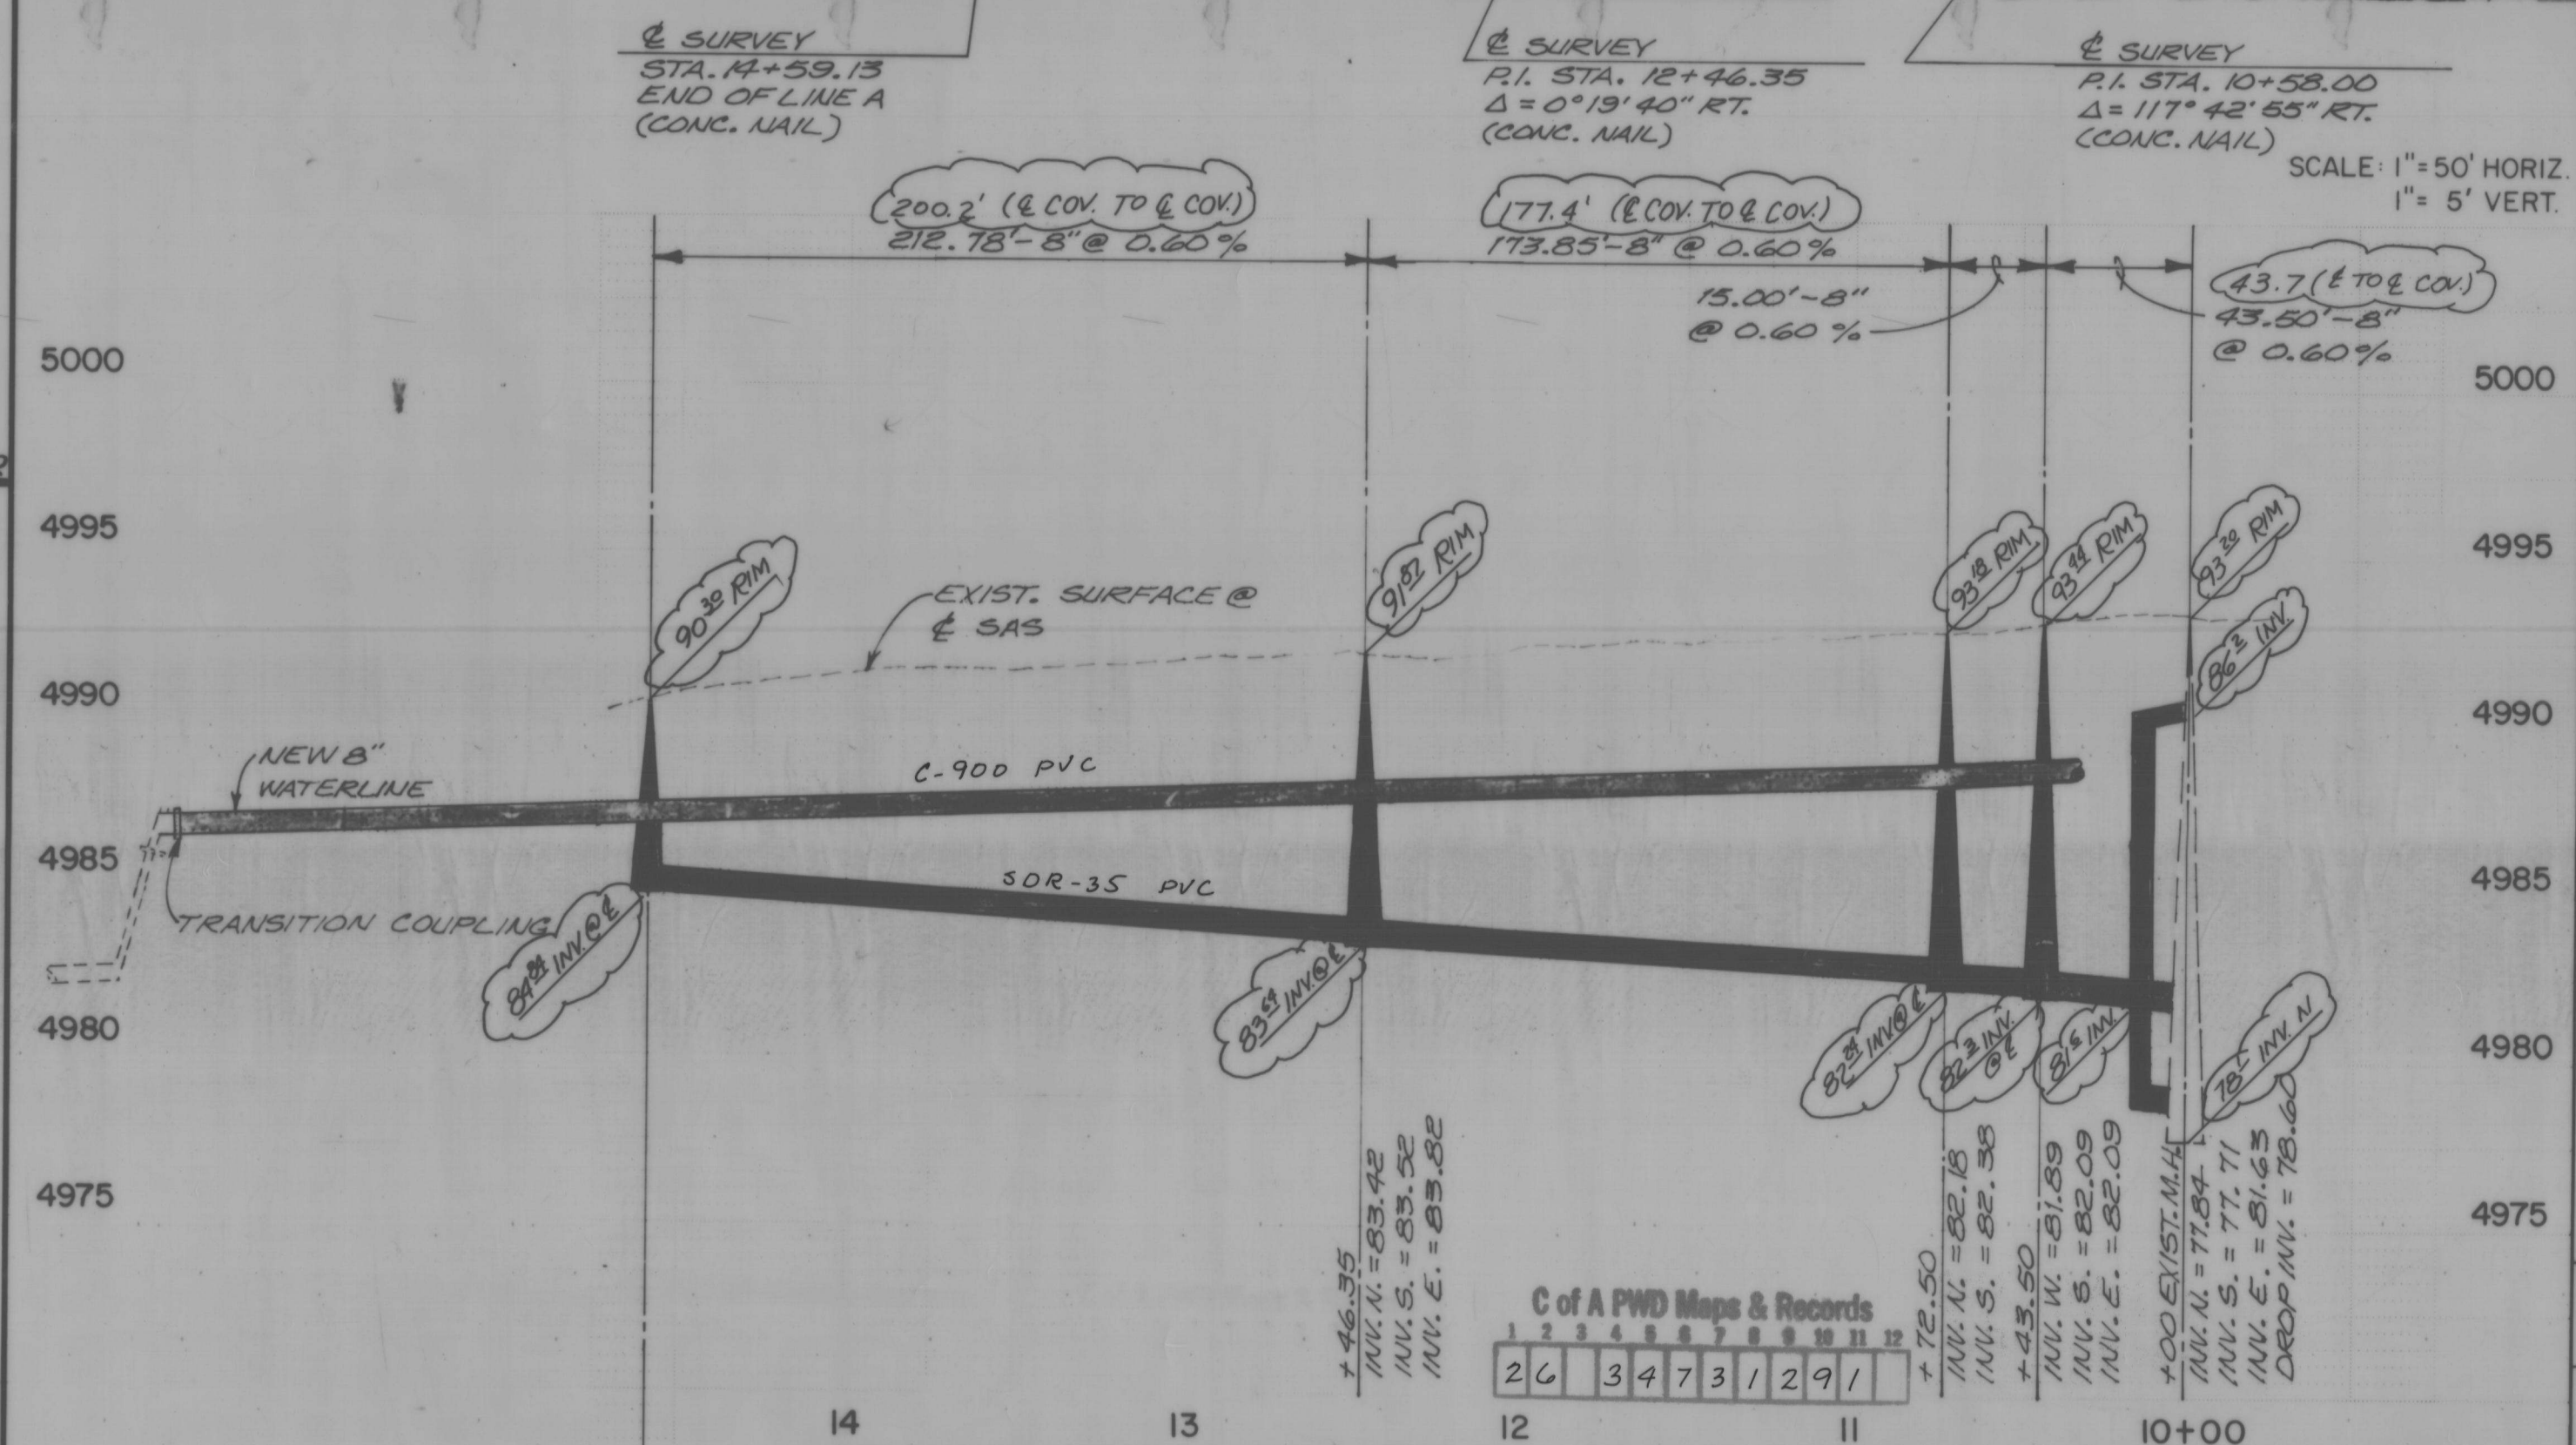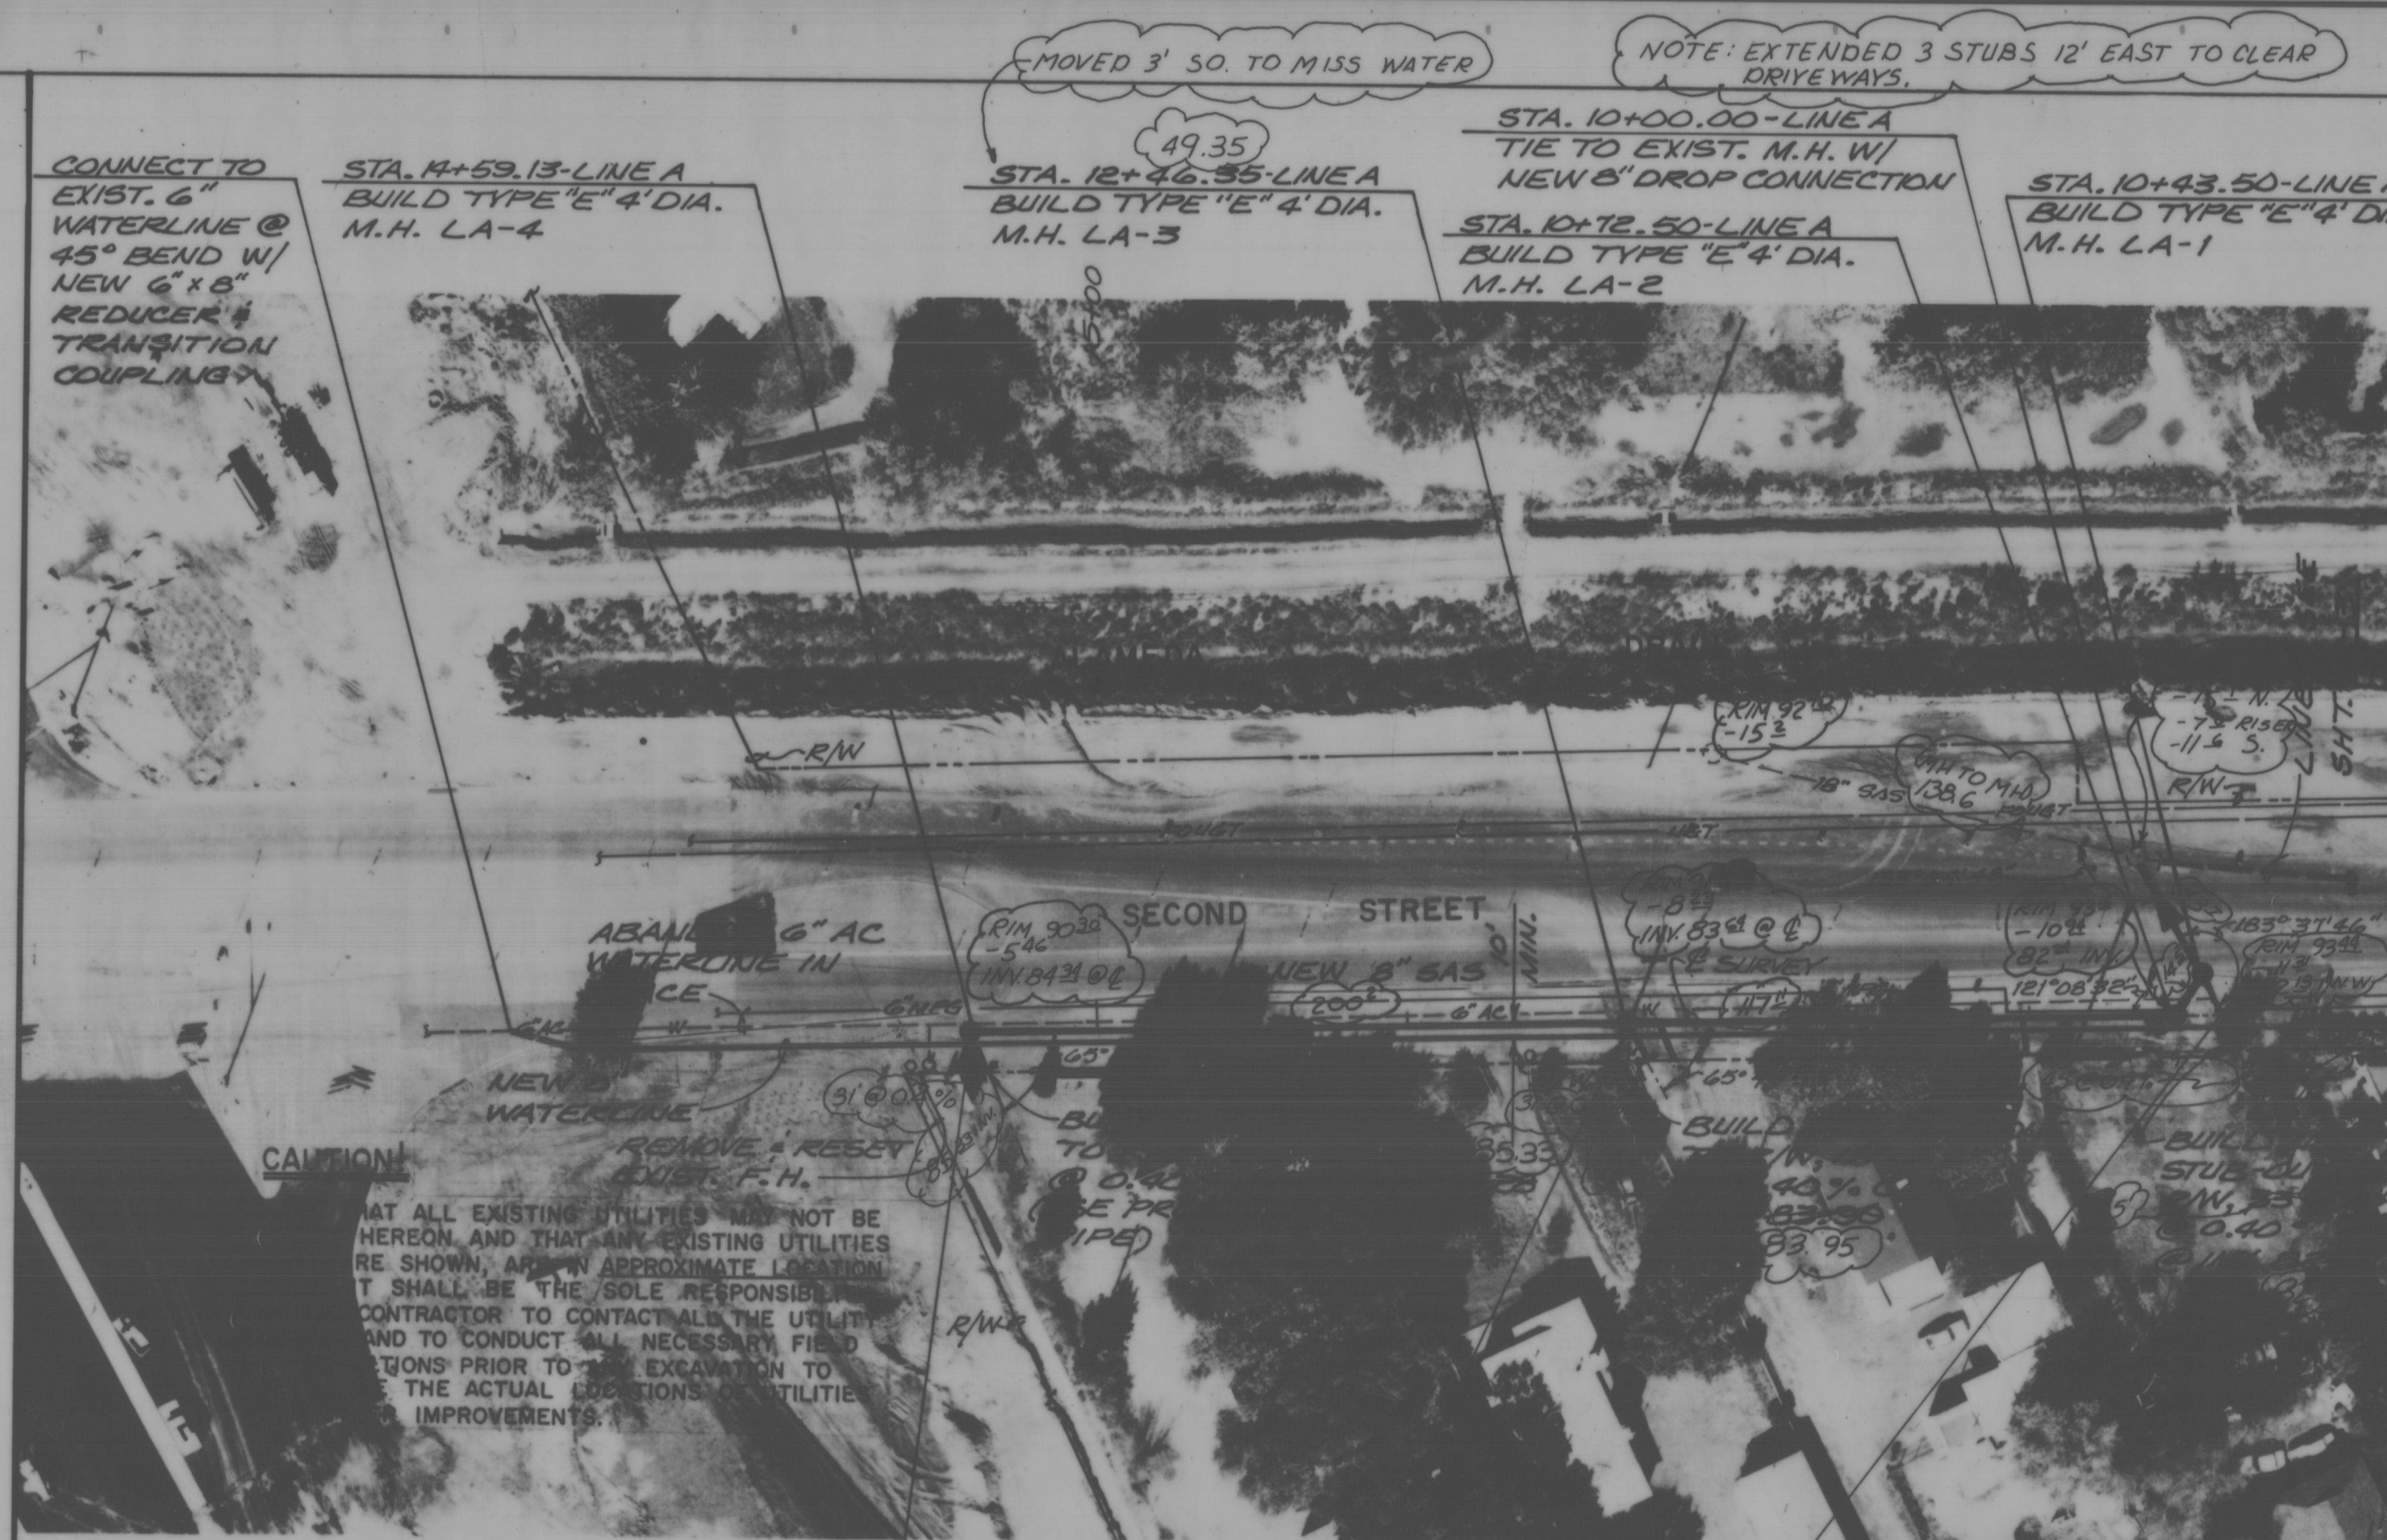[illegible]


RECORD DRAWING
DATE 9-4-89
Shirley Minter

PLANS PREPARED
UNDER THE
DIRECTION OF

NEWT S. FREEDMAN
10000
0102
N-186
REGISTERED PROFESSIONAL ENGINEER

APPROVED FOR
CONSTRUCTION
John A. Nelson
CITY ENGINEER Date

CITY OF ALBUQUERQUE PUBLIC WORKS DEPARTMENT ENGINEERING DIVISION					
TITLE: LINE A - SECOND STREET LEGEND & GENERAL NOTES					
APPROVALS	ENGINEER	DATE	APPROVALS	ENGINEER	DATE
City Engineer	NA		Liquid Waste	<i>W/General</i>	5/24/88
A.C.E. - Design	NA		Traffic	NA	
A.C.E. - Hydrology	NA		Water	<i>W/General</i>	3/24/88
DRAWING NO.		SHEET 12-2 OF			

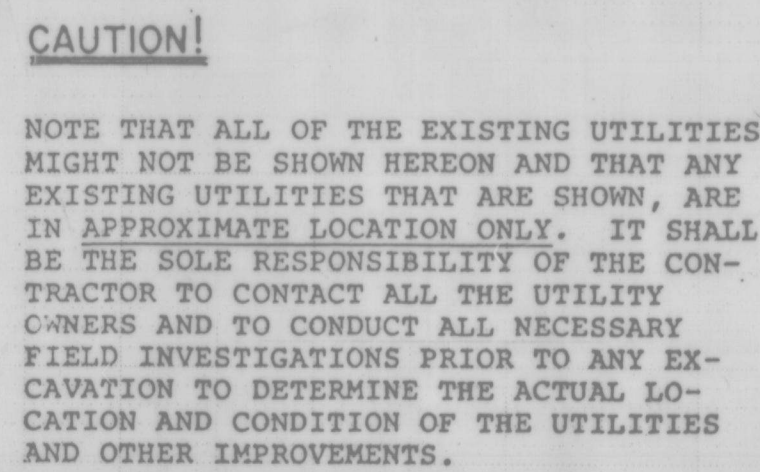

19 20+00

SECOND DRAWING
9-4-89
John J. Muto

PLANS
PREPARED
UNDER THE
DIRECTION OF

JOHN S. FOOTE
2103
4/18/88


REGISTERED PROFESSIONAL ENGINEER



APPROVED FOR
CONSTRUCTION

JOHN S. FOOTE

CITY ENGINEER DATE

CITY OF ALBUQUERQUE PUBLIC WORKS DEPARTMENT ENGINEERING DIVISION					
TITLE: LINE 9 - SECOND STREET					
APPROVALS	ENGINEER	DATE	APPROVALS	ENGINEER	DATE
City Engineer	N/A		Liquid Waste	<i>W. H. H.</i>	3/24/58
A.C.E. - Design	N/A		Traffic	1. N/A	
A.C.E. - Hydrology	N/A		Water	<i>W. H. H.</i>	3/24/58
DRAWING NO.			SHEET OF		
			12-3		

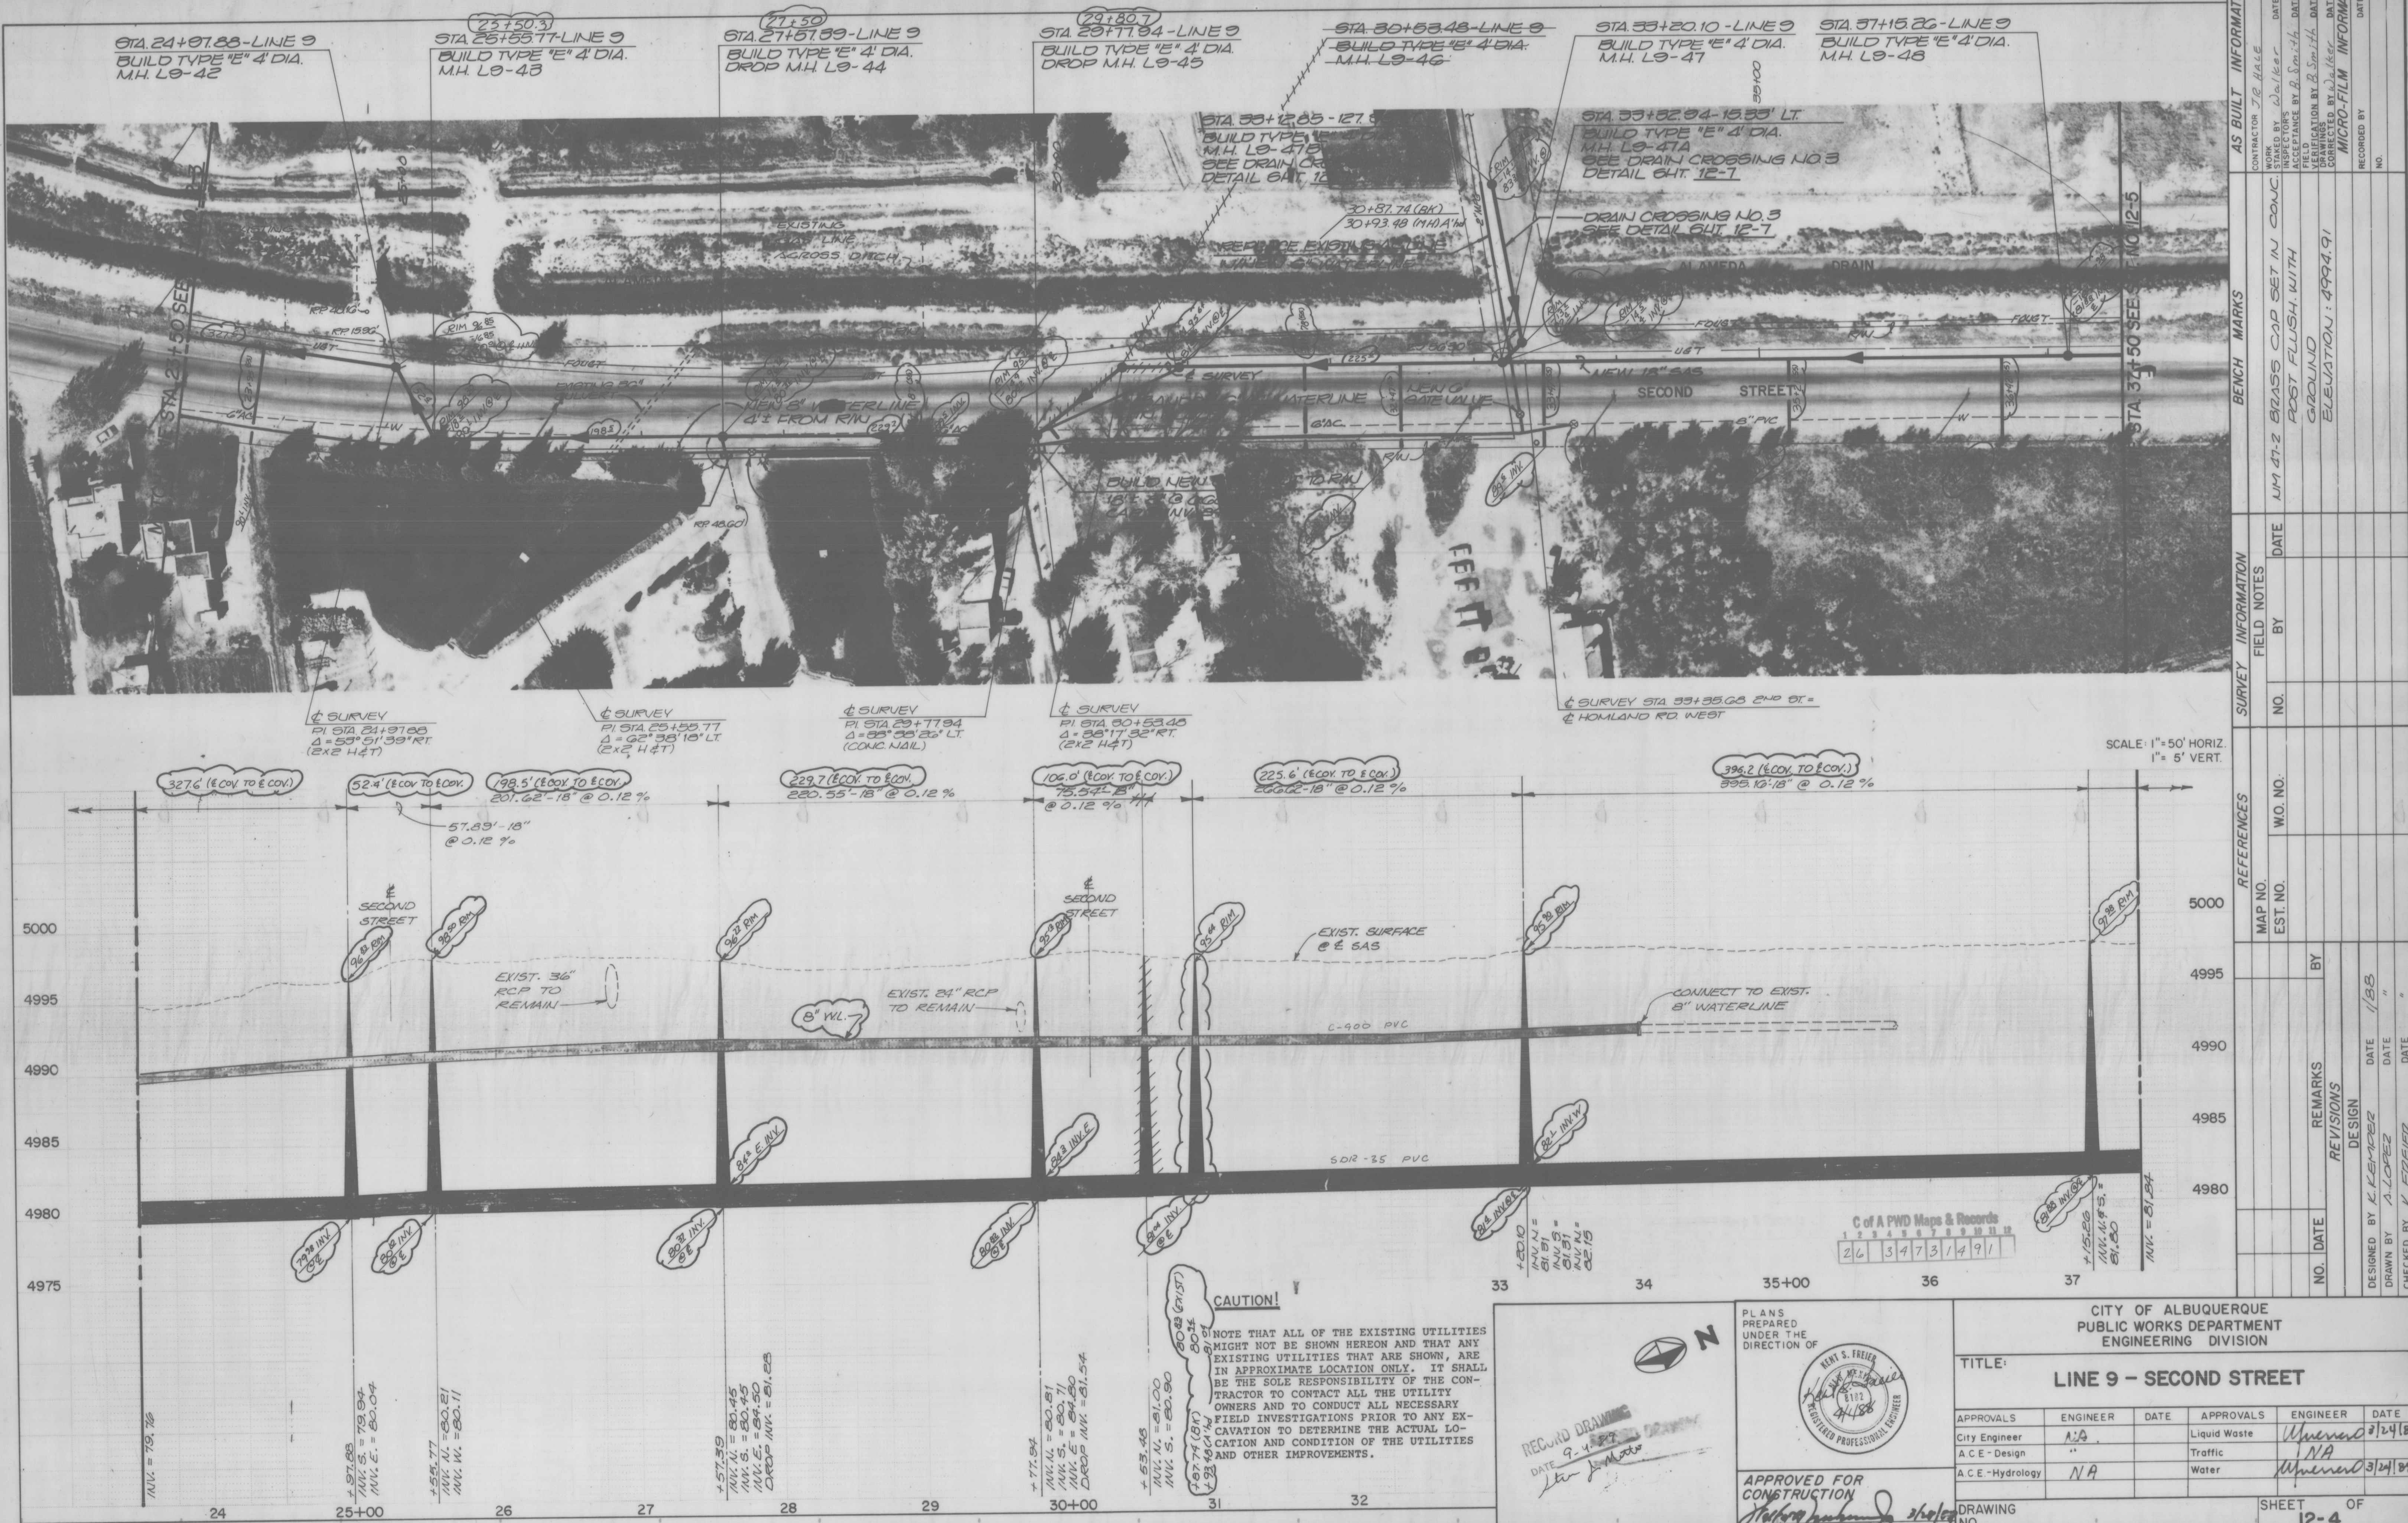

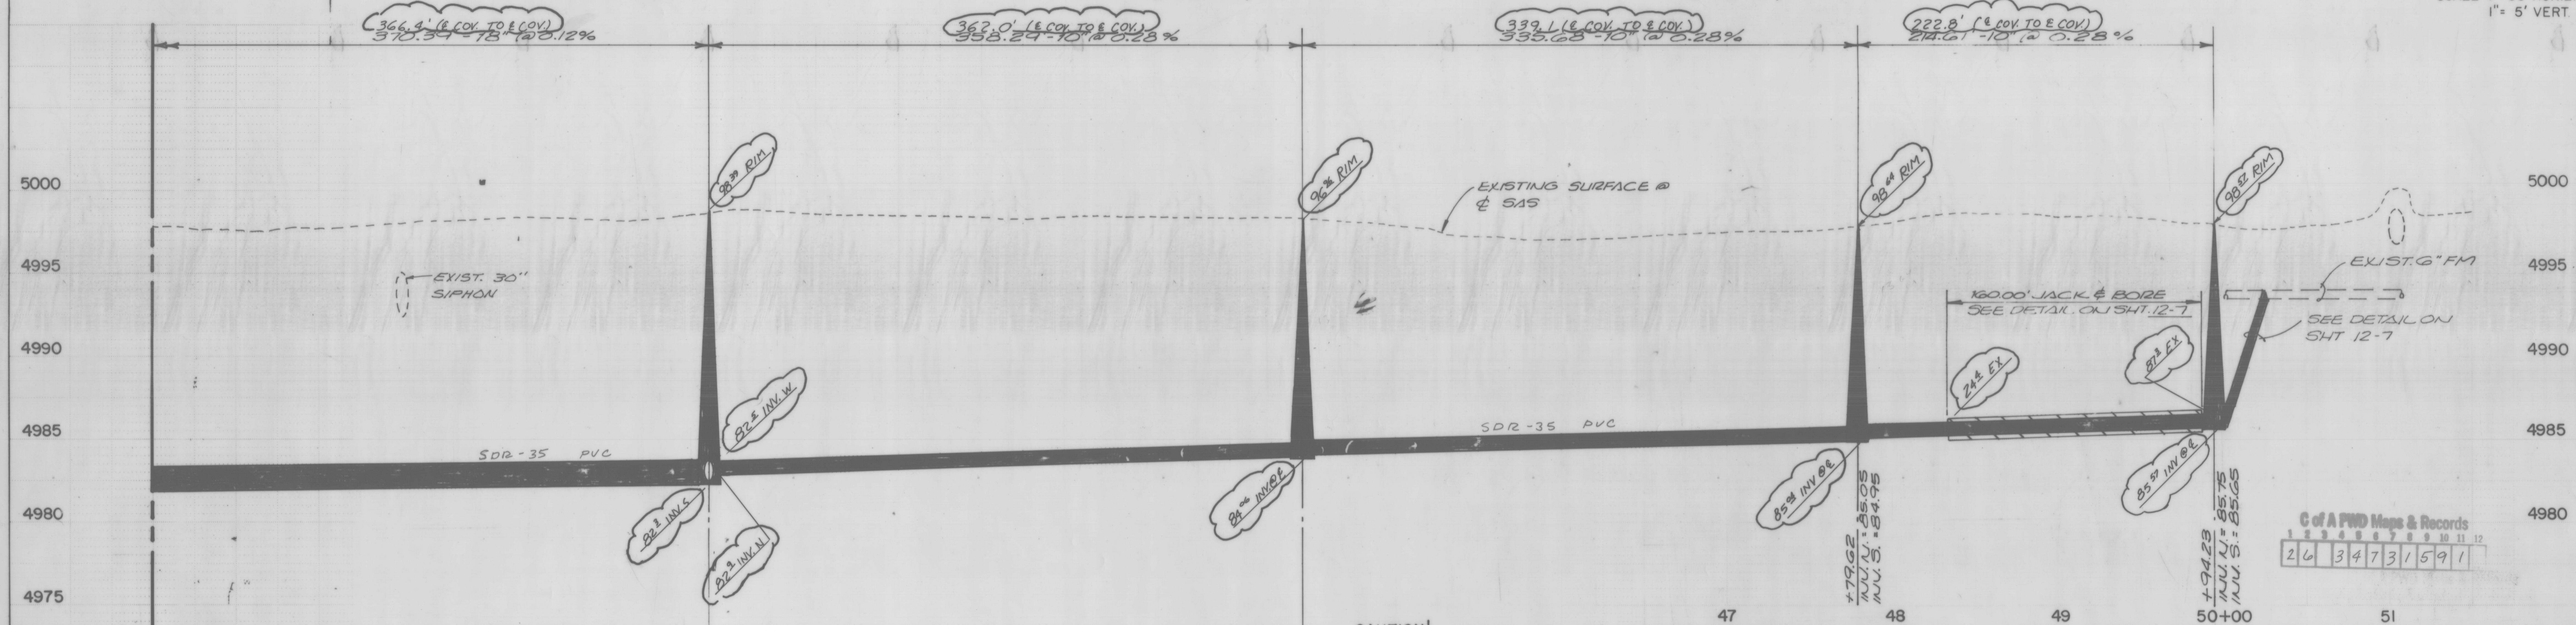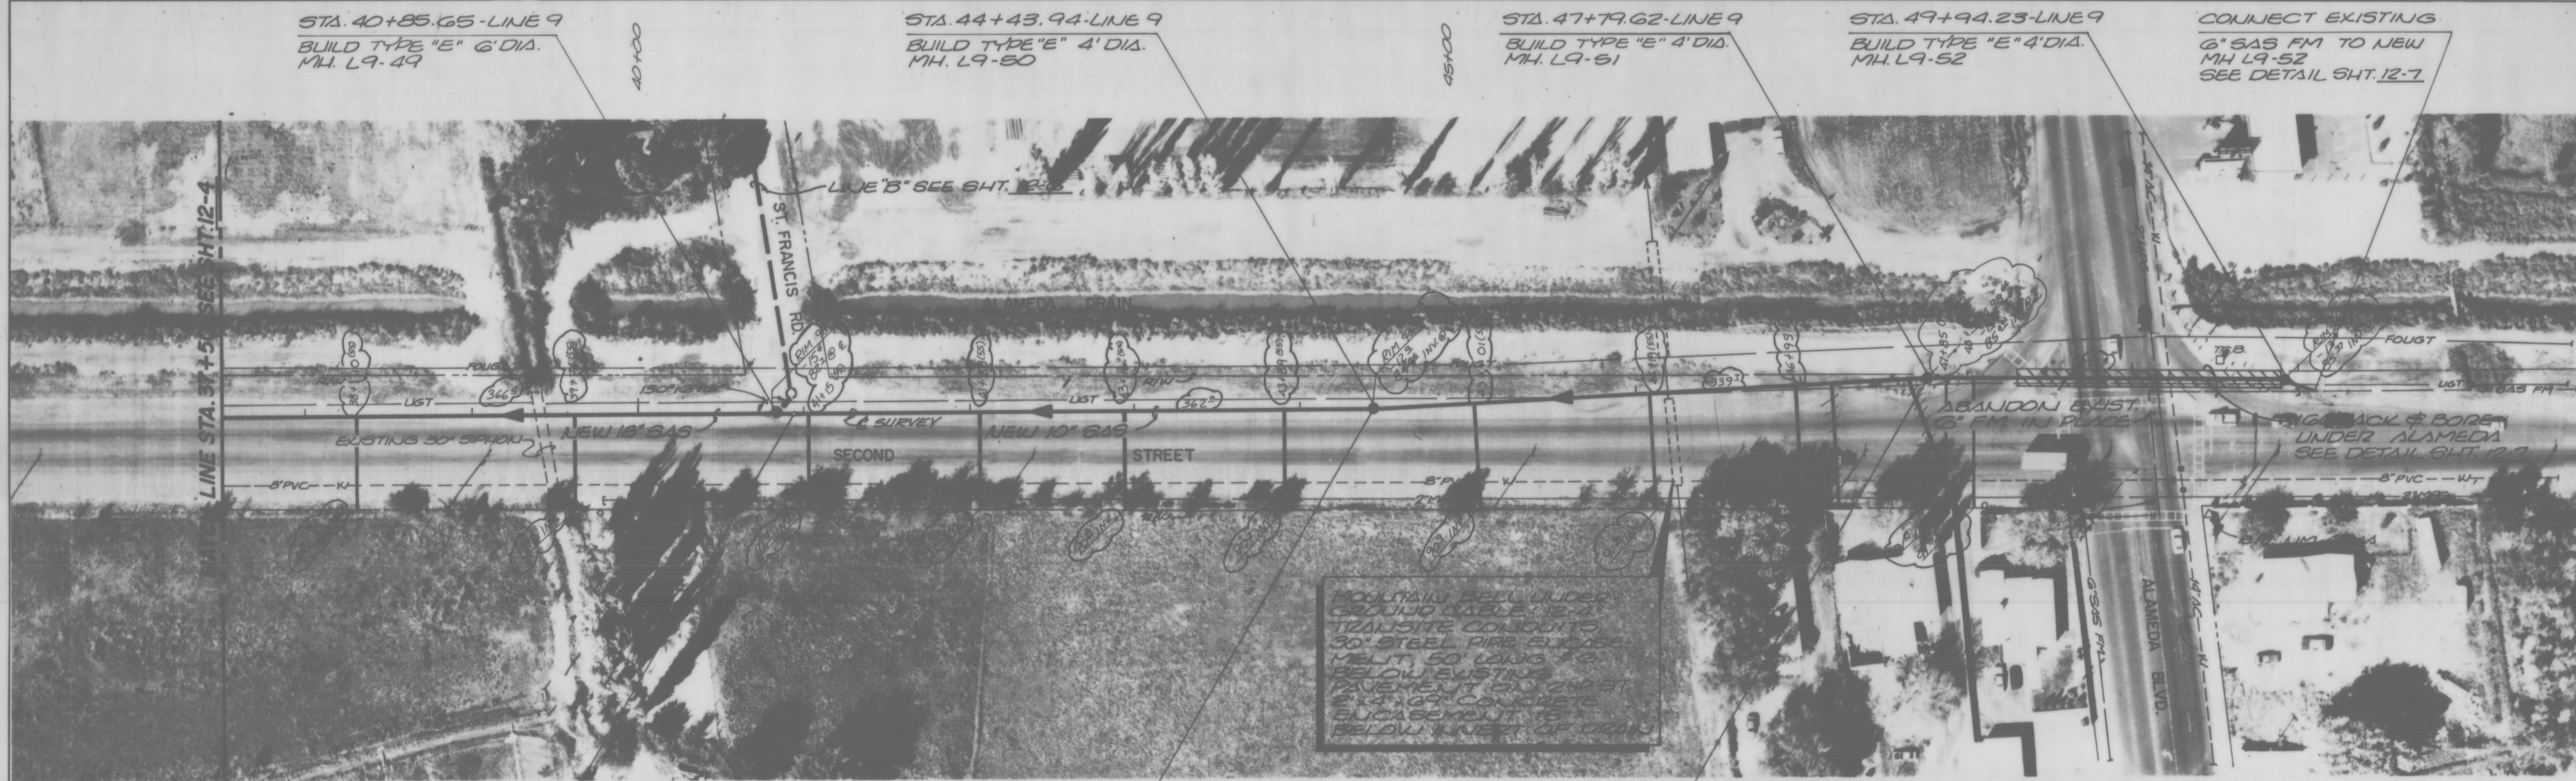

CAUTION!

NOTE THAT ALL OF THE EXISTING UTILITIES MIGHT NOT BE SHOWN HEREON AND THAT ANY EXISTING UTILITIES THAT ARE SHOWN, ARE IN APPROXIMATE LOCATION ONLY. IT SHALL BE THE SOLE RESPONSIBILITY OF THE CONTRACTOR TO CONTACT ALL THE UTILITY OWNERS AND TO CONDUCT ALL NECESSARY FIELD INVESTIGATIONS PRIOR TO ANY EXCAVATION TO DETERMINE THE ACTUAL LOCATION AND CONDITION OF THE UTILITIES AND OTHER IMPROVEMENTS.

47



RECORD DRAWING
9-4-89
Stim J. Miller

PLANS PREPARED UNDER THE DIRECTION OF




APPROVED FOR CONSTRUCTION
CITY ENGINEER
DATE

CITY OF ALBUQUERQUE
PUBLIC WORKS DEPARTMENT
ENGINEERING DIVISION
TITLE: **LINE 9 - SECOND STREET**

APPROVALS	ENGINEER	DATE	APPROVALS	ENGINEER	DATE
City Engineer	NA		Liquid Waste	Unrecorded	
A.C.E. - Design	NA		Traffic	NA	
A.C.E. - Hydrology	NA		Water	Unrecorded	

DRAWING NO. SHEET 12-5 OF

REFERENCES		SURVEY INFORMATION		BENCH MARKS		AS BUILT INFORMATION	
MAP NO.	EST. NO.	NO.	BY	DATE	DATE	CONTRACTOR	DATE
						J.R. Hale	
						INSPECTORS	DATE
						STANED BY Walker	
						ADJUSTED BY B. Smith	
						VERIFICATION BY B. Smith	
						CORRECTED BY Walker	
						DATE	
						MICRO-FILM INFORMATION	
						RECORDED BY	DATE

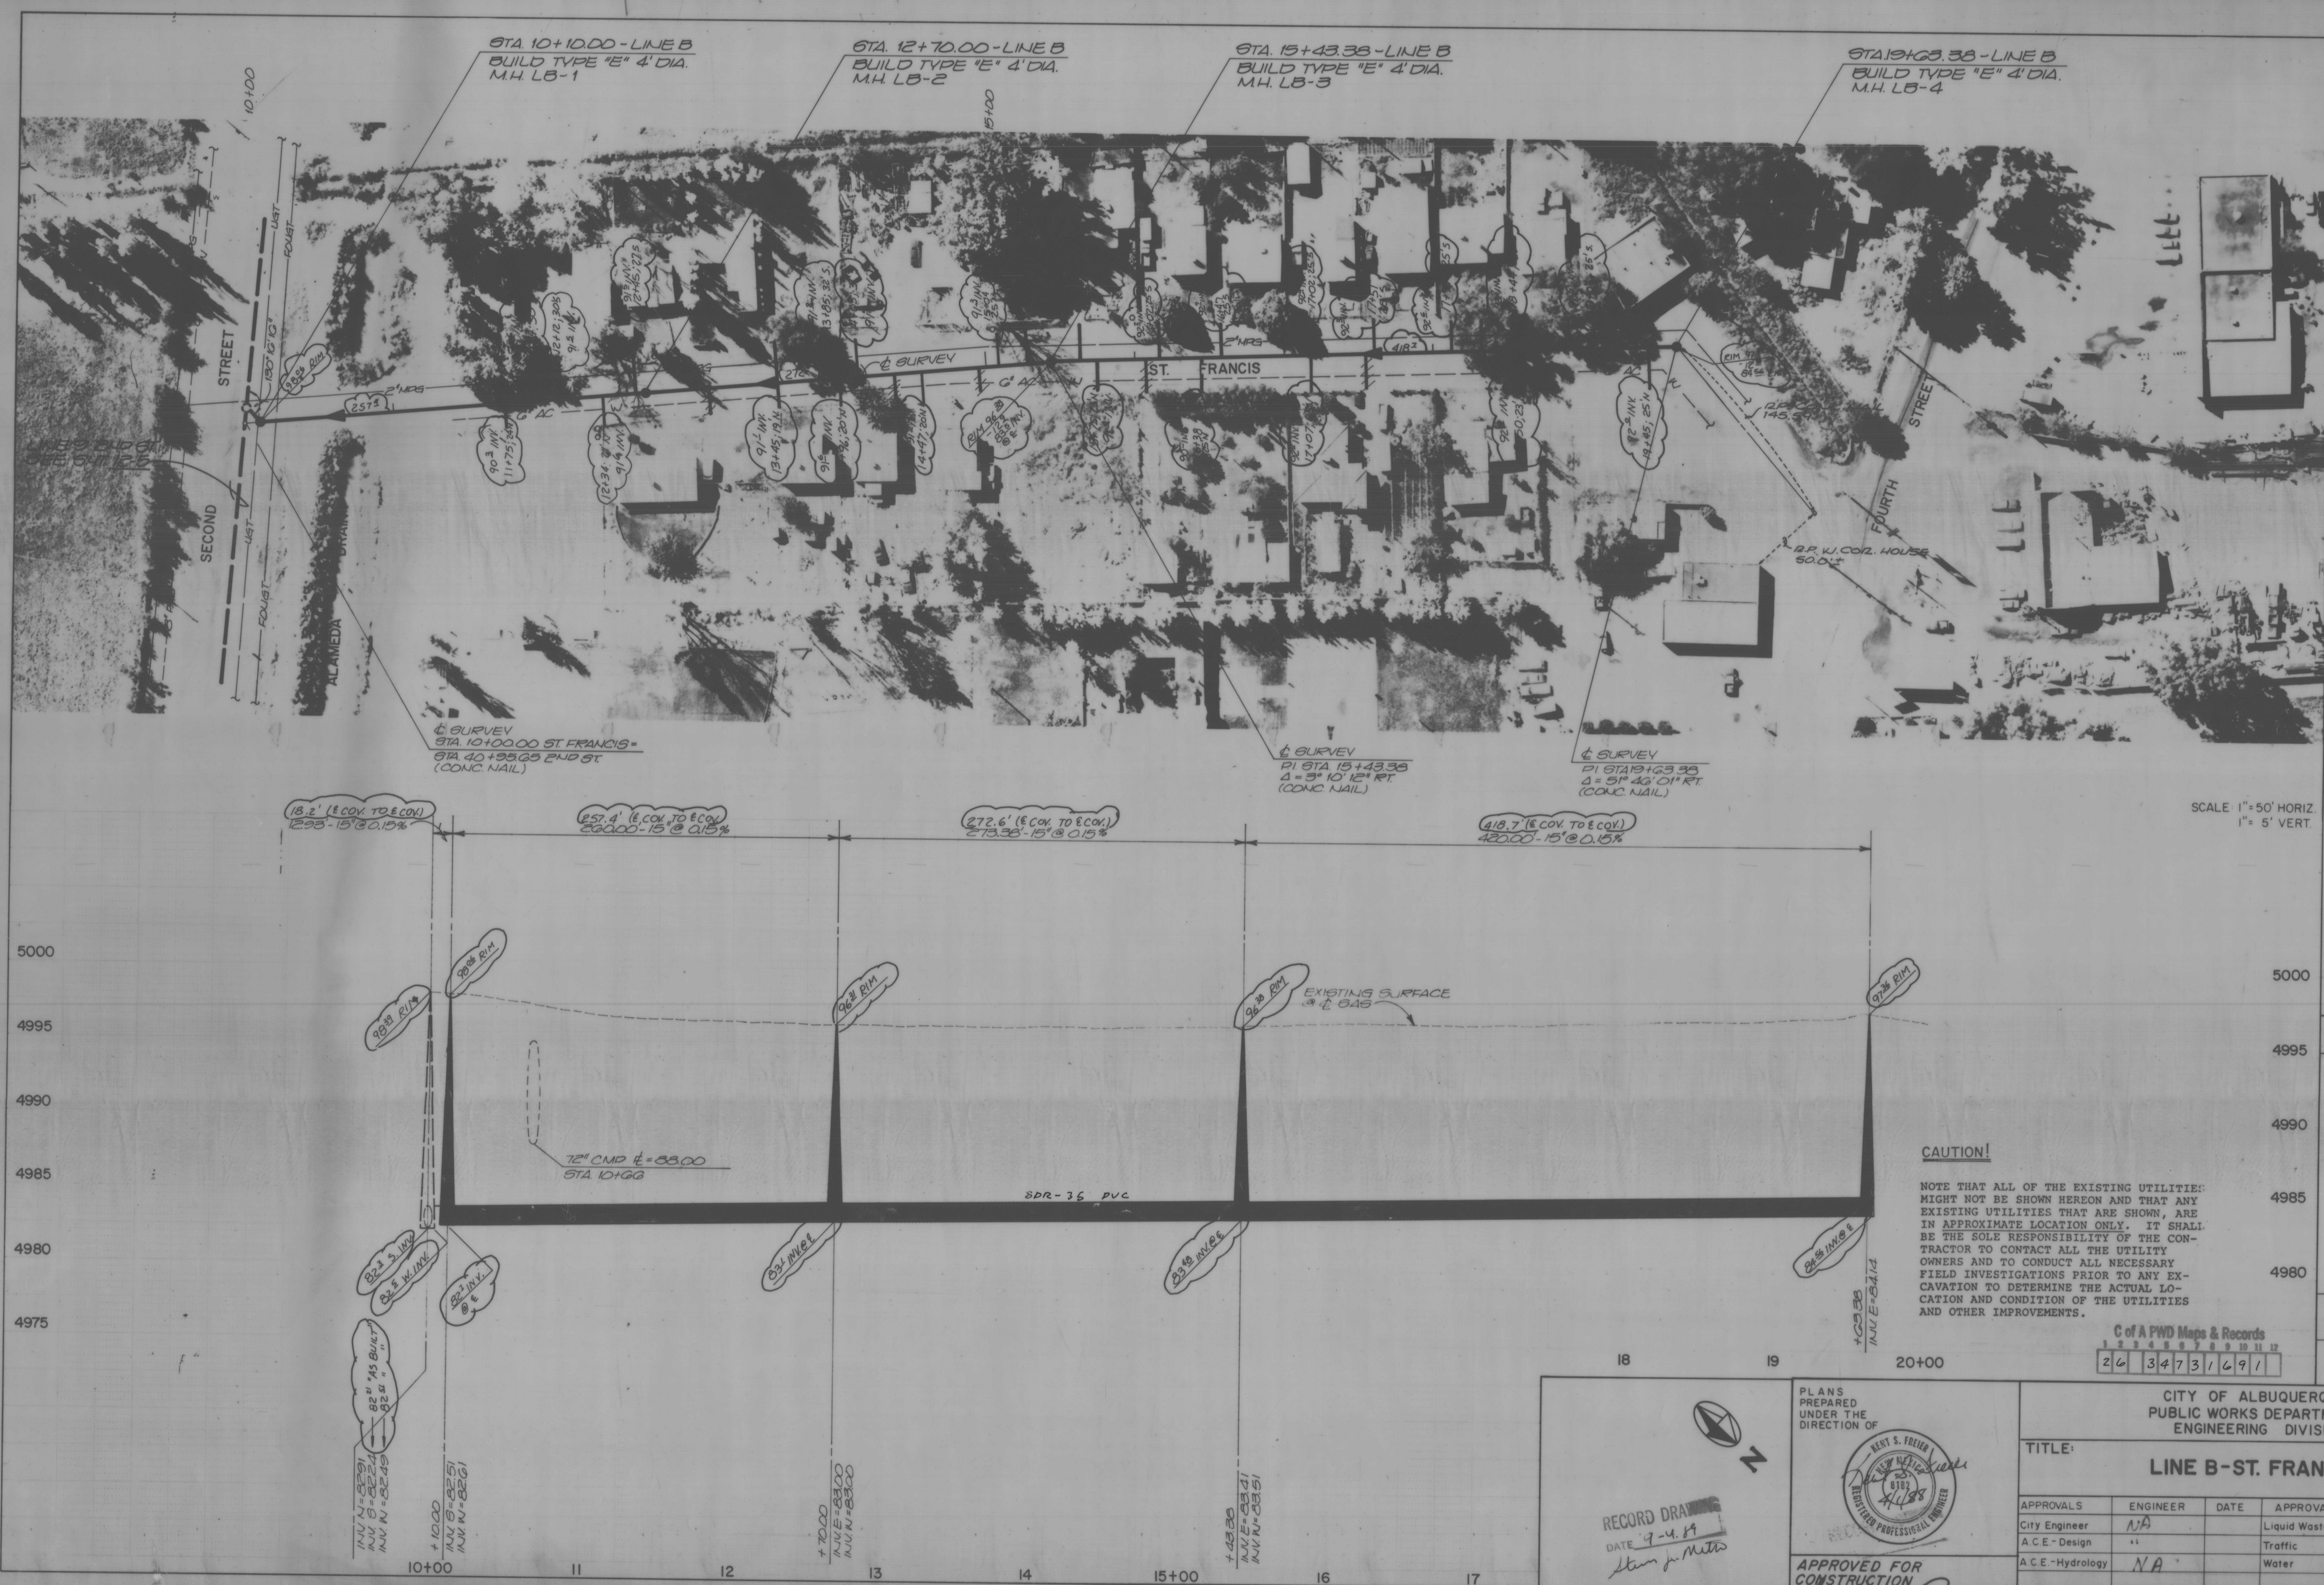

CAUTION!

NOTE THAT ALL OF THE EXISTING UTILITIES MIGHT NOT BE SHOWN HEREON AND THAT ANY EXISTING UTILITIES THAT ARE SHOWN, ARE IN APPROXIMATE LOCATION ONLY. IT SHALL BE THE SOLE RESPONSIBILITY OF THE CONTRACTOR TO CONTACT ALL THE UTILITY OWNERS AND TO CONDUCT ALL NECESSARY FIELD INVESTIGATIONS PRIOR TO ANY EXCAVATION TO DETERMINE THE ACTUAL LOCATION AND CONDITION OF THE UTILITIES AND OTHER IMPROVEMENTS.

C of A PWD Maps & Records
26 34731491

CITY OF ALBUQUERQUE PUBLIC WORKS DEPARTMENT ENGINEERING DIVISION					
TITLE: LINE B-ST. FRANCIS					
APPROVALS	ENGINEER	DATE	APPROVALS	ENGINEER	DATE
City Engineer	NA		Liquid Waste	NA	3/24/88
A.C.E.-Design	NA		Traffic	NA	
A.C.E.-Hydrology	NA		Water	NA	3/24/88
DRAWING NO.			SHEET 12-6 OF		
APPROVED FOR CONSTRUCTION DATE 7-4-89 CITY ENGINEER			DESIGNED BY K. KEMPER DRAWN BY J. CHAVEZ CHECKED BY L. FREIER DATE 1/88		

REFERENCES		SURVEY INFORMATION		BENCH MARKS		AS BUILT INFORMATION	
MAP NO.	EST. NO.	NO.	BY	DATE		CONTRACTOR	J.R. HALE
						WORKED BY	W. J. K. K.
						INSPECTED BY	W. J. K. K.
						ACCEPTANCE BY	W. J. K. K.
						VERIFICATION BY	W. J. K. K.
						DRAWINGS	DATE
						NO.	DATE
						RECORDED BY	DATE
						NO.	DATE

NOTES:

SPECIAL DROP INLET DETAILS

- ALL CONCRETE SHALL BE CLASS "A" DESIGN BASED ON A MINIMUM COMPRESSIVE STRENGTH OF 3000 PSI AT 28 DAYS. CHAMFER ALL EXPOSED EDGES $\frac{3}{4}$ ".
- REINFORCING STEEL SHALL CONFORM TO ASTM SPECIFICATION A-615, GRADE 40.
- STRUCTURAL STEEL SHALL BE CARBON STEEL CONFORMING TO AASHTO SPECIFICATION M-185.
- ASSEMBLE AND THOROUGHLY CLEAN ALL STRUCTURAL STEEL PRIOR TO PAINTING. PAINT ALL STRUCTURAL STEEL MEMBERS WITH ONE SHOP COAT OF RED LEAD PAINT (AASHTO M-72) AND TWO COATS OF ALUMINUM PAINT (AASHTO M-69) OMIT PAINT ON CONTACT SURFACES AND SURFACES EMBEDDED IN CONCRETE.
- TOP OF GRATE CROSS BARS SHALL BE FLUSH WITH TOP OF GRATE. THE GRATE SHALL BE WELDED WITH $\frac{1}{8}$ " FILLET WELD AROUND BOTH SIDES OF CROSS BARS AND $\frac{1}{4}$ " FILLET WELD AROUND BOTH SIDES OF BEARING BARS. GRIND WELDS FLUSH WITH BEARING BARS.
- STEEL ELBOW SHALL BE A 90° THREE-PIECE ELBOW, $\frac{3}{16}$ " WALL THICKNESS, 18" ID, CONSTRUCTED IN ACCORDANCE WITH AMERICAN WATER WORKS ASSOCIATION STANDARD C208, DIMENSIONS FOR FABRICATED STEEL WATER PIPE FITTINGS. PAINT INTERIOR AND EXTERIOR OF ELBOW WITH TWO COATS (30 MILS TOTAL) KOPPER'S BITUMASTIC 505, AMERON 78 H5, TNEPEC 4G-450, OR EQUAL. PREPARE SURFACE PRIOR TO PAINTING IN ACCORDANCE WITH STRUCTURAL STEEL PAINTING COUNCIL SSPC-SP6 SPECIFICATION.
- DRILLED EXPANSION ANCHORS SHALL BE TYPE 316 STAINLESS STEEL WEDGE ANCHORS AS MANUFACTURED BY PHILLIPS DRILL COMPANY OR EQUAL.

ESTIMATED QUANTITIES *






ITEM	QUANTITY
CLASS "A" CONCRETE, CU. YDS. **	1.818 + 0.524 H
REINFORCING STEEL, LBS.	263 + 42.39 H
STRUCTURAL STEEL, LBS.	1022

* FOR CONTRACTOR'S INFORMATION ONLY
 ** SEE TABLE BELOW FOR PIPE DEDUCTIONS
 H = DEPTH OF DROP INLET IN FEET

CLASS "A" CONCRETE DEDUCTIONS FOR ONE PIPE

SIZE	DEDUCTION FOR RCP
12" ϕ	0.037 CU. YDS.
18" ϕ	0.074 CU. YDS.
24" ϕ	0.134 CU. YDS.

NOTE: DEDUCTIONS ARE FOR PIPE NORMAL TO WALLS.

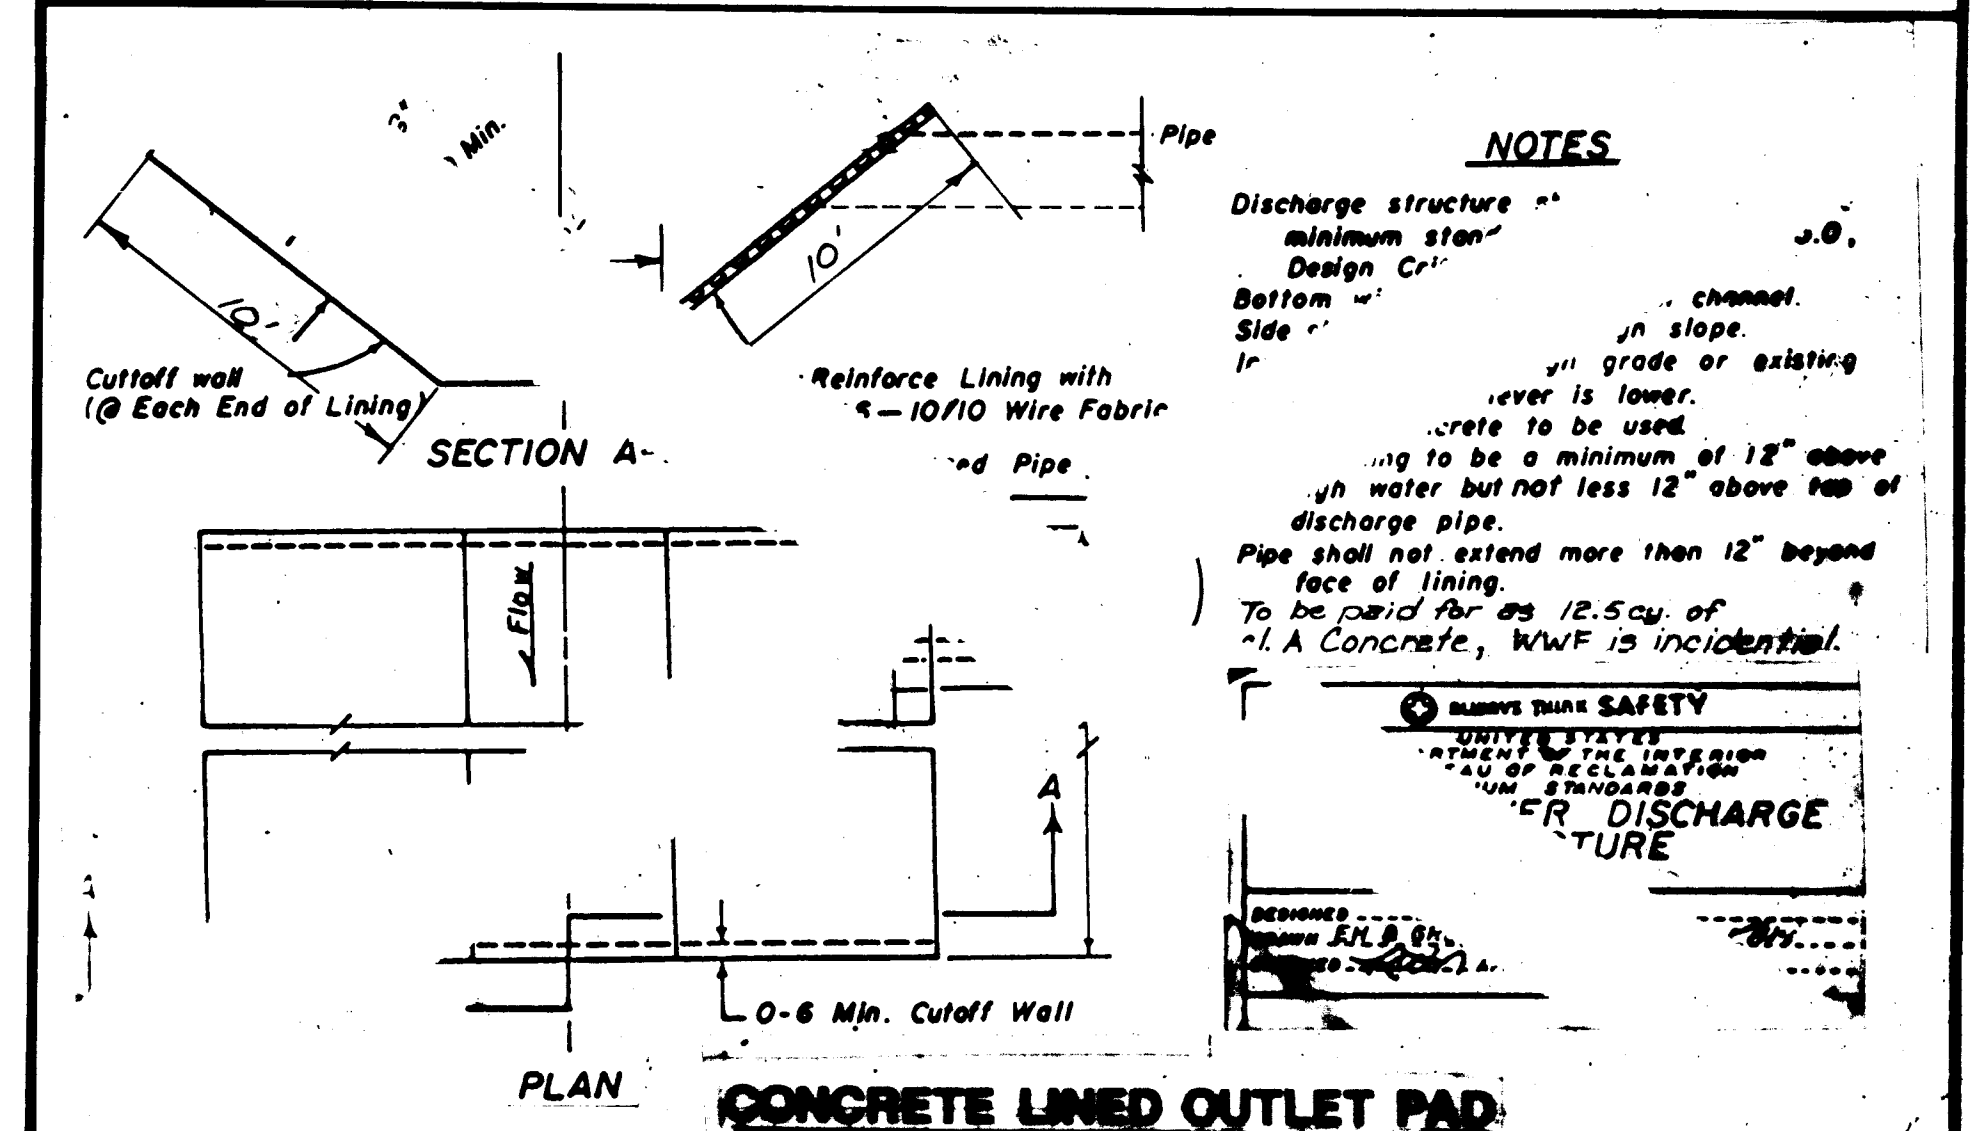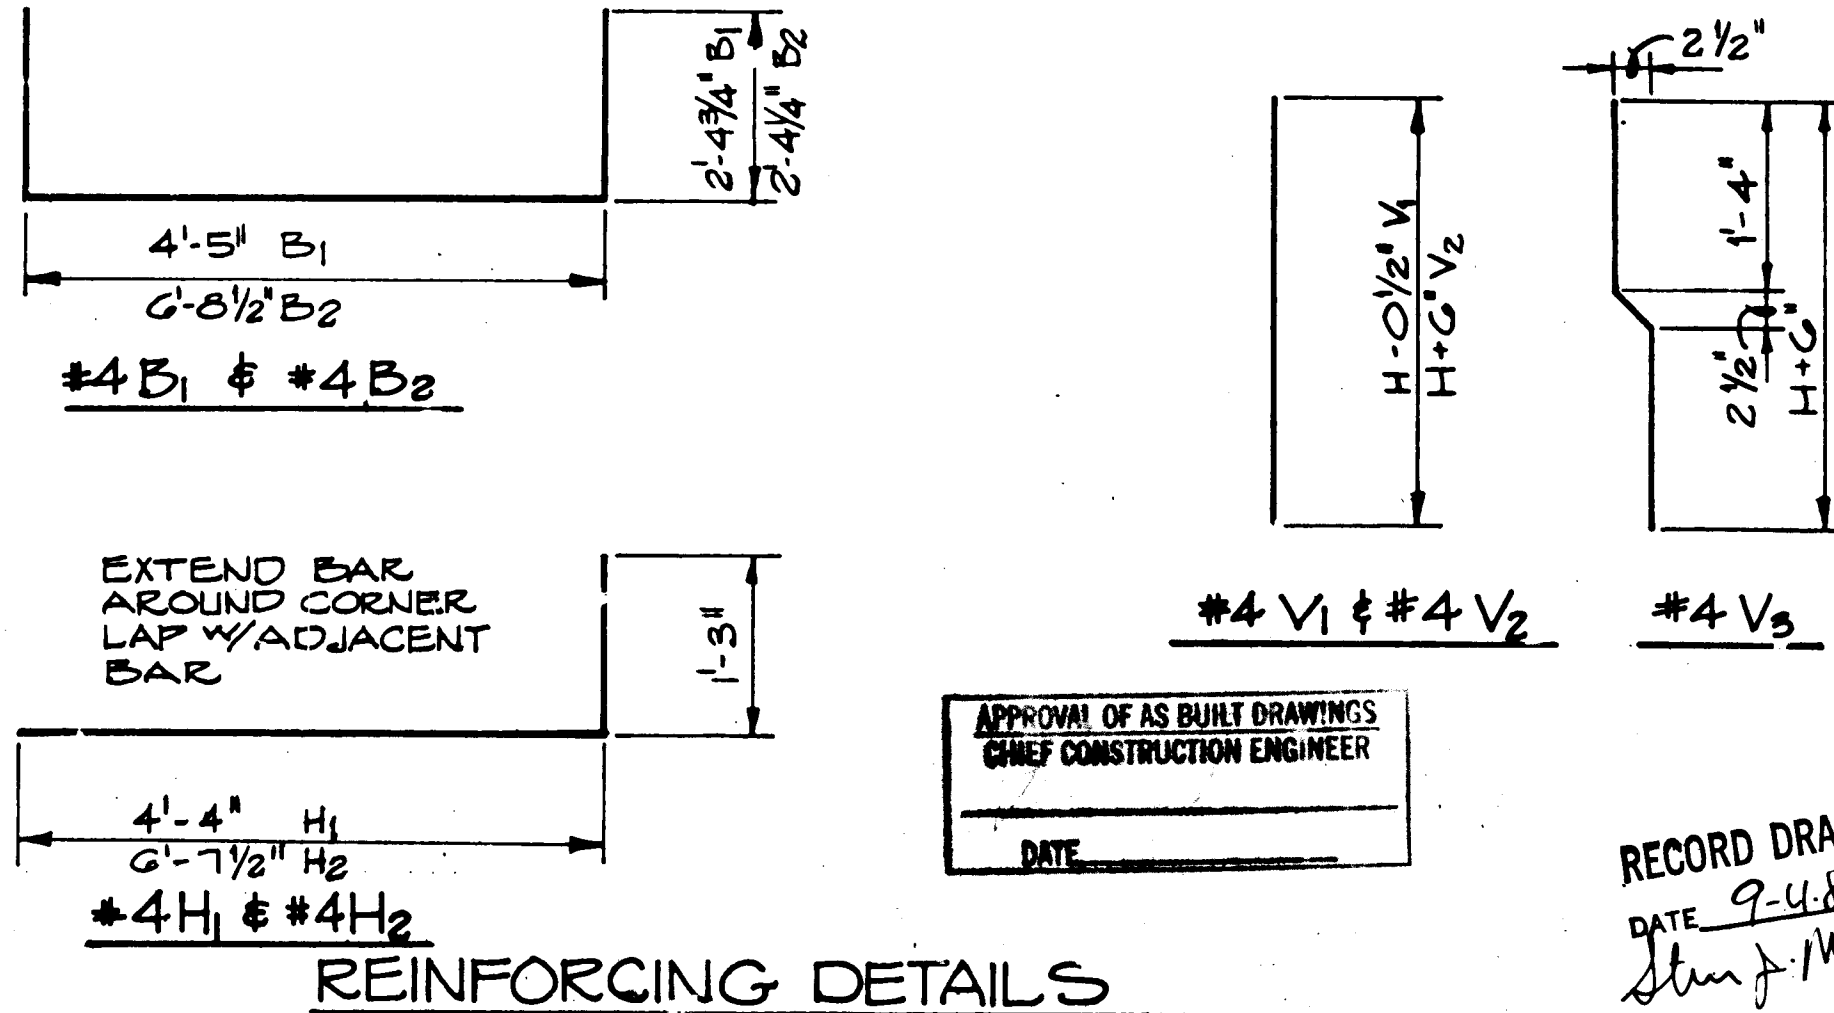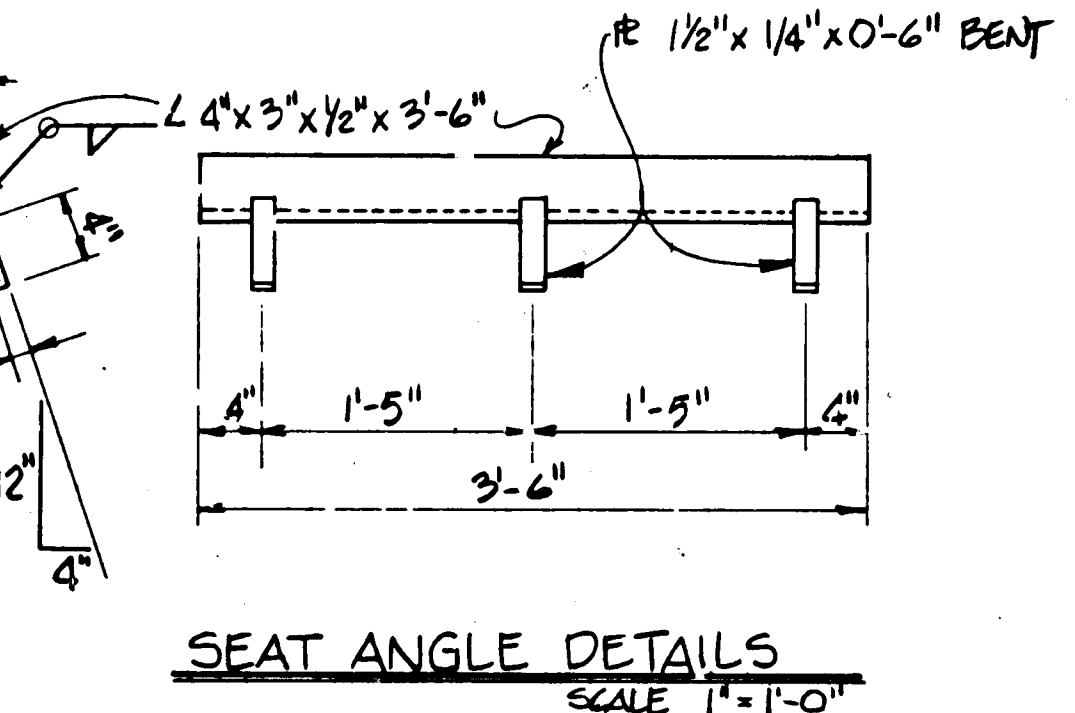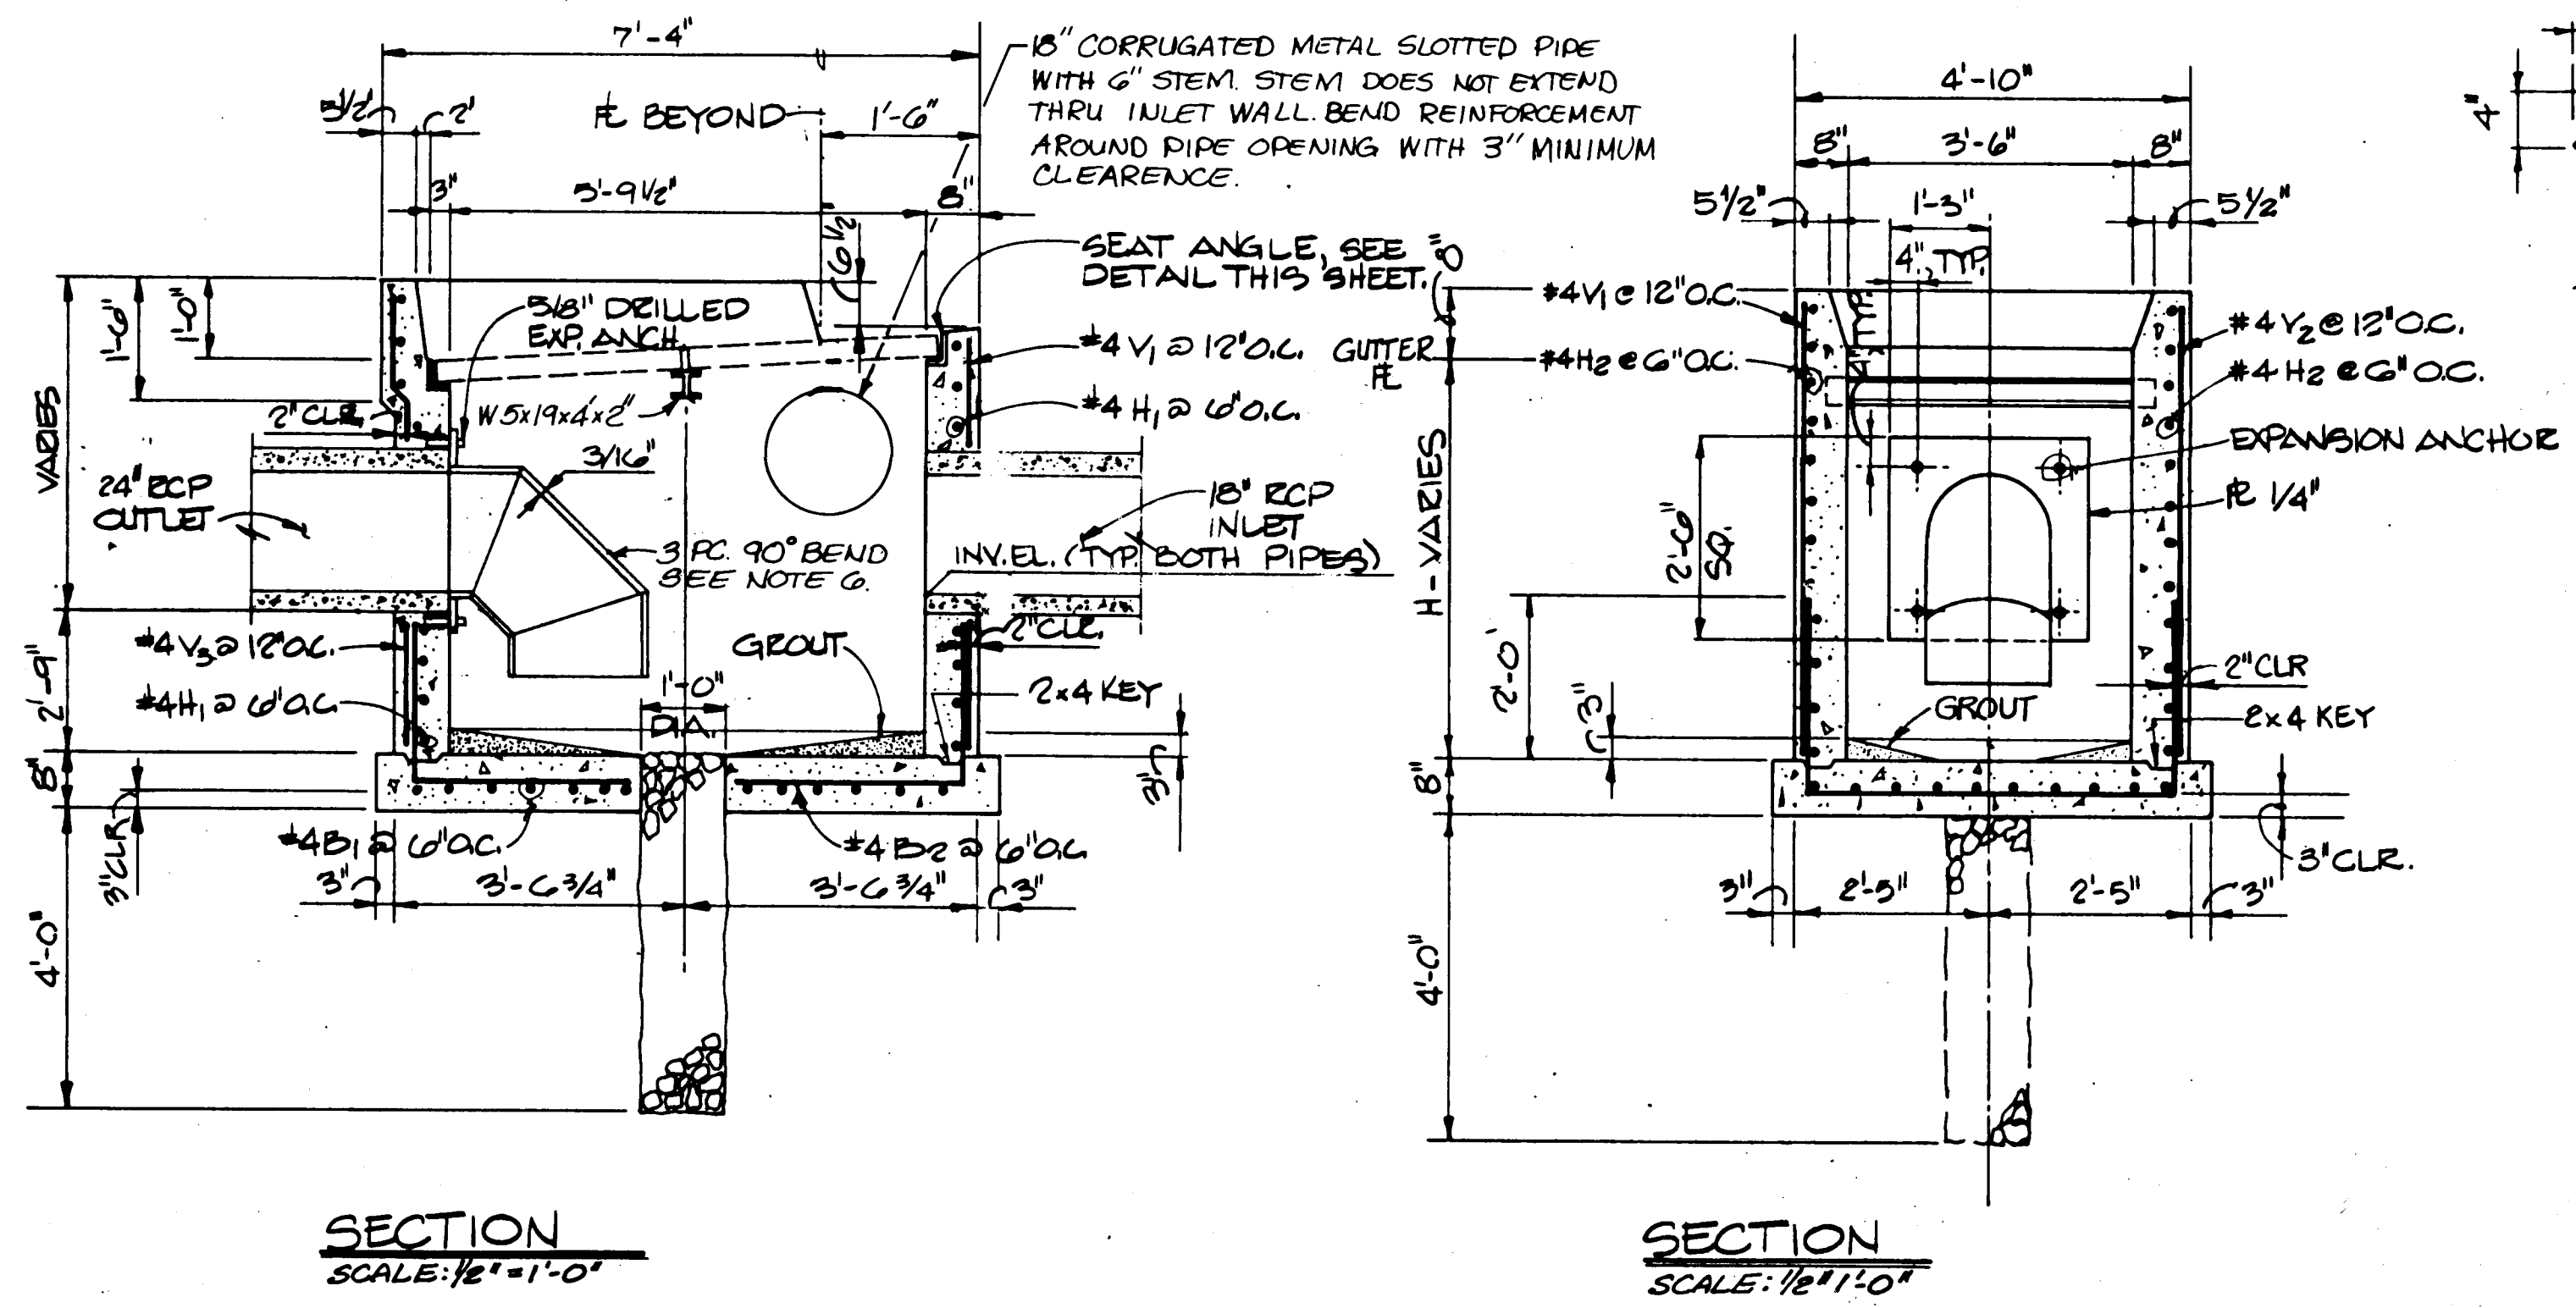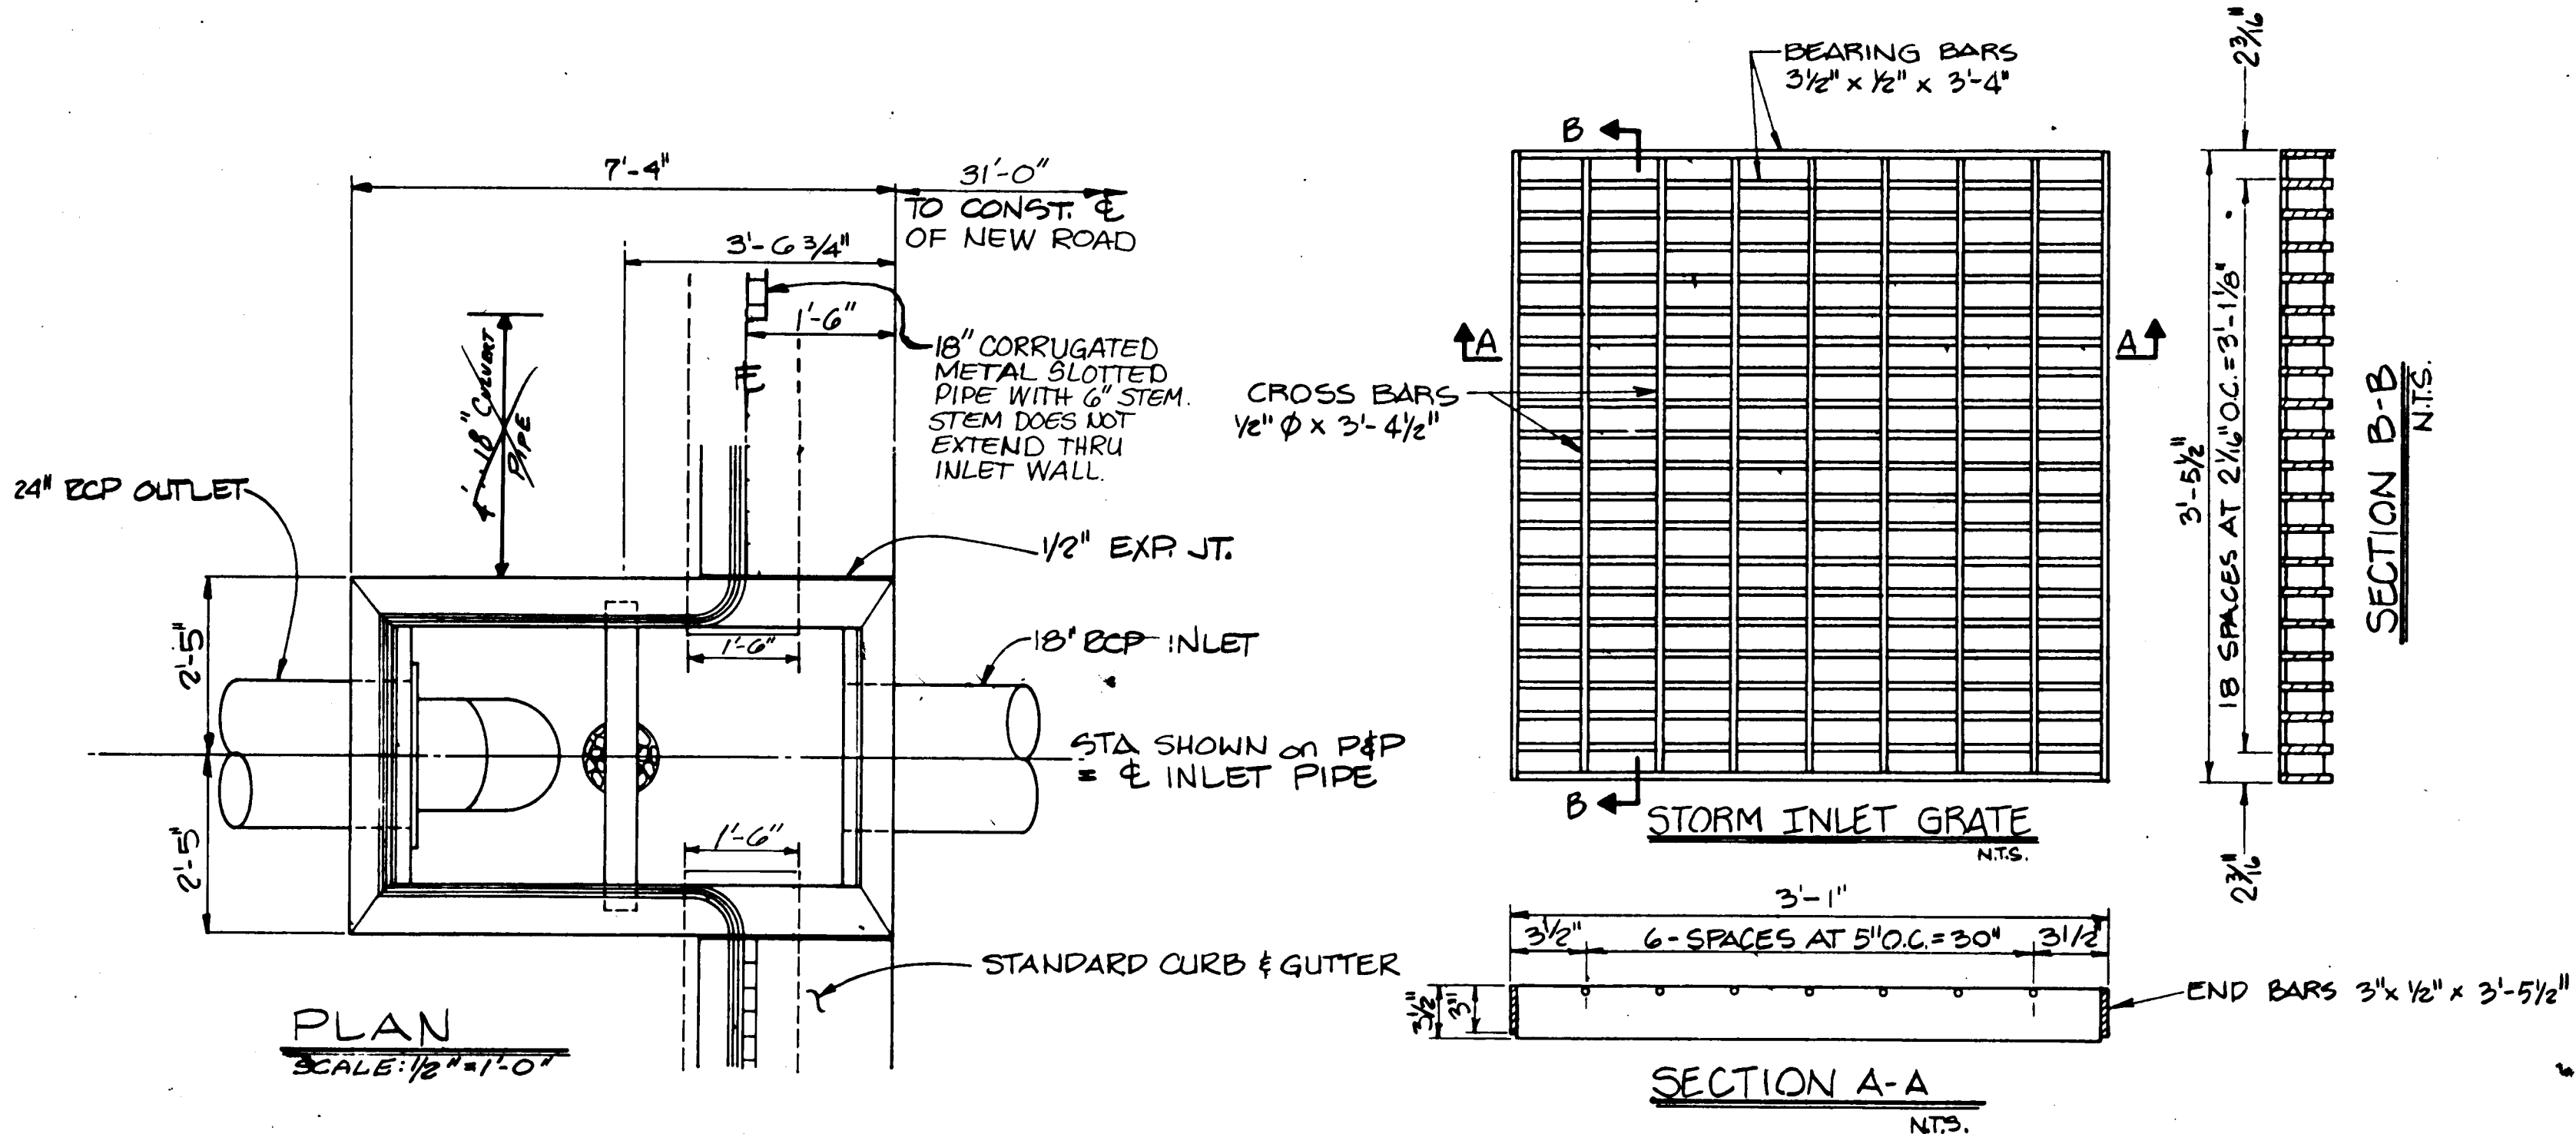

STRUCTURES LOCATED AT STATIONS:

- Sta. 290+93
 - Sta. 298+50
 - Sta. 303+27
 - Sta. 315+65
- MRGCD Curb Inlets shall be paid for by the each complete in place.

C of A PWD Maps & Records
 26 347301911






3473

MRGCD CURB INLET DETAILS

SECOND STREET



APPROVAL OF AS BUILT DRAWINGS
 CHIEF CONSTRUCTION ENGINEER
 DATE

RECORD DRAWING
 DATE 9-4-89
 Shm p Mth

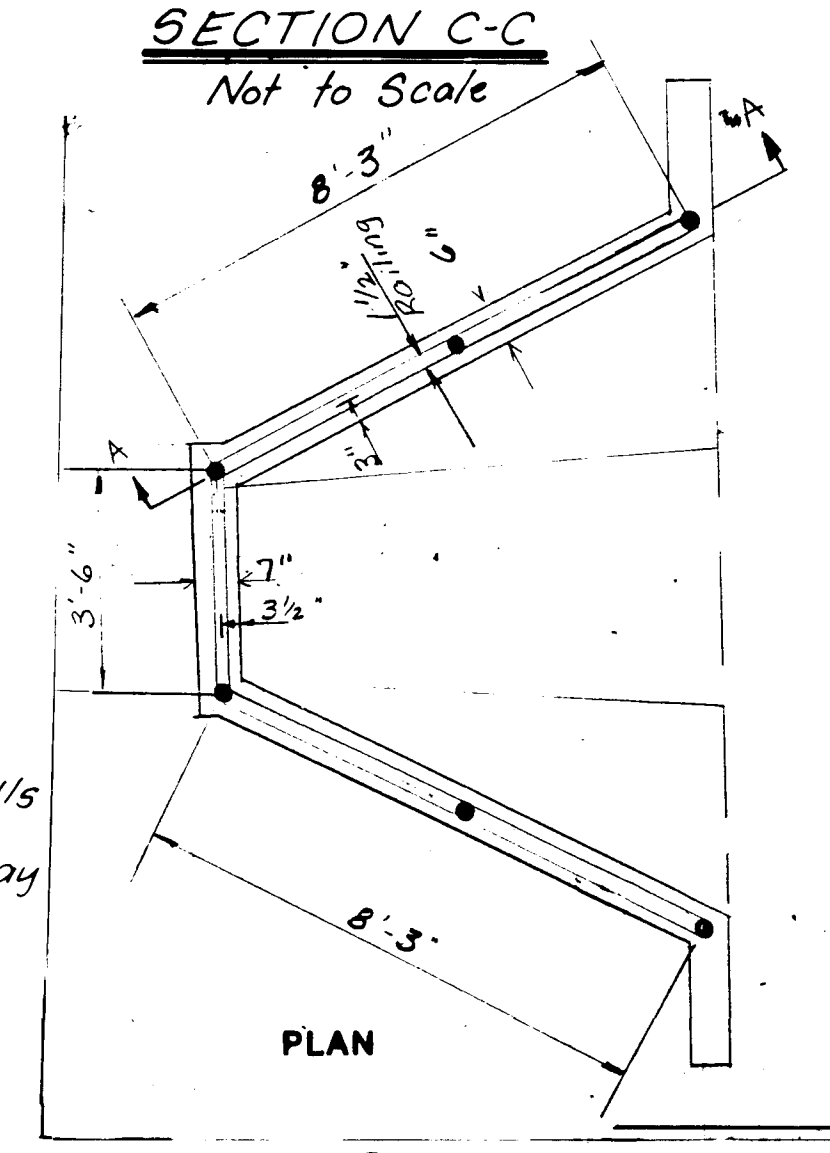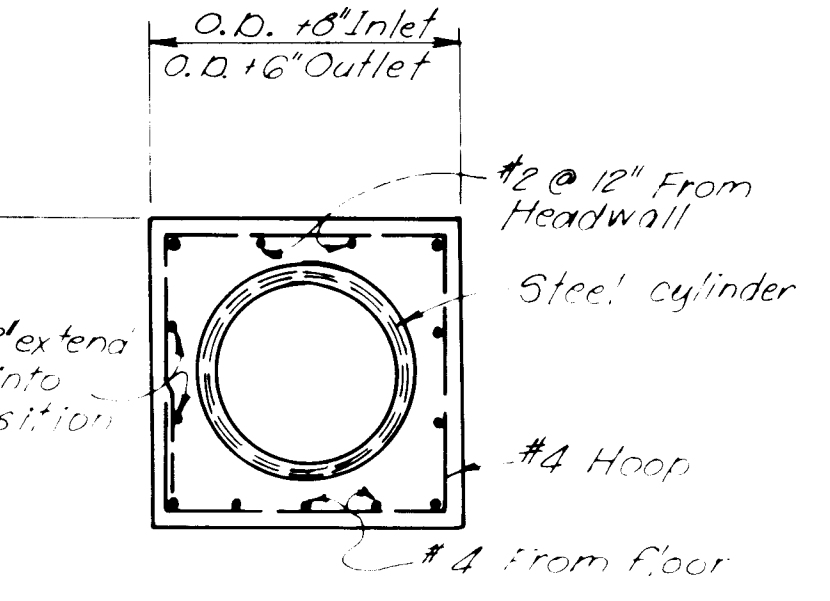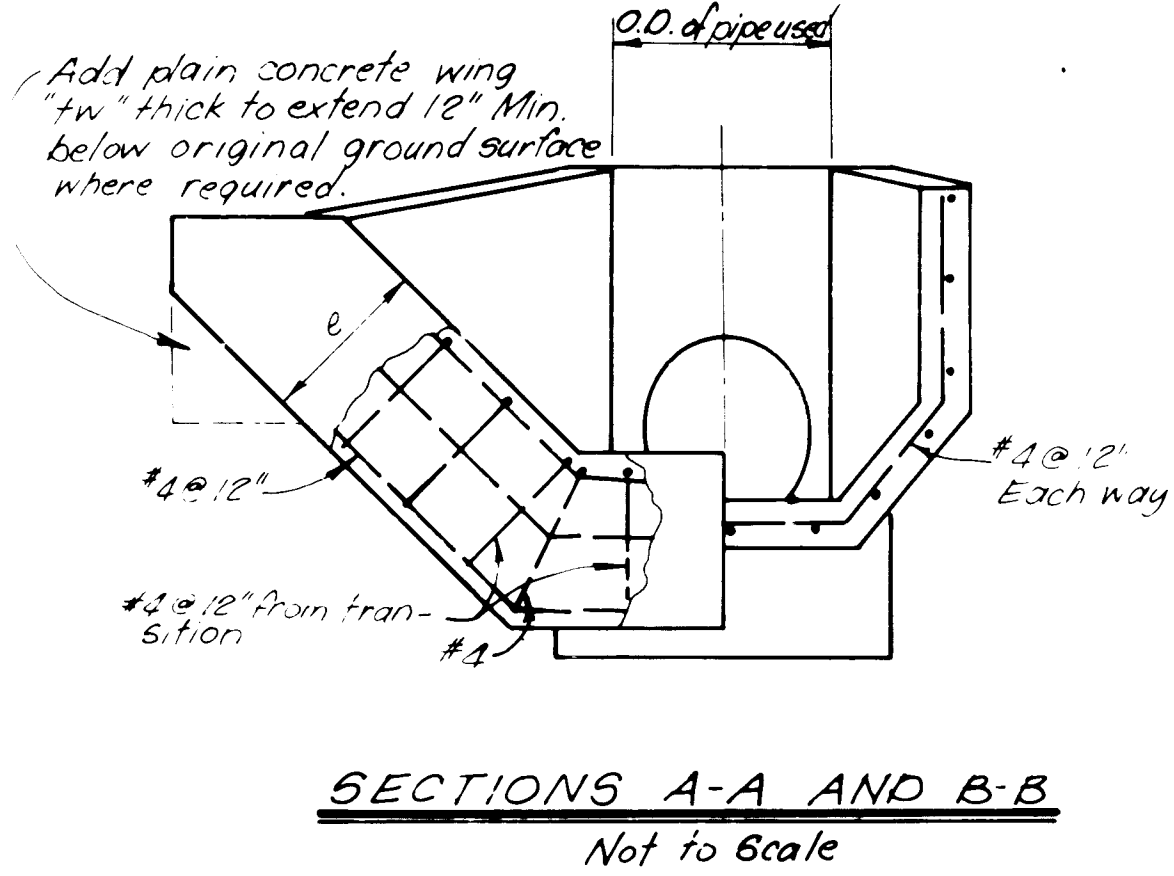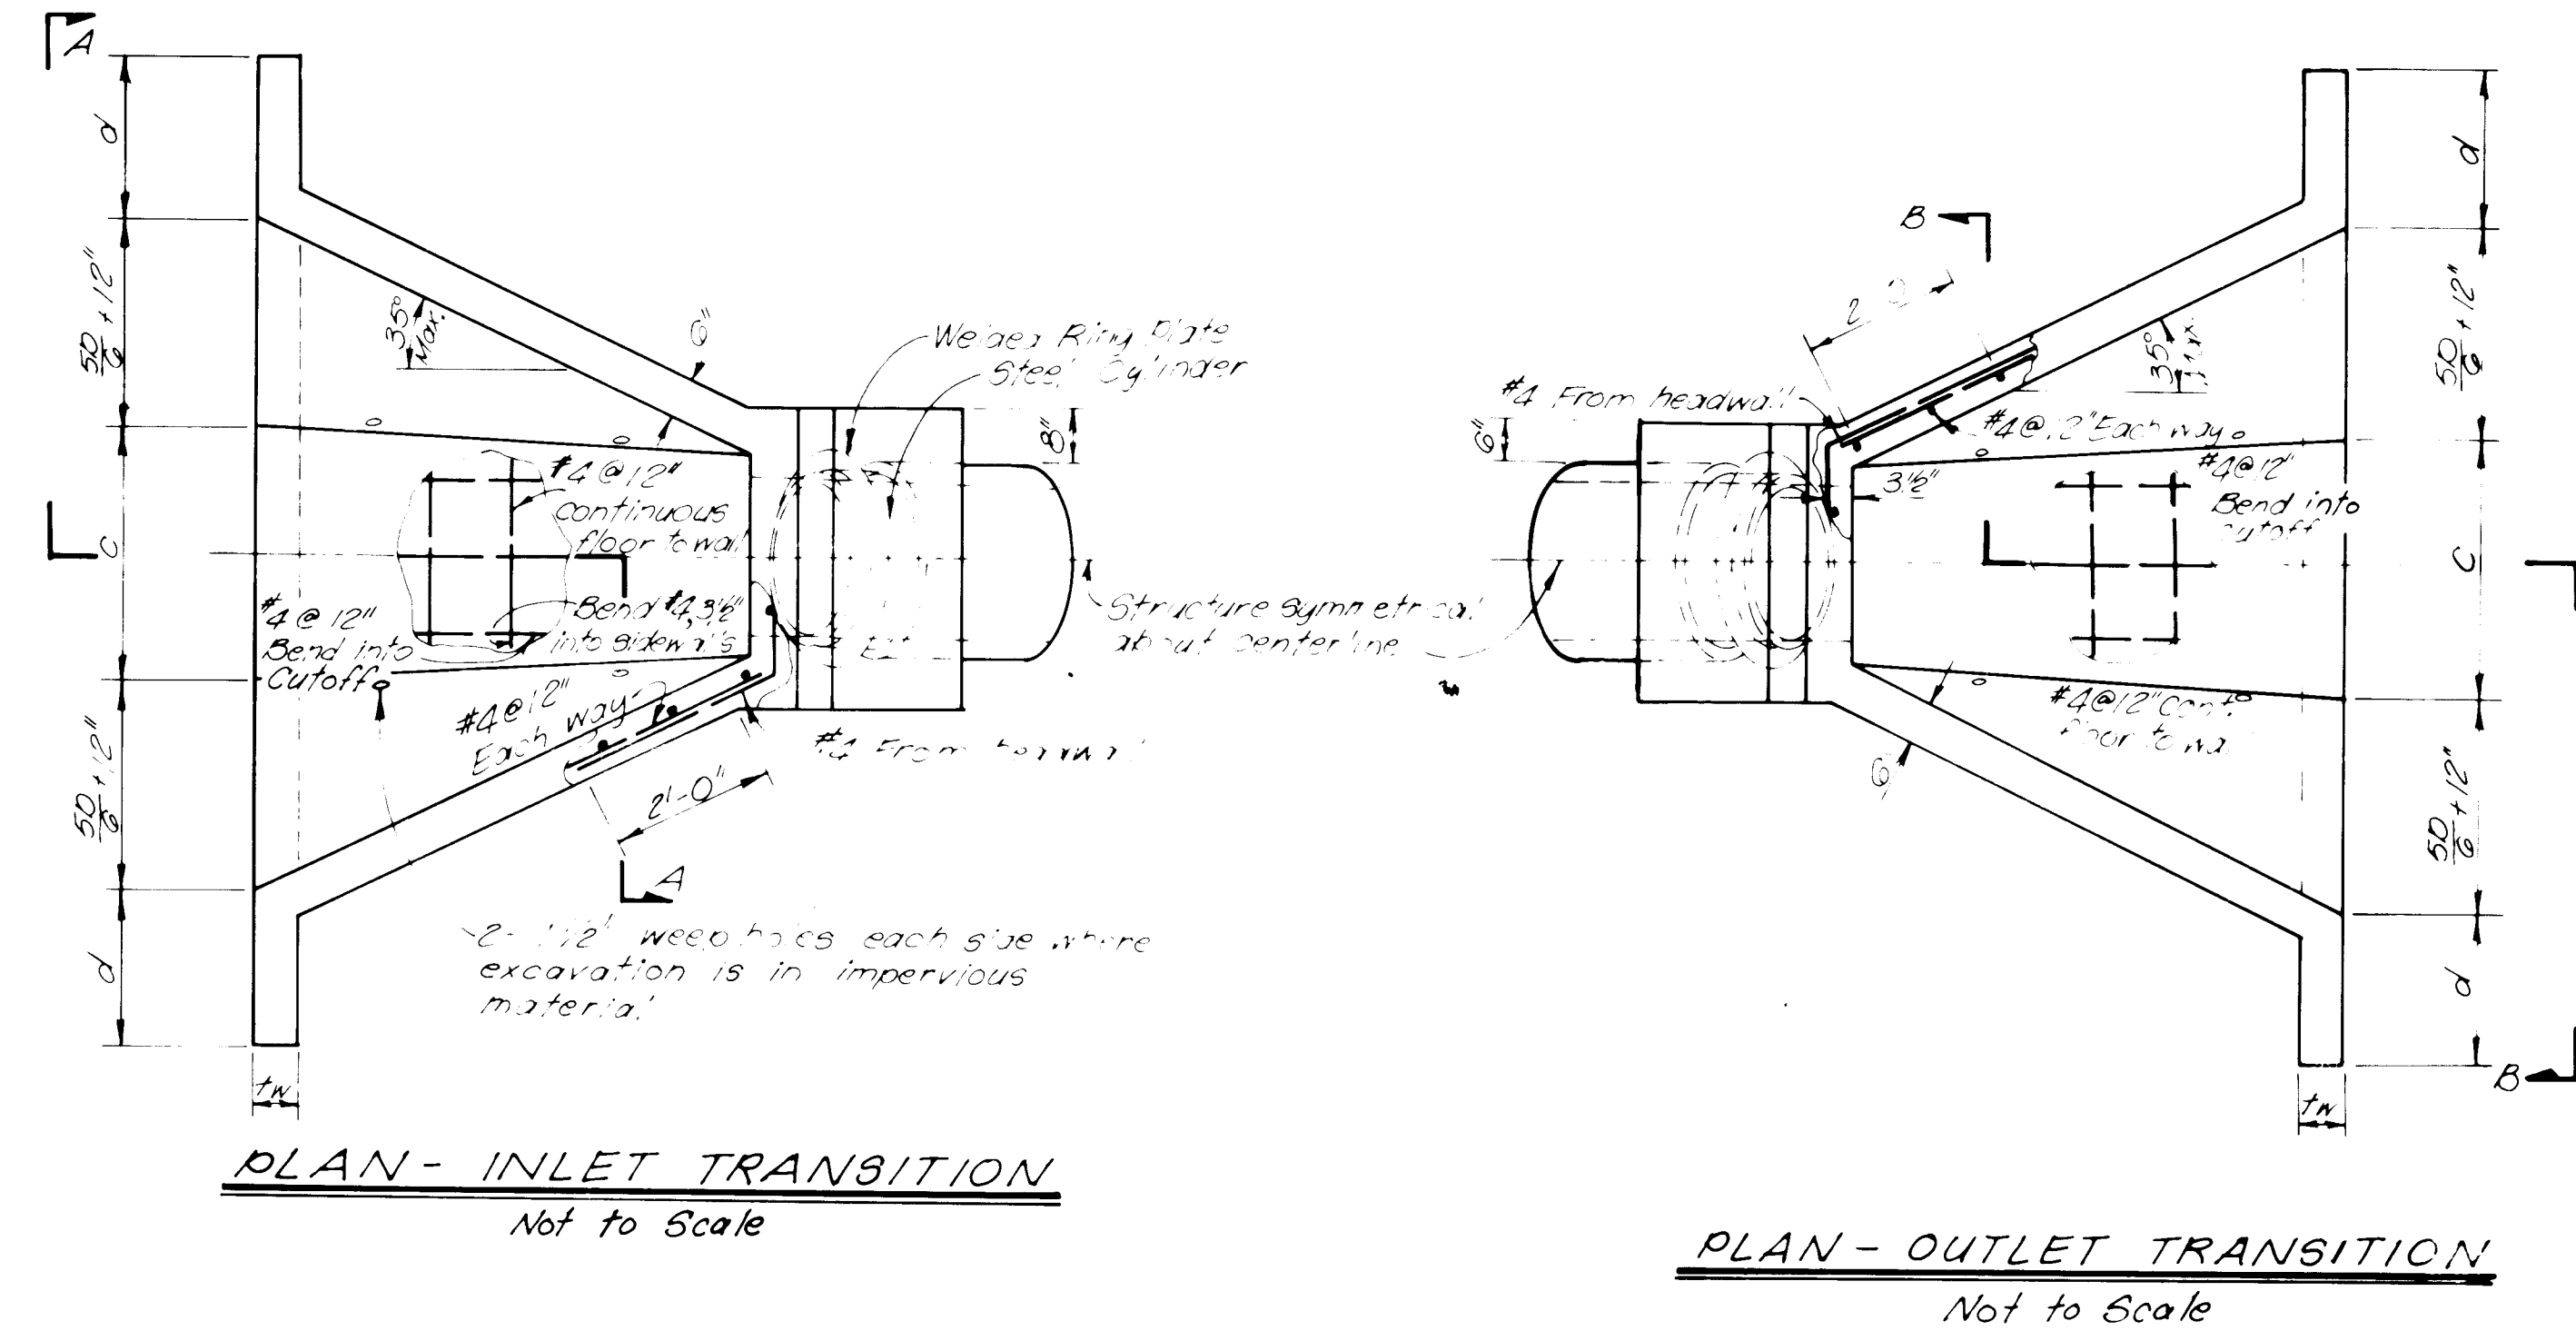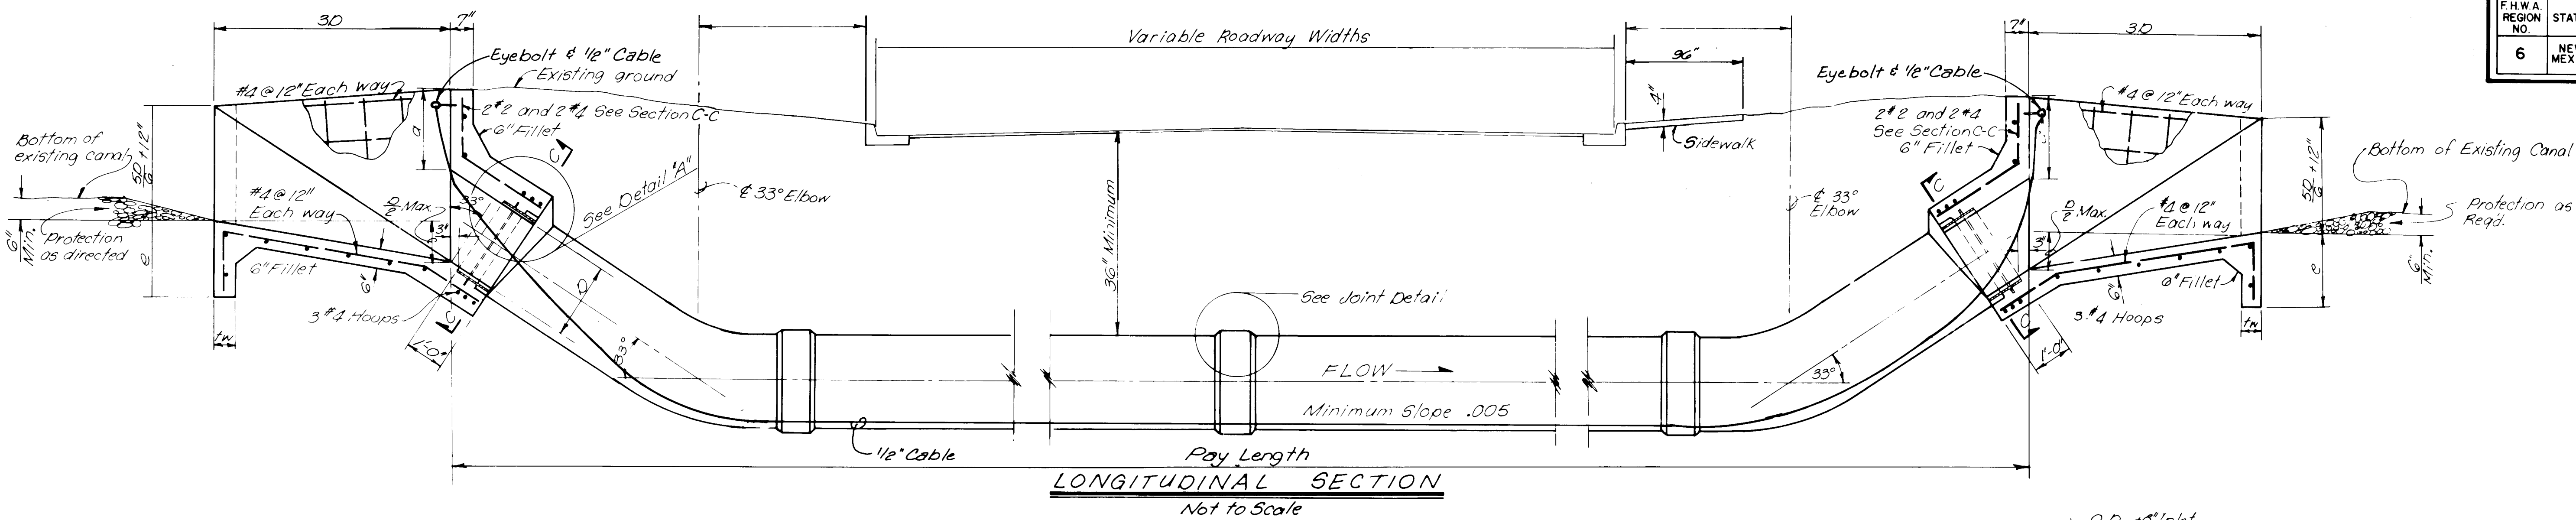

- NOTES:
1. All reinforcement in monolithic concrete shall be placed so that the centers of bars in the outer layer will be 2" from outer face, unless otherwise shown.
 2. Lap all bars 20 diameters at splices.
 3. Berms may be necessary at either or both headwalls to suit actual laying length of pipe.
 4. Values of c as given in table of dimensions may be changed as directed if 35° max. transition wall divergence is not exceeded.
 5. Chamfer all exposed corners 3/4".
 6. Pipe may be Steel Cylinder or Low Pressure Reinforced Concrete Waterpipe with Amseal joint or equal.
 7. Railing incidental to completion of Pipe.
 8. Add 1/2" Cable with eye bolts for Cleanout Purposes incidental to pipe.

D	a	c	d	e	fw
18"	24"	2'4"	18"	18"	6"
24"	2'2"	3'2"	24"	24"	6"
30"	2'6"	4'0"	2'6"	2'6"	8"
36"	2'8"	4'8"	2'6"	2'6"	8"
42"	2'10"	5'8"	2'6"	2'6"	8"
48"	3'0"	6'6"	2'6"	2'6"	8"
54"	3'0"	7'4"	2'6"	2'6"	8"
60"	3'0"	8'2"	2'6"	2'6"	8"
72"	3'0"	9'10"	2'6"	2'6"	8"
84"	3'0"	11'6"	2'6"	2'6"	8"

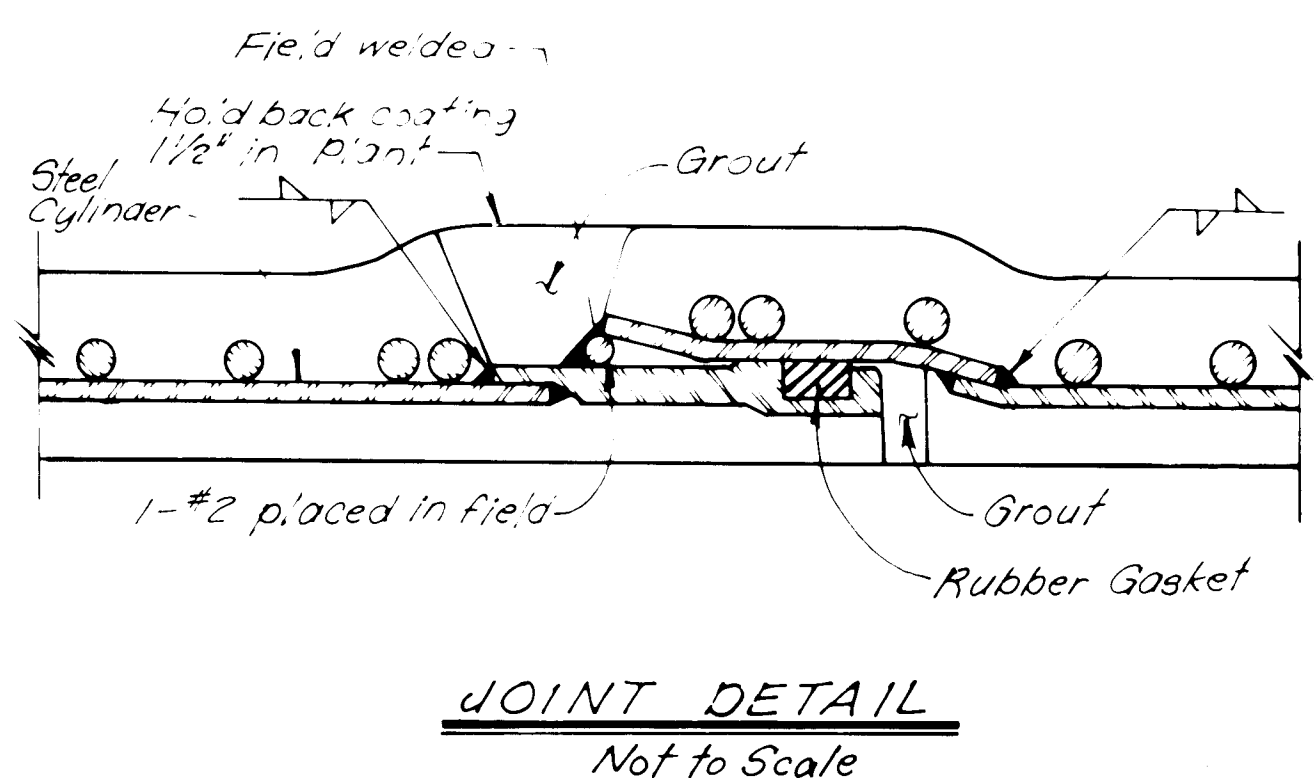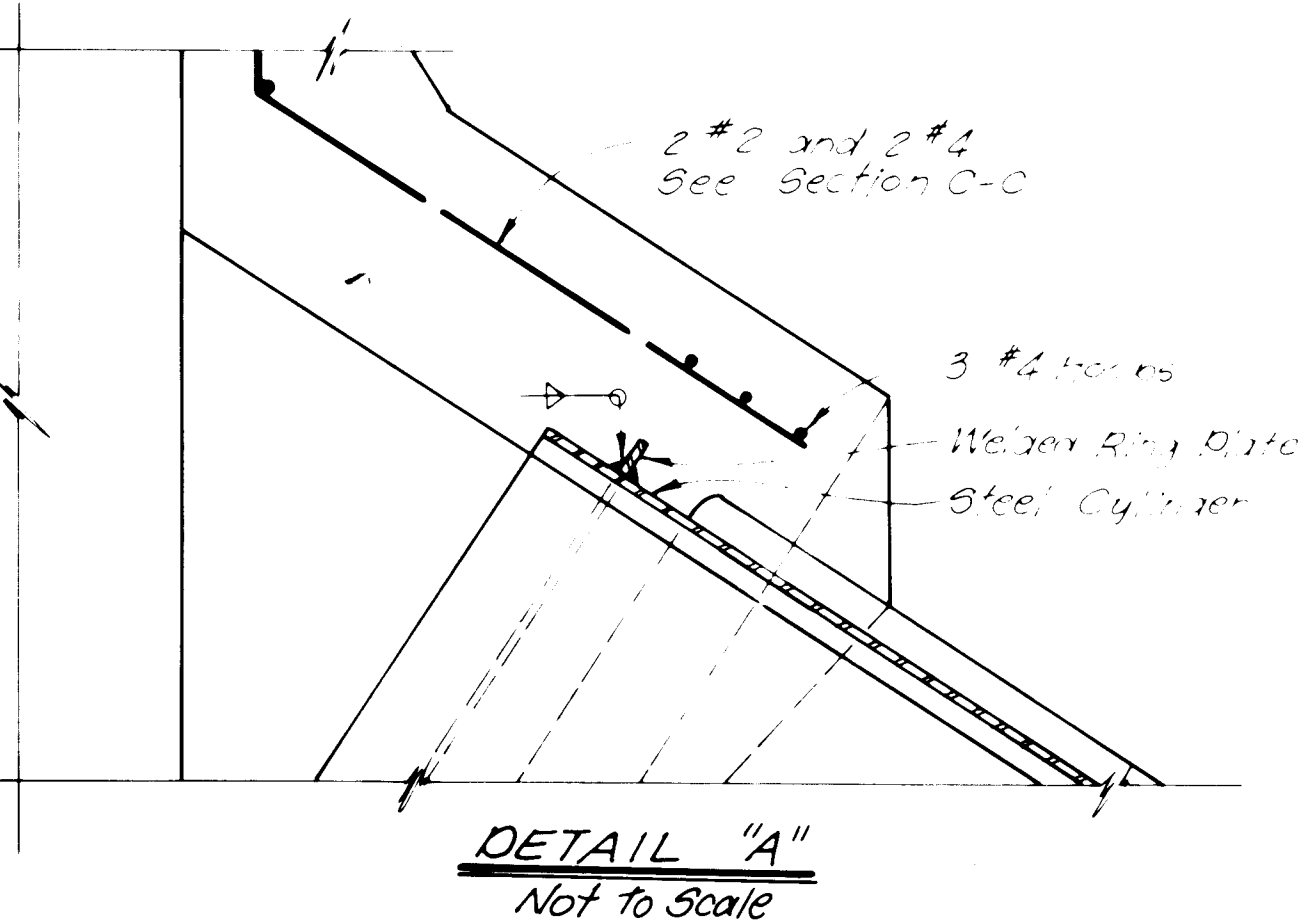

NOTE: Siphon shall be paid for as 30" RCP Item No. 501331 at Sta. 311+00

Headwalls will be paid for as Class A concrete and reinforcing bars, Grade 40 (8.0 cy Cl A concrete #1600 lbs Gr 40 ReinP steel for 1 Headwall)

C of A PWD Maps & Records

26	34	73	02	91
----	----	----	----	----

RECORD DRAWING
DATE 9-11-89
J. M. P.

GENERAL NOTES

1. C.M.P. Slotted Drain shown on this drawing is patented by Armco; Ramco; Republic or approved equal is acceptable.
2. Bearing bars and solid web spacers shall conform to A.A.S.H.T.O. specification M-183 and shall be galvanized in conformance with A.A.S.H.T.O. specification M-111.
3. After bearing bars are welded to the pipe the welded areas shall be painted with zinc-rich paint.
4. See serial MDI-I Sht.1 for C.M.P. connections to crossdrains.
5. Cost of "Tees" shall be included in the unit price bid for culvert pipe and no additional payment will be made therefor.
6. Cost of Class "A" concrete to be included in the unit price bid for corrugated steel slotted pipe.
7. Size of C.M.P. shall be as shown on the plans.
8. When C.M.P. Slotted Drain is NOT encased in concrete backfill as recommended by the Manufacturer.










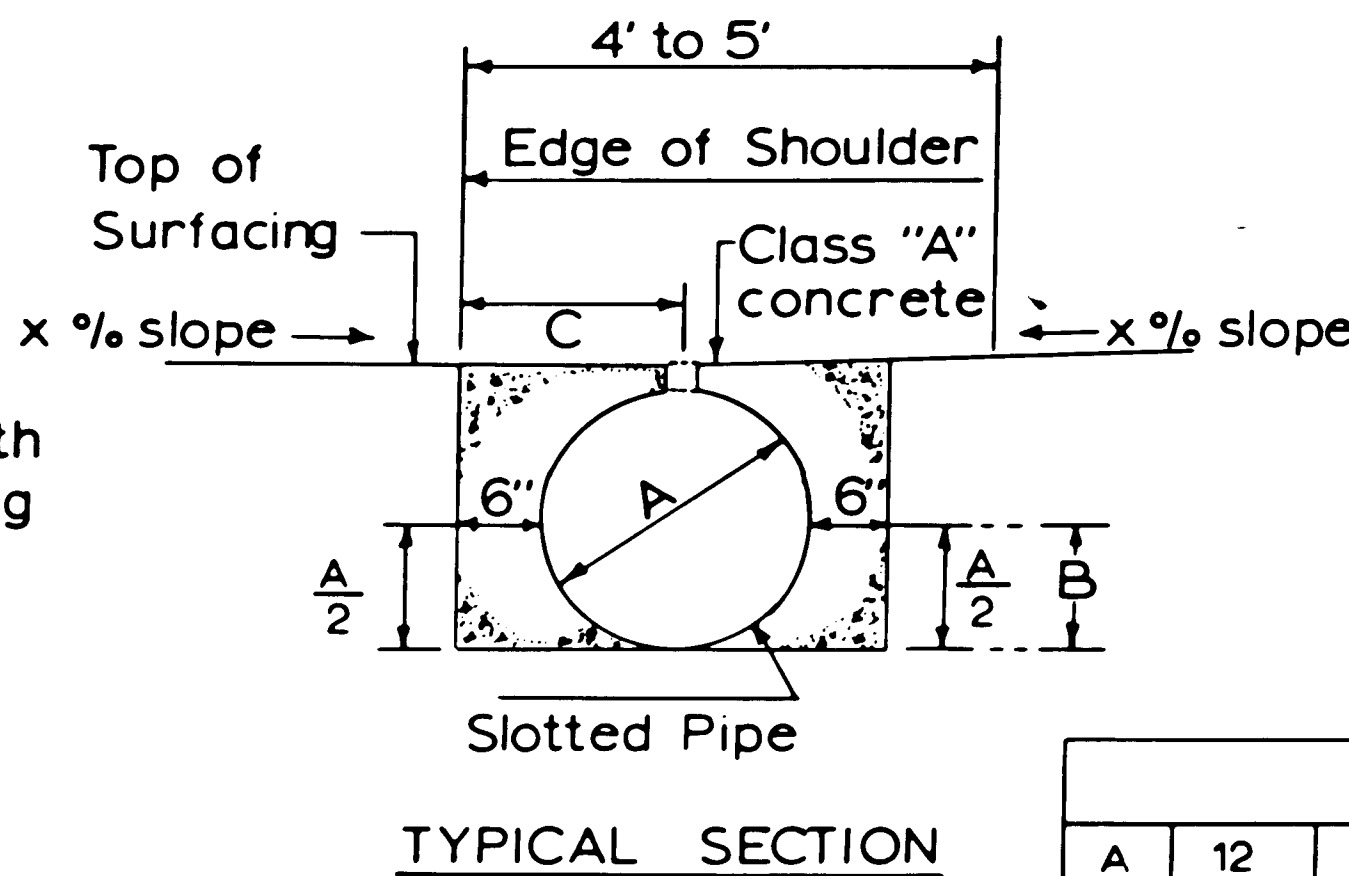


TABLE X DIMENSIONS (inches)					
A	12	15	18	24	30
B	6	7.5	9	12	15
C	12	13.5	15	18	21

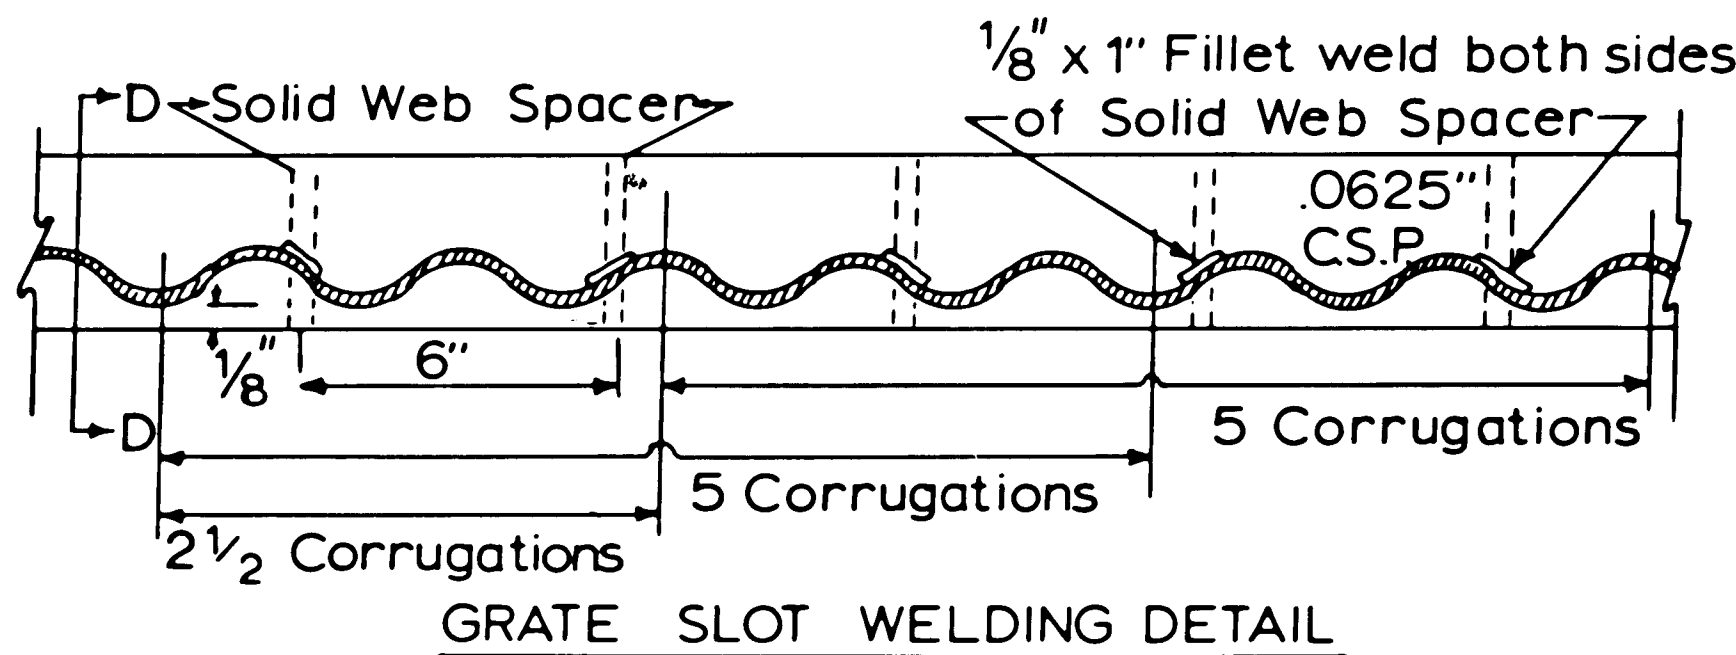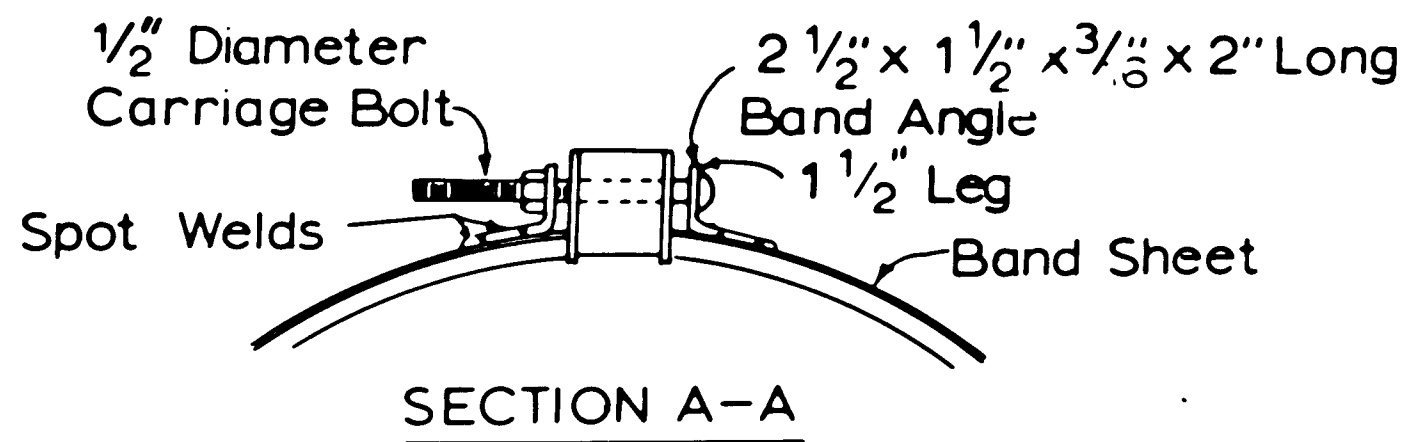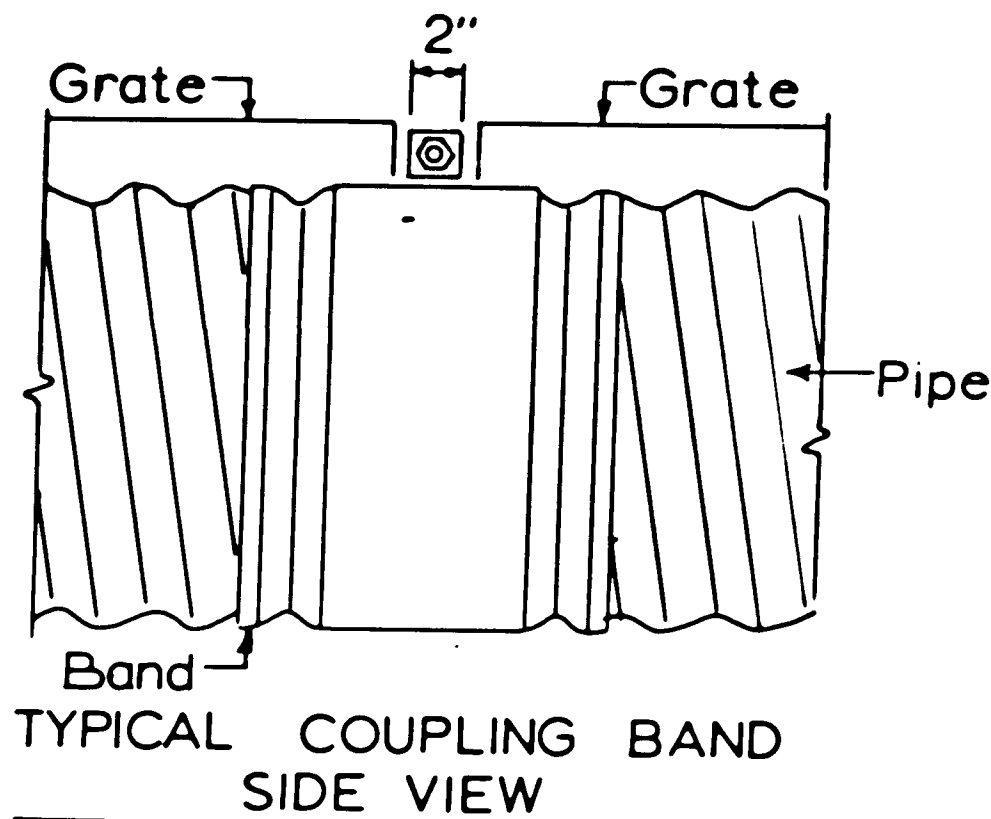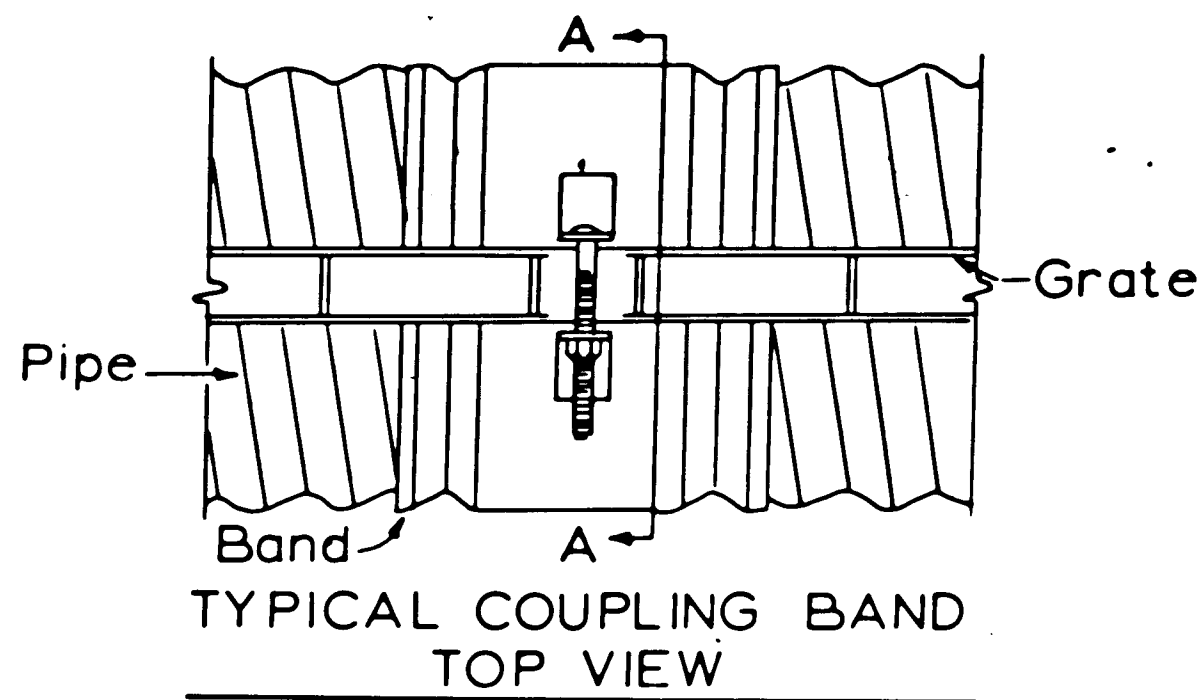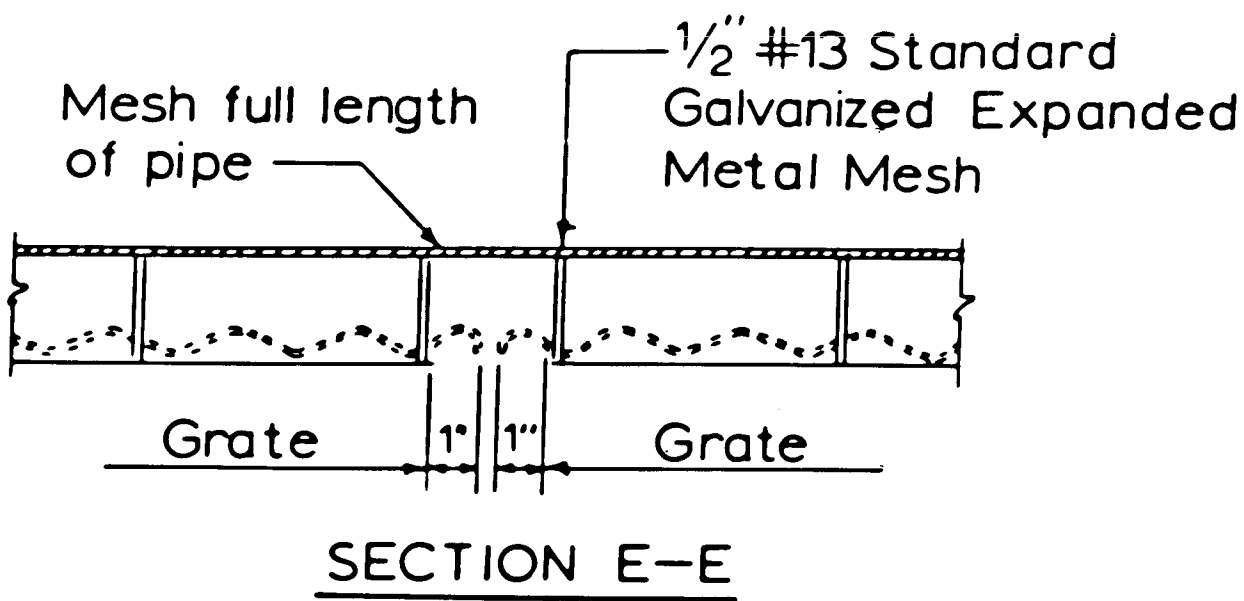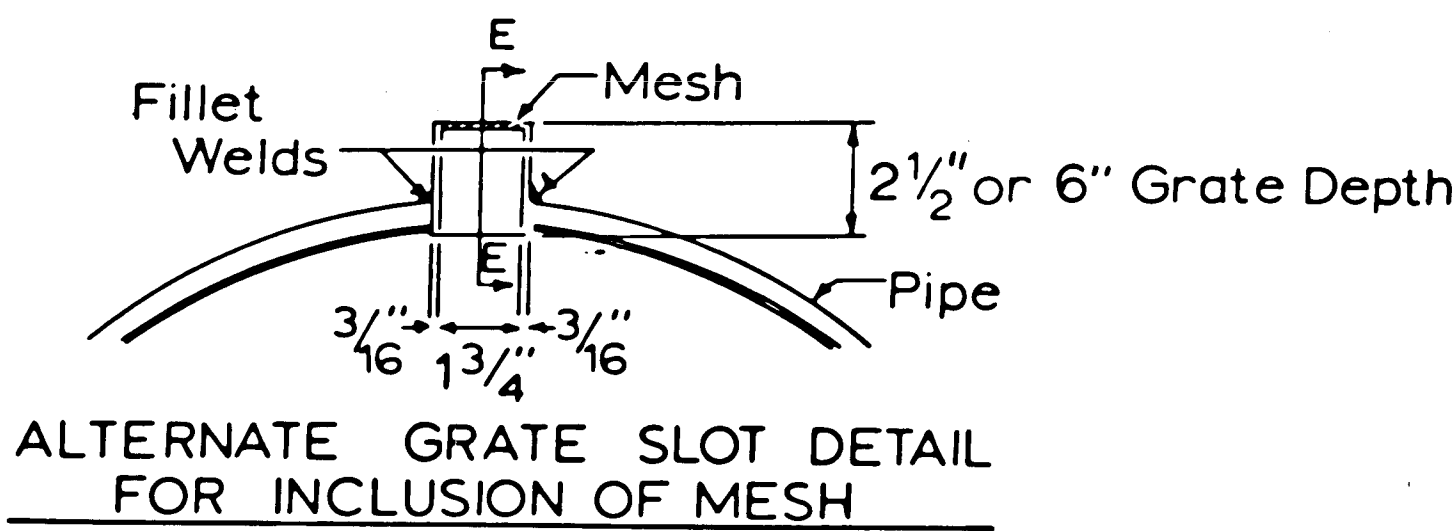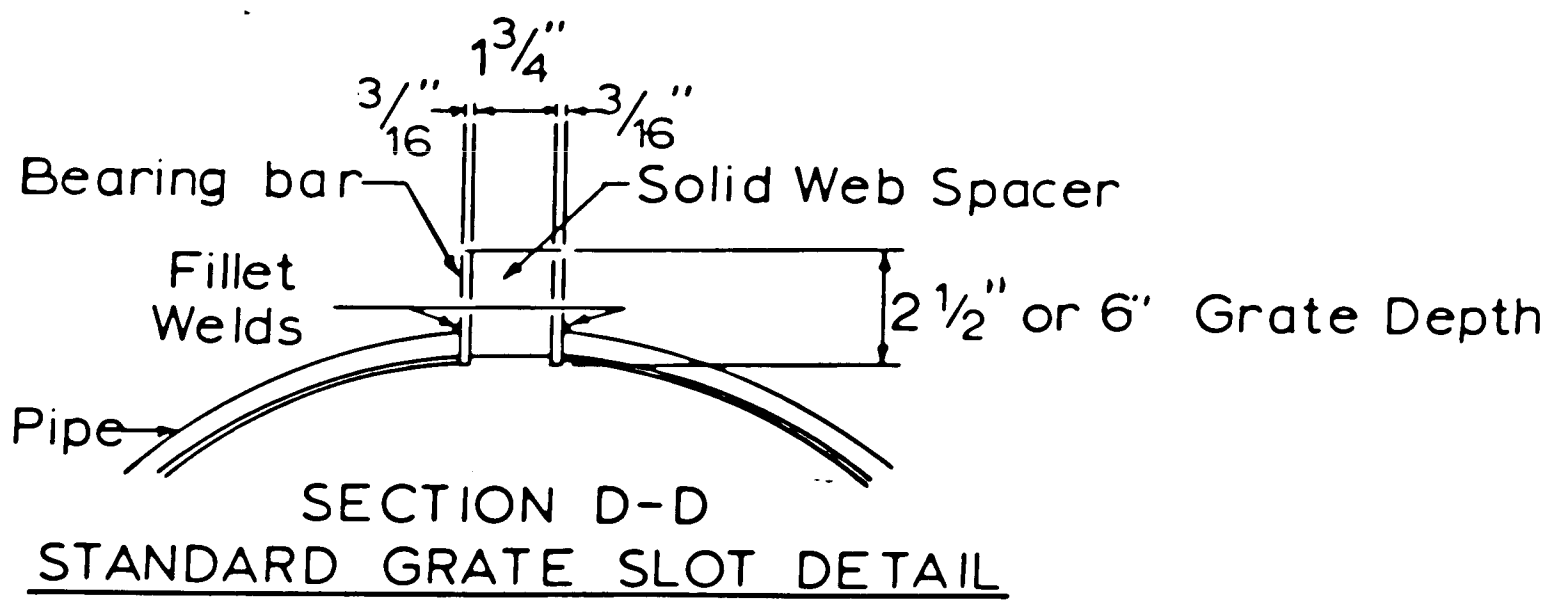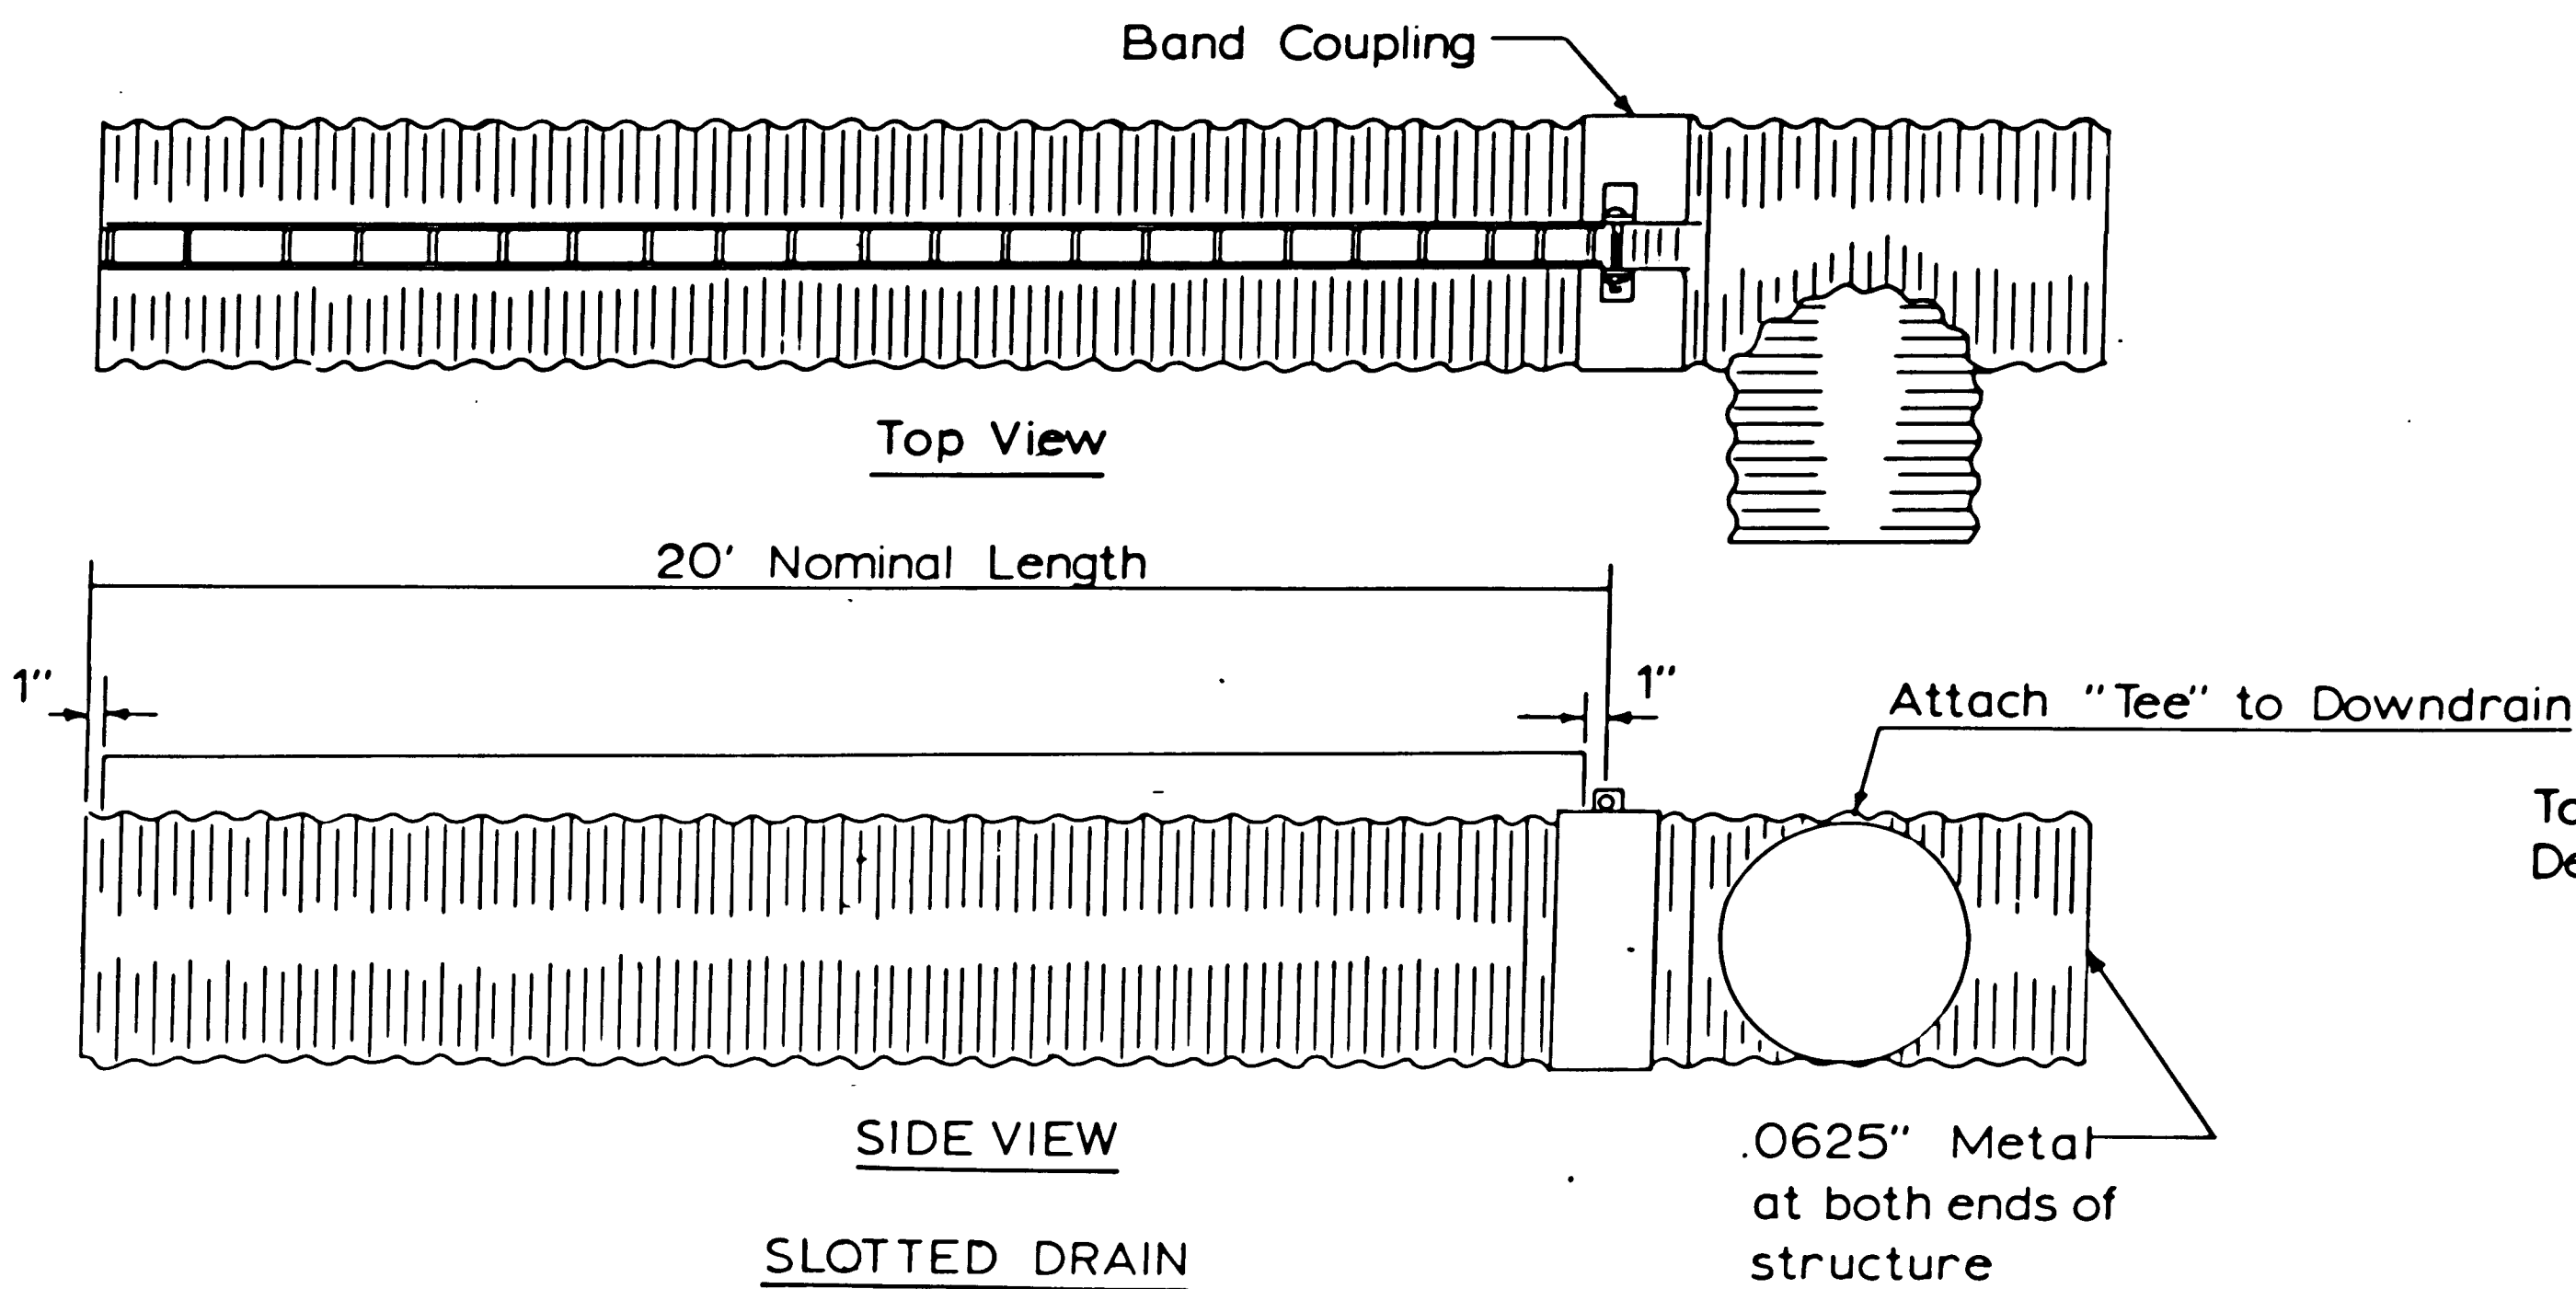

To Conform with
Design Surfacing

To Conform with
Design Surfacing

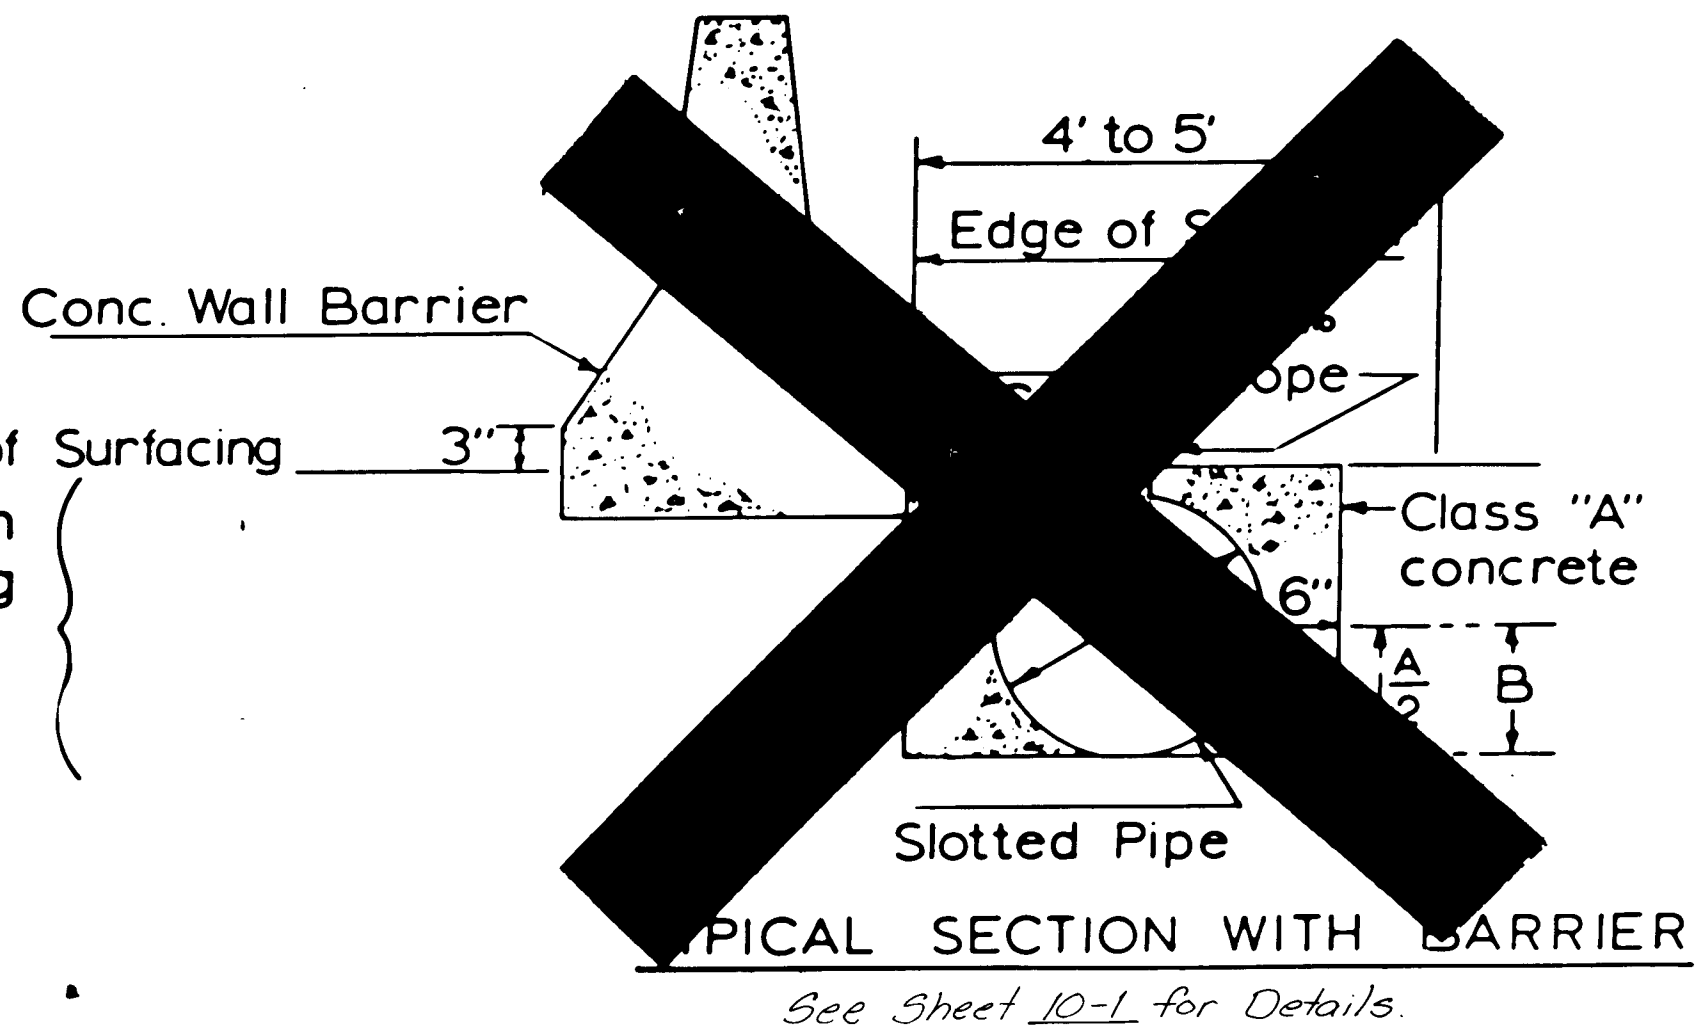

See Sheet 10-L for Details.

C of A PWD Maps & Records

1	2	3	4	5	6	7	8	9	10	11	12
2	6	3	9	7	3	0	3	9	1		

IDENT NO.	DESCRIPTION	DATE	BY
	REVISIONS (OR CHANGE NOTICES)		
NEW MEXICO STATE HIGHWAY DEPARTMENT			
C.S.P. SLOTTED DRAIN			
LAYOUT AND UPDATE BY: A.D.C.O.	APPROVAL RECOMMENDED - HWY DESIGN ENGINEER	DATE	
DRAFTED BY: D.M.B.	APPROVED	DATE	
CHECKED BY: A.R. Jr.	DIRECTOR, PROJ. DEVELOPMENT DIV.	DATE	
DRAWING - 002		SHEET	OF

NOTE:

This project begins in Town of Alameda Grant Sections 15 & 16 as projected, T. 11 N., R. 3 E., N.M.P.M.


Arc definition used Horizontal Curves (Radius of a 1° curve = 5729.58)

Earthwork Computations and Cross Section Quantities are for estimating purposes only. Final payment will be made on Slope Stake Quantities computed during Construction.

PLAN	DATE	BY
SURVEYED		
NOTED		
ALIGNED		
CHECKED		
RT. OF WAY		

PROFILE	DATE	BY
SURVEYED		
NOTED		
GRADES		
CHECKED		
STRUCTURE		
NOTATIONS		

F.H.W.A. REGION NO.	STATE	PROJECT NO.	FISCAL YEAR	SHEET NO.	TOTAL SHEETS
6	N.M.	SP-008-60-00 02-00		3-1	

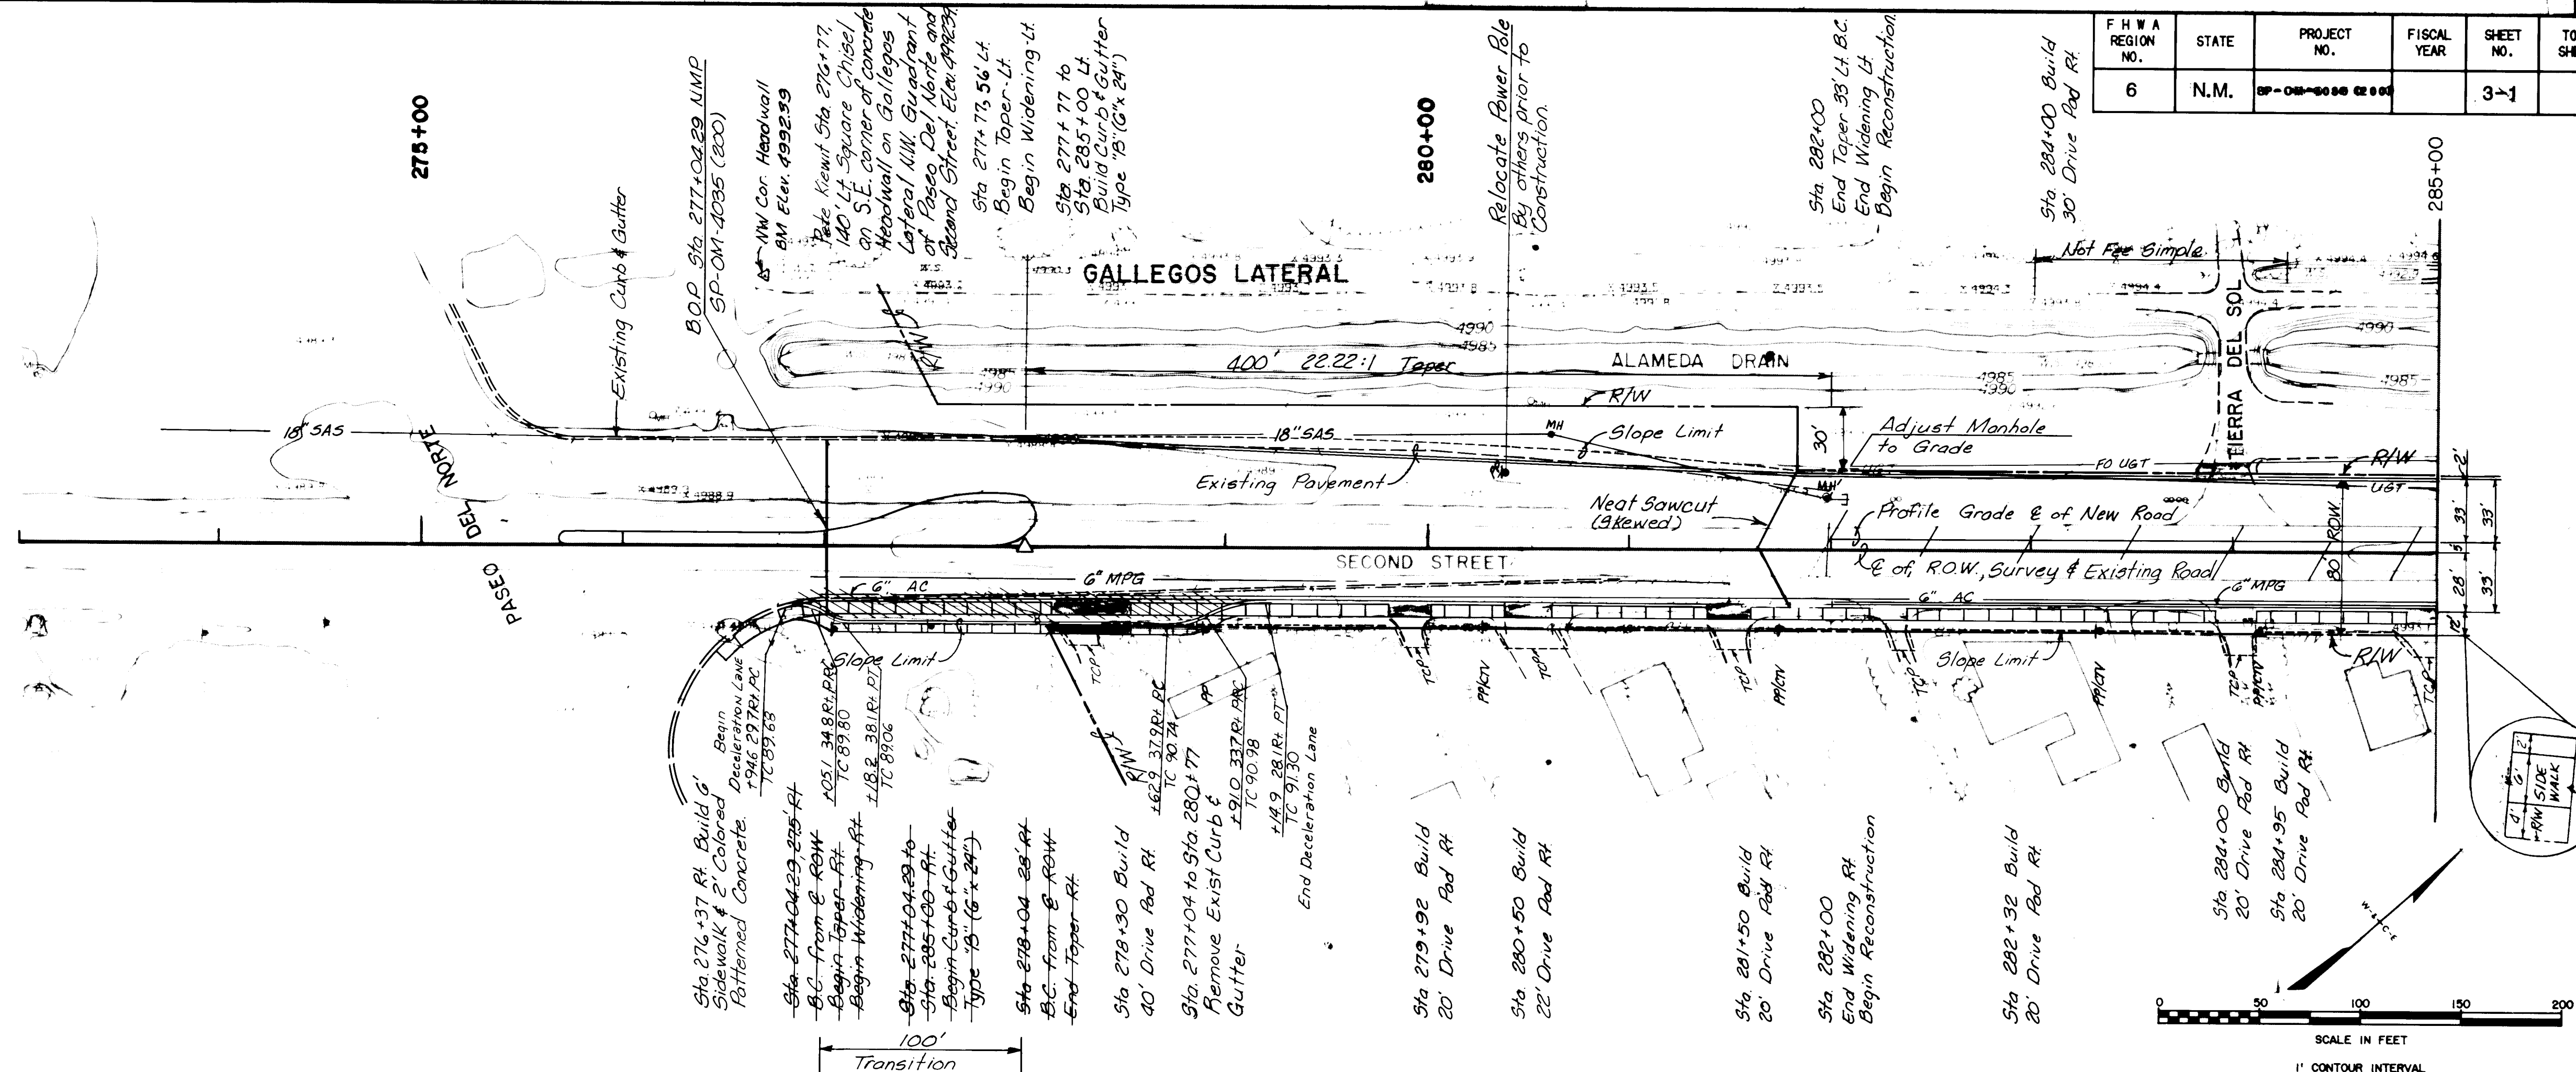

UTILITY OWNERS

Water & Sewer
City of Albuquerque
P.O. Box 1293
Albuquerque, New Mexico 87103
Attn: Buddy Smith (823-4250)


Gas
Gas Company of New Mexico
4625 Edith Blvd. N.W.
Albuquerque, New Mexico 87107
Attn: Steve Liparato (833-2521)

Telephone
Mountain Bell Telephone
505 Marquette NW, Box 954
Box 1335
Albuquerque, New Mexico 87103
Attn: Becky Olsen (765-5699)

Cable
Jones Intercable
2633 Tennessee N.E.
Albuquerque, New Mexico 87110
Attn: Yvette Guazo (761-6200)

Electric
Public Service Company
of New Mexico
4201 North Edith N.E.
Albuquerque, New Mexico 87107
Attn: Terry Moynihan (761-3304)

U.S. Postal Service
Delivery & Collection
1135 Broadway N.E.
Albuquerque, New Mexico 87101-3601
Attn: Al Bago (848-3063)

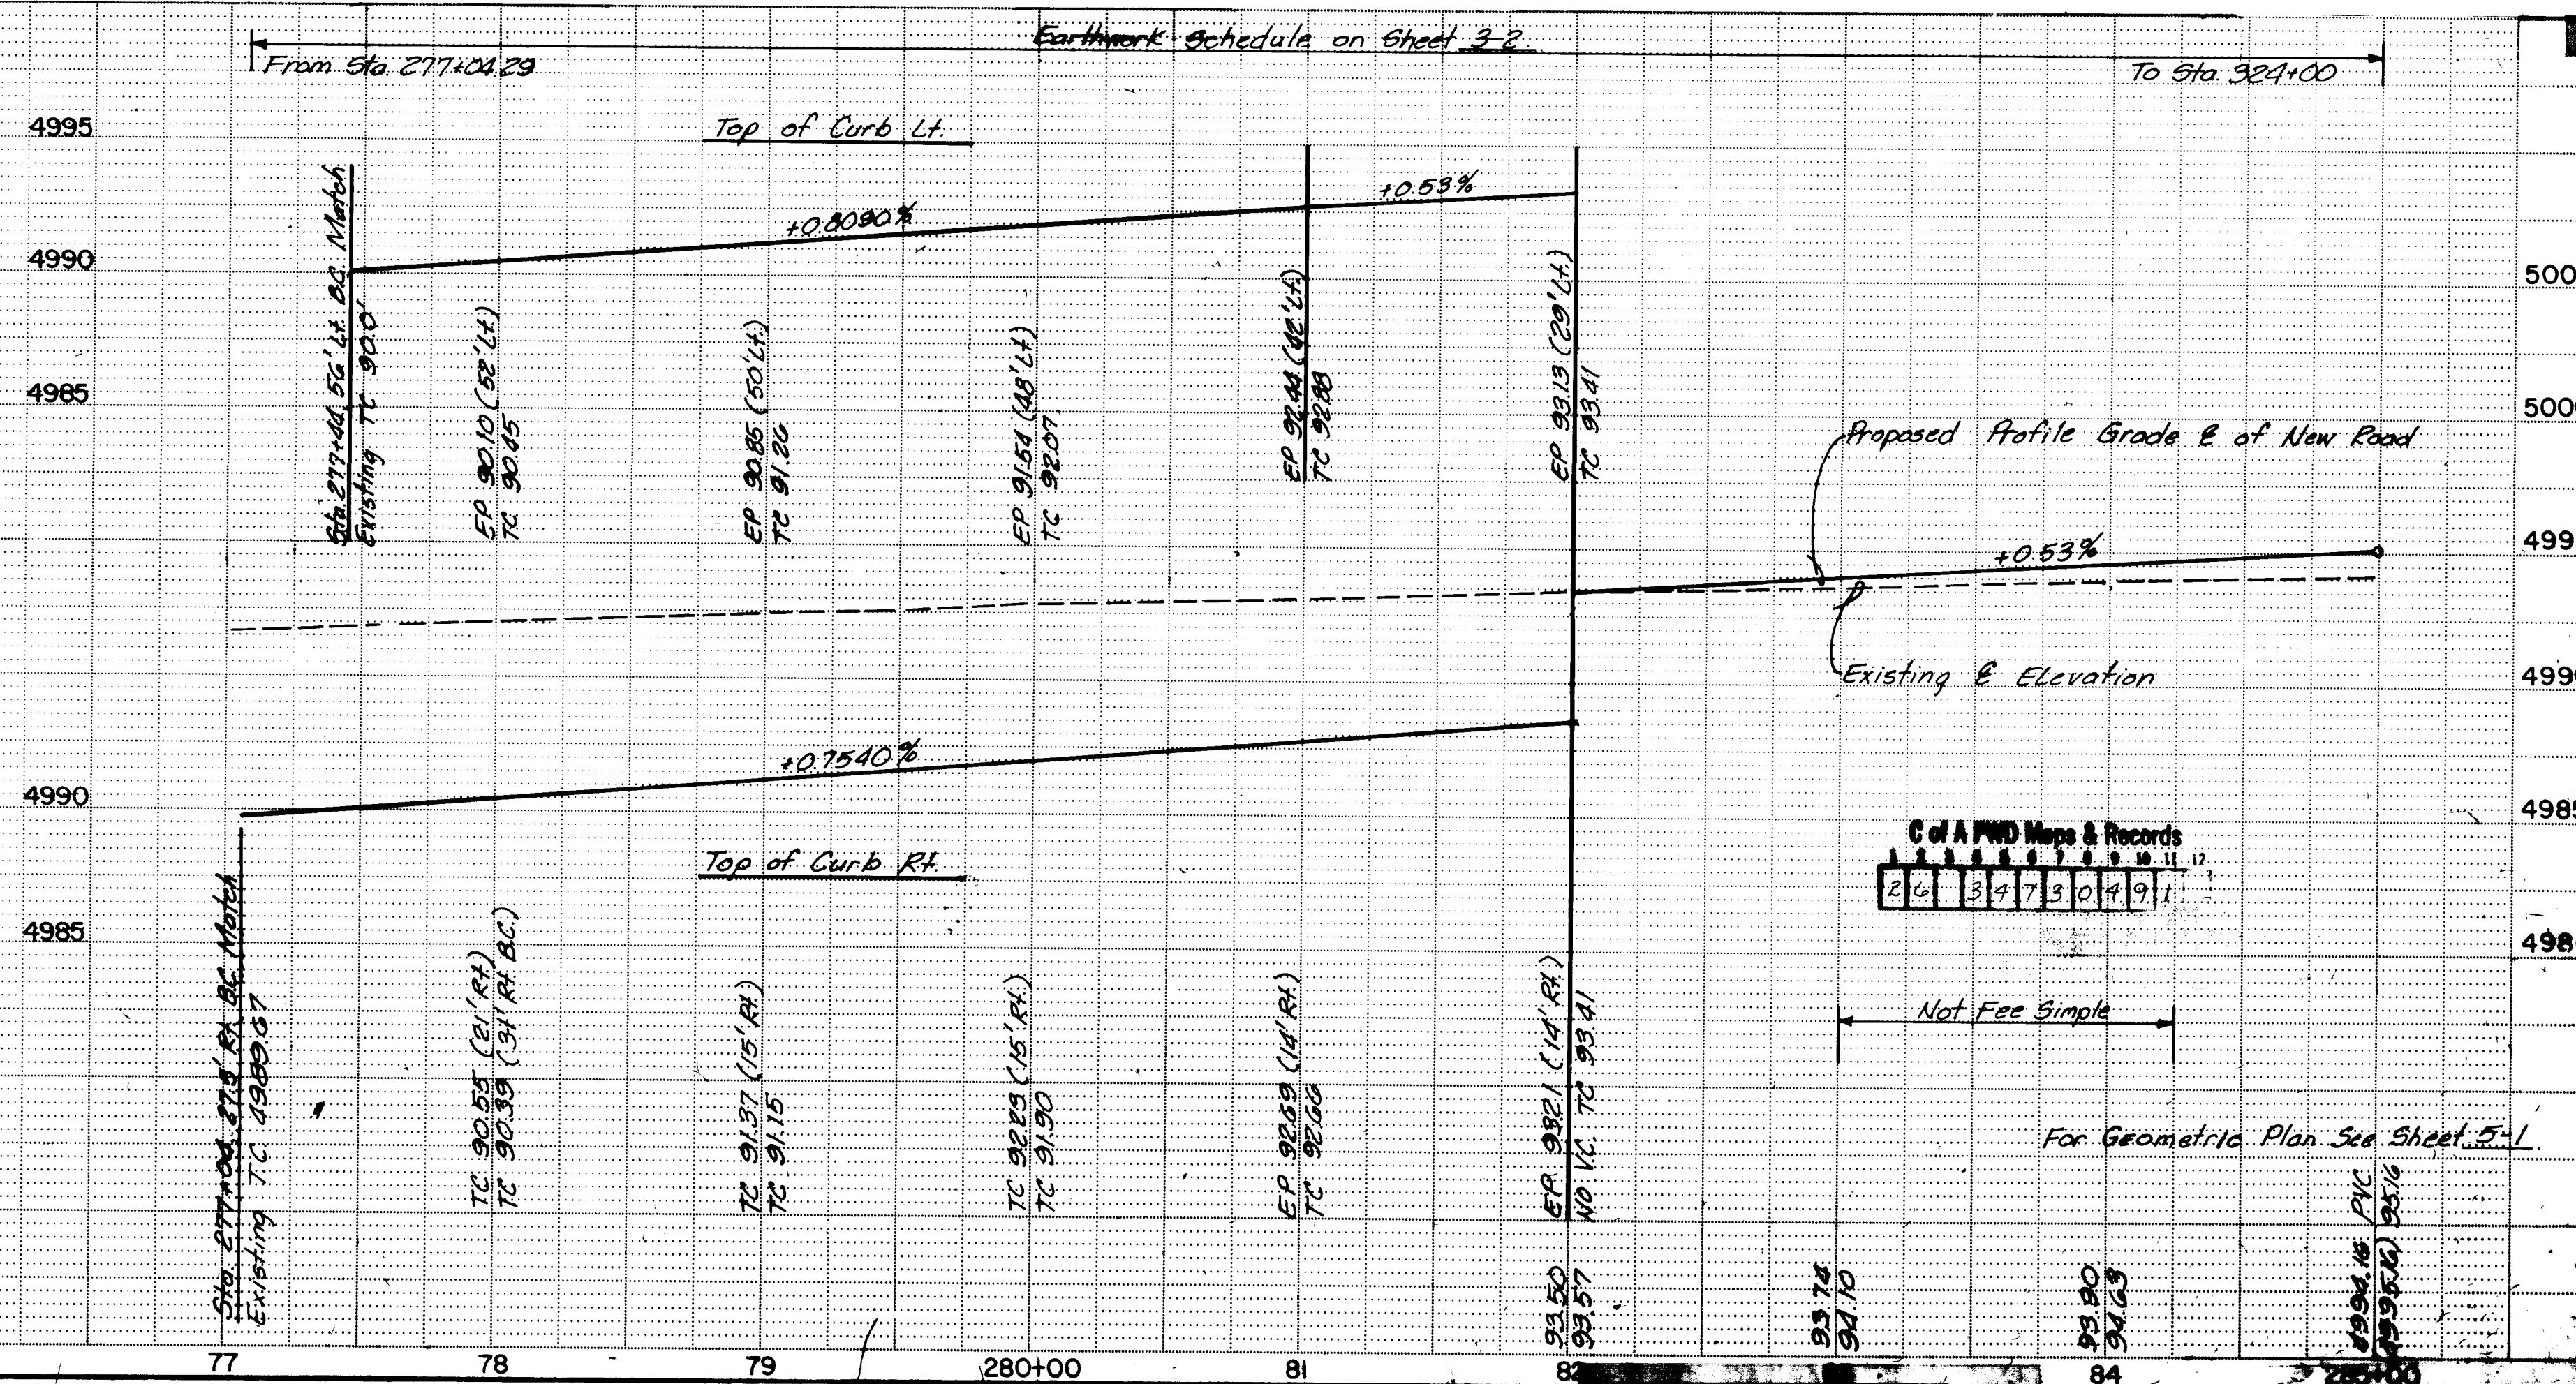


C of A PWD Maps & Records
26 31 73 0 4 9

For Geometric Plan See Sheet 5-1

RECORD DRAWING
DATE 2-1-61

PROFILE		BY	DATE
SURVEYED			
PLOTTED			
NOTE BOOK			
NO.			
B. M. NOTED			
STRUCTURE NOTATIONS CH'KD.			



1 2 3 4 5 6 7 8 9 10 11 12
 26 34730591

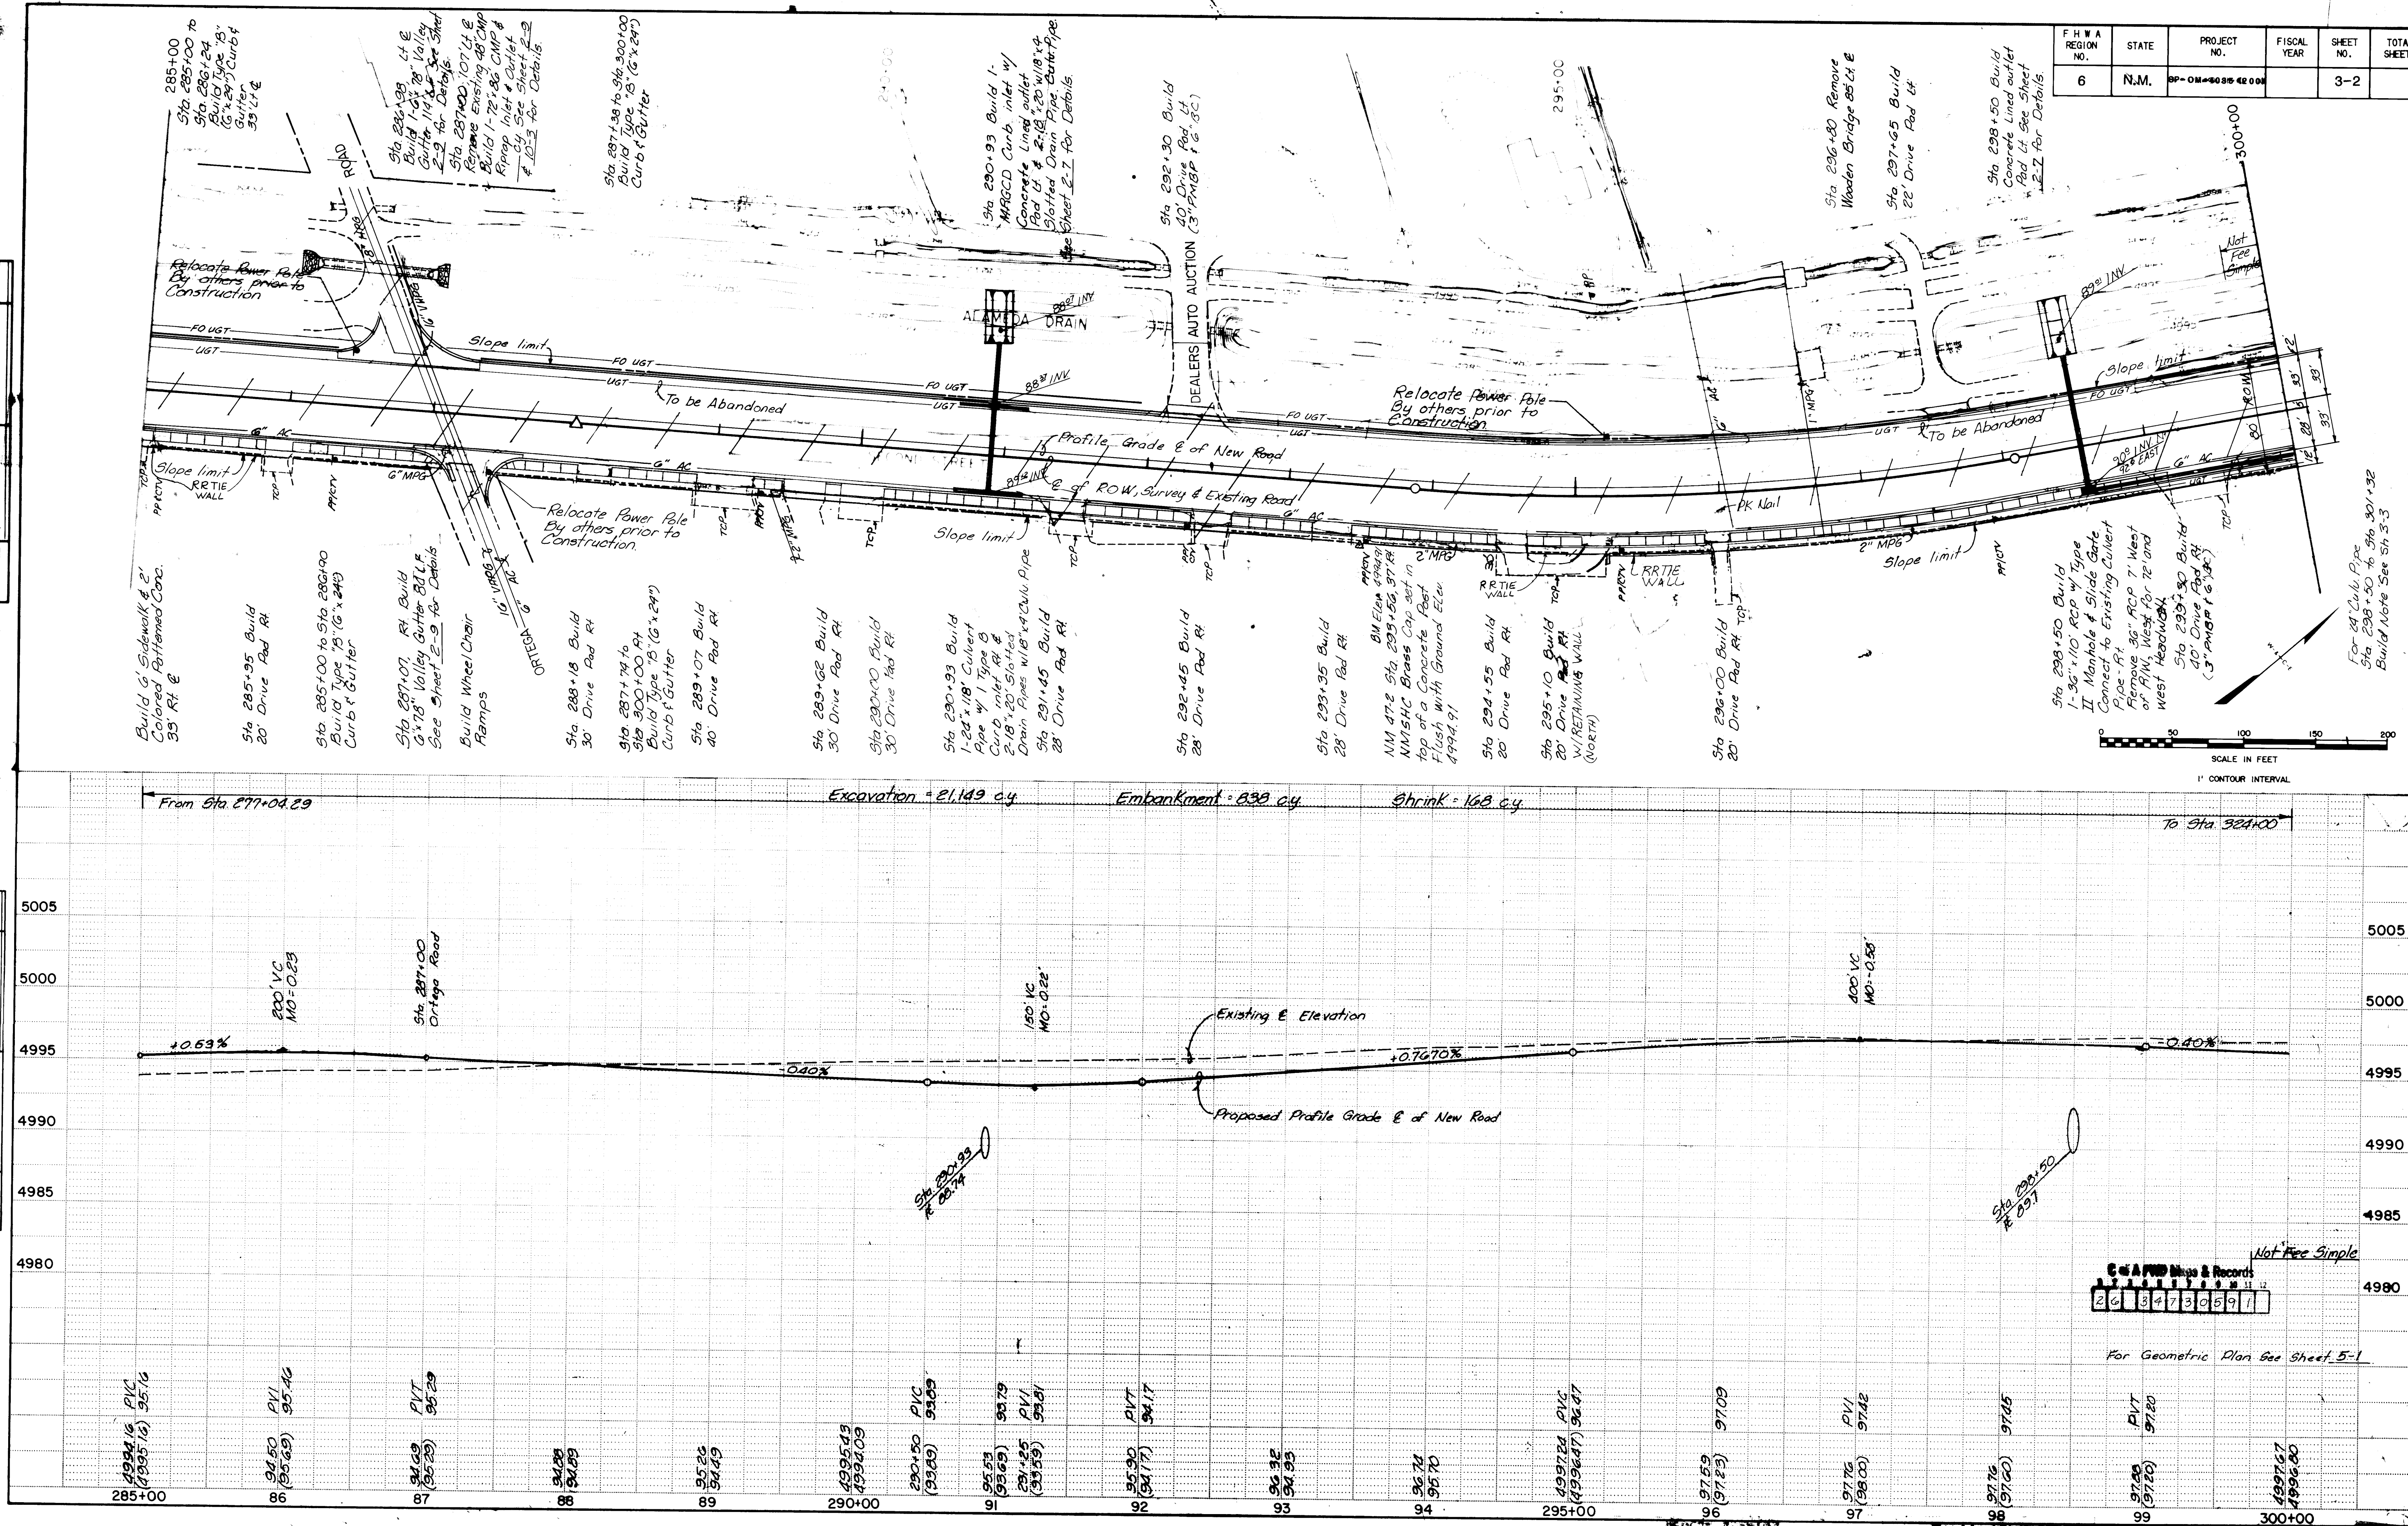

RECORD DATED 9-4-88 *Steve L. Smith* WILSON COMPANY ENGINEERS ARCHITECTS ALBUQUERQUE NEW MEXICO PROJECT NO. [REDACTED]



PLAN	SURVEYED	BY	DATE
NOTED	PLOTTED		
NOTED	GRADES CHECKED		
NOTED	STRUCTURE NOTATION CHKD		

PROFILE	SURVEYED	BY	DATE
NOTED	PLOTTED		
NOTED	GRADES CHECKED		
NOTED	STRUCTURE NOTATION CHKD		

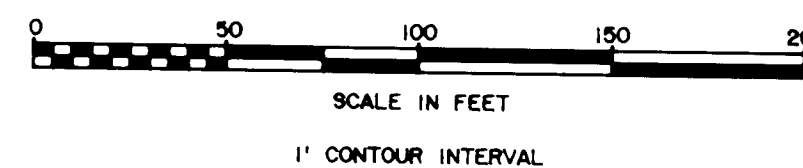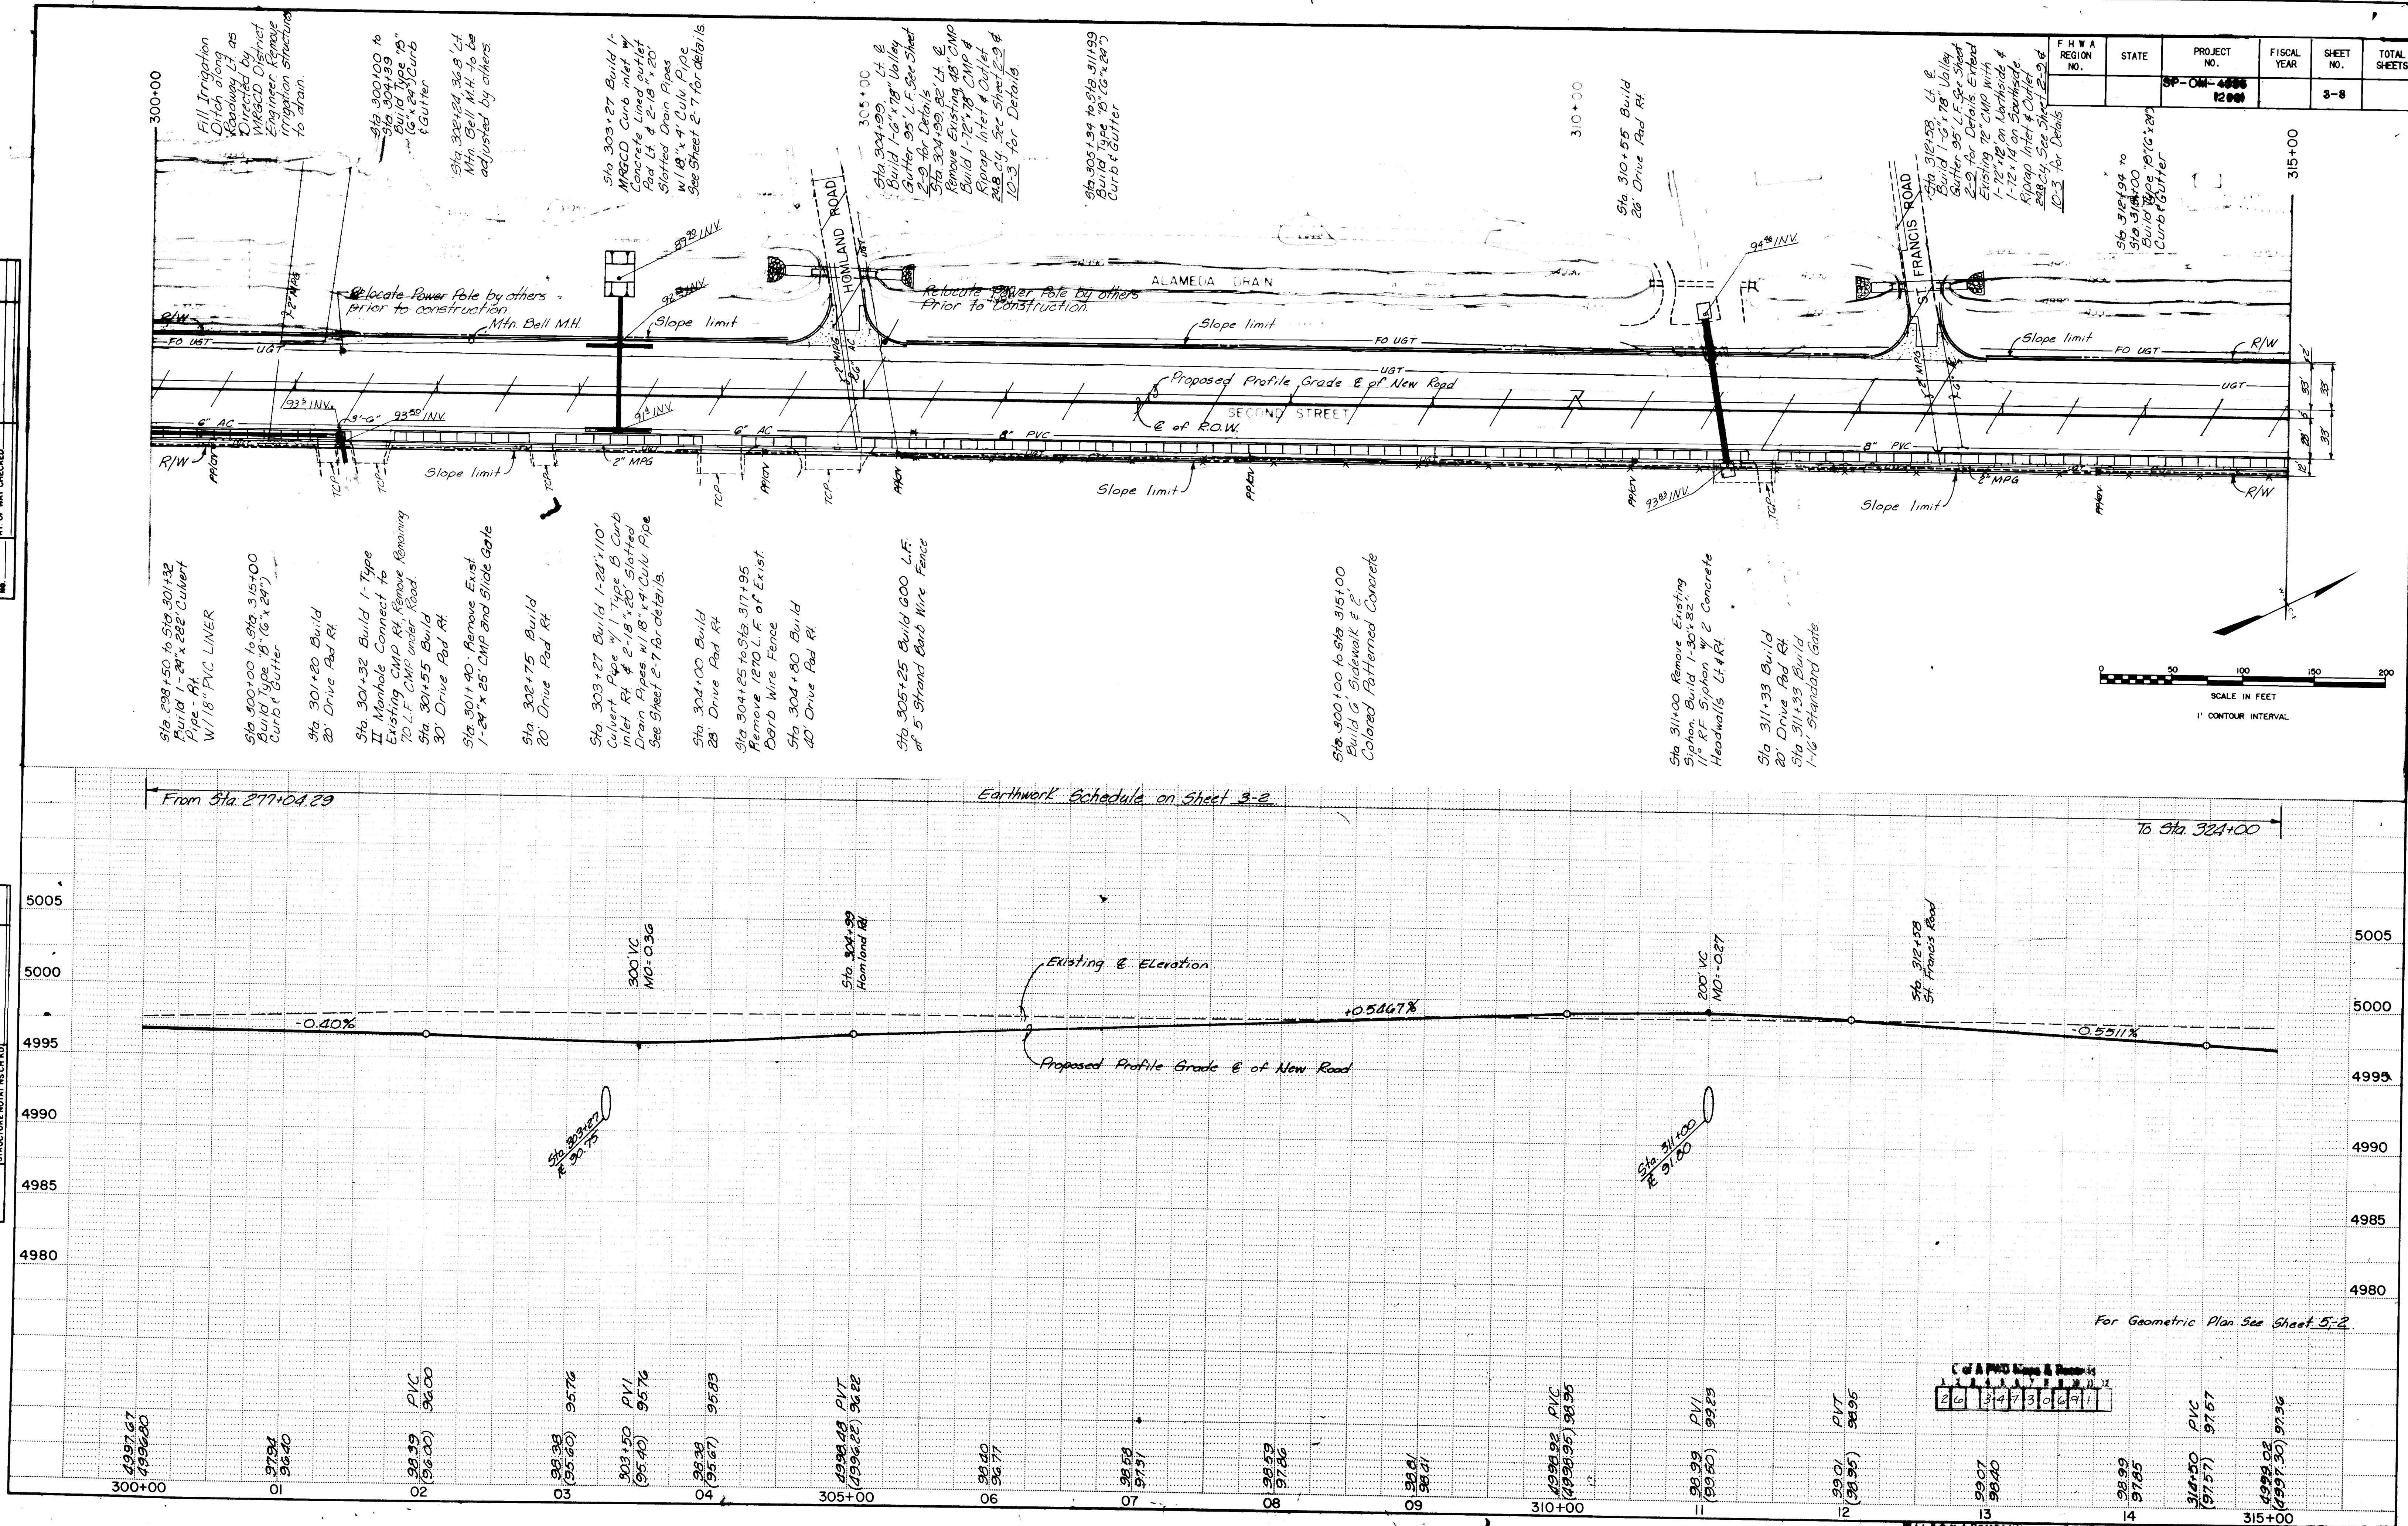

For Geometric Plan See Sheet 5-2

F.M.W.A. REGION NO.	STATE	PROJECT NO.	FISCAL YEAR	SHEET NO.	TOTAL SHEETS
6	NEW MEXICO	MP-046-0000 (2000)	19	10-1	

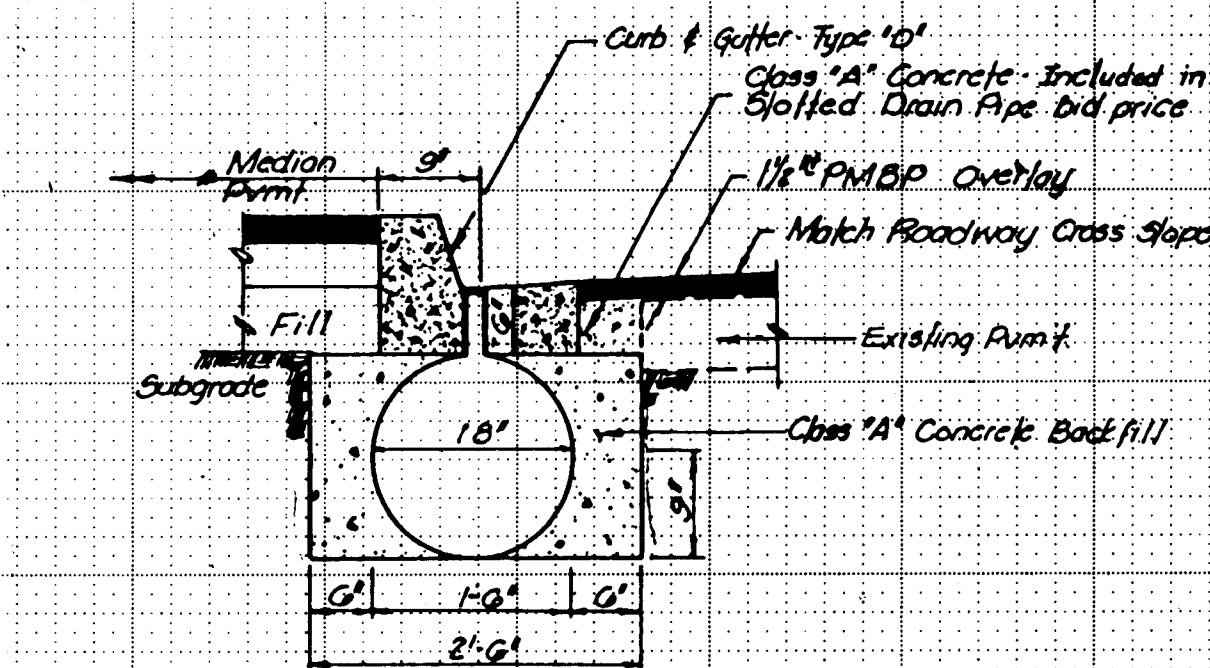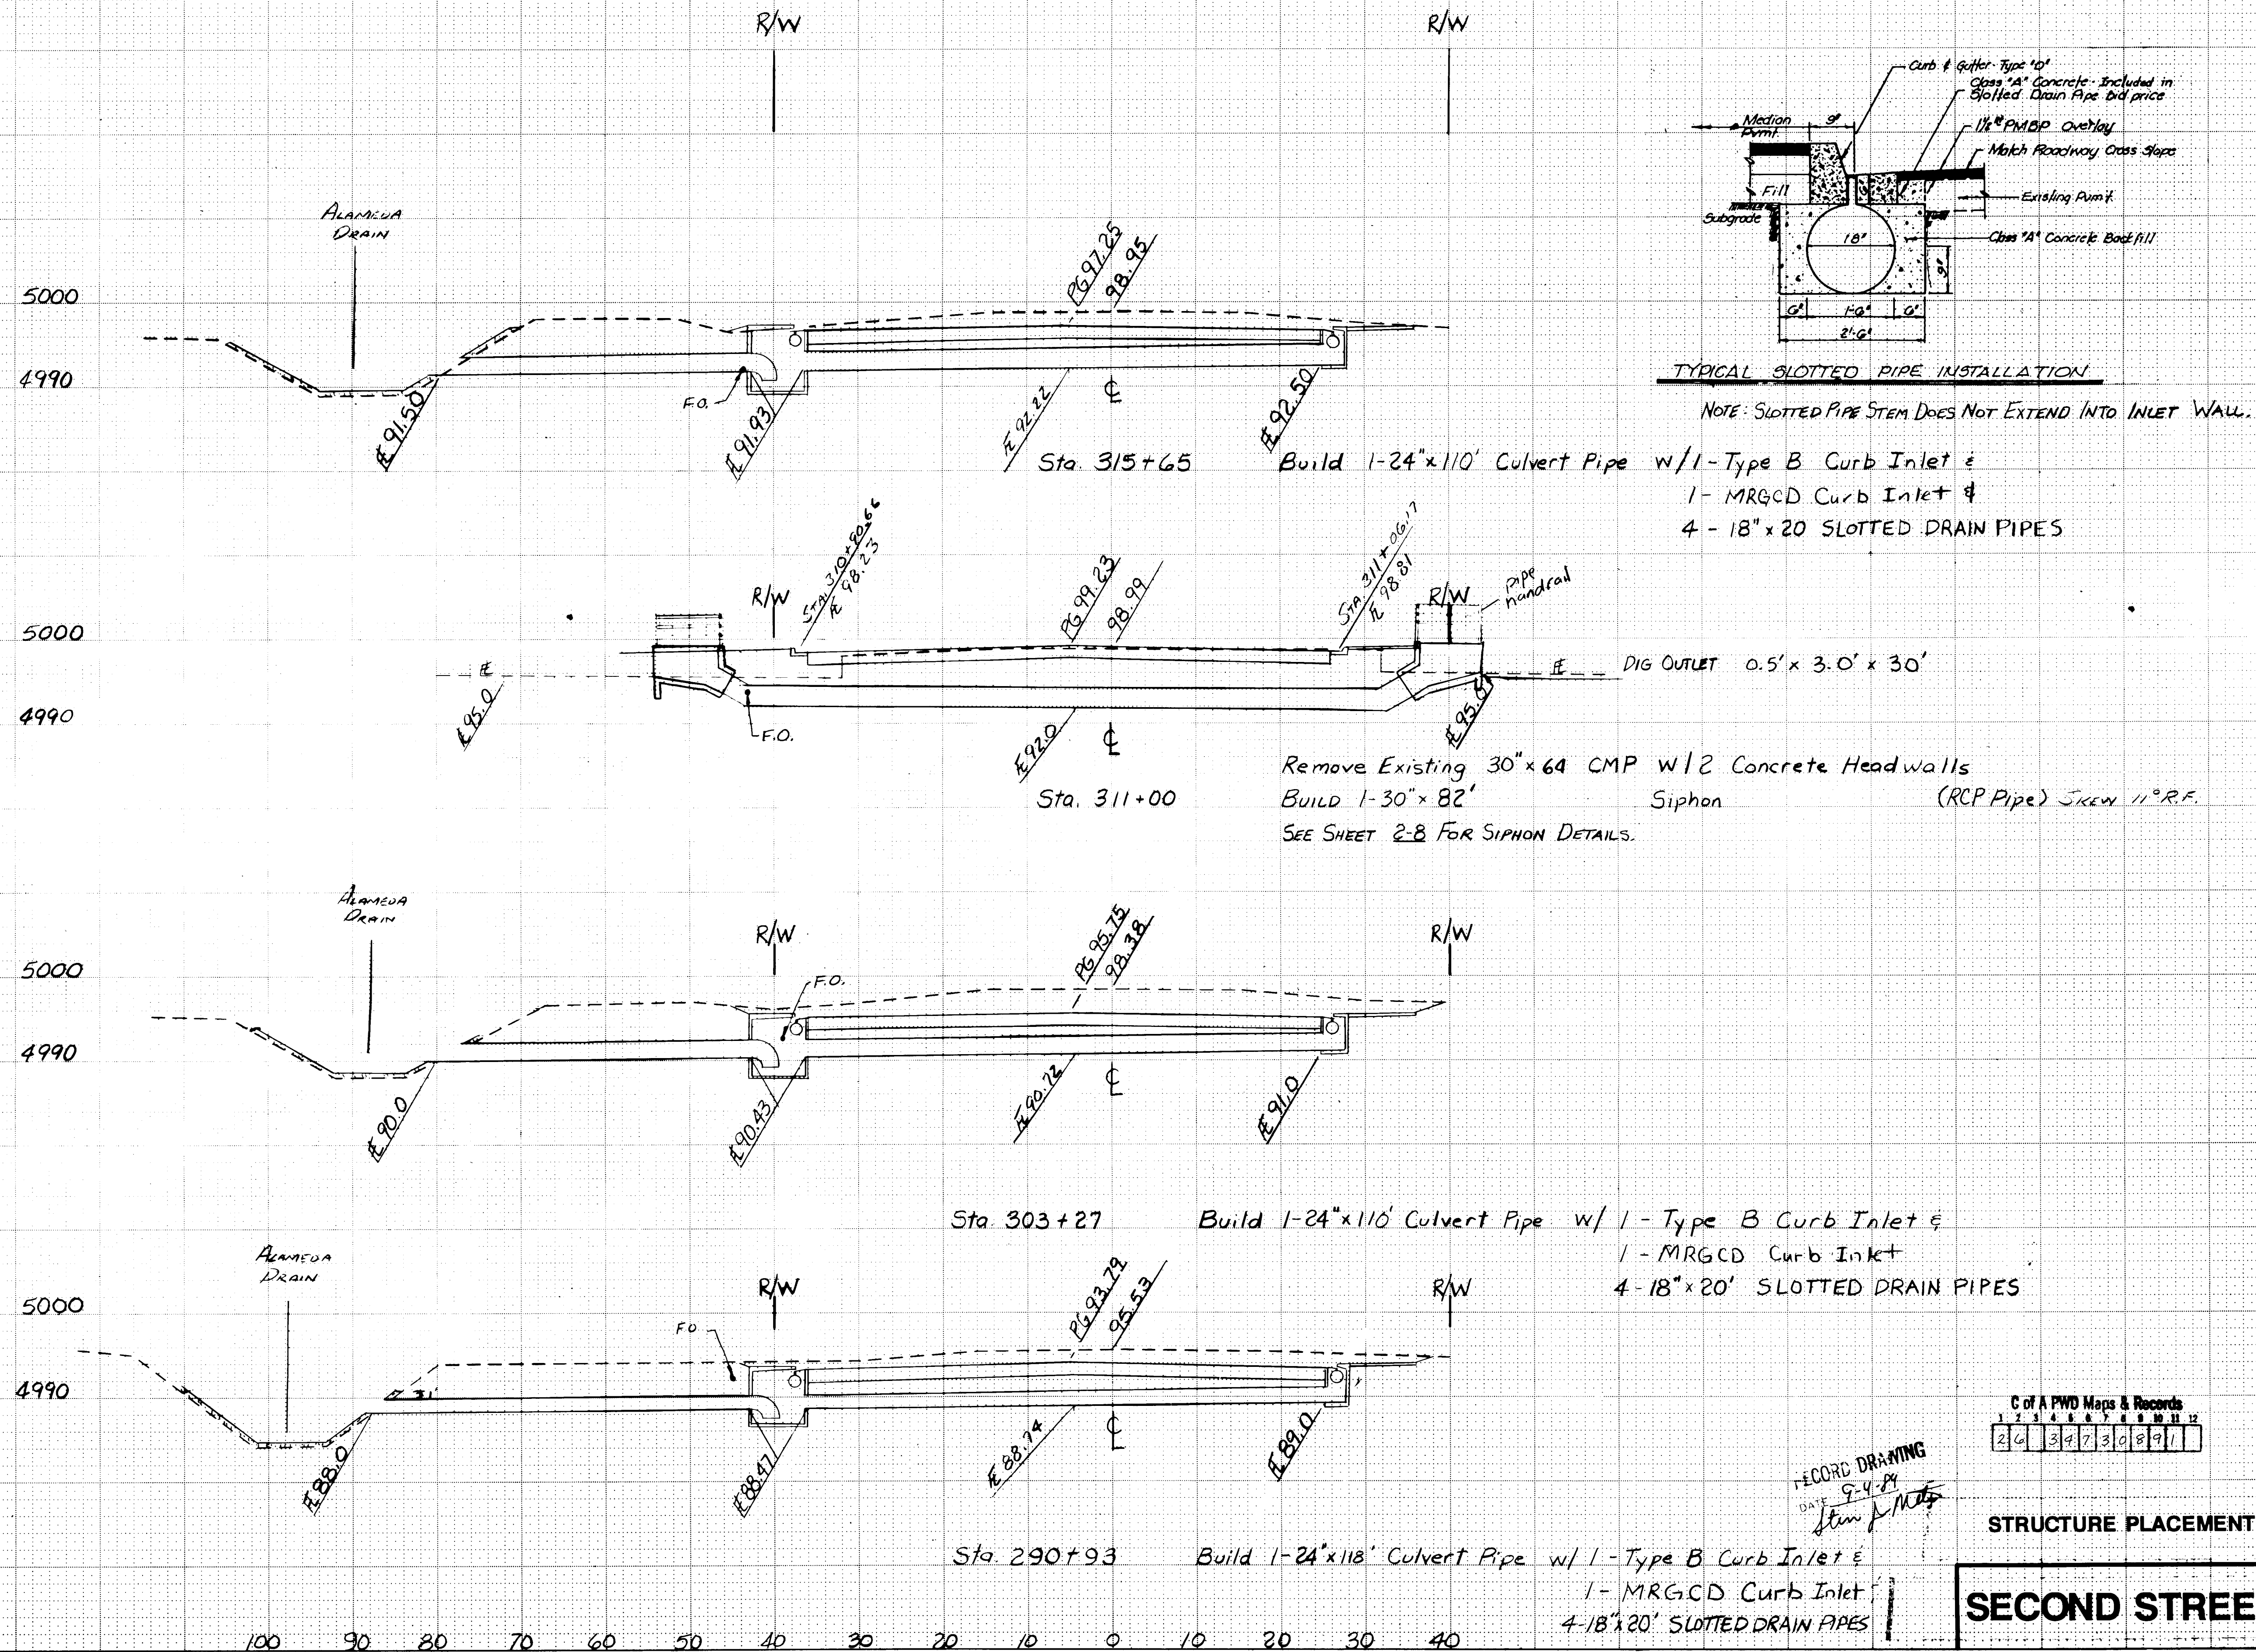

TYPICAL SLOTTED PIPE INSTALLATION

NOTE: SLOTTED PIPE STEM DOES NOT EXTEND INTO INLET WALL.

Build 1-24"x110' Culvert Pipe w/1-Type B Curb Inlet & 1-MRGCD Curb Inlet & 4-18"x20 SLOTTED DRAIN PIPES

C of A PWD Maps & Records
1 2 3 4 5 6 7 8 9 10 11 12
2 4 3 2 3 0 8 9 1

RECORD DRAWING
DATE 9-11-29
JIM F. MILES




STRUCTURE PLACEMENT

SECOND STREET

F H W A REGION NO.	STATE	PROJECT NO.	FISCAL YEAR	SHEET NO.	TOTAL SHEETS
6	NEW MEXICO	07-000-0000000000	10	10-2	

DATE	BY	FINAL SURVEY	SURVEYED PLOTTED NOTE BOOK NO.	AREAS CHECKED

DATE	BY	ORIGINAL SURVEY	SURVEYED PLOTTED NOTE BOOK NO.	AREAS CHECKED

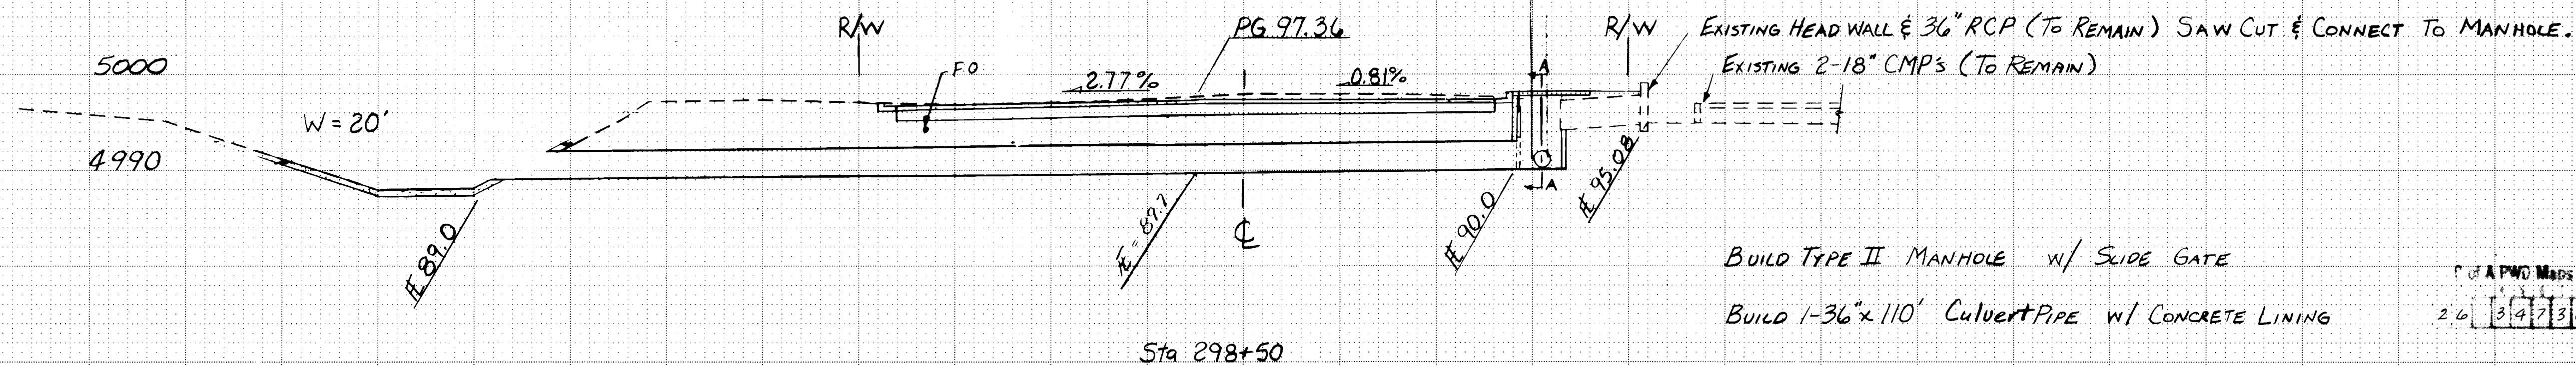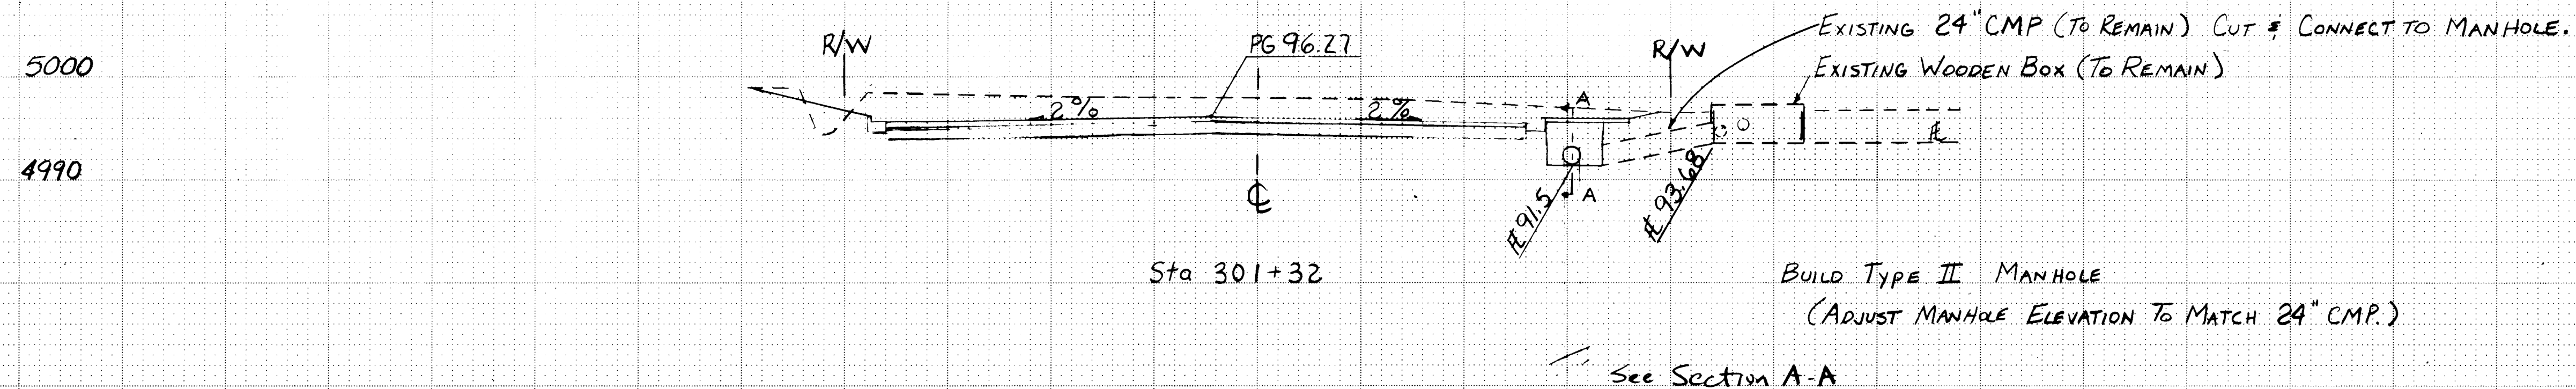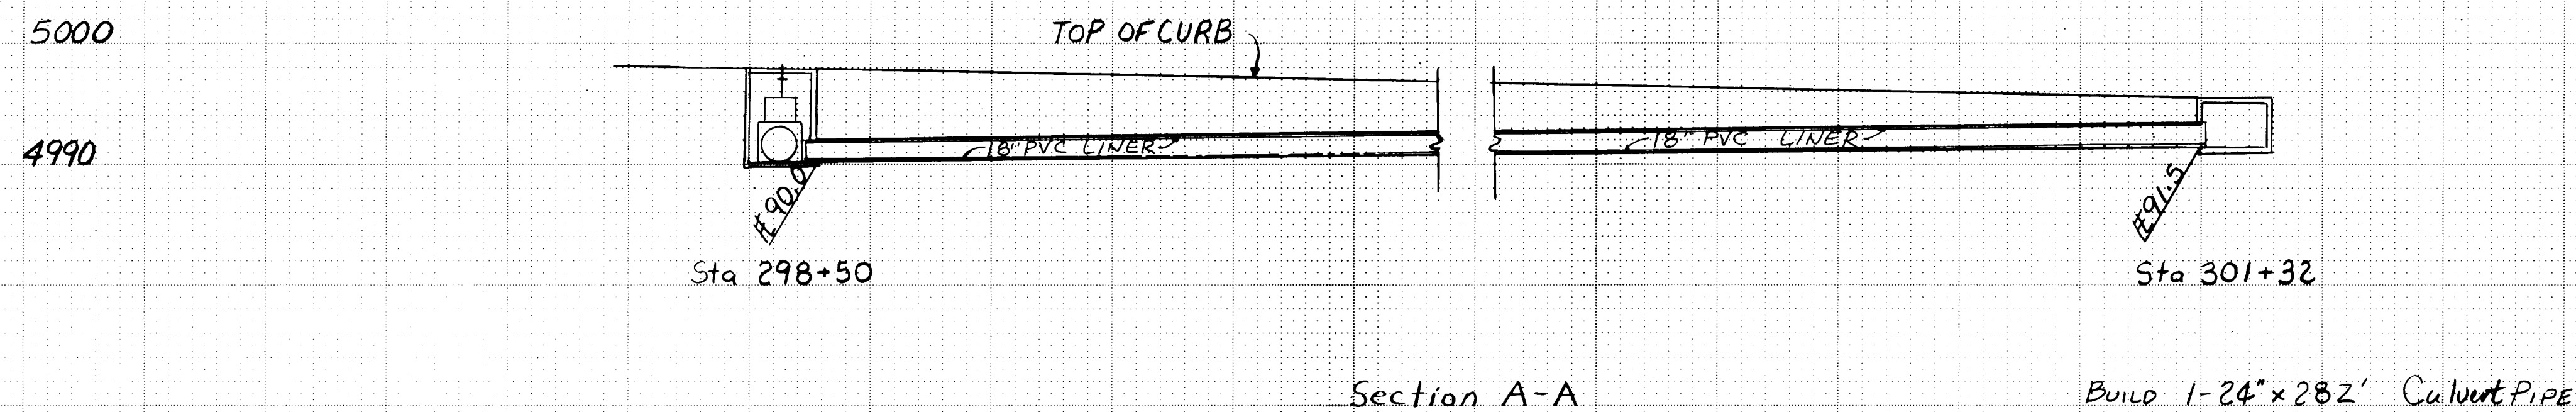




PWD Maps & Records
2.6 3 4 2 3 0 9 9 1

RECORD DRAWING
DATE 9-4-09
Jared Miller

STRUCTURE PLACEMENT

SECOND STREET

F H W A REGION NO.	STATE	PROJECT NO.	FISCAL YEAR	SHEET NO.	TOTAL SHEETS
6	NEW MEXICO	66-04-488-1000	10	10-8	

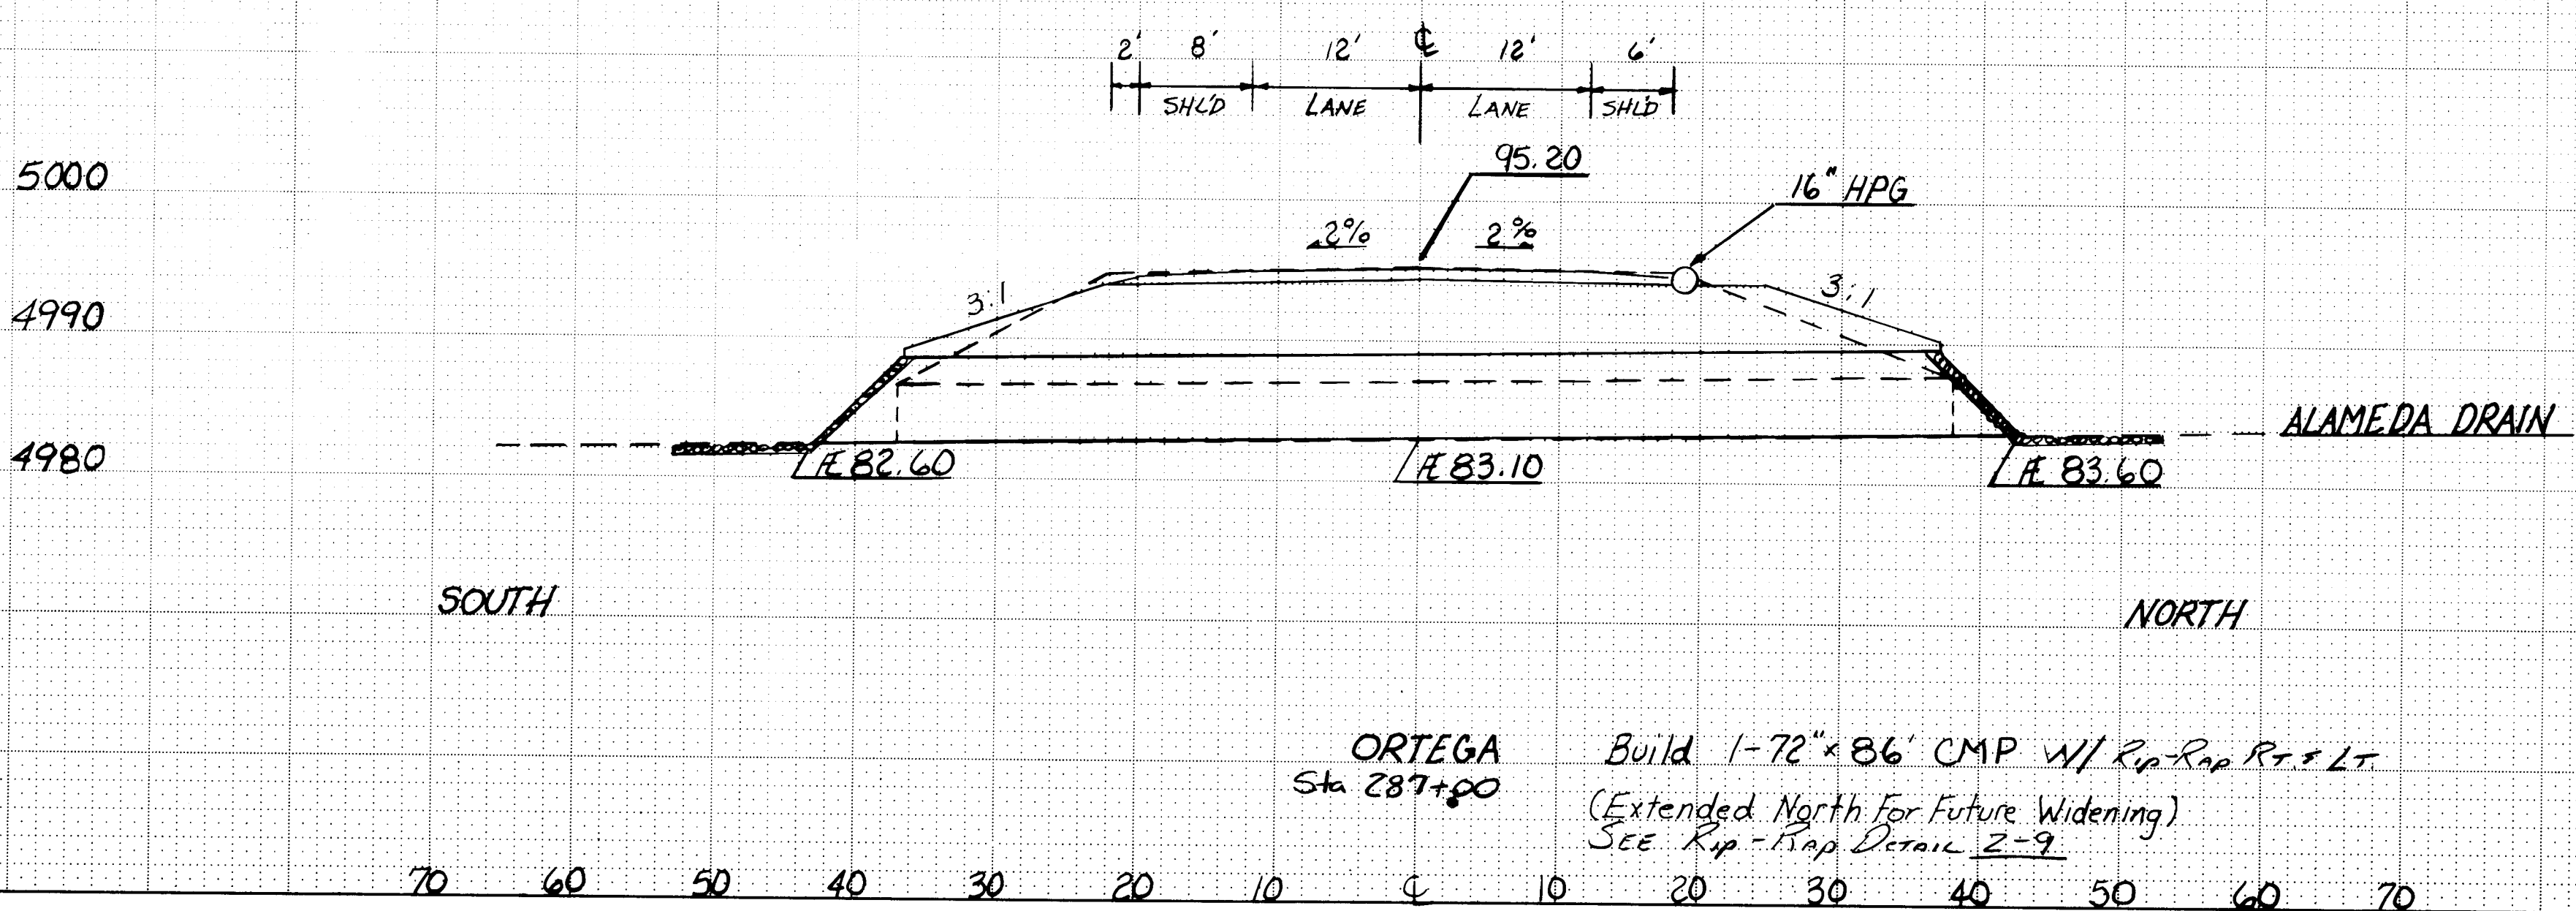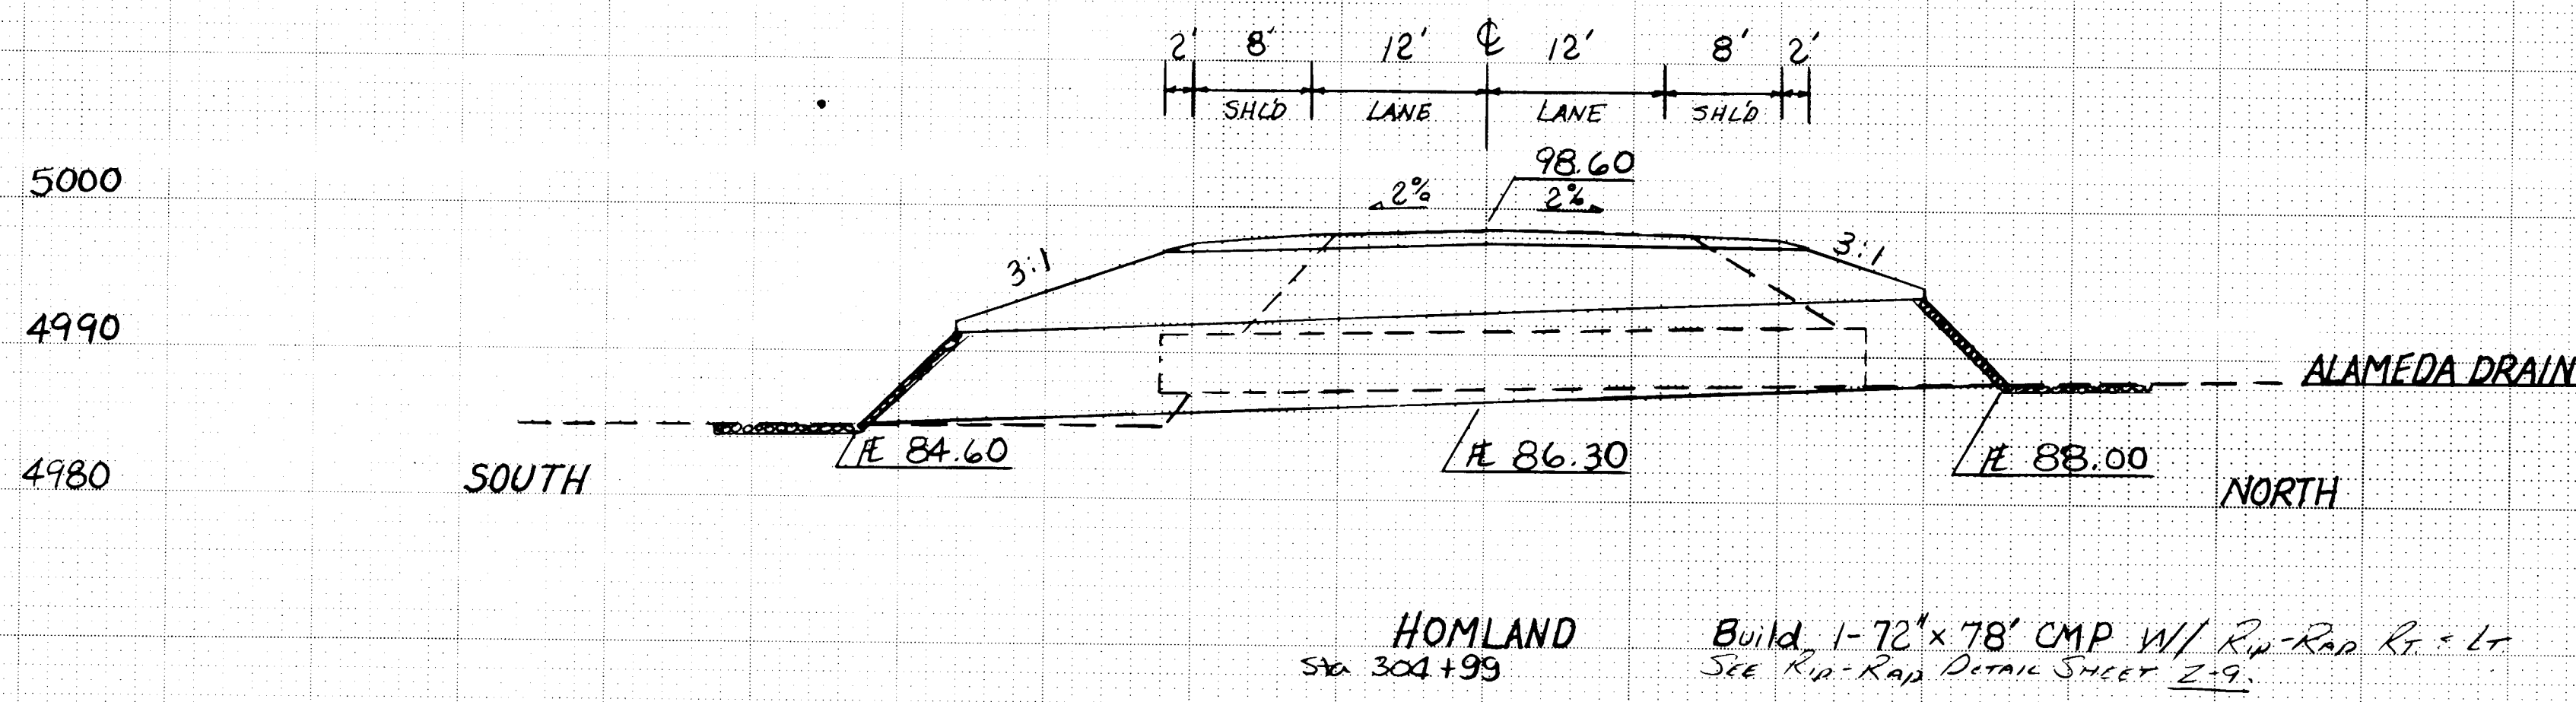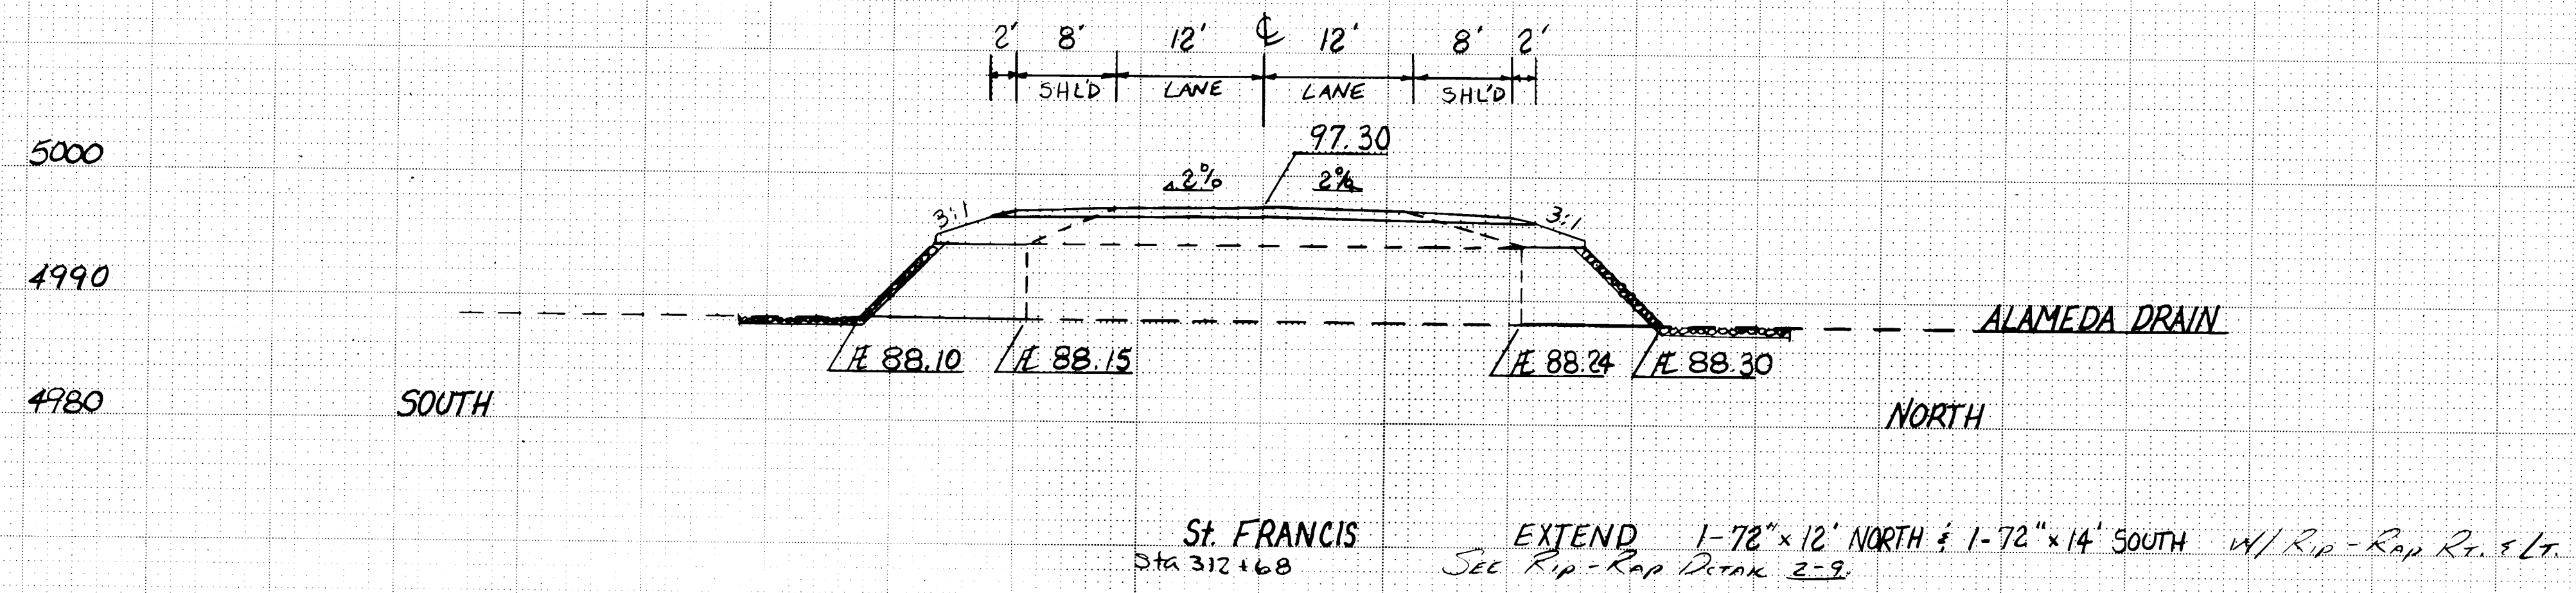


C of A PWD Maps & Records
26 397310911

ALAMEDA DRAIN
STRUCTURE PLACEMENT


SECOND STREET

DATE	BY	FINAL SURVEY NOTE BOOK NO.	SURVEYED PLOTTER AREA CHECKED


DATE	BY	ORIGINAL SURVEY NOTE BOOK NO.	SURVEYED PLOTTER AREA CHECKED

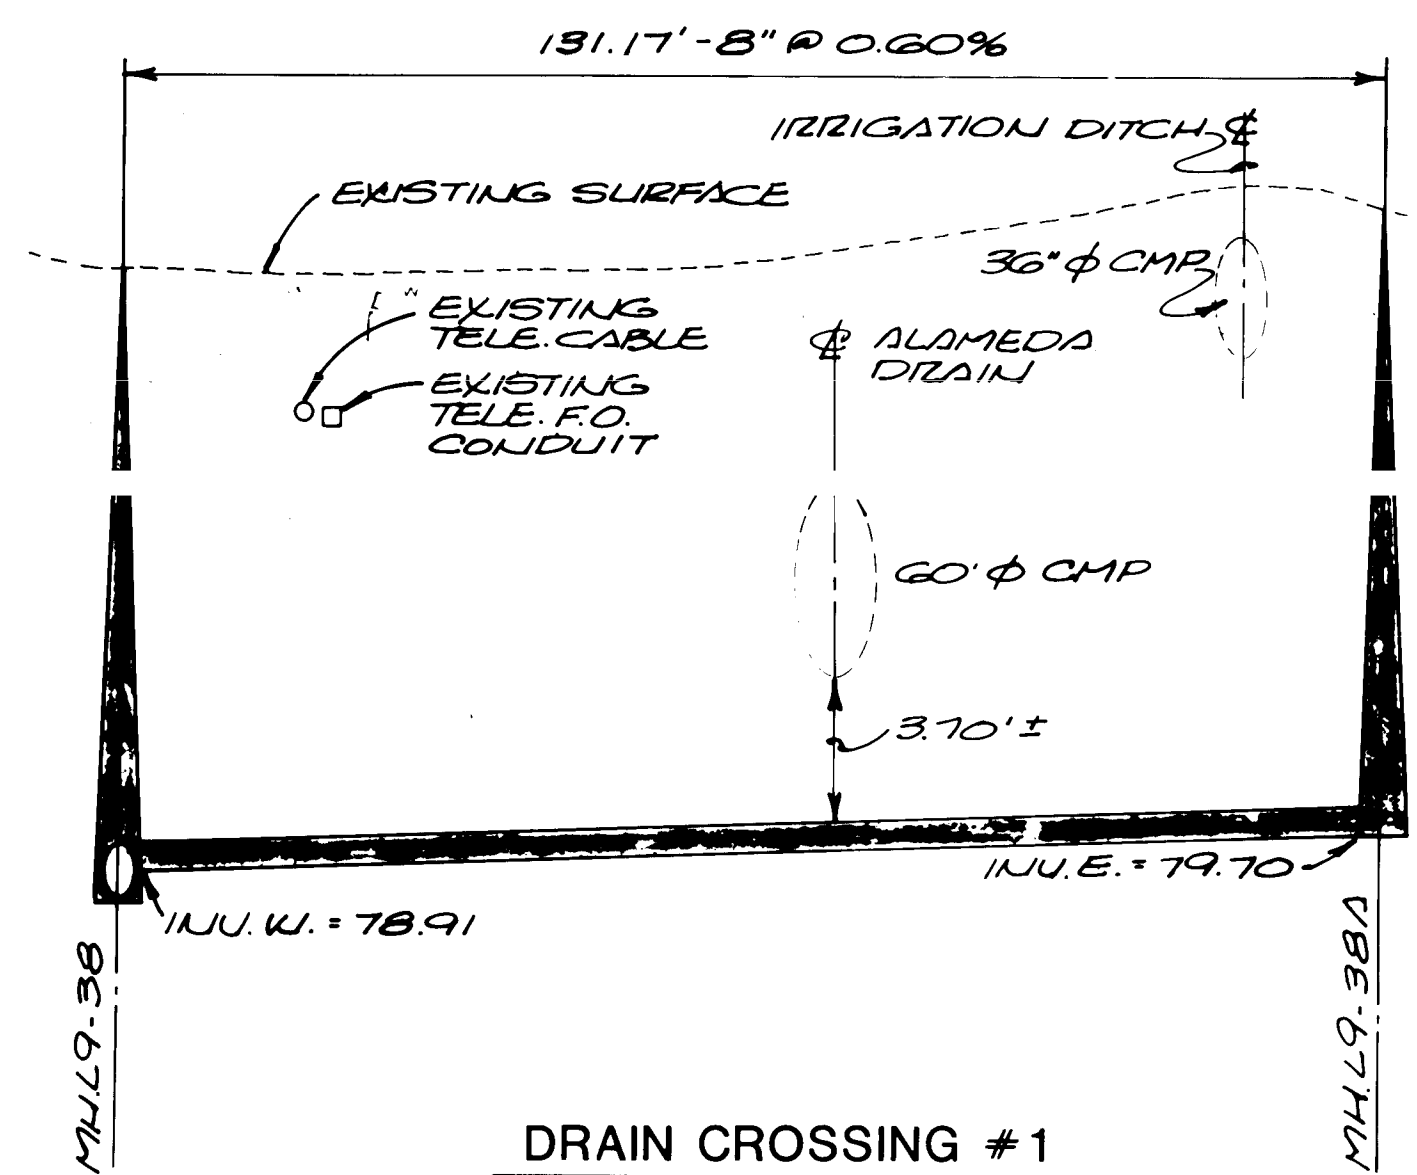

DRAIN CROSSING #1
PRIVATE DR. N.T.S.

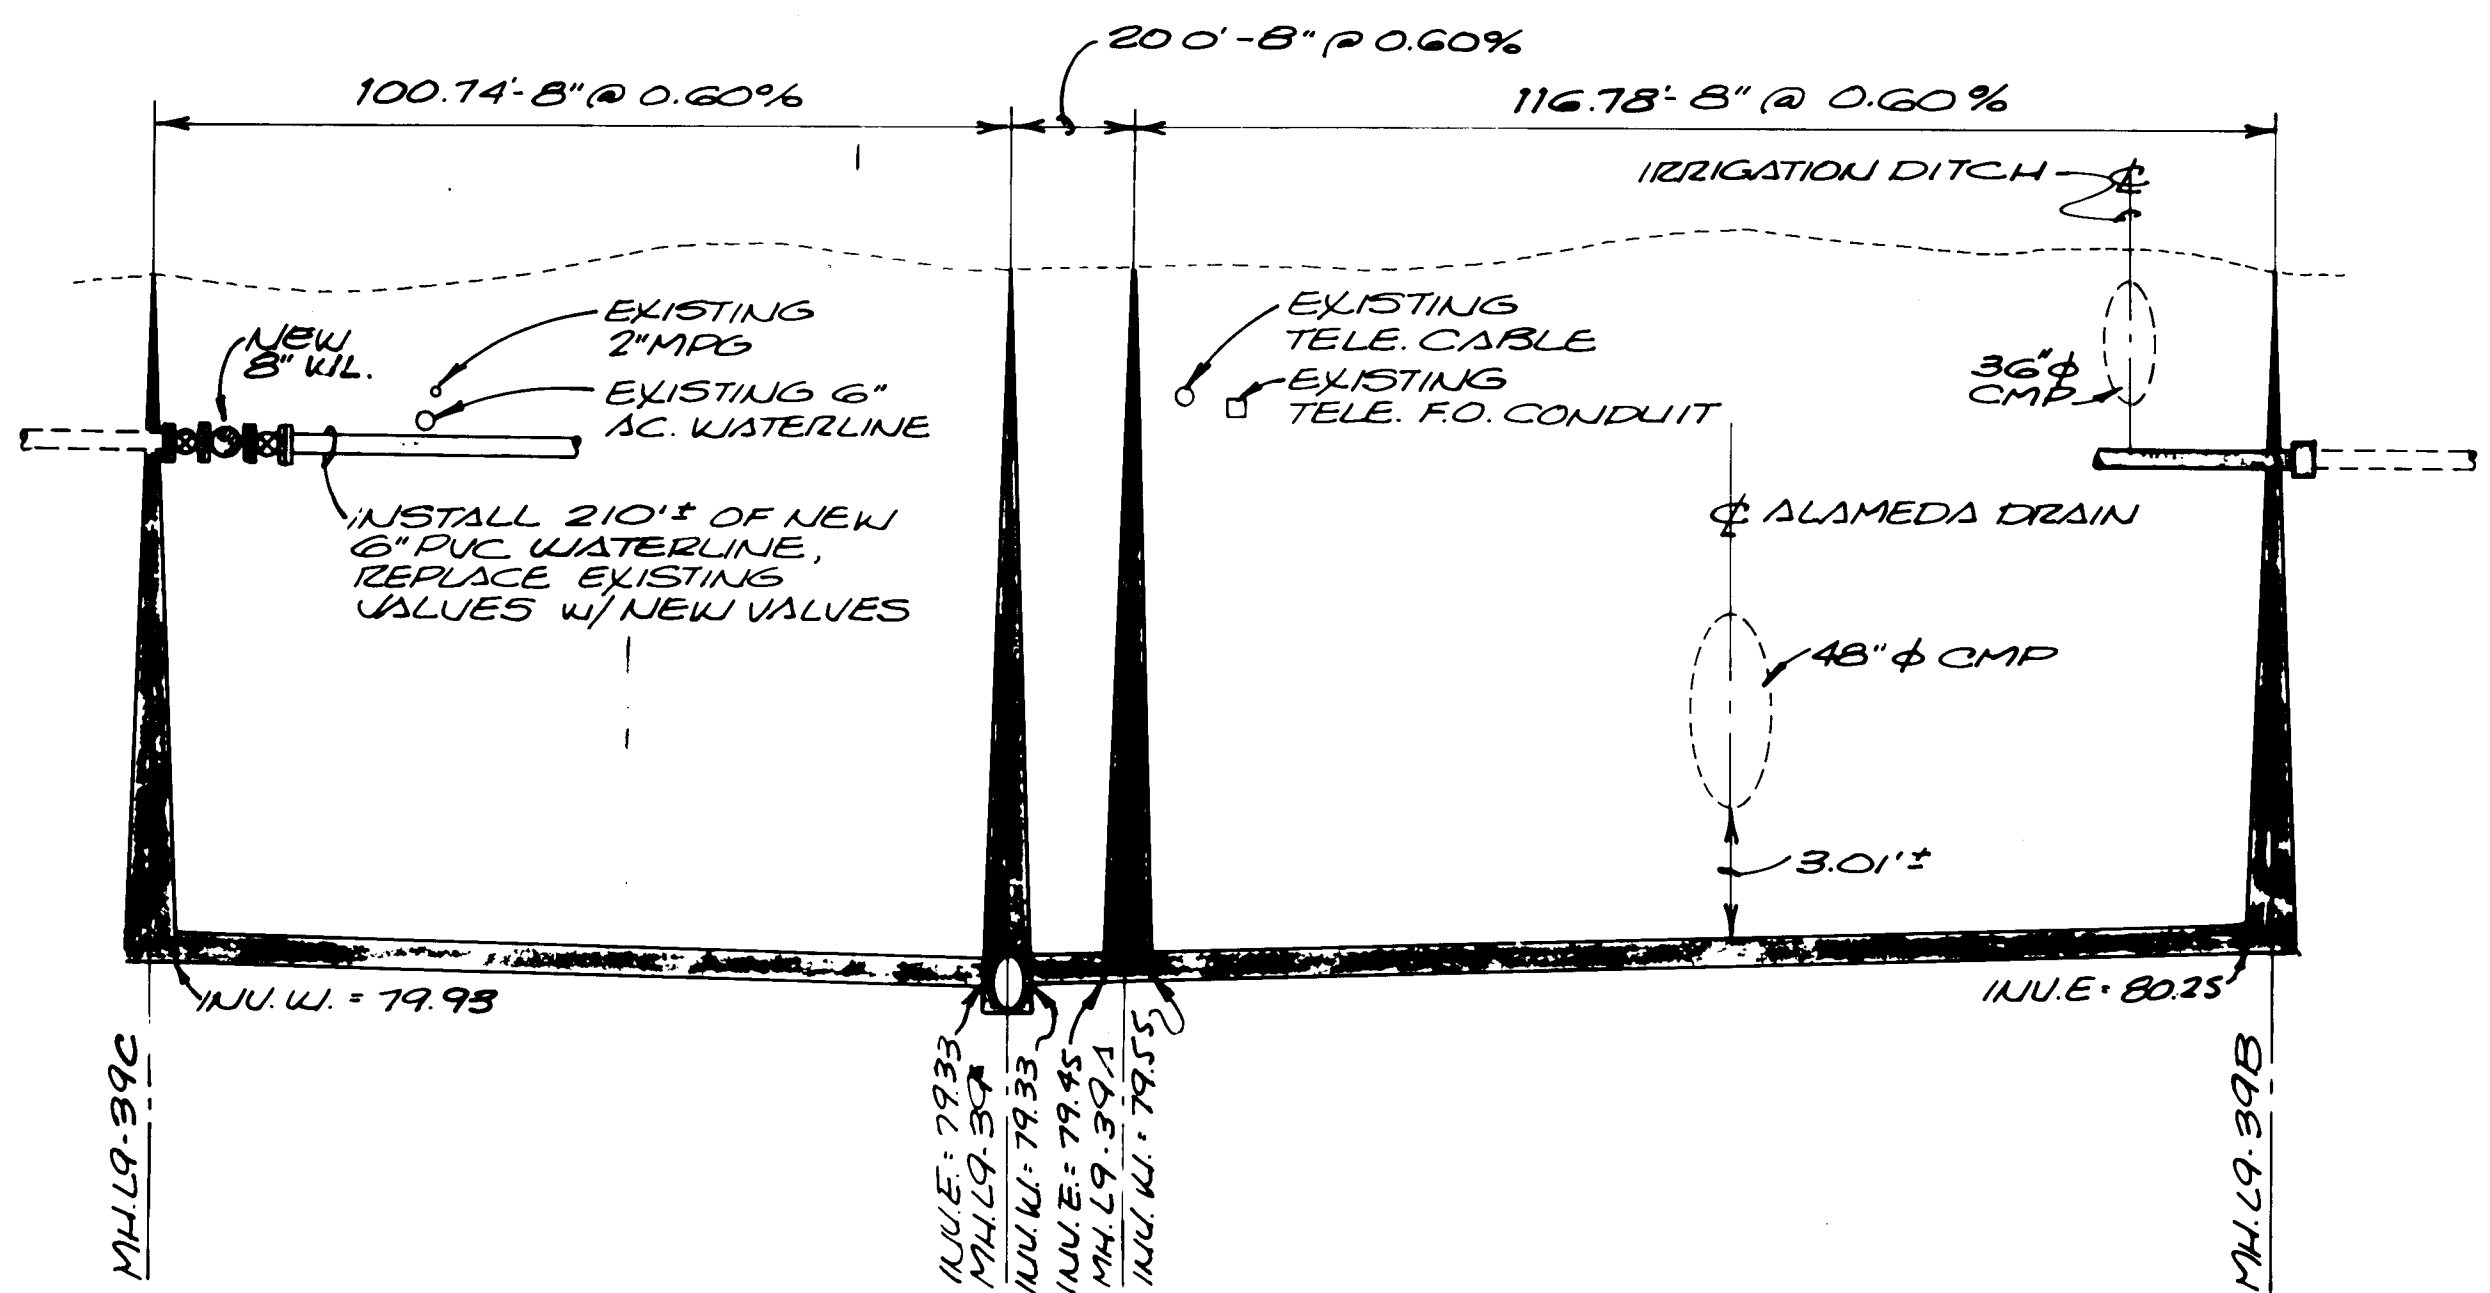


DRAIN CROSSING #2
ORTEGA RD. N.T.S.

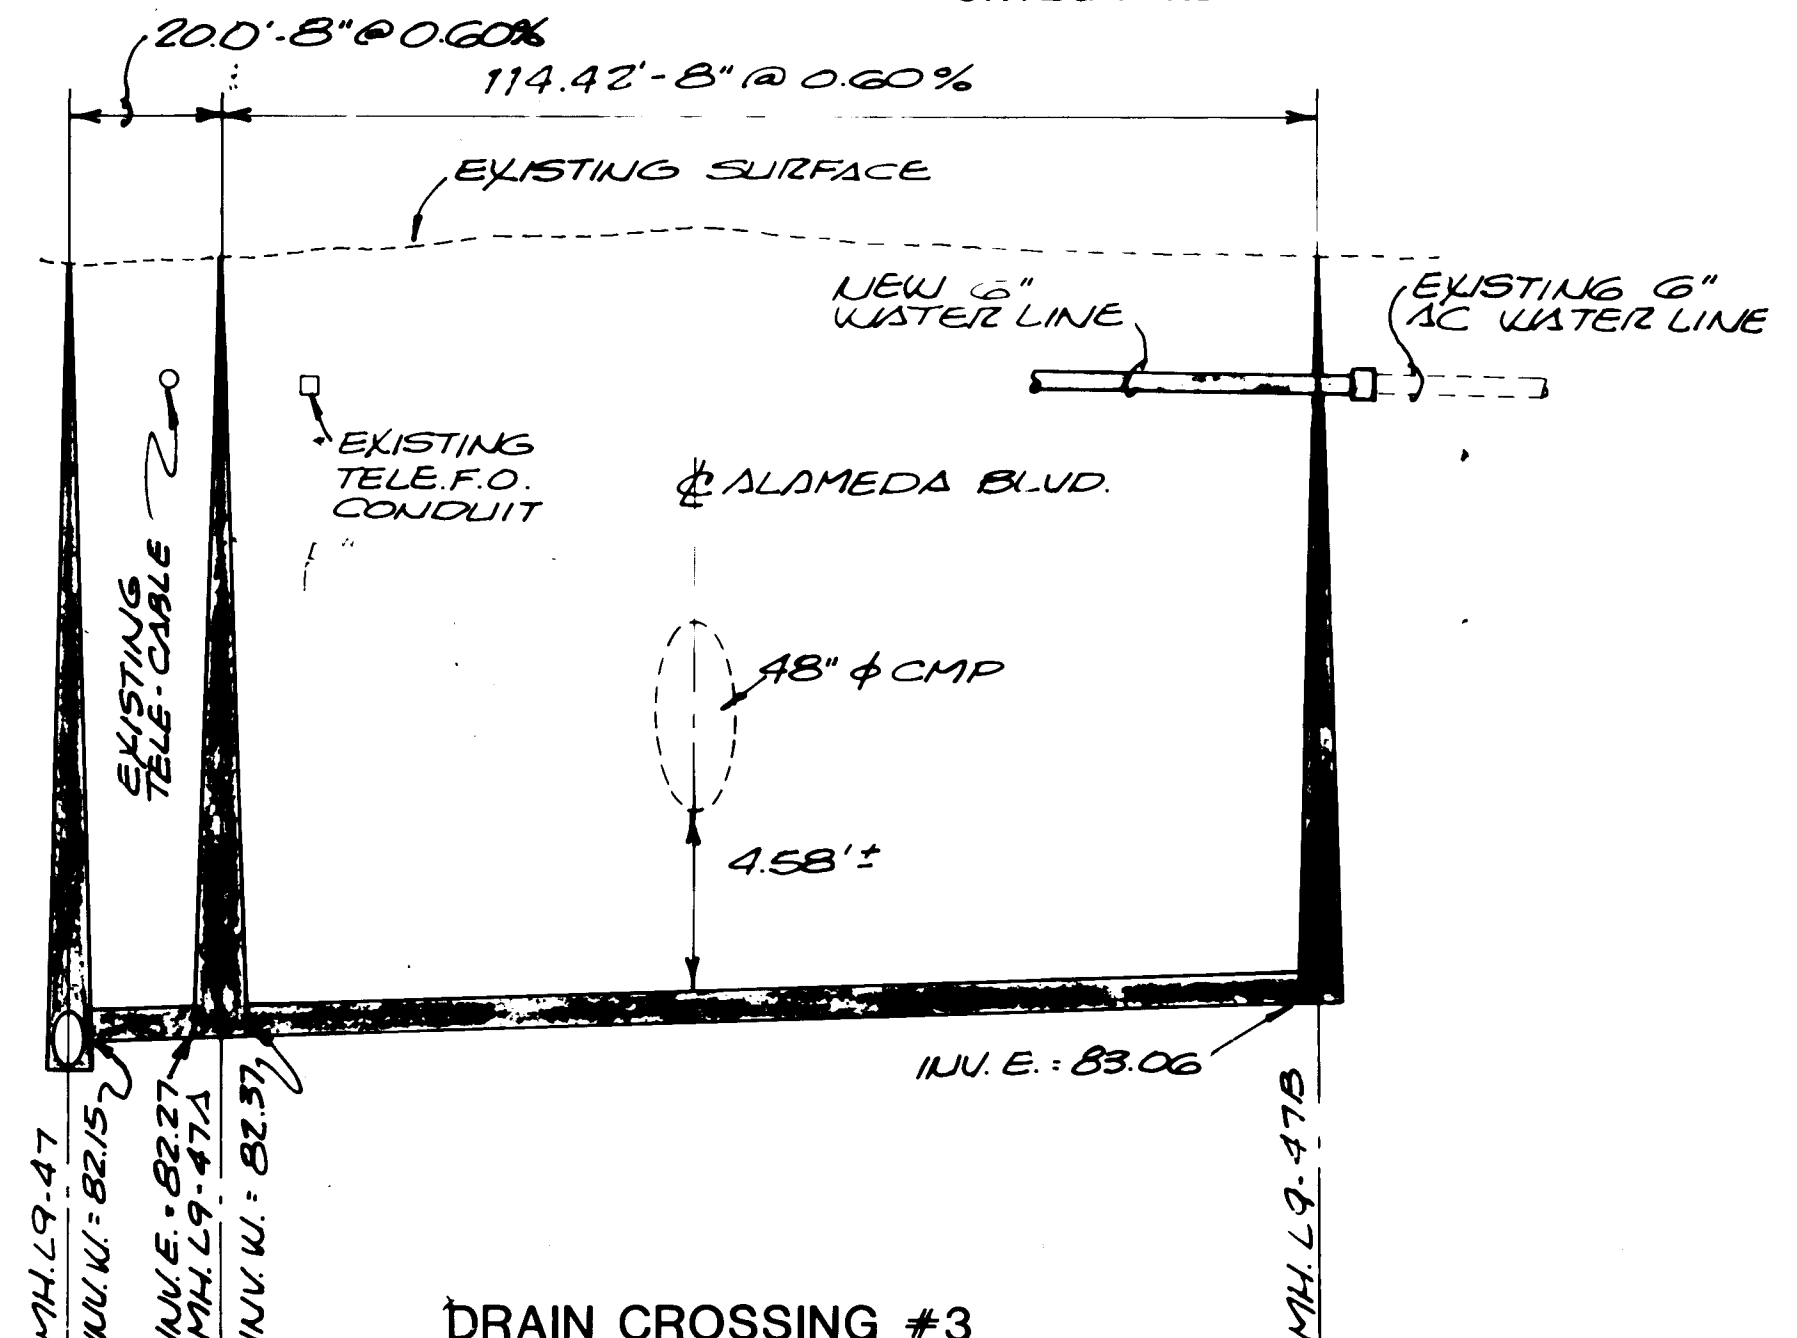


DRAIN CROSSING #3
HOMLAND RD. N.T.S.


- GENERAL NOTES:**
1. CONTRACTOR TO LOCATE EXIST. G" FORCEMAIN & VARY INVERT IN THE FIELD PRIOR TO CONSTRUCTION.
 2. THE CONTRACTOR SHALL COORDINATE THE INTERRUPTION OF THE LIFT STATION OPERATION WITH LEE BENDER, MANAGER OF THE VILLAGE PARK MOBILE HOME COMMUNITY @ 10200 2ND N.W. (898-9526).
 3. THE CONTRACTOR IS RESPONSIBLE FOR EVACUATING THE LIFT STATION WET WELL, AS NECESSARY, DURING THE CONSTRUCTION OF THE FORCE MAIN TO MANHOLE L9-52.

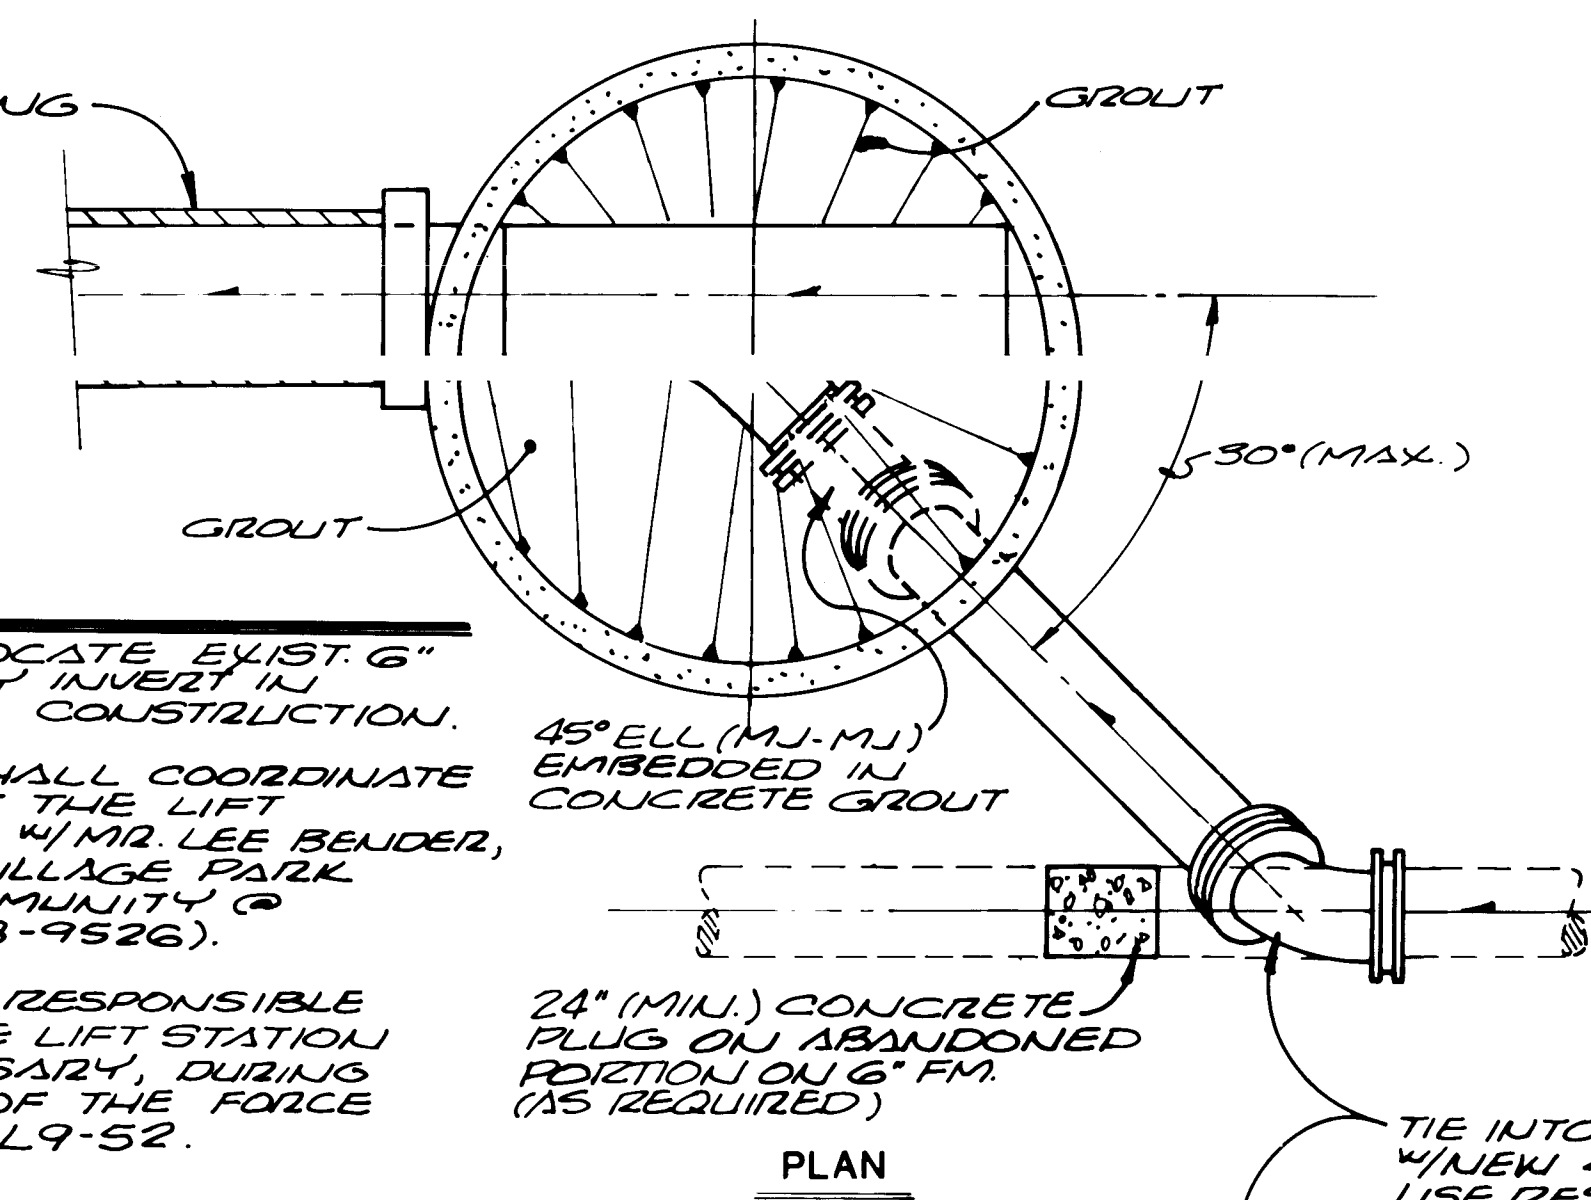


NOTE: ALL NEW FORCEMAIN MATERIAL SHALL BE PVC-C900

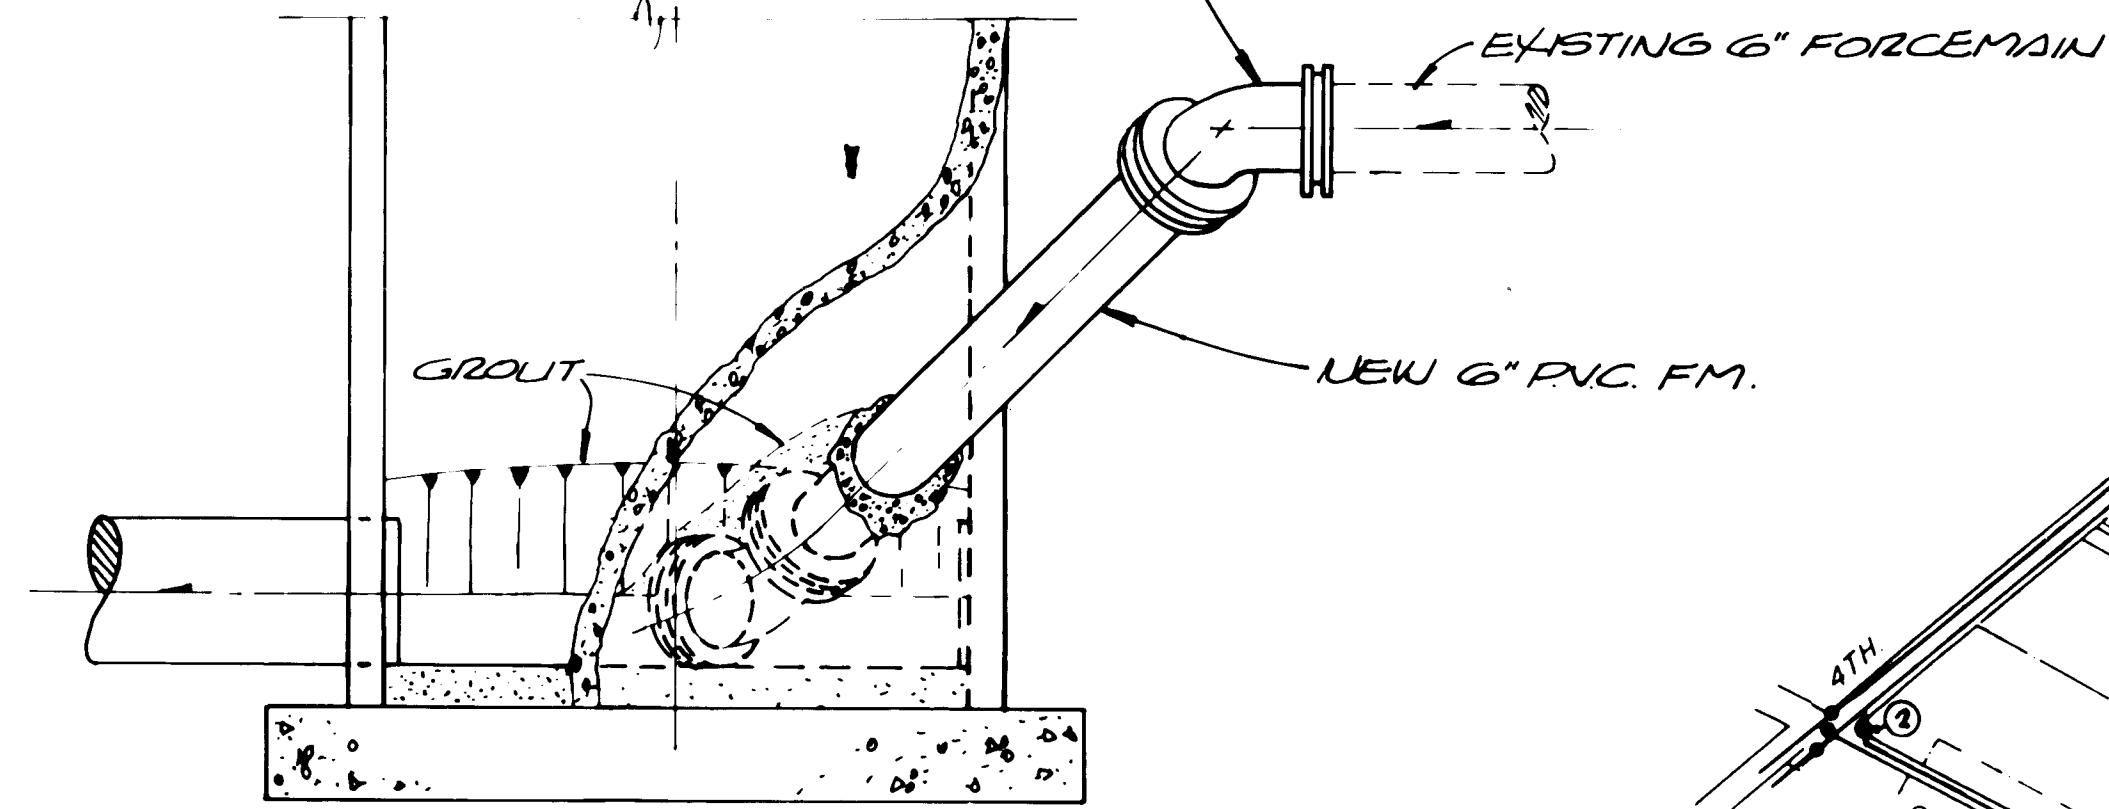


MANHOLE #L9-52 DETAIL
N.T.S.

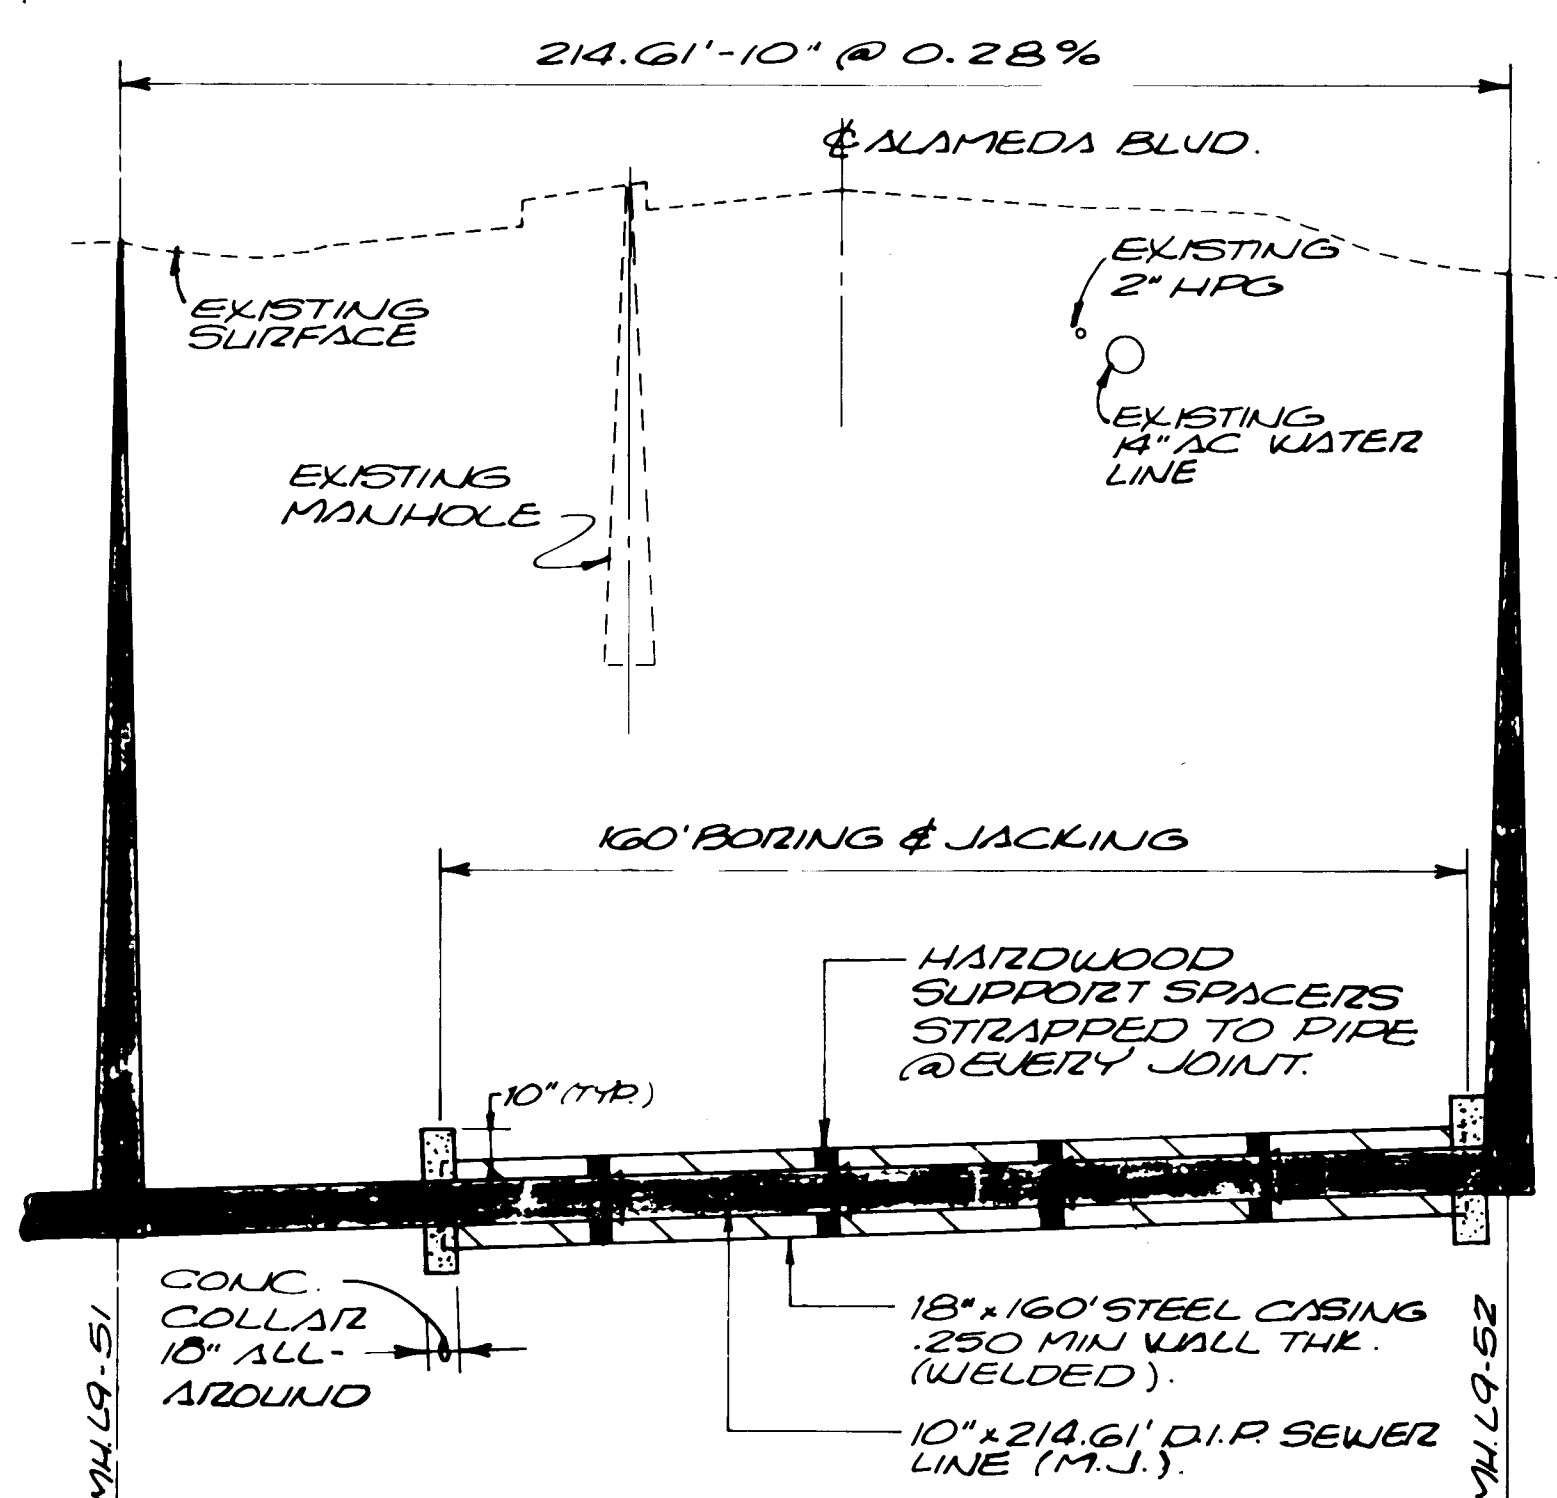

ALAMEDA BLVD. CROSSING
N.T.S.

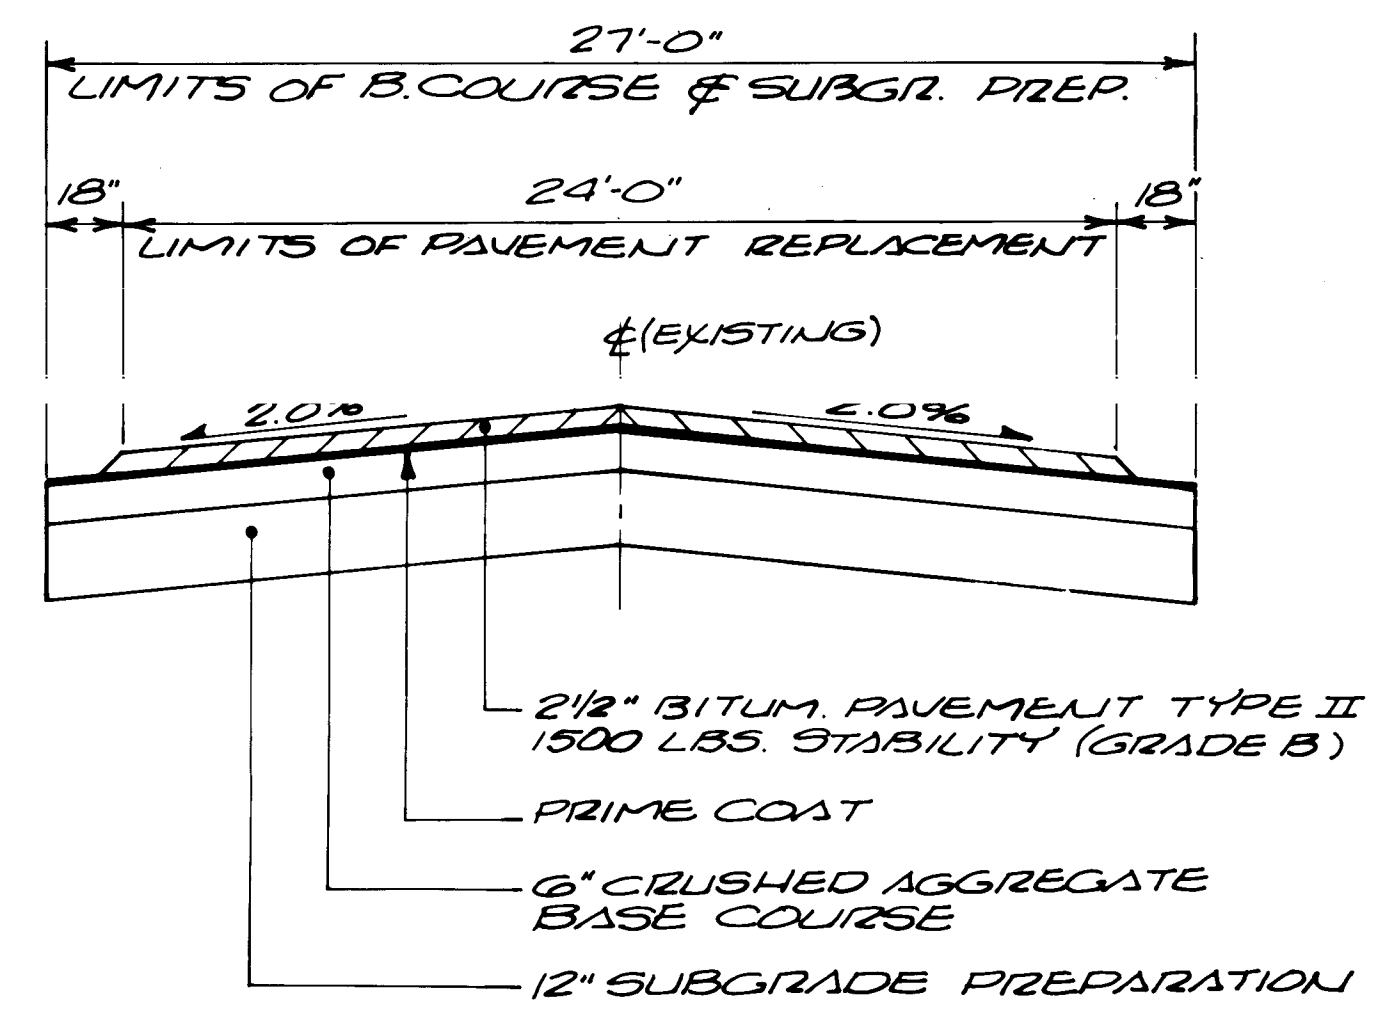

PAVEMENT REPLACEMENT SECTION FOR ST. FRANCIS RD., HOMLAND RD., & ORTEGA RD.
N.T.S.

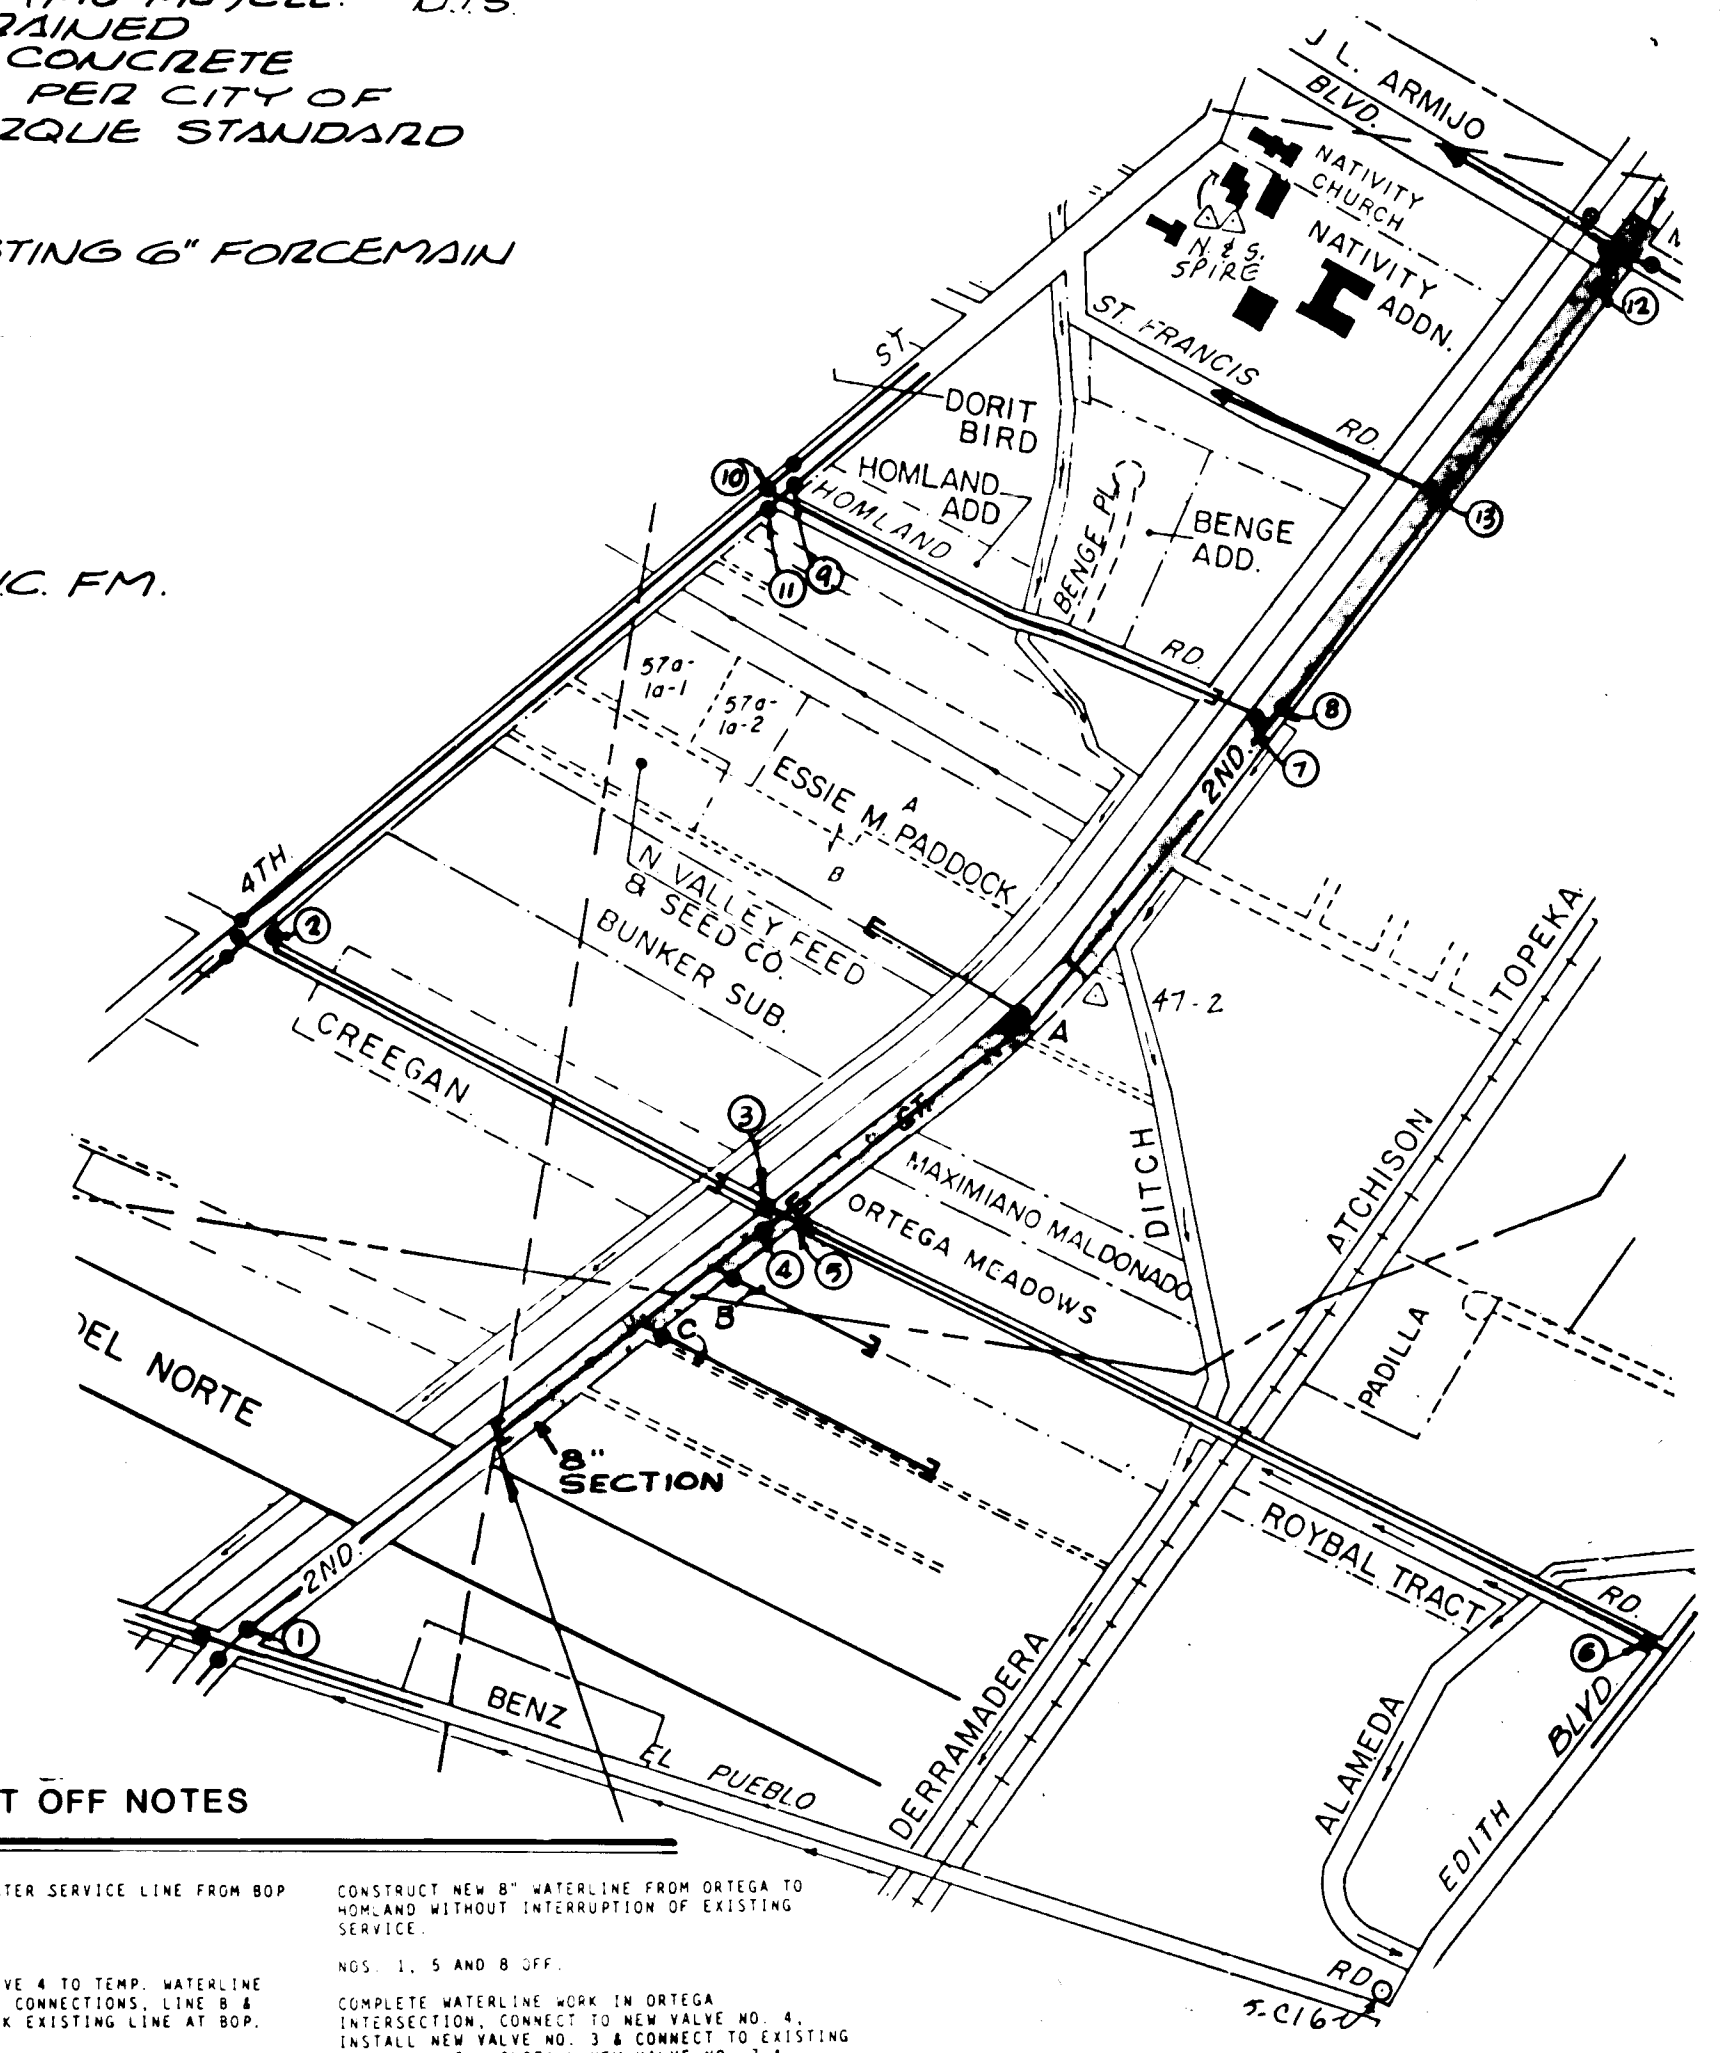

VALVE SHUT OFF NOTES

- CONSTRUCT A TEMP. WATER SERVICE LINE FROM BOP TO VALVE NO. 4.
NOS. 1 AND 4 OFF.
CONNECT EXISTING VALVE 4 TO TEMP. WATERLINE AND TRANSFER SERVICE CONNECTIONS. LINE B & LINE C, CAP AND BLOCK EXISTING LINE AT BOP.
NOS. 4 AND 1 ON.
CONSTRUCT NEW 8" WATERLINE FROM BOP TO ORTEGA RD. INSTALL NEW 8" VALVE (NO. 4) AT ORTEGA RD. 1 OFF.
REMOVE CAP AND CONNECT NEW 8" LINE TO EXISTING LINE AT BOP. TRANSFER ALL SERVICE LINES, LINE B AND LINE C TO NEW LINE.
EXISTING NO. 4 OFF.
NEW NO. 4 OFF.
NOS. 2 AND 3 ON AFTER CONNECTION TO EXISTING LINE IS MADE.
CUT, CAP & BLOCK EXISTING 6" WATERLINE ON ORTEGA AT MISC WEST RD.
NO. 2 ON.
NOS. 7, 9, 10, AND 11 OFF.
CUT, CAP & BLOCK EXISTING 6" WATERLINE ON HOMLAND AT MISC WEST RD.
NOS. 9, 10 AND 11 ON.
- CONSTRUCT NEW 8" WATERLINE FROM ORTEGA TO HOMLAND WITHOUT INTERRUPTION OF EXISTING SERVICE.
NOS. 1, 4, 5 AND 8 OFF.
COMPLETE WATERLINE WORK IN ORTEGA INTERSECTION. CONNECT TO NEW VALVE NO. 4. INSTALL NEW VALVE NO. 3 & CONNECT TO EXISTING VALVE NO. 5. INSTALL NEW VALVE NO. 7 & CONNECT TO EXISTING VALVE NO. 8. TRANSFER ALL SERVICE LINES & LINE A.
NOS. 3 AND 7 OFF.
NOS. 1, 4, 5, AND 8 ON.
NO. 2 OFF.
CONSTRUCT NEW 8" WATERLINE FROM VALVE NO. 3 TO MISC WEST RD. CONNECT TO EXISTING LINE ONLY AFTER THE SANITARY SEWER & CULVERT REPLACEMENT WORK IS COMPLETE.
NOS. 2 AND 3 ON AFTER CONNECTION TO EXISTING LINE IS MADE.
NOS. 9, 10 AND 11 OFF.
CONSTRUCT NEW 8" WATERLINE FROM VALVE NO. 7 TO MISC WEST RD. CONNECT TO EXISTING LINE ONLY AFTER THE SANITARY SEWER & CULVERT REPLACEMENT WORK IS COMPLETE.
NOS. 7, 9, 10 AND 11 ON AFTER CONNECTION TO EXISTING LINE IS MADE.

VALVE SHUT OFF DETAIL
N.T.S.

C of A PWD Maps & Records
26 314 73 179 1

CITY OF ALBUQUERQUE
PUBLIC WORKS DEPARTMENT
ENGINEERING GROUP

TITLES			REVISIONS		
APPROVALS	ENGINEER	DATE	NO.	DATE	REMARKS
DRC Chair	VA				
Trans Dev	VA				
Utility Dev					
DRAWING NO.			MAP NO.		
			SHEET OF		
			12-7		