

COUNTY OF BERNALILLO, NEW MEXICO
ENVIRONMENTAL HEALTH AND PUBLIC WORKS DEPARTMENTS
CONSTRUCTION PLANS
FOR

NORTH VALLEY AREAS B AND F
VACUUM PUMP STATION

WILSON PROJECT NUMBER
96-210-034

CITY PROJECT NUMBER
567292


BERNALILLO COUNTY PROJECT

INDEX OF DRAWING SHEETS

SHT	DESCRIPTION
1	COVER/VICINITY MAP/INDEX
2	GENERAL NOTES
3	SITE LAYOUT - GRADING AND DRAINAGE PLAN
4	SITE PIPING PLAN AND SEWER PROFILES
5	STRUCTURAL - FOUNDATION PLANS BELOW AND AT GRADE LEVEL
5A	STRUCTURAL DETAILS
5B	STRUCTURAL DETAILS
6	STRUCTURAL - ROOF FRAMING PLANS AT LOW AND HIGH ROOFS
7	ARCHITECTURAL - FLOOR PLAN AND DETAILS
8	ARCHITECTURAL - ROOF PLAN AND DETAILS
9	ARCHITECTURAL ELEVATIONS AND DETAILS
10	EQUIPMENT AND SECTION PLAN - BELOW AND AT GRADE LEVEL
11	MECHANICAL PLAN AND SECTIONS - SECTIONS, AND DETAILS
12	NOT USED
13	COMPOST FILTER - PLAN, SECTIONS & DETAILS
14	NOT USED
15	ELECTRICAL LEGEND/NOTES/ABBREVIATIONS
16	ELECTRICAL SITE LAYOUT
17	ELECTRICAL - POWER & LIGHTING PLAN
18	ELECTRICAL - ONE-LINE DIAGRAMS
19	ELECTRICAL - DETAILS
20-25	AIR VAC DRAWINGS

APPROVAL BY:
[Signature] 5-6-99
BERNALILLO COUNTY PUBLIC WORKS DIVISION DATE
[Signature] 5-6-99
BERNALILLO COUNTY PUBLIC WORKS DIVISION DATE

APPROVAL BY:
[Signature] 5/7/99
CITY OF ALBUQUERQUE CITY ENGINEER DATE
[Signature] 5/6/99
CITY OF ALBUQUERQUE DRC CHAIRMAN DATE
[Signature] 5-6-99
CITY OF ALBUQUERQUE WWTP PLANT MANAGER DATE

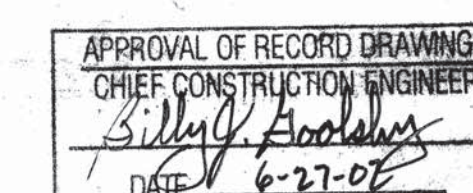

VICINITY MAP
N.T.S.
ZONE ATLAS MAP B-16Z



REV	SHEETS	CITY ENGINEER	DATE	USER DEPT.	DATE	USER DEPT.


ENGINEER'S SEAL	WILSON & COMPANY 4775 INDIAN SCHOOL ROAD N.E. SUITE 200 ALBUQUERQUE, NEW MEXICO 87110 (505) 254-4000	APPROVED FOR CONSTRUCTION
	PROJECT No. 96210034	SHEET 1 OF 19

2000



CITY PROJECT #567292			2	1	NO.	W	DESIG	DRAW
COUNTY OF BERNALILLO ENVIRONMENTAL HEALTH AND PUBLIC WORKS DEPARTMENTS								
	NORTH VALLEY AREAS B AND VACUUM STATION							
	SITE LAYOUT GRADING & DRAINAGE PLAN							
	PROJECT NO. 96034				SHEET 3 OF 1			

SCANNED BY
MESA REPRO

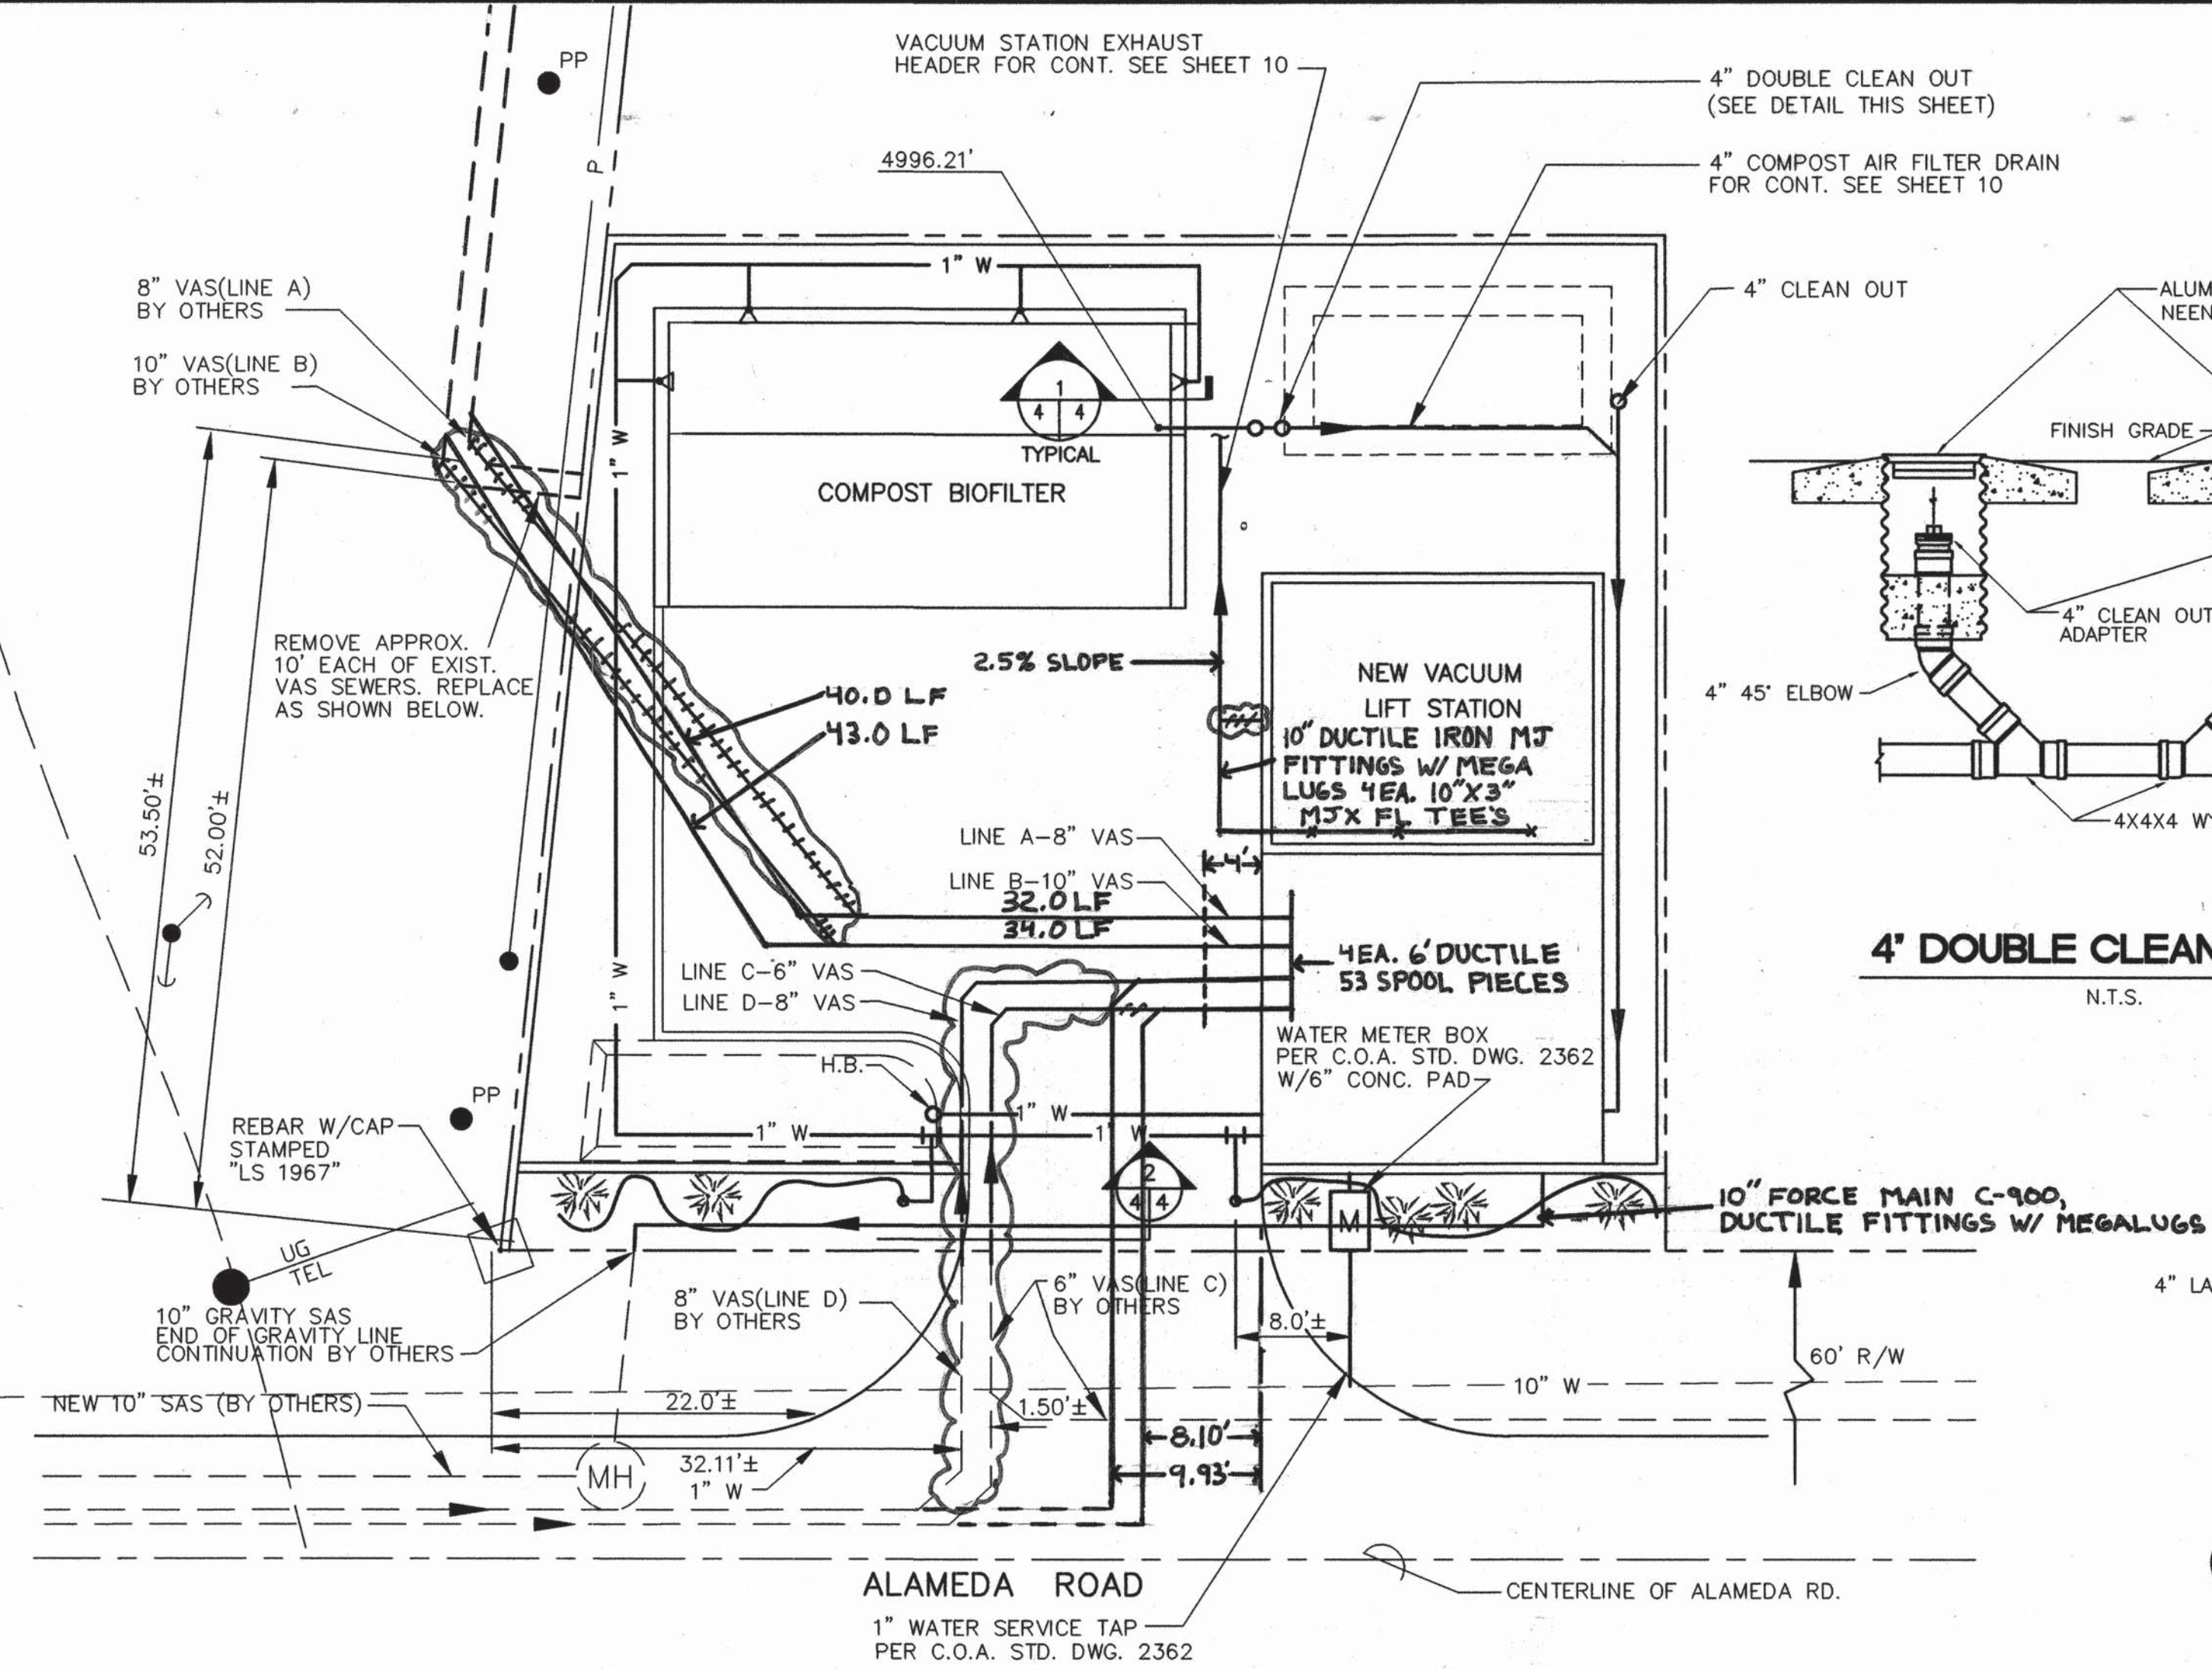

NOTE: LINES A, B, C, & D ARE CONSTRUCTED BY ANOTHER CONTRACTOR TO PROPERTY BOUNDARY. COORDINATE & VERIFY HORIZONTAL & VERTICAL LOCATIONS OF LINES WITHIN SITE.

4\"/>

N.T.S.

IRRIGATION SPRINKLER


NO SCALE

XERISCAPING IRRIGATION DETAIL

NO SCALE

NOTE: TYPICAL BOTH SIDES OF ENTRANCE

SCALE:
HORIZ: 1\"/>

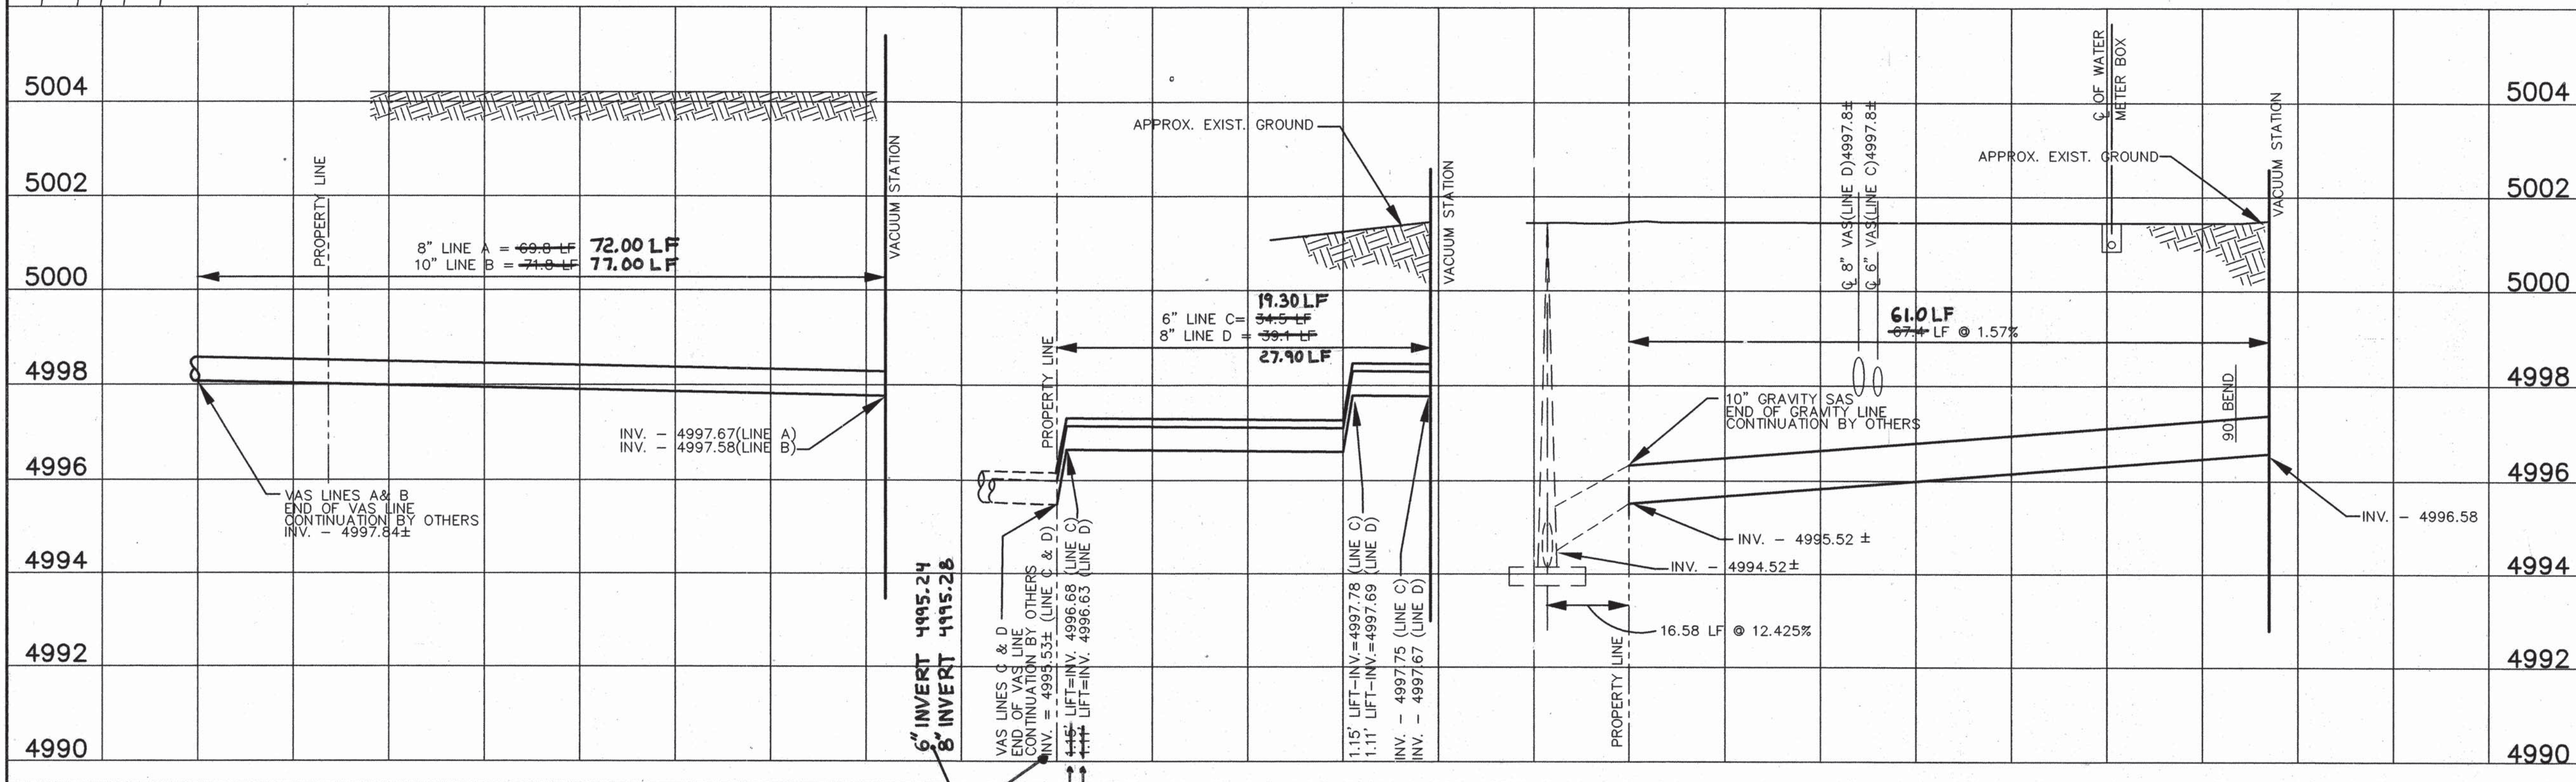

NOTES:

1. ALL UNDERGROUND UTILITIES SHOWN ON THIS PLAN ARE APPROXIMATE LOCATIONS. VERIFY LOCATION OF ALL UNDERGROUND UTILITIES BEFORE COMMENCING WORK.

2. VACUUM STATION & ASSOCIATED PIPING CONNECT TO SEWERS CONSTRUCTED BY OTHERS AND ARE ASSUMED TO BE COMPLETE PRIOR TO CONSTRUCTION OF THIS PROJECT. PROTECT PLUGGED PIPES UNTIL FINAL CONNECTION IS MADE.

3. FOR CONTINUATION OF PIPING INTO PUMP STATION SEE SHT. 10.

AS-BUILT INFORMATION		BENCH MARKS		SURVEY INFORMATION		ENGINEER'S SEAL	
CONTRACTOR	DATE	NO.	BY	NO.	BY	NO.	BY
TRIM BUILDERS OF NM	1/1/99						
WILSON & CO.	3/00						
WILSON & CO.	9/00						

ENGINEER'S SEAL

REGISTERED PROFESSIONAL ENGINEER
STATE OF NEW MEXICO
12763

REVISIONS		REMARKS		DESIGNED BY		DRAWN BY		CHECKED BY	
NO.	DATE	NO.	DATE	NO.	DATE	NO.	DATE	NO.	DATE
2	1/19/00	1/3	RELOCATION PUMP STATION	1	1/19/99				
1	1/19/99	1/3	RELOCATION PUMP STATION						

WILSON & COMPANY, ENGINEERS & ARCHITECTS

CITY PROJECT #567292


COUNTY OF BERNALILLO
ENVIRONMENTAL HEALTH AND
PUBLIC WORKS DEPARTMENTS

**BERNALILLO COUNTY
STATE OF NEW MEXICO**


NORTH VALLEY AREAS B AND F
VACUUM SEWER IMPROVEMENTS

SITE PIPING PLAN
AND SEWER PROFILES


PROJECT NO. 96034 SHEET 4 OF 19

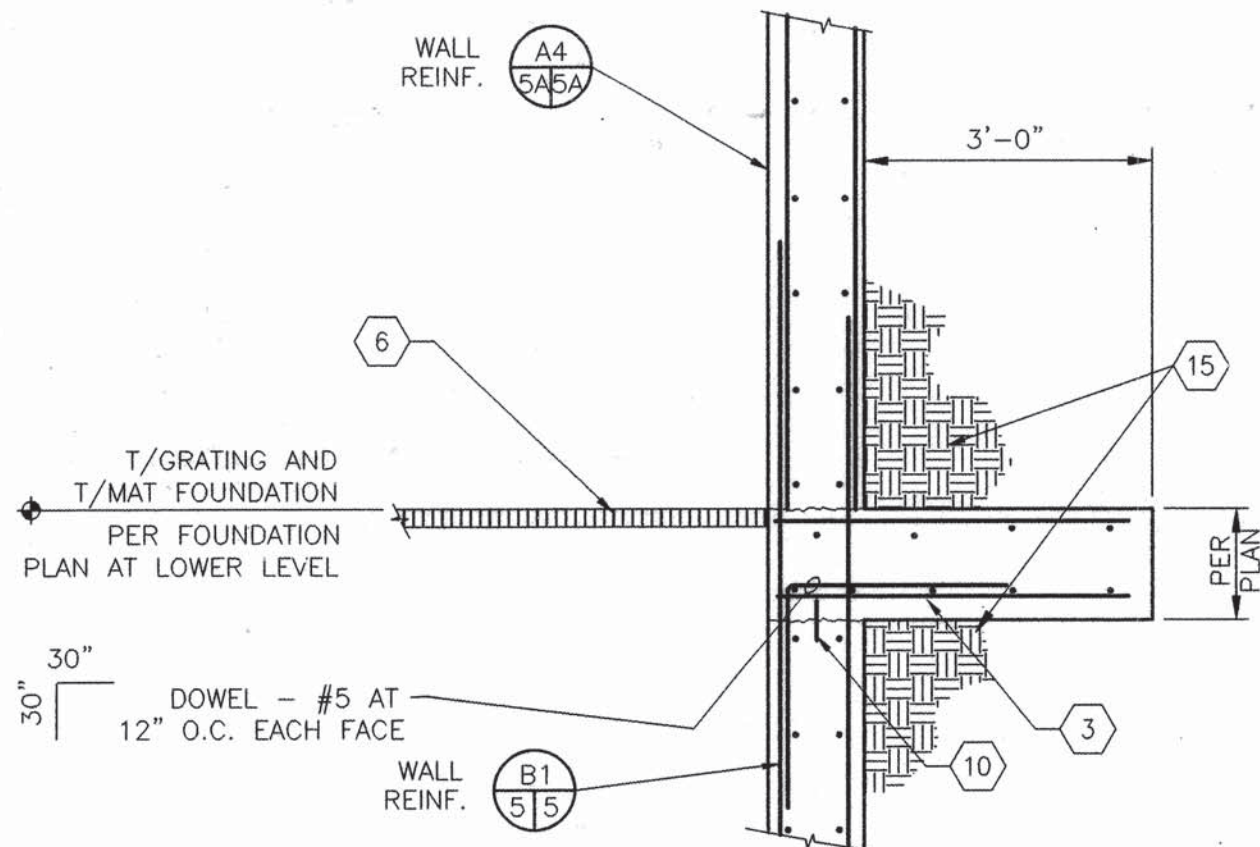


SECTION AT PUMP EQUIPMENT PIT
SCALE: 1/2" = 1'-0"

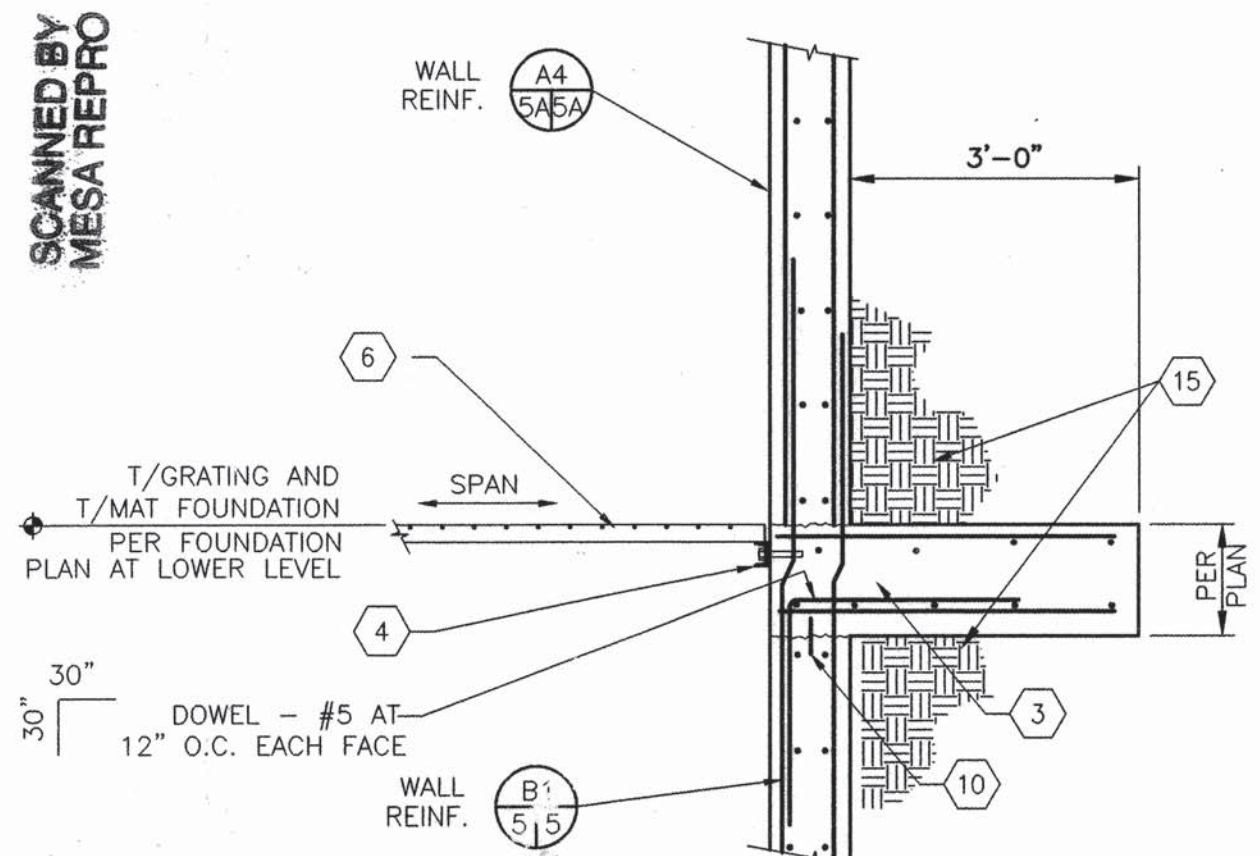

SECTION AT PUMP EQUIPMENT PIT
SCALE: 1/2" = 1'-0"

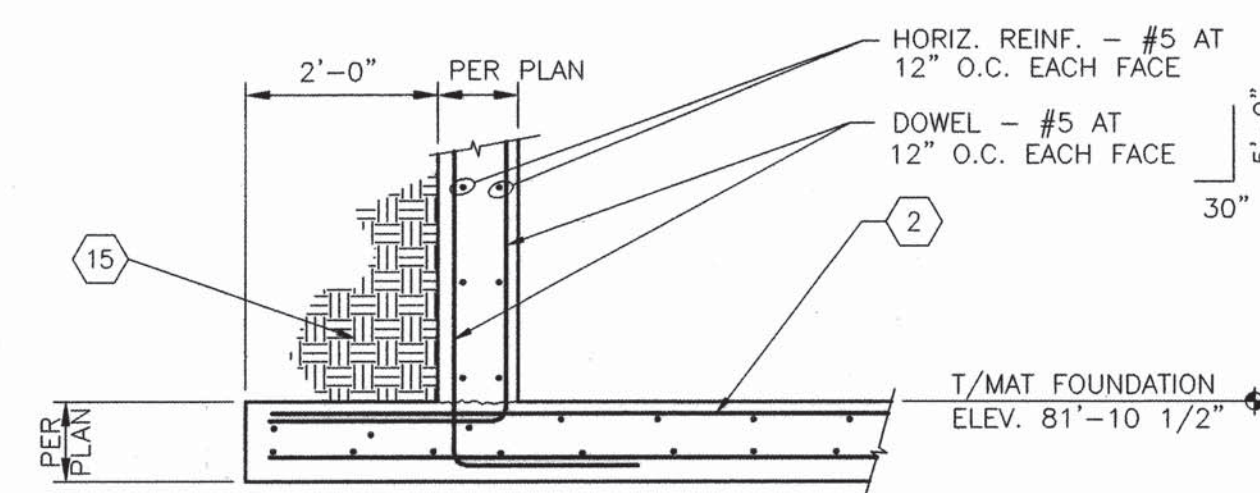


SECTION AT PUMP EQUIPMENT PIT
SCALE: 1/2" = 1'-0"

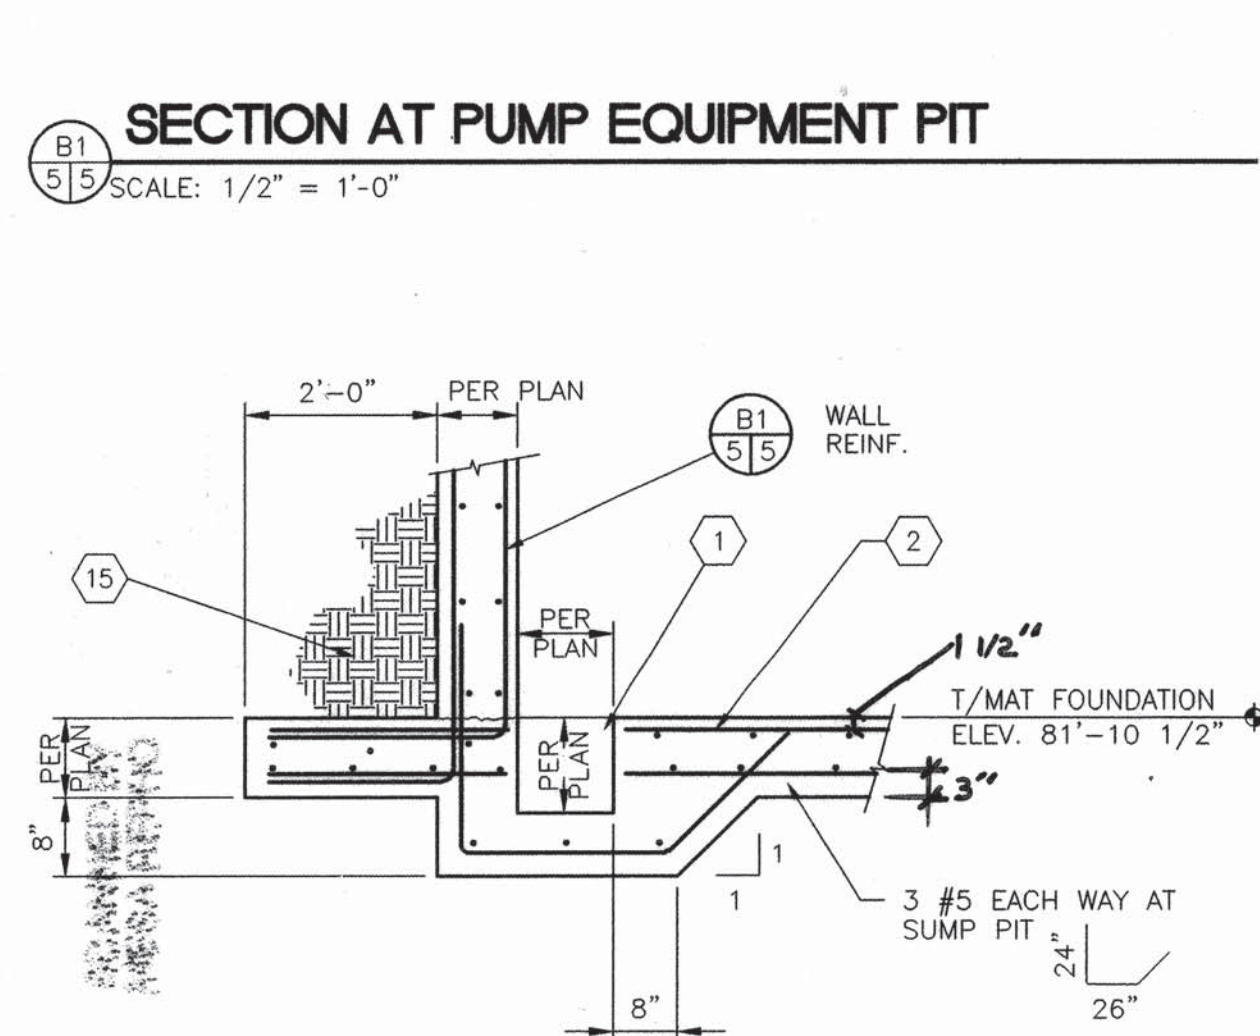


SECTION AT PUMP EQUIPMENT PIT
SCALE: 1/2" = 1'-0"


SECTION AT SUMP PIT
SCALE: 1/2" = 1'-0"

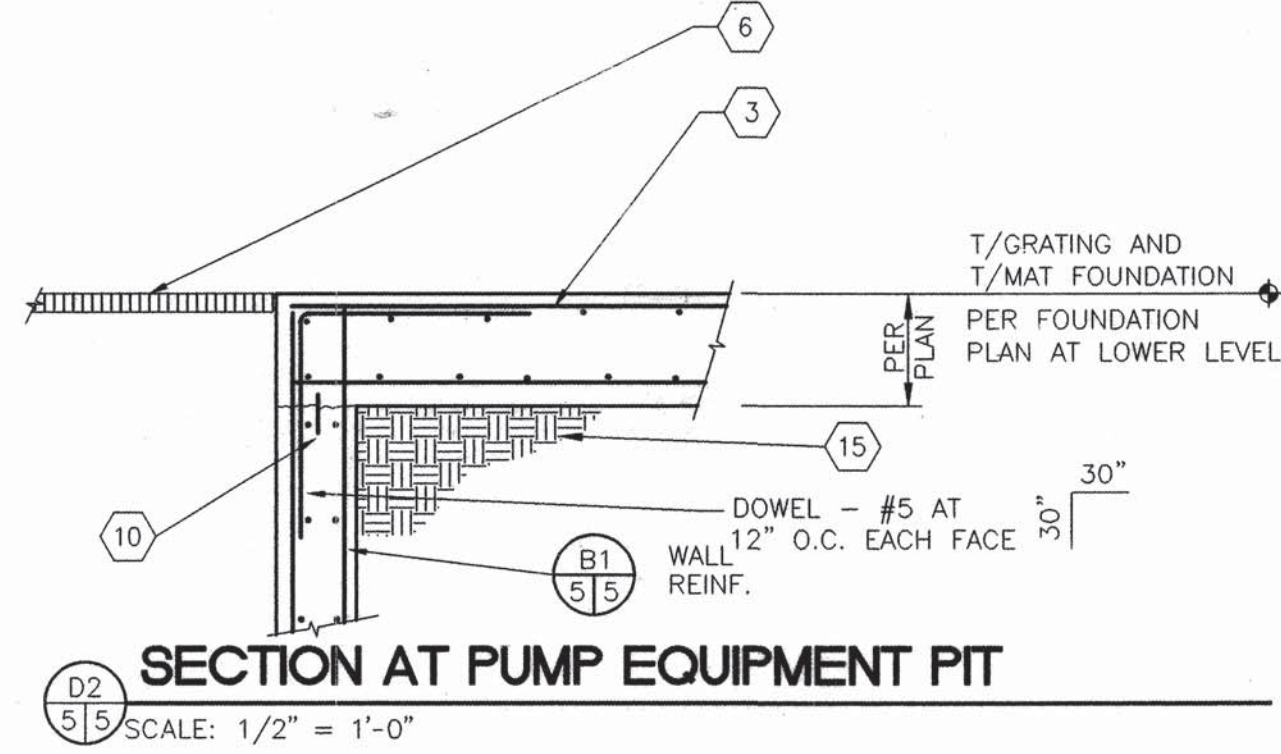


SECTION AT PUMP EQUIPMENT PIT
SCALE: 1/2" = 1'-0"

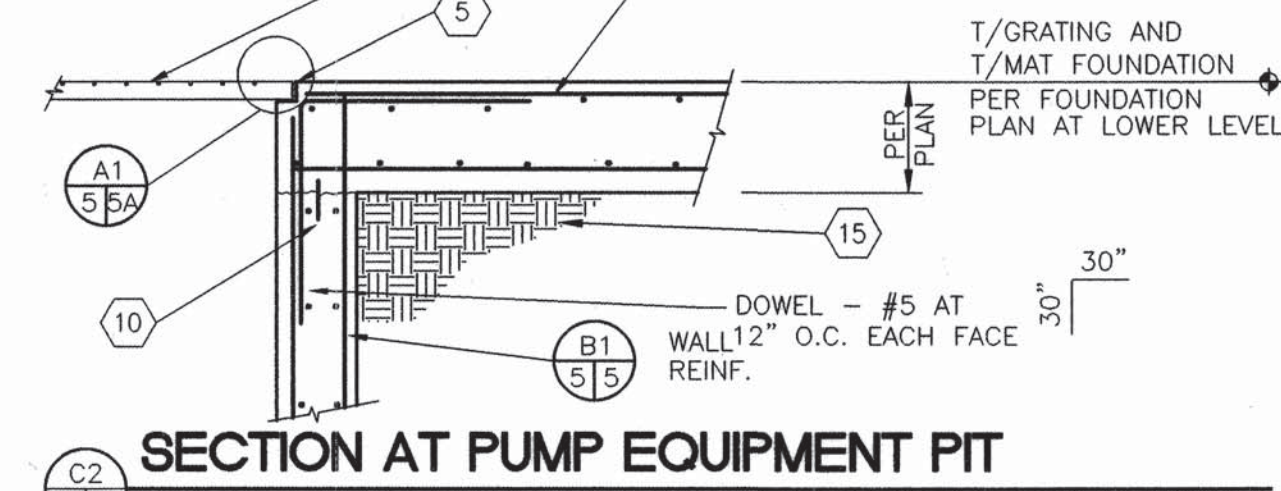


SECTION AT PUMP EQUIPMENT PIT
SCALE: 1/2" = 1'-0"

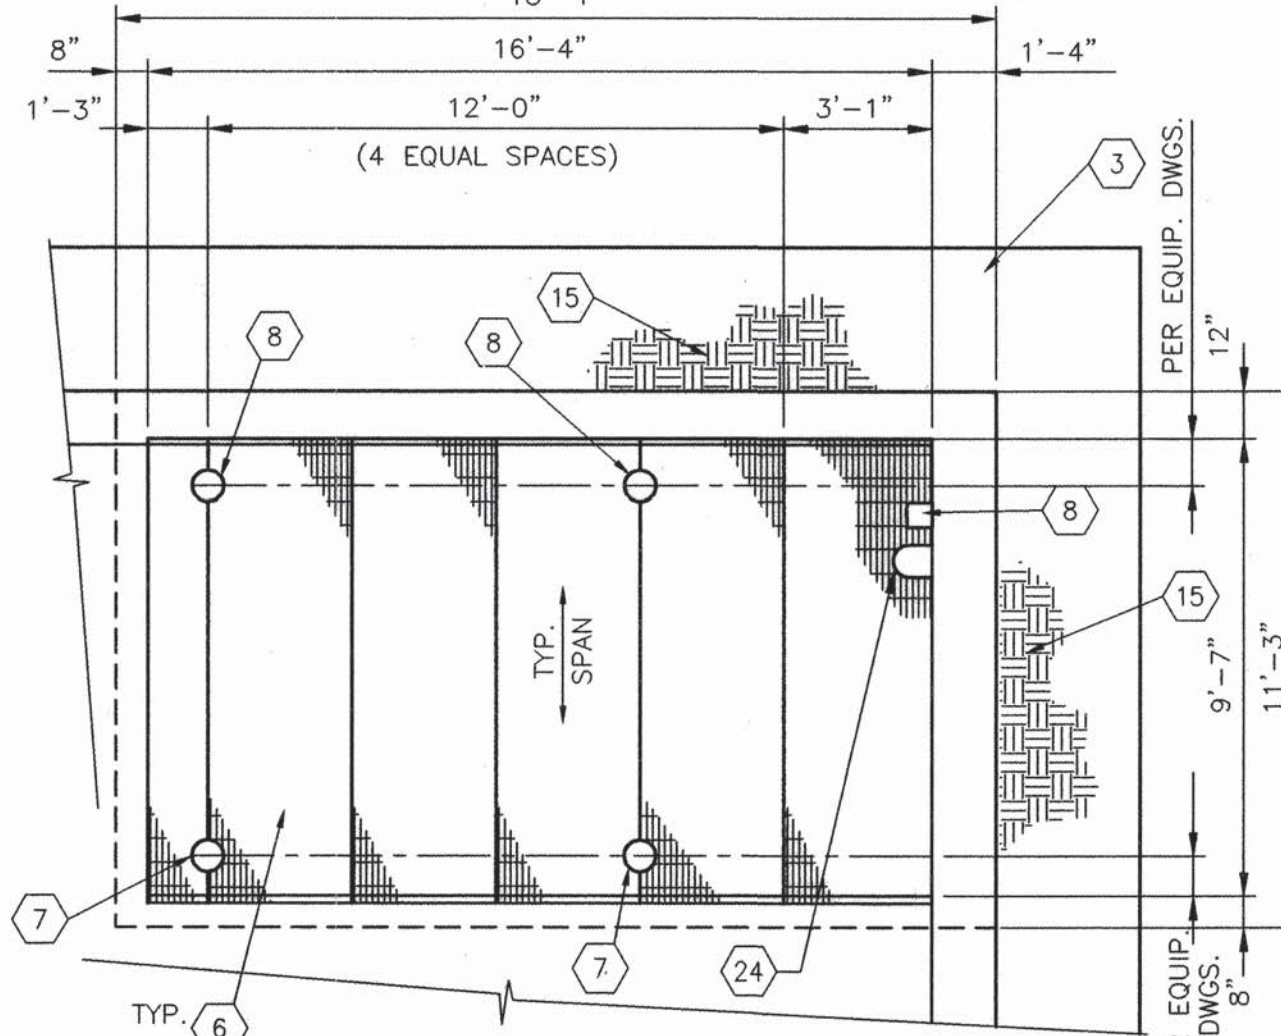


GRATING PLAN AT PUMP EQUIPMENT PIT
SCALE: 1/4" = 1'-0"

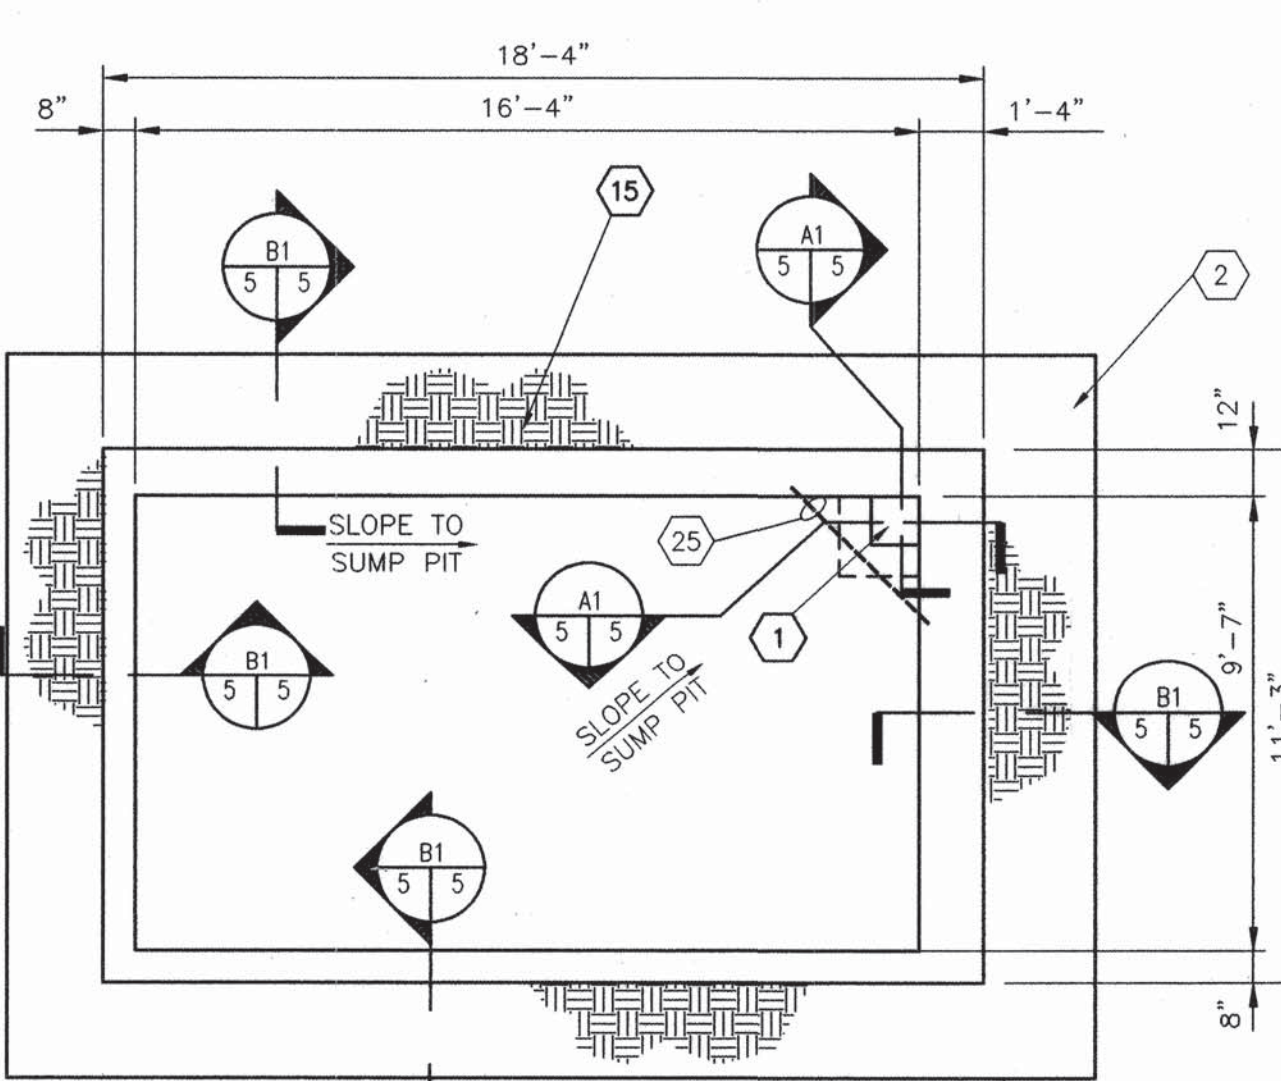

FOUNDATION PLAN AT PUMP EQUIPMENT PIT
SCALE: 1/4" = 1'-0"

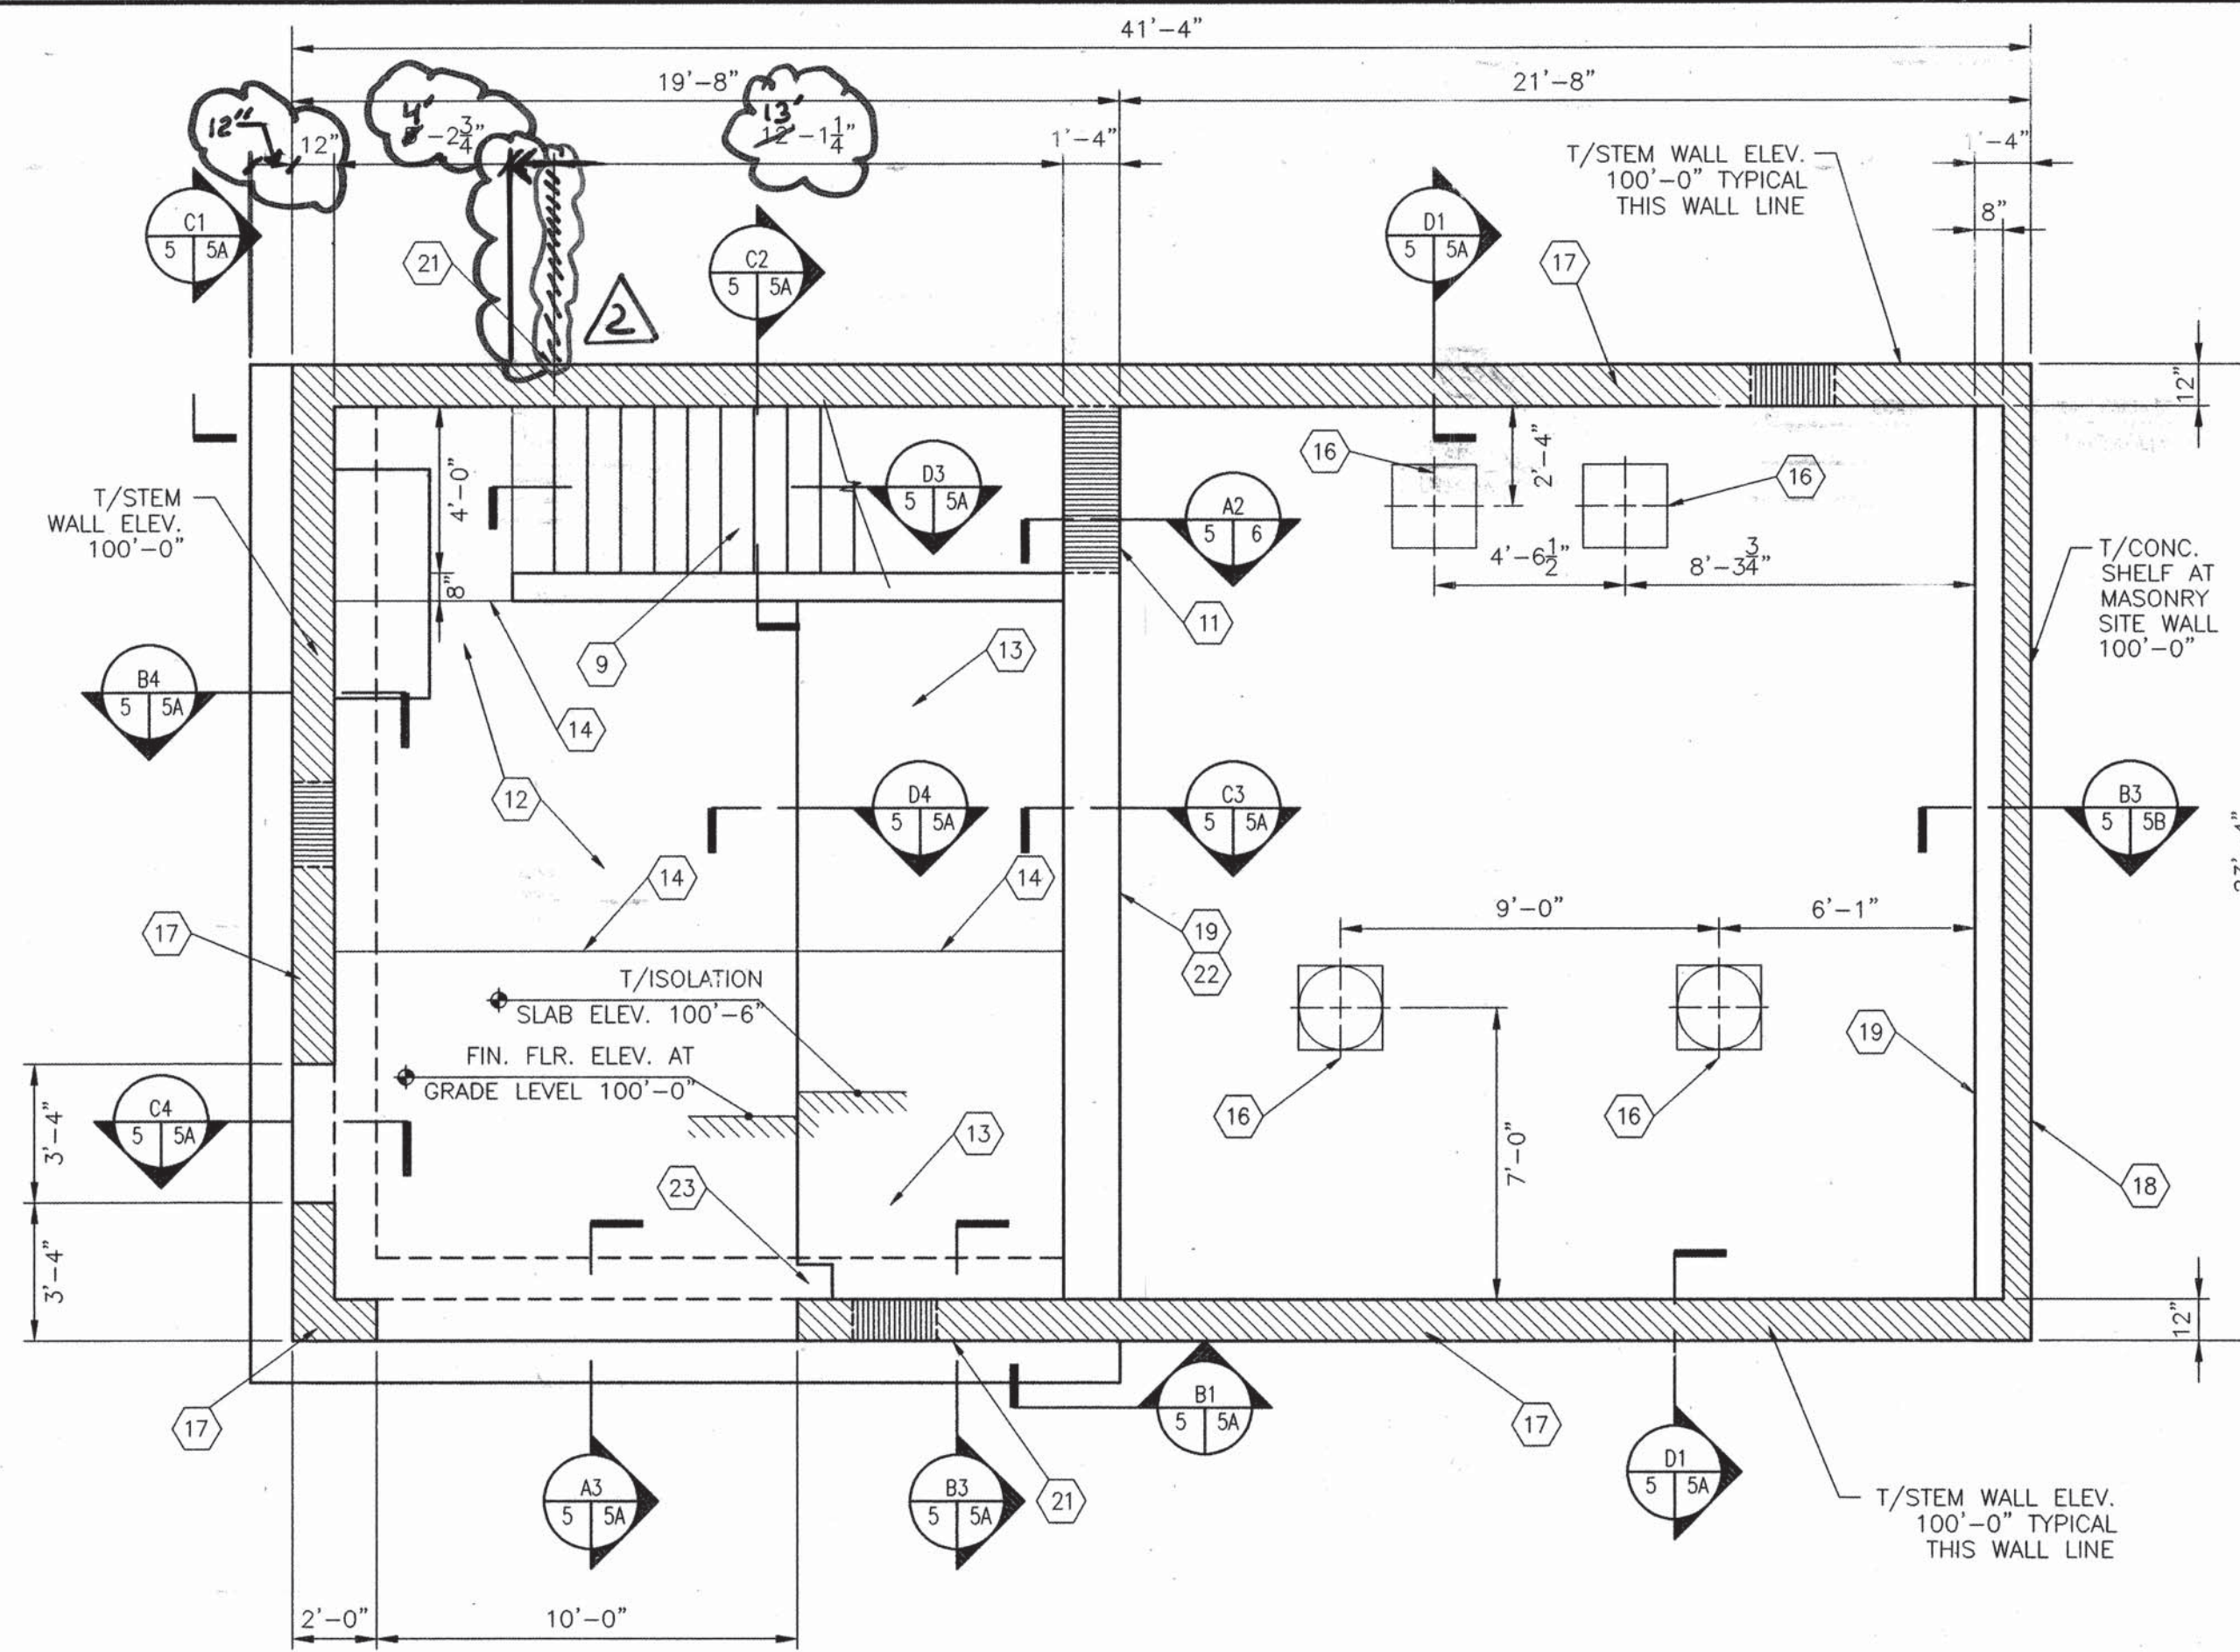

FOUNDATION PLAN AT GRADE LEVEL
SCALE: 1/4" = 1'-0"

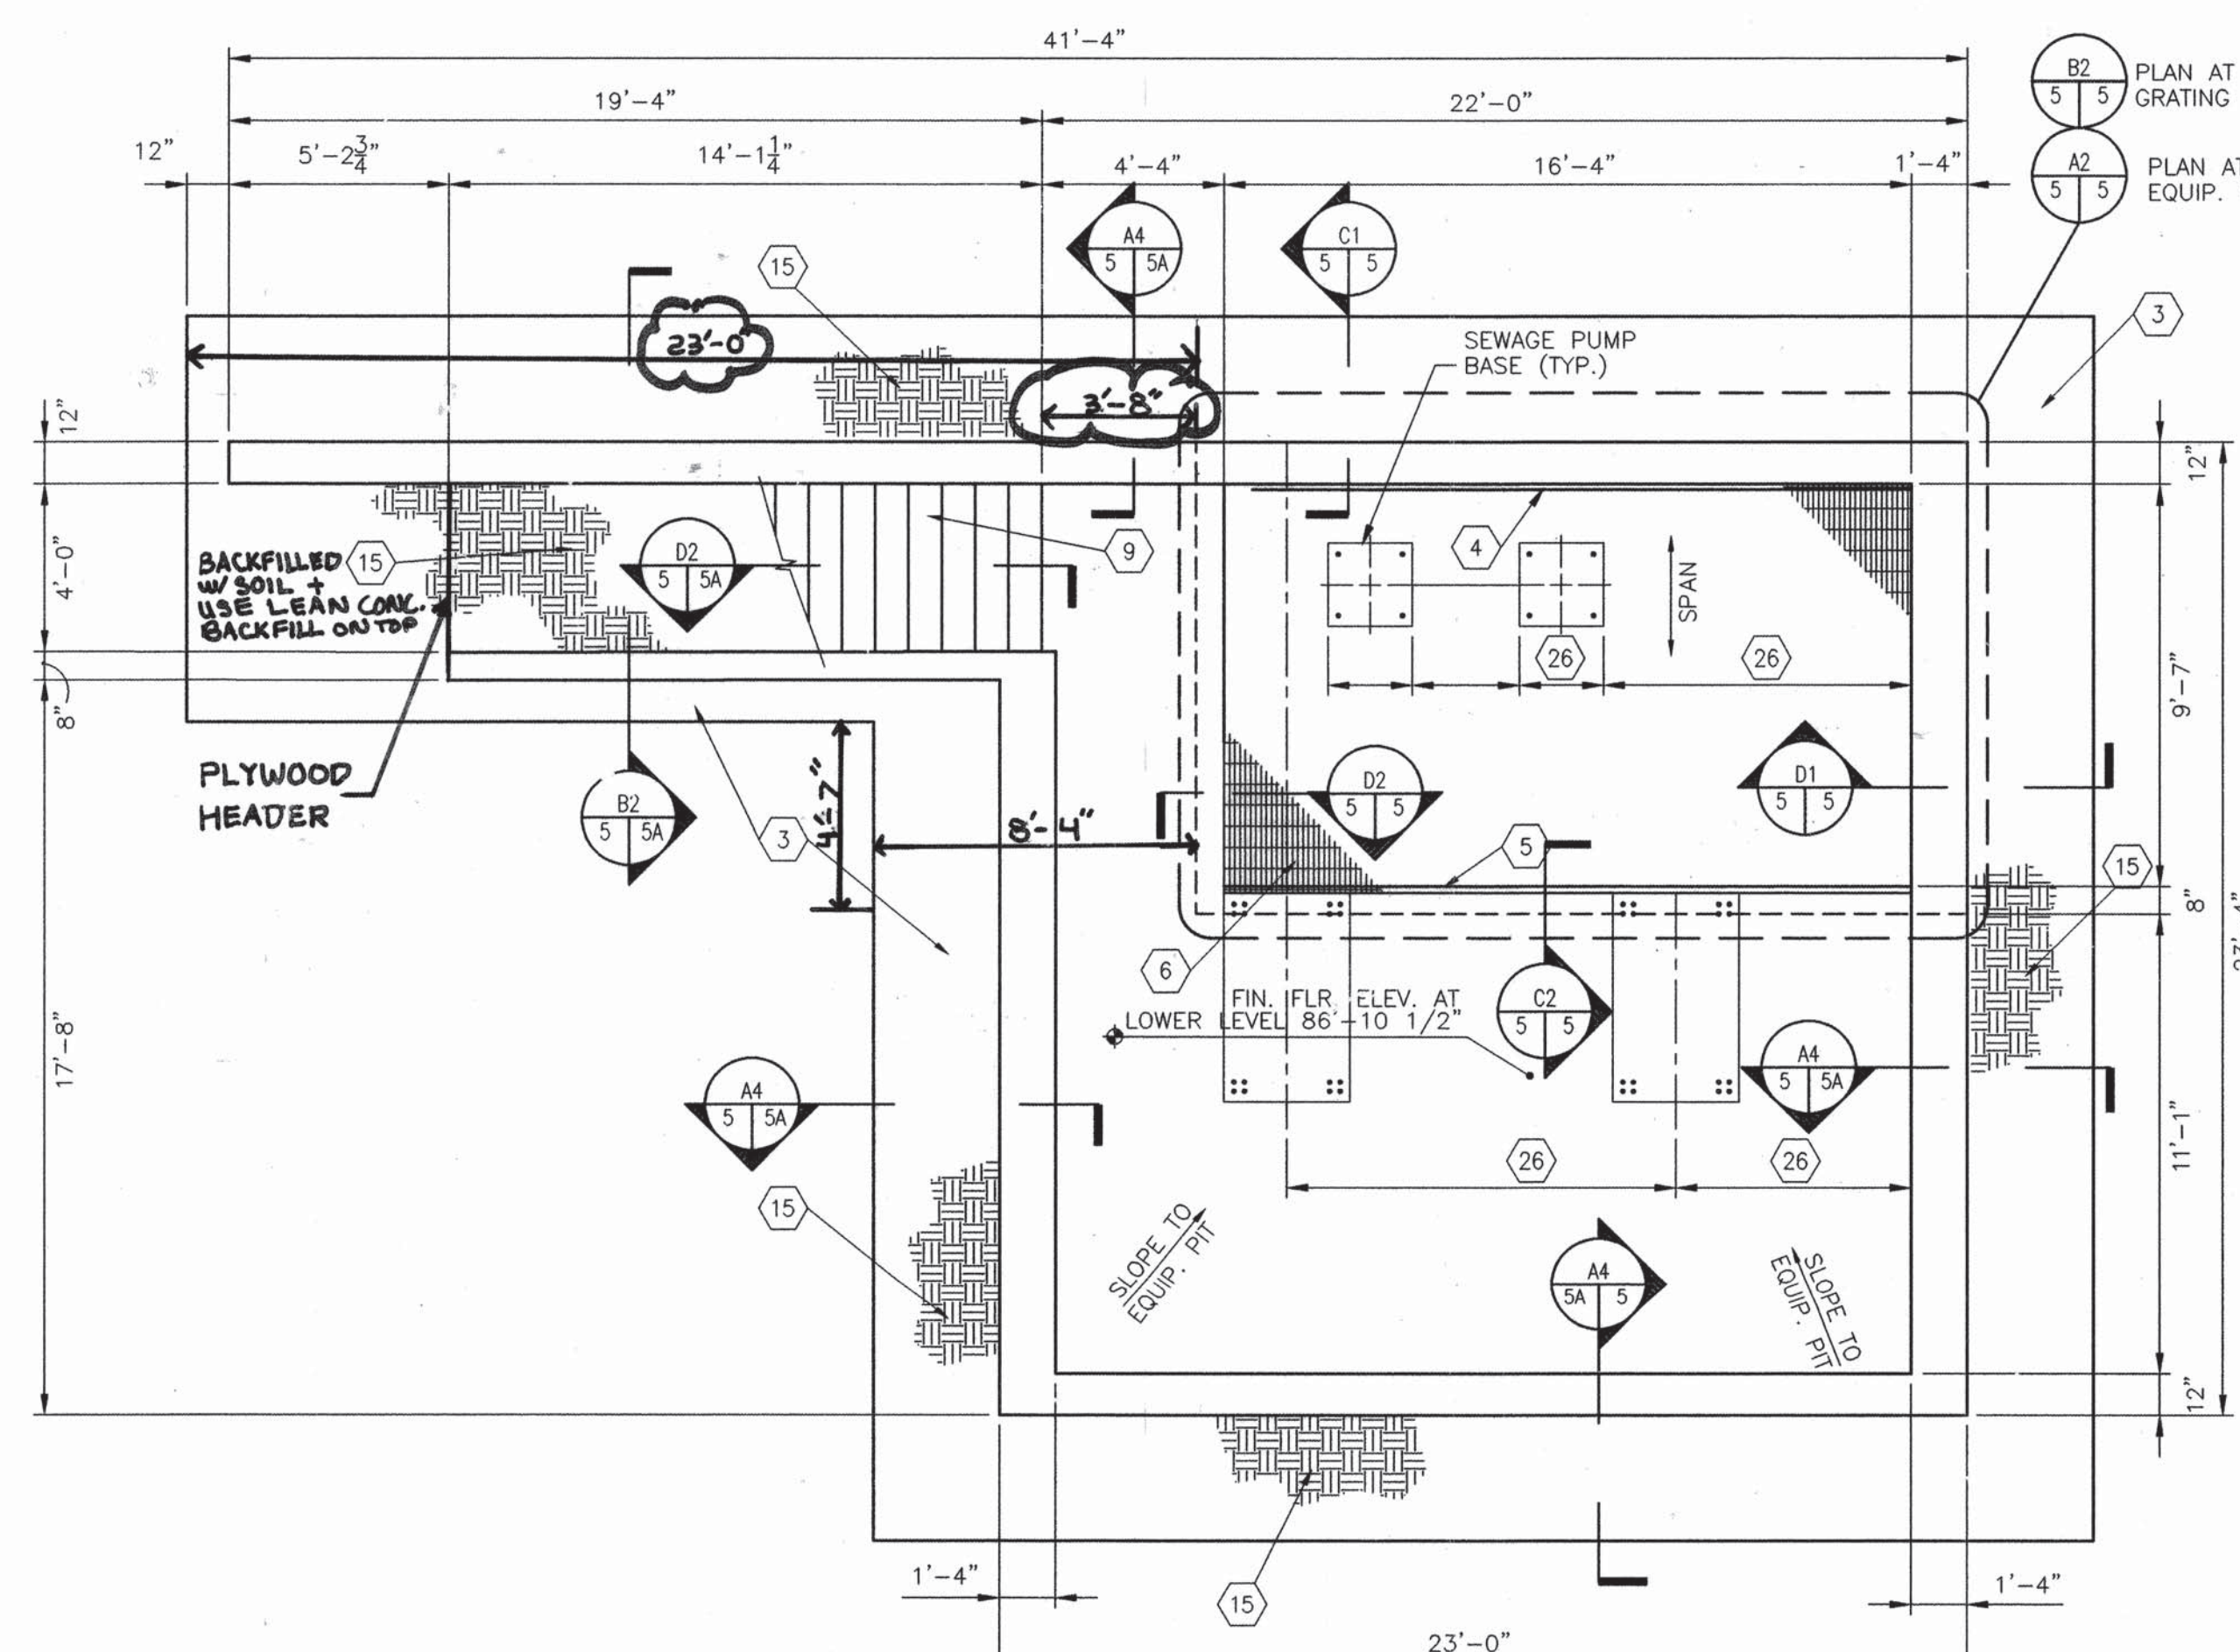

FOUNDATION PLAN AT LOWER LEVEL
SCALE: 1/4" = 1'-0"


GENERAL SHEET NOTES:

- A) REFERENCE FINISH FLOOR ELEVATION 100'-0" AND REFERENCES DATUM ELEVATION SHOWN ON SHEET 3
- B) FOR STOOPS, BOLLARDS AND HANDRAILS, SEE ARCHITECTURAL DRAWINGS.
- C) BUILDING LOCATION SHALL BE PER SITE PLAN, SEE SHEET 3
- D) FOR PIPE SIZES AND LOCATIONS, SEE EQUIPMENT PLAN, SECTION AND DETAIL DRAWING.
- E) FOR MECHANICAL WALL PENETRATION LOCATIONS AND SIZES, SEE AND COORDINATE WITH ARCHITECTURAL AND MECHANICAL DRAWINGS AND SEE DETAIL A1/5.
- F) EQUIPMENT DIMENSIONS ARE SUBJECT TO MANUFACTURE. VERIFY PRIOR TO INITIATION OF CONSTRUCTION.
- G) FOR SHEET WATERPROOFING BELOW GRADE, SEE ARCHITECTURAL DRAWINGS

SHEET KEYED NOTES : (X)

- 1) SUMP PIT - 12" x 12" x 12" DEEP, CONSTRUCTION PER SECTION
- 2) CAST-IN-PLACE CONCRETE MAT FOUNDATION 15'-3" WIDE x 22'-4" LONG x 0'-10" THICK W/ #5 AT 18" O.C. EACH WAY IN BOTTOM AND W/ #5 AT 12" O.C. EACH WAY IN TOP
- 3) CAST-IN-PLACE CONCRETE MAT FOUNDATION SHAPE AS SHOWN x 1'-2" THICK W/ #5 AT 10" O.C. EACH WAY IN BOTTOM AND W/ #5 AT 12" O.C. EACH WAY AT TOP
- 4) ALUMINUM CHANNEL - C 3 x 2.07 W/ CHEMICAL ANCHORS, STAINLESS STEEL, THREADED ROD - 3/4" DIAMETER W/ 4" EMBEDMENT, AT 3" FROM EACH END AND AT 12" O.C. BETWEEN
- 5) GALVANIZED STEEL ANGLE
- 6) GRATING TYPE 1, SPAN AS INDICATED
- 7) BANDED OPENING AT GRATING EDGE FOR PIPE PENETRATION DOWN TO PIT BELOW, VERIFY SIZE AND LOCATION WITH EQUIPMENT DRAWINGS
- 8) BANDED OPENING AT GRATING EDGE FOR PIPE PENETRATION UP FROM PIT BELOW, VERIFY SIZE AND LOCATION WITH EQUIPMENT DRAWINGS
- 9) CAST-IN-PLACE CONCRETE STAIRS - SEE ARCHITECTURAL DRAWINGS FOR RISE AND RUN
- 10) WATERSTOP
- 11) CAST-IN-PLACE CONCRETE LINTEL AT STAIRWELL
- 12) CAST-IN-PLACE CONCRETE SLAB - 5" THICK W/ #4 AT 12" O.C. EACH WAY
- 13) CAST-IN-PLACE CONCRETE CONCRETE ISOLATION SLAB - 11" THICK W/ #5 AT 12" O.C. EACH WAY AT CENTER OF SLAB
- 14) SAW CUT JOINT - SEE TYPICAL SAW CUT JOINT DETAIL SHEET 2
- 15) STRUCTURAL BACK FILL
- 16) EQUIPMENT ACCESS DOORS ABOVE
- 17) CONCRETE MASONRY UNIT WALL - 12" WIDE
- 18) CONCRETE MASONRY UNIT WALL - 8" WIDE
- 19) CONCRETE WALL PER SECTION
- 20) HORIZ. BOND BEAMS THIS WALL LINE PER HORIZONTAL REINFORCING SECTION C3/5B
- 21) HORIZ. BOND BEAMS THIS WALL LINE PER HORIZONTAL REINFORCING SECTION C4/5B
- 22) HORIZ. BOND BEAMS THIS WALL LINE PER HORIZONTAL REINFORCING SECTION C2/5B
- 23) PROVIDE 8" x 8" BLOCK-OUT IN ISOLATION SLAB AT OVERHEAD JAMB
- 24) BANDED SLOT AT PIPING ALONG WALL LINE, VERIFY SIZE AND SPACING W/ EQUIPMENT DRAWINGS
- 25) PROVIDE (1) #5 x 4'-0" DIAG. CORNER BAR AT SUMP PIT
- 26) LOCATION OF TANKS AND ANCHORING REQUIREMENTS SUBJECT TO EQUIPMENT SUPPLIED. COORDINATE WITH MANUFACTURER PRIOR TO CONSTRUCTION.

CITY PROJECT #567292

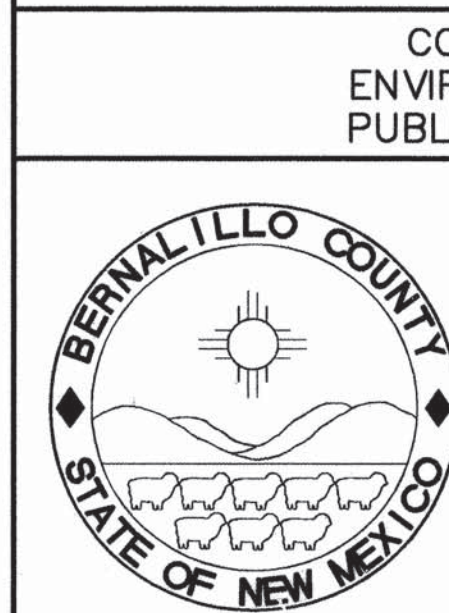

COUNTY OF BERNALILLO
ENVIRONMENTAL HEALTH AND
PUBLIC WORKS DEPARTMENTS

**NORTH VALLEY AREAS B AND F
VACUUM STATION**

STRUCTURAL - FOUNDATION PLANS
BELOW AND AT GRADE LEVEL

PROJECT NO. 96034 SHEET 5 OF 19

**WILSON
& COMPANY**

X:\PUBLIC\PROJECTS\96034\DRAWINGS\VACSTA\STRUCT\6034VS-SHT5-9-1-99.DWG



AS-BUILT INFORMATION	
CONTRACTOR	TRAD Builders of NM
WORK	TRAD
DATE	1/99
INSPECTOR	Wilson & Co.
DATE	3/00
VERIFICATION BY	Wilson & Co.
DATE	9/00
MICRO-FILM INFORMATION	
RECORDED BY	
DATE	

BENCH MARKS	
NO.	DATE

SURVEY INFORMATION	
FIELD BY	DATE
NO.	

ENGINEER'S SEAL	
NO.	DATE

FOUNDATION CORRECTION	
NO.	DATE

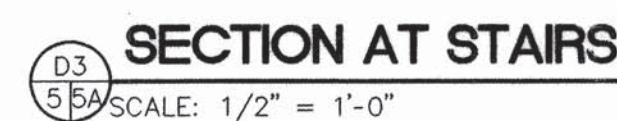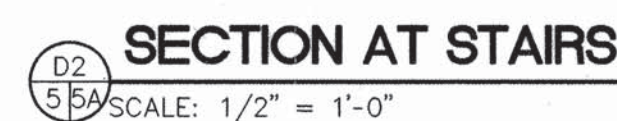

- 1) CONCRETE FOOTING SIZE AND REINFORCEMENT PER FOUNDATION PLAN
- 2) CAST-IN-PLACE MAT FOUNDATION REINFORCEMENT PER FOUNDATION PLAN
- 3) CONCRETE FLOOR SLAB PER FOUNDATION PLAN
- 4) CONCRETE ISOLATION SLAB PER FOUNDATION PLAN
- 5) CAST-IN-PLACE CONCRETE STAIRS, FOR STAIR RISE, RUN AND NOSING SEE ARCHITECTURAL DRAWINGS
- 6) CONCRETE MASONRY UNIT WALL - 12" WIDE
- 7) FINISH GRADE AT EXTERIOR

COUNTY OF BERNALILLO
ENVIRONMENTAL HEALTH AND
PUBLIC WORKS DEPARTMENTS

NORTH VALLEY AREAS B AND F
VACUUM STATION

STRUCTURAL DETAILS

PROJECT NO.	96034
-------------	-------

SHEET 5A OF 19

AS-BUILT INFORMATION
CONTRACTOR: TRIAD BUILDERS OF NM
WORKED BY: TRIAD
START DATE: 11/99
PROJECT NO.: 3100
ISSUED BY: WILSON & Co.
FIELD DATE: 3/00
VERIFICATION BY: WILSON & Co.
DRAWING NO.: 9100
RECORDED BY: WILSON & Co.
NO.

BENCH MARKS

SURVEY INFORMATION

ENGINEER'S SEAL

CONTRACTOR TRIAD BUILDERS OF NM	
WORK STATED BY TRIAD	DATE 11/99
INSPECTOR'S ACCEPTANCE BY WILSON & Co.	DATE 3/00
DRAWINGS CORRECTED BY WILSON & Co.	
DATE 9/00	
MICRO-FILM INFORMATION	
RECORDED BY	
NO	

FIELD NOTES		DATE
-------------	--	------

ERT J. PAUL

STAMPED BY <u>11111</u>	DATE <u>3/00</u>
INSPECTOR'S ACCEPTANCE BY <u>WILSON & Co.</u>	DATE <u>3/00</u>
FIELD VERIFICATION BY	
DRAWINGS CORRECTED BY <u>WILSON & Co.</u>	DATE <u>4/00</u>
MICRO-FILM INFORMATION	
RECORDED BY	
NU	

U		
5		
6		

ROBERTO MEXICO

DATE _____
 VERIFICATION BY _____
 DRAWINGS CORRECTED BY **WILSON & Co.** 9/60
MICRO-FILM INFORMATION
 RECORDED BY _____
 NO. _____

--	--	--

12763

MICRO-FILM INFORMATION

RECORDED BY _____

NO. _____

93-7

NU


SCANNED BY
MESA REPRO

**WILSON
& COMPANY**


X: \\PUBLIC\\PROJECTS\\96034\\DRAWINGS\\VACSTA\\STRUCT\\6034VS-SHT5A-9-1-99.DWG

6034VS-SHT5B.dwg 111898 105842


SCANNED BY
MESA REPRO
MESA REPRO

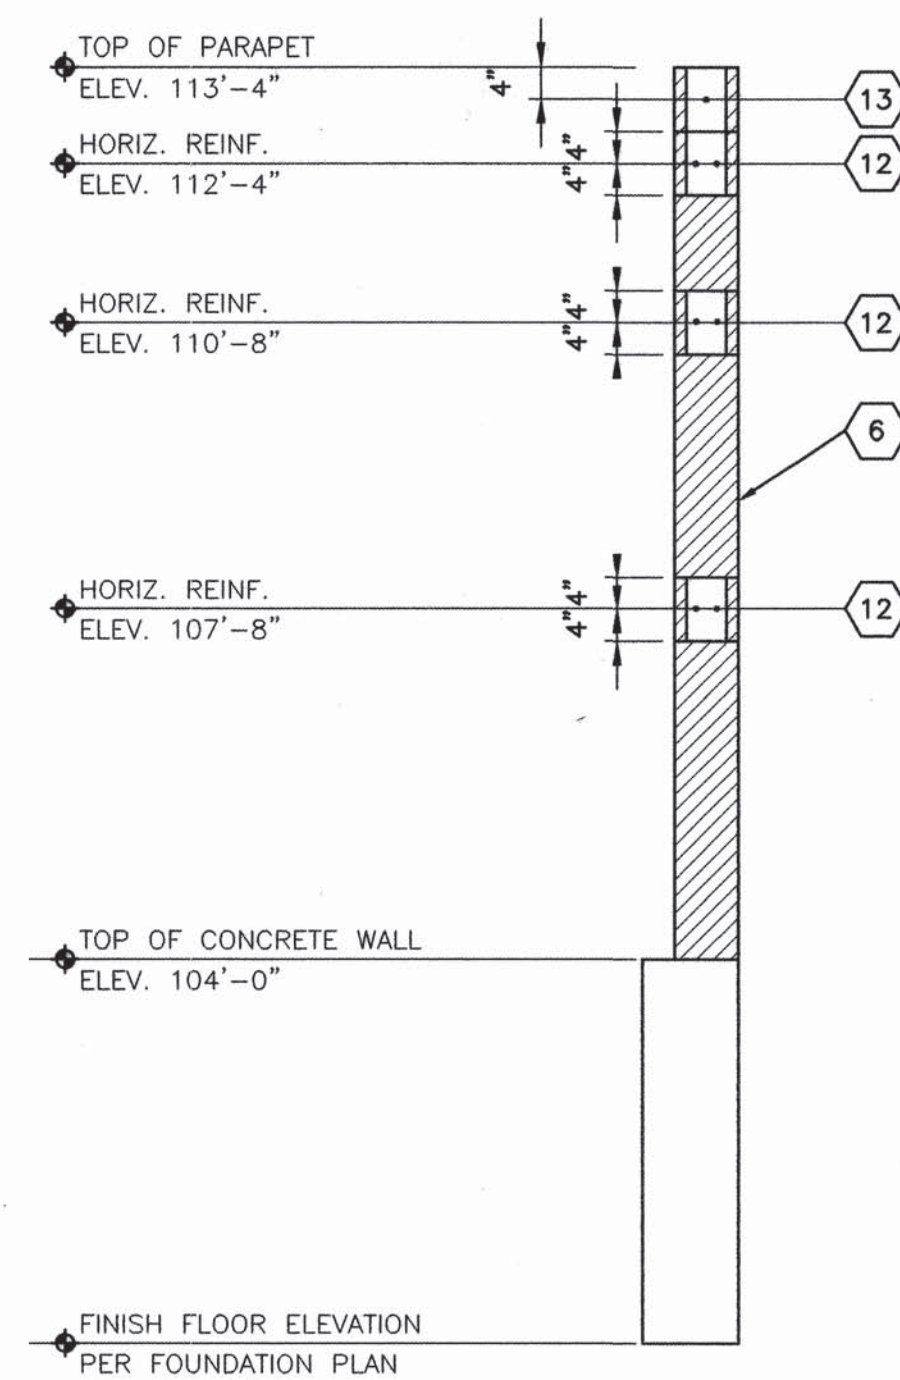


C2
5/5/98 HORIZONTAL BOND BEAM SECTION
SCALE: 1/2" = 1'-0"

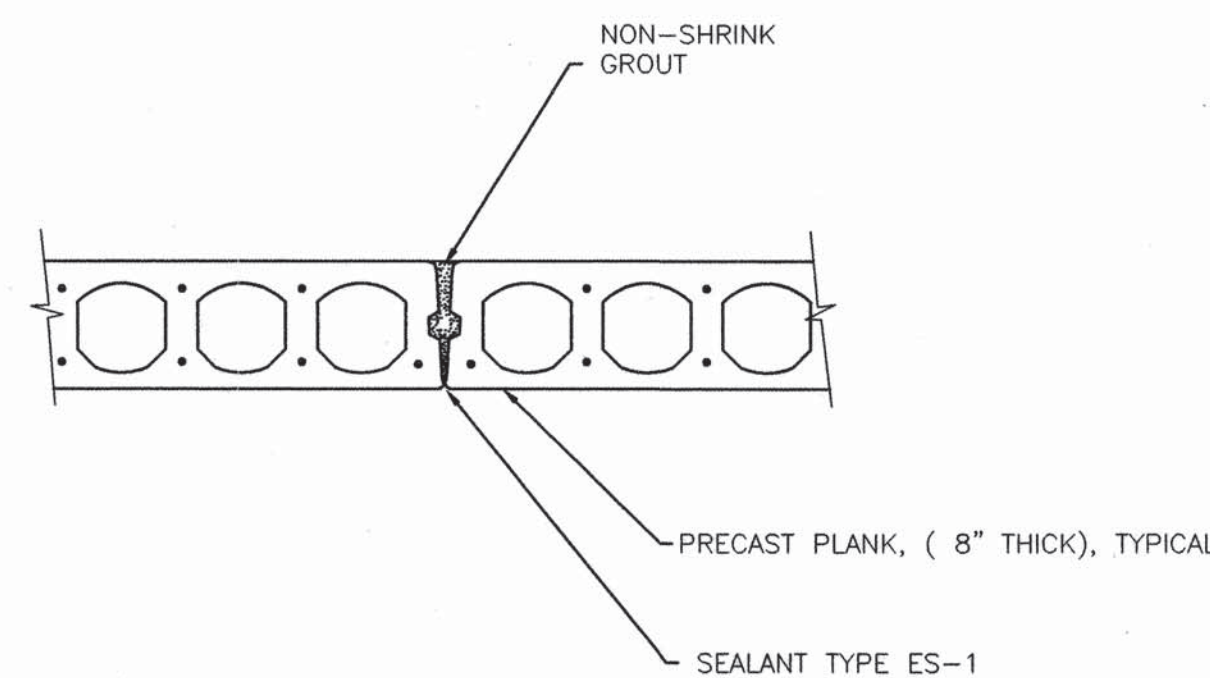


B2
6/5/98 PRECAST PLANK JOINT DETAIL
SCALE: 1/4" = 1'-0"

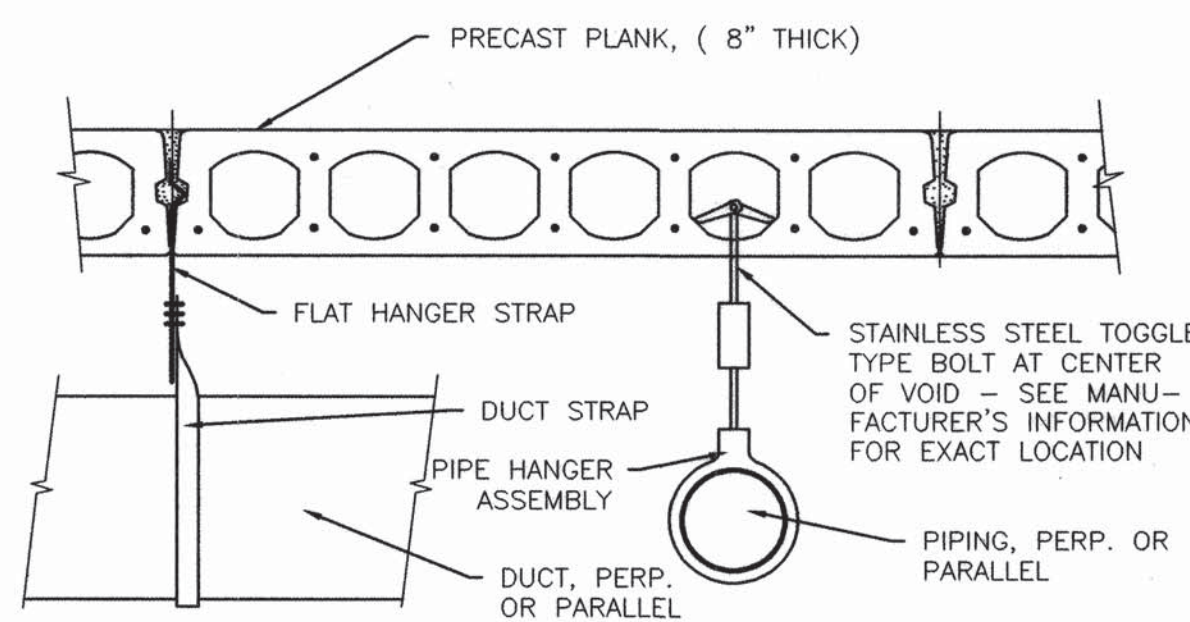


A2
6/5/98 PRECAST PLANK DUCT ANCHORAGE
SCALE: 1/4" = 1'-0"

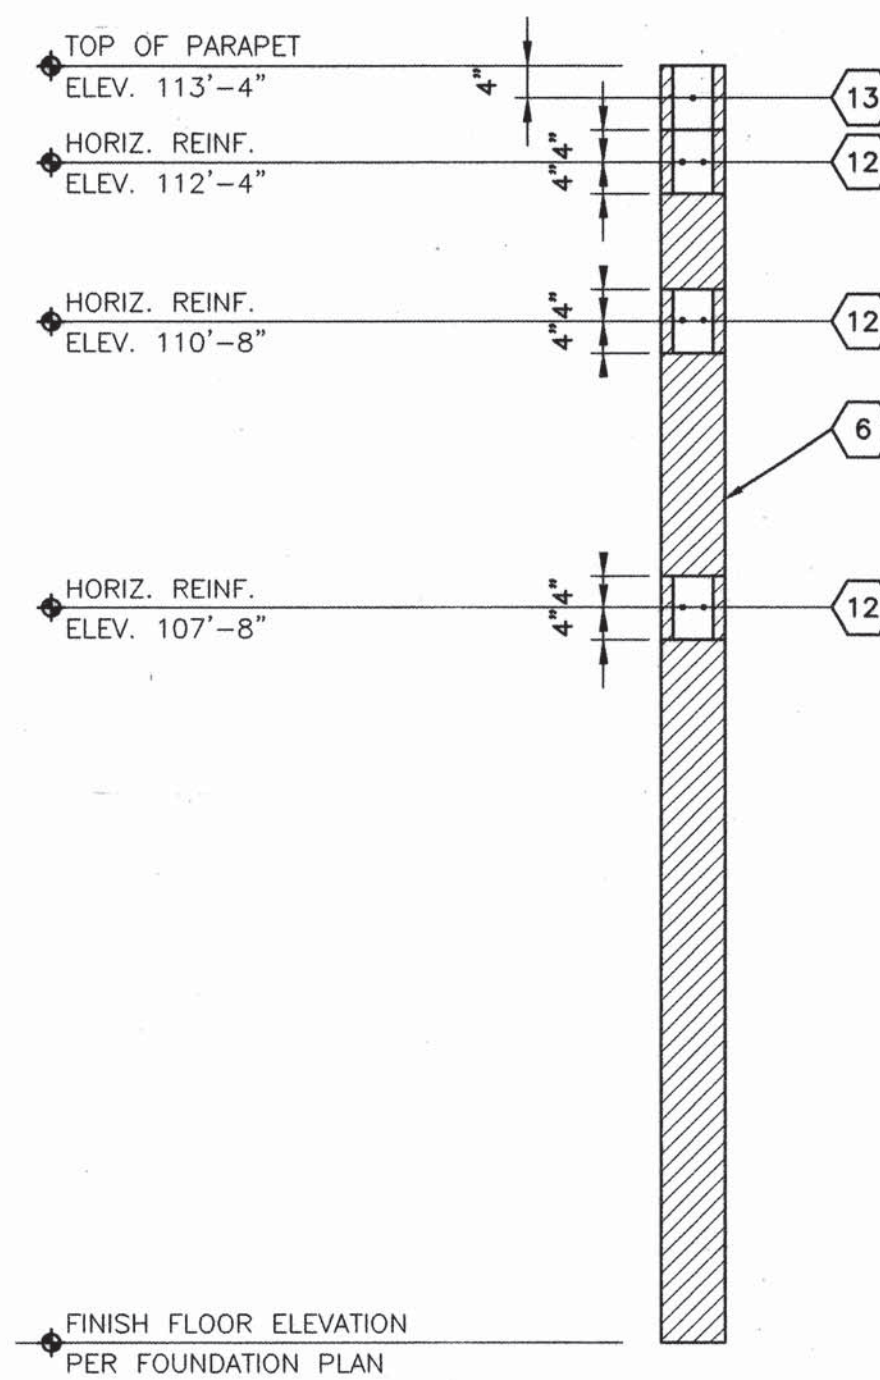


C3
5/5/98 HORIZONTAL BOND BEAM SECTION
SCALE: 1/2" = 1'-0"

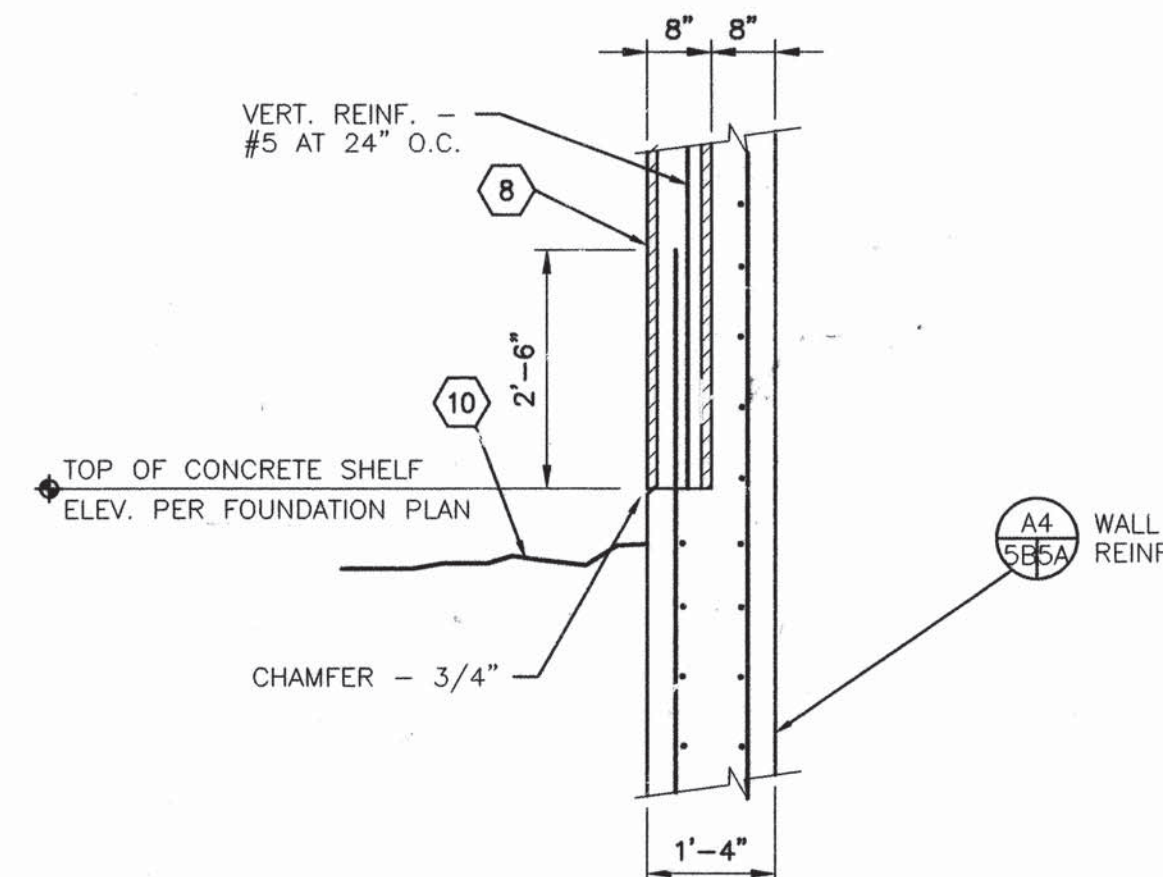


B3
5/5/98 SECTION AT SITE WALL/ BUILDING INTERFACE
SCALE: 1/2" = 1'-0"

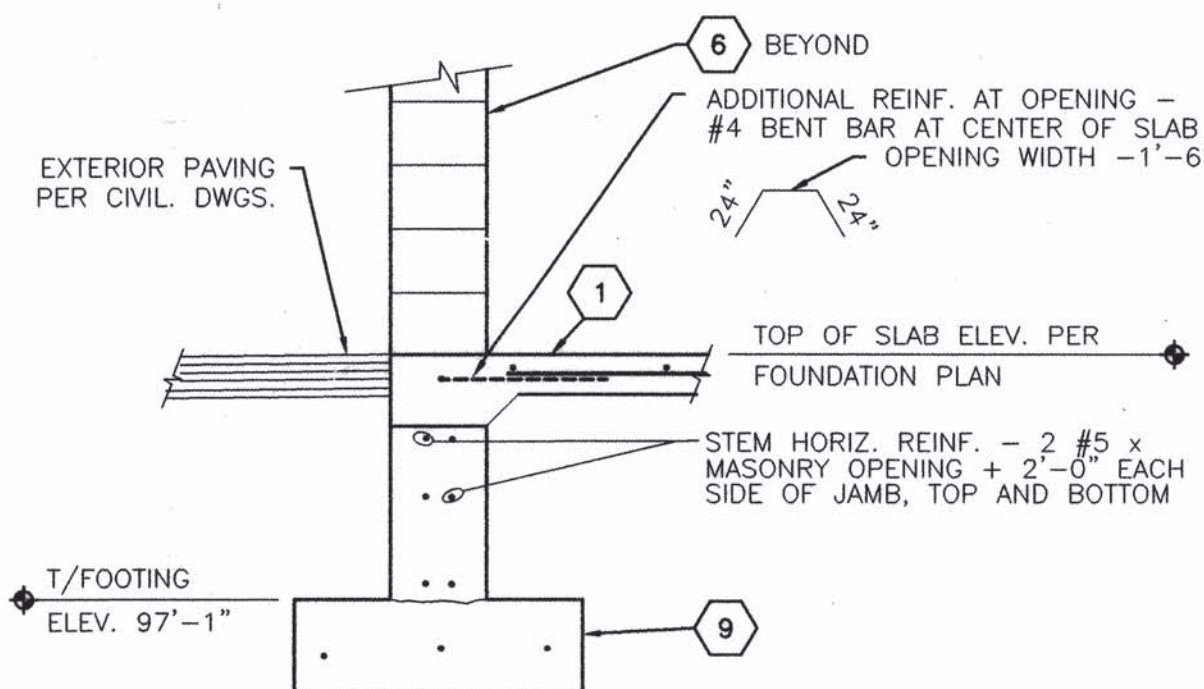


A3
5/5/98 SECTION AT OVERHEAD DOOR SILL
SCALE: 1/2" = 1'-0"

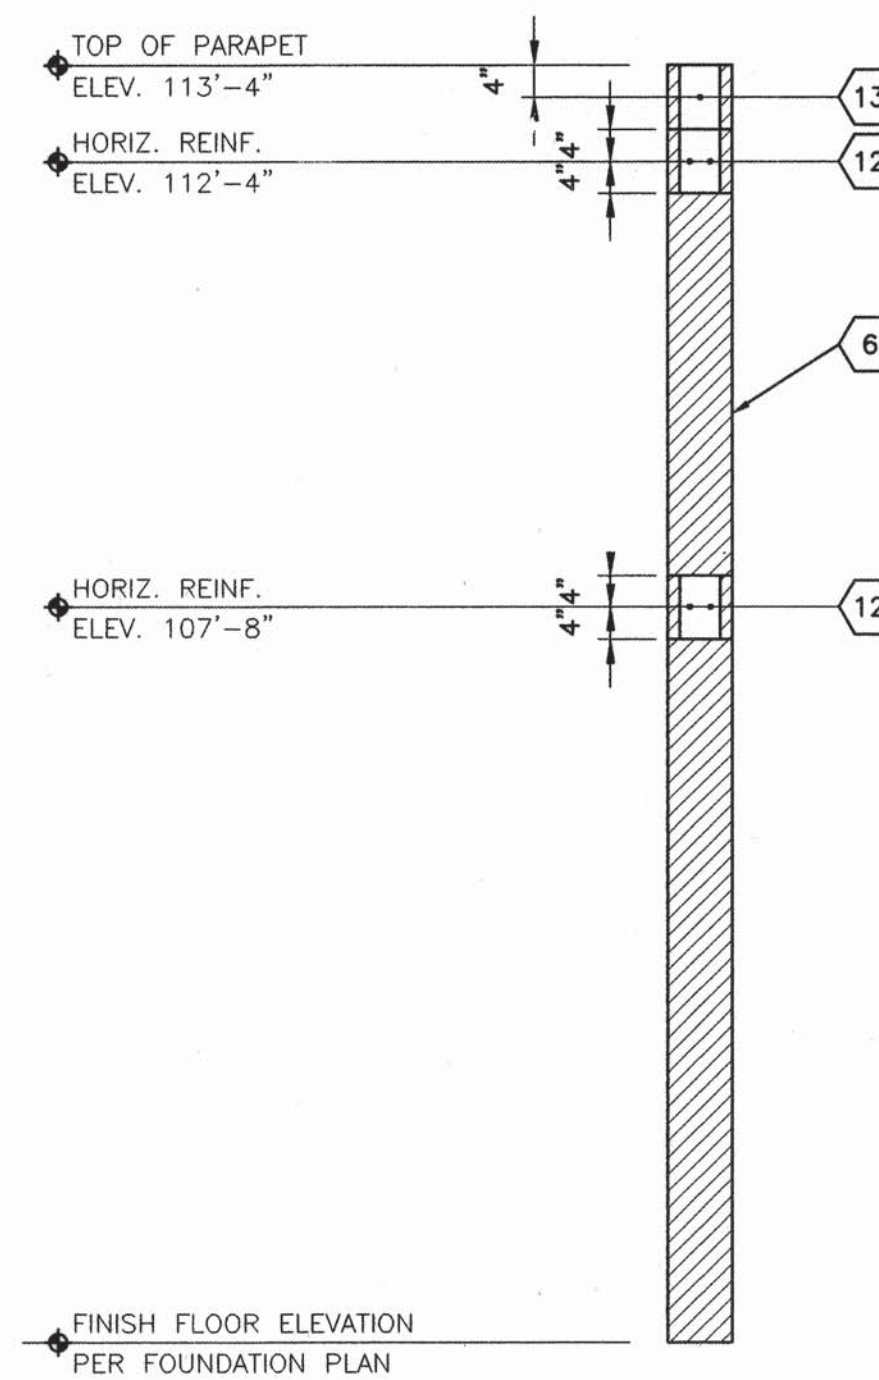

C4
5/5/98 HORIZONTAL BOND BEAM SECTION
SCALE: 1/2" = 1'-0"

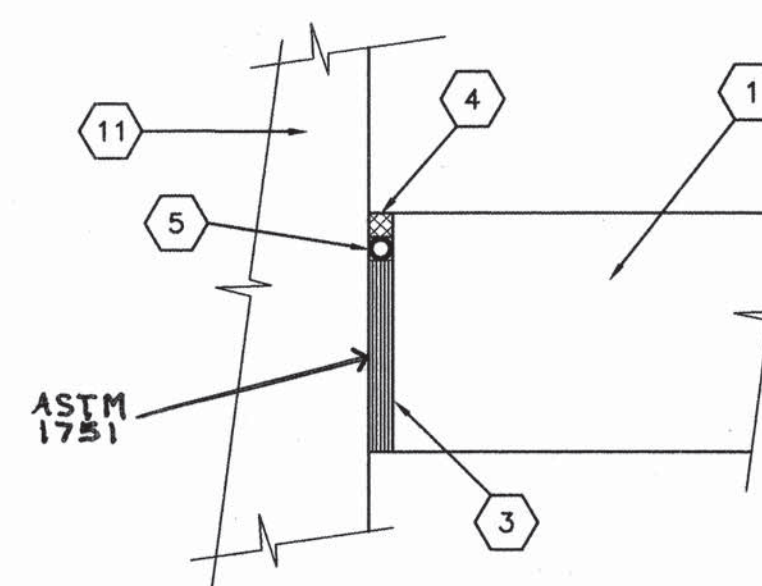

B4
5/5/98 JOINT SEALANT DETAIL
SCALE: 3" = 1'-0"

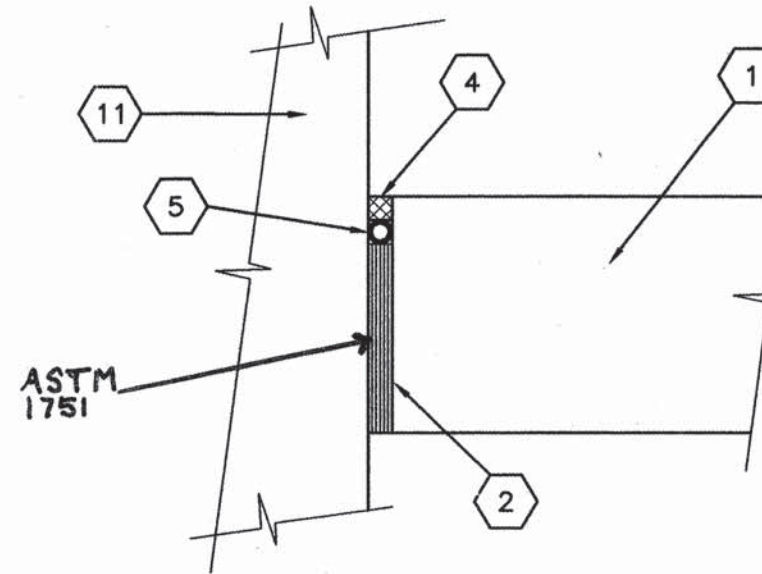

A4
5/5/98 JOINT SEALANT DETAIL
SCALE: 3" = 1'-0"

GENERAL SHEET NOTES:

SHEET KEYED NOTES : (X)

- 1) CONCRETE SLAB PER FOUNDATION PLAN
- 2) JOINT FILLER - TYPE 1
- 3) JOINT FILLER - TYPE 2
- 4) SEALANT TYPE ES-2
- 5) JOINT BACKER
- 6) CONCRETE MASONRY UNIT WALL - 12" WIDE
- 7) CONCRETE MASONRY UNIT PARAPET WALL - 8" WIDE
- 8) CONCRETE MASONRY UNIT WALL - 8" WIDE
- 9) CONCRETE FOOTING SIZE AND REINFORCING PER FOUNDATION PLAN
- 10) FINISH GRADE LINE
- 11) CONCRETE MASONRY UNIT WALL OR CONCRETE WALL PER FOUNDATION PLAN
- 12) BOND BEAM - 8" DEEP W/ 2 #5 CONT. HORIZONTALLY
- 13) BOND BEAM - 8" DEEP W/ 1 #5 CONT. HORIZONTALLY

CITY PROJECT #567292

COUNTY OF BERNALILLO
ENVIRONMENTAL HEALTH AND
PUBLIC WORKS DEPARTMENTS



NORTH VALLEY AREAS B AND F
VACUUM STATION

STRUCTURAL DETAILS

PROJECT NO.
96034


SHEET 5B OF 19

AS-BUILT INFORMATION		BENCH MARKS		SURVEY INFORMATION		ENGINEER'S SEAL		REVISIONS		DESIGNED BY		DRAWN BY		CHECKED BY	
CONTRACTOR	TRAD BUILDERS OF NM	DATE	11/98	NO.	BY	NO.	DATE	NO.	DATE	NO.	DATE	NO.	DATE	NO.	DATE
STAGED BY	TRAD	DATE	3/00												
ACCEPTANCE BY	WILSON & Co.	DATE	9/00												
REVISIONS	WILSON & Co.	DATE	9/00												
CORRECTED BY	WILSON & Co.	DATE	9/00												
RECORDED BY	MICRO-FILM INFORMATION	DATE													




WILSON
& COMPANY


X:\PUBLIC\PROJECTS\96034\DRAWINGS\VACSTA\STRUCT\6034VS-SHT5B.DWG

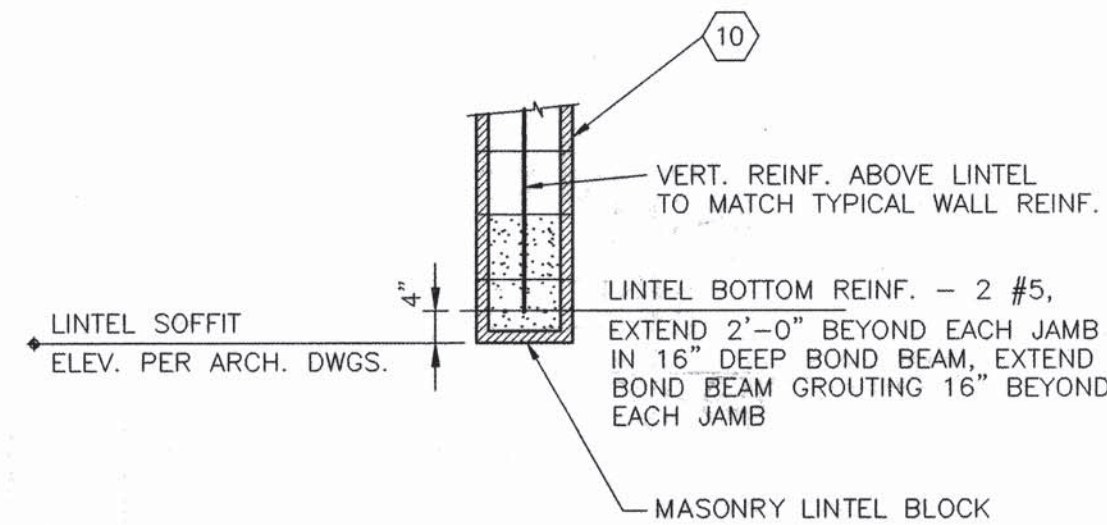


D1
6/6 SCALE: 1/2" = 1'-0"

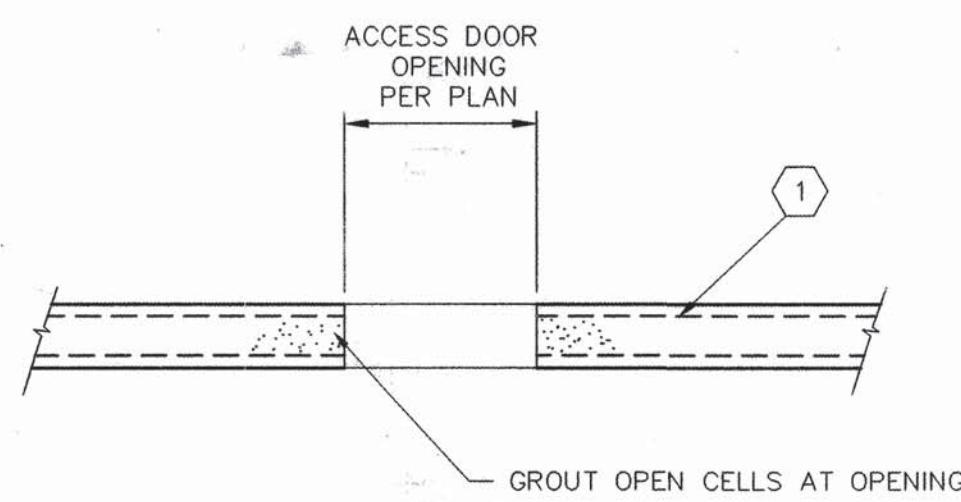


D2
6/6 SCALE: 1/2" = 1'-0"

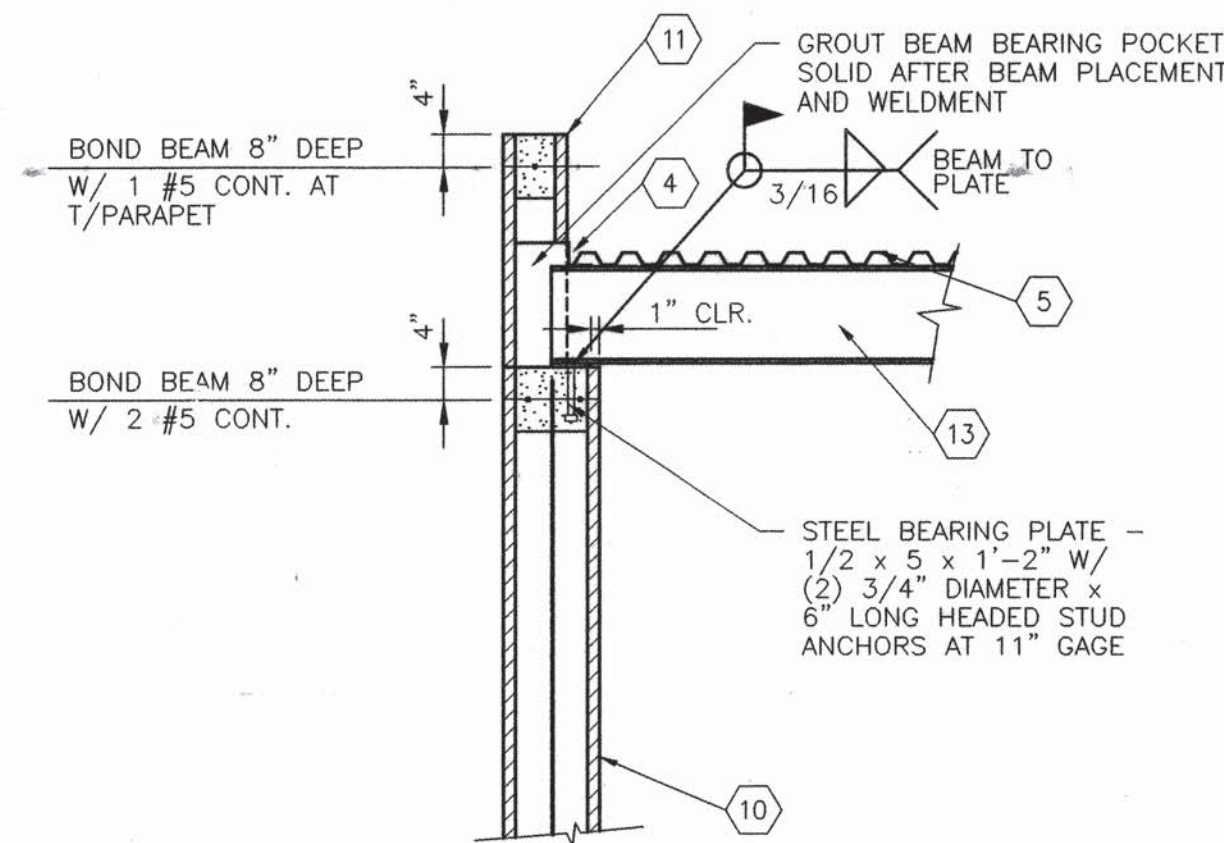


D3
6/6 SCALE: 1/2" = 1'-0"

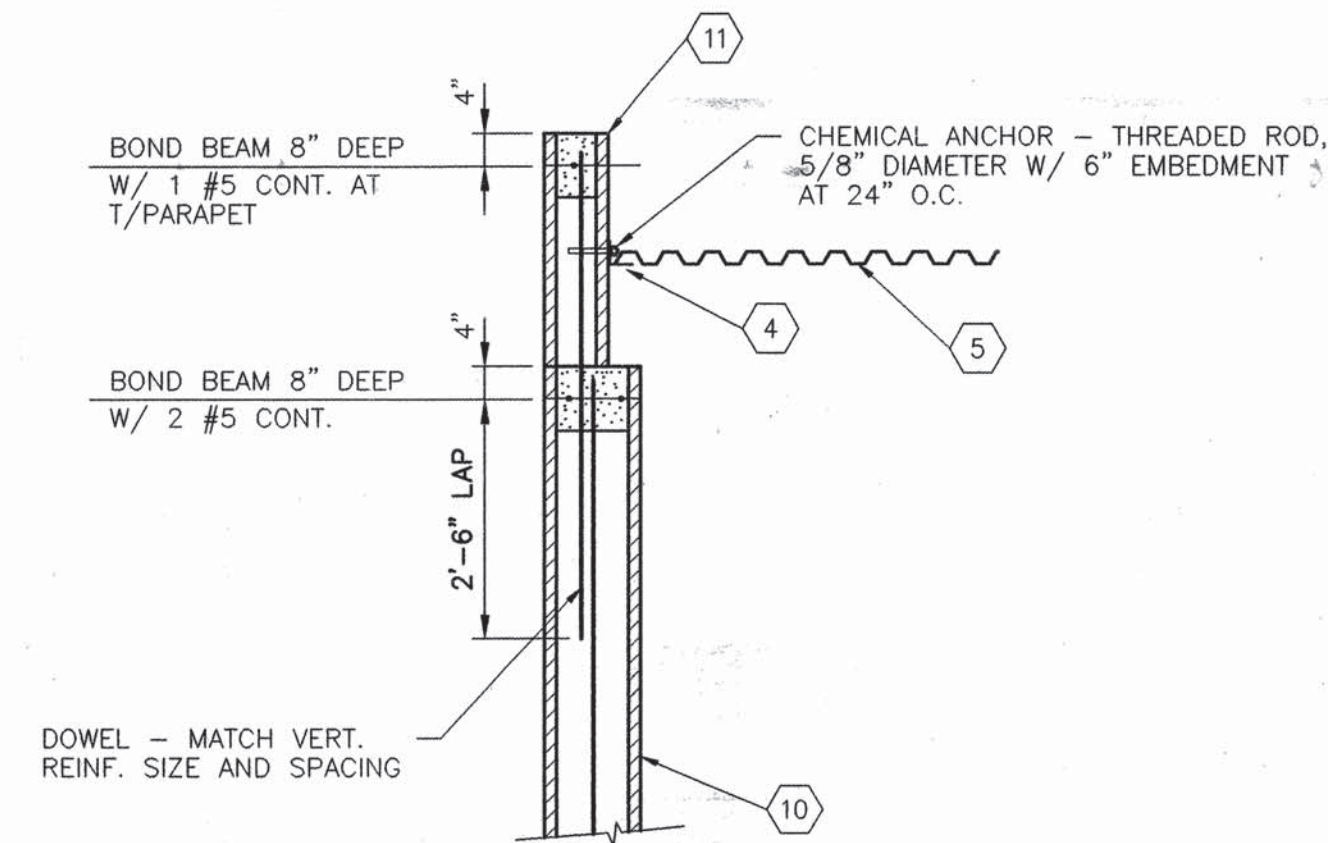


D4
6/6 SCALE: 1/2" = 1'-0"

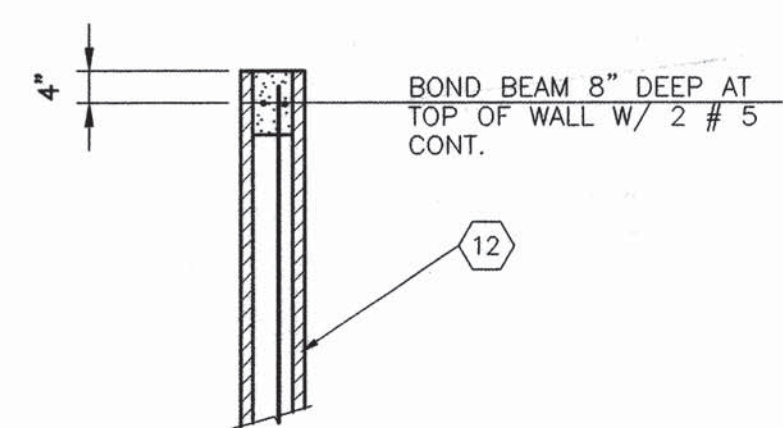


C1
6/6 SCALE: 1/2" = 1'-0"

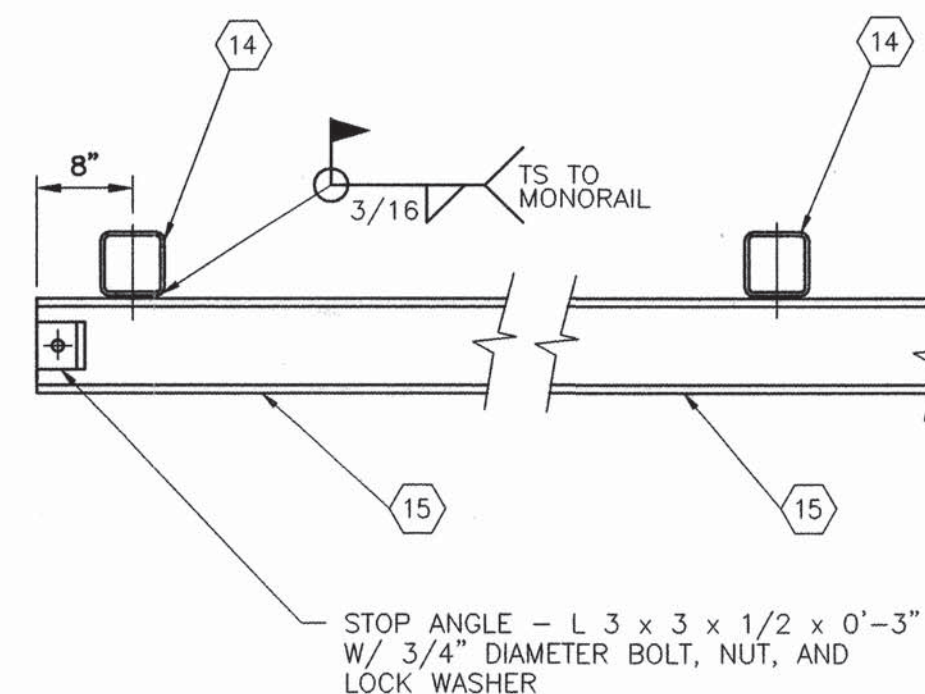


C2
6/6 SCALE: 1" = 1'-0"

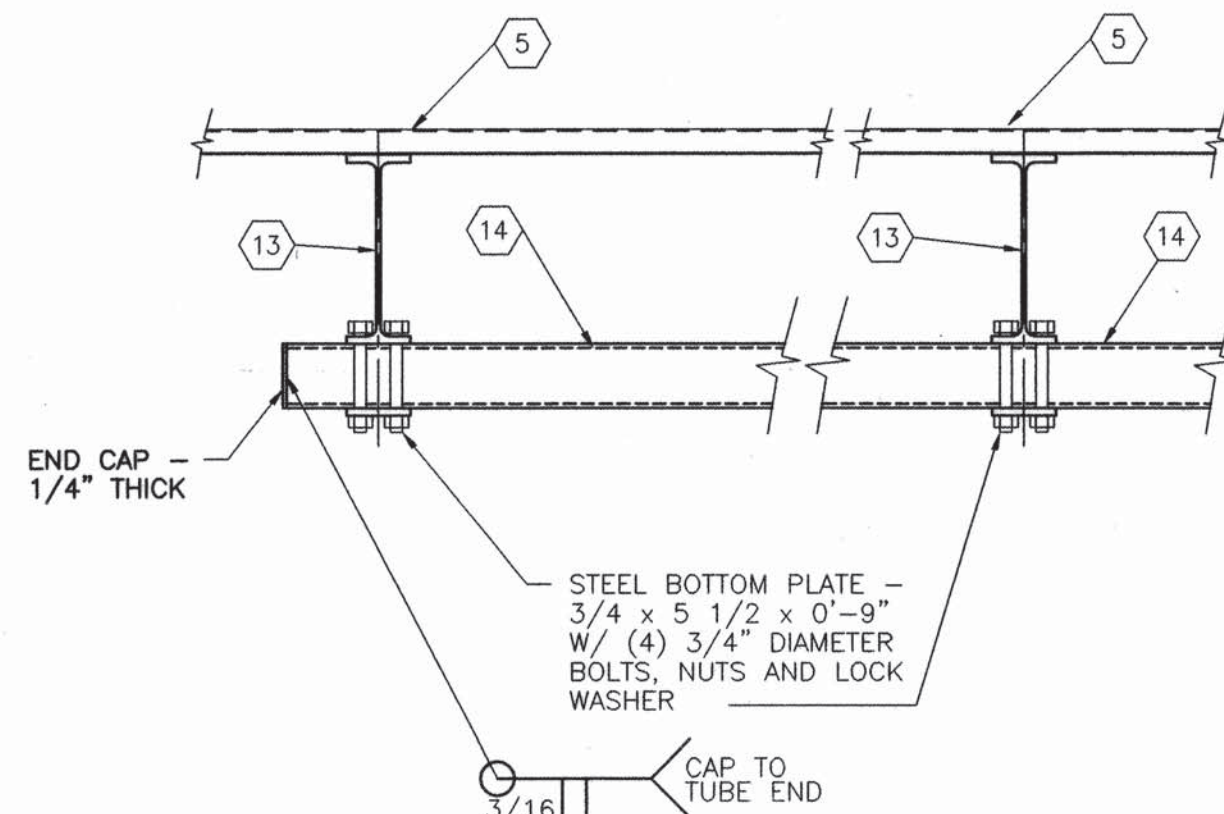


C3
6/6 SCALE: 1" = 1'-0"

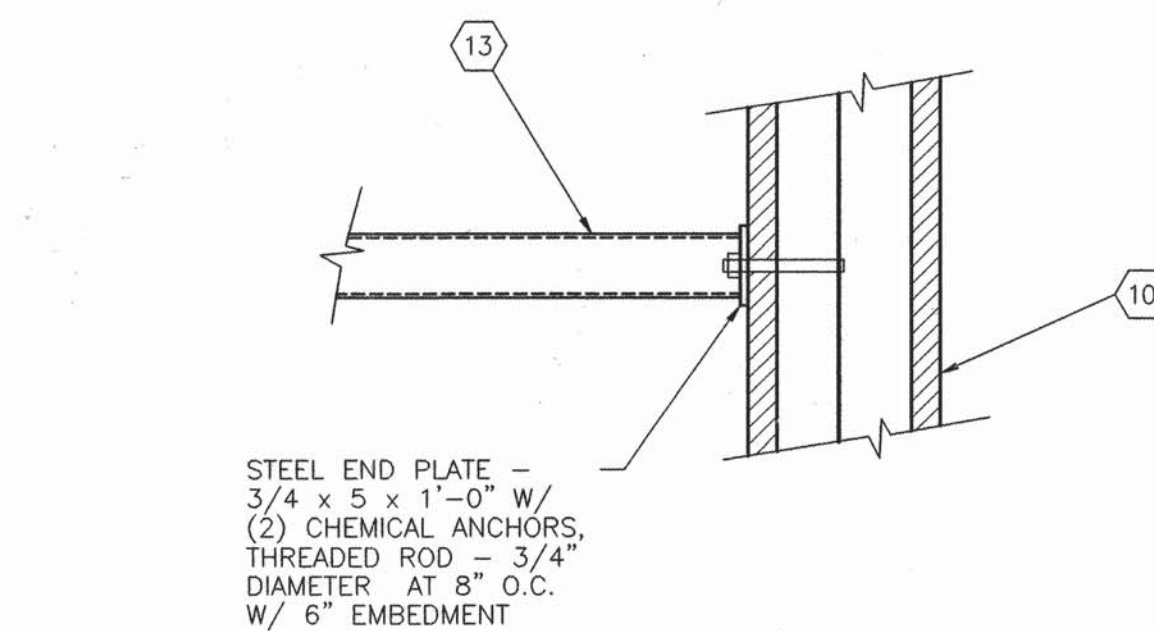


C4
6/6 SCALE: 1" = 1'-0"

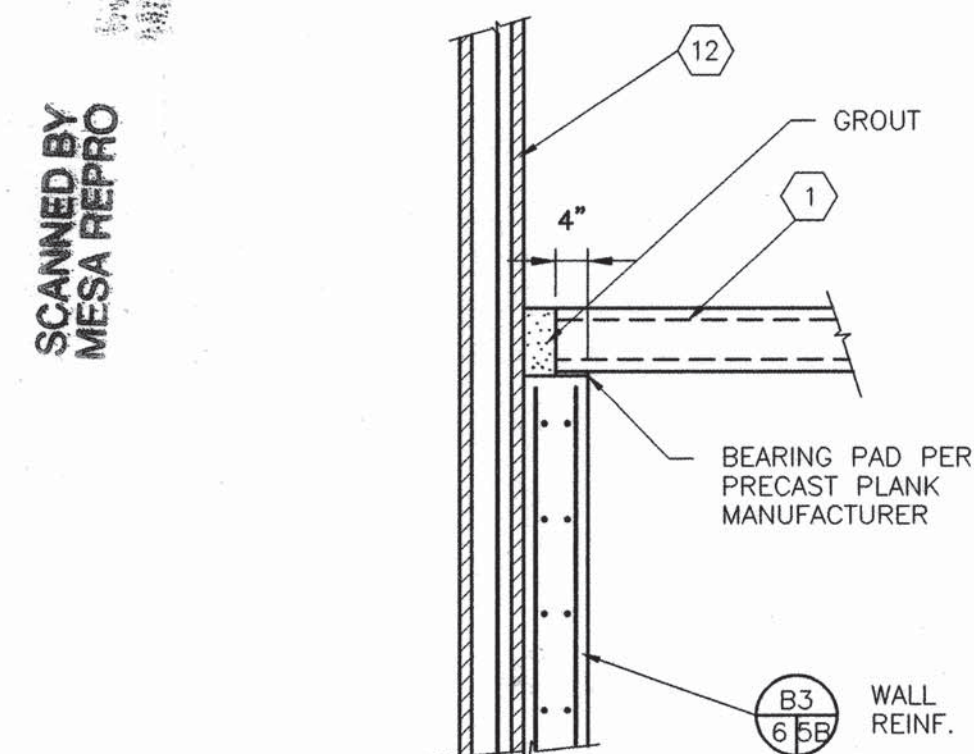


B1
6/6 SCALE: 1/2" = 1'-0"

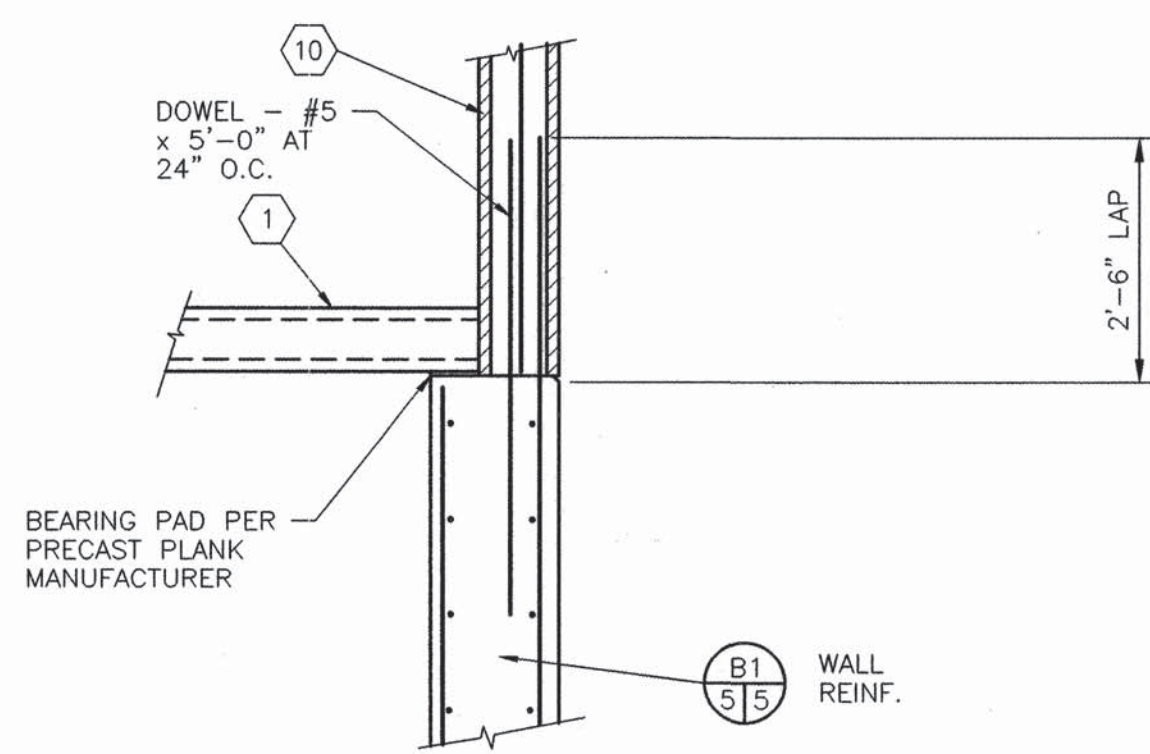


B2
6/6 SCALE: 1/2" = 1'-0"

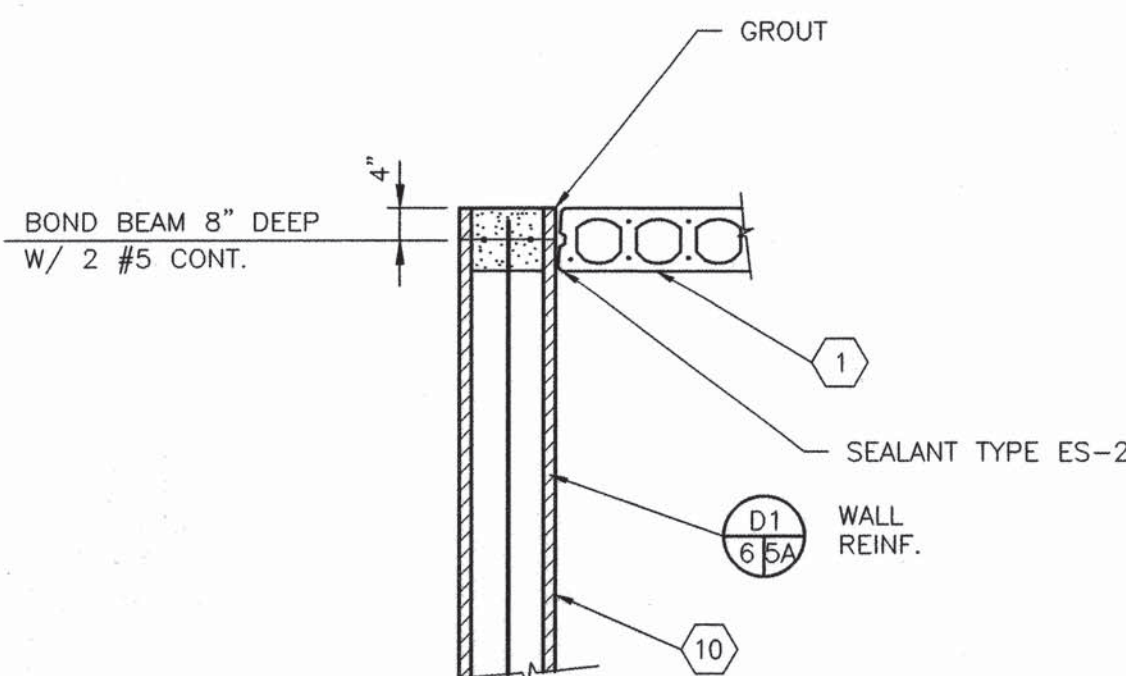

A1
6/6 SCALE: 1/2" = 1'-0"

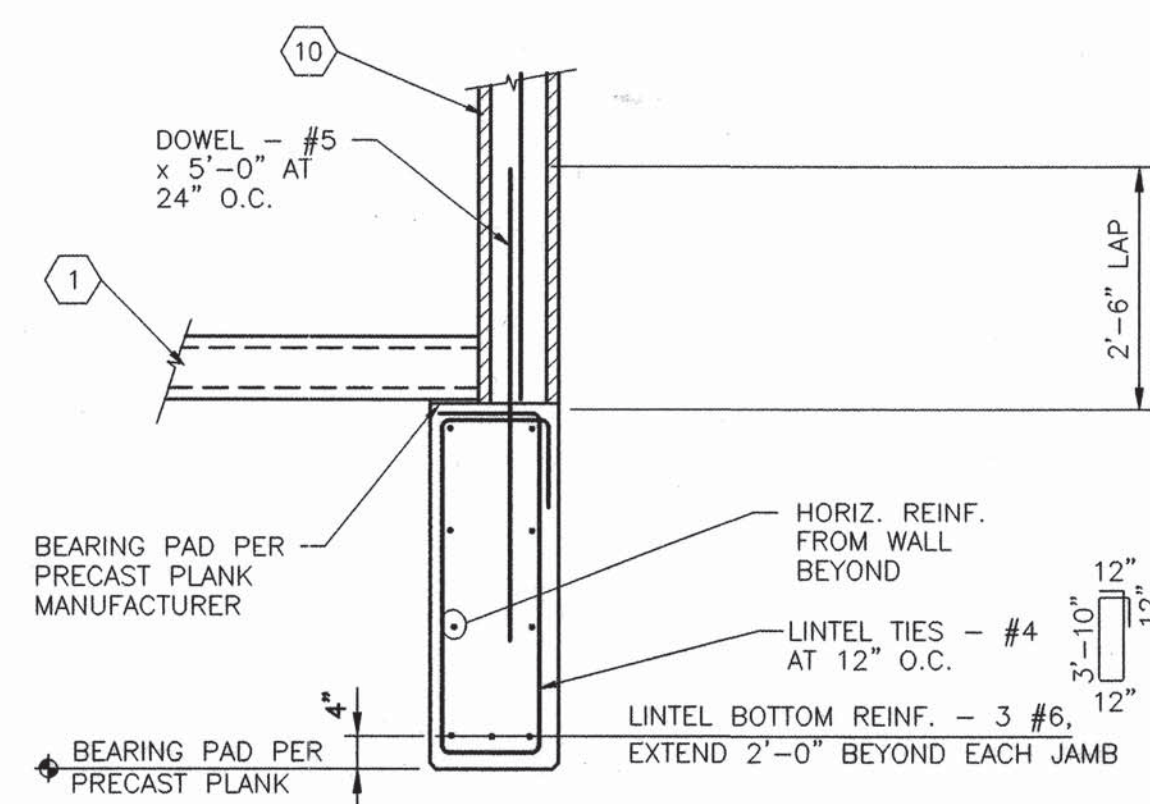

A2
6/6 SCALE: 1/2" = 1'-0"

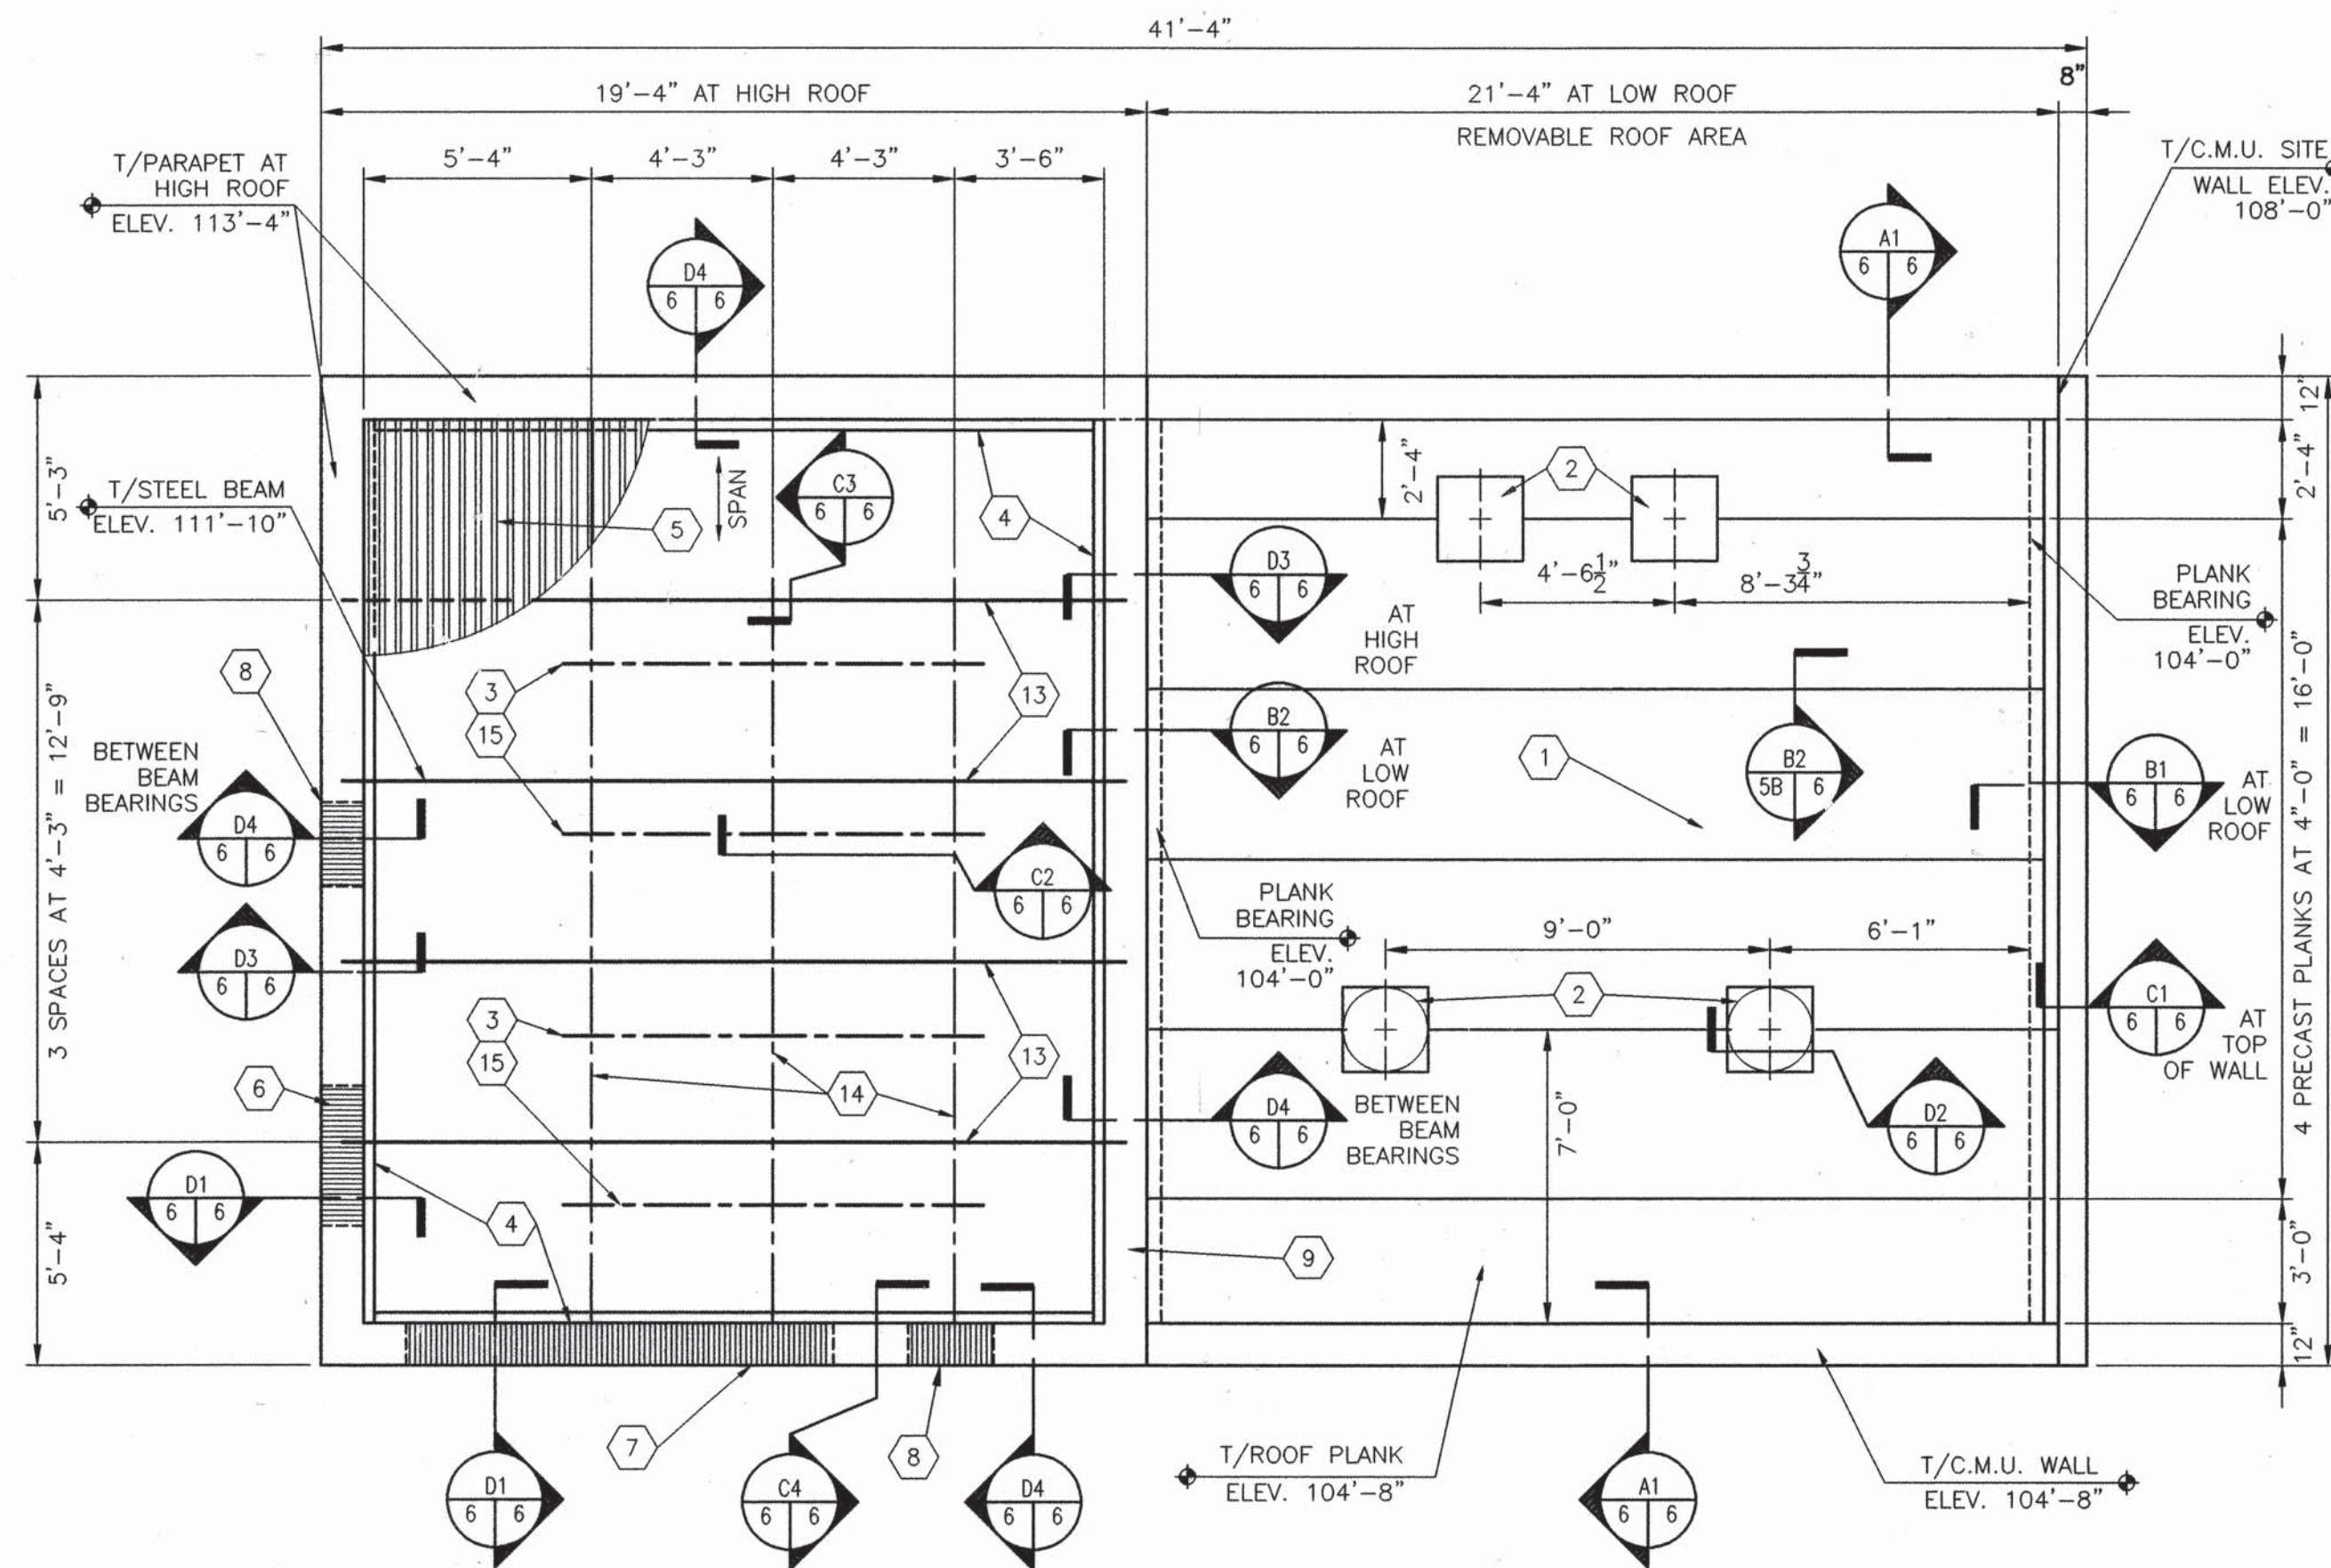

ROOF FRAMING PLAN AT LOW AND HIGH ROOFS
SCALE: 1/4" = 1'-0"

GENERAL SHEET NOTES:


- A) REFERENCE FINISH FLOOR ELEVATION = 100'-0" AND REFERENCES DATUM ELEVATION SHOWN ON SHEET 3
- B) ANCHORAGE OF DUCT WORK AND PIPING TO PRECAST PLANKS SHALL BE PER DETAIL A2 ON SHEET 5B
- C) SEE ARCHITECTURAL ROOF PLAN FOR SCUPPER LOCATIONS AND DETAILS AT SCUPPERS

SHEET KEYED NOTES : (X)

- 1) PRECAST PLANK - 8" THICK
- 2) CUTOUTS AT ACCESS DOORS - 2'-0" x 2'-0" CENTERED ON PLANK EDGE AS SHOWN
- 3) CENTERLINE MONORAIL BEAMS OVER PUMPS, VERIFY LOCATION W/ EQUIPMENT DRAWINGS
- 4) LEDGER ANGLE - L 3 x 3 x 5/16 x CONT.
- 5) ROOF DECK - SPAN AS INDICATED ON PLAN
- 6) CONCRETE MASONRY LINTEL BELOW, 12" WIDE AT MANDOR
- 7) CONCRETE MASONRY LINTEL BELOW, 12" WIDE AT OVERHEAD DOOR
- 8) CONCRETE MASONRY LINTEL BELOW, 12" WIDE AT MECHANICAL PENETRATION, SEE ARCHITECTURAL DRAWINGS FOR LOCATION
- 9) HORIZ. BOND BEAMS THIS WALL LINE PER HORIZONTAL BOND BEAM SECTION C2/5B
- 10) CONCRETE MASONRY UNIT WALL - 12" WIDE
- 11) CONCRETE MASONRY UNIT PARAPET - 8" WIDE
- 12) CONCRETE MASONRY UNIT SITE WALL - 8" WIDE W/ VERT. REINF. - 1 # 5 AT 24" O.C.
- 13) STEEL ROOF BEAM - W 12 x 14
- 14) STEEL MONORAIL INTERMEDIATE SUPPORT BEAM - TS 4 x 4 x 1/4
- 15) STEEL MONORAIL BEAM - S6 x 12.5

AS-BUILT INFORMATION		BENCH MARKS	
CONTRACTOR	TRIAID BUILDERS OF NA	DATE	11/99
WORKER	WILSON & Co.	DATE	11/99
ACCEPTANCE BY	WILSON & Co.	DATE	11/99
REVISIONS	WILSON & Co.	DATE	11/99
RECORDING	WILSON & Co.	DATE	11/99

SURVEY INFORMATION		FIELD NOTES	
NO.	DATE	BY	DATE

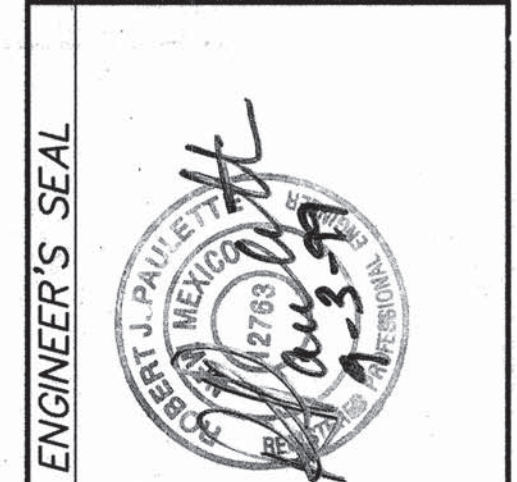

REVISIONS		REMARKS	
NO.	DATE	BY	DATE
1	11/20/98	JDC	11/20/98

CITY PROJECT #567292

COUNTY OF BERNALILLO
ENVIRONMENTAL HEALTH AND
PUBLIC WORKS DEPARTMENTS



NORTH VALLEY AREAS B AND F
VACUUM STATION







STRUCTURAL - ROOF FRAMING
PLANS AT LOW AND HIGH ROOFS

PROJECT NO. 96034 SHEET 6 OF 19

WILSON
& COMPANY

X:\PUBLIC\PROJECTS\96034\DRAWINGS\VACSTA\STRUCT\6034VS-SHT69-1-99.DWG

SCANNED BY
MESA REPRO

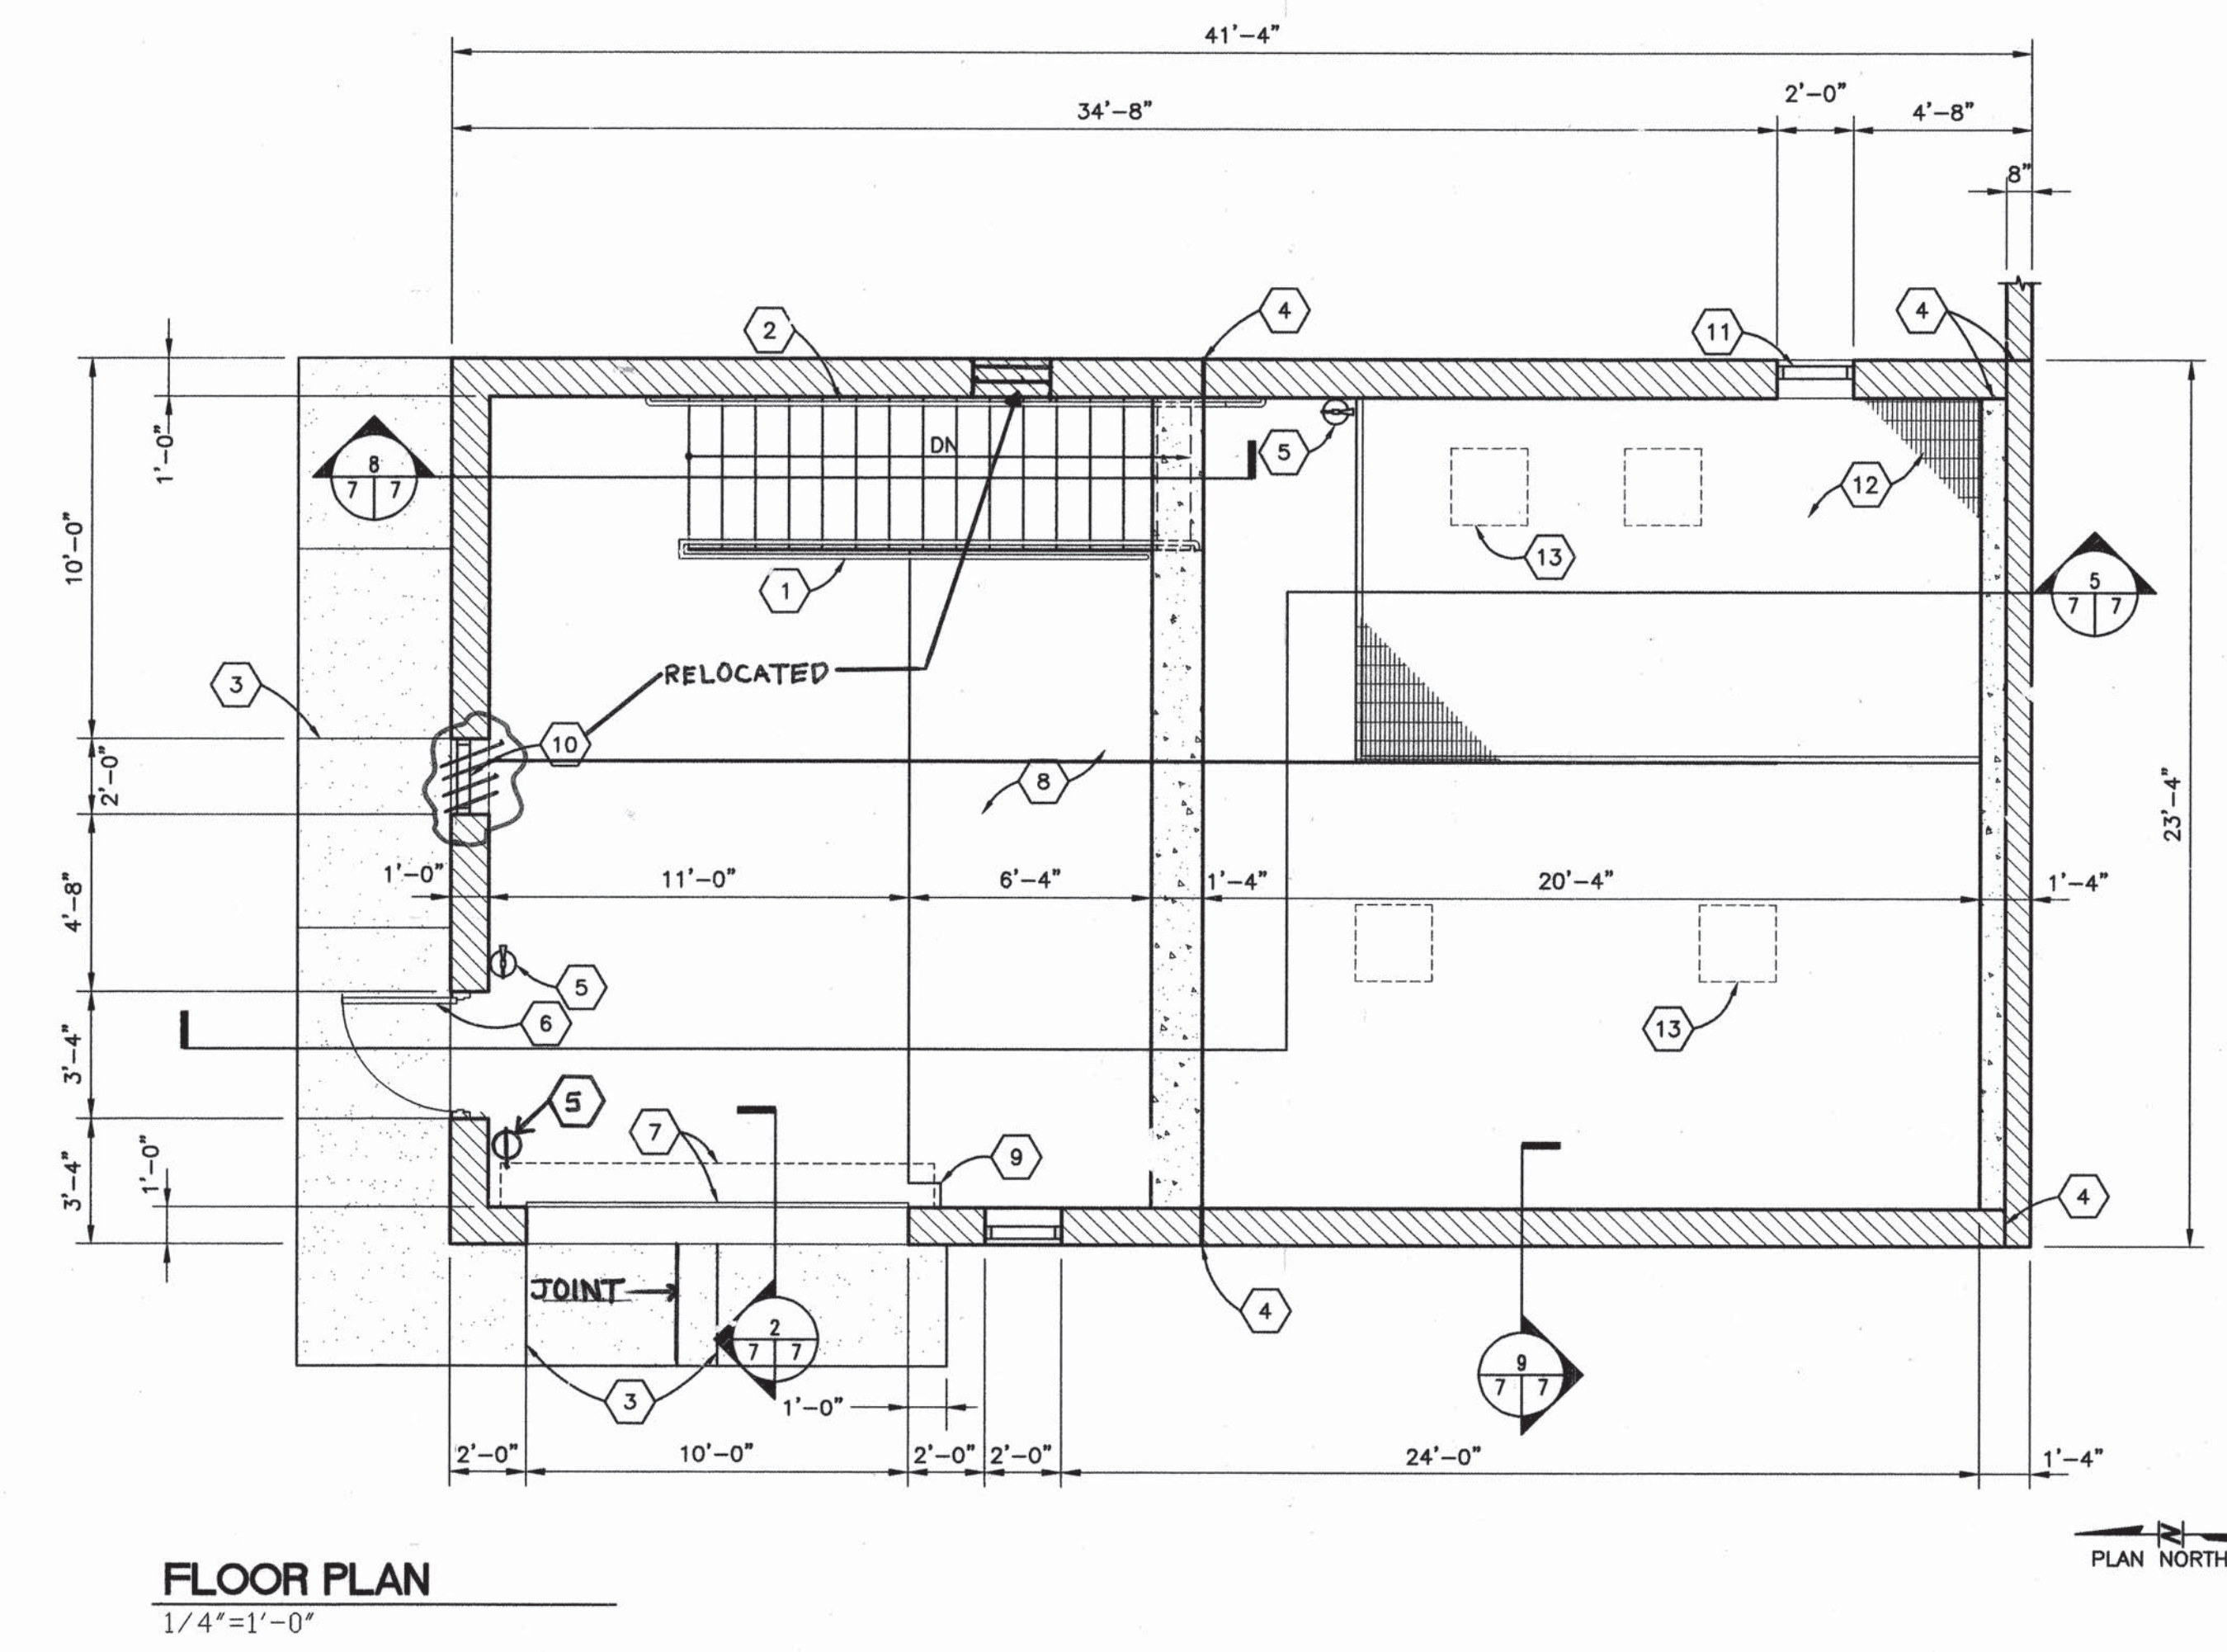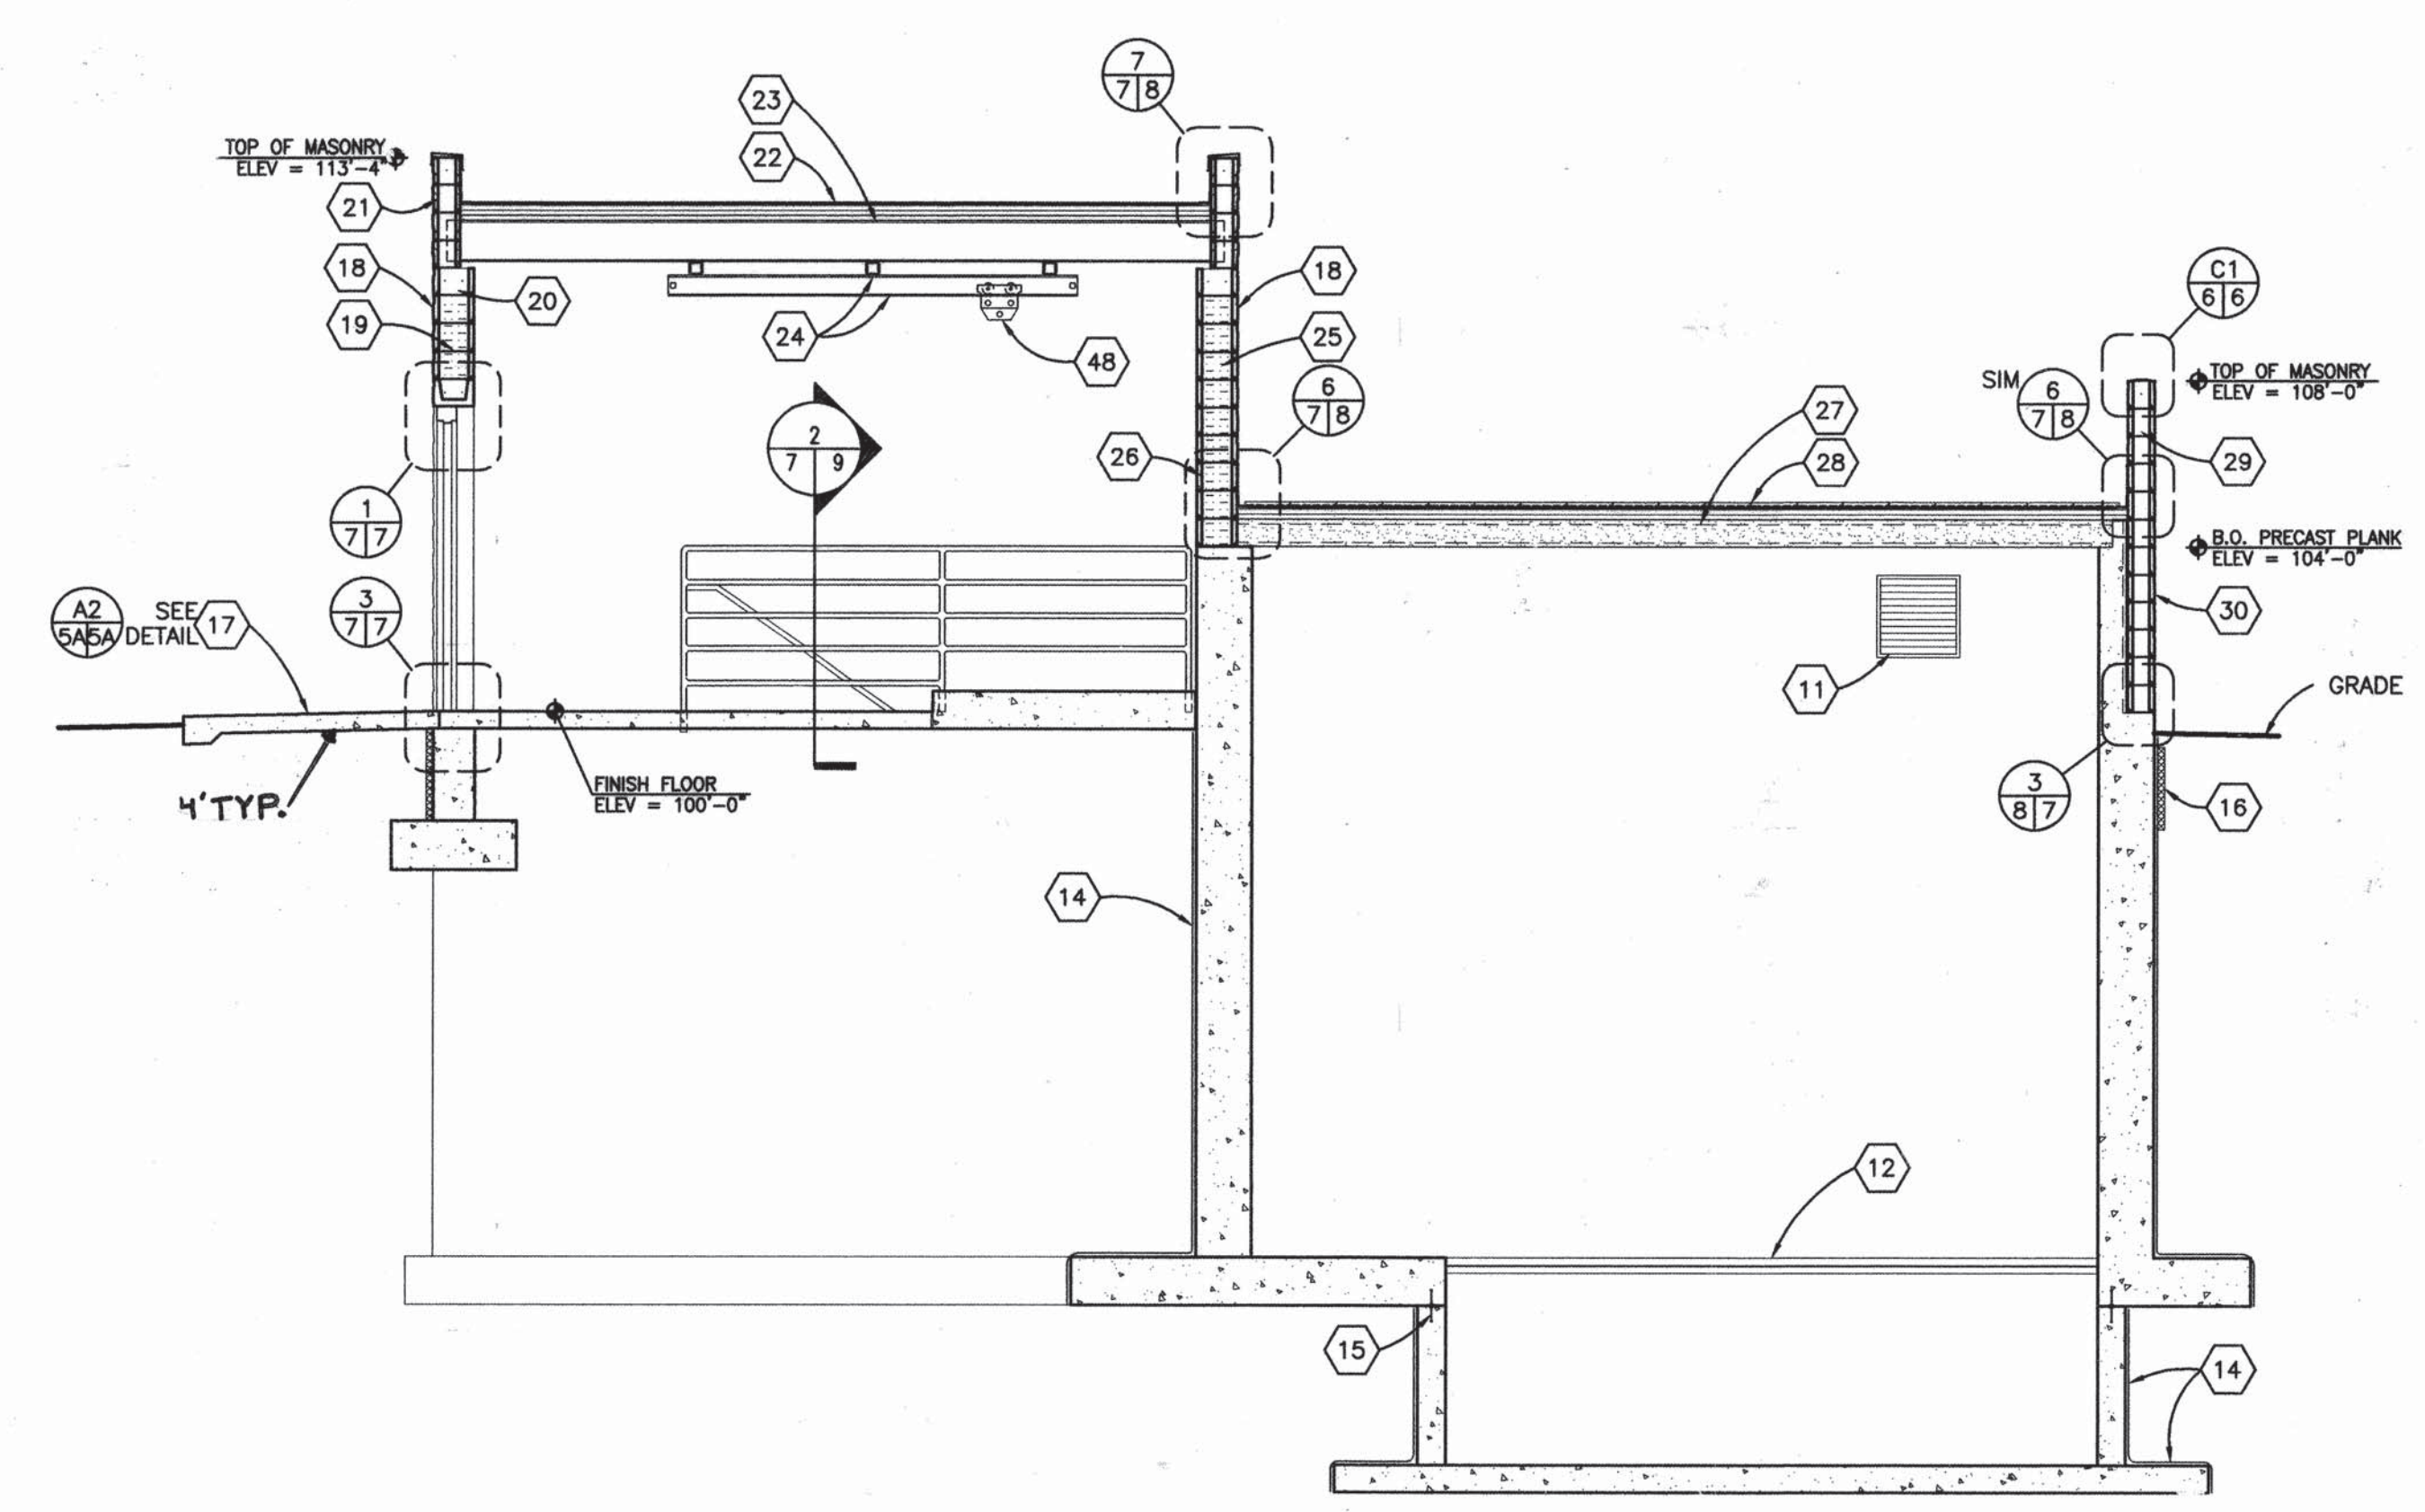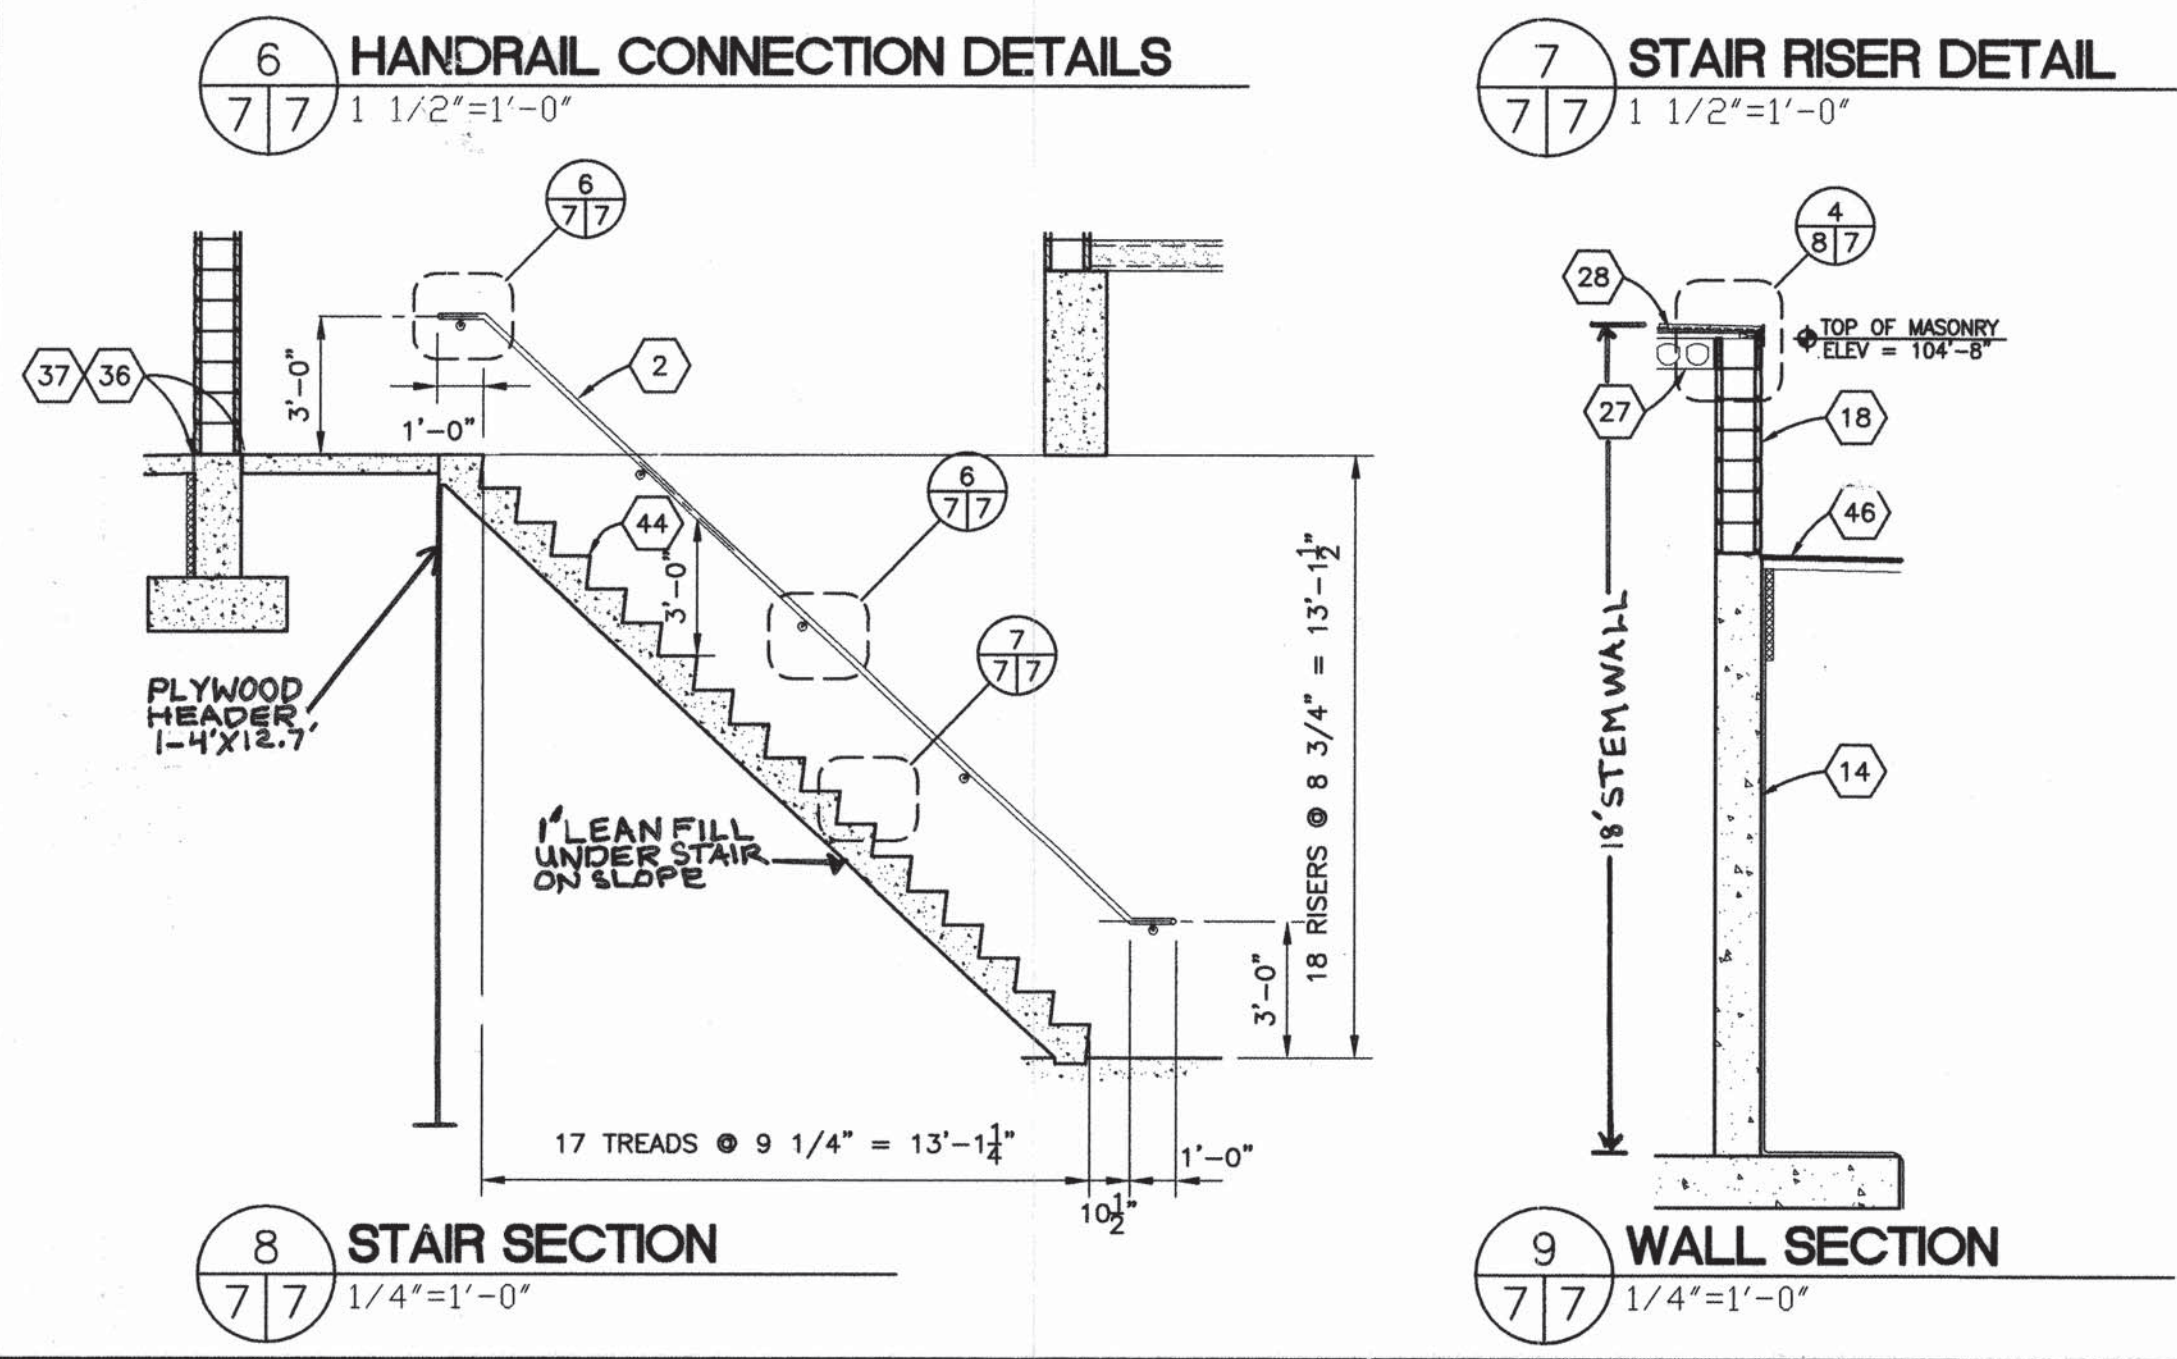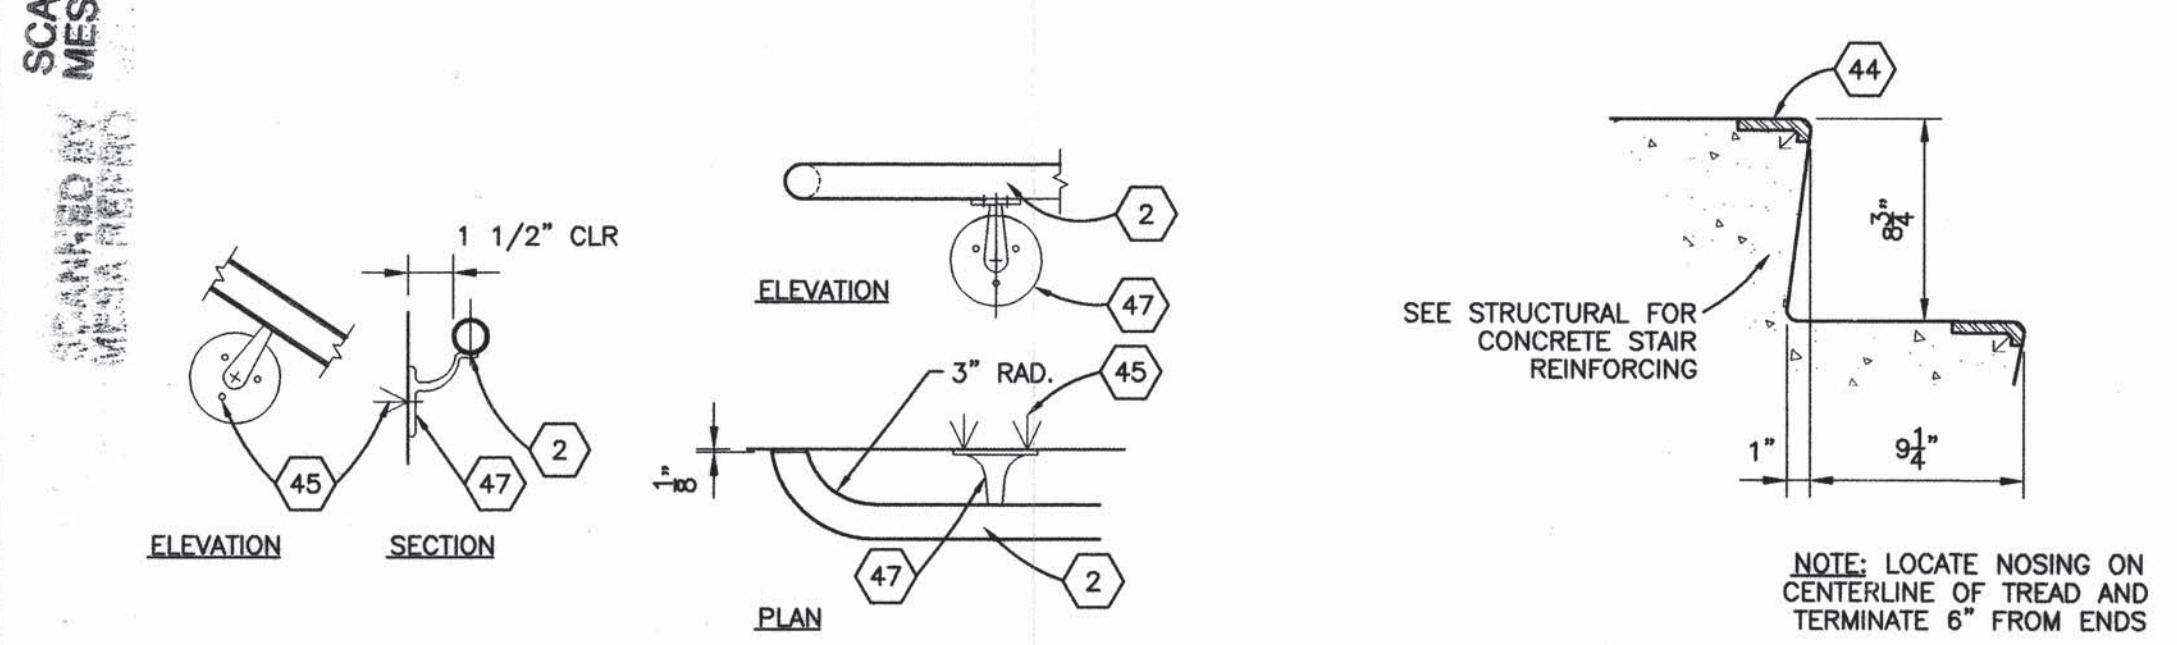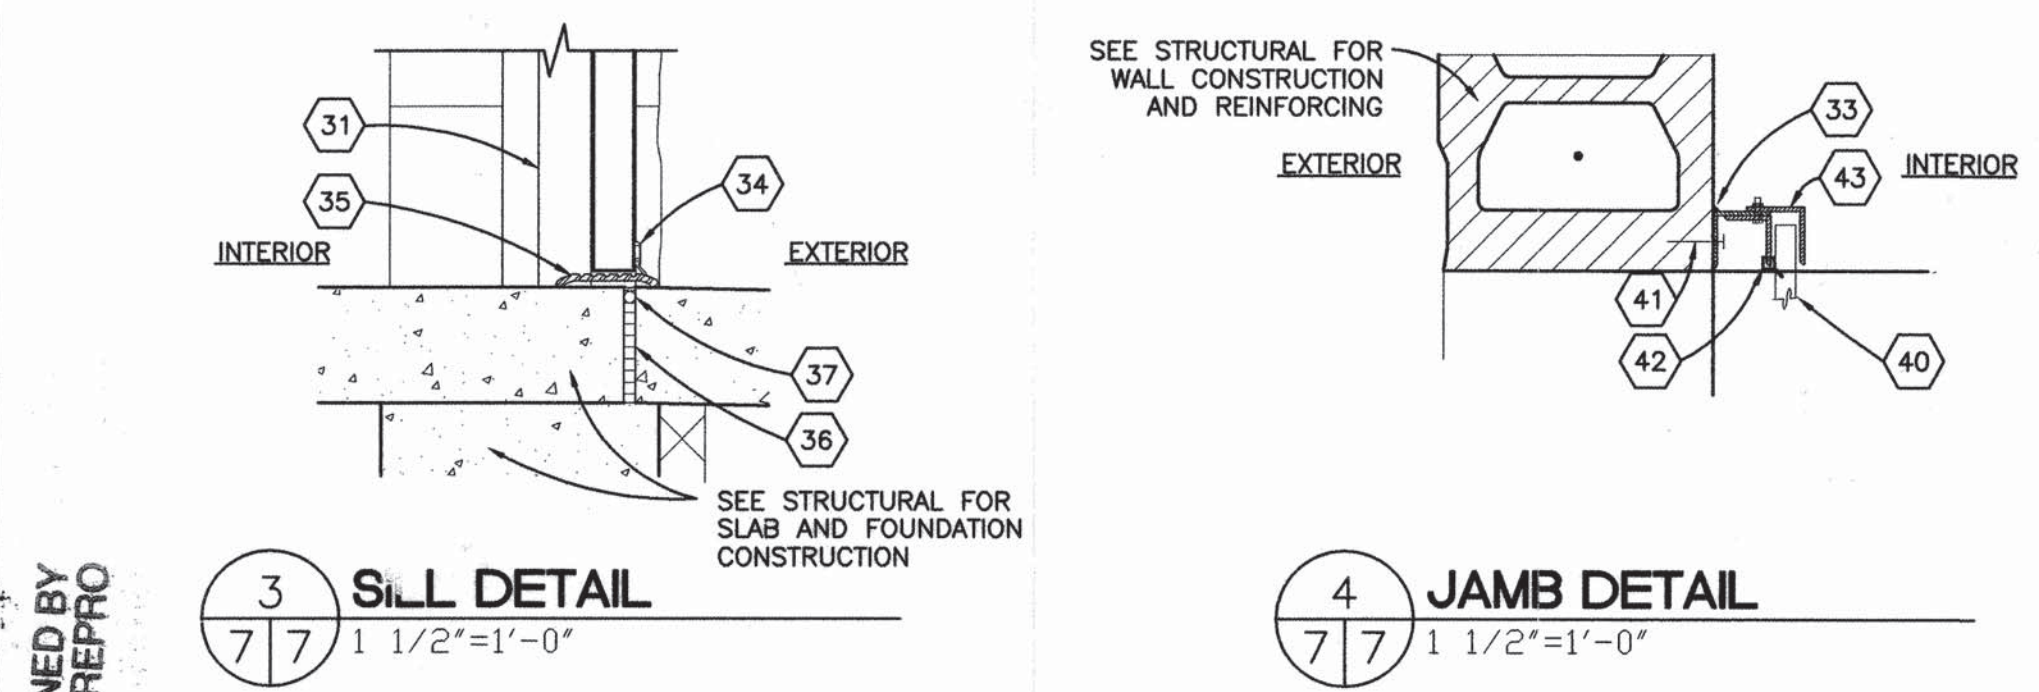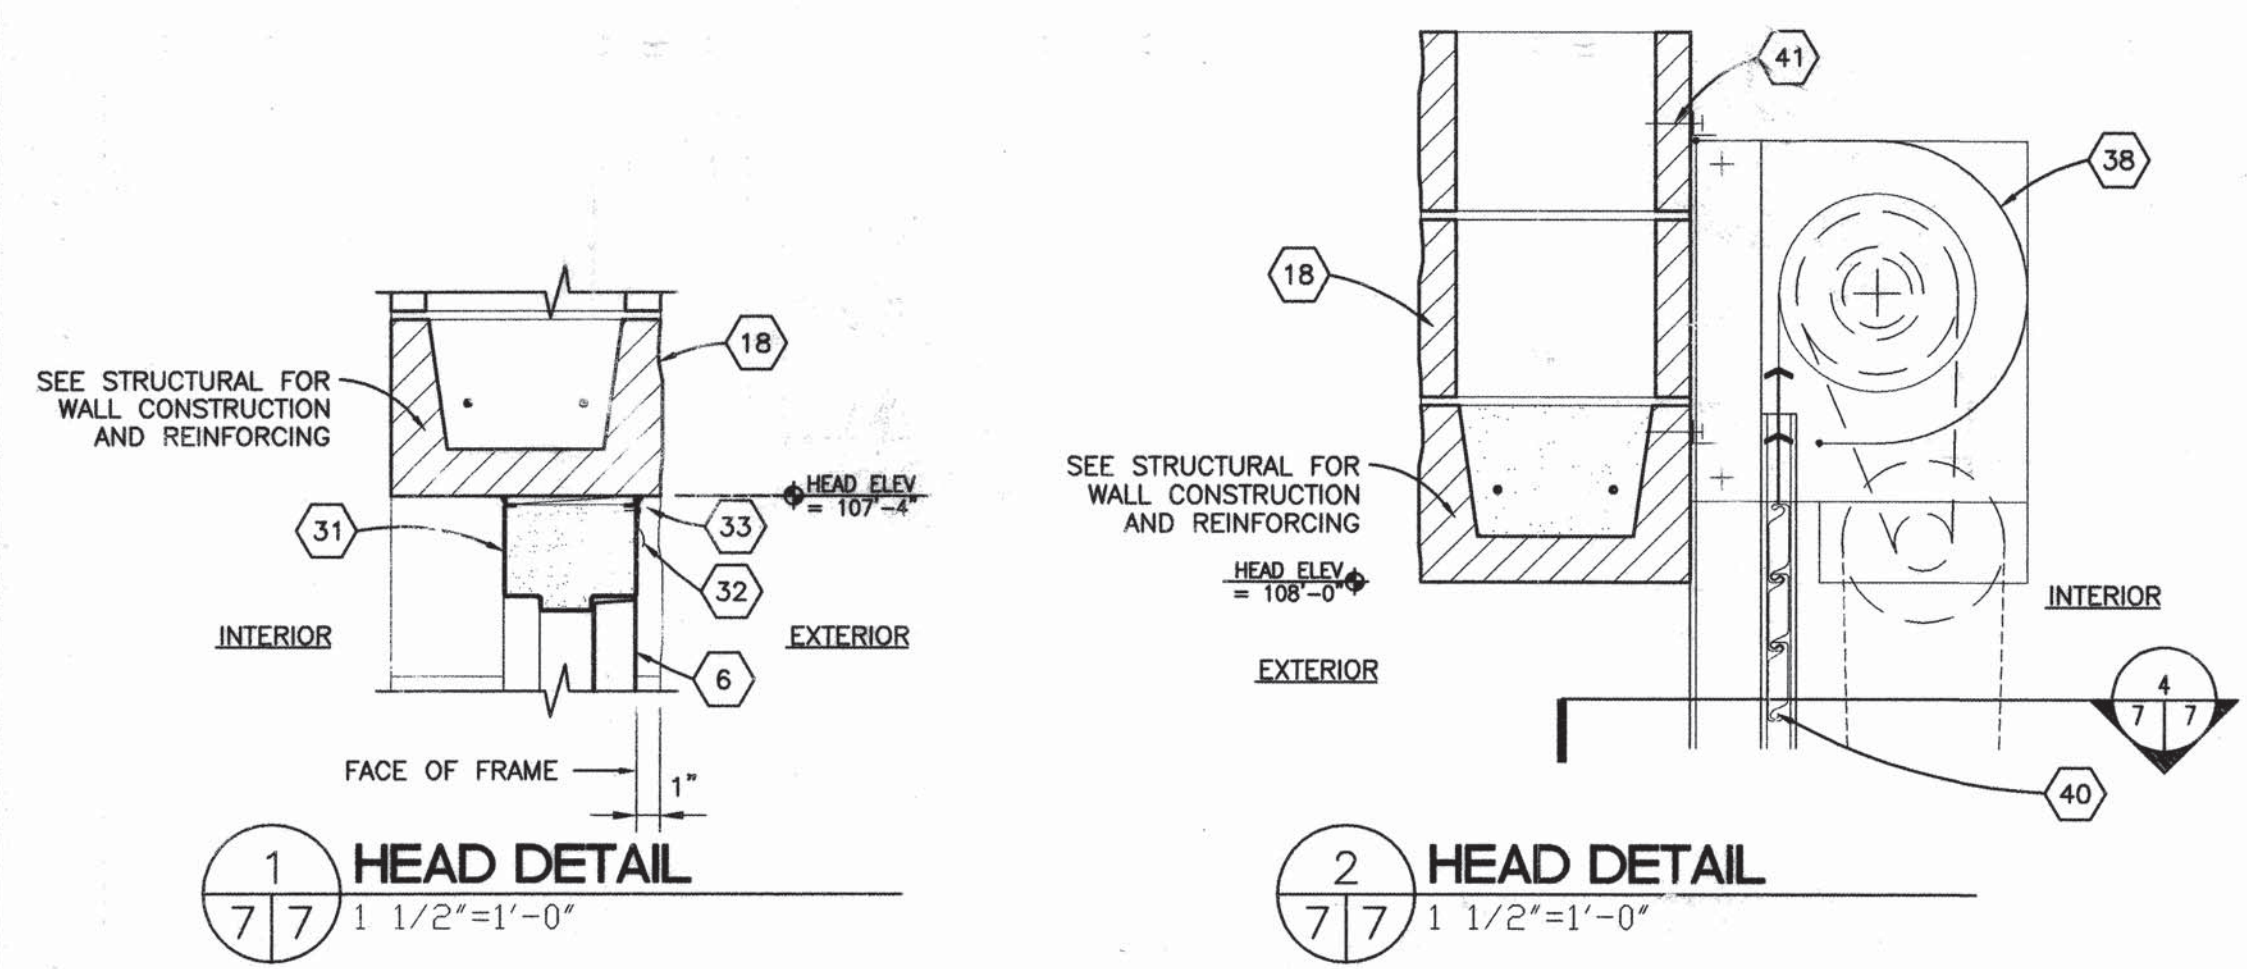

GENERAL SHEET NOTES:

A) REFERENCE FINISH FLOOR ELEVATION = 100'-0" AND REFERENCES DATUM ELEVATION, SEE CIVIL DRAWINGS FOR DATUM.

SHEET KEYED NOTES : (X)

- 1. STEEL RAILING SYSTEM
- 2. RAILING
- 3. SAW CUT ~~TOOL JOINT~~
- 4. MASONRY CONTROL JOINT
- 5. SURFACE MOUNTED FIRE EXTINGUISHER
- 6. STEEL DOOR - USE HARDWARE SET HW-1
- 7. EXTERIOR OVERHEAD COILING DOOR
- 8. RAISED EQUIPMENT SLAB- SEE STRUCTURAL
- 9. PROVIDE NOTCH IN RAISED SLAB FOR EXTERIOR COILING DOOR- SEE STRUCTURAL
- 10. EXHAUST FAN- SEE MECHANICAL
- 11. AIR INTAKE COVER- SEE MECHANICAL
- 12. GRATING- SEE STRUCTURAL
- 13. DASHED LINES INDICATE ROOF HATCH ABOVE
- 14. SHEET WATERPROOFING
- 15. WATERSTOP- SEE STRUCTURAL
- 16. PERIMETER INSULATION (2" THICK)
- 17. CONCRETE PAVING
- 18. ~~TYPE 2~~ CONCRETE MASONRY UNITS (12" DEEP)
- 19. HORIZONTAL JOINT REINFORCING (16" OC)
- 20. BOND BEAM
- 21. ~~TYPE 2~~ CONCRETE MASONRY UNITS (8" DEEP)
- 22. ELASTOMERIC MEMBRANE ROOFING OVER COVER BOARD OVER TAPERED BOARD INSULATION
- 23. STEEL BEAM- SEE STRUCTURAL
- 24. STEEL FRAMING FOR MONORAIL- SEE STRUCTURAL
- 25. LOOSE FILL INSULATION
- 26. ~~TYPE 2~~ CONCRETE MASONRY UNITS
- 27. PRECAST PLANK
- 28. PAVERS OVER ELASTOMERIC MEMBRANE ROOFING OVER COVER BOARD OVER TAPERED BOARD INSULATION
- 29. ~~TYPE 2~~ CONCRETE MASONRY UNITS (2 SIDES)
- 30. ~~TYPE 2~~ CONCRETE MASONRY UNITS (1 SIDE)
- 31. STEEL FRAME- GROUT SOLID
- 32. DRIP WEATHERSTRIP
- 33. SEALANT TYPE ES-1
- 34. SWEEP
- 35. THRESHOLD
- 36. JOINT FILLER
- 37. BACKER ROD AND SEALANT TYPE ES-2
- 38. HOOD ENCLOSURE
- 39. NOT USED
- 40. EXTERIOR OVERHEAD COILING DOOR
- 41. ANCHOR
- 42. WEATHERSTRIPPING
- 43. GUIDES
- 44. NOSING
- 45. EXPANSION ANCHOR (3/8" X 4")
- 46. ~~GRANULAR~~ CONCRETE PAVING
- 47. WALL BRACKET
- 48. HOIST TROLLEY COFFING ET-20-A OR EQUAL (TYP. 4)
- 49. 1" T MANUAL CHAIN HOIST (TYP.1)
- COFFING MODEL CB-1 OR EQUAL

CITY PROJECT #567292

COUNTY OF BERNALILLO
ENVIRONMENTAL HEALTH AND
PUBLIC WORKS DEPARTMENTS

**BERNALILLO COUNTY
STATE OF NEW MEXICO**

NORTH VALLEY AREAS B AND F
VACUUM STATION

ARCHITECTURAL-
FLOOR PLAN AND DETAILS

PROJECT NO. 96034 SHEET 7 OF 19

AS-BUILT INFORMATION

CONTRACTOR: TRIAD BUILDERS OF NM

WORK: VACUUM STATION

STANDARD: 1/94

DESIGNED BY: WILSON & COMPANY

DATE: 11/20/98

DESIGNED BY: WILSON & COMPANY

DATE: 11/20/98

RECORDED BY: JDC

DATE: 11/20/98

BENCH MARKS

SURVEY INFORMATION

FIELD NOTES

DATE

NO.

BY

REVISIONS

NO.

DATE

WILSON & COMPANY, ENGINEERS & ARCHITECTS

DESIGNED BY: HMK

DATE: 11/20/98

DRAWN BY: JDC

CHECKED BY: JDC

DATE: 11/20/98

ENGINEER'S SEAL

ROBERT J. PAULET

12763

11/20/98



SCUPPER DETAIL



 
3 SECTION
7 8 1 1/2" = 1' - 0"




6 SECTION
7 8 1 1/2" = 1' - 0"



7 SECTION
8 8 $1\ 1/2'' = 1' - 0''$



5 ROOF HATCH DETAIL
8 8 1 1/2" = 1'-0"

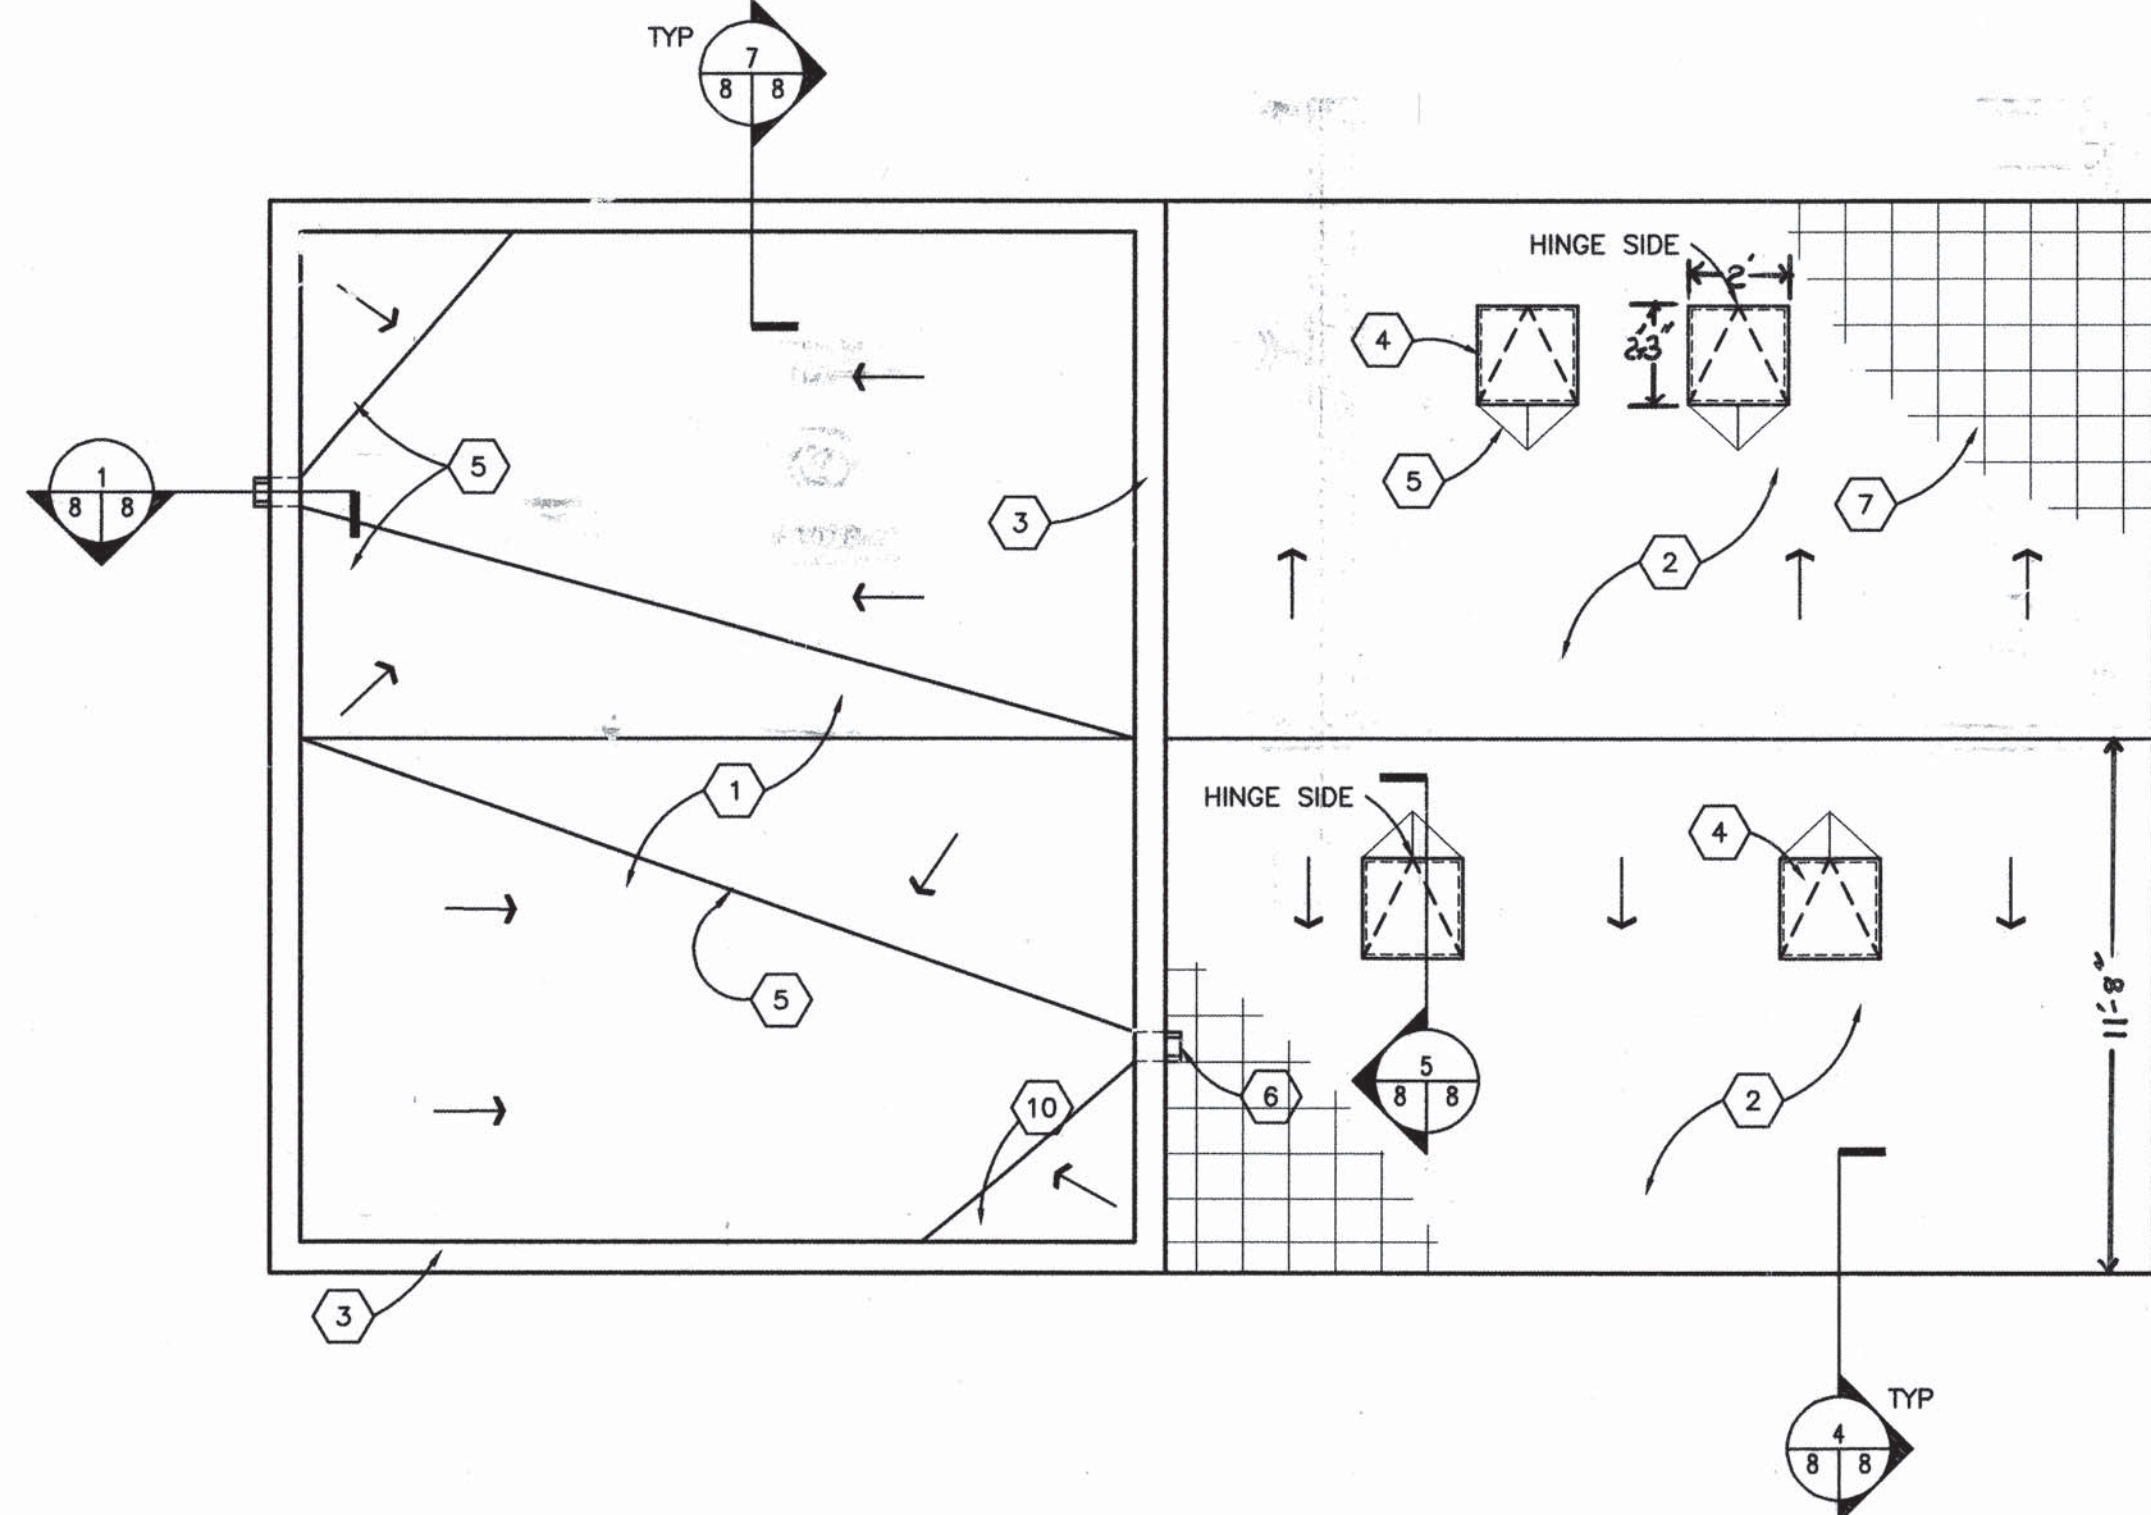

ROOF PLAN
1/4"=1'-0"

A) REFERENCE FINISH FLOOR ELEVATION = 100'-0" AND REFERENCES DATUM ELEVATION, SEE CIVIL DRAWINGS FOR DATUM.

B) SOLID GROUT ALL CMU CELLS WITH REINFORCING- SEE STRUCTURAL

SHEET KEYED NOTES :

1. ELASTOMERIC MEMBRANE ROOFING OVER COVER BOARD OVER TAPERED BOARD INSULATION
2. PAVERS OVER ELASTOMERIC MEMBRANE ROOFING OVER COVER BOARD OVER TAPERED BOARD INSULATION
3. COPING
4. ROOF HATCH
5. CRICKET
6. PRECAST CONCRETE SCUPPER
7. PAVERS
8. NOT USED
9. ELASTOMERIC MEMBRANE ROOFING COVER BOARD
10. TAPERED BOARD INSULATION
11. PRECAST PLANK
12. SEAM CAULK
14. ROOF PAVEMENT TERMINATION
15. FACIA
16. FACIA ANCHOR BAR
17. PRESSURE TREATED DIMENSION LUMBER (2x6)
18. ~~TYPE A~~ CONCRETE MASONRY UNITS (12" DEEP)
19. BACKER ROD AND SEALANT TYPE ES-1
20. CONCRETE MASONRY UNITS (8" DEEP)
21. FLEXIBLE FLASHING
22. TERMINATION BAR
23. ~~TYPE B~~ CONCRETE MASONRY UNITS
24. WALL TIES
25. ~~TYPE C~~ CONCRETE MASONRY UNITS (1 SIDE)
26. CAVITY DRAINAGE MATERIAL
27. SEALANT TYPE ES-1
28. SHEET WATERPROOFING
29. PERIMETER INSULATION (2" THICK)
30. FLASHING
31. HORIZONTAL JOINT REINFORCING (16"OC)

CITY PROJECT #567292

COUNTY OF BERNALILLO
ENVIRONMENTAL HEALTH AND
PUBLIC WORKS DEPARTMENTS




NORTH VALLEY AREAS B AND F VACUUM STATION
--

ARCHITECTURAL—
ROOF PLAN AND DETAILS


PROJECT NO. 96034	SHEET 8 OF 19
----------------------	---------------

**WILSON**
& COMPANY


X: \PUBLIC\PROJECTS\96034\DRAWINGS\VACSTA\ARCH\A6034VS07-9-1-99.DWG

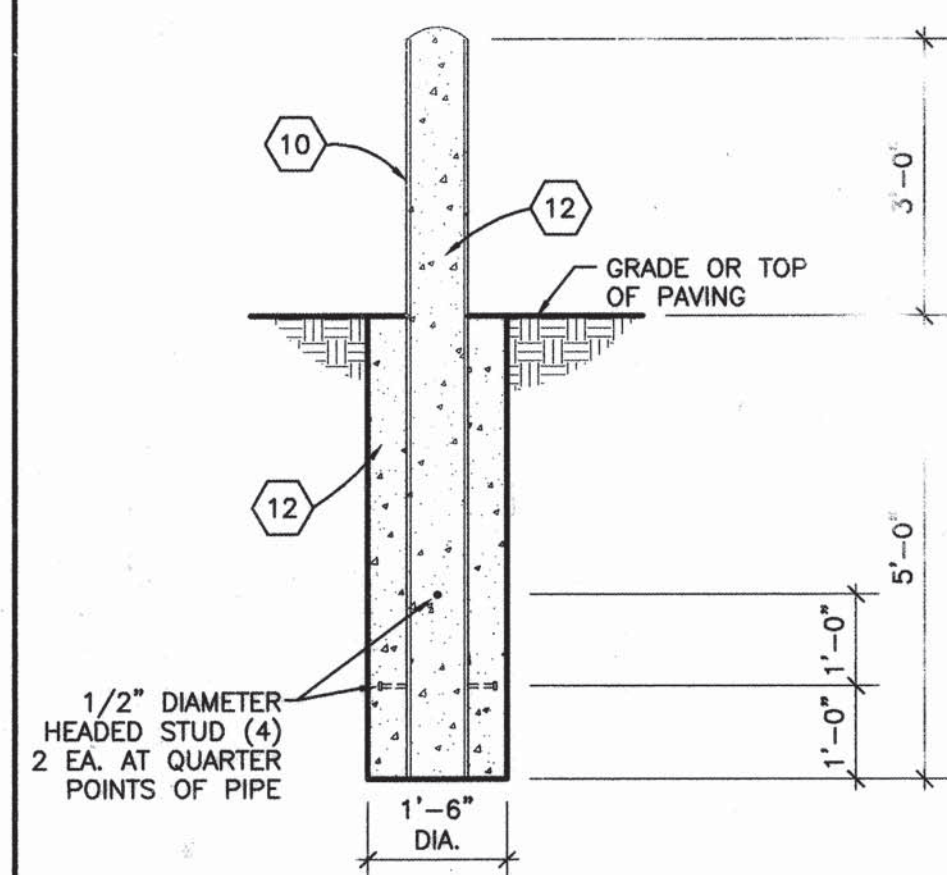


1 BOLLARD DETAIL
1/2"=1'-0"

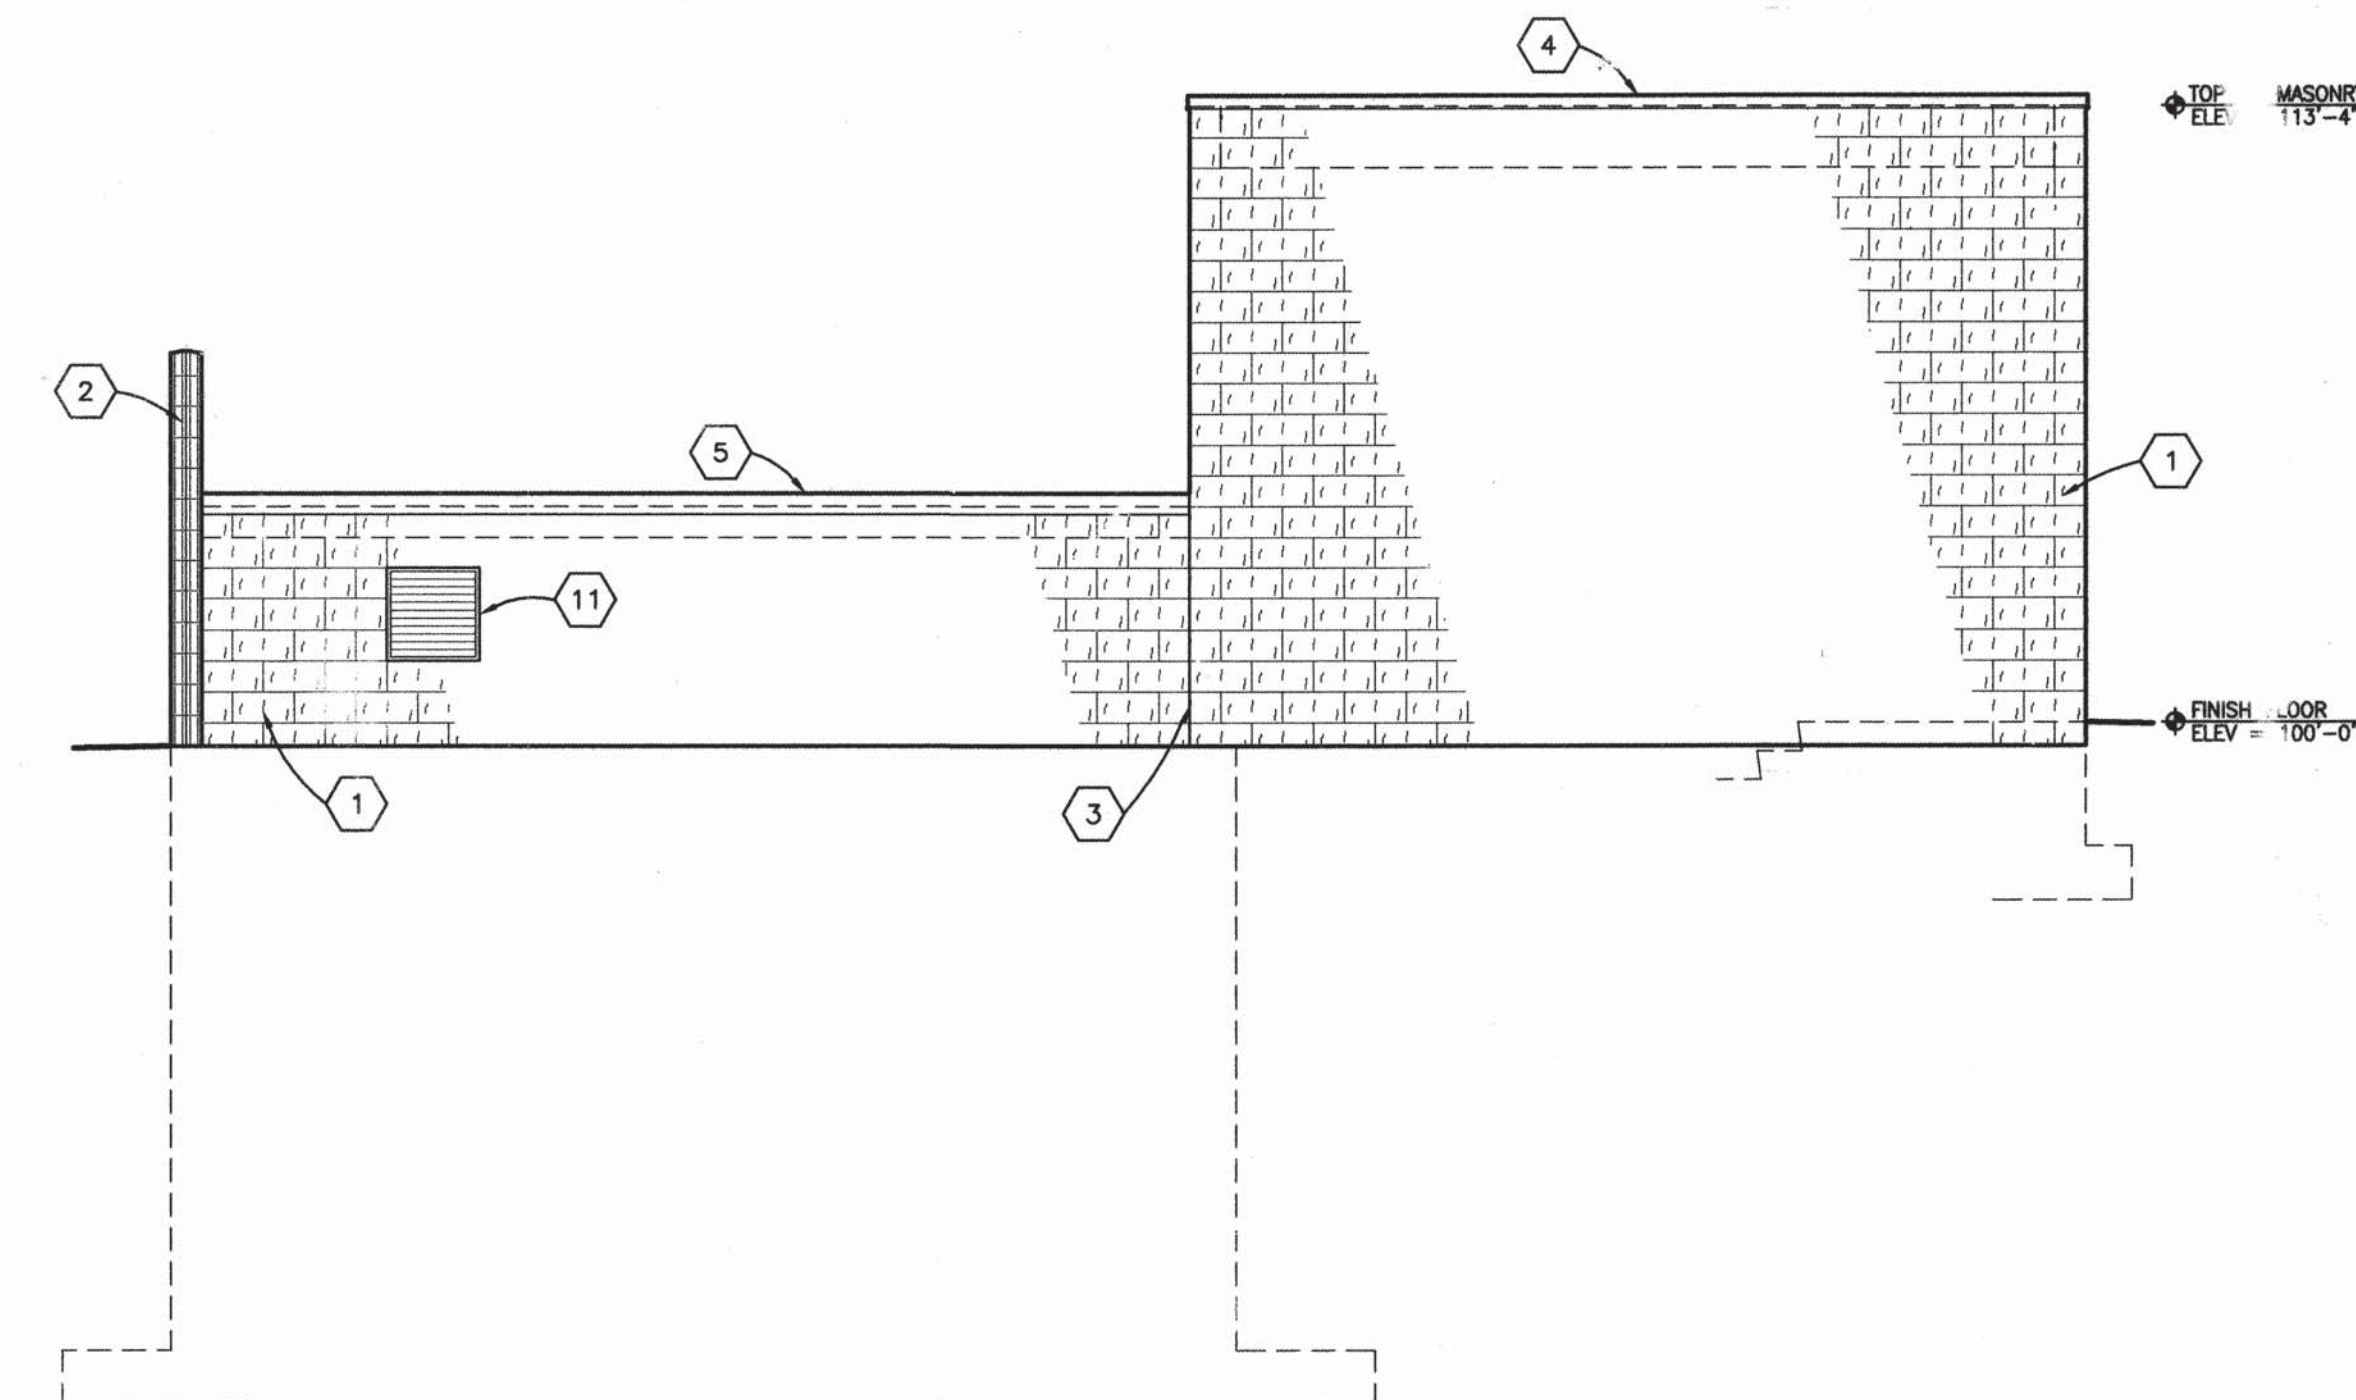


EAST ELEVATION
1/4"=1'-0"

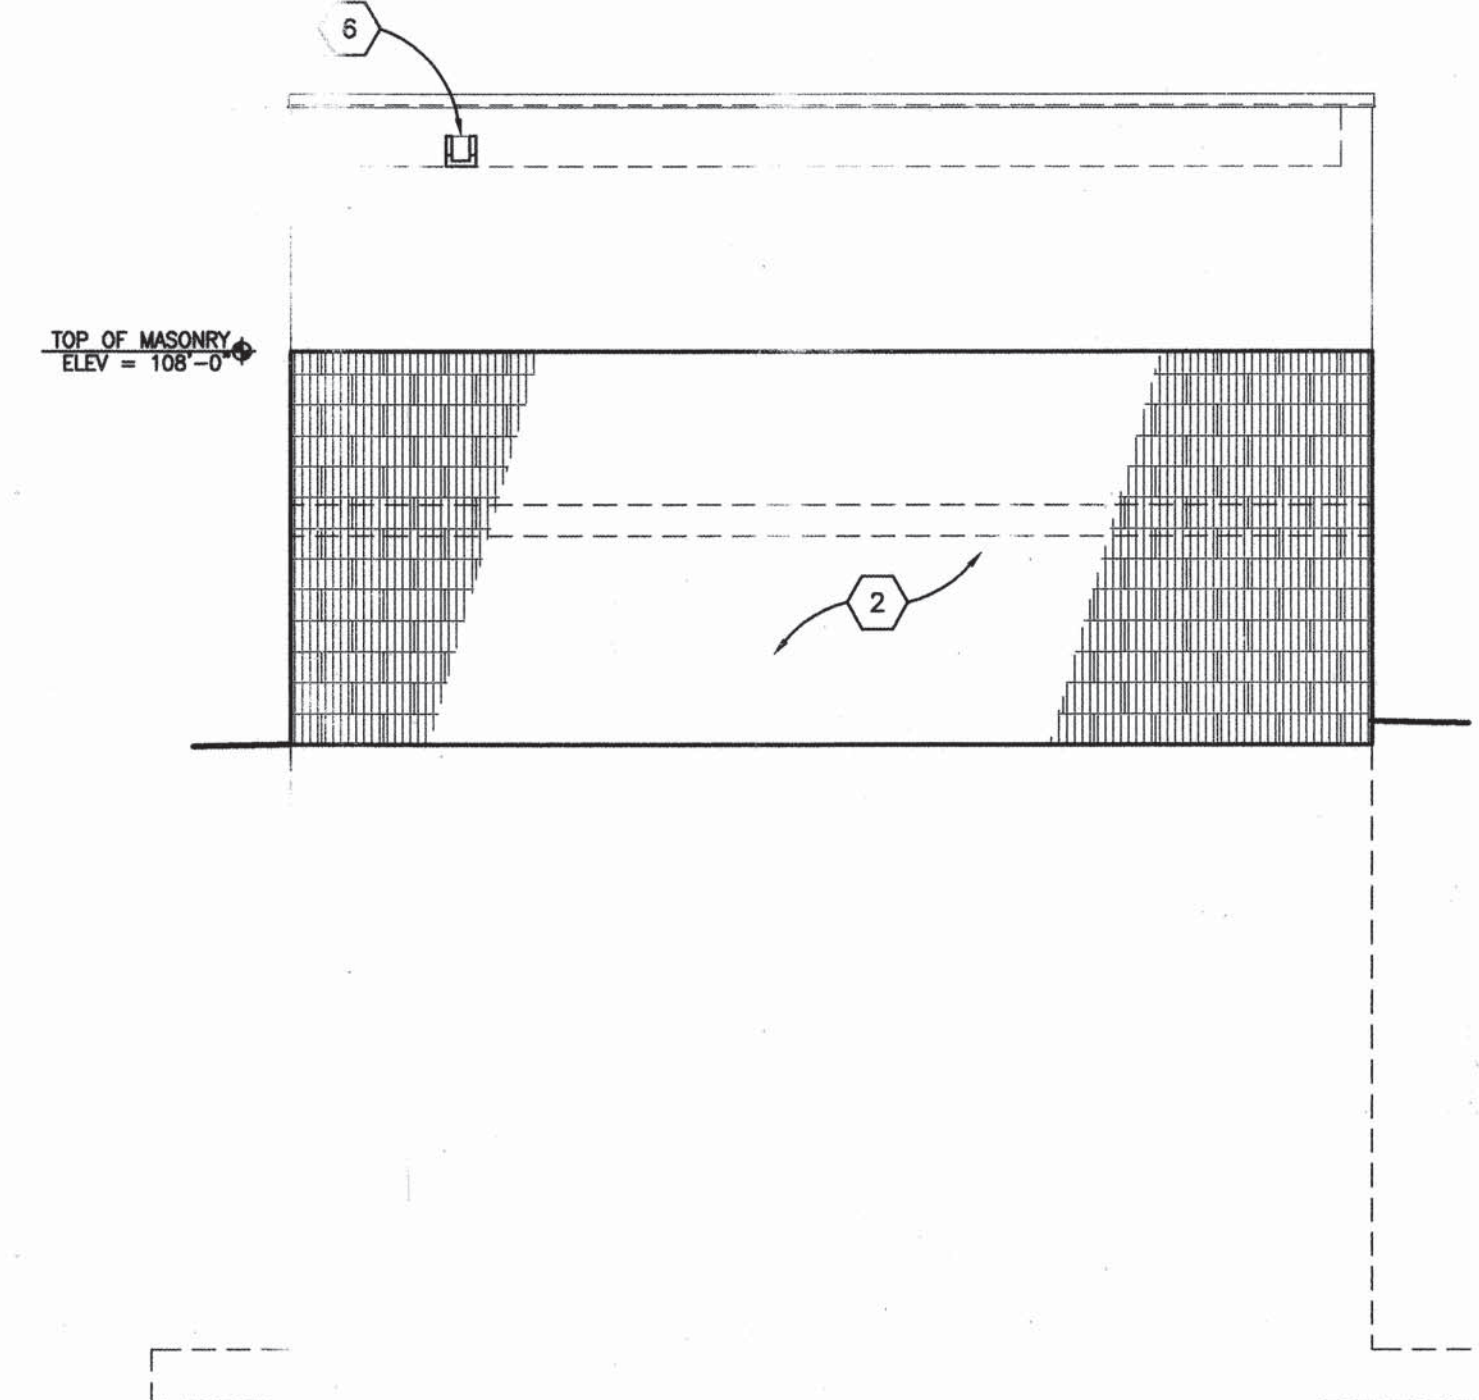


SOUTH ELEVATION
1/4"=1'-0"

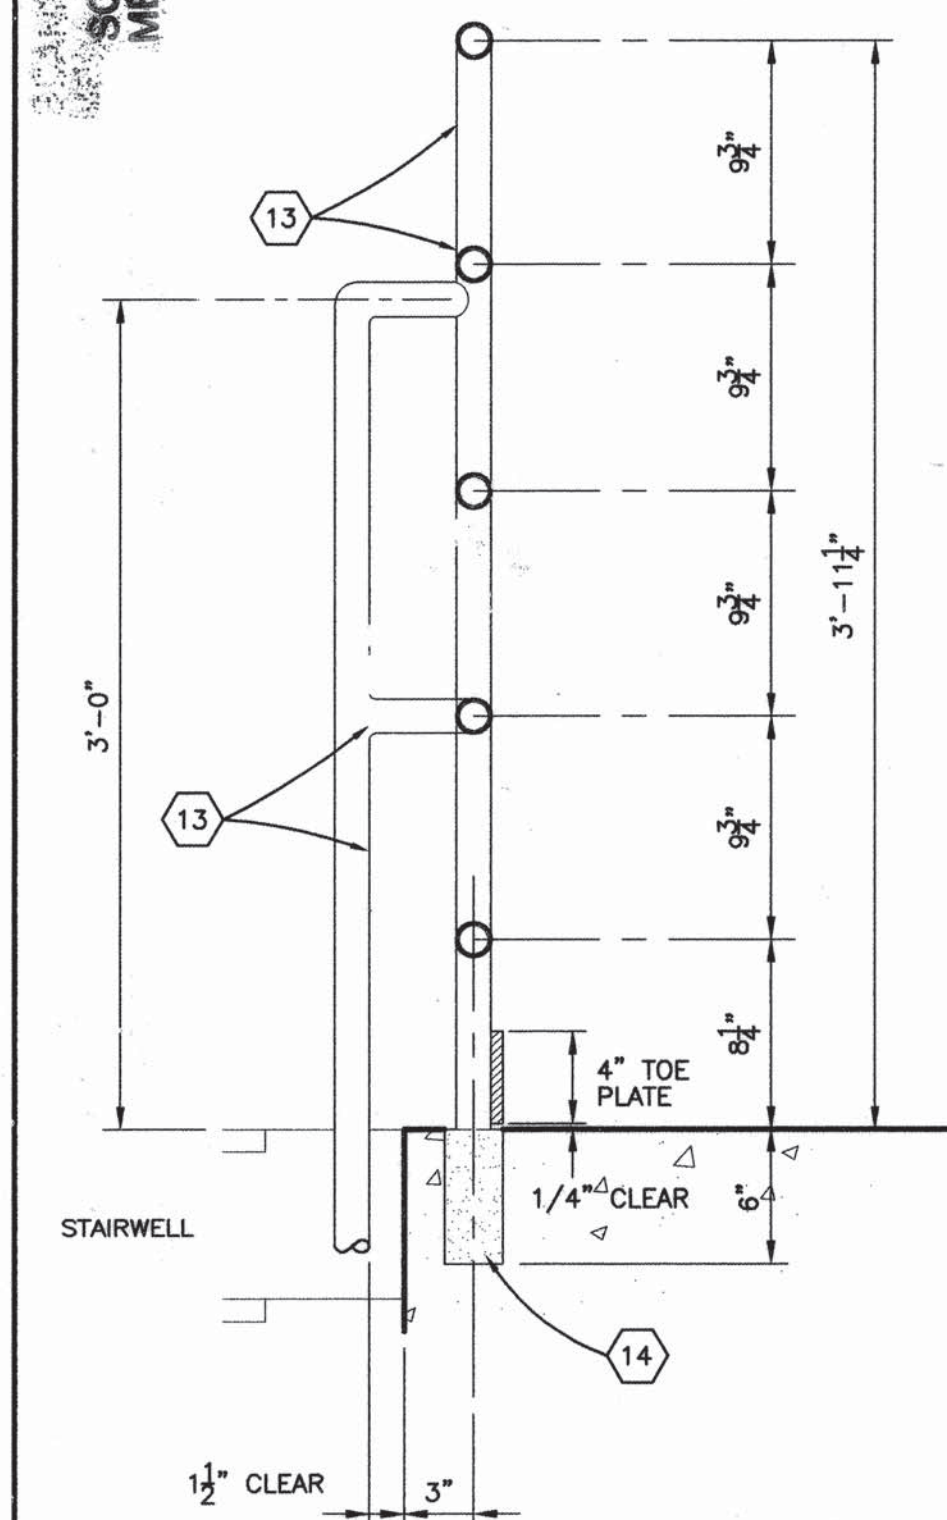

2 RAILING DETAIL
1 1/2"=1'-0"

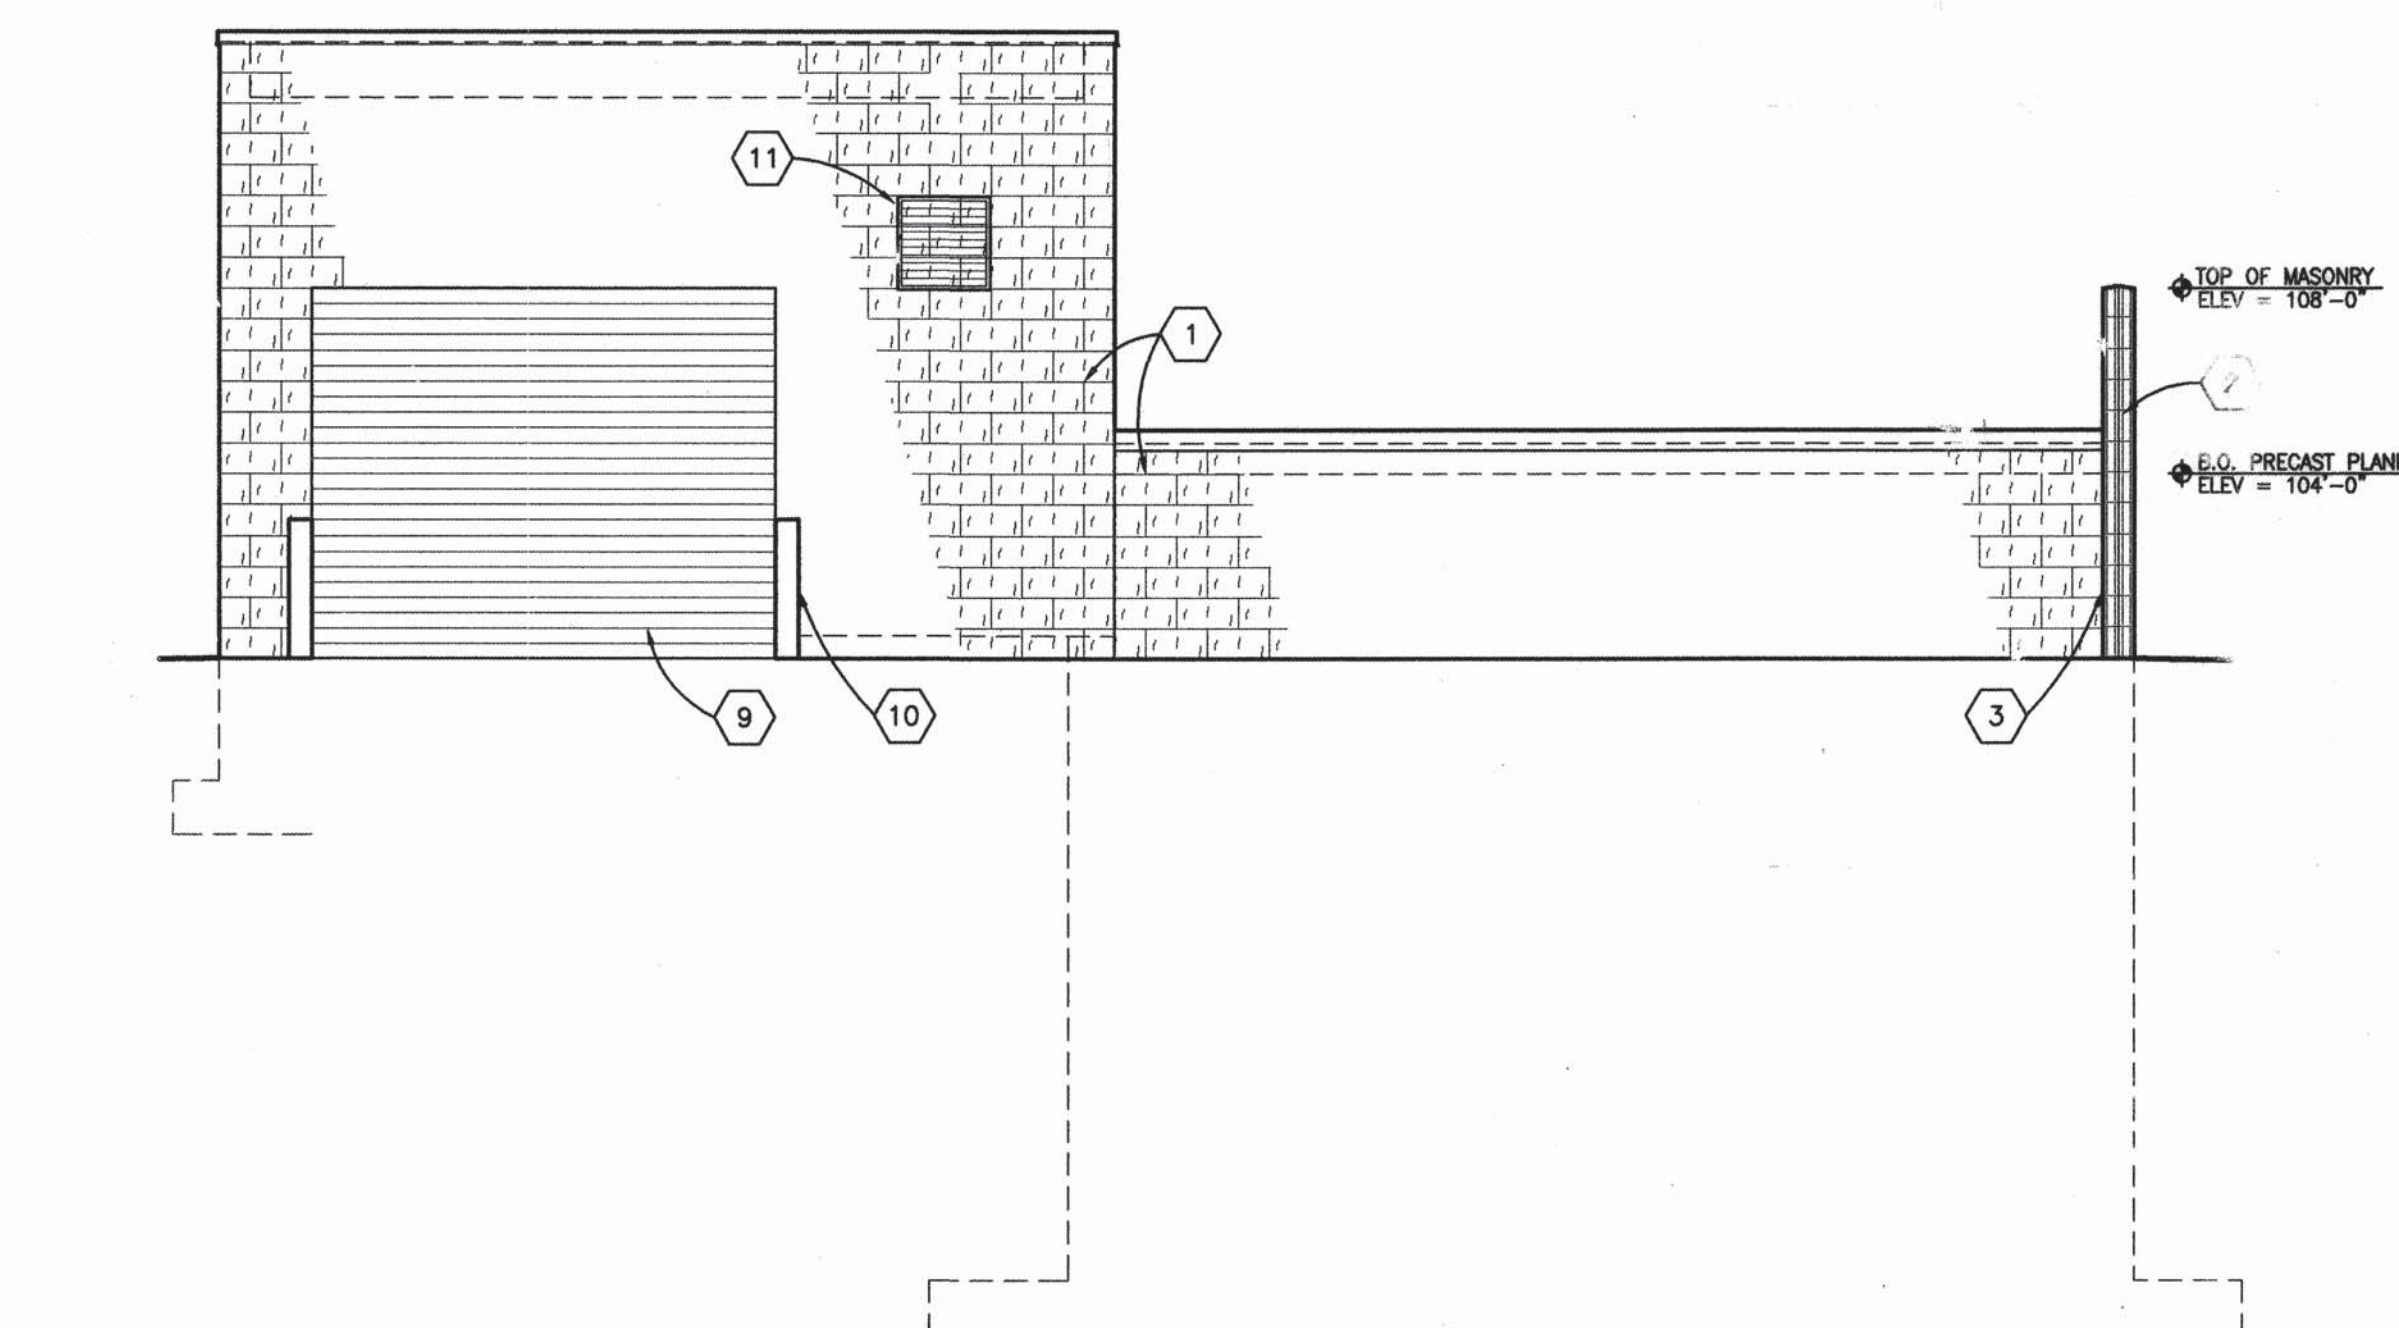

WEST ELEVATION
1/4"=1'-0"

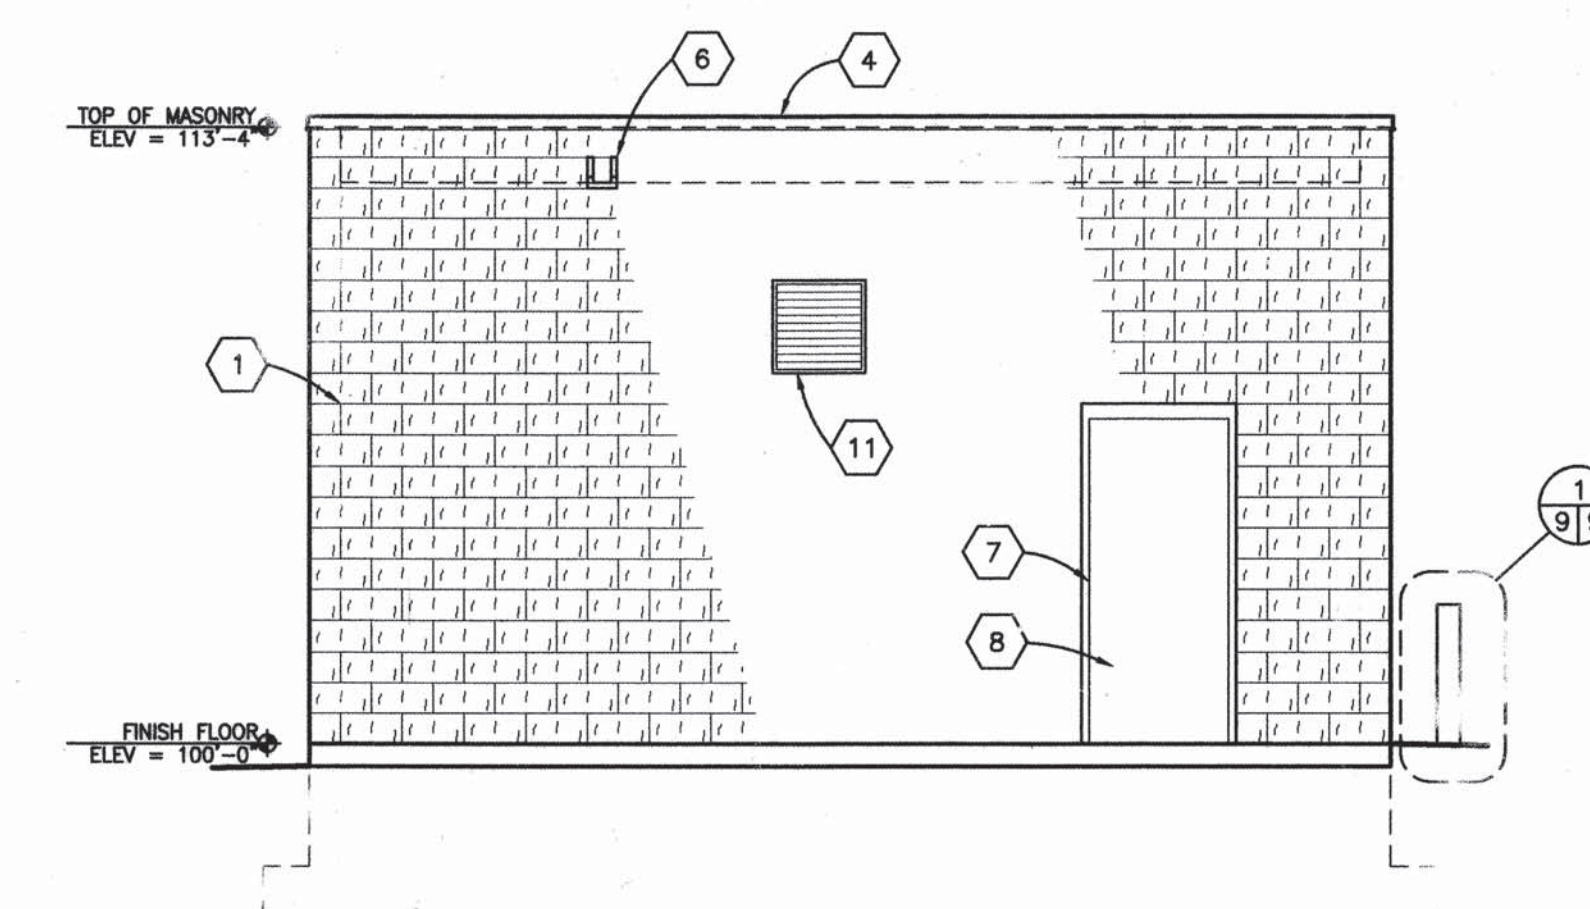

NORTH ELEVATION
1/4"=1'-0"

GENERAL SHEET NOTES:

A. REFERENCE FINISH FLOOR ELEVATION = 100'-0" AND REFERENCES DATUM ELEVATION, SEE CIVIL DRAWINGS FOR DATUM.

SHEET KEYED NOTES: (X)

1. TYPE 1 CONCRETE MASONRY UNITS
2. TYPE 2 CONCRETE MASONRY UNITS
3. MASONRY CONTROL JOINT
4. COPING
5. FACIA
6. PRECAST CONCRETE SCUPPER
7. STEEL FRAME
8. STEEL DOOR
9. OVERHEAD COILING DOOR
10. SCHEDULE 20 GALVANIZED STEEL 6" BOLLARD
11. WALL LOUVER
12. CONCRETE
13. STEEL RAILING SYSTEM
14. GROUT POCKET

AS-BUILT INFORMATION		BENCH MARKS		SURVEY INFORMATION		ENGINEER'S SEAL	
CONTRACTOR	TRAMP BUILDERS OF NM	NO.	DATE	FIELD NOTES	NO.	NO.	DATE
WORK BY	TRAMP	NO.	DATE	BY	NO.	NO.	DATE
INSPECTOR'S	WILSON & Co.	NO.	DATE	REVISIONS	NO.	NO.	DATE
ACCEPTANCE BY	WILSON & Co.	NO.	DATE	DESIGNED BY	NO.	NO.	DATE
VERIFICATION BY	WILSON & Co.	NO.	DATE	DRAWN BY	NO.	NO.	DATE
DRAWING NO.	WILSON & Co.	NO.	DATE	CHECKED BY	NO.	NO.	DATE
MICRO-FILM INFORMATION		RECORDED BY		DATE		DATE	
NO.		NO.		NO.		NO.	

CITY PROJECT #567292

COUNTY OF BERNALILLO
ENVIRONMENTAL HEALTH AND
PUBLIC WORKS DEPARTMENTS



NORTH VALLEY AREAS B AND F
VACUUM STATION


ARCHITECTURAL-
ELEVATIONS AND DETAILS

PROJECT NO. 96034 SHEET 9 OF 19


WILSON
& COMPANY

X:\PUBLIC\PROJECTS\96034\DRAWINGS\VACSTA\ARCH\A6034VS07-9-1-99.DWG


SCANNED BY
MESAVEPRO

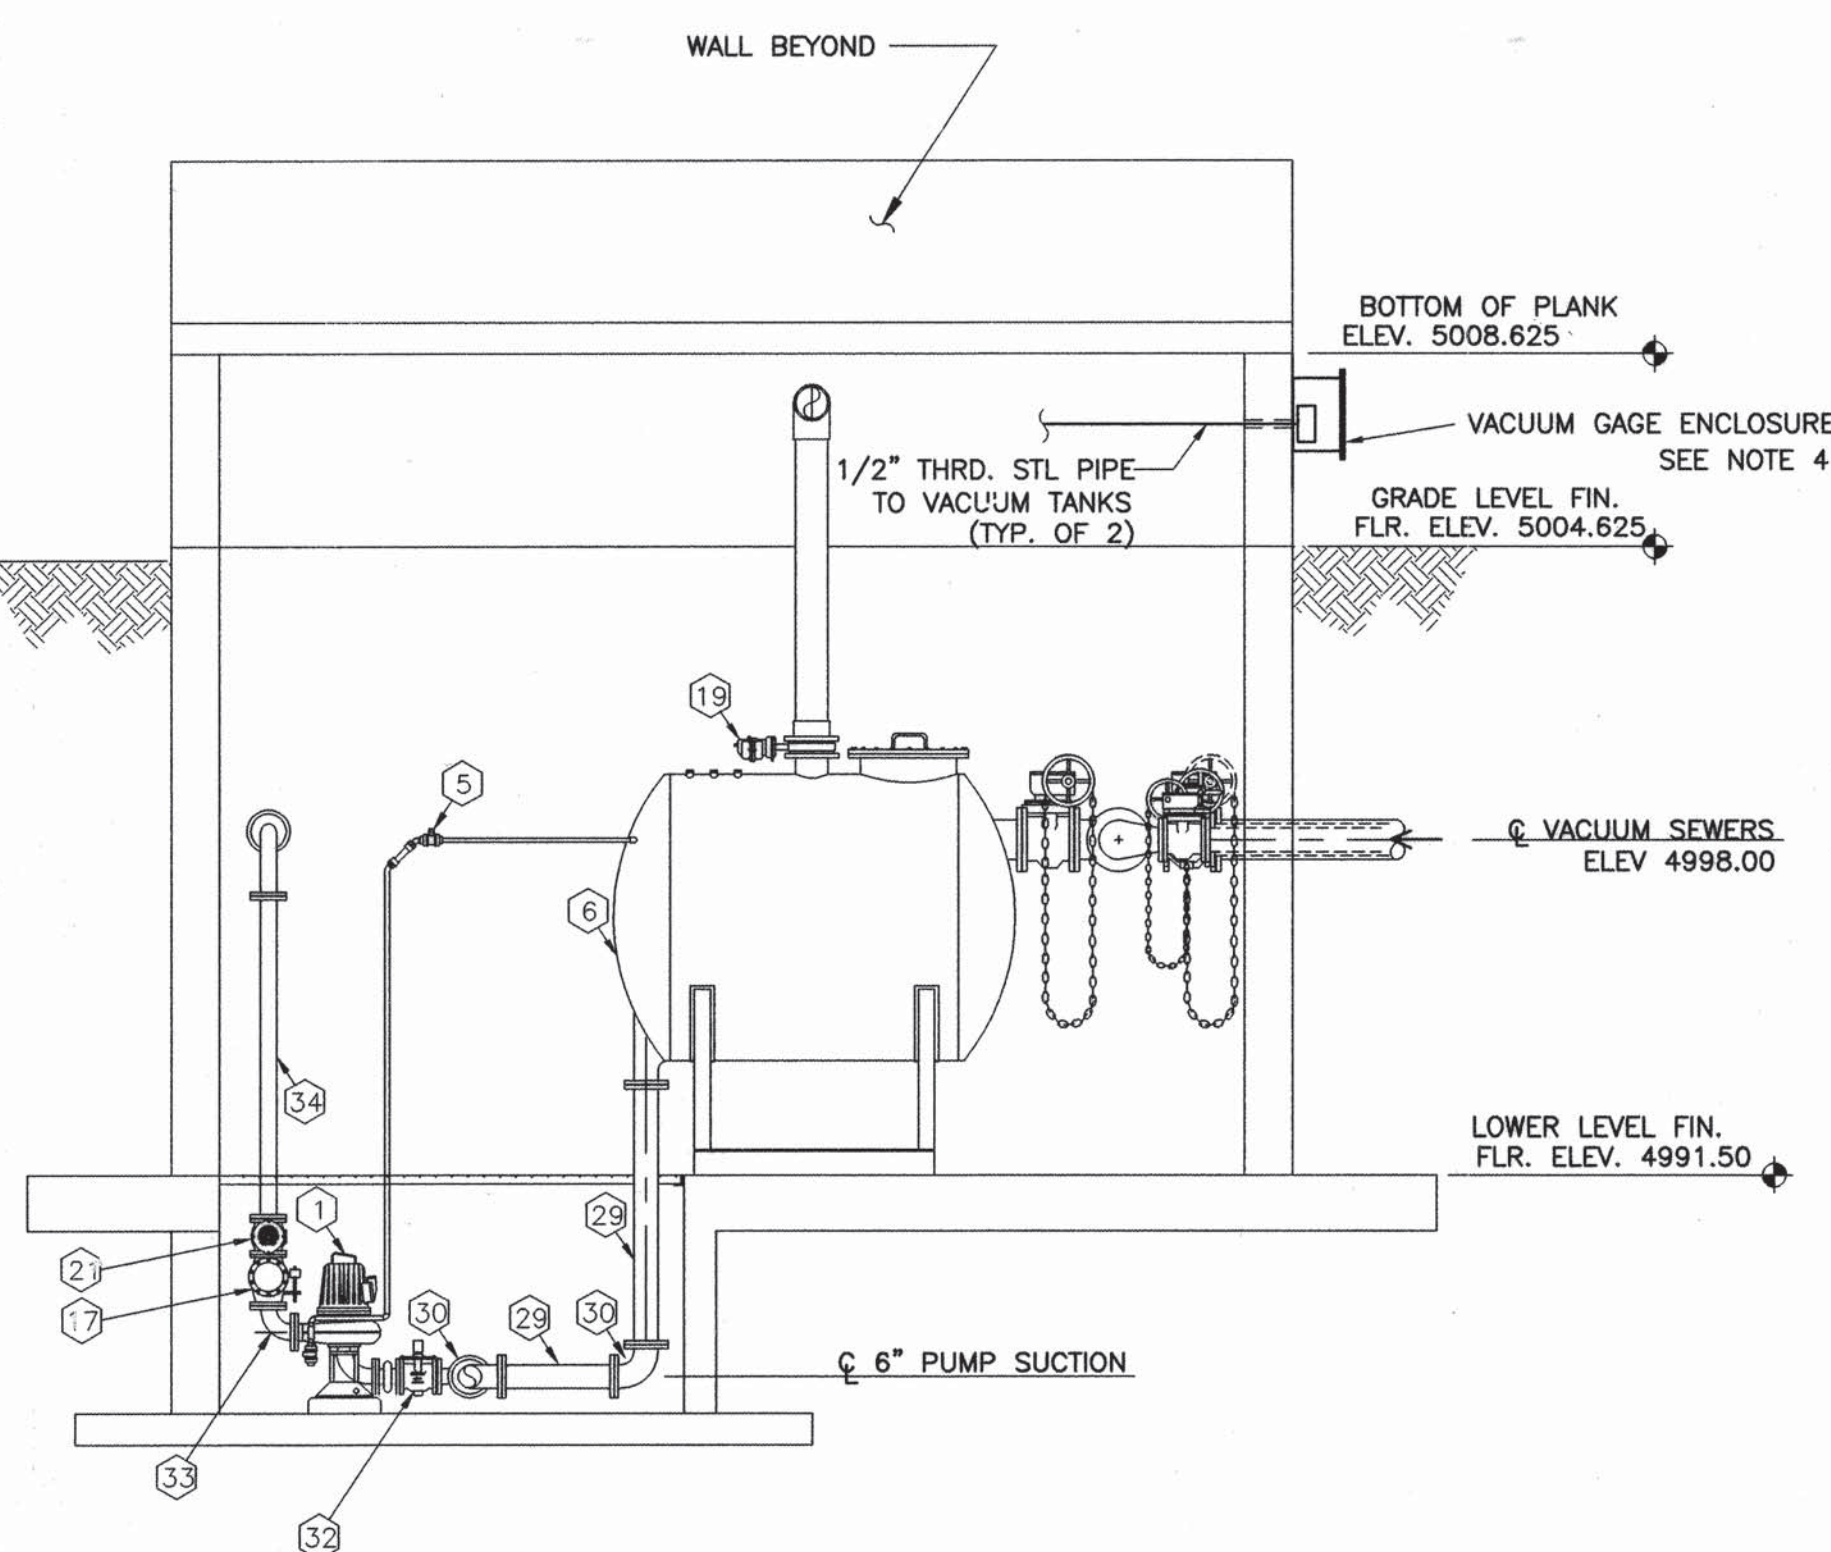


A
10 BUILDING SECTION AT LOWER LEVEL LOOKING SOUTH
SCALE: 1/4" = 1'-0"

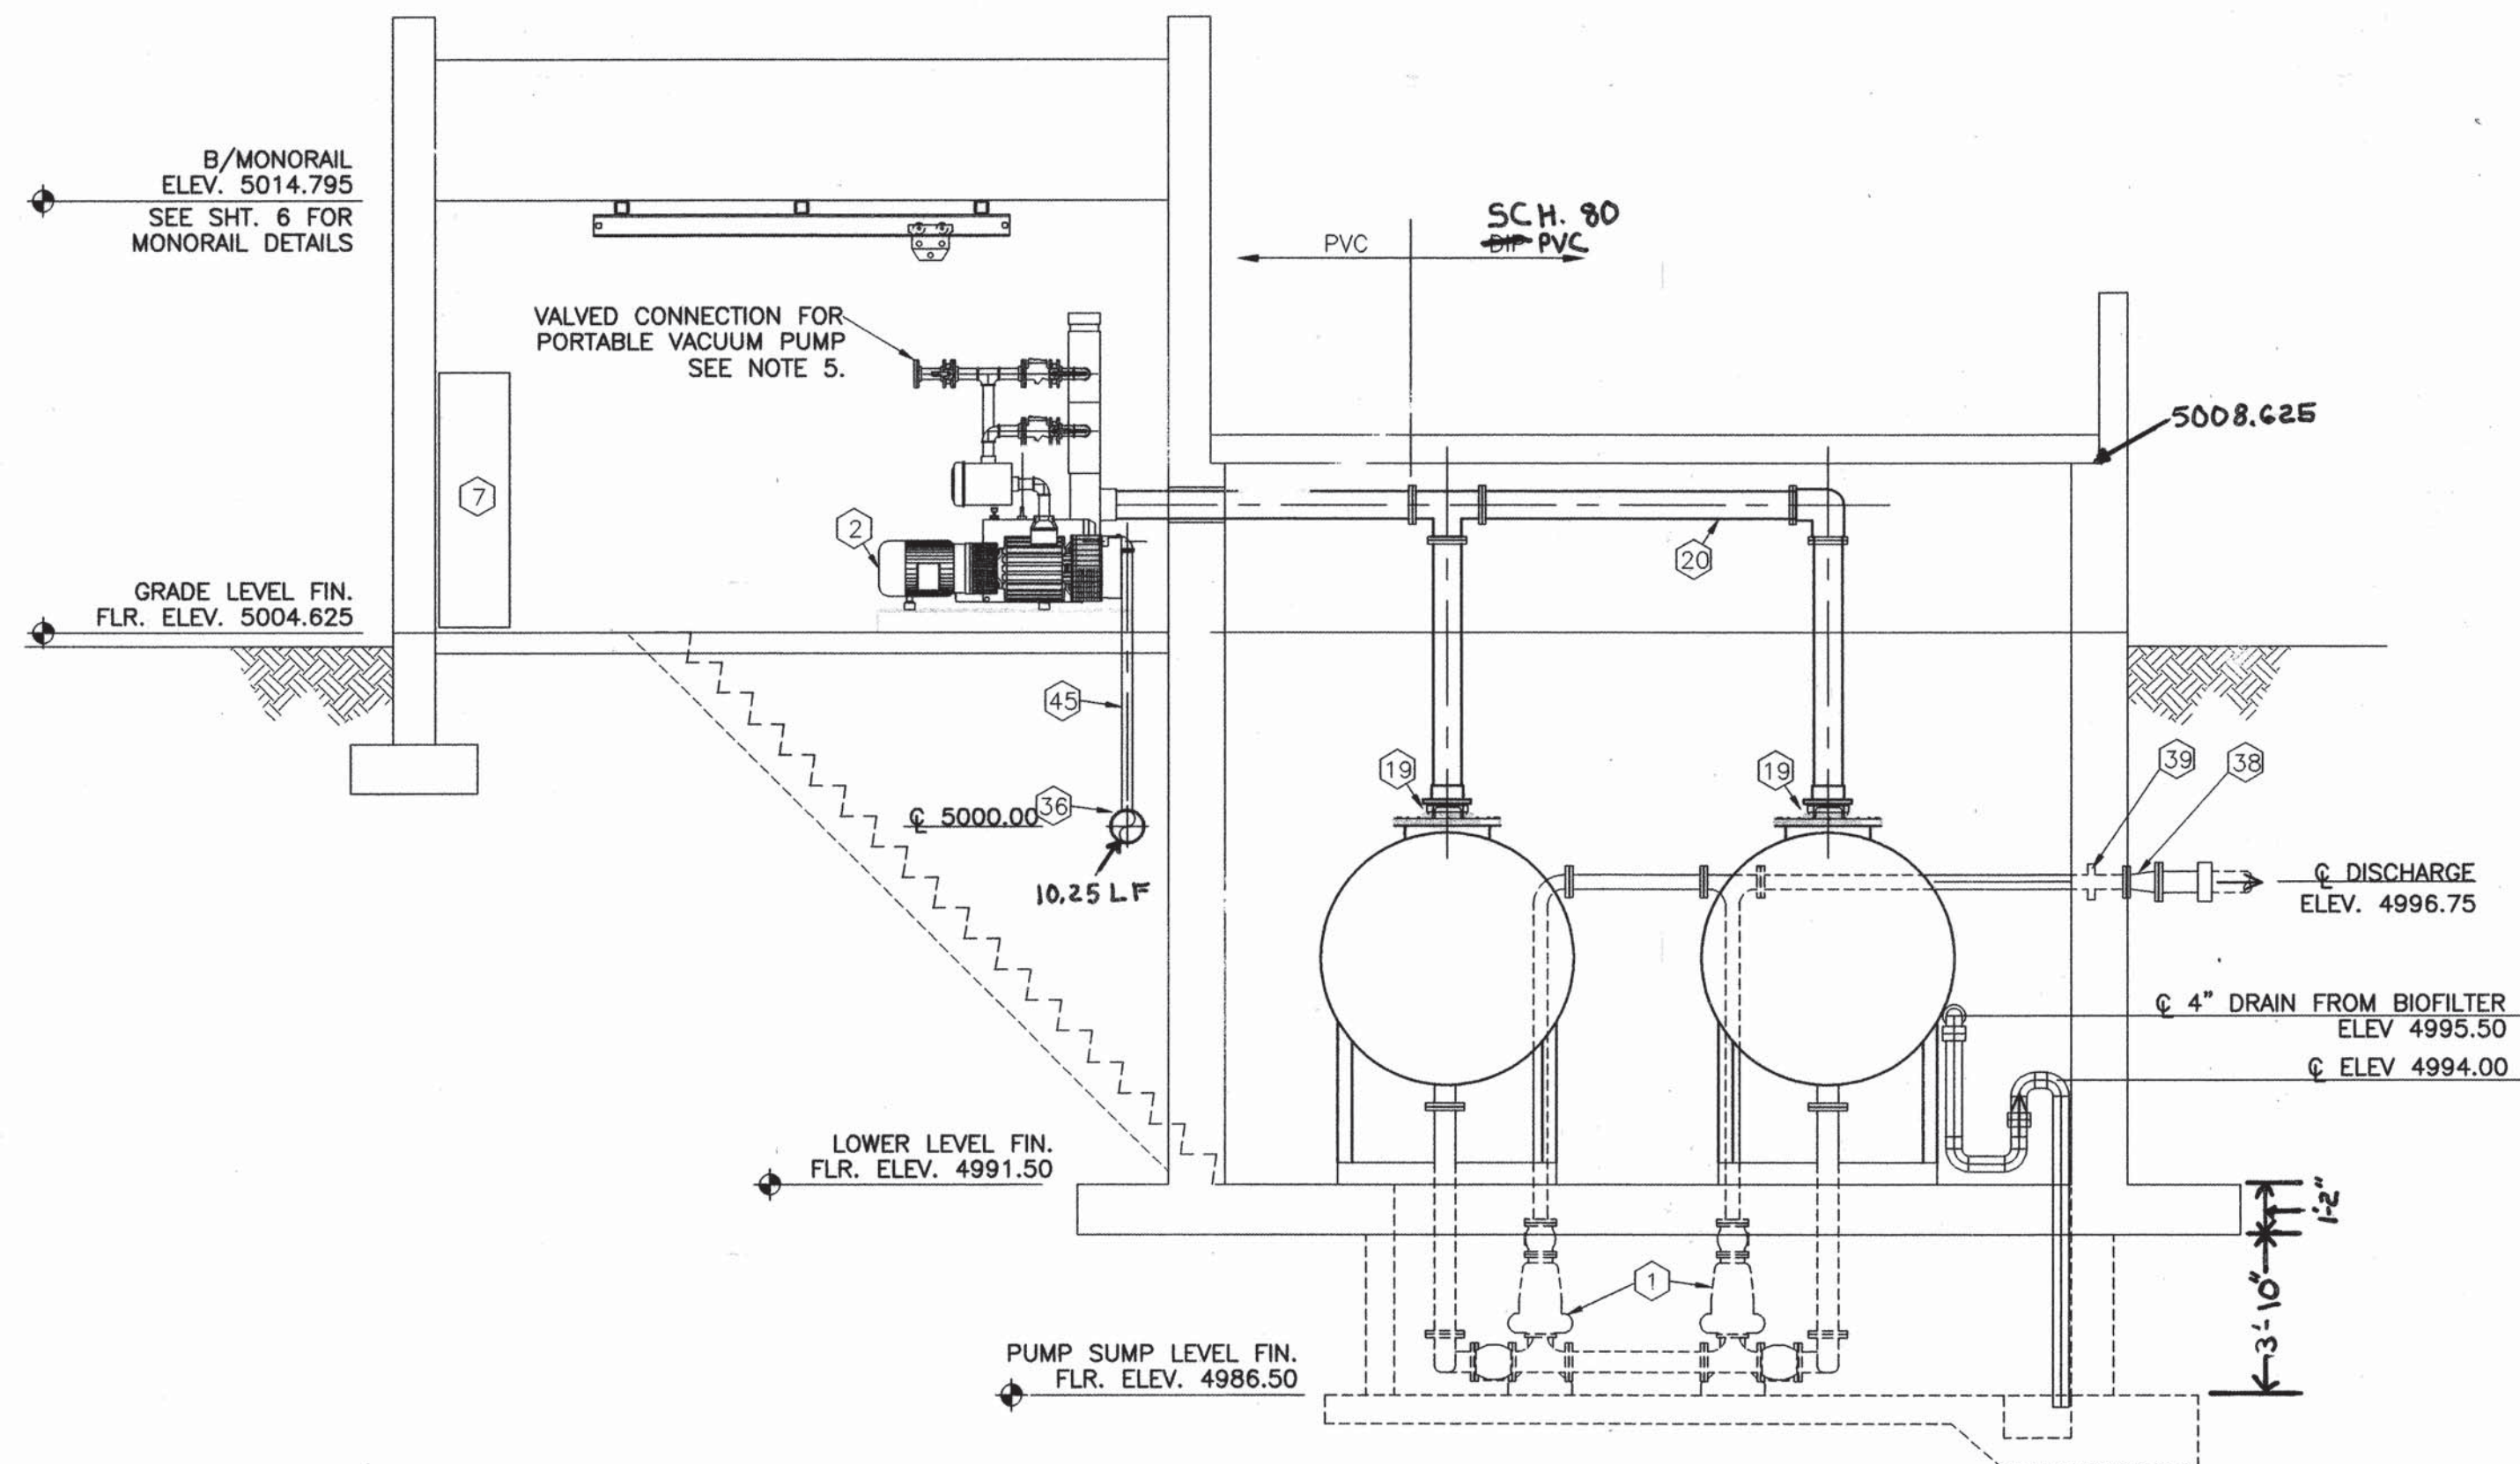

B
10 BUILDING SECTION LOOKING EAST
SCALE: 1/4" = 1'-0"

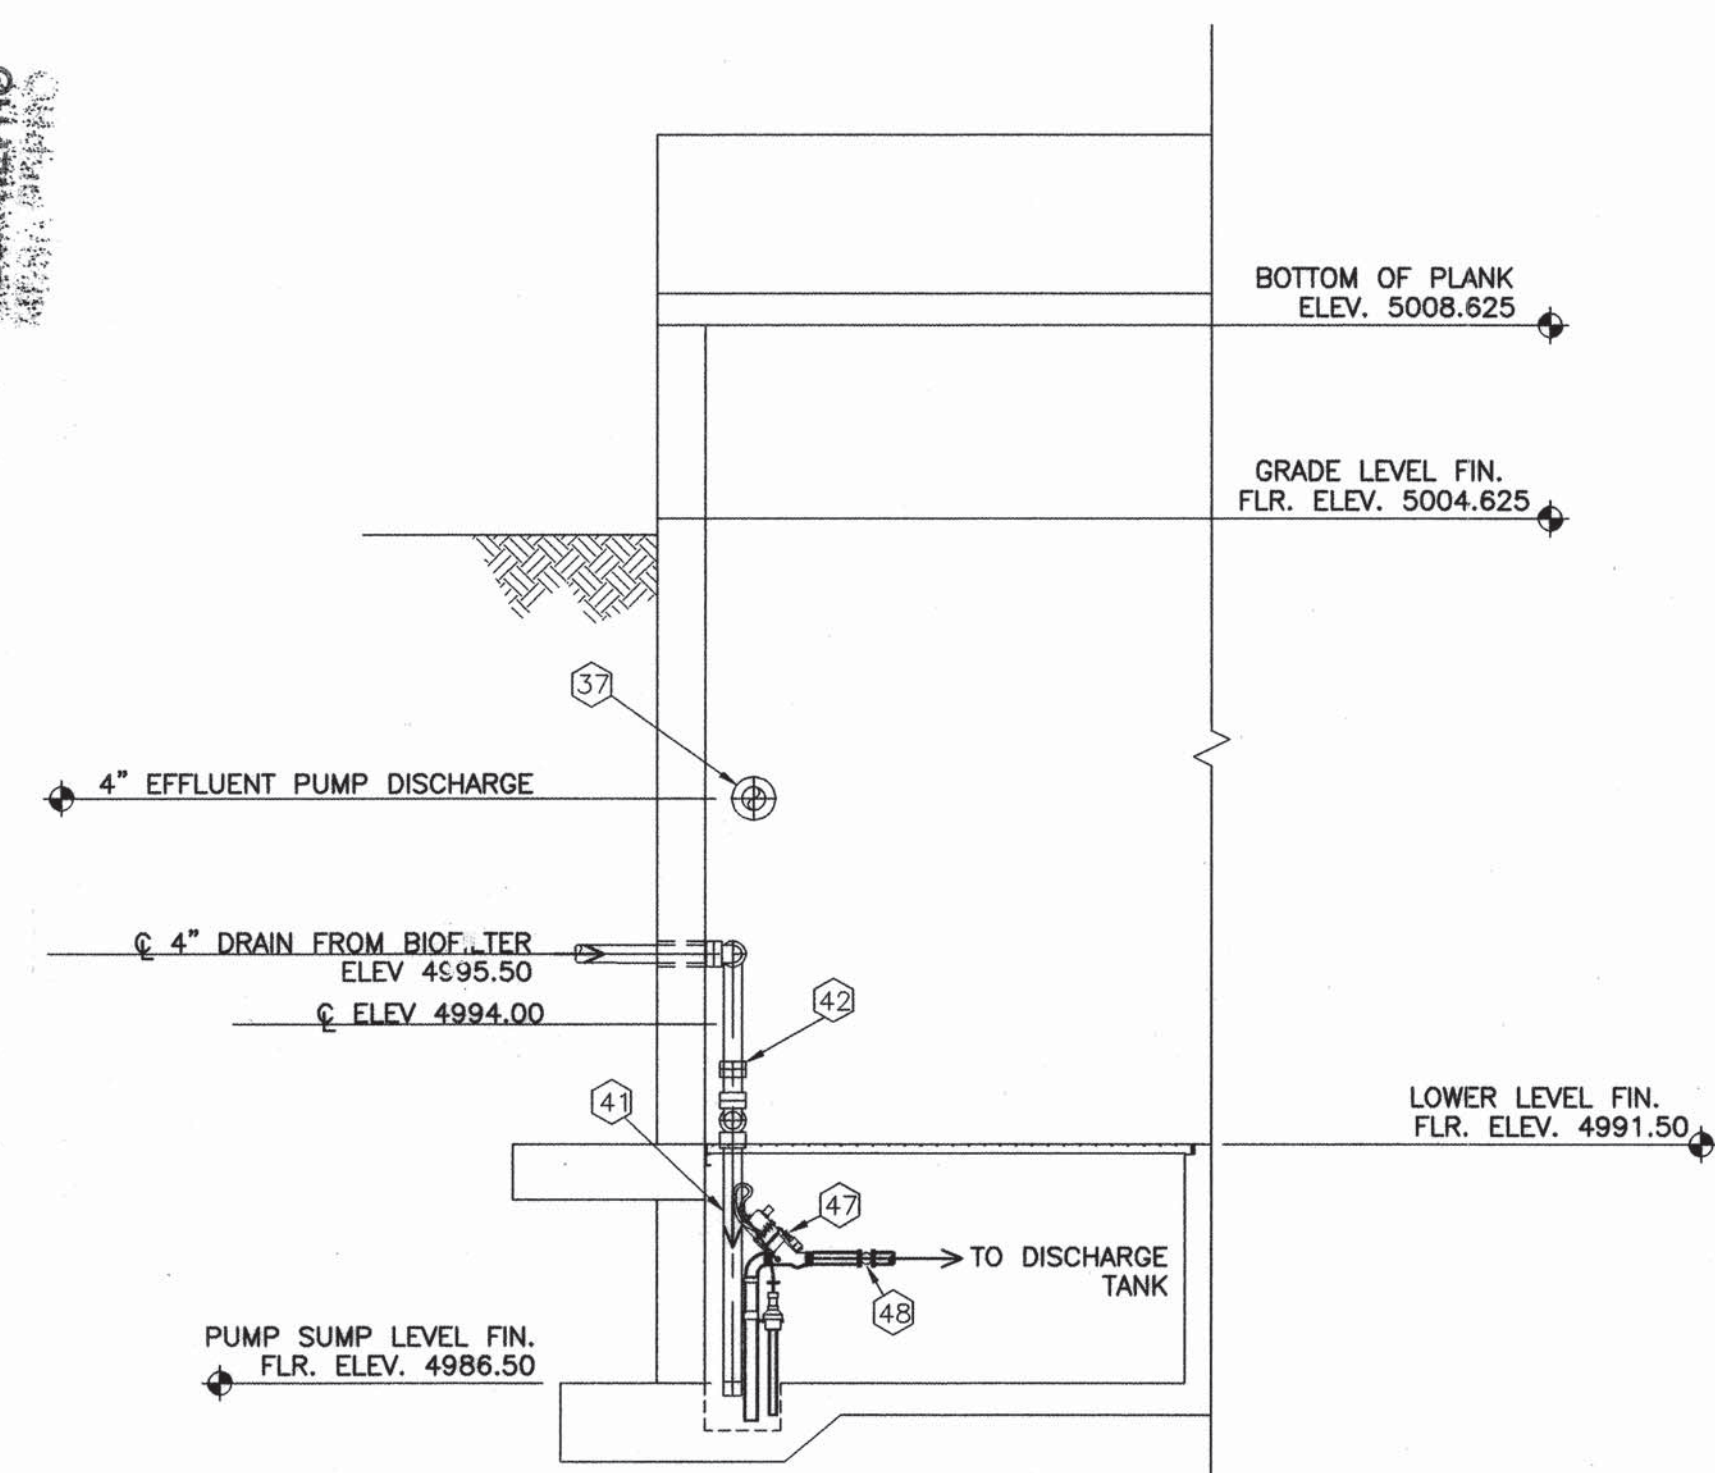

C
10 BUILDING SECTION LOOKING SOUTH
SCALE: 1/4" = 1'-0"

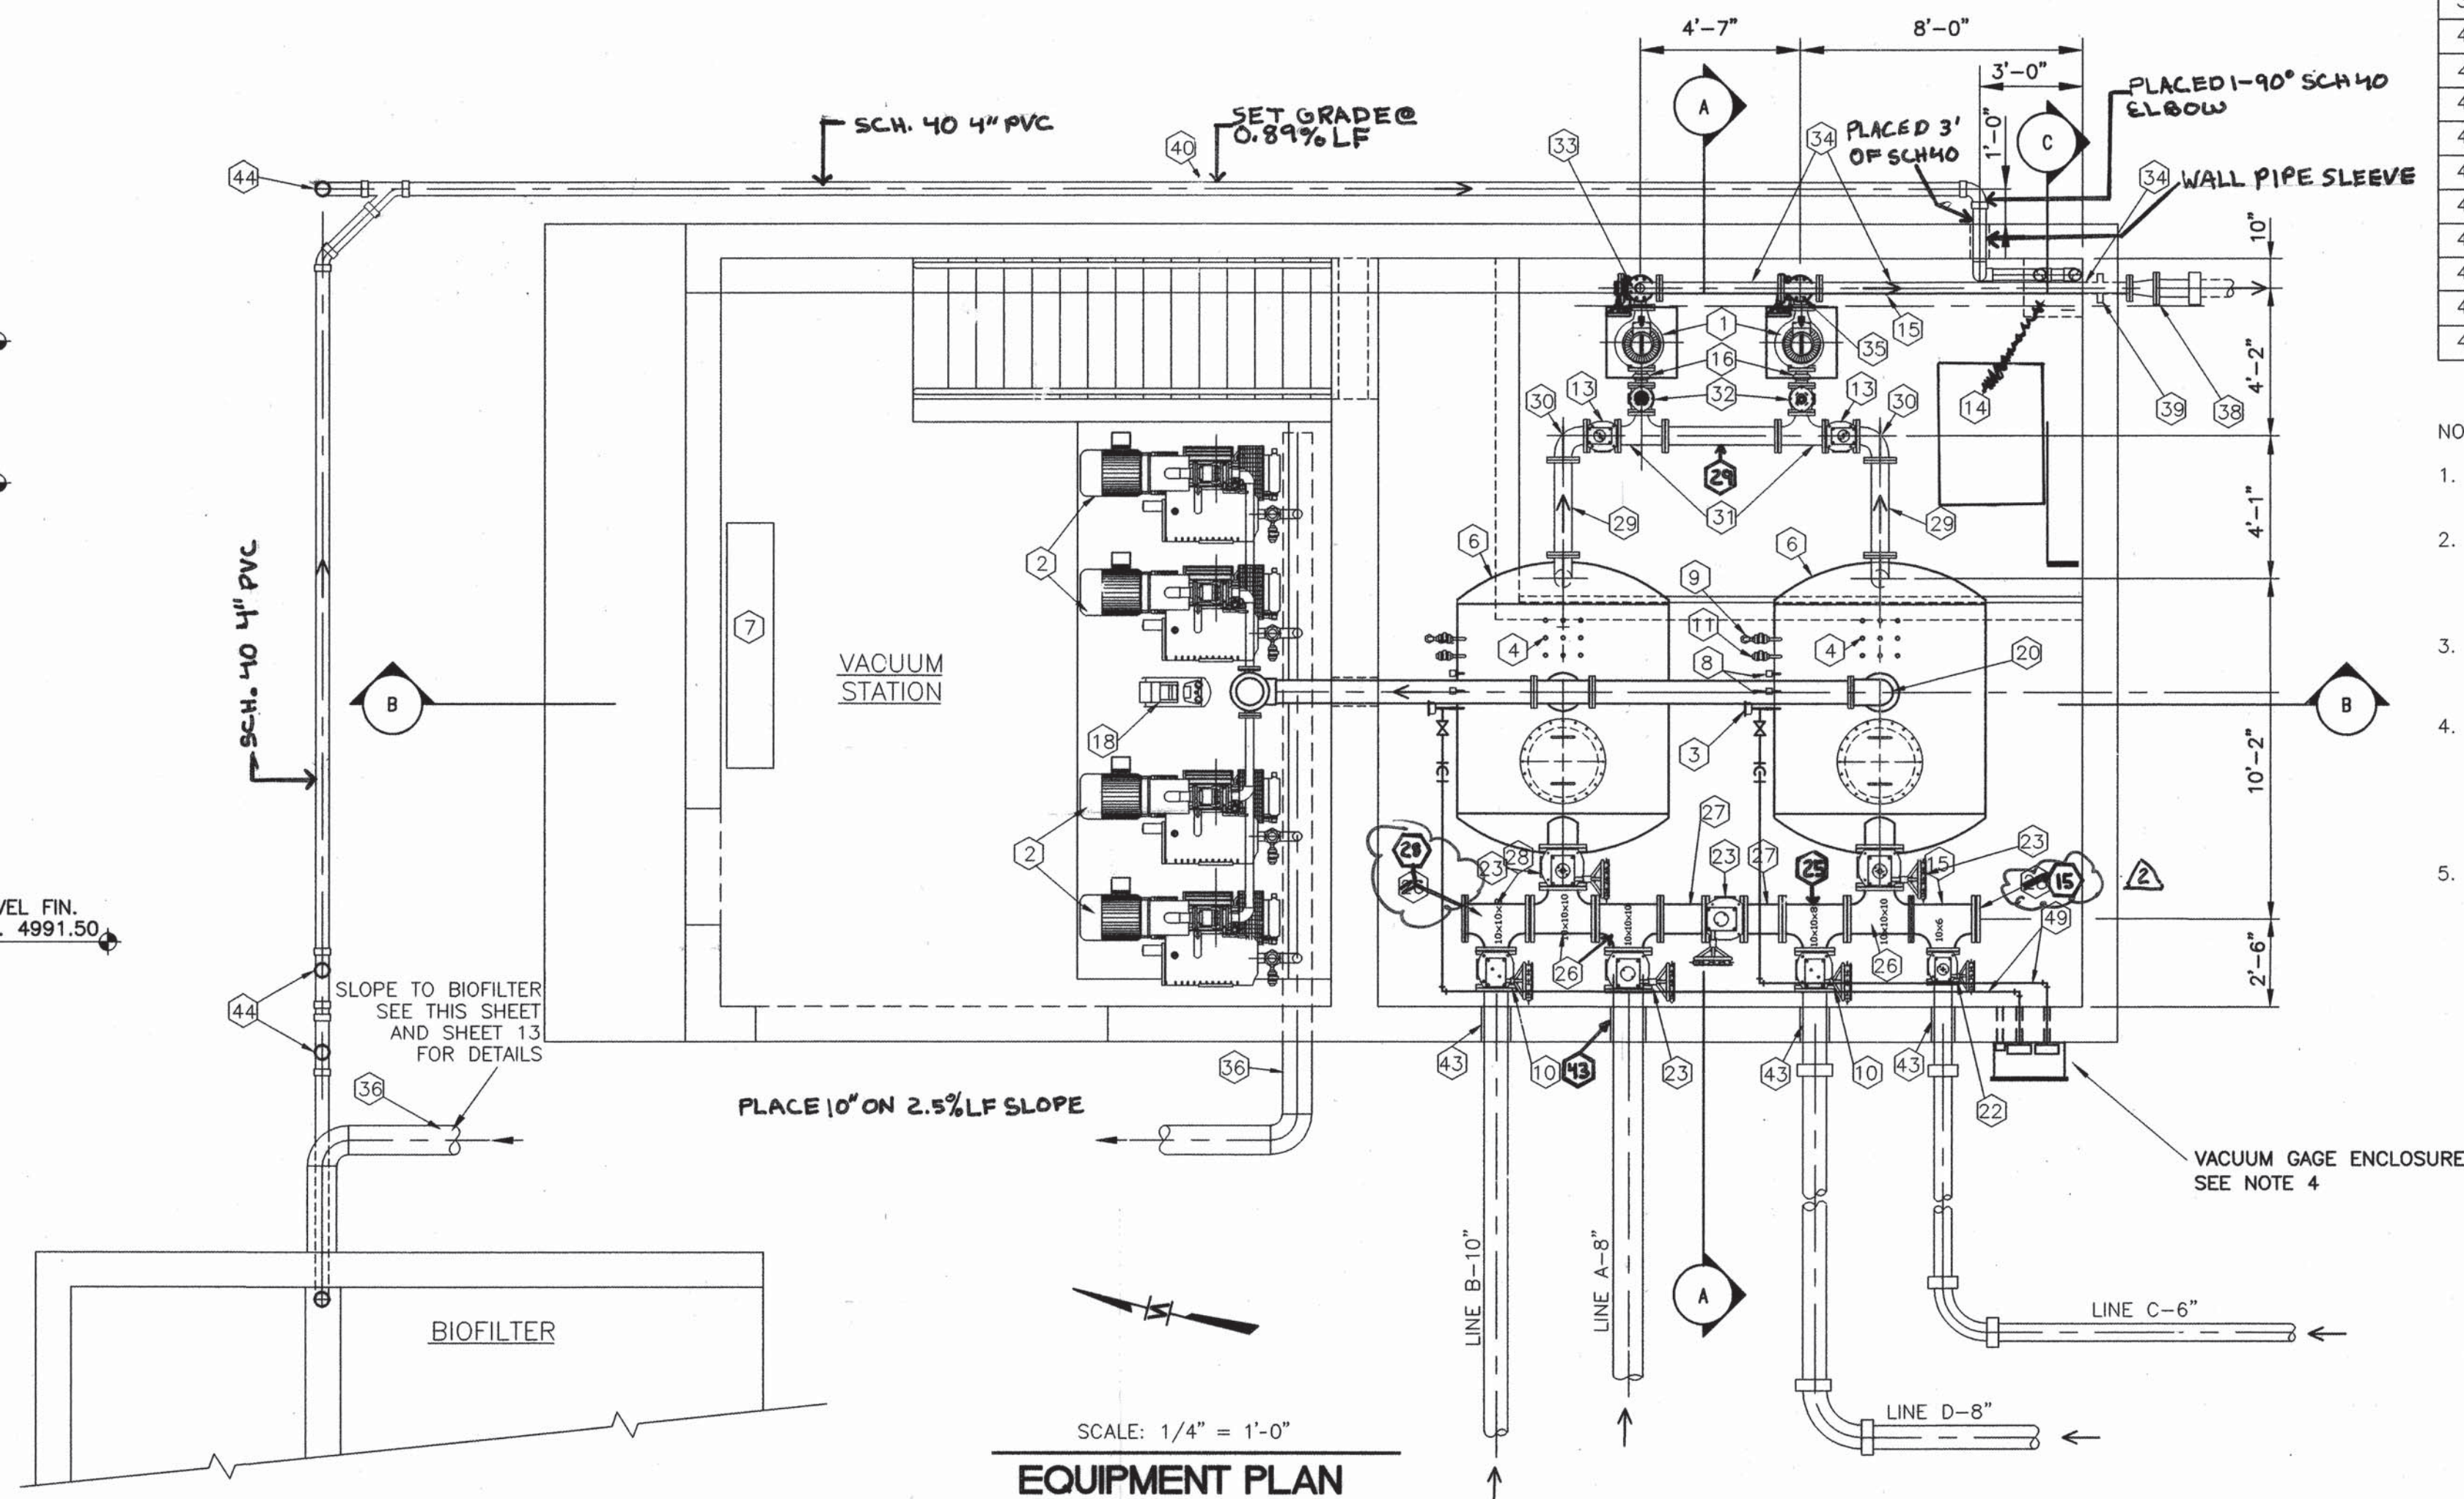

SCALE: 1/4" = 1'-0"
EQUIPMENT PLAN

SHEET KEYED NOTES : (X)

#	DESCRIPTION	QTY	MANUF. MATERIAL
1	CENTRIFUGAL SEWAGE PUMP	2	AIRVAC
2	VACUUM PUMP, 430 CFM	4	AIRVAC
3	0-30" HG. VACUUM GAUGE	2	AIRVAC
4	LEVEL SENSING PROBES	14	AIRVAC
5	1" EQUALIZING LINE ASSEMBLY	2	AIRVAC
6	1500 GALLON STEEL COLLECTION TANK	2	AIRVAC
7	MOTOP CONTROL CENTER	1	AIRVAC
8	0-30" HG. VACUUM SWITCH	4	AIRVAC
9	1" CLEAR SITE TUBE ASSEMBLY	2	AIRVAC
10	8" PLUG VALVE-VACUUM MAINS	2	AIRVAC
11	1" PVC PLUG VALVE	2	AIRVAC
12	3" PVC BALL VALVE NOT USED	1	AIRVAC
13	6" PLUG VALVE-PUMP SUCTION	2	AIRVAC
14	NOT USED ACCESS HATCH		
15	10" X 10" X 6" TEE	1	AIRVAC
16	4" VIBRATION ISOLATOR	2	AIRVAC
17	4" CHECK VALVE-PUMP DISCHARGE	2	AIRVAC
18	3/4 H.P. AIR COMPRESSOR (SEE NOTE)	1	AIRVAC
19	8" BUTTERFLY VALVE W/AIR ACTUATOR	2	AIRVAC
20	8" VACUUM HEADER ASSEMBLY	2	AIRVAC
21	4" PLUG VALVE-PUMP DISCHARGE	2	AIRVAC
22	6" PLUG VALVE-VACUUM MAINS	1	AIRVAC
23	10" PLUG VALVE-VACUUM MAINS	4	AIRVAC
24	2" PUMP VALVE NOT USED	2	AIRVAC
25	10" X 8" TEE	1	AIRVAC
26	10" X 10" X 8" TEE	3	AIRVAC
27	10" SPOOL	2	AIRVAC
28	10" X 8" TEE WITH BLIND FLANGE	1	AIRVAC
29	6" SPOOL	5	AIRVAC
30	6" FLG X FLG 90° BEND	2	AIRVAC
31	6" X 4" X 6" TEE	2	AIRVAC
32	4" PLUG VALVE- SUCTION	2	AIRVAC
33	4" FLG X FLG 90° BEND	1	SEC 15060
34	4" FLG X FLG SPOOL	4	SEC 15060
35	4" FLG X FLG TEE	2	AIRVAC
36	10" DISCHARGE HEADER AIR	1	SEC 15060
37	4" PUMP DISCHARGE	1	SEC 15060
38	10" X 4" REDUCER	1	SEC 15060
39	4" X 2'-6" LONG WALL PIPE	1	SEC 15060
40	4" COMPOST FILTER DRAIN	1	SEC 15060
41	4" DRAIN TRAP	1	SEC 15060
42	4" COUPLING	2	SEC 15060
43	LINK SEAL- SEE PIPE SIZE	4	SEC 15060
44	4" CLEANOUT	3	SEC 15060
45	3" VACUUM PUMP DISCHARGE	4	SEC 15060
46	4" CLEANOUT NOT USED	1	AIRVAC
47	2" VACUUM VALVE	1	AIRVAC
48	VACUUM VALVE PIPING	1	SEC 15060
49	VACUUM GAGE PIPING	2	SEC 15060

NOTE:

- PROVIDE AIR PIPING BETWEEN AIR COMPRESSOR 18 AND TANK ISOLATION VALVES 19 PER REQUIREMENTS OF AIRVAC.
- SPECIFIC LOCATIONS AND ANCHORAGE OF VACUUM EQUIPMENT AND SEWER PIPING INTO STATION SUBJECT TO EQUIPMENT SUPPLIED. SUBMIT DIMENSIONAL PLAN OF ALL EQUIPMENT PRIOR TO CONSTRUCTION.
- VAS PIPING ELEVATIONS SUBJECT TO EQUIPMENT FURNISHED. COORDINATED ELEVATION W/MANUFACTURER PRIOR TO CONSTRUCTION.
- VACUUM GAGE ENCLOSURE - 2' x 1'-6" x 9" DEEP 12 GA. STEEL W/ BULLET-PROOF GLASS FRONT TO 2" FLANGE LIP. ANCHOR TO WALL W/ CHEMICAL ANCHORS, 3" MIN. EMBEDMENT. PROVIDE 8" DIA. (0" - 30") VACUUM GAGES AND CONVENIENCE OUTLET WITHIN ENCLOSURE. PROVIDE 3 - 2" SLEEVES THROUGH WALL FOR PIPING AND ELECTRICAL WIRING.
- PROVIDE VALVED AND BLIND FLANGED CONNECTION FOR PORTABLE VACUUM PUMP CONNECTION DURING POWER FAILURES. CONNECTION TYPICAL FOR ONE VACUUM DISCHARGE LINE ONLY.

CITY PROJECT #567292

COUNTY OF BERNALILLO
ENVIRONMENTAL HEALTH AND
PUBLIC WORKS DEPARTMENTS



NORTH VALLEY AREAS B AND F
VACUUM STATION

EQUIPMENT & SECTION PLAN
BELOW AND AT GRADE LEVEL

PROJECT NO.
96034

SHEET 10 OF 19

WILSON
& COMPANY

X:\PUBLIC\PROJECTS\96034\DRAWINGS\EQPLAN1-9-1-99.DWG

AS-BUILT INFORMATION		BENCH MARKS		SURVEY INFORMATION	
CONTRACTOR	TRAD Builders of NM	DATE	11/4/99	FIELD NOTES	DATE
DESIGNED BY	WILSON & COMPANY	DATE	11/20/98	NO.	BY
DRAWN BY	WILSON & COMPANY	DATE	11/20/98		
CHECKED BY	WILSON & COMPANY	DATE	11/20/98		
RECORDED BY	WILSON & COMPANY	DATE	11/20/98		



ENGINEER'S SEAL		KEY NOTES	
NO.	DATE	REVISIONS	BY
2	9/20/96	KEY NOTES	ALC
		REVISIONS	

WILSON & COMPANY, ENGINEERS & ARCHITECTS	DATE	11/20/98
DESIGNED BY HMK	DATE	11/20/98
DRAWN BY PUM	DATE	11/20/98
CHECKED BY JDC	DATE	11/20/98

PROVIDE FLEXIBLE DUCT CONNECTION AT SUPPLY FAN.

PROVIDE W/GRAVITY BACKDRAFT DAMPER WITH LOUVER

24" x 24"

1000 CFM

IN-LINE SUPPLY FAN

TRANSITION FROM FAN OUTLET TO 14" x 14" DUCT

BOTTOM OF PLANK
ELEV. 5008.625

GRADE LEVEL FIN.
FLR. ELEV. 5004.625

LOWER LEVEL FIN.
FLR. ELEV. 4991.50

A BUILDING SECTION AT LOWER LEVEL LOOKING SOUTH
SCALE: 1/4" = 1'-0"

B/MONORAIL
ELEV. 5014.795

W/EXPLOSION
PROOF MOTOR

GRADE LEVEL FIN.
FLR. ELEV. 5004.625

LOWER LEVEL FIN.
FLR. ELEV. 4991.50

FLOW SWITCH
SEE ELECTRICAL DRAWINGS

B BUILDING SECTION LOOKING EAST
SCALE: 1/4" = 1'-0"

NOTES:

- 1) HERESITE COAT ALL NON-ALUMINUM PARTS OF EQUIPMENT.
- 2) DUCTWORK TO BE ALUMINUM.
- 3) PROVIDE BIRDSCREEN FOR LOUVER & THE PROPELLER FAN WALL OPENING.
- 4) OPERATION OF THERMOSTAT SET AT 55F.
- 5) INSULATE ALL POTABLE WATER PIPING WITH 1/2" FIBERGLASS INSULATION. PROTECT INSULATION WITH ASJ JACKET.

SCANNED BY
MESA REPRO

WALL MOUNTED PROPELLER FAN
W/PROTECTIVE GUARDS, DAMPER
& DAMPER PROTECTIVE GUARDS.
HERESITE COAT ALL NON-ALUM.
EQUIPMENT. (TYP. FOR 2)

W/EXPLOSION
PROOF MOTOR
PROVIDE BACKDRAFT
DAMPER

HOSE BIB AT 3'
ABOVE F.F.

W/EXPLOSION
PROOF MOTOR
PROVIDE BACKDRAFT
DAMPER

INSTALL
AS HIGH
AS POSSIBLE
(SEE ELECTRICAL
FOR SPECIFICATION)

EQUIPMENT PLAN
SCALE: 1/4" = 1'-0"

IN-LINE SUPPLY FAN
WITH 24" x 24"
SUPPLY PLENUM.

1000 CFM

24" x 24" OPENING

W/EXPLOSION
PROOF MOTOR

INSTALLED @ 45° ANGLE

PROVIDED TURNING VANES IN
ALL RECTANGULAR ELBOWS

INSTALL DUCT AS CLOSE
TO WALL AS POSSIBLE

HOSE BIB AT 3'
ABOVE F.F.

2EA CITY PRE-APPROVED DOUBLE
CHECK VALVE ASSEMBLY

14" x 14" DOWN
TO 12" AFF. COVER
BOTTOM OF DUCT WITH
1/2" ALLUMINUM SCREEN

1" IRRIGATION WATER
FOR CONT. SEE SHT. 4

FREEZELESS YARD HYDRANT
SEE SHT. 4 FOR LOCATION

EQUIPMENT SCHEDULE

EQUIPMENT SCHEDULE						
SYMBOL	DESCRIPTION					
EF-1 (2 UNITS)	EXHAUST FAN: CARNES MODEL NO. LYDK COMPLETE WITH EXPLOSION PROOF MOTOR, WALL HOUSING, MOTOR SIDE GUARD, BACKDRAFT DAMPER, AND BIRD SCREEN.					
	CFM	DRIVE	HP	RPM	ELEC.: VOLT/PHASE	OPERATION
	550	DIRECT	1/6	1350	120/1	CONTINUOUS
SF-1	SUPPLY FAN: GREENHECK MODEL NO. B50-100-4 COMPLETE WITH EXPLOSION PROOF MOTOR, ISOLATORS, & MOTOR SIDE GUARD.					
	CFM	DRIVE	HP	RPM	ESP	ELEC.: VOLT/PHASE
	1000	BELT	1/4	1335	0.0125	120V/1ph
						CONTINUOUS
ES-1	<u>EMERGENCY SHOWER</u> : REFER TO SPEC. SECTION 15440					
L-1	<u>LOUVER</u> : CARNES FLGA 24"x24"H W/GRAVITY BACKDRAFT DAMPER, AND BIRDSCREEN. 1.8SF MIN. FREE AREA					

CITY PROJECT #567292



COUNTY OF BERNALILLO
ENVIRONMENTAL HEALTH AND
PUBLIC WORKS DEPARTMENTS


**NORTH VALLEY AREAS B AND F
VACUUM STATION**

**MECHANICAL PLAN & SECTIONS
SECTIONS & DETAILS**


PROJECT NO. 96034 SHEET 11 OF 19

AS-BUILT INFORMATION	
CONTRACTOR	TRAD BUILDERS OF NM
DATE	11/19/98
DESIGNED BY	WILSON & CO.
DATE	11/20/98
DRAWN BY	WILSON & CO.
DATE	11/20/98
CHECKED BY	WILSON & CO.
DATE	11/20/98
RECORDED BY	WILSON & CO.
DATE	11/20/98


SURVEY INFORMATION	
FIELD NOTES	DATE
NO.	BY

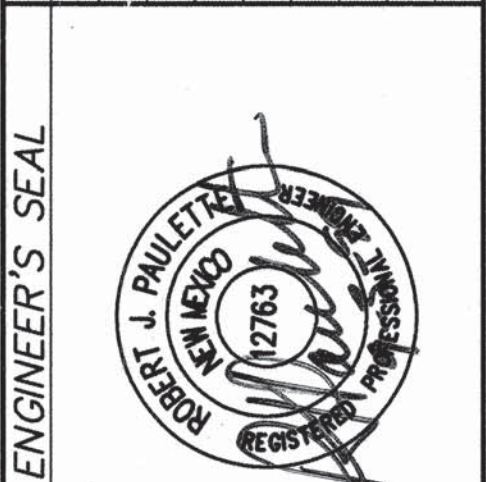


ENGINEER'S SEAL	
2	1/30/00
TEXT EDIT	100
REVISIONS	REMARKS
NO.	DATE
1	19/3/99
RELOCATION PUMP STATION	RJP
BY	DATE
WILSON & COMPANY, ENGINEERS & ARCHITECTS	DATE 11/20/98
DESIGNED BY RJP	DATE 11/20/98
DRAWN BY RPS	DATE 11/20/98
CHECKED BY RJP	DATE 11/20/98

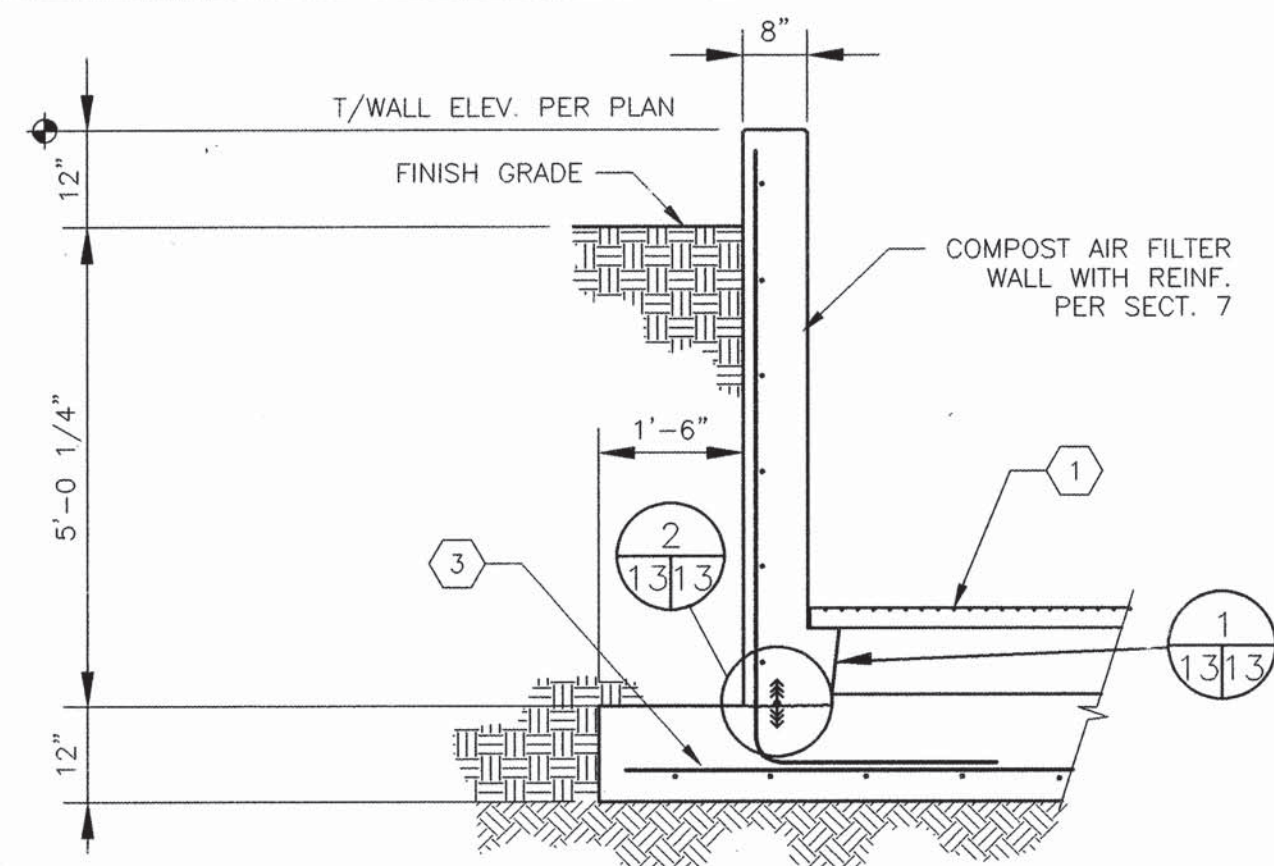


16 SECTION AT COMPOST AREA WALL
1/2" = 1'-0"

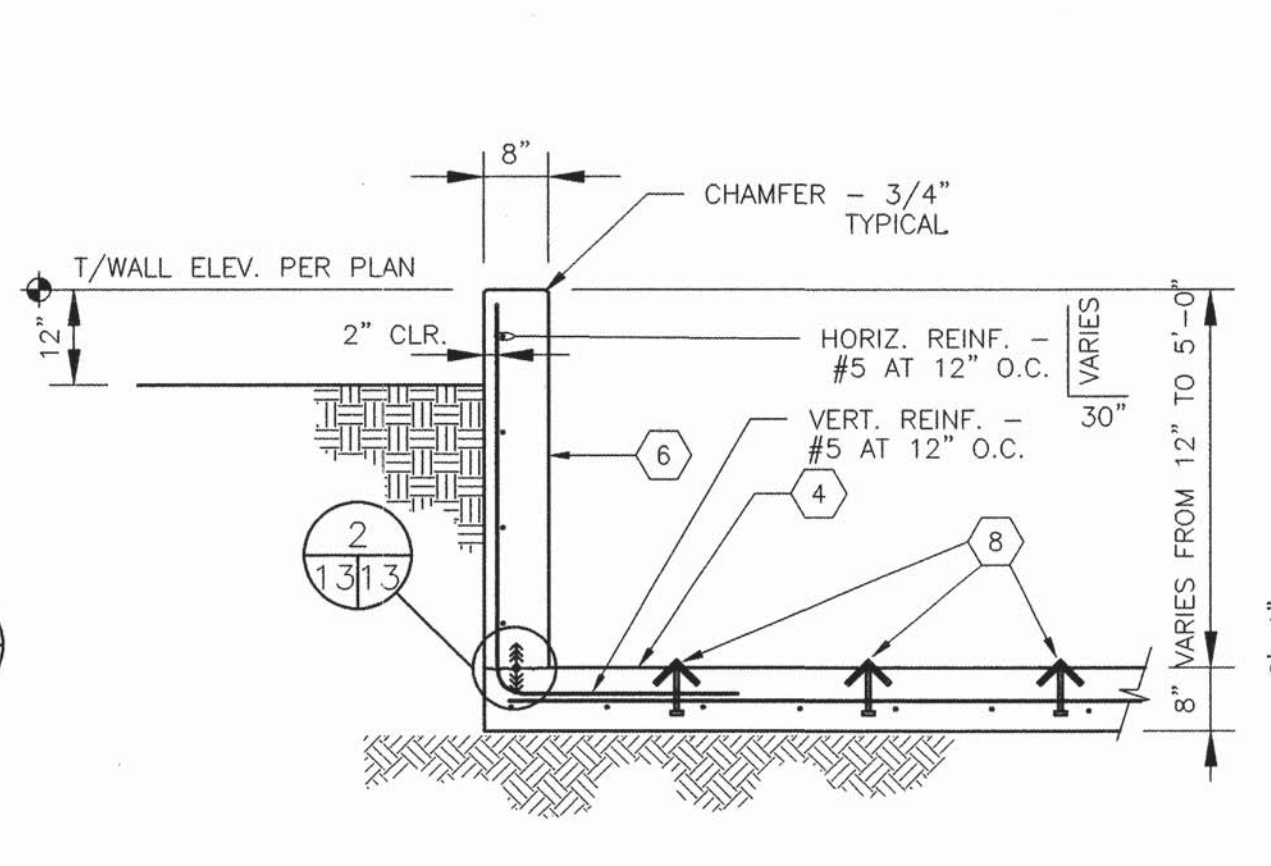


17 SECTION AT RAMP WALL
1/2" = 1'-0"

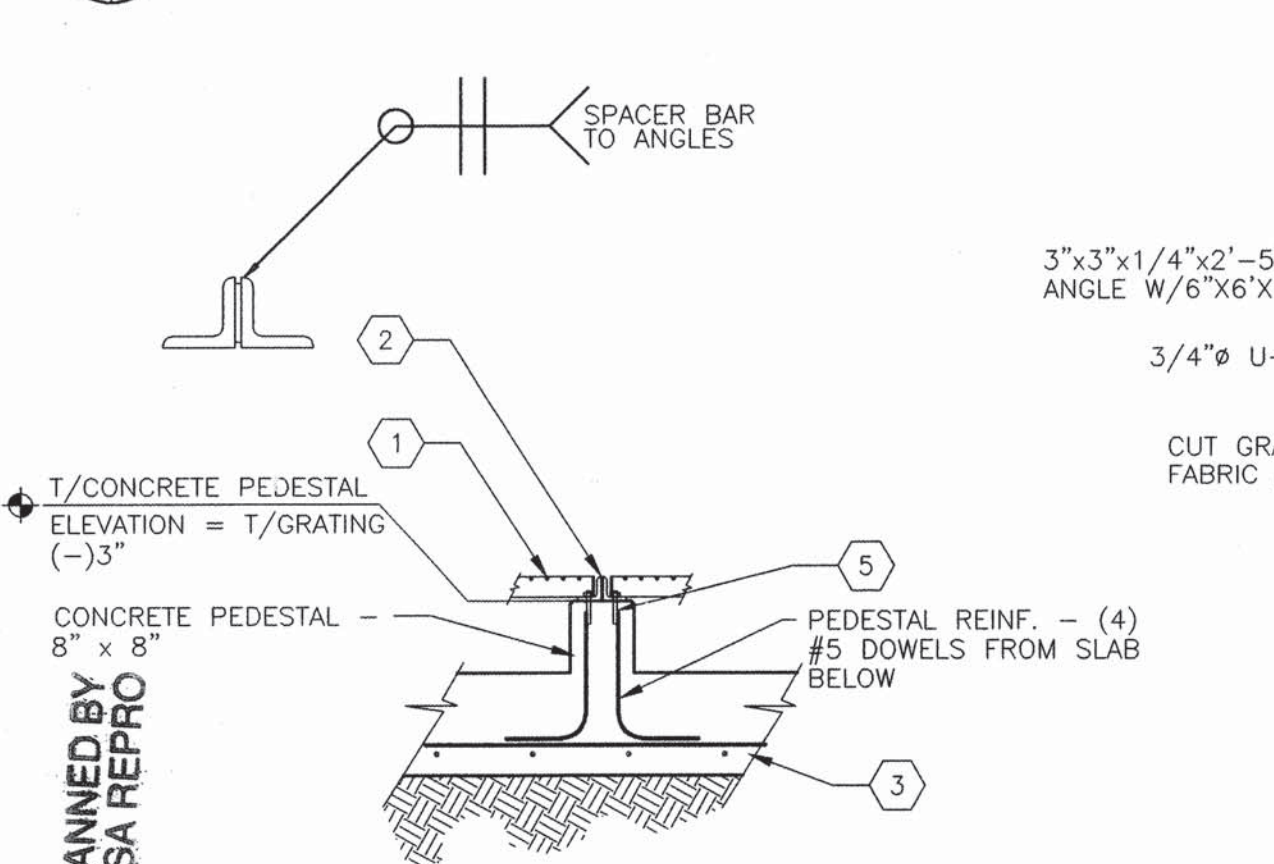


11 SECTION AT SUPPORT PEDESTAL
1/2" = 1'-0"

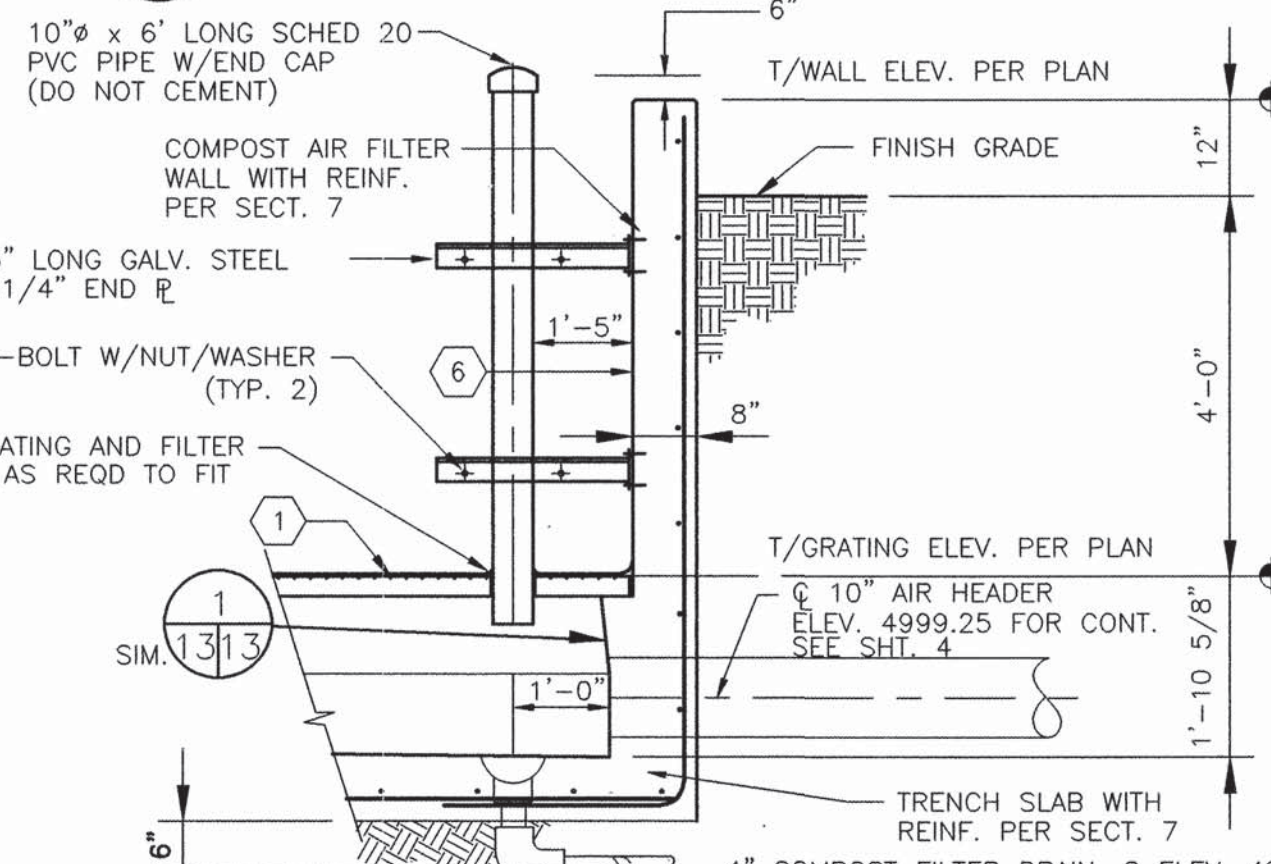


12 SECTION AT TRENCH
1/2" = 1'-0"

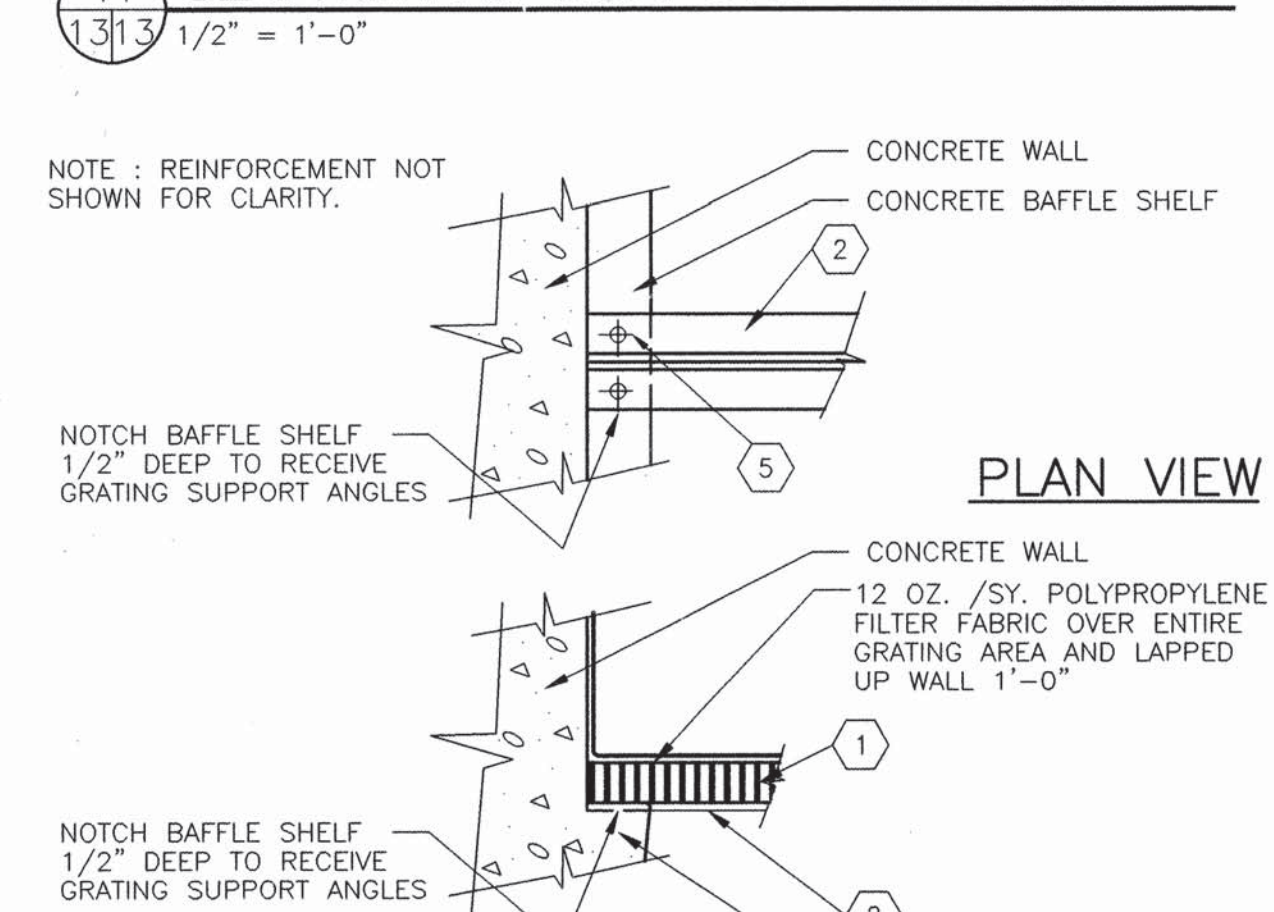


6 SECTION AT ANGLE BEARING
1" = 1'-0"

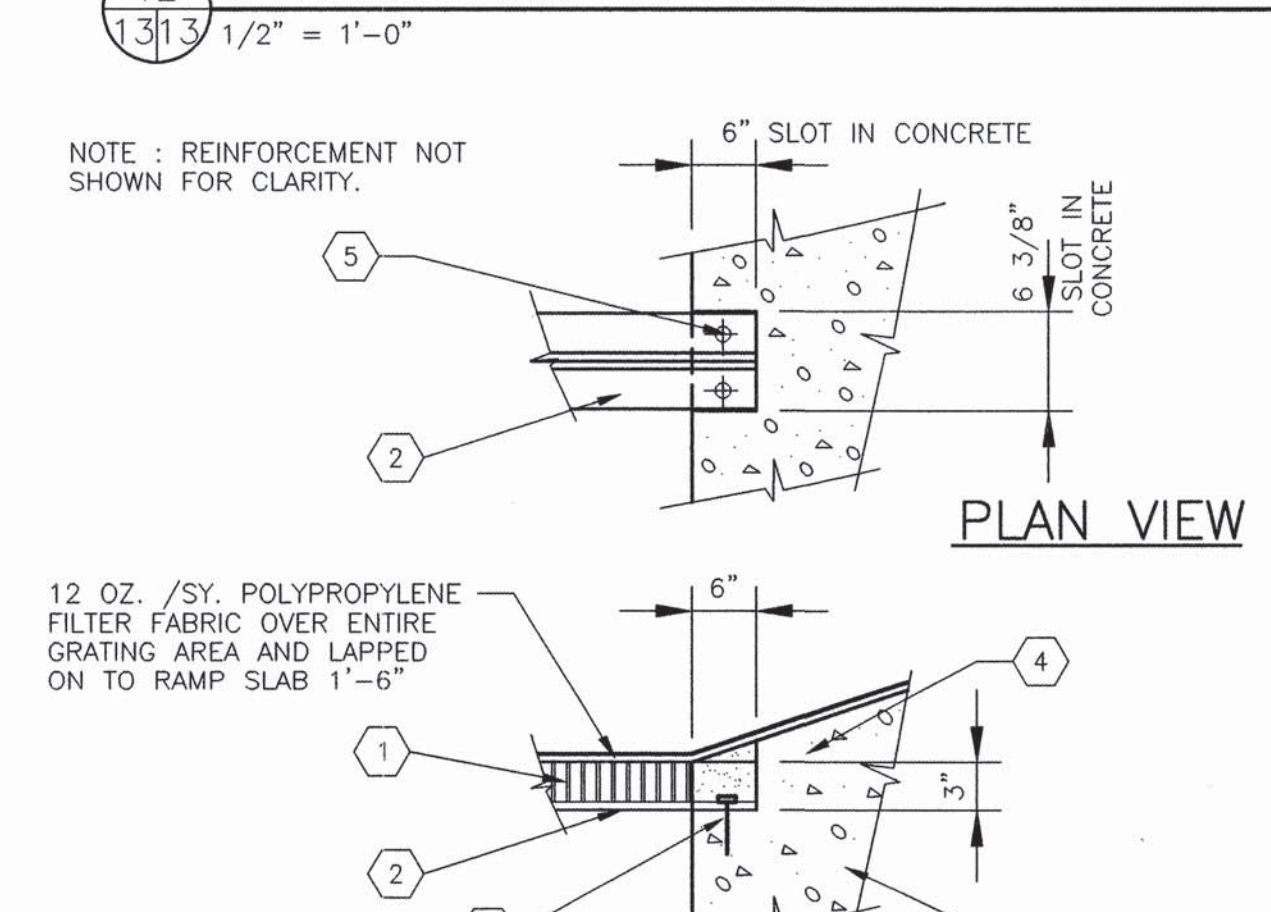


7 SECTION AT ANGLE BEARING
1" = 1'-0"

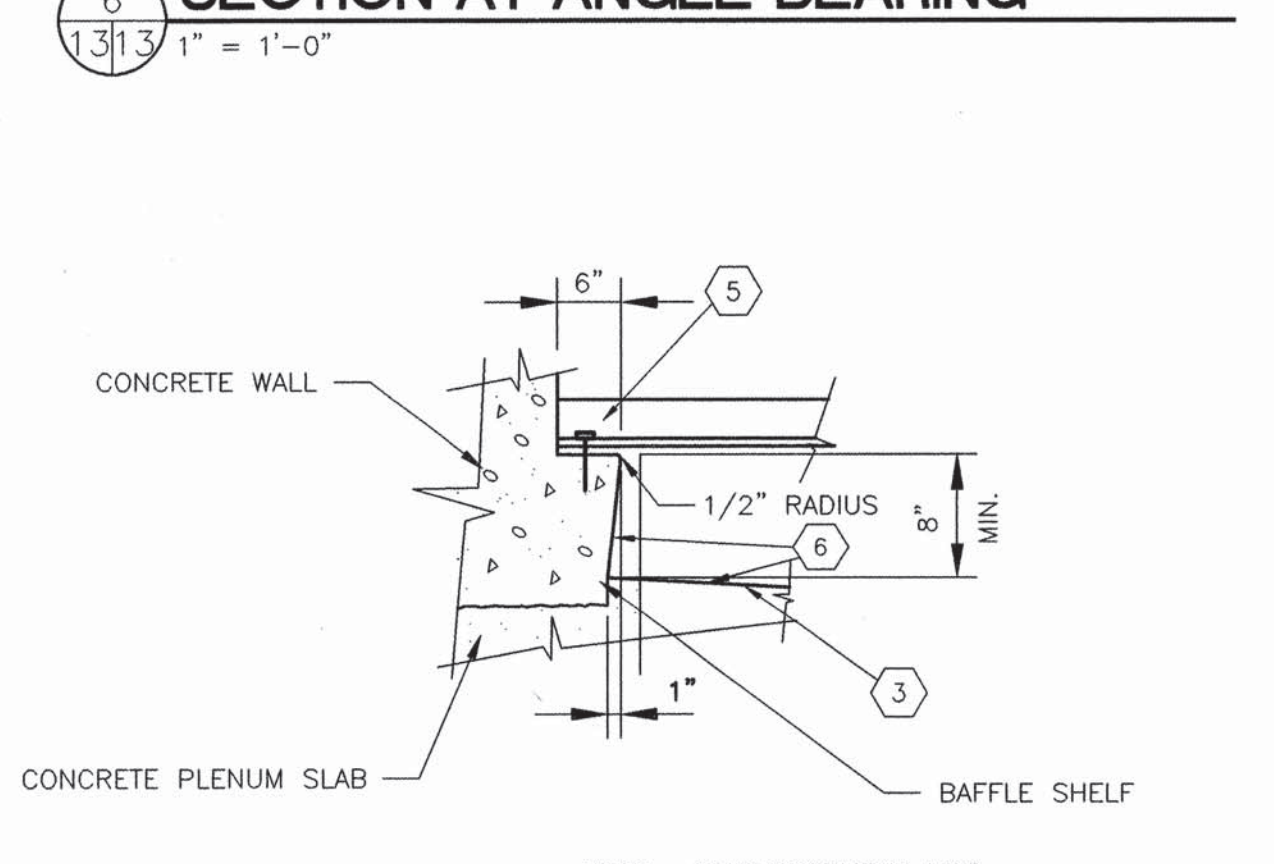


1 SECTION AT BAFFLE SHELF
1" = 1'-0"

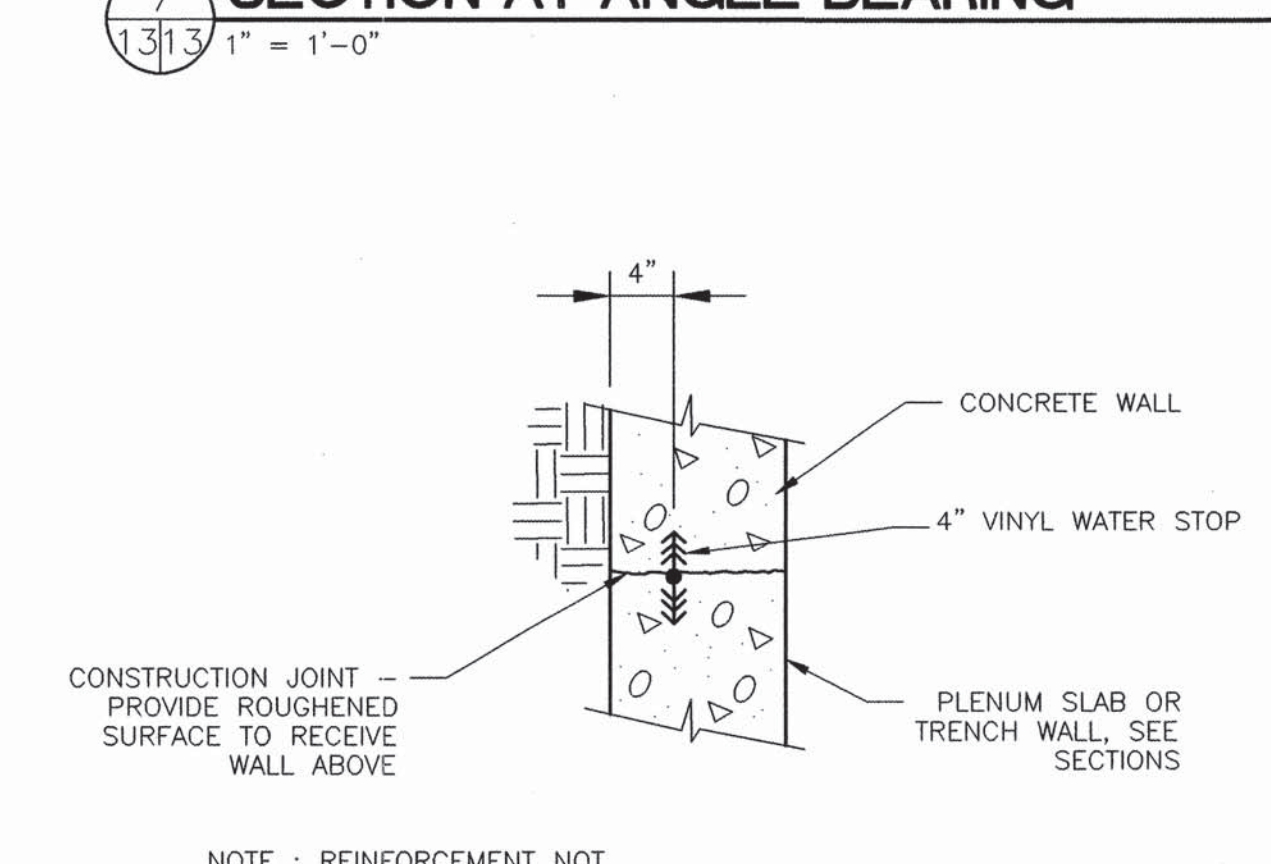

2 SECTION AT WATER STOP
1" = 1'-0"

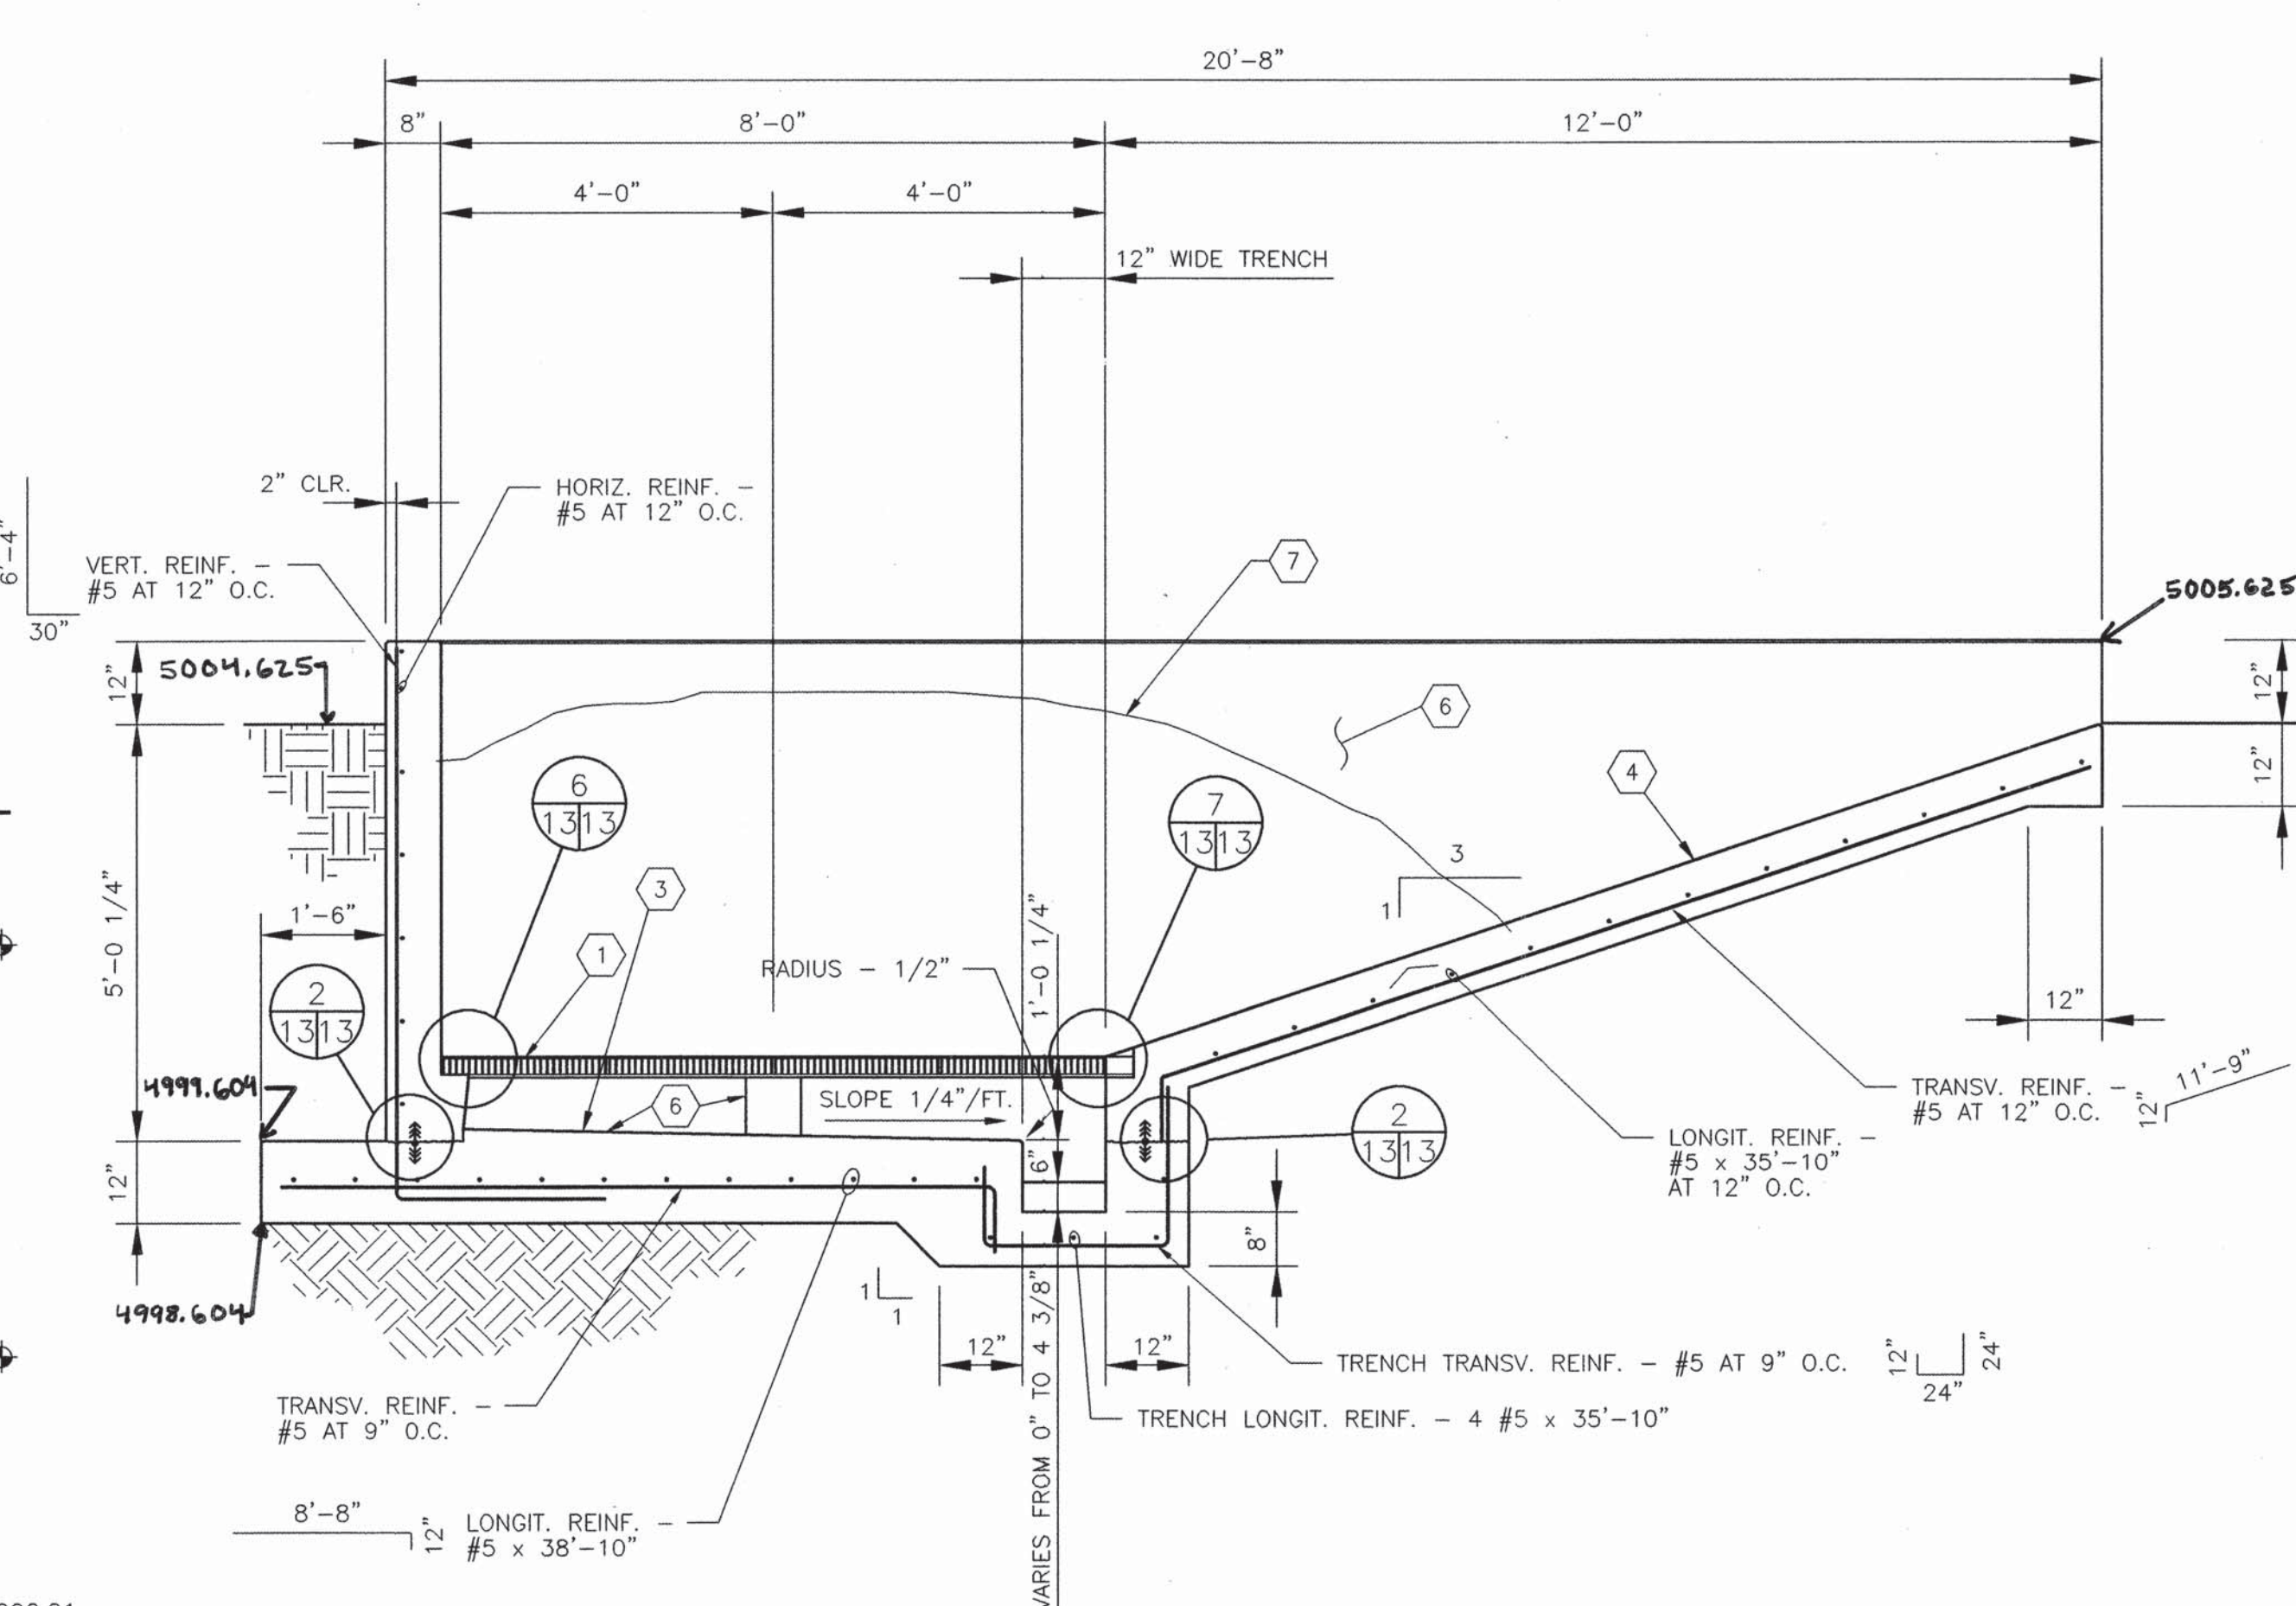

13 SECTION - TRANSVERSE
1/2" = 1'-0"

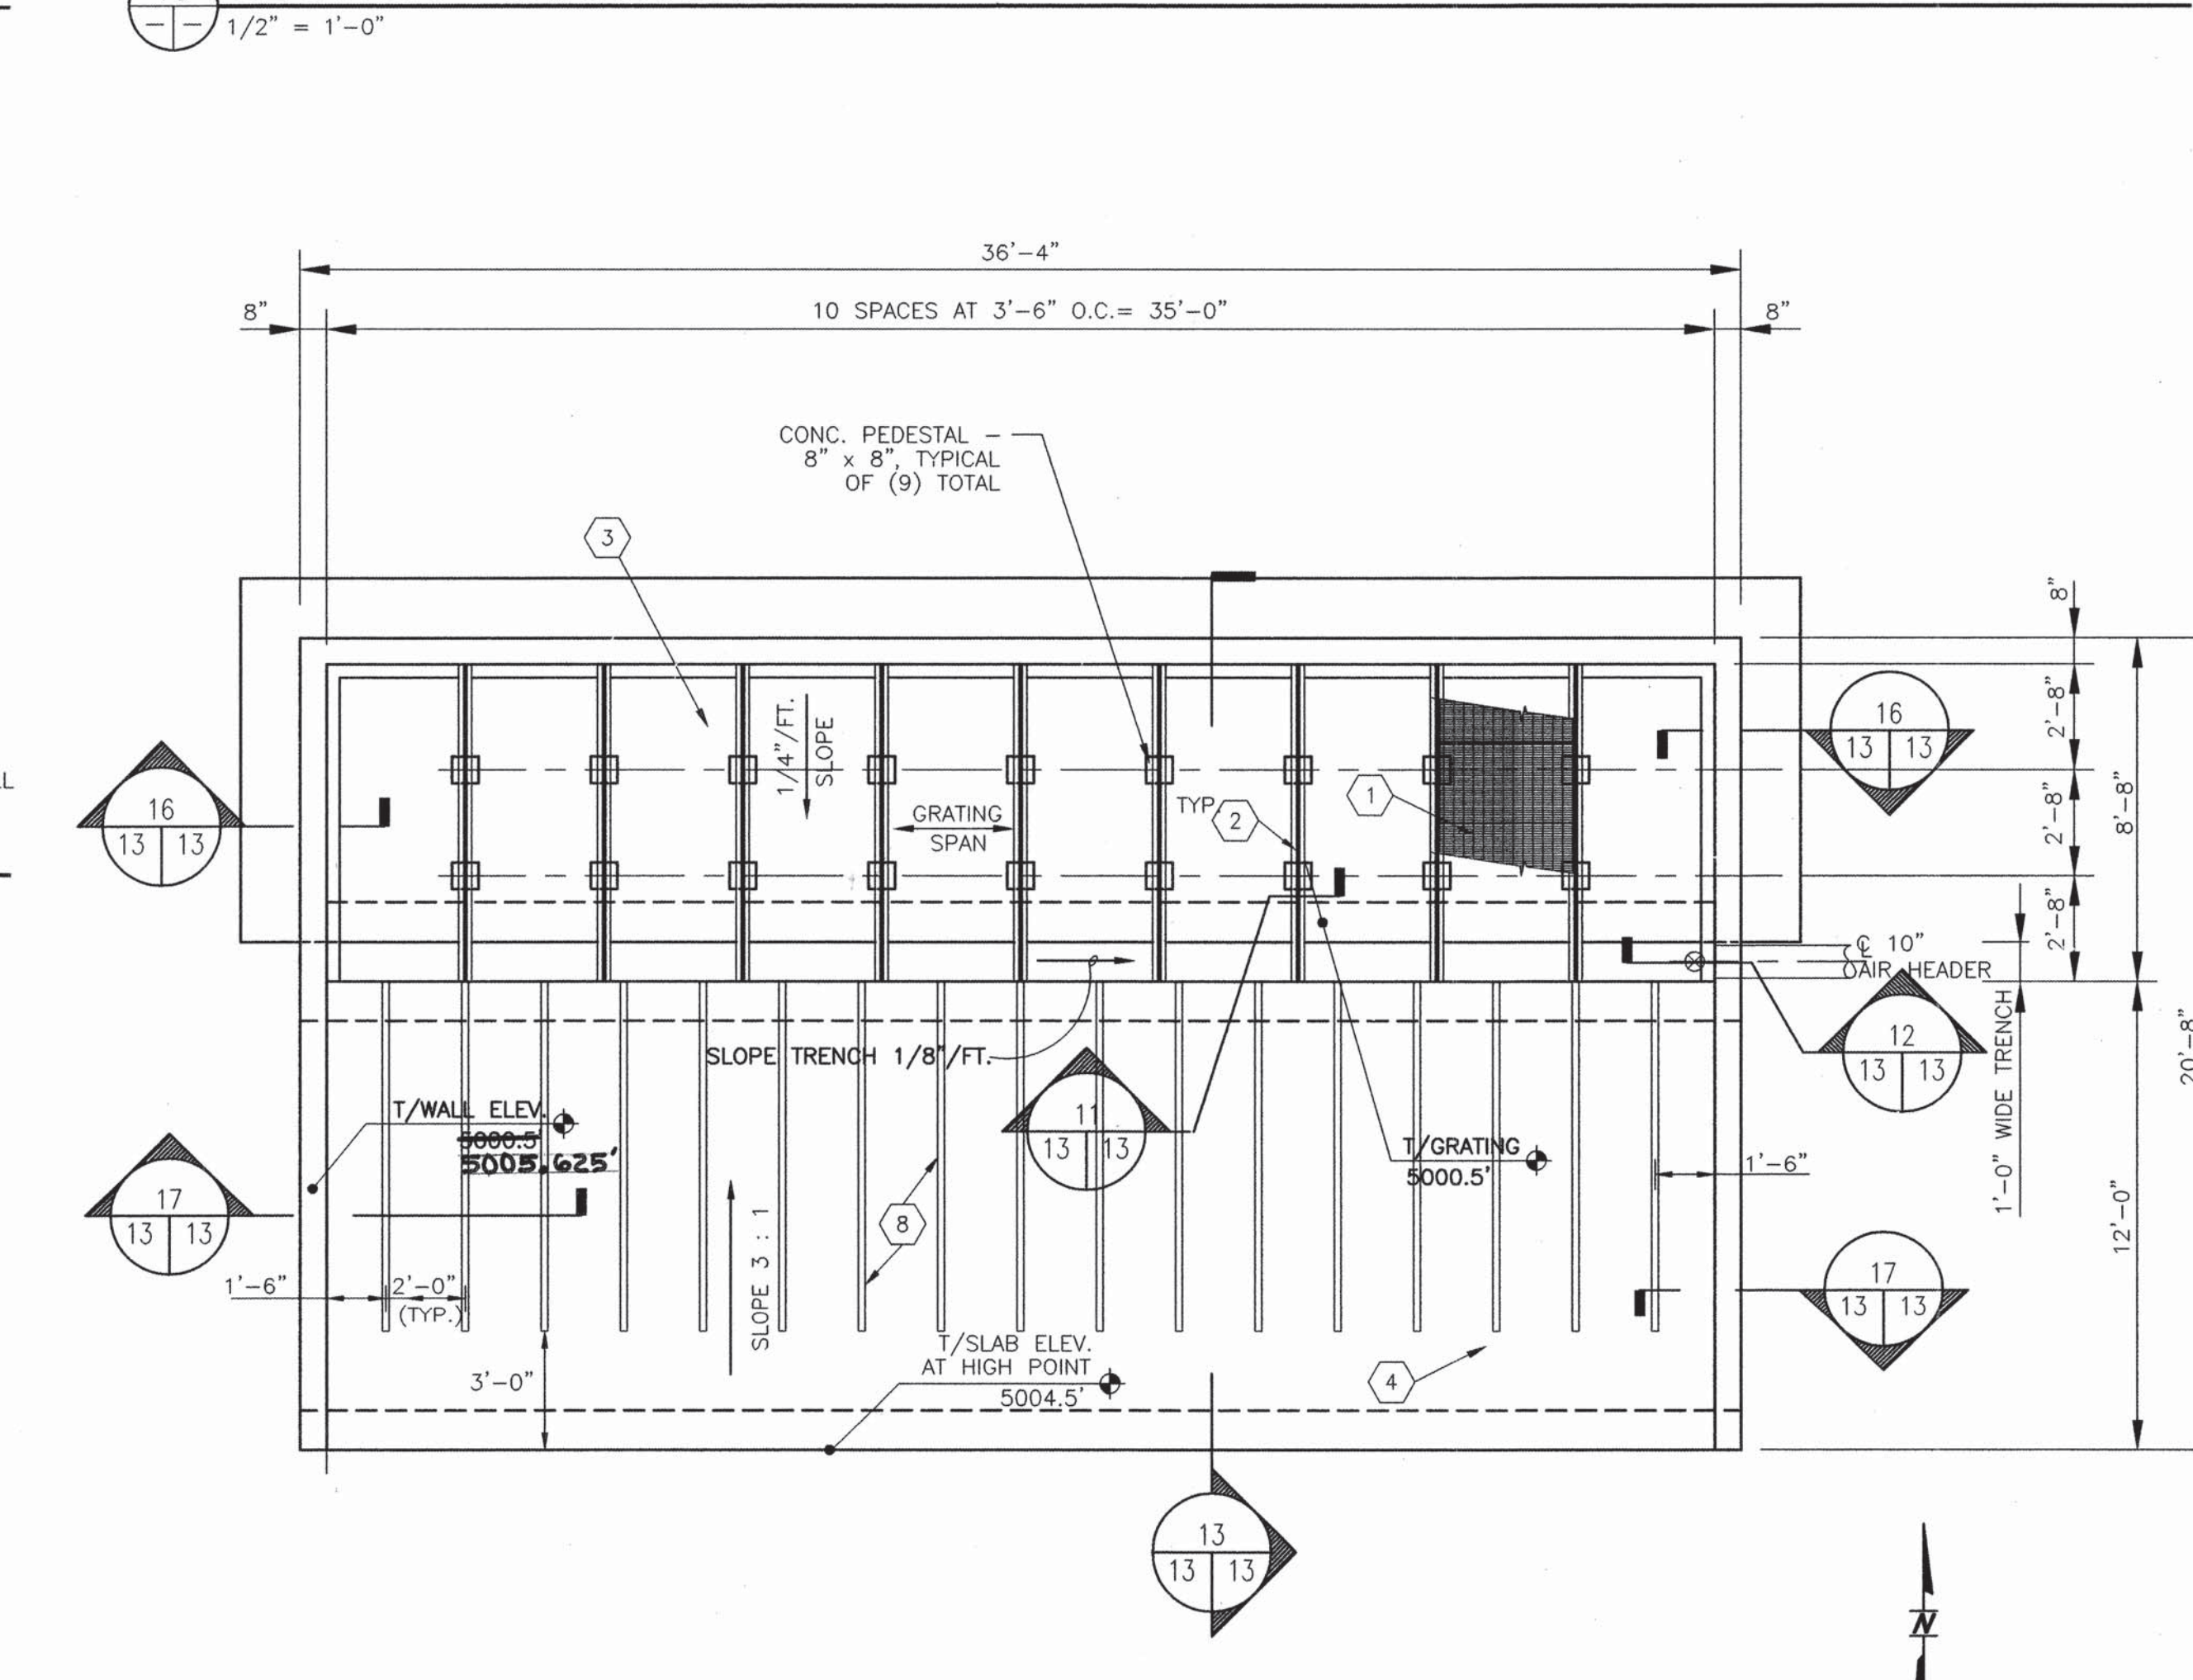

PLAN - COMPOST AIR FILTER
1/4" = 1'-0"

GENERAL SHEET NOTES :

- FOR PIPE SIZES AND LOCATIONS, SEE EQUIPMENT PLAN, SECTIONS AND DETAILS.
- COMPOST AIR FILTER LOCATION SHALL BE SITE PLAN.
- REFER TO GENERAL NOTES ON SHEET 2 FOR CONCRETE AND CONCRETE REINFORCEMENT INFORMATION.
- REFER TO SHEET 2 FOR TYPICAL CONCRETE CORNER DETAILS.
- REFER TO SHEET 2 FOR ADDITIONAL REINFORCEMENT AT TYPICAL CONCRETE WALL PENETRATION.

SHEET KEYED NOTES : (XX)

- GRATING TYPE 2
- ALUMINUM ANGLE - DOUBLE L 3 x 3 x 1/2, BACK TO BACK WITH SPACER BAR - 1/4 x 2 1/2 x 2 1/2 AT 12" O.C. MAXIMUM BETWEEN AND AT EACH ENDS, PROVIDE 1/16" THICK NEOPRENE GASKET AT ALL ANGLE TO CONCRETE BEARING LOCATIONS
- CAST-IN-PLACE CONCRETE PLENUM SLAB - 1'-0" THICK MINIMUM
- CAST-IN-PLACE RAMP SLAB - 8" THICK
- PROVIDE CHEMICAL ANCHORS - STAINLESS STEEL THREADED ROD - 1/2" DIAMETER - 4' LONG - W/ 3" EMBEDMENT - EACH ANGLE AT CONCRETE BEARING EMBEDDED IN CONC.
- BITUMASTIC EPOXY COATING ALL INTERIOR SURFACES.
- COMPOST - SEE NOTE BELOW
- 3" x 3" x 9'-0" GALV. ANGLE WITH 3/4" x 3" LONG BOLT ANCHORS @ 1'-0" O.C. EXPOSE ANGLE 1" ABOVE FINISHED SLAB. BEVEL ENDS OF ANGLE IRON PRIOR TO EMBEDMENT.

INSTALLED 60

NOTE: ~~INSTALL 60~~ C.Y. OF COA-FURNISHED COMPOST AND PLACE PER COA STAFF DIRECTION. COMPOST IS AVAILABLE FOR PICKUP AT CITY COMPOSTING FACILITY NEAR DOUBLE EAGLE II AIRPORT.

CITY PROJECT #567292

COUNTY OF BERNALILLO
ENVIRONMENTAL HEALTH AND
PUBLIC WORKS DEPARTMENTS

**NORTH VALLEY AREAS B AND F
VACUUM STATION**


COMPOST FILTER
PLAN, SECTIONS, & DETAILS

PROJECT NO. 96034 SHEET 13 OF 19

WILSON & COMPANY

X: \PUBLIC\PROJECTS\96034\DRAWINGS\VACSTA\STRUCT\6034VS-SHT13-9-1-99.DWG


ONE LINE DIAGRAM LEGEND

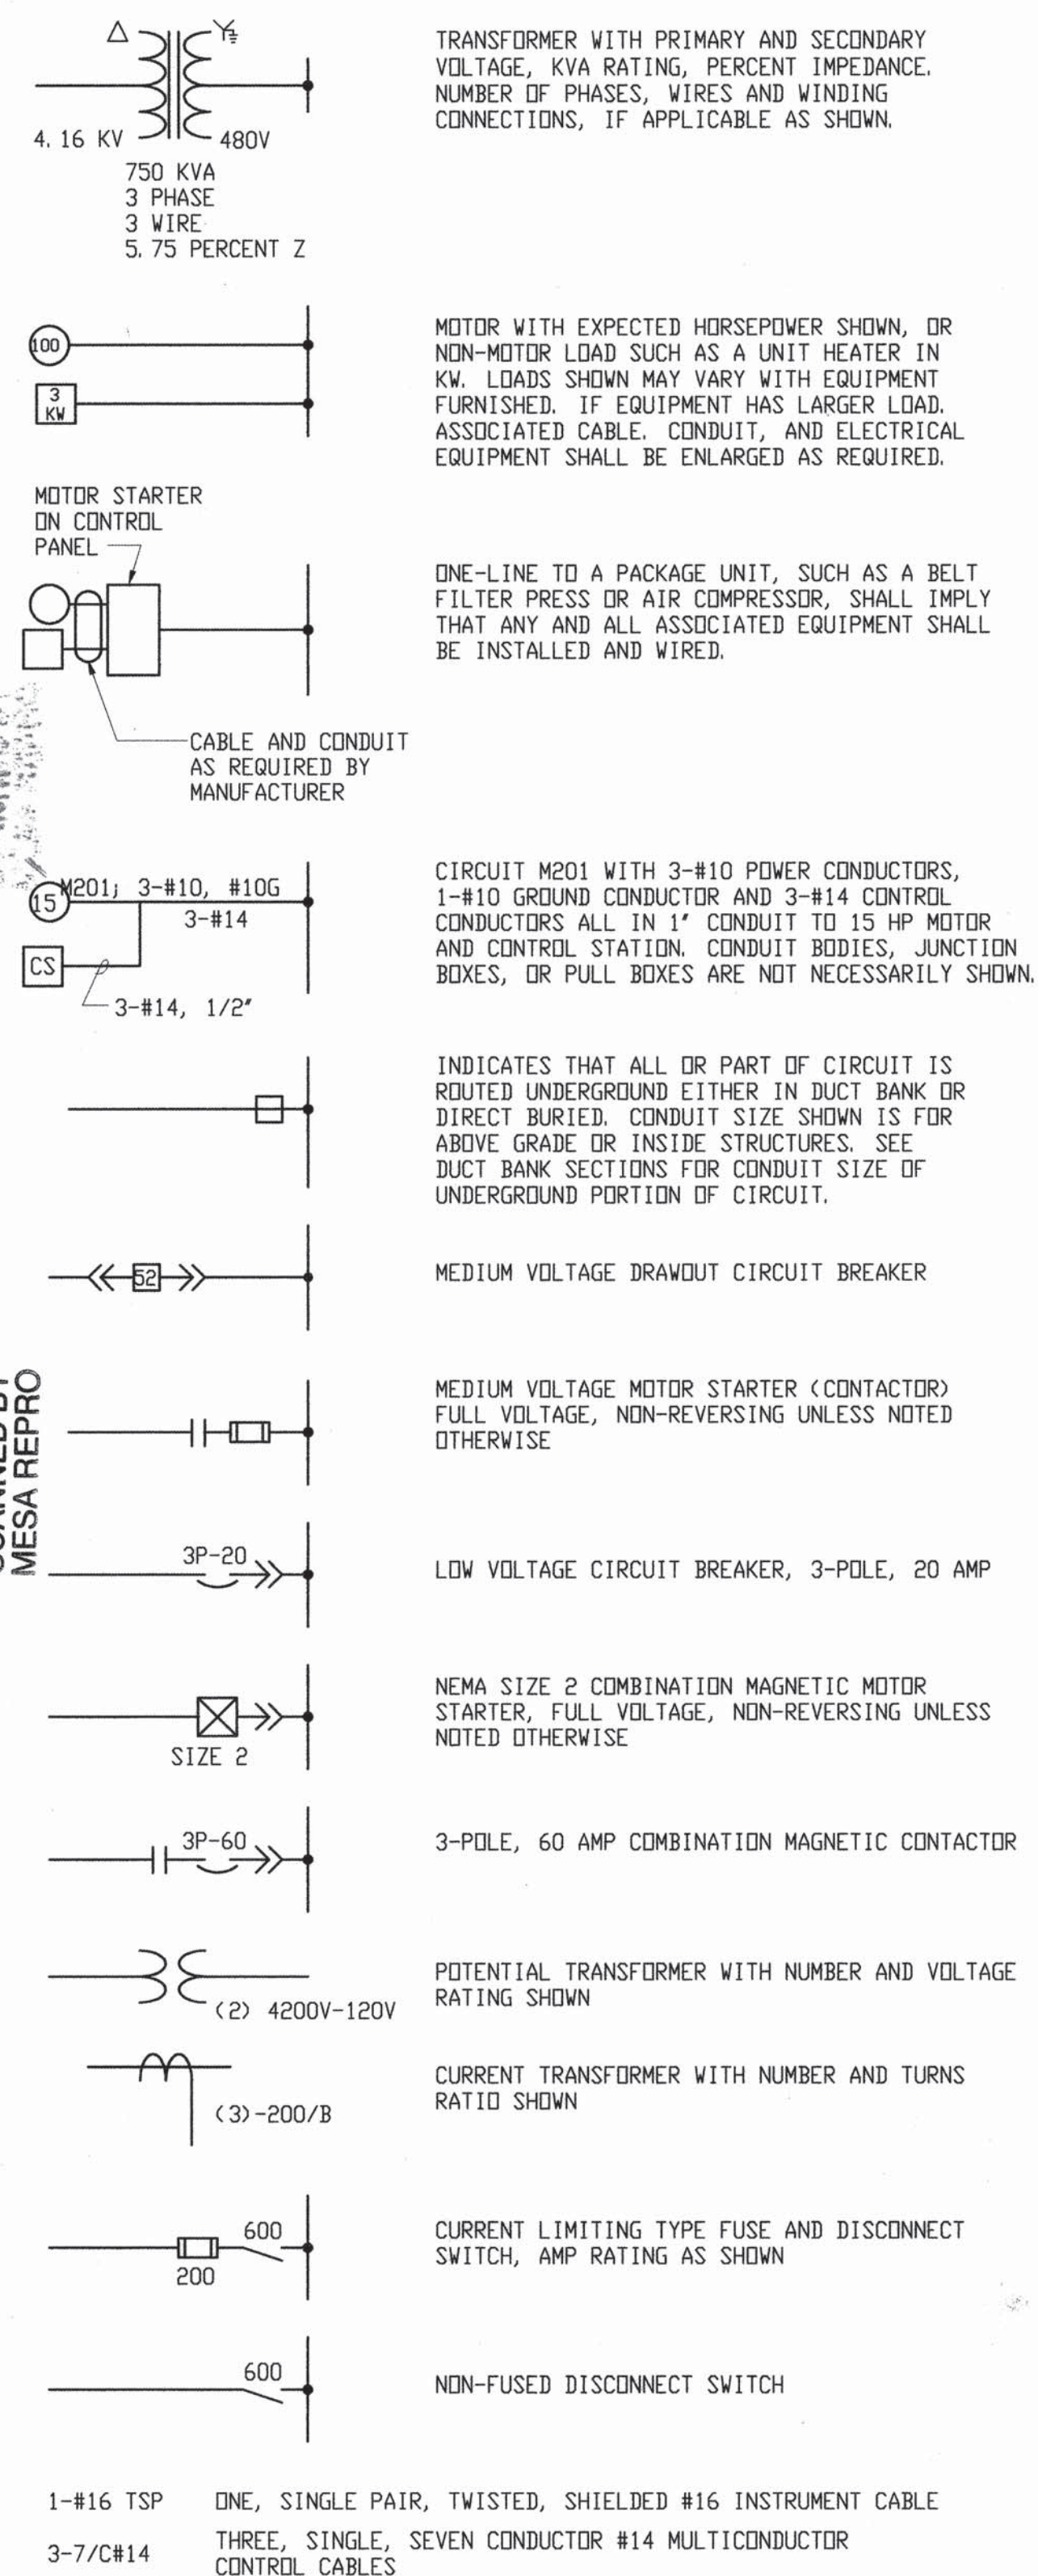


GENERAL NOTES

- IN GENERAL CONDUIT ROUTING IS NOT SHOWN ON THE PLANS. THE CONTRACTOR SHALL BE RESPONSIBLE FOR ROUTING ALL CONDUITS INCLUDING THOSE SHOWN ON ONE-LINES AND HOMERUNS. SEE SPECIFICATIONS FOR CONDUIT INSTALLATION REQUIREMENTS. CONDUIT ROUTING AND STUB-UP LOCATIONS THAT ARE SHOWN ARE APPROXIMATE. EXACT ROUTINGS SHALL BE AS REQUIRED FOR EQUIPMENT FURNISHED.
- HEAVY LINES INDICATE NEW WORK OR EQUIPMENT FOR THIS CONTRACT. LIGHT LINES INDICATE EXISTING EQUIPMENT OR WORK UNDER ANOTHER CONTRACT. DASHED LINES INDICATE FUTURE WORK OR EQUIPMENT.
- THIS IS A GENERAL LEGEND AND ABBREVIATIONS SHEET, SOME SYMBOLS AND ABBREVIATIONS MAY NOT BE UTILIZED ON THIS SPECIFIC PROJECT.


SCHEMATIC SYMBOLS

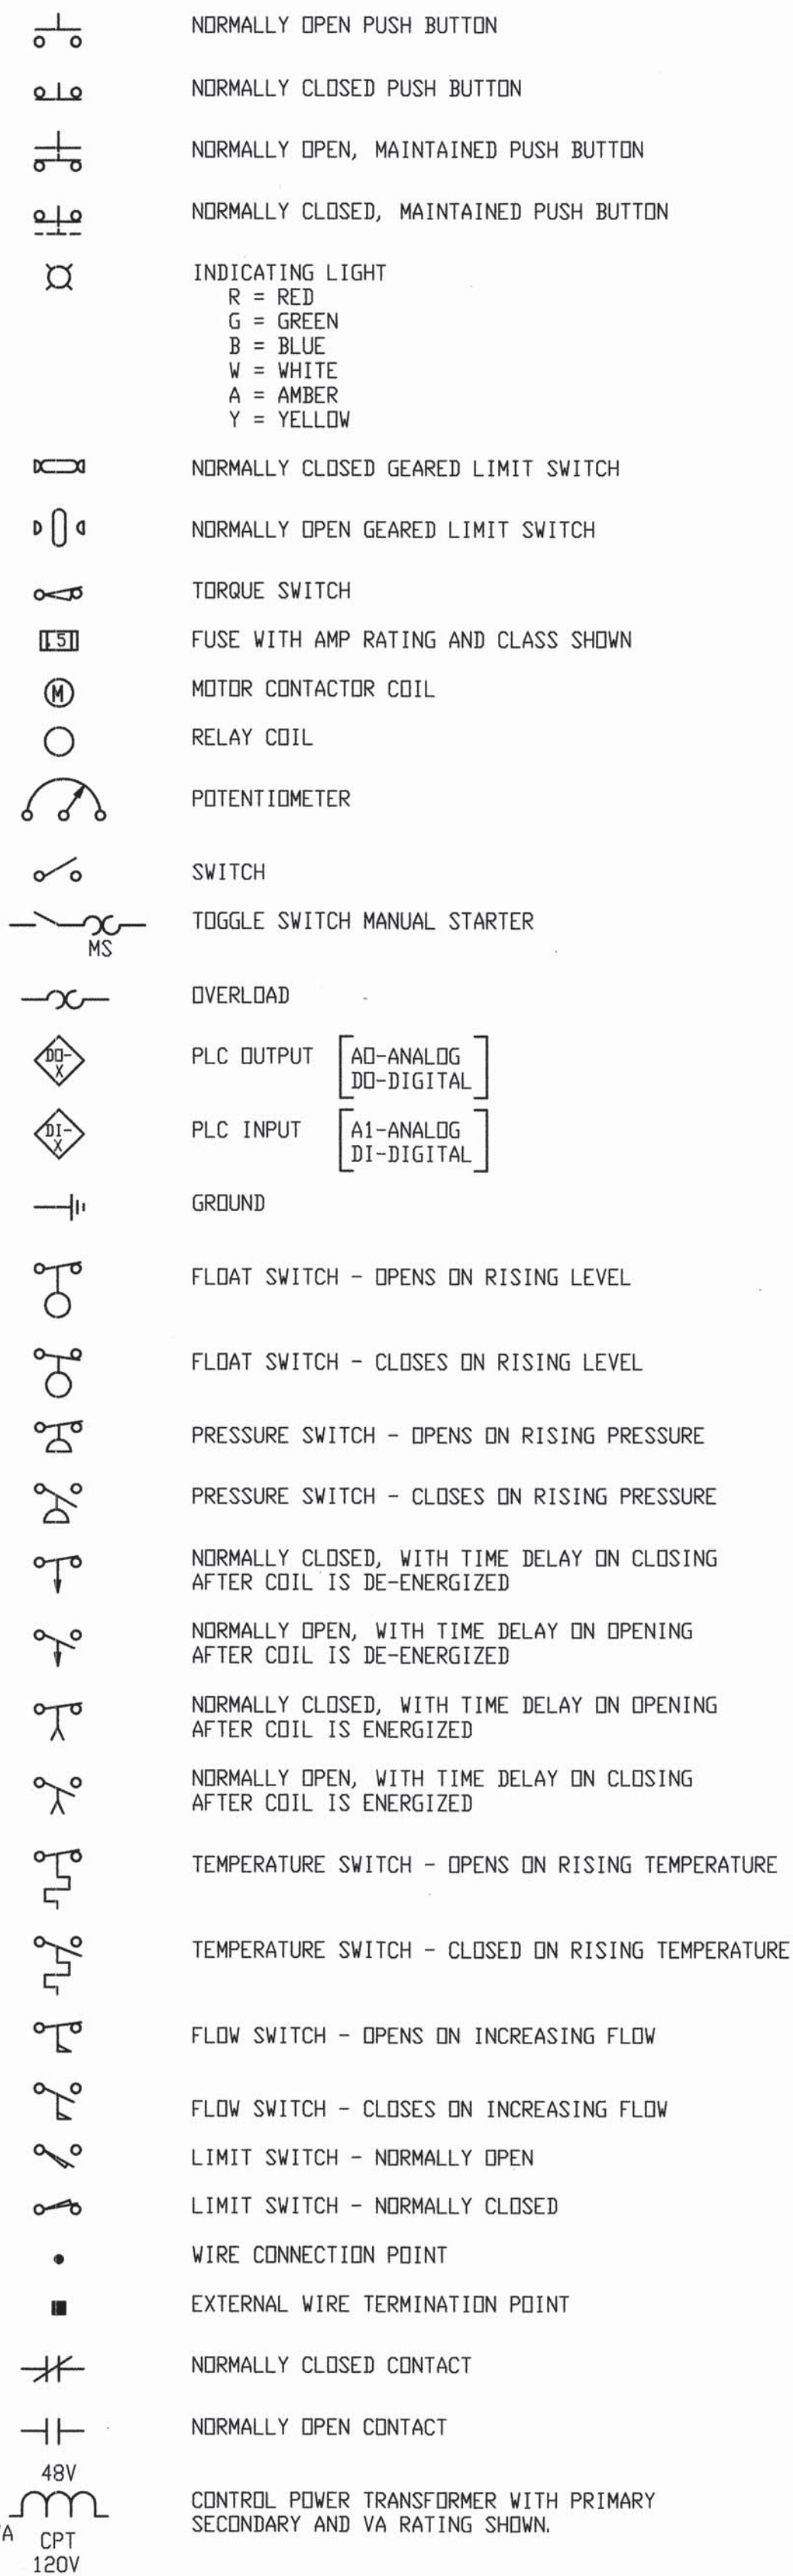

CONDUIT AND WIRING INSTALLATION

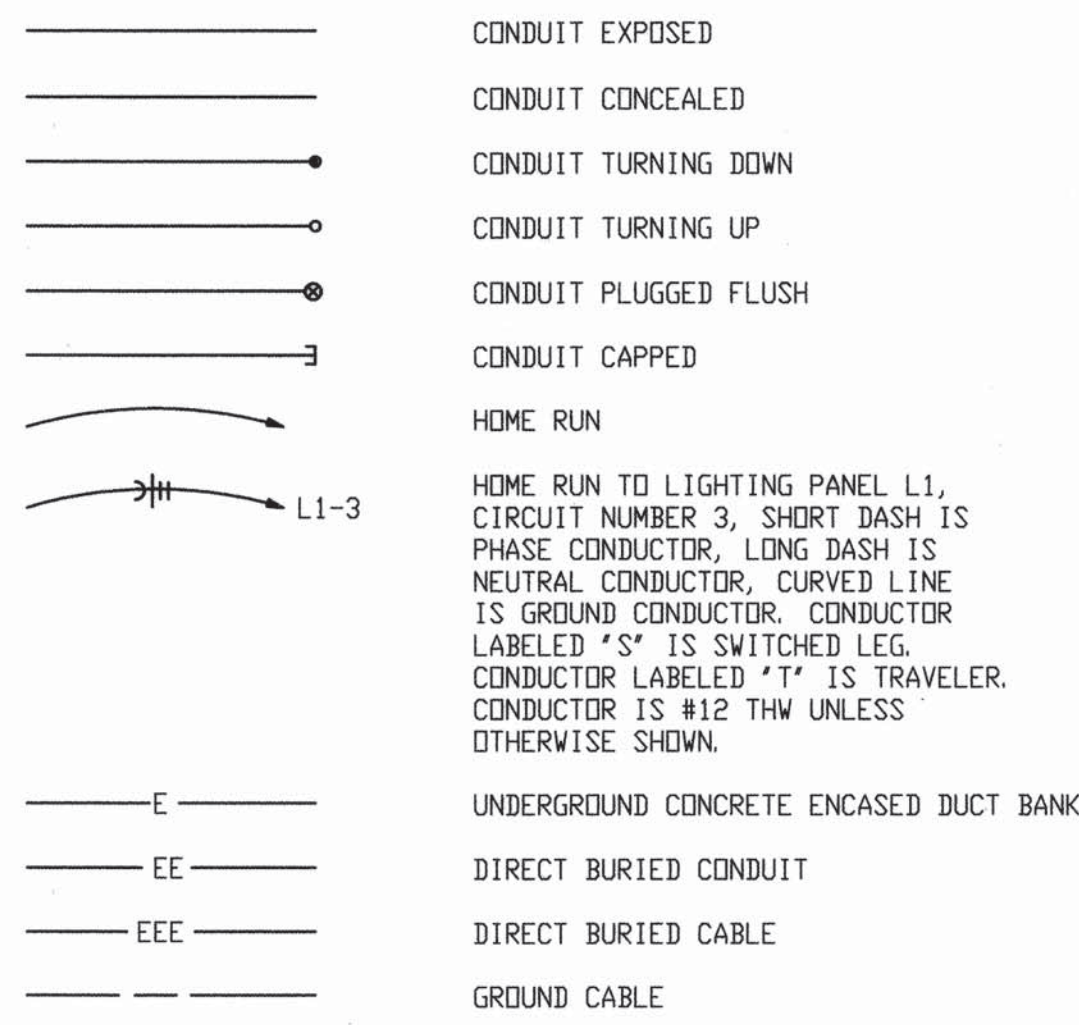

MISCELLANEOUS PLAN SYMBOLS

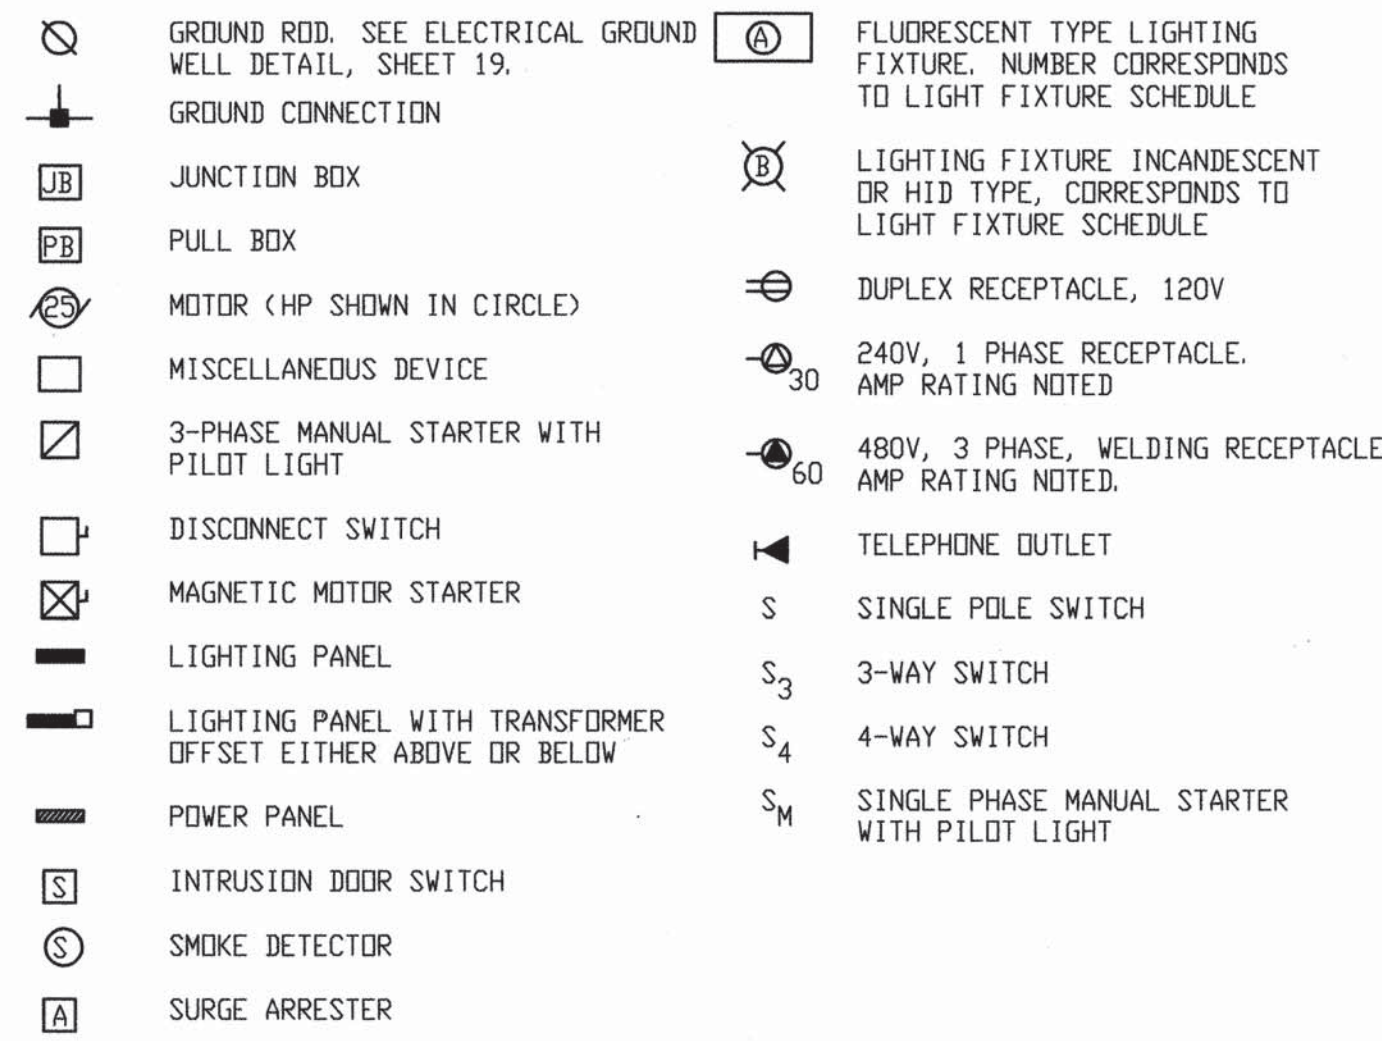

ABBREVIATIONS

A	AMPERE, ALARM	M	MAGNETIC MOTOR STARTER
AC	ALTERNATING CURRENT	MA	MILLIAMPERE
ACB	AIR CIRCUIT BREAKER	MCC	MOTOR CONTROL CENTER
AFD	ADJUSTABLE FREQUENCY DRIVE	MCLU	MOTOR CONTROL LINEUP
AM	AMMETER	MD	MOISTURE DETECTOR
ANN	ANNUNCIATOR	MFM	MAGNETIC FLOW METER
AR	ALARM RELAY	MFR	MANUFACTURER
AS	AMMETER SWITCH	MH	MANHOLE OR MOUNTING HEIGHT
AWG	AMERICAN WIRE GAGE	MDG	MOTOR OPERATED GATE
		MDV	MOTOR OPERATED VALVE
BC	BATTERY CHARGER	MS	MANUAL MOTOR STARTER
BT	BEARING TEMPERATURE	MSH	MOTOR SPACE HEATER
		MV	MILLIVOLT
		MVA	MEGAVOLT AMPERE
C	CLOSE, COUNTER OR CONTACTOR		
CB	CIRCUIT BREAKER	N	NEUTRAL
CB'a'	CIRCUIT BREAKER AUXILIARY CONTACT (OPEN WHEN BREAKER IS OPEN AND CLOSED WHEN BREAKER IS CLOSED OR TRIPPED)	NC	NORMALLY CLOSED
CB'b'	CIRCUIT BREAKER AUXILIARY CONTACT (CLOSED WHEN BREAKER IS OPEN AND OPEN WHEN BREAKER IS CLOSED OR TRIPPED)	NO	NORMALLY OPEN, NUMBER
		O	OPEN
CI	CELL INTERLOCK	OL	OVERLOAD
CKT	CIRCUIT	P	PRIMARY
CL2	CHLORINE	PB	PUSHBUTTON OR PULL BOX
CDS	CABLE OPERATED SWITCH	PE	PHOTOELECTRIC
CP	CONTROL PANEL	PF	POWER FACTOR METER
CPT	CONTROL POWER TRANSFORMER	PH	PHASE, CHEMICAL TERM
CR	CONTROL RELAY	PLC	PROGRAMMABLE LOGIC CONTROLLER
CS	CONTROL STATION	PRV	POWER ROOF VENTILATOR
CT	CYCLE TIMER OR CURRENT TRANSFORMER	PRXS	PROXIMITY SWITCH
CTC	CYCLE TIMER CLUTCH	PS	PRESSURE SWITCH
CTM	CYCLE TIMER MOTOR	PT	POTENTIAL TRANSFORMER, PROGRAM
2/C	2 CONDUCTOR	2P	2-POLE
4/C	4 CONDUCTOR		
		R	RAISE, RELAY OR REVERSE
DC	DIRECT CURRENT	RECP	RECEPTACLE
DI	DOOR INTERLOCK	RT	REPEATING TIMER
DM	DAMPER MOTOR OR DEMAND METER	RTD	RESISTANCE TYPE TEMP DETECTOR
DPDT	DOUBLE POLE DOUBLE THROW	RTU	REMOTE TERMINAL UNIT
DPST	DOUBLE POLE SINGLE THROW		
DPR	DIFFERENTIAL PRESSURE REGULATOR	S2	SIZE 2 STARTER
DPS	DIFFERENTIAL PRESSURE SWITCH	SH	SPACE HEATER
DS	DISCONNECT SWITCH	SN	SOLID NEUTRAL
DVLS	DISCHARGE VALVE LIMIT SWITCH	SD	SOLENOID DILER
		SP	SINGLE POLE
EC	EMPTY CONDUIT	SPDT	SINGLE POLE DOUBLE THROW
EL	ELEVATION OR EMERGENCY LIGHT	SPST	SINGLE POLE SINGLE THROW
EMH	ELECTRICAL MANHOLE	SS	SELECTOR SWITCH
ER	ELECTRODE RELAY	SUPV	SUPERVISORY CONTROL
ES	END SWITCH	SV	SOLENOID VALVE
ETM	ELAPSED TIME METER	SWBD	SWITCHBOARD
EHM	ELECTRICAL HANDHOLE	SWGR	SWITCHGEAR
		T	THERMOSTAT, TIMER, OR TOTALIZER
F	FORWARD	TACH	TACHOMETER
FS	FLOW SWITCH	TB	TERMINAL BLOCK
		TD	TIME DELAY RELAY
G	GROUND	TDE	TIME DELAY AFTER ENERGIZATION
GD	GROUND DETECTOR	TDO	TIME DELAY AFTER DE-ENERGIZATION
GEN	GENERATOR	TEMP	TEMPERATURE
GFI	GROUND FAULT INTERRUPTER	THH	TELEPHONE HANDHOLE
GLS	GEARED LIMIT SWITCH	TM	TIMER MOTOR
#8G	#8 GROUND WIRE	TDS	TORQUE SWITCH
H	HIGH OR HUMIDISTAT	TTB	TELEPHONE TERMINAL BOX
HC	HOT CIRCUIT	TSP	TWISTED SHIELDED PAIR
H-O-A	HAND-OFF-AUTO		
H-O-R	HAND-OFF-REMOTE	UG	UNDERGROUND
HP	HORSEPOWER	UV	UNDER VOLTAGE, ULTRAVIOLET
HWCO	HIGH WATER CUTOFF	UPS	UNINTERRUPTIBLE POWER SUPPLY
HZ	HERTZ (CYCLE)		
		V	VOLTS
I/O	INPUT/OUTPUT	VA	VOLT AMPERE
		VAR	VARMETER
JB	JUNCTION BOX	VLS	VALVE LIMIT SWITCH
		VM	VOLTMETER
K	KEY INTERLOCK	VPI	VALVE POSITION INDICATOR
KCM	THOUSAND CIRCULAR MIL	VS	VOLTMETER SWITCH
KV	KILOVOLT		
KVA	KILOVOLT AMPERE	V	WATT
KVAR	KILOVAR	VH	WATT HOUR METER
KV	KILOWATT	WM	WATT METER
KWH	KILOWATT HOUR	WP	WEATHERPROOF
L	LOW LEVEL	X	AUXILIARY RELAY
LA	LIGHTNING ARRESTER	XFMR	TRANSFORMER
LC	LIGHTING CONTACTOR	XP	EXPLOSION-PROOF
L-O-R	LOCAL-OFF-REMOTE		
LP	LIGHTING PANEL	Z	AUXILIARY RELAY
LS	LIMIT OR LEVEL SWITCH	ZS	POSITION SWITCH
LWCO	LOW WATER CUTOFF		

CITY PROJECT #567292

BERNALILLO COUNTY

STATE OF NEW MEXICO

ENVIRONMENTAL HEALTH AND PUBLIC WORKS DEPARTMENTS

NORTH VALLEY AREAS B AND F VACUUM STATION

LEGEND/NOTES/ABBREVIATIONS

PROJECT NO. 96034

SHEET 15 OF 19

DATE 11/20/98

REVISIONS

DESIGNED BY JH

DRAWN BY

CHECKED BY

REMARKS



DATE 11/20/98

DATE 11/20/98

DATE 11/20/98

WILSON & COMPANY X:\PUBLIC\PROJECTS\96034\DRAWINGS\VACSTA\96034VS15.DWG

SCANNED BY
MESA REPRO

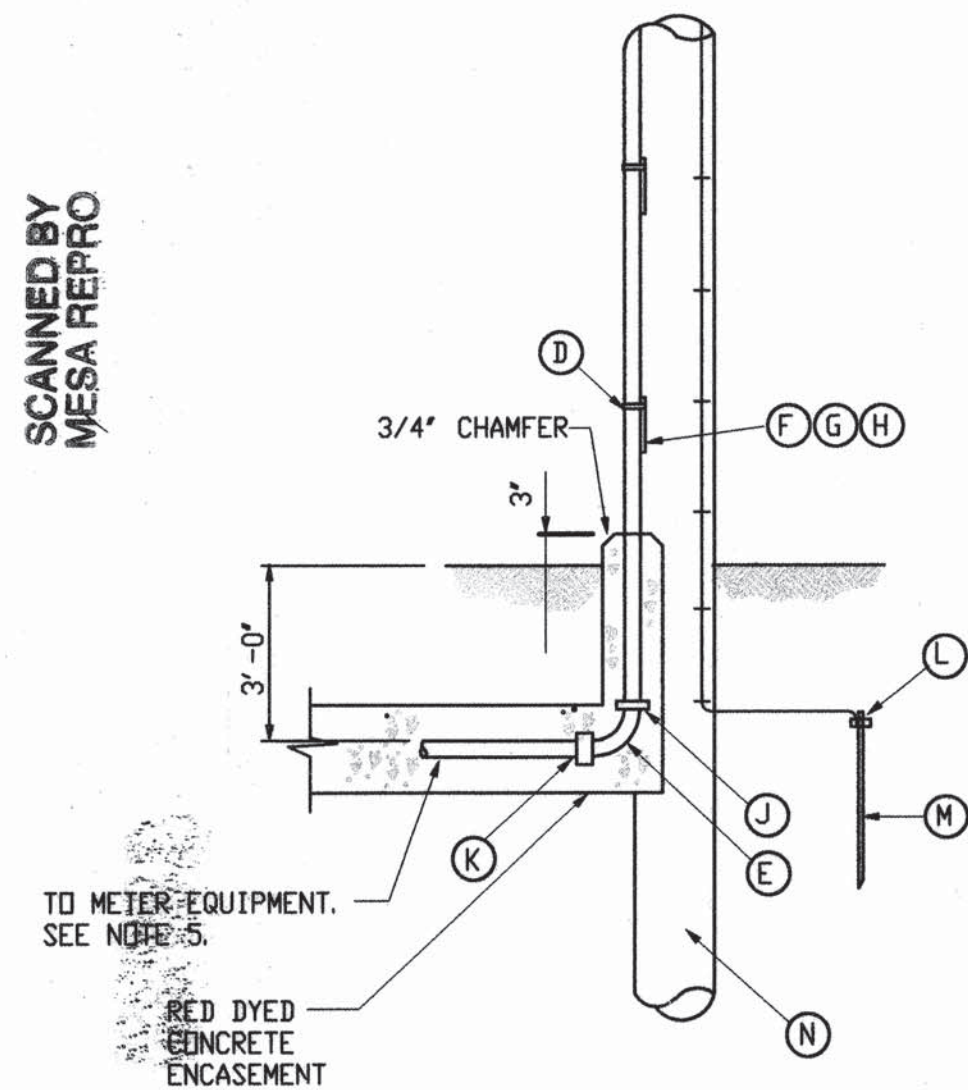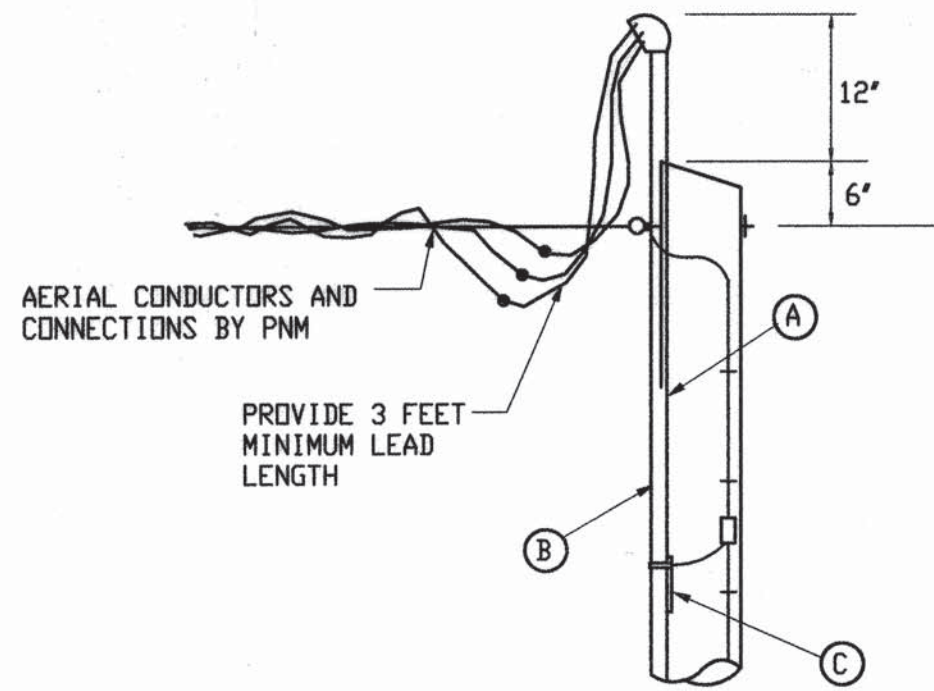

MATERIAL LIST	
ITEM	DESCRIPTION
A	CLAMP TYPE WH
B	GALVANIZED CONDUIT
C	UNIVERSAL SUPPORT BRACKET
D	PIPE STRAP KIT
E	PVC COATED RIGID METAL ELBOW
F	5/8" X MACHINE BOLT
G	5/8" LOCK NUT
H	2-1/4" SQ. WASHER
I	COUPLING
J	STEEL TO PLASTIC ADAPTOR
K	#10-#2 GROUND LUG
L	3/4" X 10' COPPERCLAD GROUND ROD
M	WOOD POLE, 35" CLASS 5


NOTES:

1. WEATHERHEAD SHALL BE 3' ABOVE NEUTRAL.
2. RISER BRACKET ASSEMBLY MUST HAVE PROVISIONS FOR GROUNDING.
3. CONTACT PNM CUSTOMER SERVICE FOR POLE QUADRANT.
4. ALL ABOVE-GRADE CONDUIT SHALL BE RIGID GALVANIZED OR IMC.
5. CONTRACTOR PROVIDES AND INSTALLS: CONDUIT, BRACKET, WEATHERHEAD, CONDUCTORS, METER BASE(S), METERING INSTRUMENT TRANSFORMER ENCLOSURE AND ALL MINOR FITTINGS.


REFERENCES TO PNM STANDARDS

- (1) SEE DS-4-95 UNDERGROUND COMMERCIAL CUSTOMER OWNED SERVICE.
SEE DS-18-13.0 UNIVERSAL SUPPORT BRACKET.
SEE DS-18-20.1 GROUND ASSEMBLY.


SERVICE RISER POLE DETAIL
NOT TO SCALE

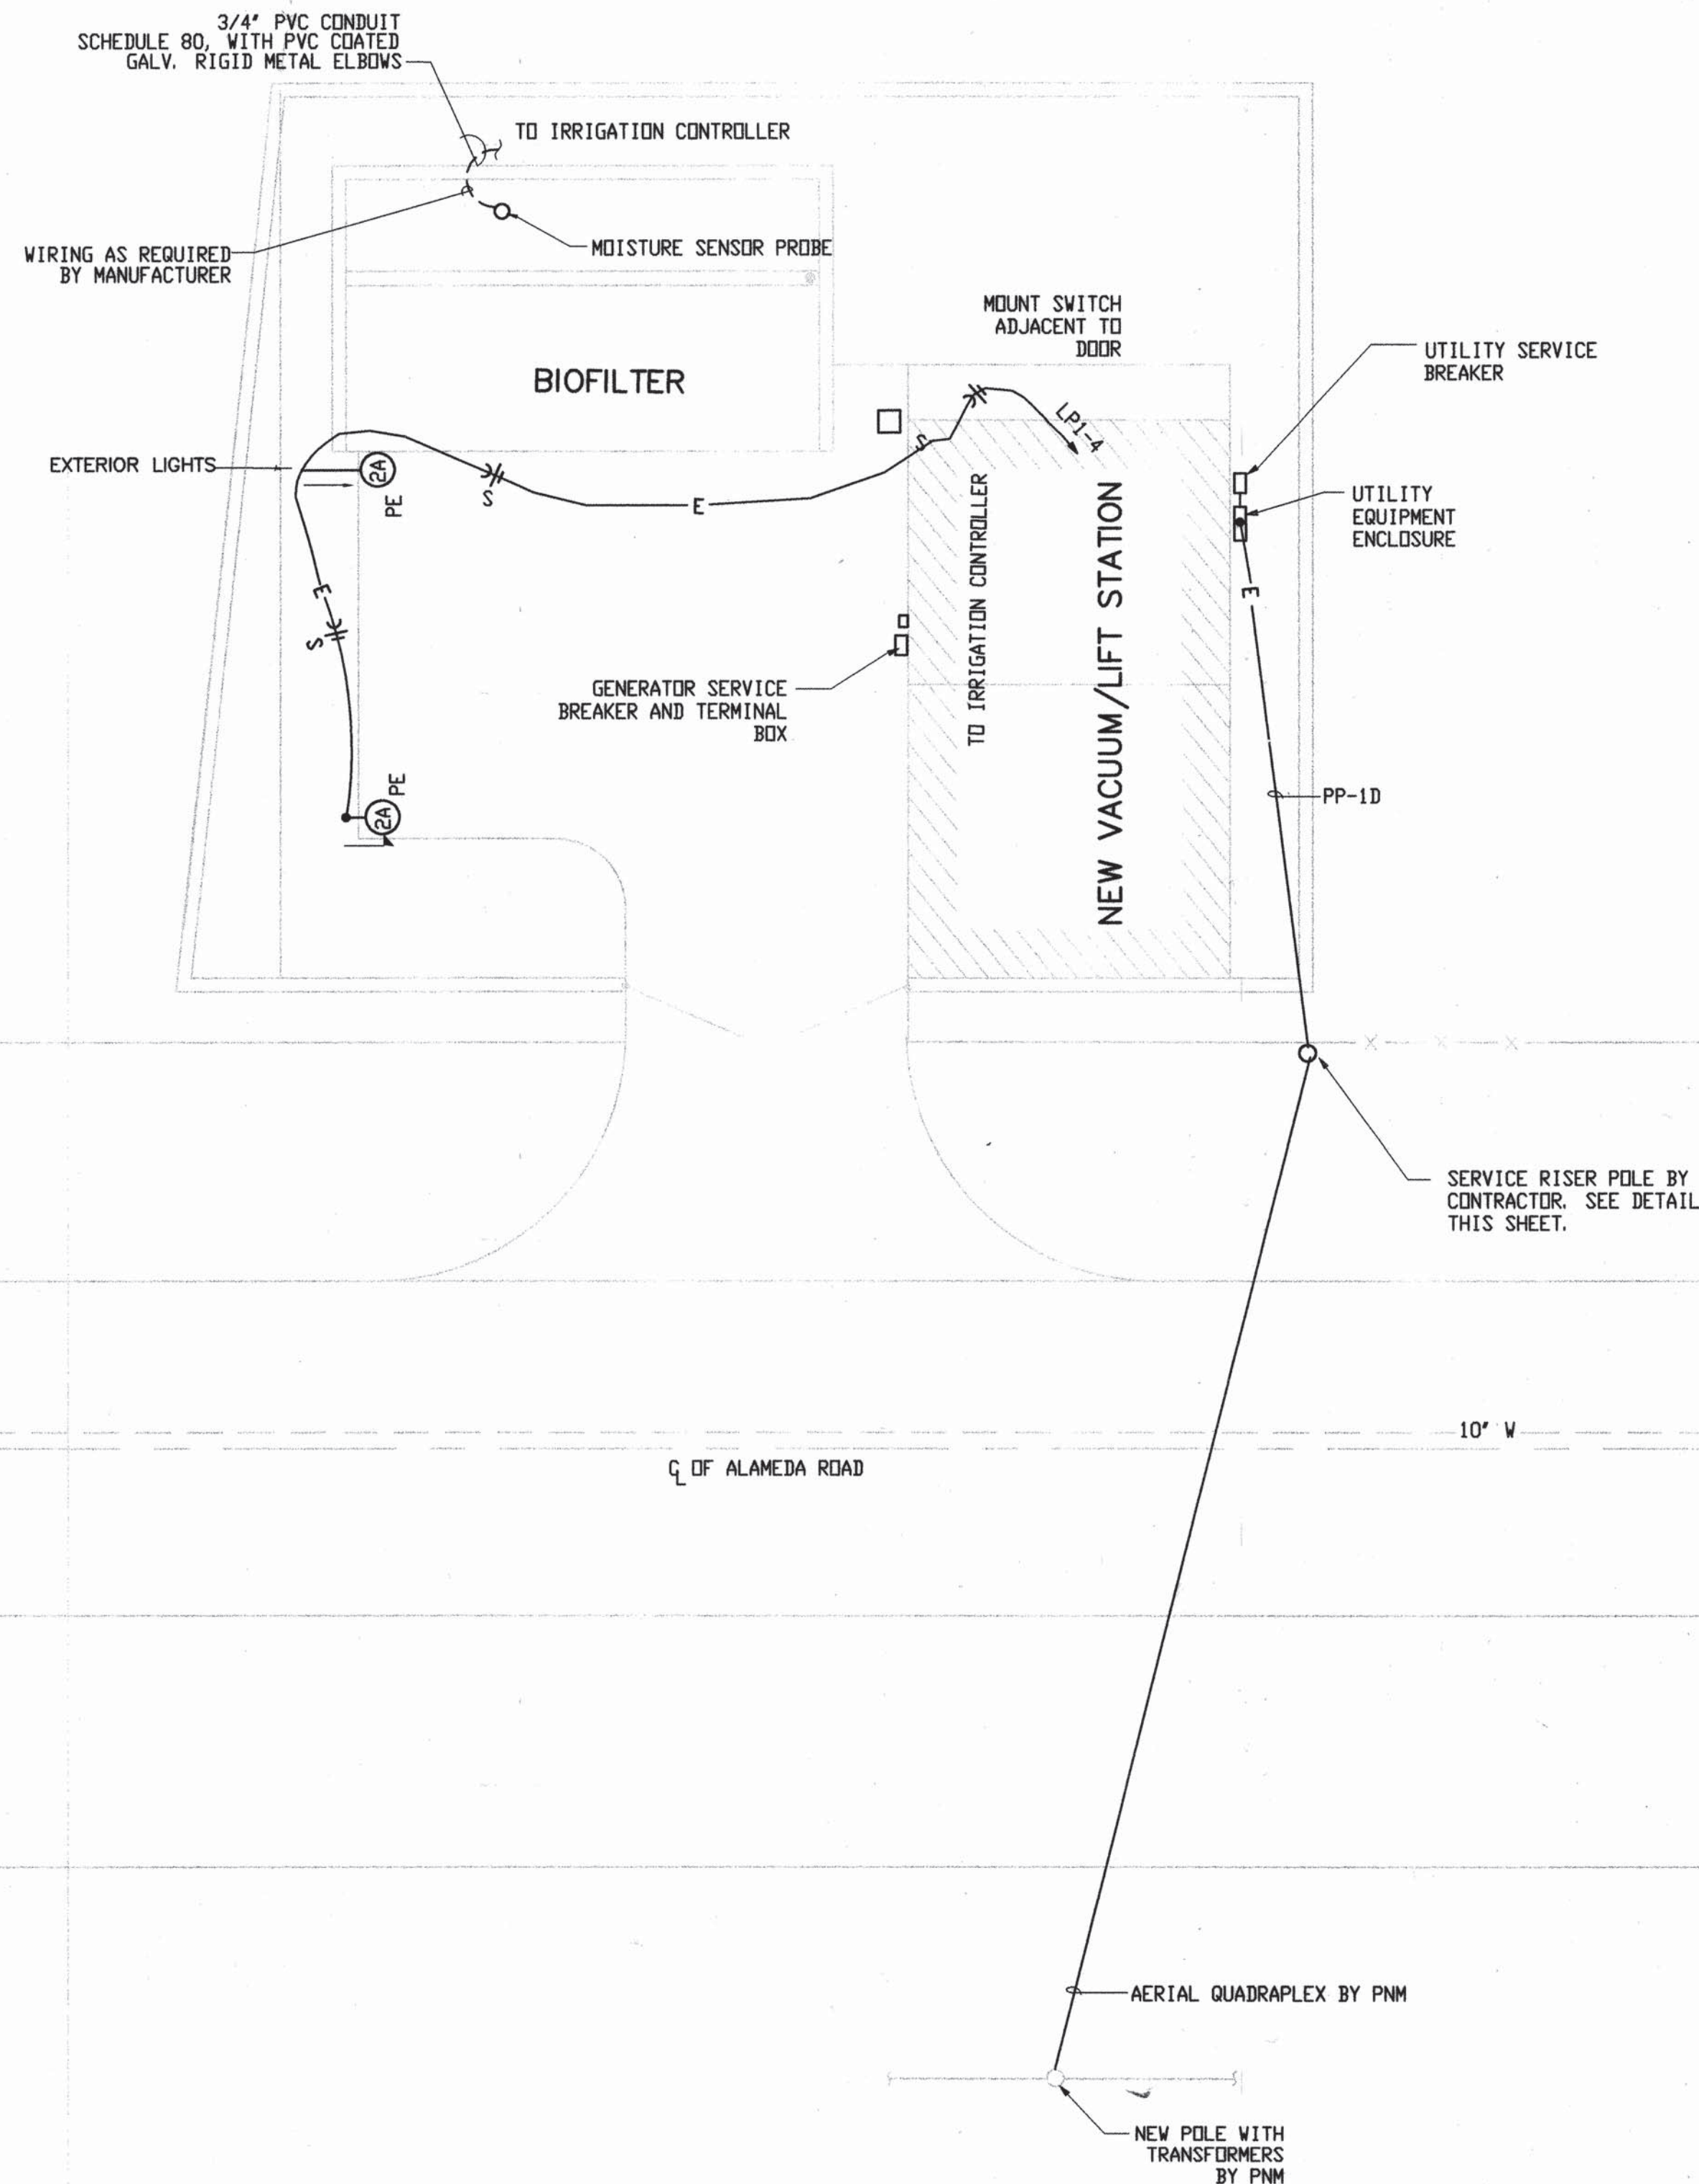

ELECTRICAL SITE PLAN
SCALE: 1"=10'

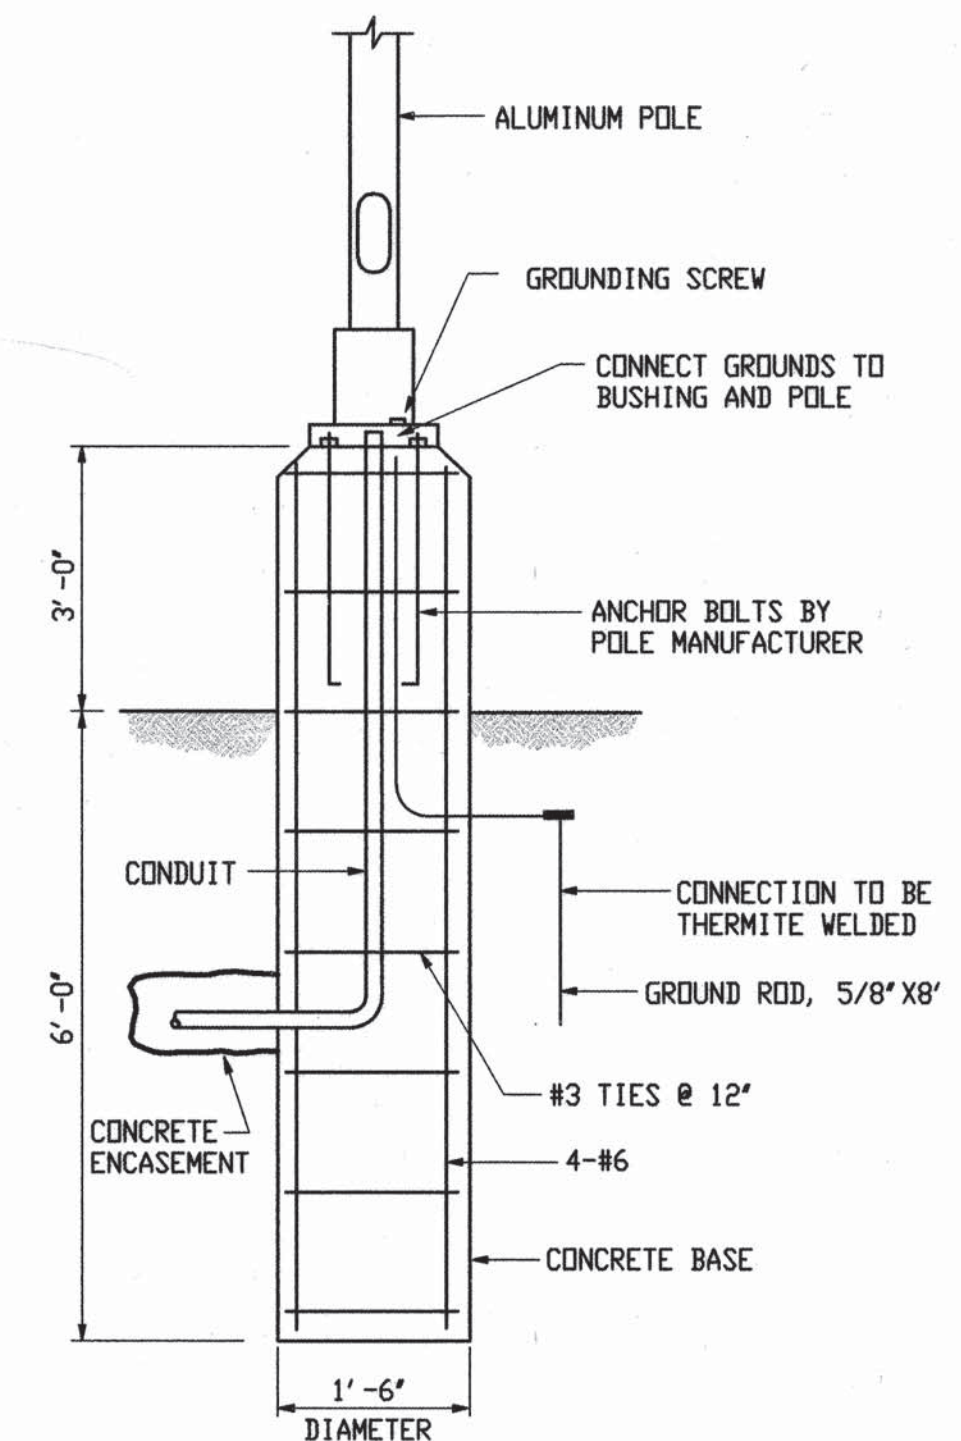

POLE BASE DETAIL
NOT TO SCALE

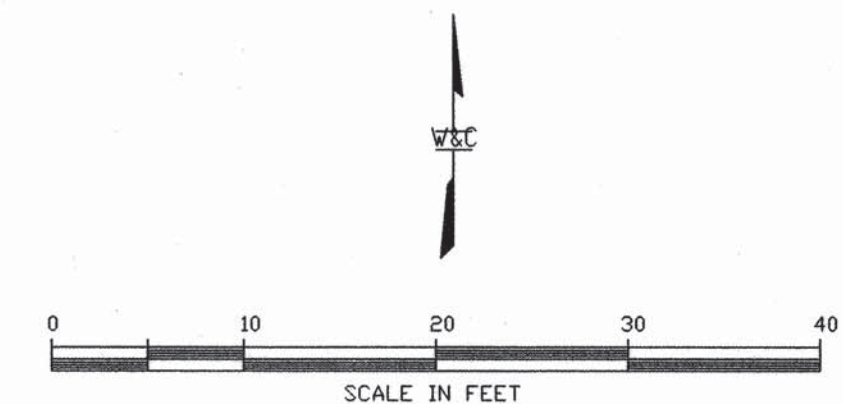


CITY PROJECT #567292

COUNTY OF BERNALILLO ENVIRONMENTAL HEALTH AND PUBLIC WORKS DEPARTMENTS	
NORTH VALLEY AREAS B AND F VACUUM STATION	
ELECTRICAL SITE LAYOUT	
PROJECT NO. 96034	SHEET 16 OF 19

WILSON
& COMPANY


X:\PUBLIC\PROJECTS\96034\DRAWINGS\VACSTA\ELECSITE-9-1-99.DWG

AS-BUILT INFORMATION		BENCH MARKS		SURVEY INFORMATION	
CONTRACTOR	TRIAD BUILDERS OF NM	DATE	4/99	FIELD NOTES	DATE
INSPECTOR	WILSON & CO.	DATE	3/00	BY	
FIELD VERIFICATION	WILSON & CO.	DATE		NO.	
MICRO-FILM INFORMATION		DATE			
RECORDED BY		DATE			
NO.					

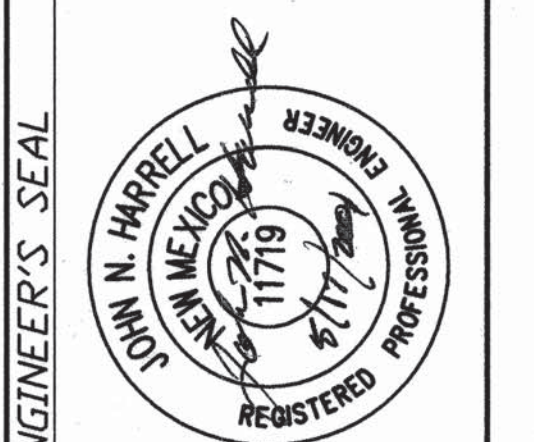

REVISIONS	DATE	BY
1	9/3/99	RELOCATED PUMP STATION
WILSON & COMPANY, ENGINEERS & ARCHITECTS		
DESIGNED BY	J.H.	DATE 2/20/99
DRAWN BY	P.R.D.	DATE 2/20/99
CHECKED BY	R.J.P.	DATE 2/20/99


SCANNED BY
MESA REPRO


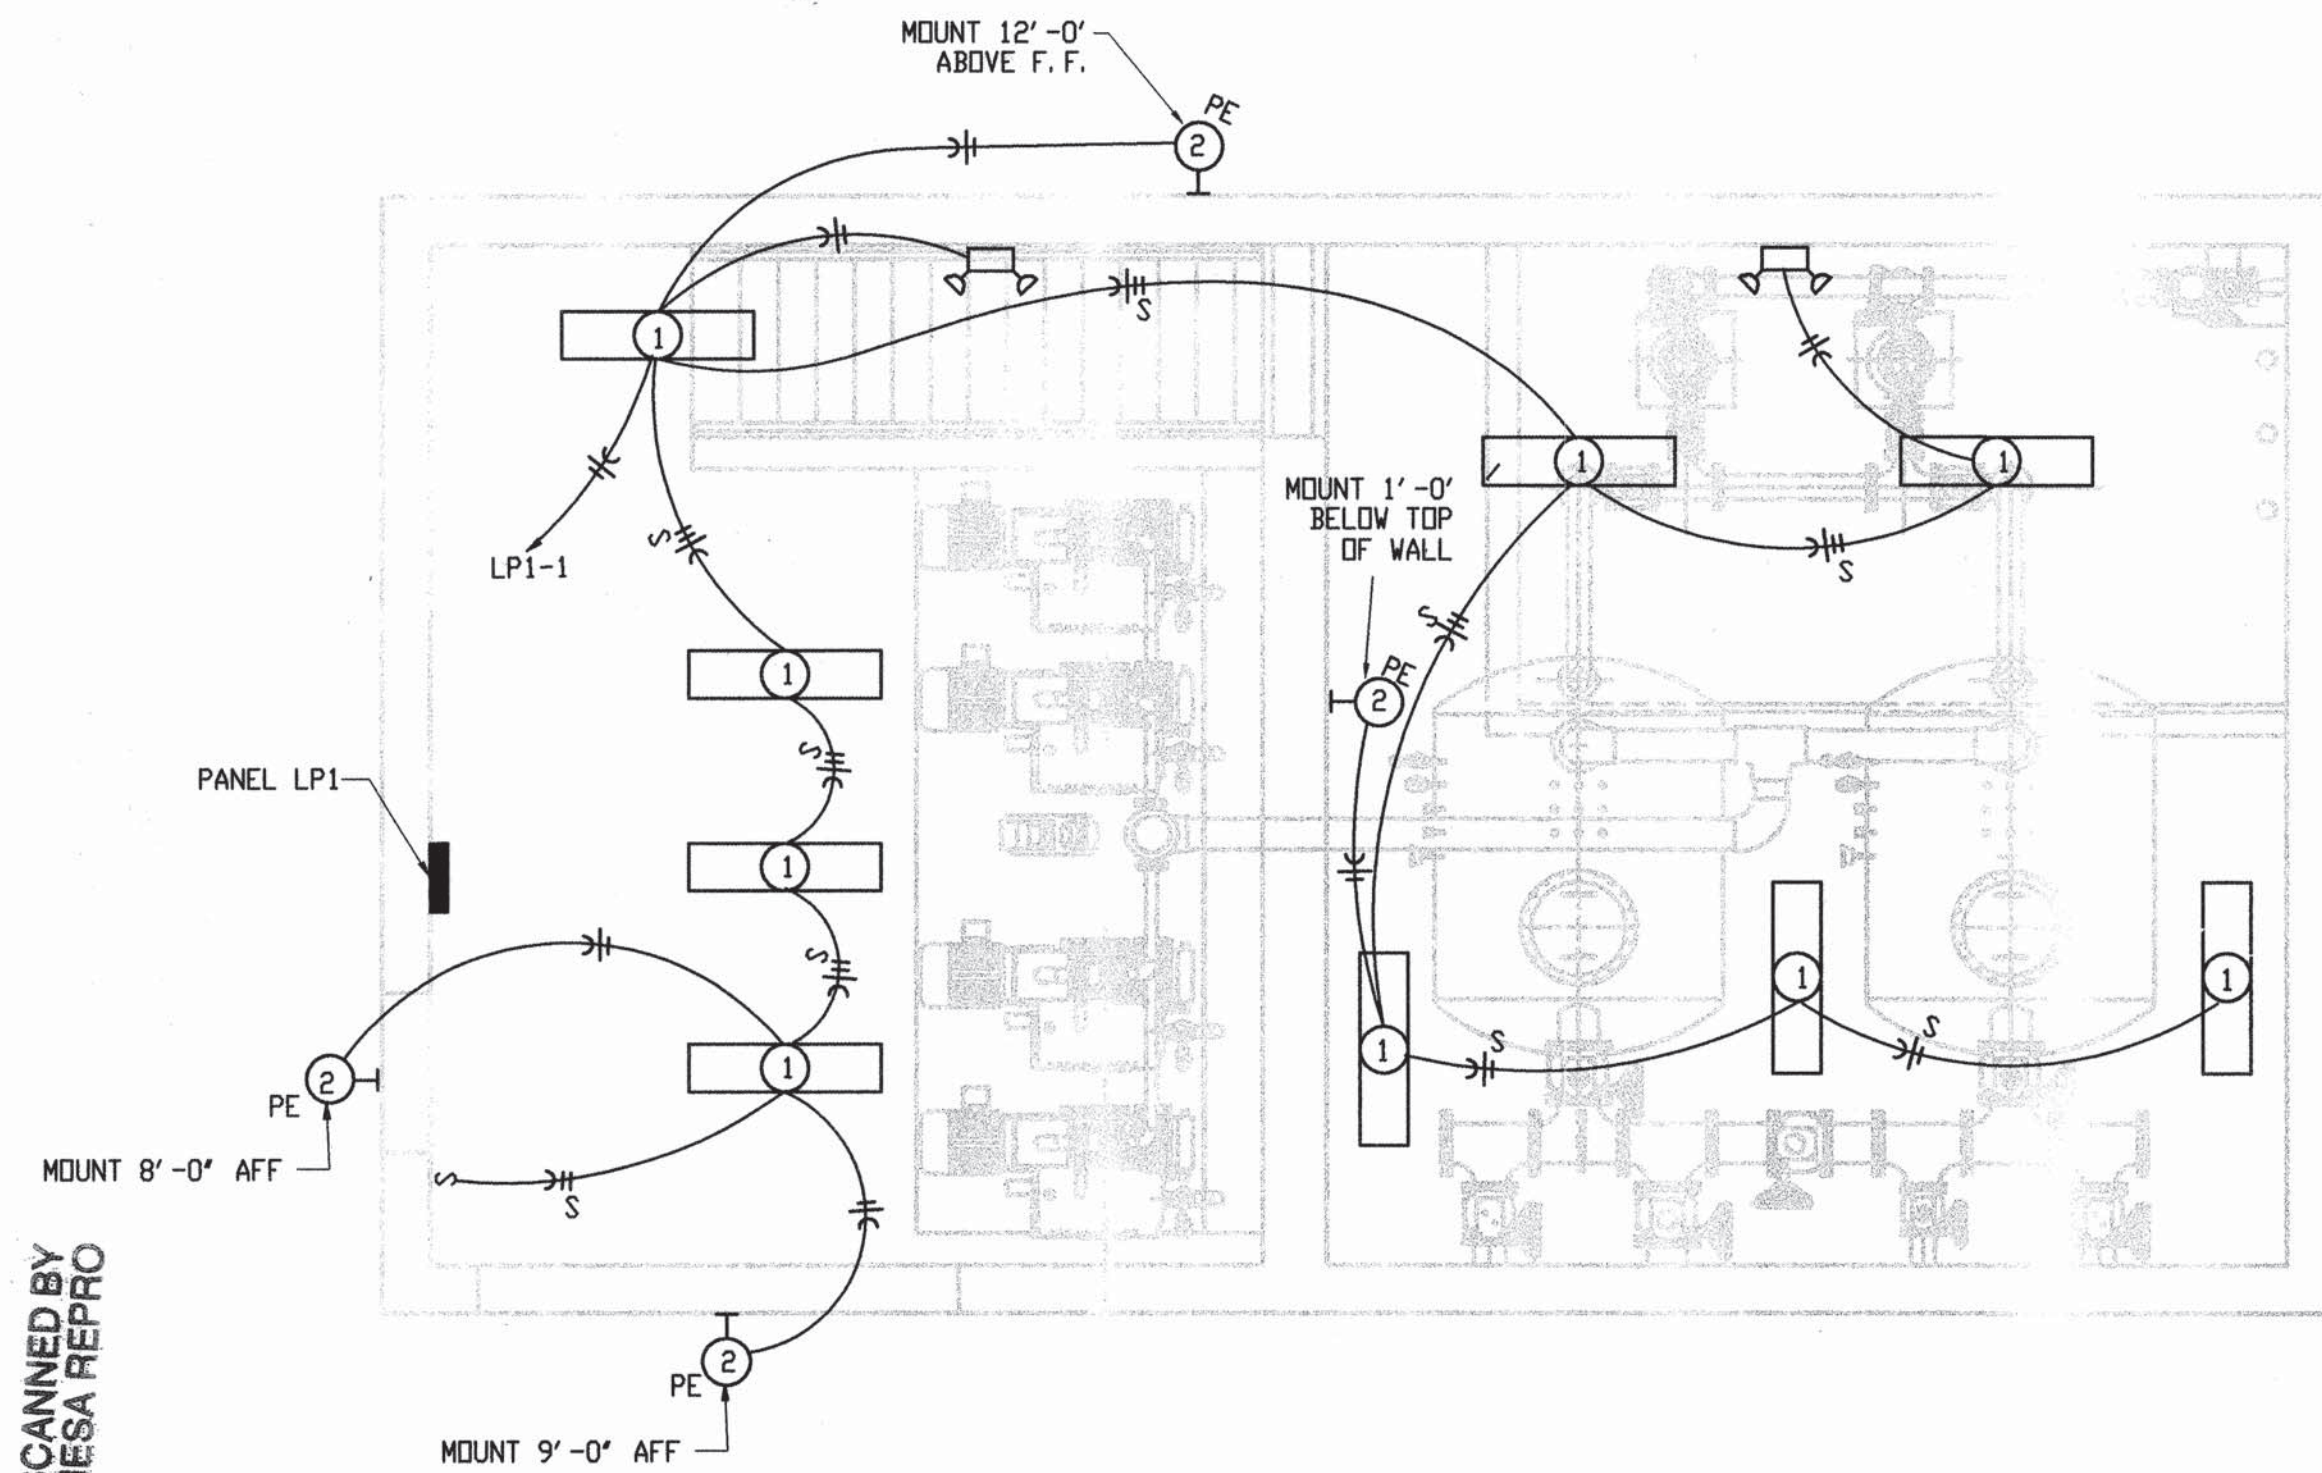


LIGHTING PLAN
SCALE 1/4" = 1'-0"

LIGHTING FIXTURE SCHEDULE				
SYMBOL	LAMP	MOUNTING HEIGHT	DESCRIPTION	MANUFACTURER MODEL NO.
	F32T8-CW	PENDANT AS NOTED	2-LAMP, 120V, HEAVY DUTY INDUSTRIAL FLUORESCENT, 10% UPLIGHT, RAPID START, ENERGY SAVING BALLAST, PORCELAIN REFLECTOR, PROVIDE WIRE GUARDS.	DAY-BRITE FL-1024-4U
	70W, HPS	12" ALUMINUM SQUARE, NON-TAPERED POLE	120V, HIGH PRESSURE SODIUM, SHARP CUTOFF LUMINAIRE DARK BRONZE ANODIZED FINISH, PROVIDE PHOTOCELL RECEPTACLE WITH NEMA BASE PHOTOCELL, LEXAN SHIELD.	KIM/EKG401/70HPS 120/DB-A (NOTE 1)
	70W, HPS	WALL AS NOTED	120V, HIGH PRESSURE SODIUM, SHARP CUTOFF LUMINAIRE DARK BRONZE ANODIZED FINISH, PROVIDE PHOTOCELL RECEPTACLE WITH NEMA BASE PHOTOCELL, LEXAN SHIELD.	KIM/EKG401/70HPS 120/DB-A/A-25
	8 WATT HALOGEN	WALL 8'-0" AFF	MAINTENANCE FREE LEAD CALCIUM BATTERY, EMERGENCY LIGHT COMPLYING WITH NEMA 4X AND NEMA 12 RATINGS. 12V OUTPUT 120V POWER SUPPLY.	EXIDE/LIGHTGUARD LTC12SXW2ACF1

NOTE:
1. PROVIDE BREAKOVER POLE, KW INDUSTRIES THSP-30-6.25-11-P-DM-BC
ARROW INDICATES DIRECTION THE POLE SHALL BREAK FOR LOWERING.

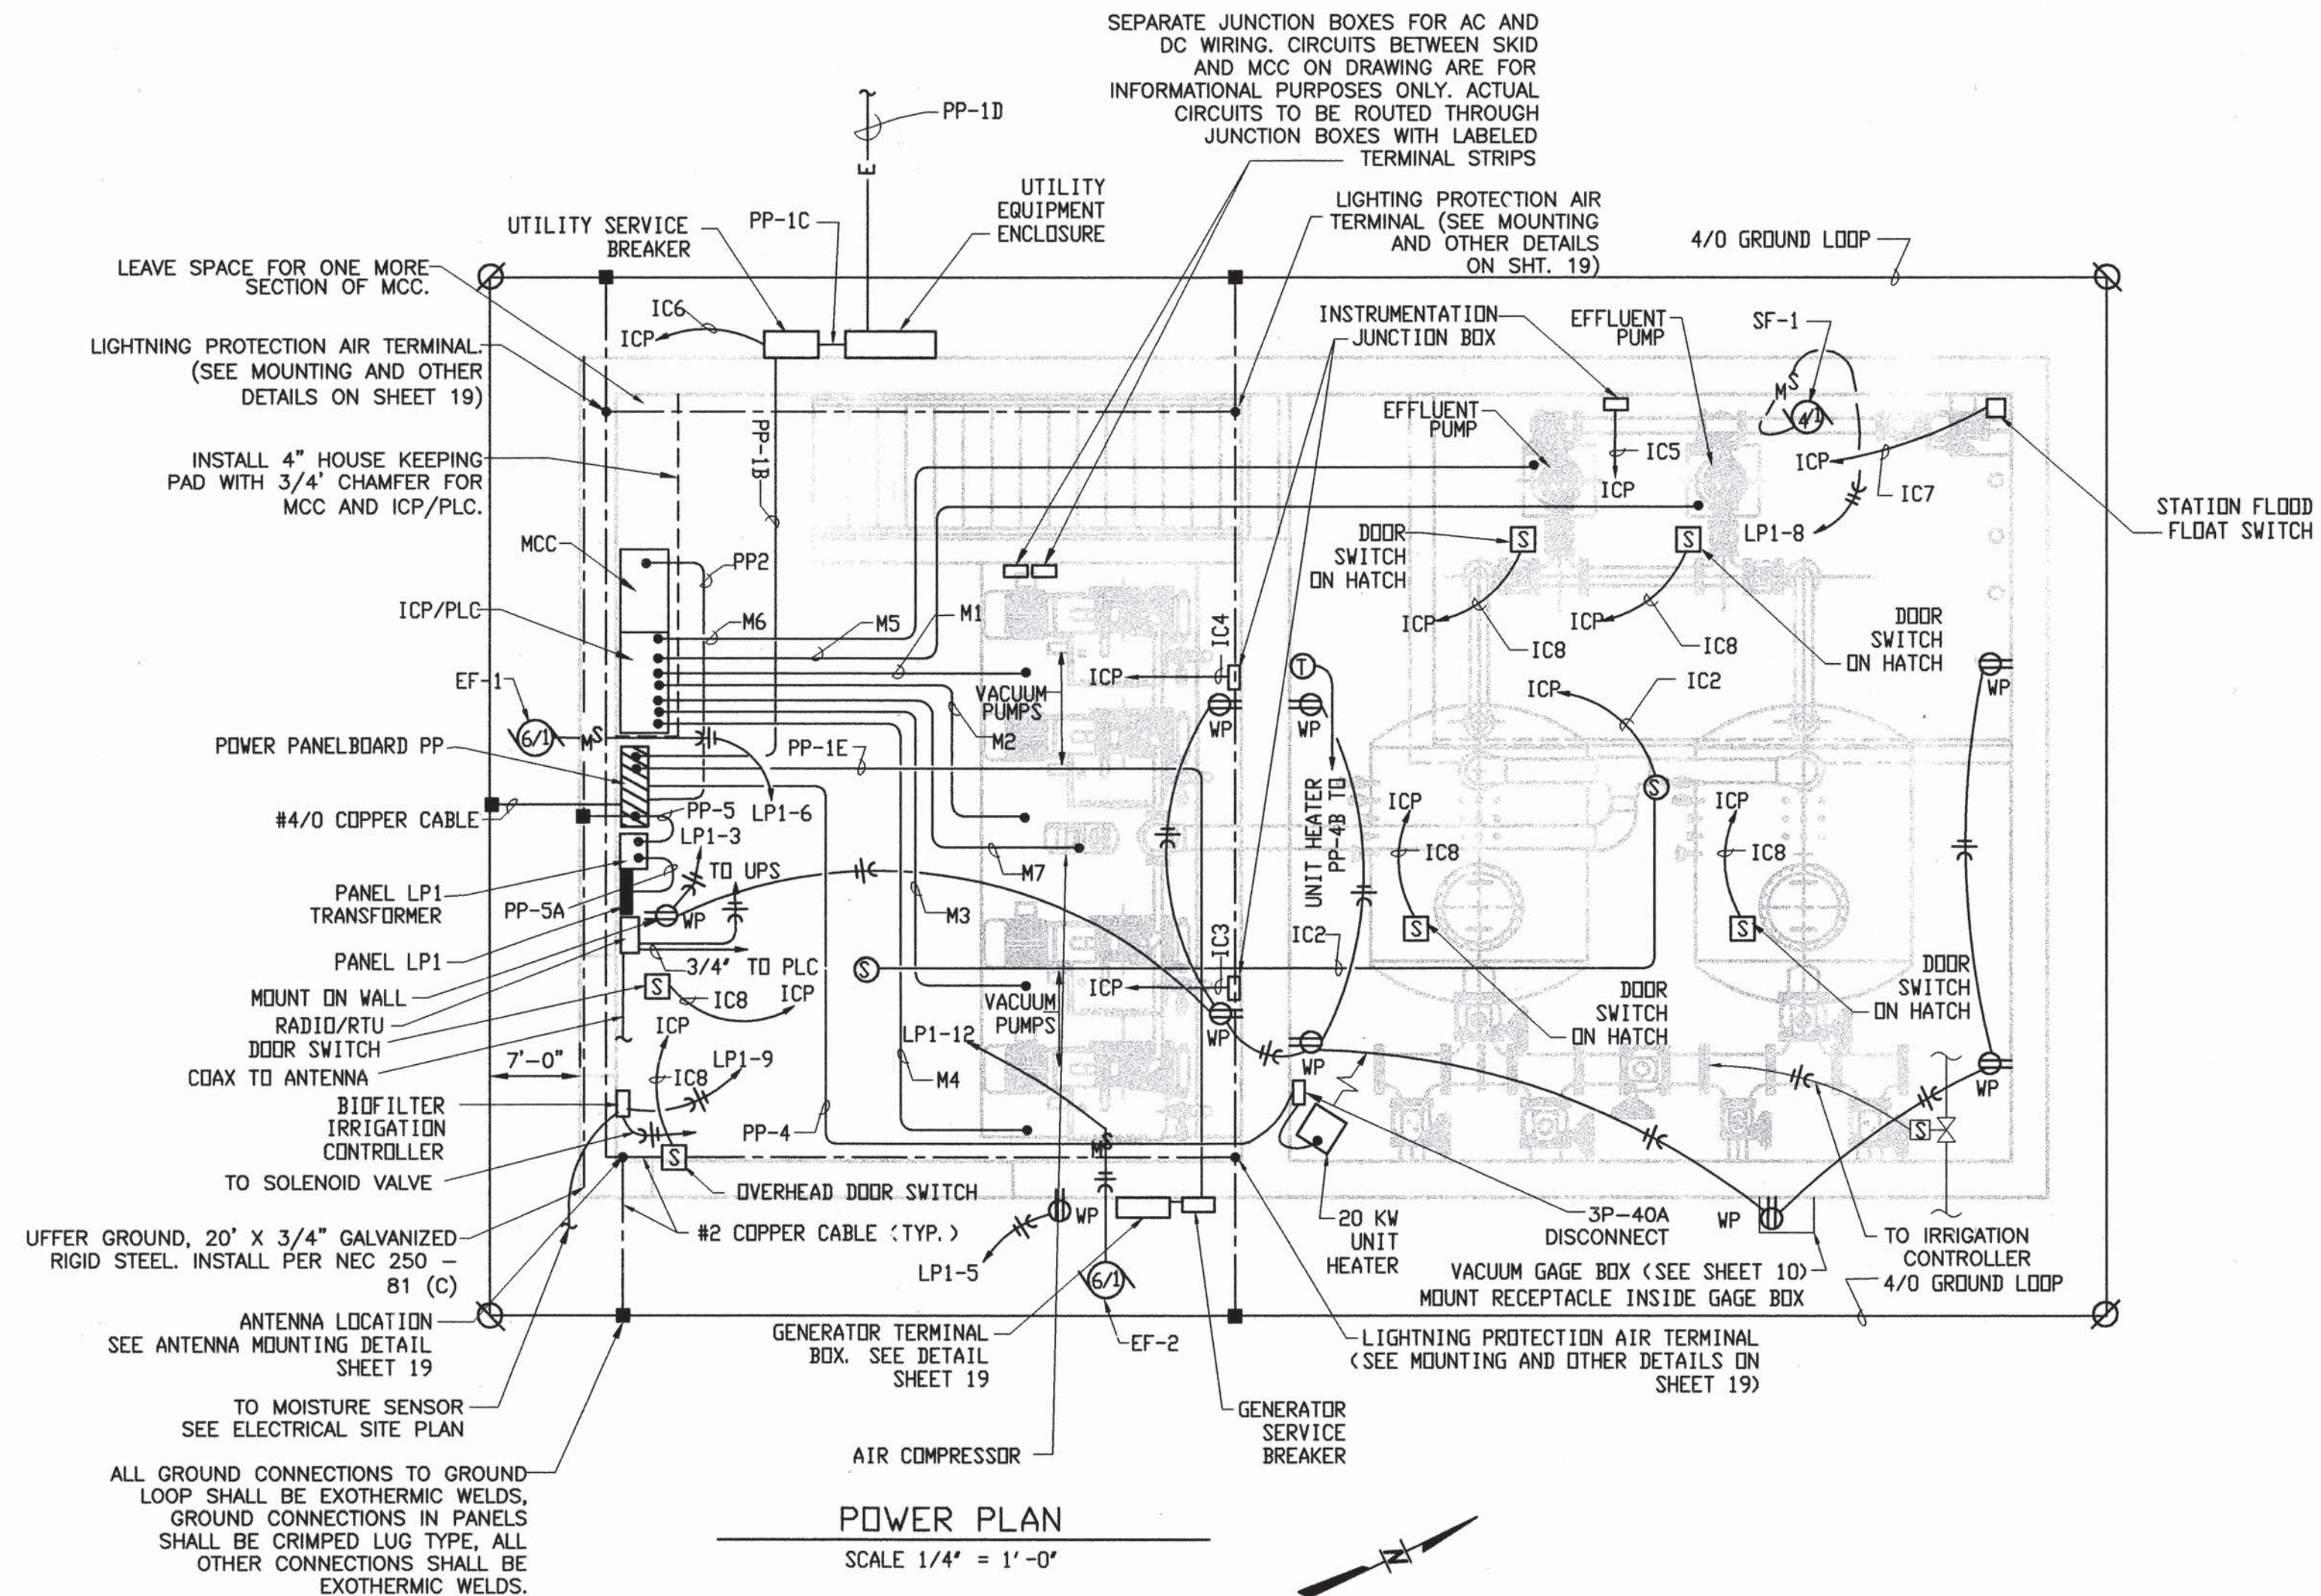


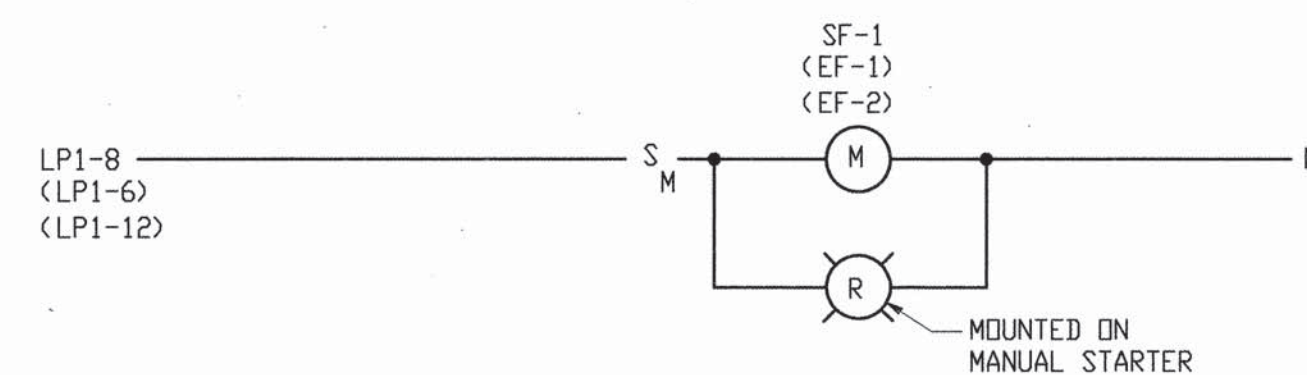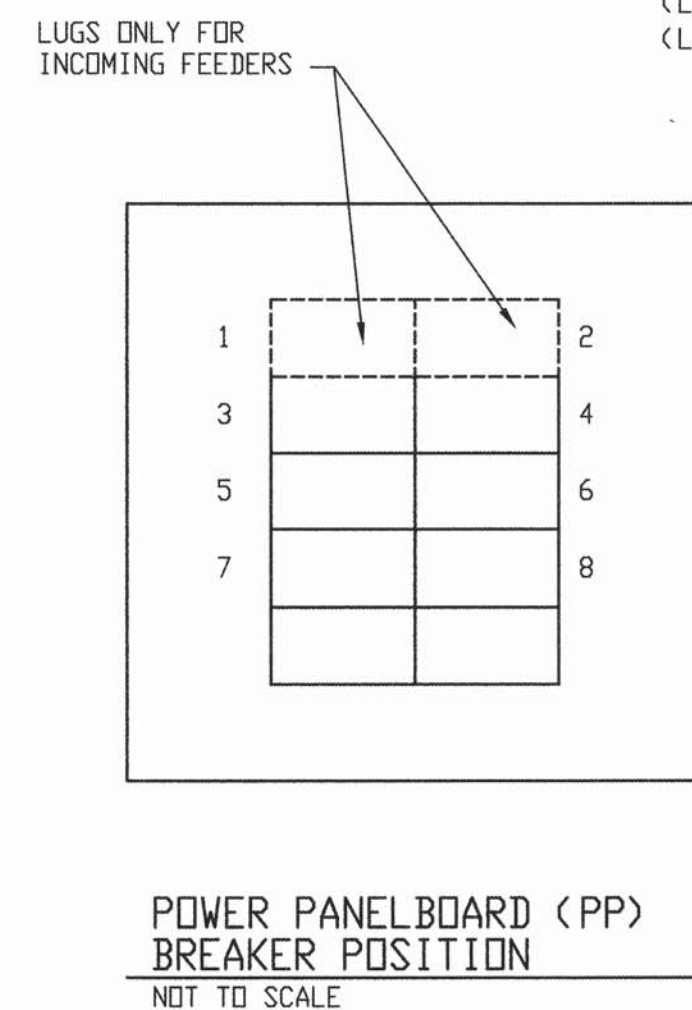

SF-1 CONTROL DIAGRAM

(TYPICAL FOR EF-1 AND EF-2)


NOTE:
FANS ARE TO RUN CONTINUOUSLY

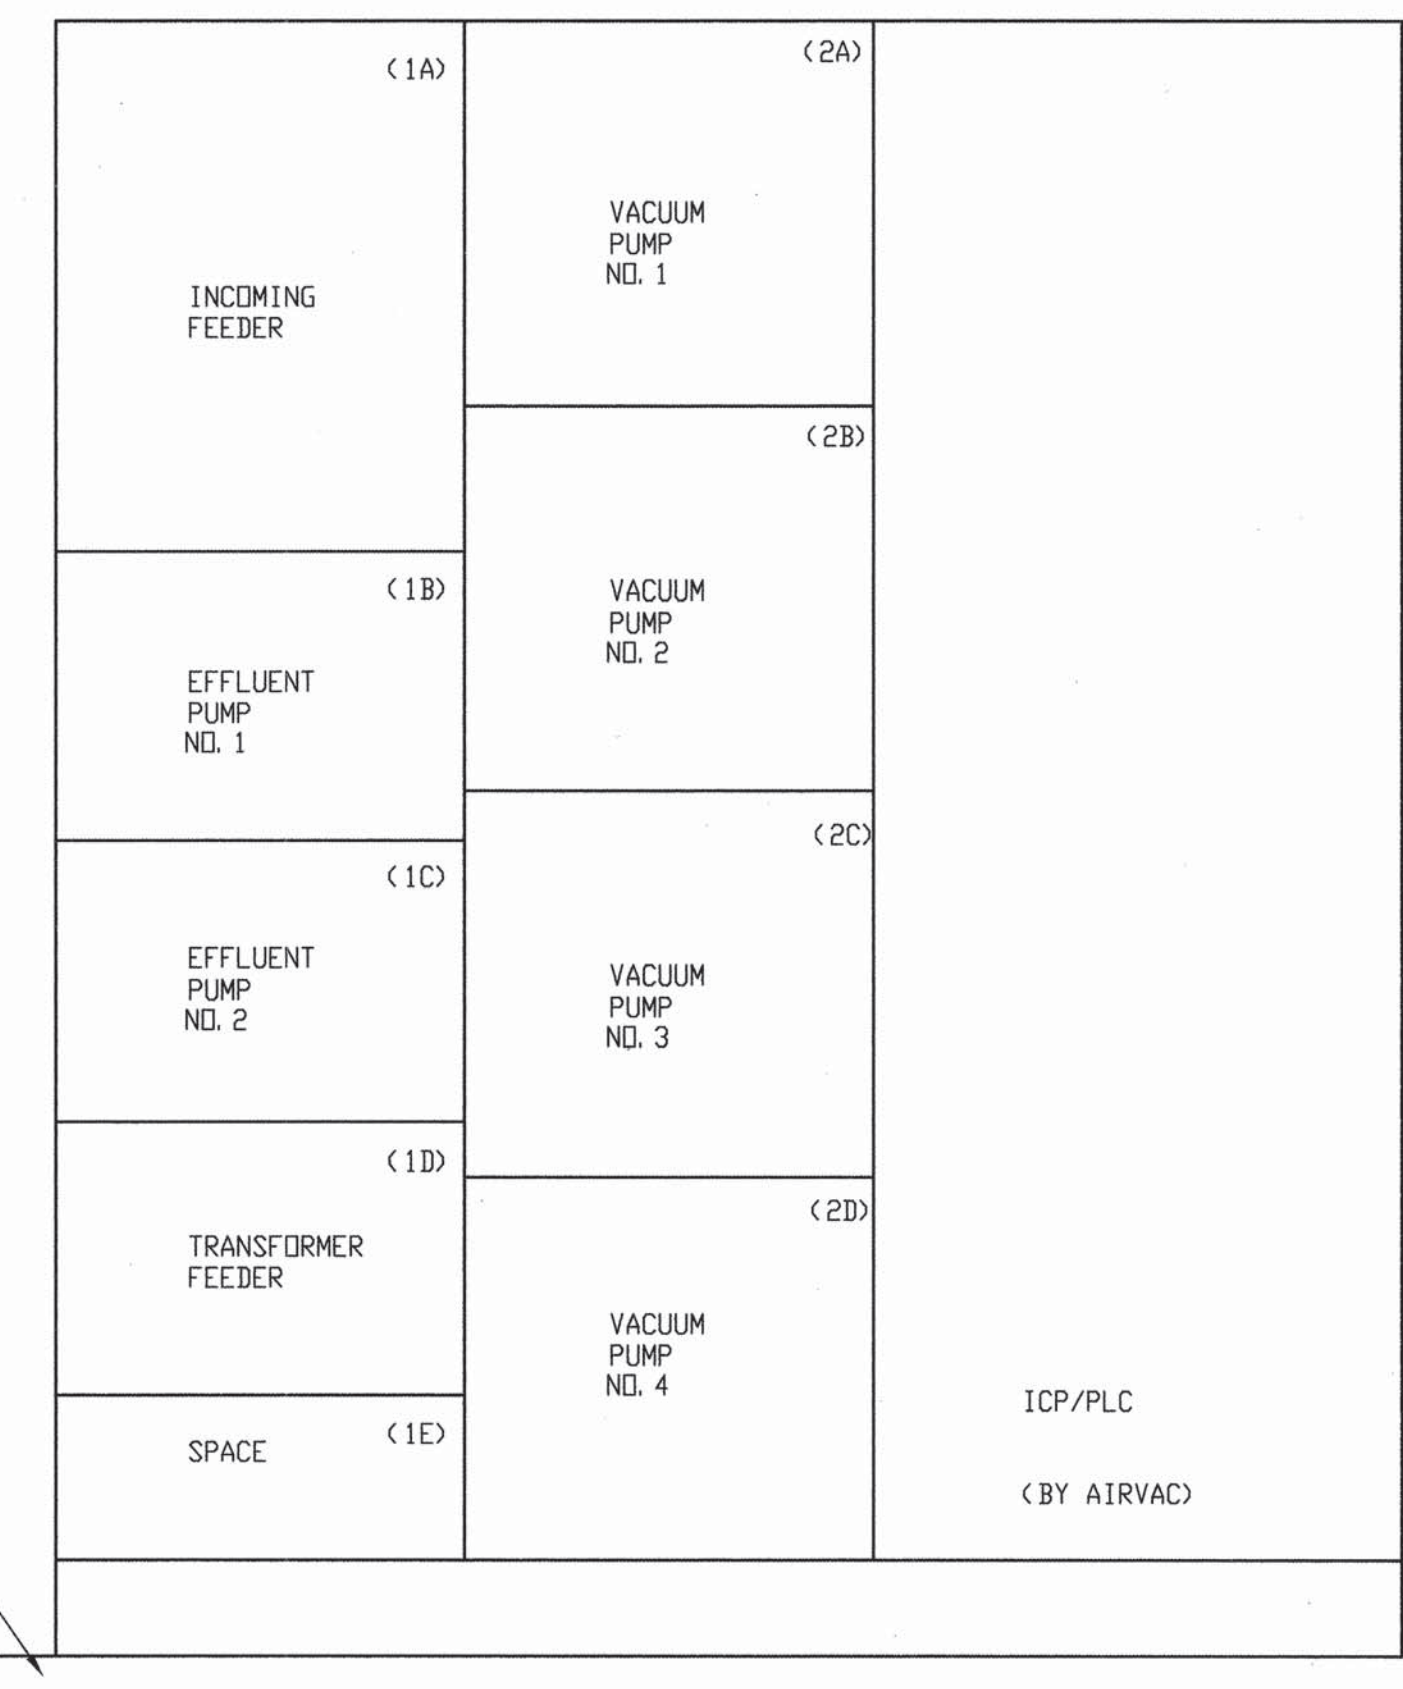

MCC - ELEVATION

NOT TO SCALE

NOTE: PAD SHALL EXTEND 2' BEYOND EDGE OF EQUIPMENT

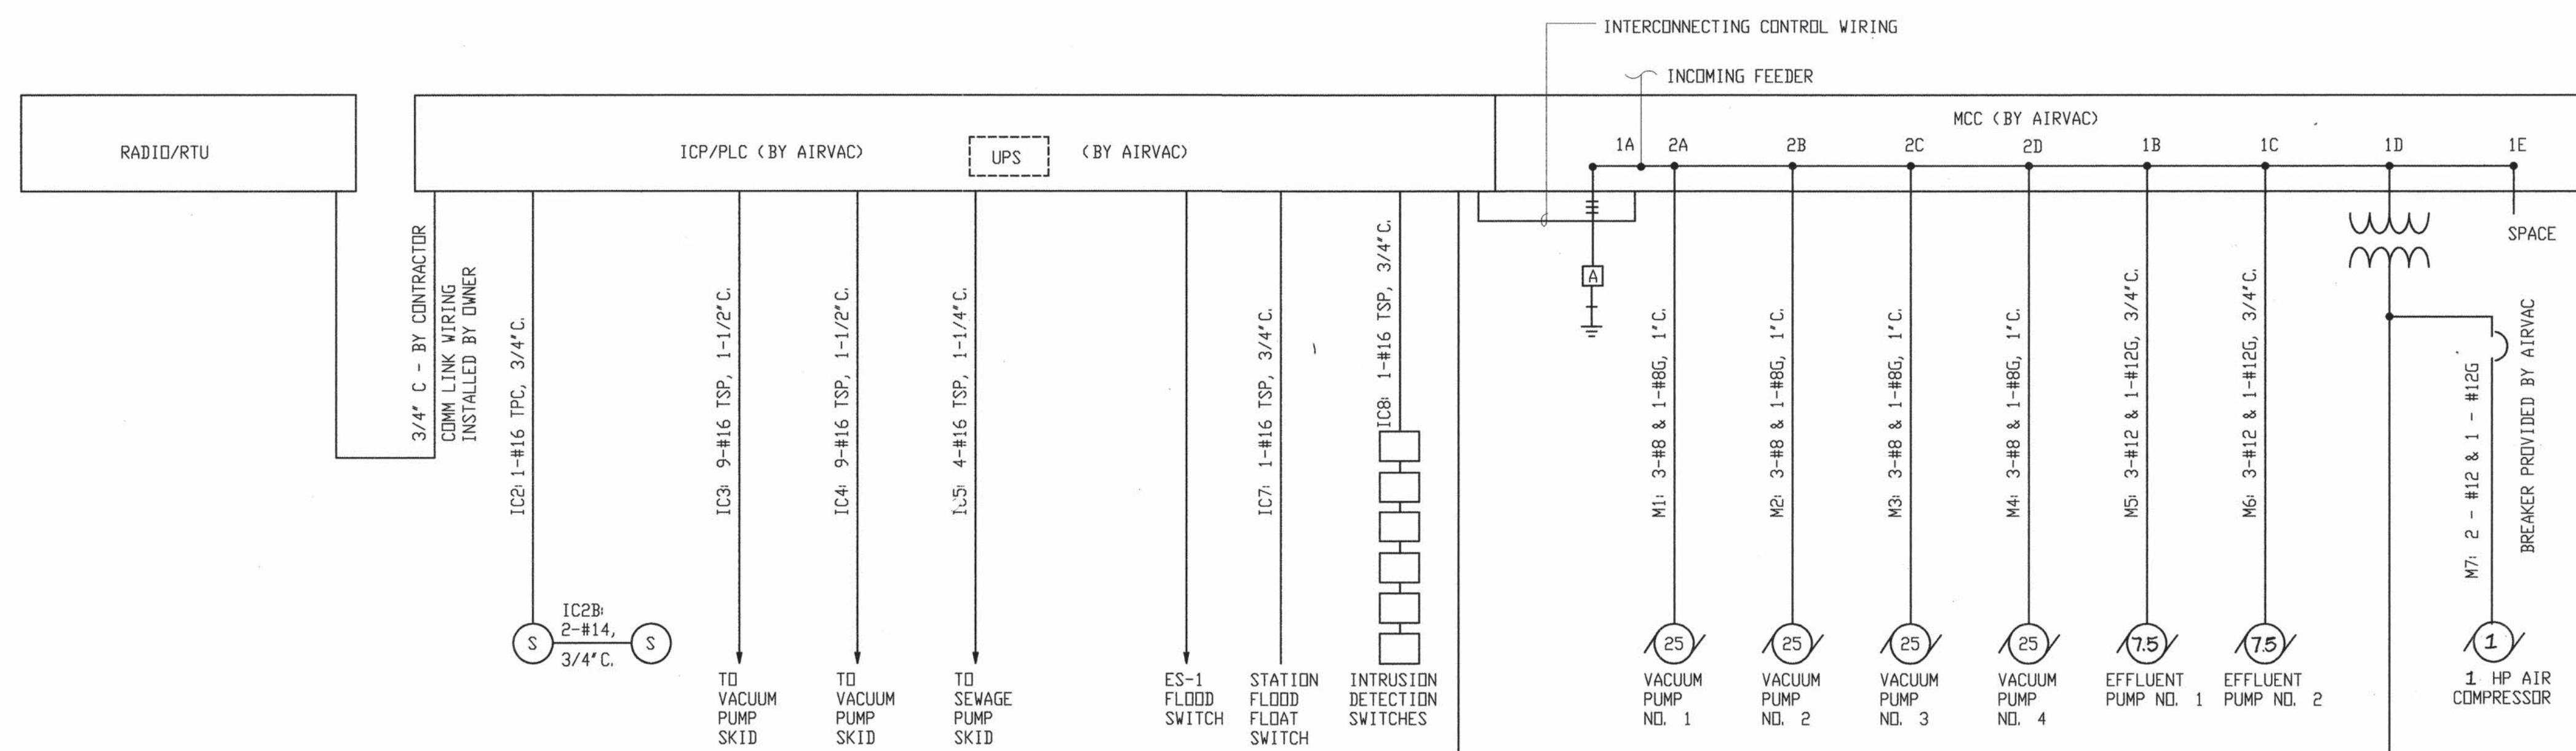

NOTE: WIRING OF EQUIPMENT ON VACUUM/SEWAGE PUMP SKID
BY AIRVAC. SEE AIRVAC DRAWING FOR DETAILED WIRING.

MISCELLANEOUS ONE-LINE DIAGRAMS

[illegible]

CITY PROJECT #567292

COUNTY OF BERNALILLO
ENVIRONMENTAL HEALTH AND
PUBLIC WORKS DEPARTMENTS



NORTH VALLEY AREAS B AND F
VACUUM STATION

ONE LINE DIAGRAMS


PROJECT NO.	96034
-------------	-------

SHEET 18 OF 19


SCANNED BY
MESA REPRO




TYPICAL TEE CABLE SPLICE
NOT TO SCALE

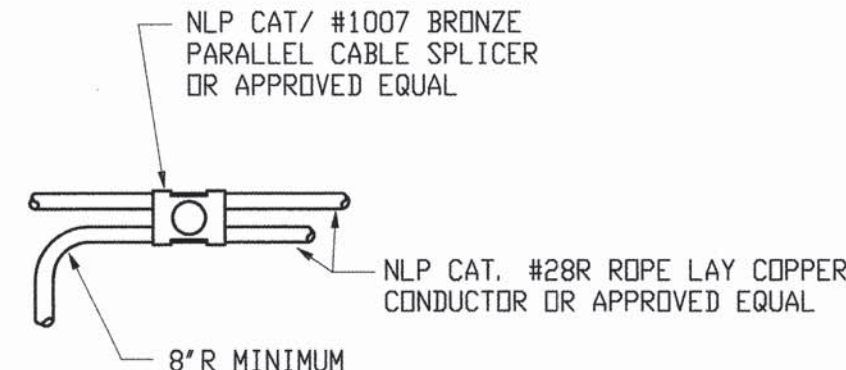


TYPICAL CABLE SPLICE DETAIL
NOT TO SCALE

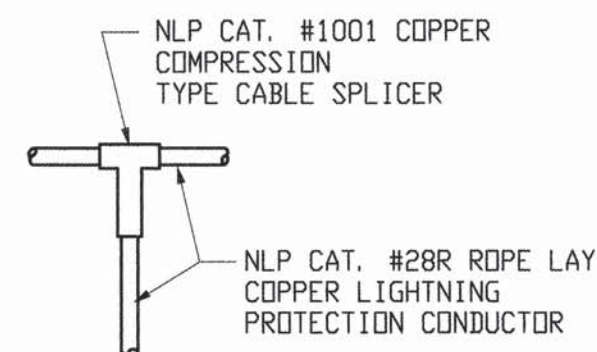



TYPICAL TEE CABLE SPLICE DETAIL
NOT TO SCALE

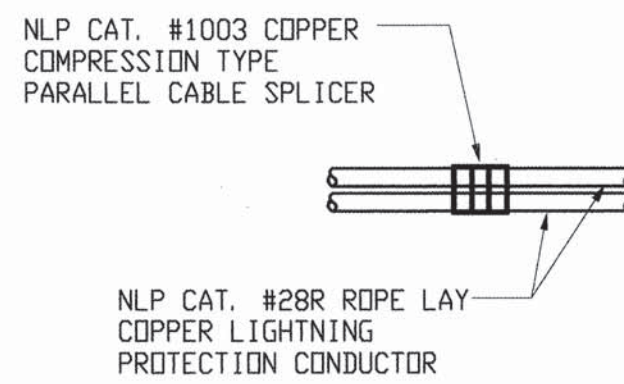

TYPICAL PARALLEL
CABLE SPLICE DETAIL
NOT TO SCALE

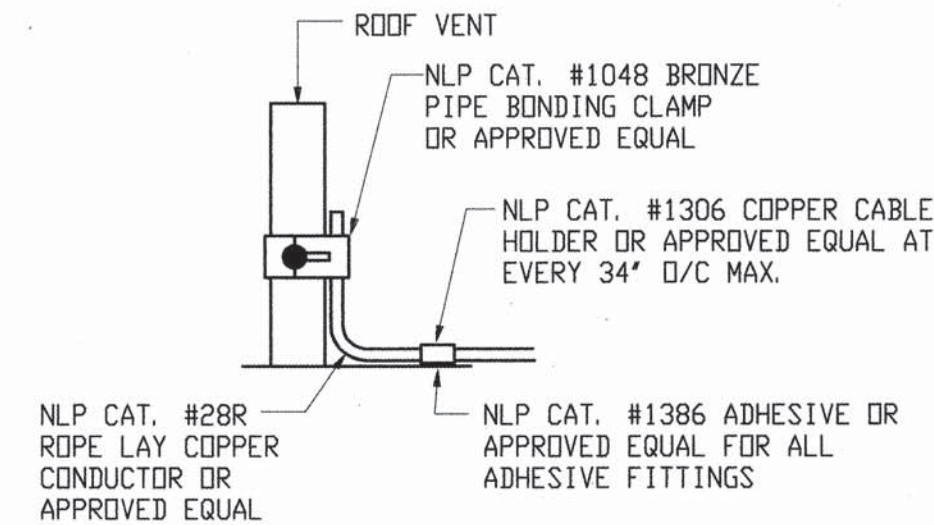


TYPICAL ROOF VENT BONDING DETAIL
NOT TO SCALE

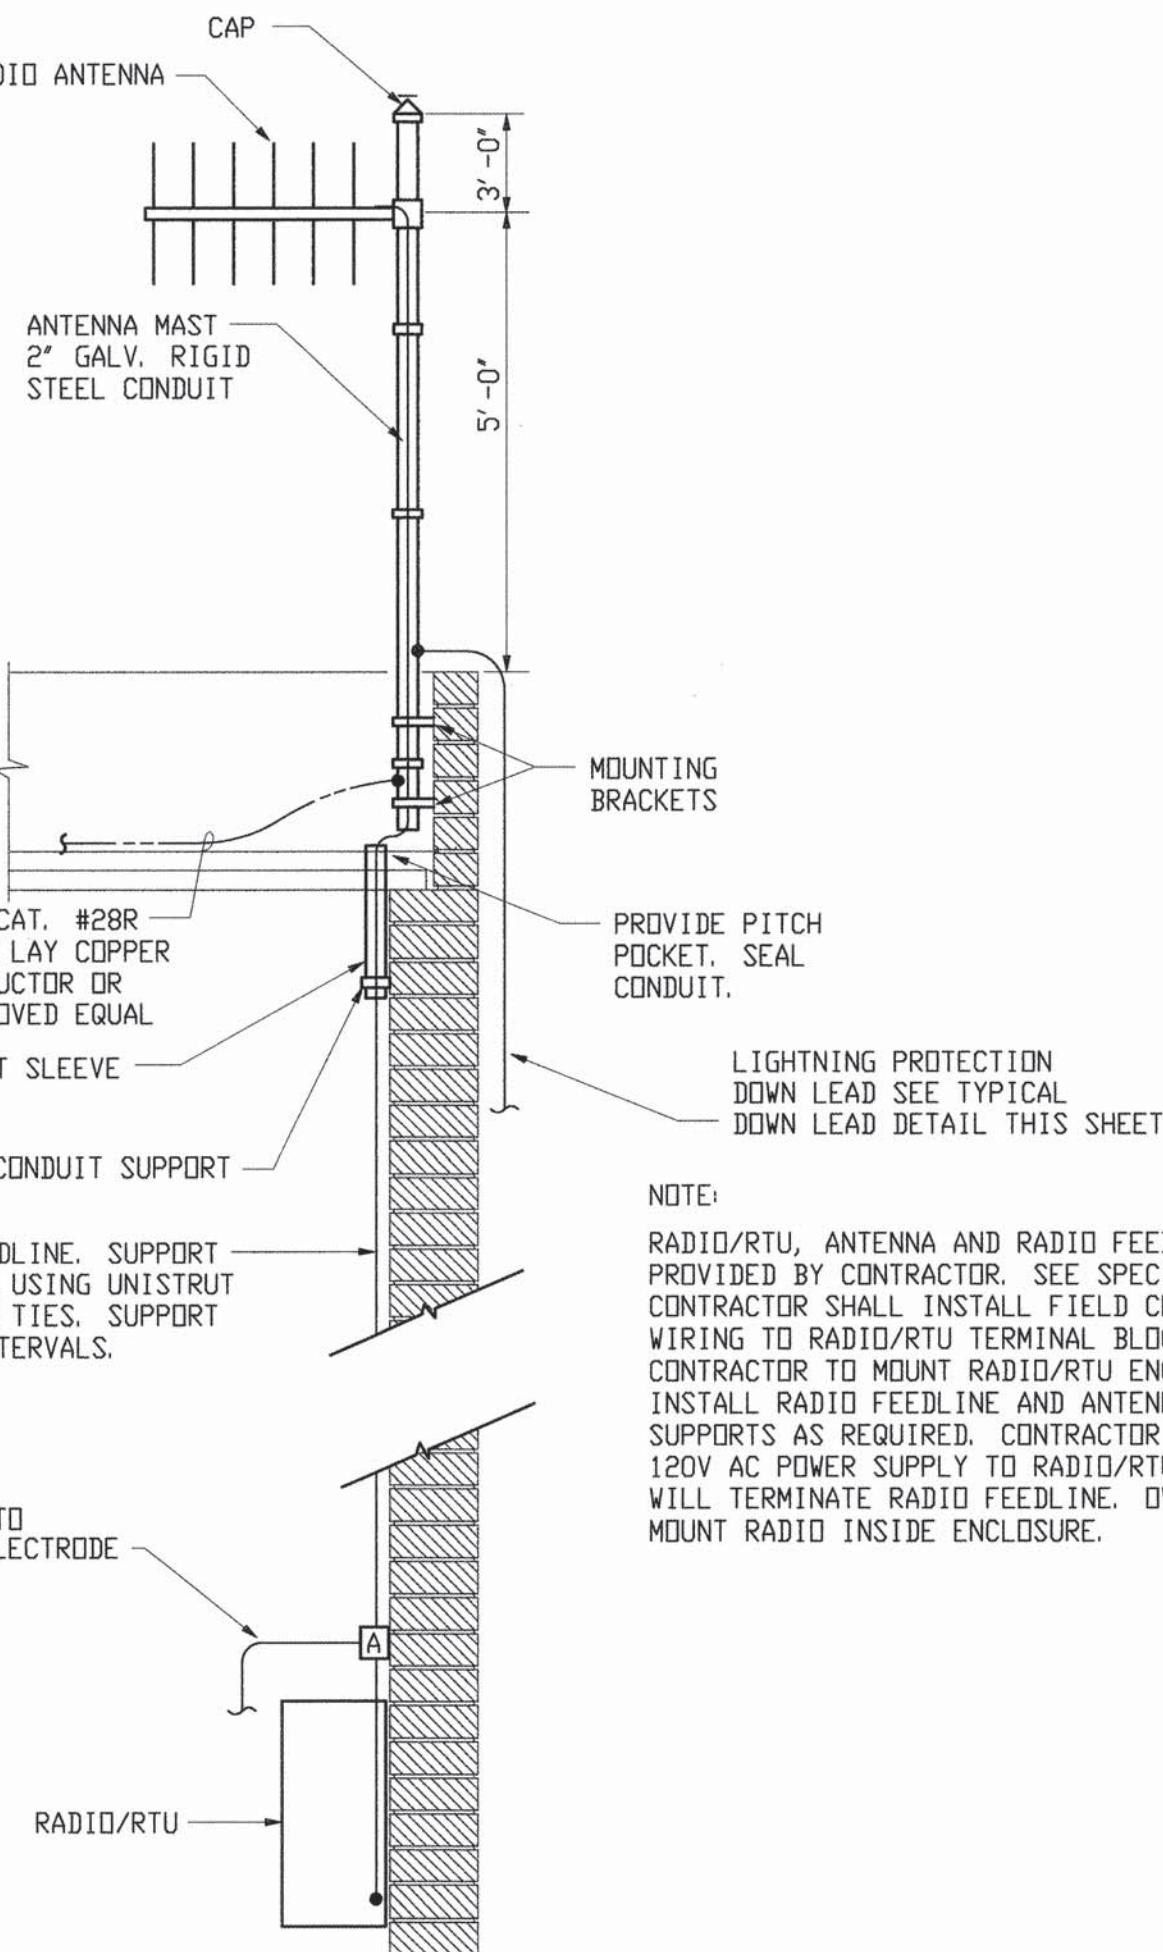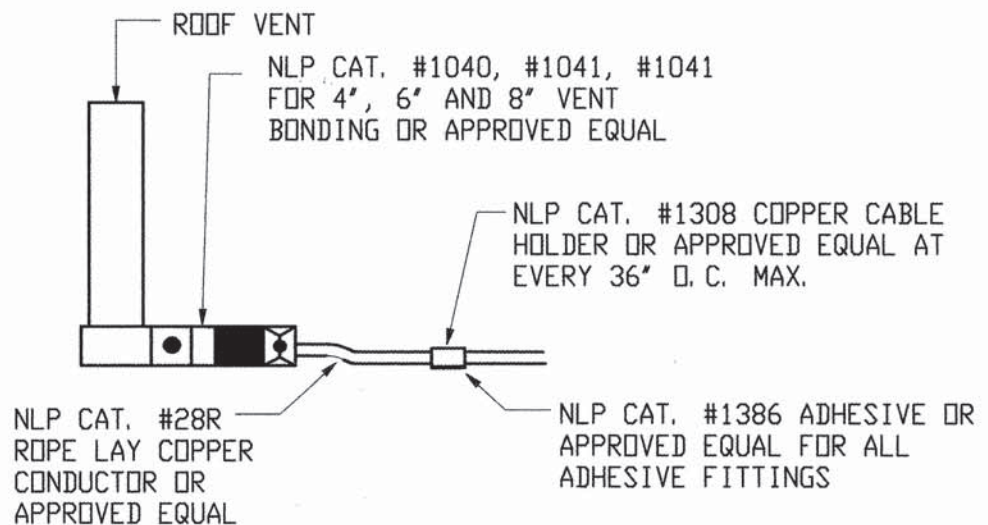


ANTENNA MOUNTING DETAIL
NOT TO SCALE


NOTE:
RADIO/RTU, ANTENNA AND RADIO FEEDLINE TO BE PROVIDED BY CONTRACTOR. SEE SPECIFICATIONS. CONTRACTOR SHALL INSTALL FIELD CONTROL WIRING TO RADIO/RTU TERMINAL BLOCK. CONTRACTOR TO MOUNT RADIO/RTU ENCLOSURE, INSTALL RADIO FEEDLINE AND ANTENNA PLUS SUPPORTS AS REQUIRED. CONTRACTOR TO PROVIDE 120V AC POWER SUPPLY TO RADIO/RTU. OWNER WILL TERMINATE RADIO FEEDLINE. OWNER WILL MOUNT RADIO INSIDE ENCLOSURE.

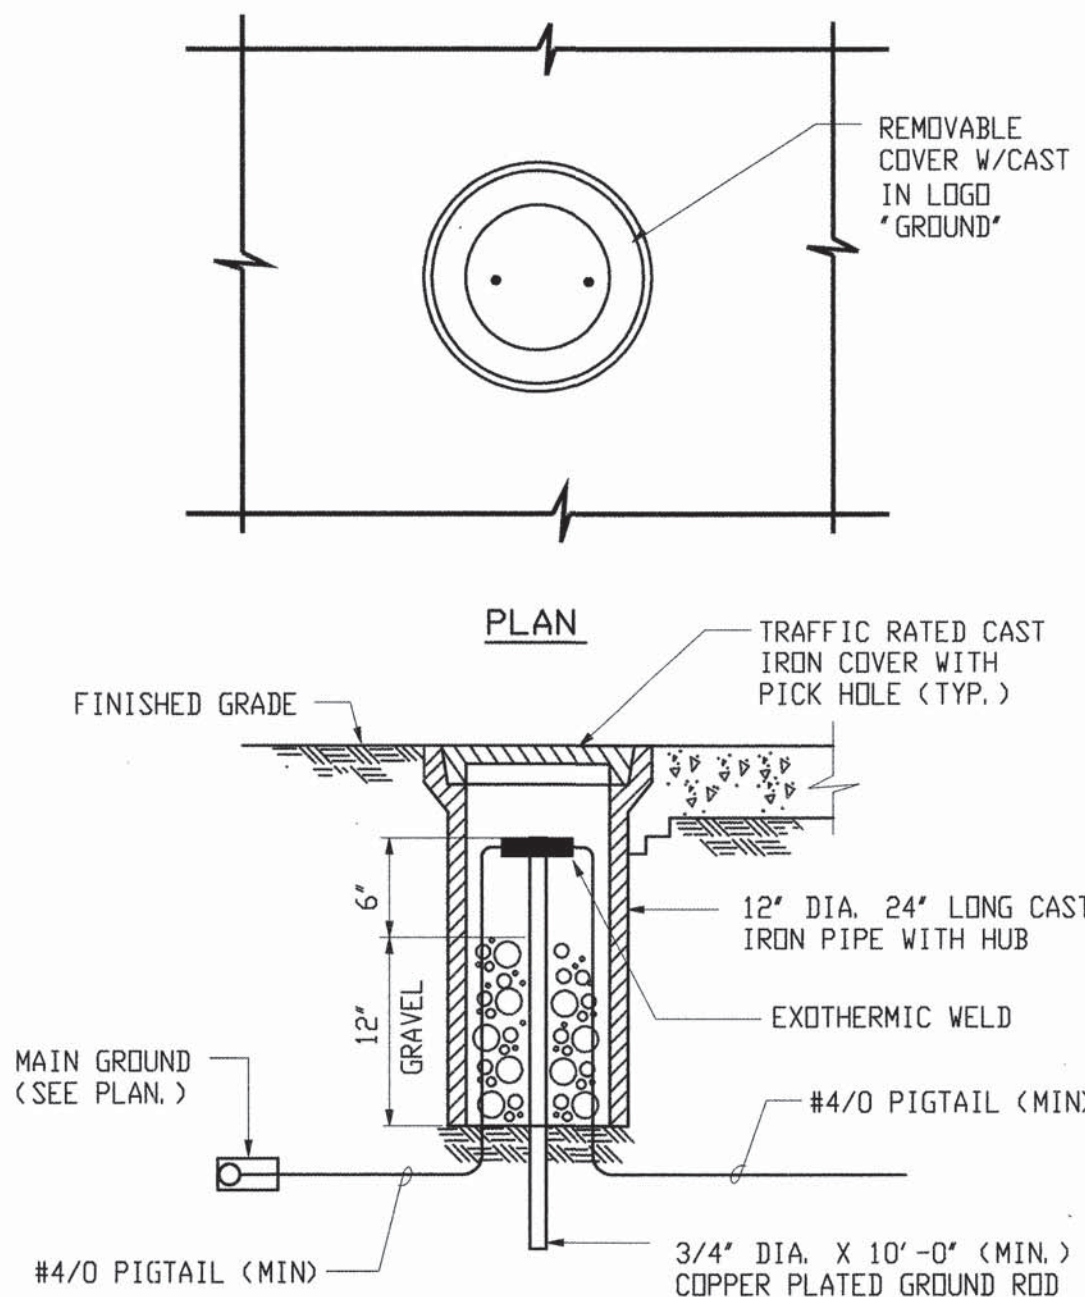


SECTION
ELECTRICAL GROUND WELL DETAIL
NOT TO SCALE
(PROVIDE AT EACH GROUND ROD LOCATION)

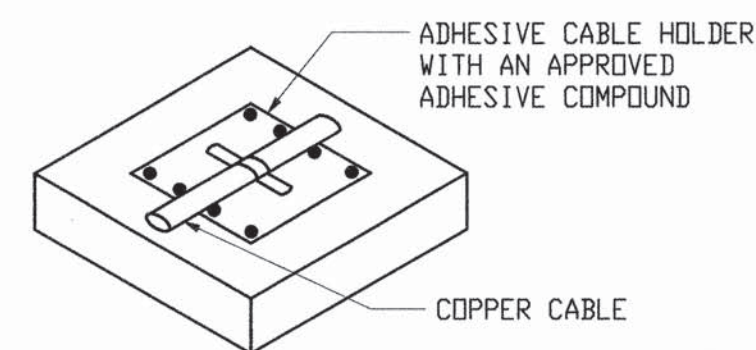

TYPICAL ADHESIVE CABLE HOLDER
NOT TO SCALE

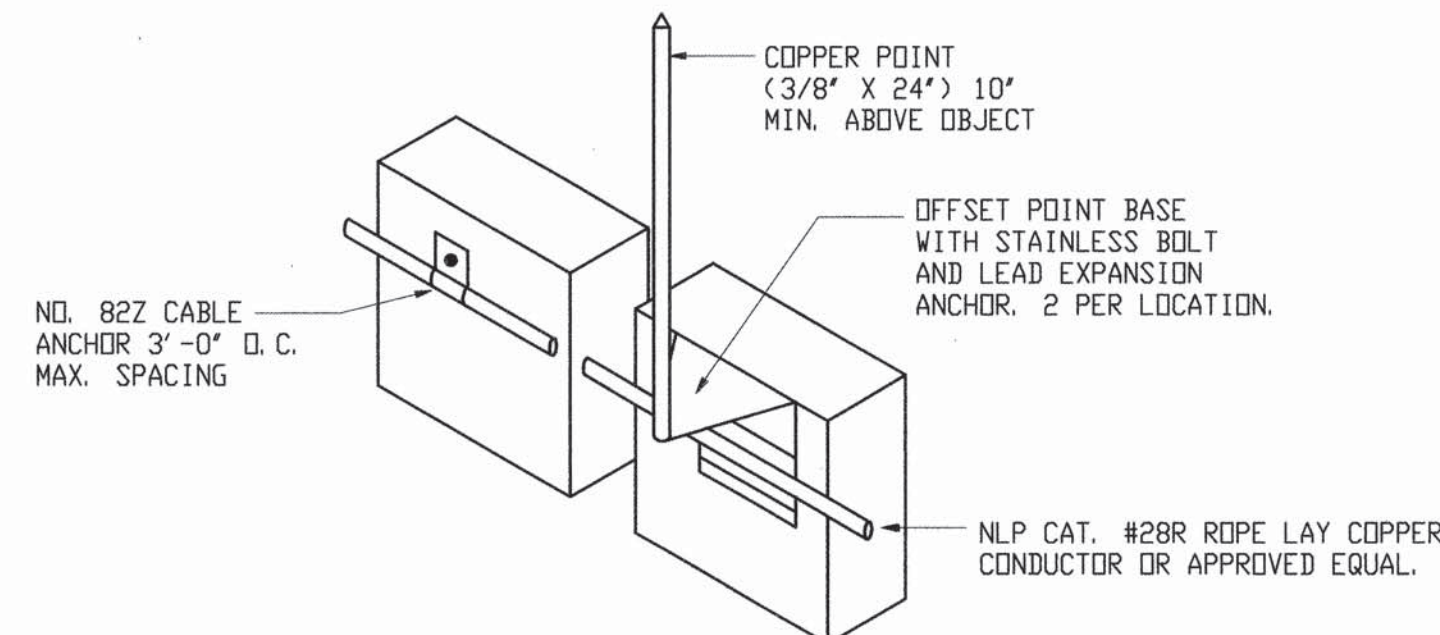


TYPICAL OFFSET AIR TERMINAL
NOT TO SCALE

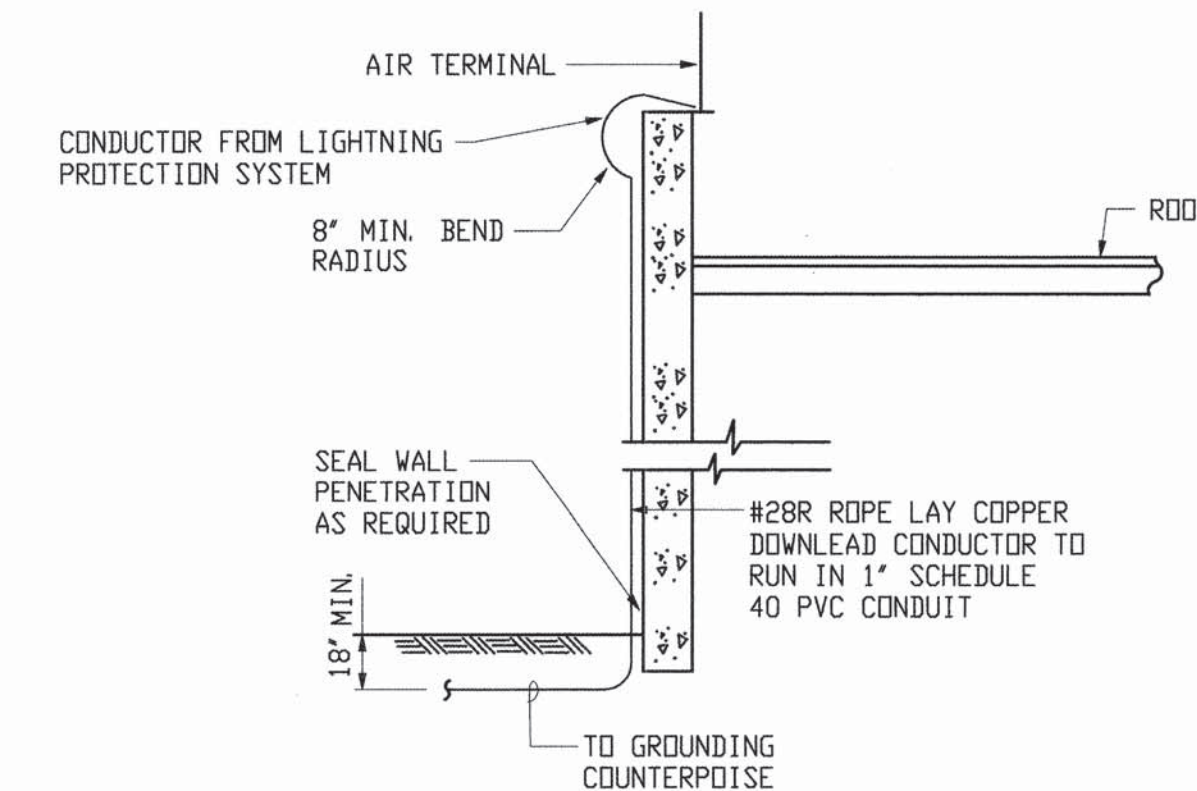


TYPICAL DOWNLEAD DETAIL
NOT TO SCALE

GENERAL NOTES ON LIGHTNING PROTECTION

1. DEVICE AND COMPONENT NUMBERS CALLED OUT ARE SPECIFIC TO NATIONAL LIGHTNING PROTECTION CORPORATION, UNLESS OTHERWISE NOTED.
2. SEE SPECIFICATIONS FOR ADDITIONAL REQUIREMENTS.
3. CONDUCTOR BEND SHALL NOT FORM A SHARPER ANGLE THAN 90 DEGREES OR HAVE A RADIUS LESS THAN 8 INCHES.
4. METAL BODIES OF INDUCTANCE LOCATED WITHIN 6' OF MAIN LIGHTNING CONDUCTORS SHALL BE BONDED TO THE LIGHTNING PROTECTION SYSTEMS.
5. CONNECTIONS TO GROUND AND COUNTERPOISE SHALL BE MADE AT A POINT NOT LESS THAN 2'-0" BELOW GRADE, AND 3'-0" AWAY FROM FOUNDATION WALL.
6. JOB CONDITIONS MAY DICTATE SLIGHT VARIATIONS IN AIR TERMINAL AND GROUND LOOP LOCATIONS.
7. CONDUCTORS SHALL MAINTAIN A HORIZONTAL OR DOWNWARD PATH FREE FROM 'U' AND 'V' POCKETS. ANY RISE IN HORIZONTAL CONDUCTOR SHALL NOT EXCEED 6 INCHES.
8. AIR TERMINAL SHALL BE PLACED AT THE LOCATIONS INDICATED. NOT MORE THAN 2'-0" FROM THE ENDS OF RIDGES, OUTSIDE CORNERS OR OUTSIDE EDGES OF MAIN ROOFS AND MUST EXTEND A MINIMUM OF 10' ABOVE THE OBJECT TO BE PROTECTED.
9. COPPER LIGHTNING PROTECTION MATERIALS SHALL NOT BE PLACED ON ALUMINUM SURFACES, NOR SHALL ALUMINUM MATERIALS BE PLACED ON COPPER SURFACES.
10. ALL STRUCTURAL STEEL SHALL BE MADE ELECTRICALLY CONTINUOUS THROUGH CONSTRUCTION.
11. ELECTRIC AND ANTENNA SYSTEM GROUNDS SHALL BE CONNECTED WITH #4/0 COPPER CONDUCTOR TO ONE LIGHTNING PROTECTION GROUND.
12. A LIGHTNING ARRESTOR, PROTECTOR OR ANTENNA-DISCHARGE UNIT MUST BE INSTALLED ON EACH ELECTRIC SERVICE ENTRANCE AND RADIO ANTENNA LEAD IN.
13. THE GENERAL CONTRACTOR IS RESPONSIBLE FOR MAKING ALL REBAR ELECTRICALLY CONTINUOUS.
14. ALL ADHESIVE FIXTURES SHALL BE SET WITH AN ADHESIVE COMPOUND COMPATIBLE WITH THE ROOFING MATERIAL. ADHESIVES SHALL BE APPROVED IN ADVANCE BY THE ROOFING CONTRACTOR.
15. SEAL THE ENDS OF CONDUIT MOISTURE TIGHT WITH DUCT SEAL, SILICONE OR LEAD WEDGES.
16. ALL EXOTHERMIC WELDS MUST BE INSPECTED BY THE OWNER'S REPRESENTATIVE OR THE INSPECTOR AND THE ENGINEER.

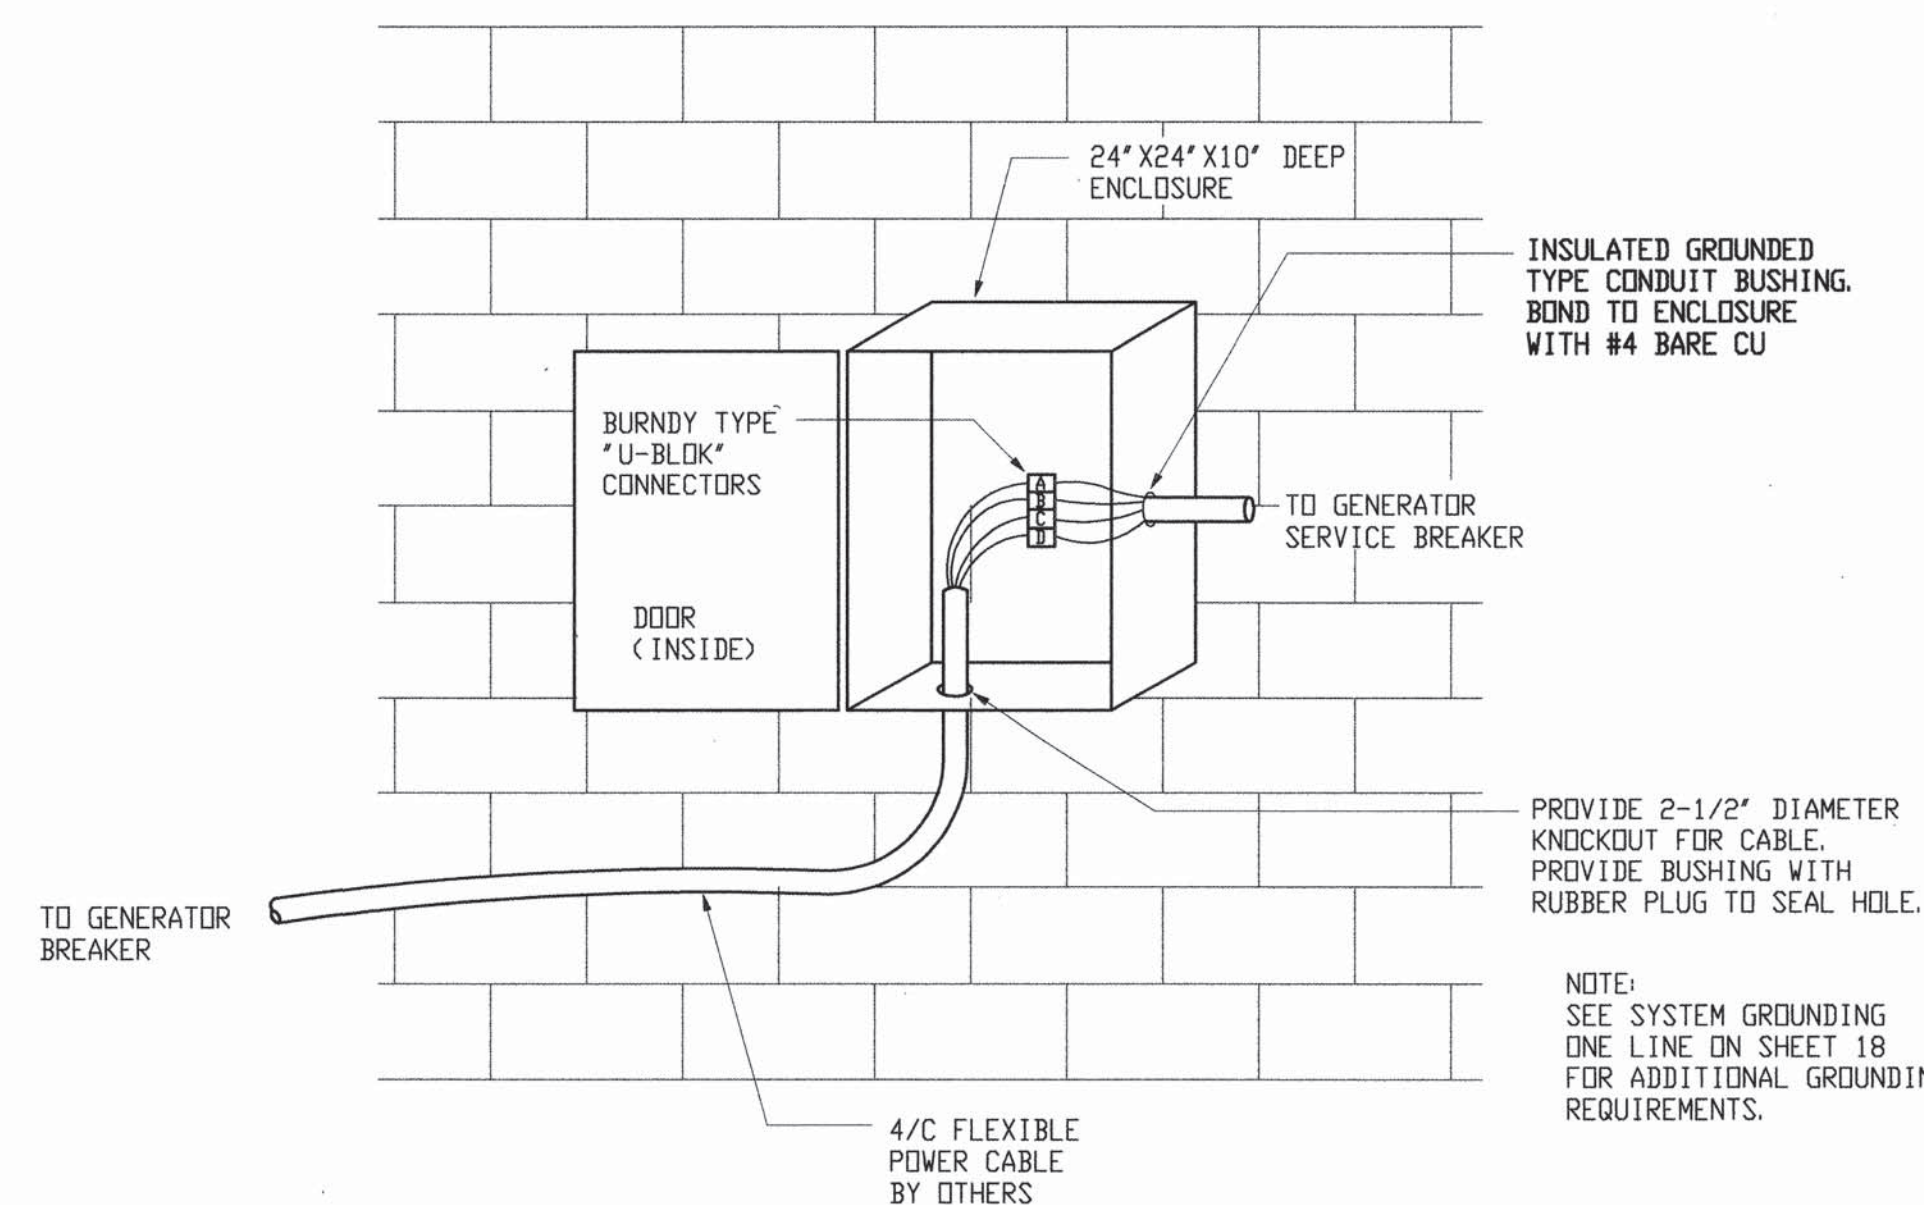

GENERATOR TERMINAL BOX CONNECTION DETAIL
NOT TO SCALE

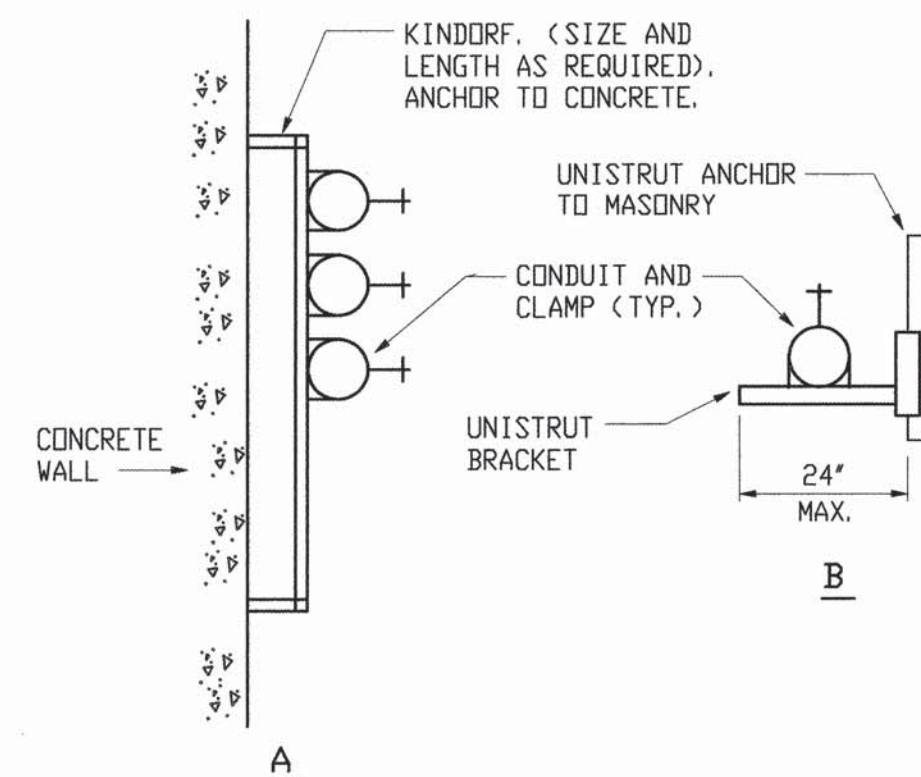

CONDUIT SUPPORT FROM WALL
NOT TO SCALE

AS-BUILT INFORMATION				BENCH MARKS			
CONTRACTOR: TRIAD BUILDERS OF NM	INSPECTED BY: TRAD	DATE: 11/99	DATE: 11/99				
VERIFIED BY: WILSON & CO.	DATE: 9/00	DATE: 9/00	DATE: 9/00				
MICRO-FILM INFORMATION							
RECORDED BY: WILSON & CO.	DATE: 9/00	DATE: 9/00	DATE: 9/00				
NO.	NO.	NO.	NO.				

SURVEY INFORMATION				ENGINEER'S SEAL			
FIELD NOTES							
NO.	BY	DATE	DATE				

REVISIONS				ENGINEER'S SEAL			
NO.	DATE	REMARKS	BY				

DESIGNED BY: J.H.	DATE: 2/22/99	DATE: 2/22/99	DATE: 2/22/99				
DRAWN BY: P.R.D.	DATE: 2/22/99	DATE: 2/22/99	DATE: 2/22/99				
CHECKED BY: R.J.P.	DATE: 2/22/99	DATE: 2/22/99	DATE: 2/22/99				




CITY PROJECT #567292

COUNTY OF BERNALILLO
ENVIRONMENTAL HEALTH AND
PUBLIC WORKS DEPARTMENTS

NORTH VALLEY AREAS B AND F
VACUUM STATION

ELECTRICAL - DETAILS

PROJECT NO. 96034 SHEET 19 OF 19

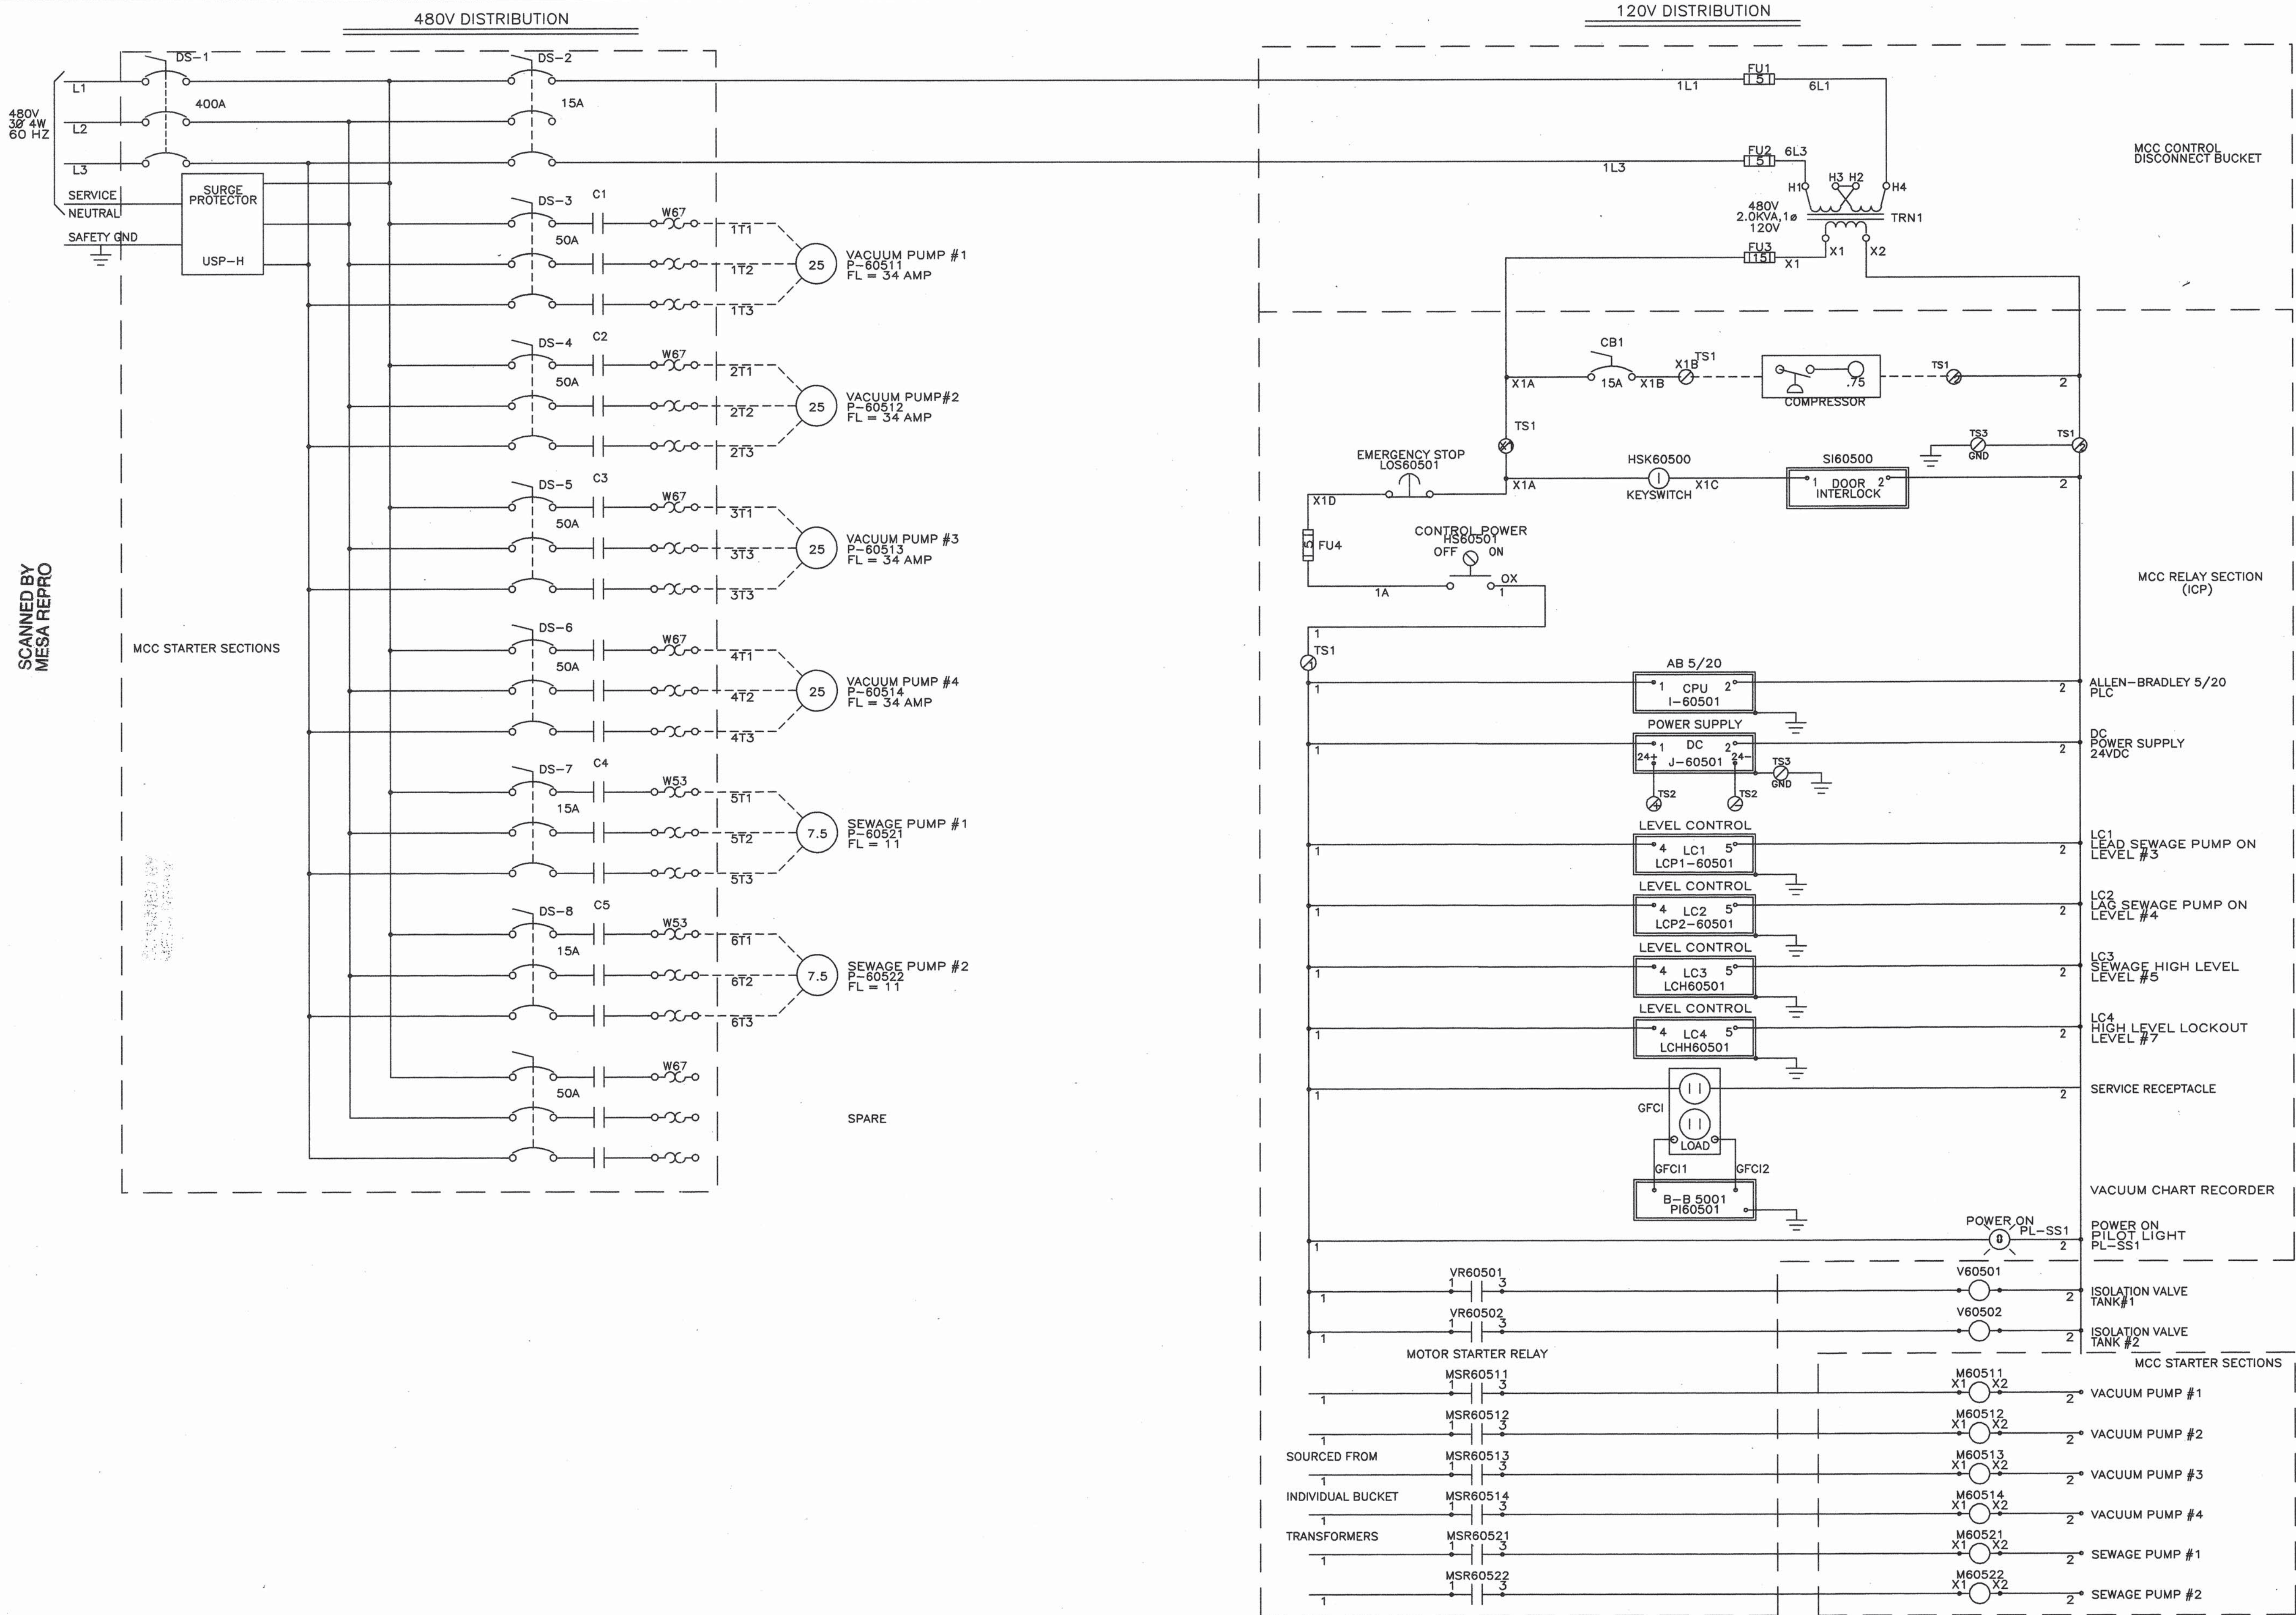

WILSON PROJECT NUMBER
96-210-034
CITY PROJECT NUMBER
567292
SHEET-20




IN CONSIDERATION OF THE RECEIPT OF THIS DOCUMENT, THE RECIPIENT AGREES NOT TO REPRODUCE, COPY, USE, OR TRANSMIT THIS DOCUMENT AND/OR THE INFORMATION THEREIN CONTAINED IN WHOLE OR IN PART, OR TO SUFFER SUCH ACTION BY OTHER, FOR ANY PURPOSE EXCEPT WITH THE WRITTEN PERMISSION OF AIRVAC, INC. AND FURTHER AGREES TO SURRENDER SAME TO AIRVAC, INC. UPON DEMAND.

VACUUM SEWER SYSTEMS

AIRVAC, INC.
P.O. BOX 528, 4217 N. OLD U.S. 31, ROCHESTER, INDIANA 46975 U.S.A.

TELEPHONE (219) 223-3980
FAX (219) 223-5566

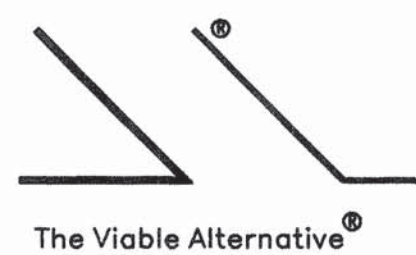

COPYRIGHT © AIRVAC, INC.

AS BUILT

REVISIONS

11/30/99

DATE

POWER DISTRIBUTION

CLIENT AREA B&F: ALBUQUERQUE, NM

DRAWN BY RJB

DESIGN BY









DATE 06-21-99

COPYRIGHT © AIRVAC

SCALE

DRAWING NO.

PJ99-122

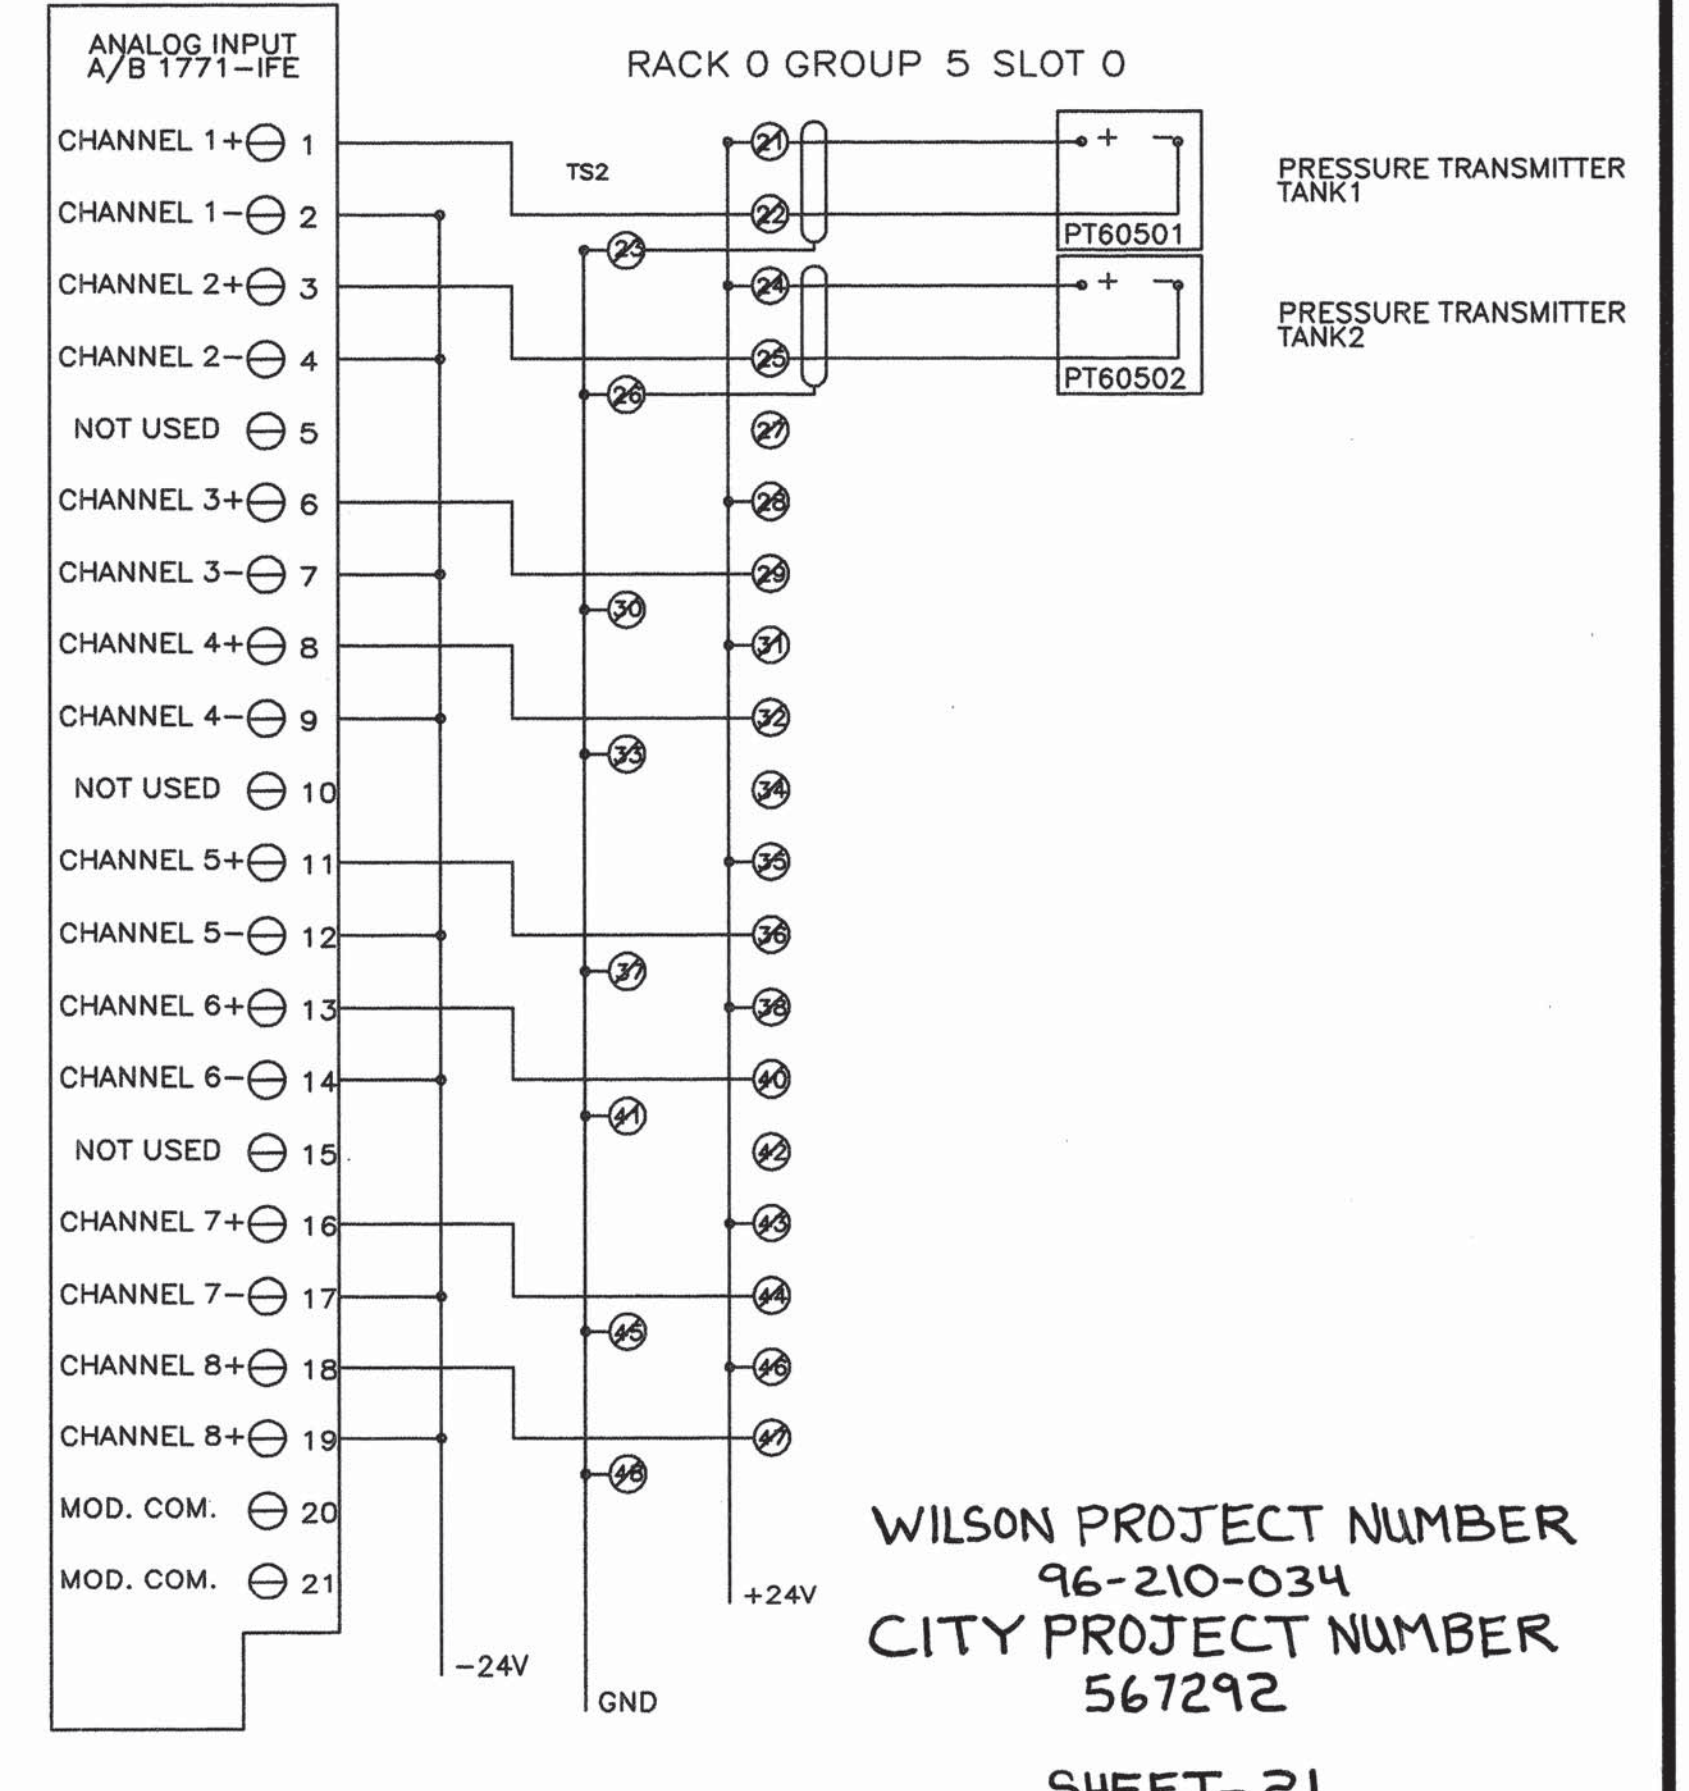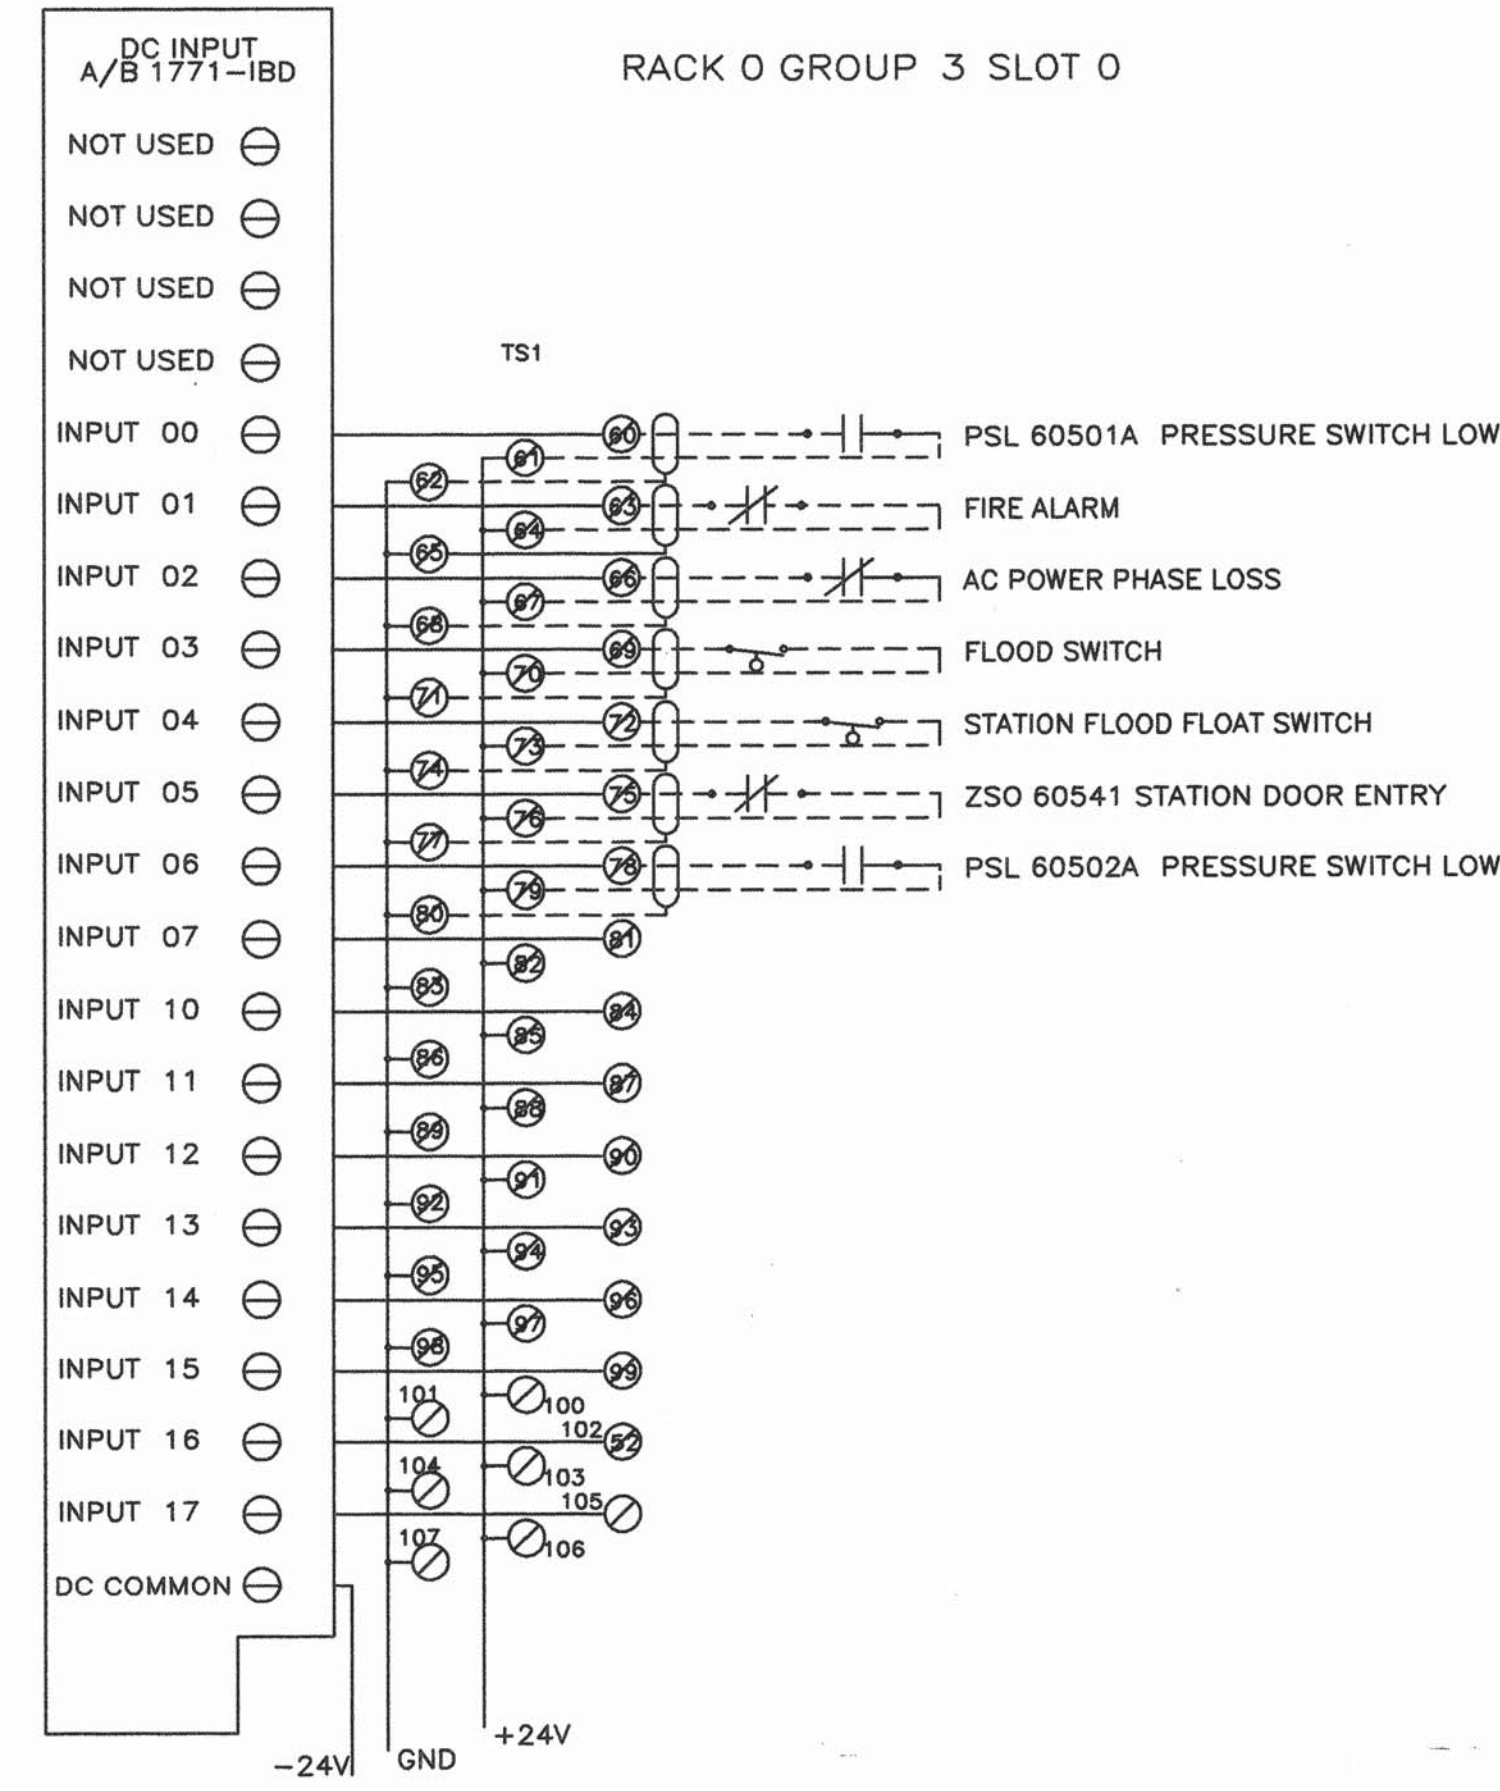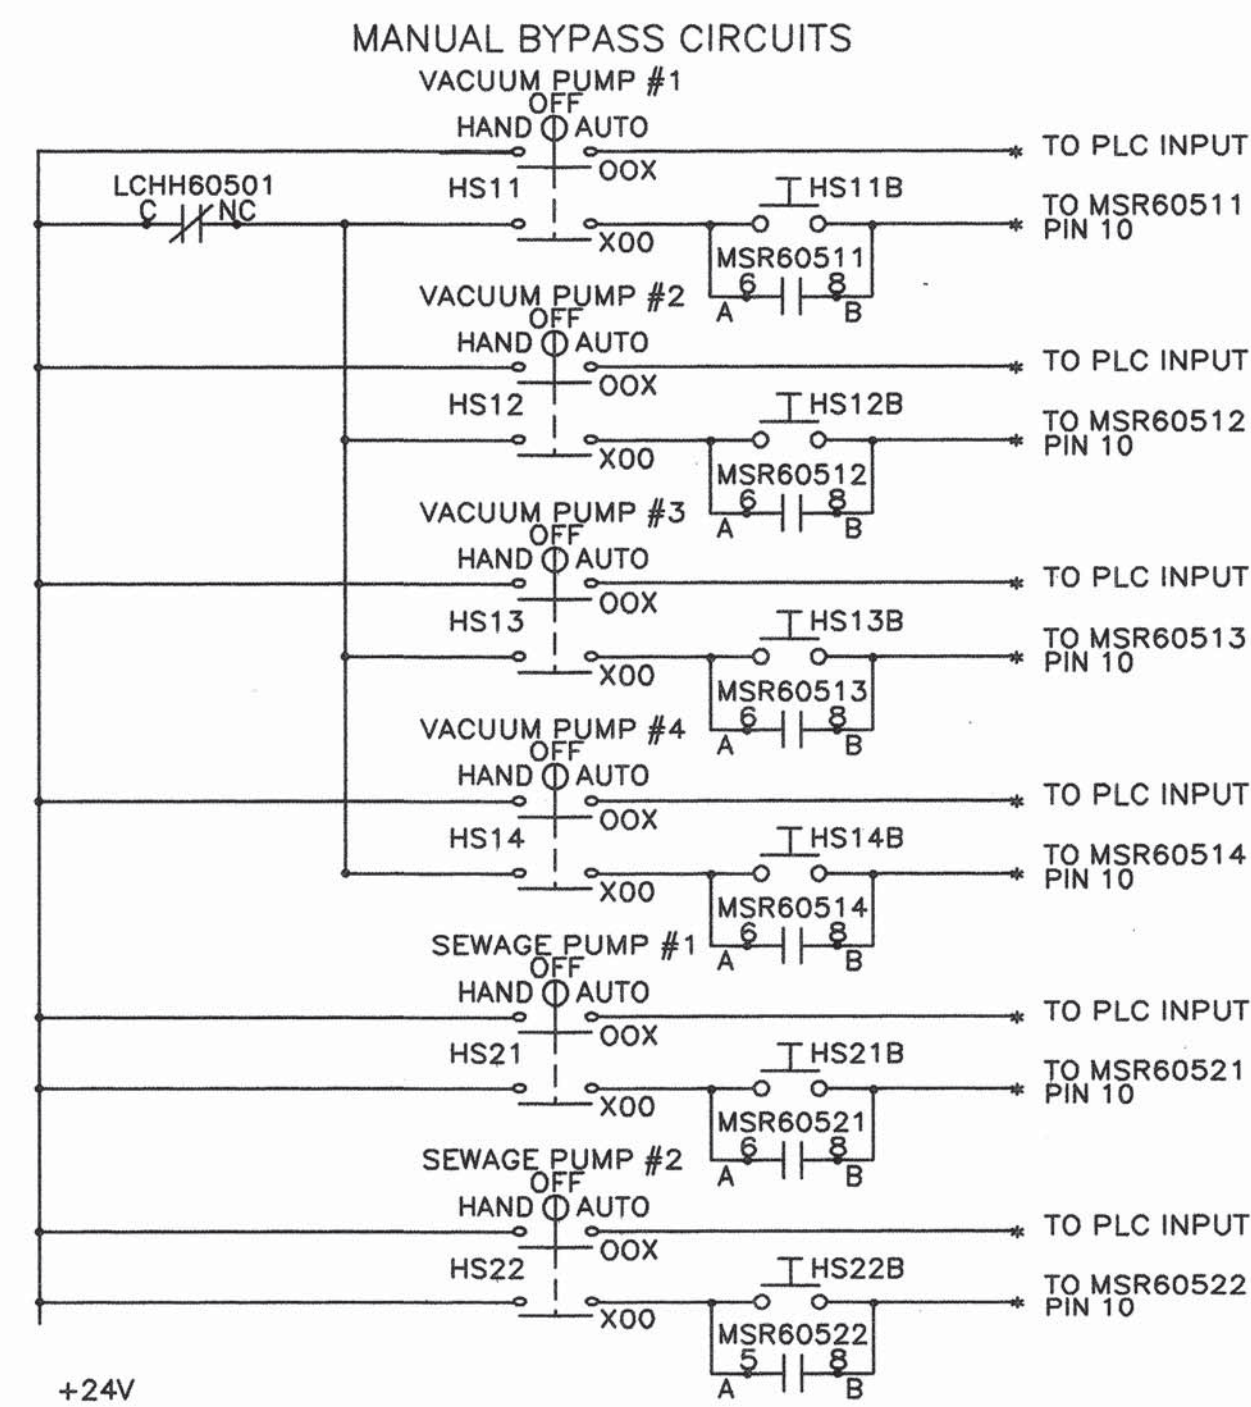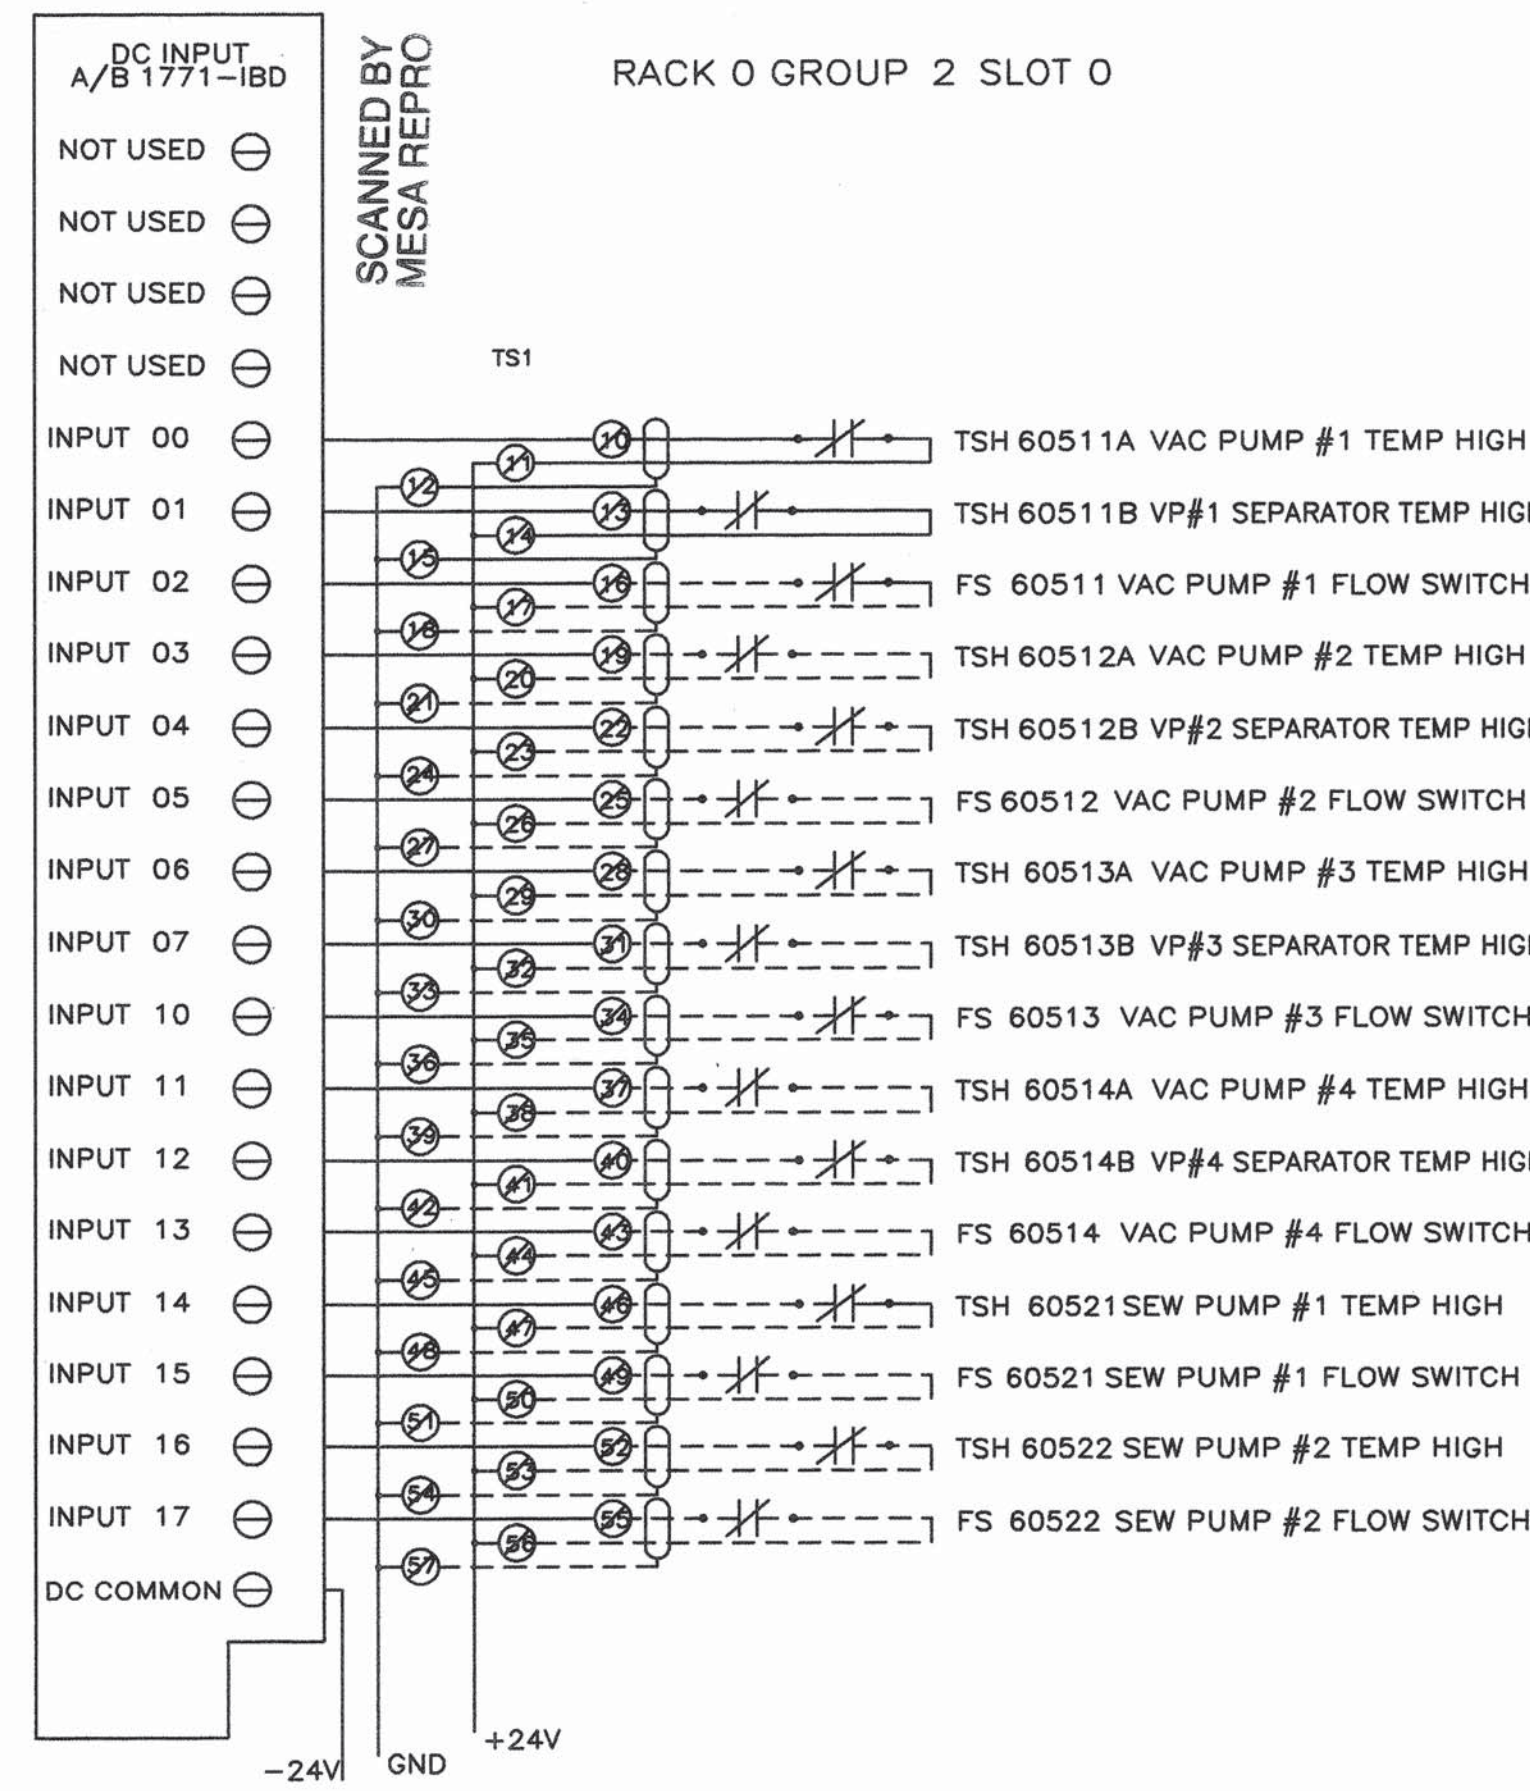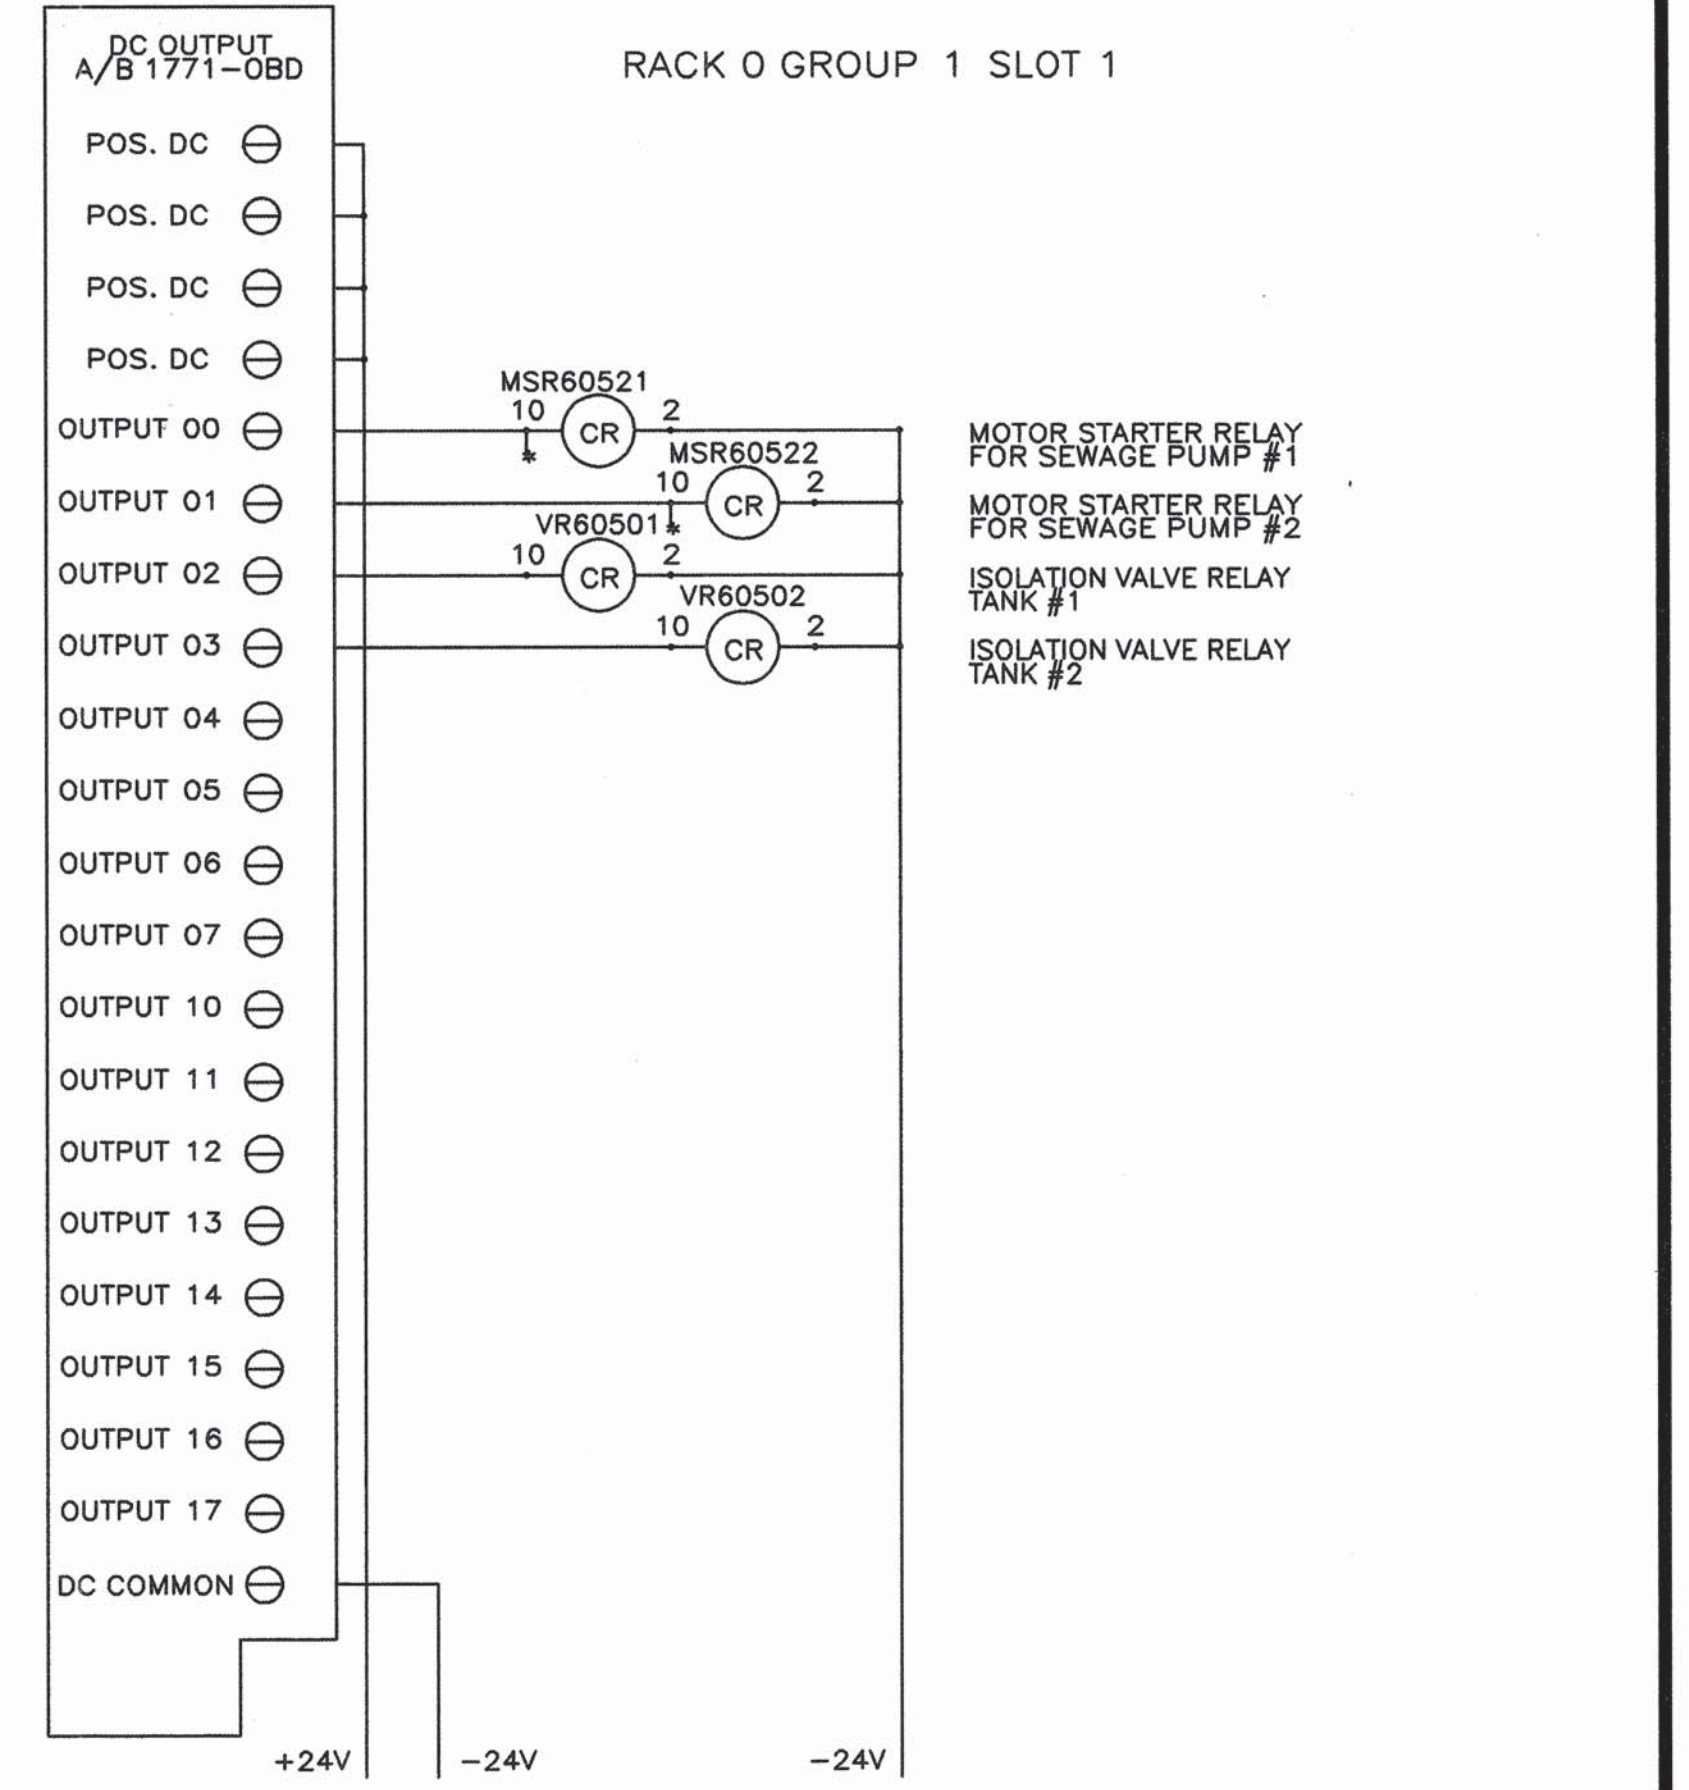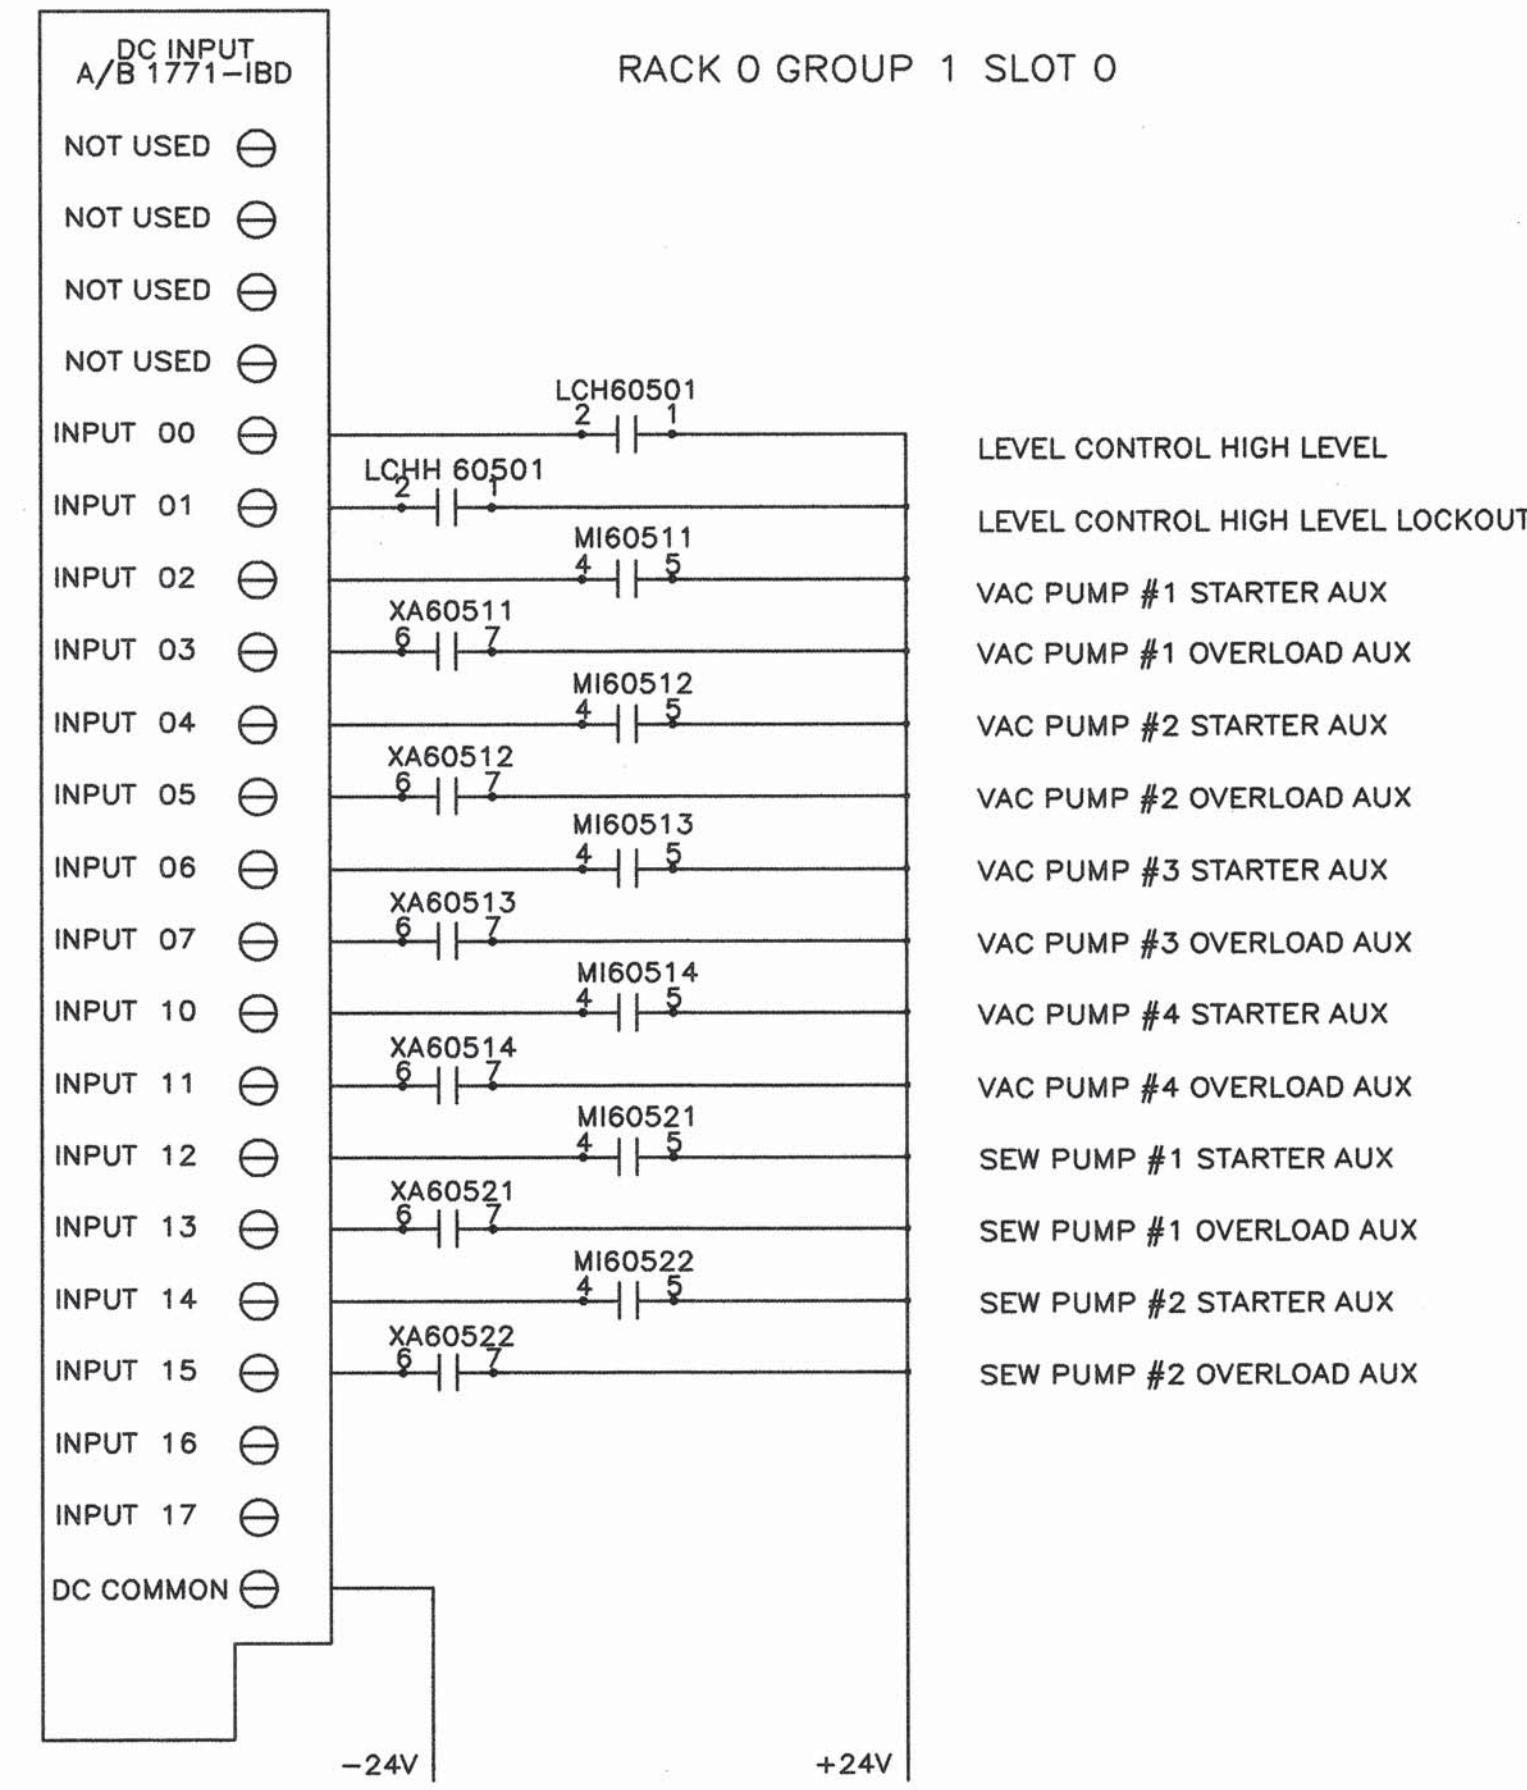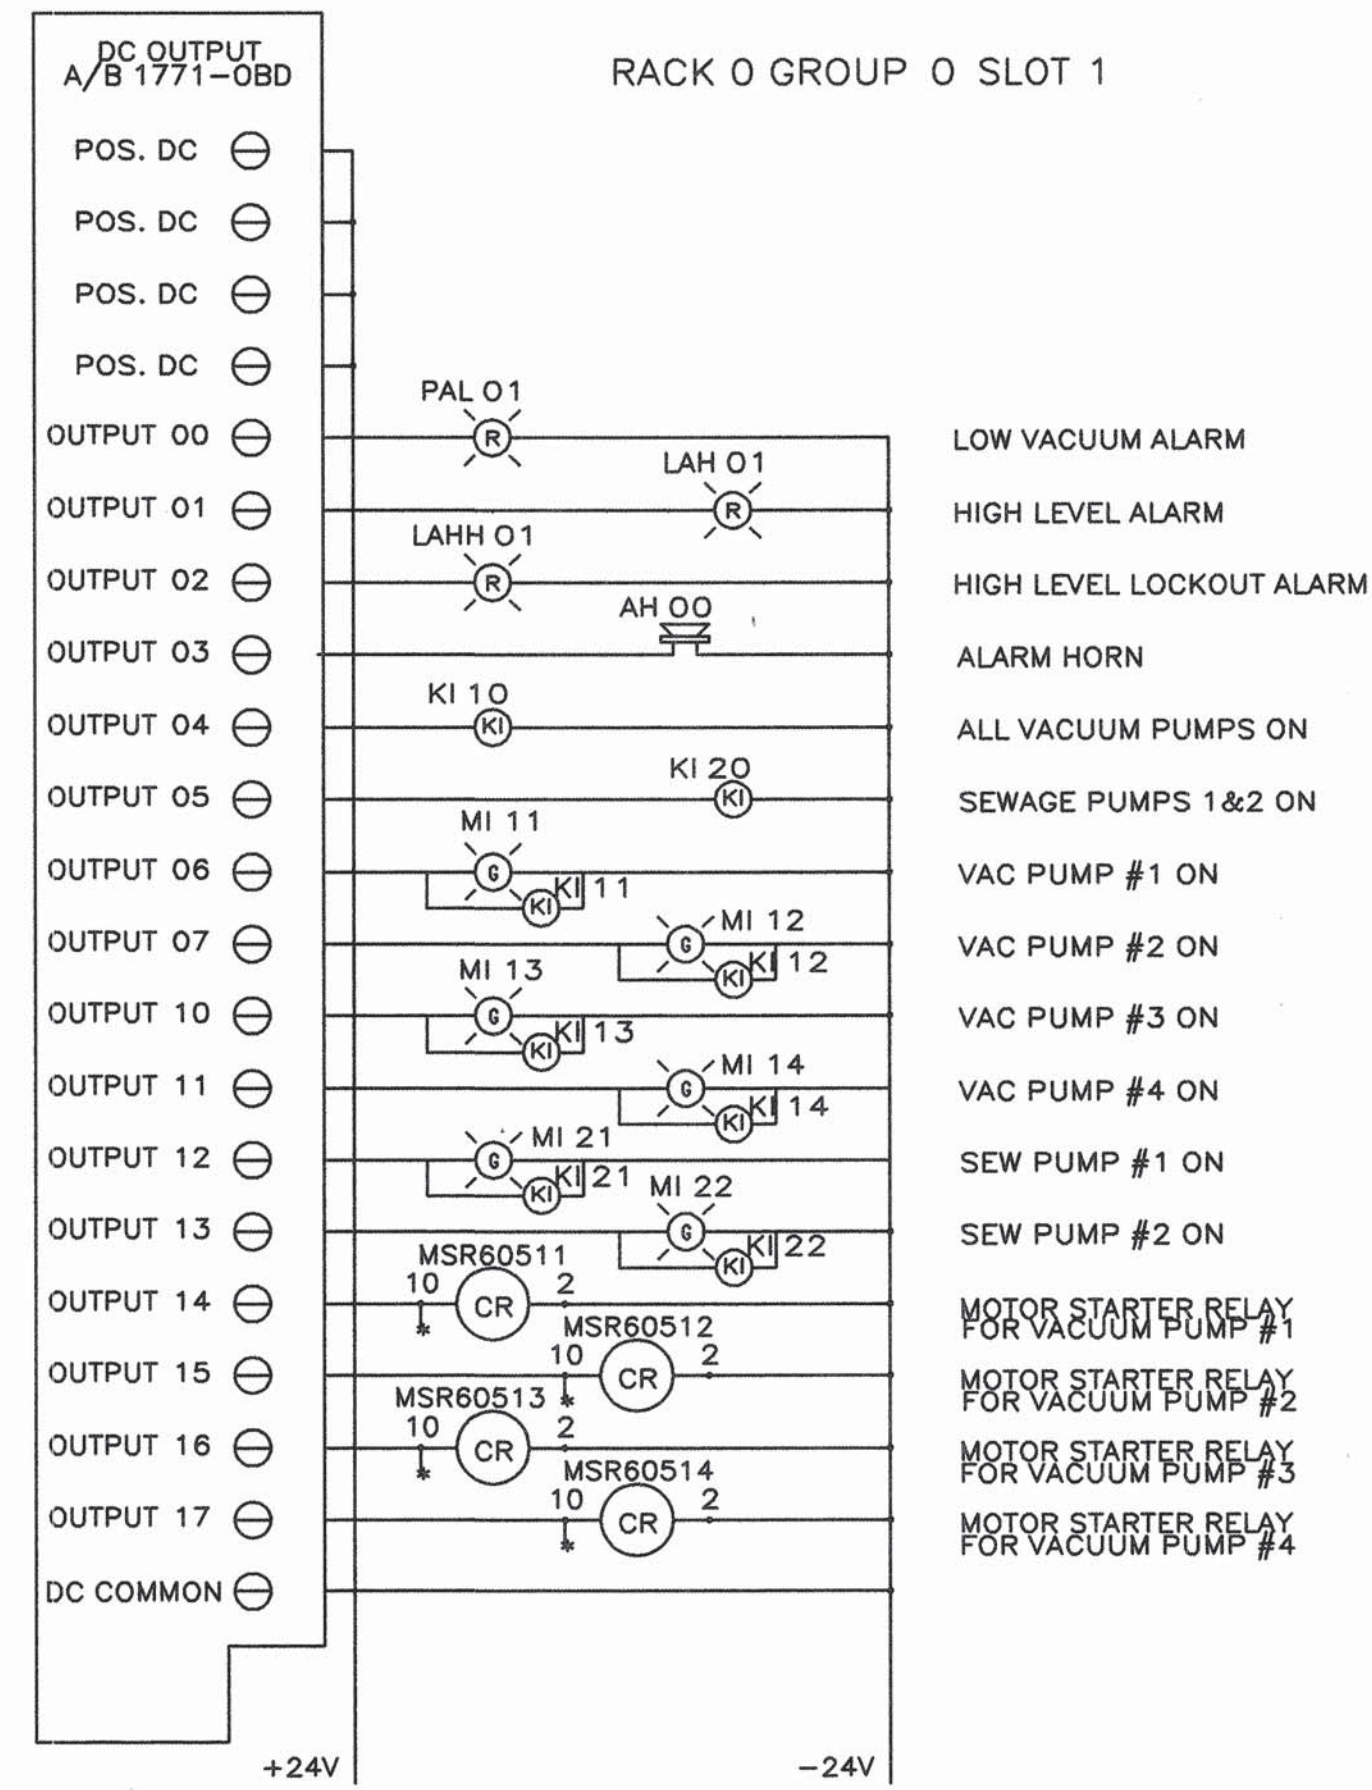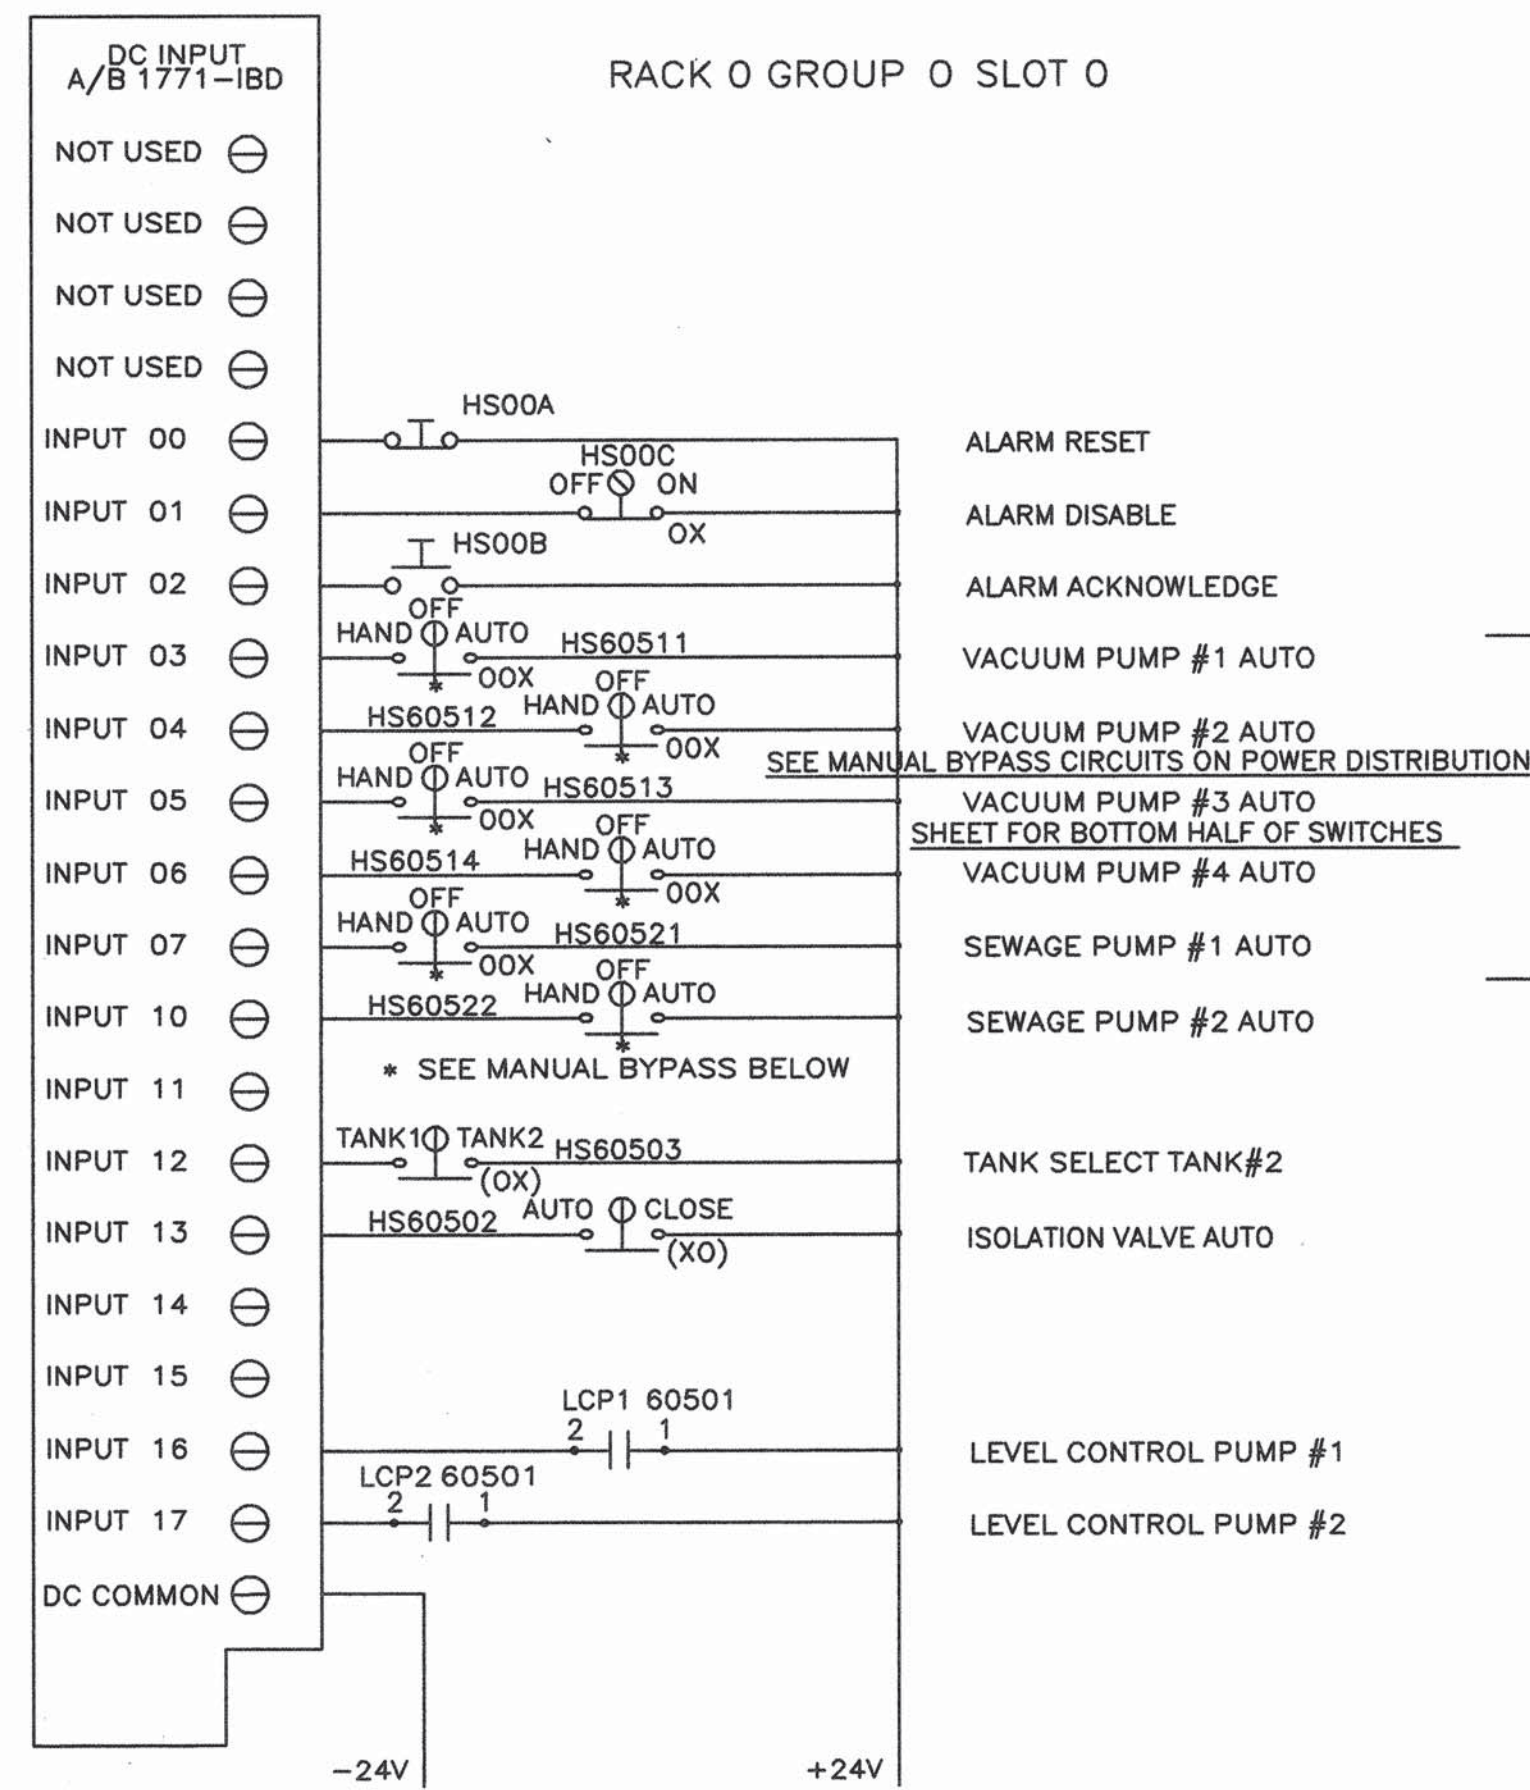

WILSON PROJECT NUMBER
96-210-034
CITY PROJECT NUMBER
567292

SHEET- 21

AIRVAC

IN CONSIDERATION OF THE RECEIPT OF THIS DOCUMENT, THE RECIPIENT AGREES NOT TO REPRODUCE, COPY, USE, OR TRANSMIT THIS DOCUMENT AND/OR THE INFORMATION THEREIN CONTAINED IN WHOLE OR IN PART, OR TO SUFFER SUCH ACTION BY OTHER, FOR ANY PURPOSE EXCEPT WITH THE WRITTEN PERMISSION OF AIRVAC, INC. AND FURTHER AGREES TO SURRENDER SAME TO AIRVAC, INC. UPON DEMAND.

VACUUM SEWER SYSTEMS

AIRVAC, INC.
P.O. BOX 528, 4217 N. OLD U.S. 31, ROCHESTER, INDIANA 46975 U.S.A.

TELEPHONE (219) 223-3980
FAX (219) 223-5566

The Viable Alternative

COPYRIGHT © AIRVAC, INC.

AS BUILT

REVISIONS

11/30/99

DATE

TITLE

I/O LAYOUT

CLIENT

AREA B&F: ALBUQUERQUE, NM

DRAWN BY

RJB

DATE




06-21-99

SCALE

DRAWING NO.

PJ99-123

SCANNED BY
MESA REPRO

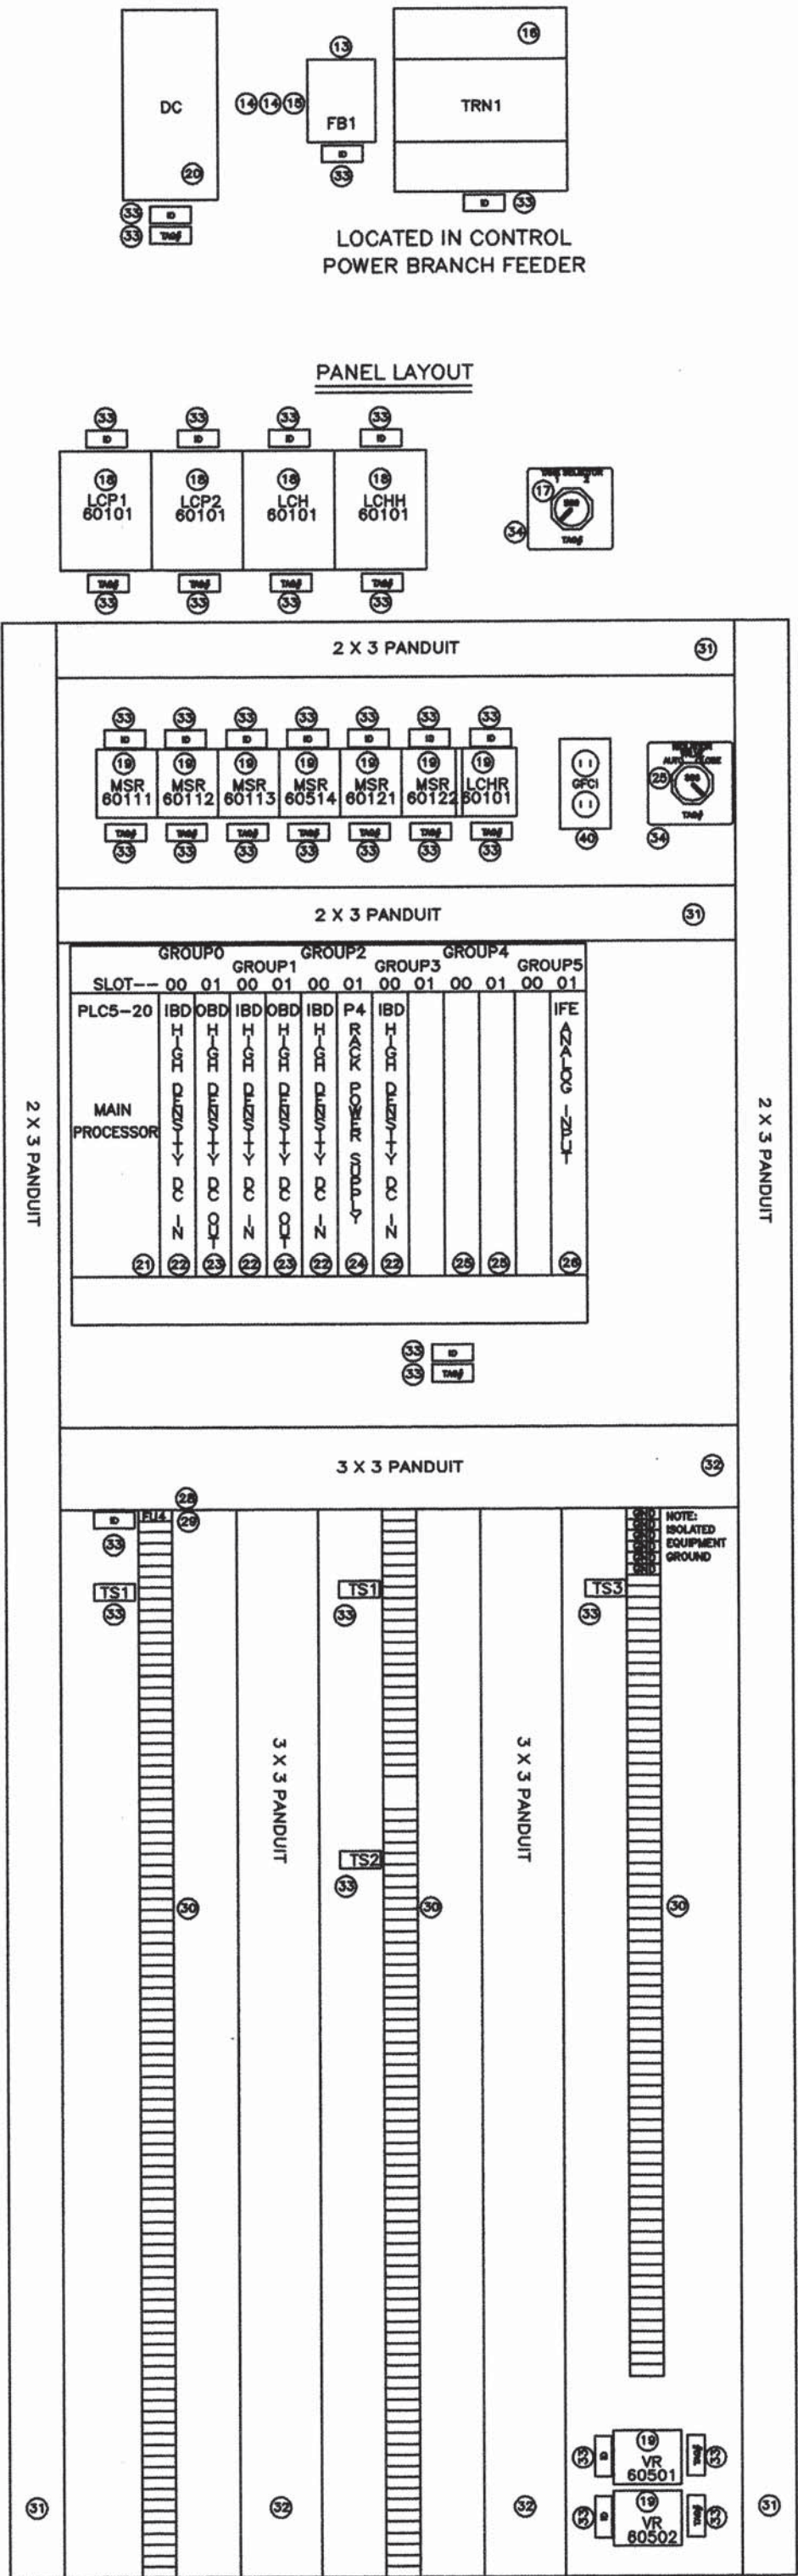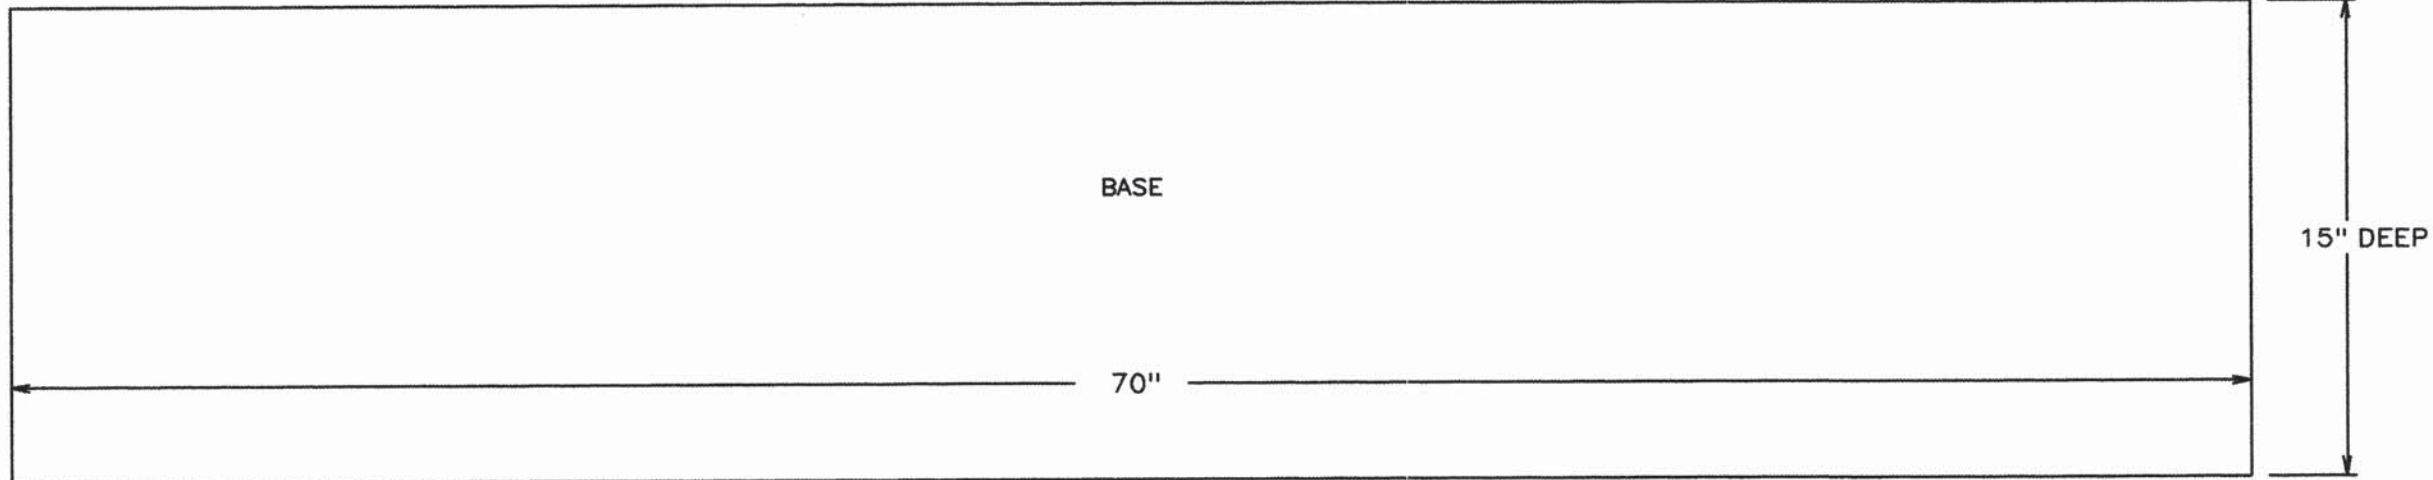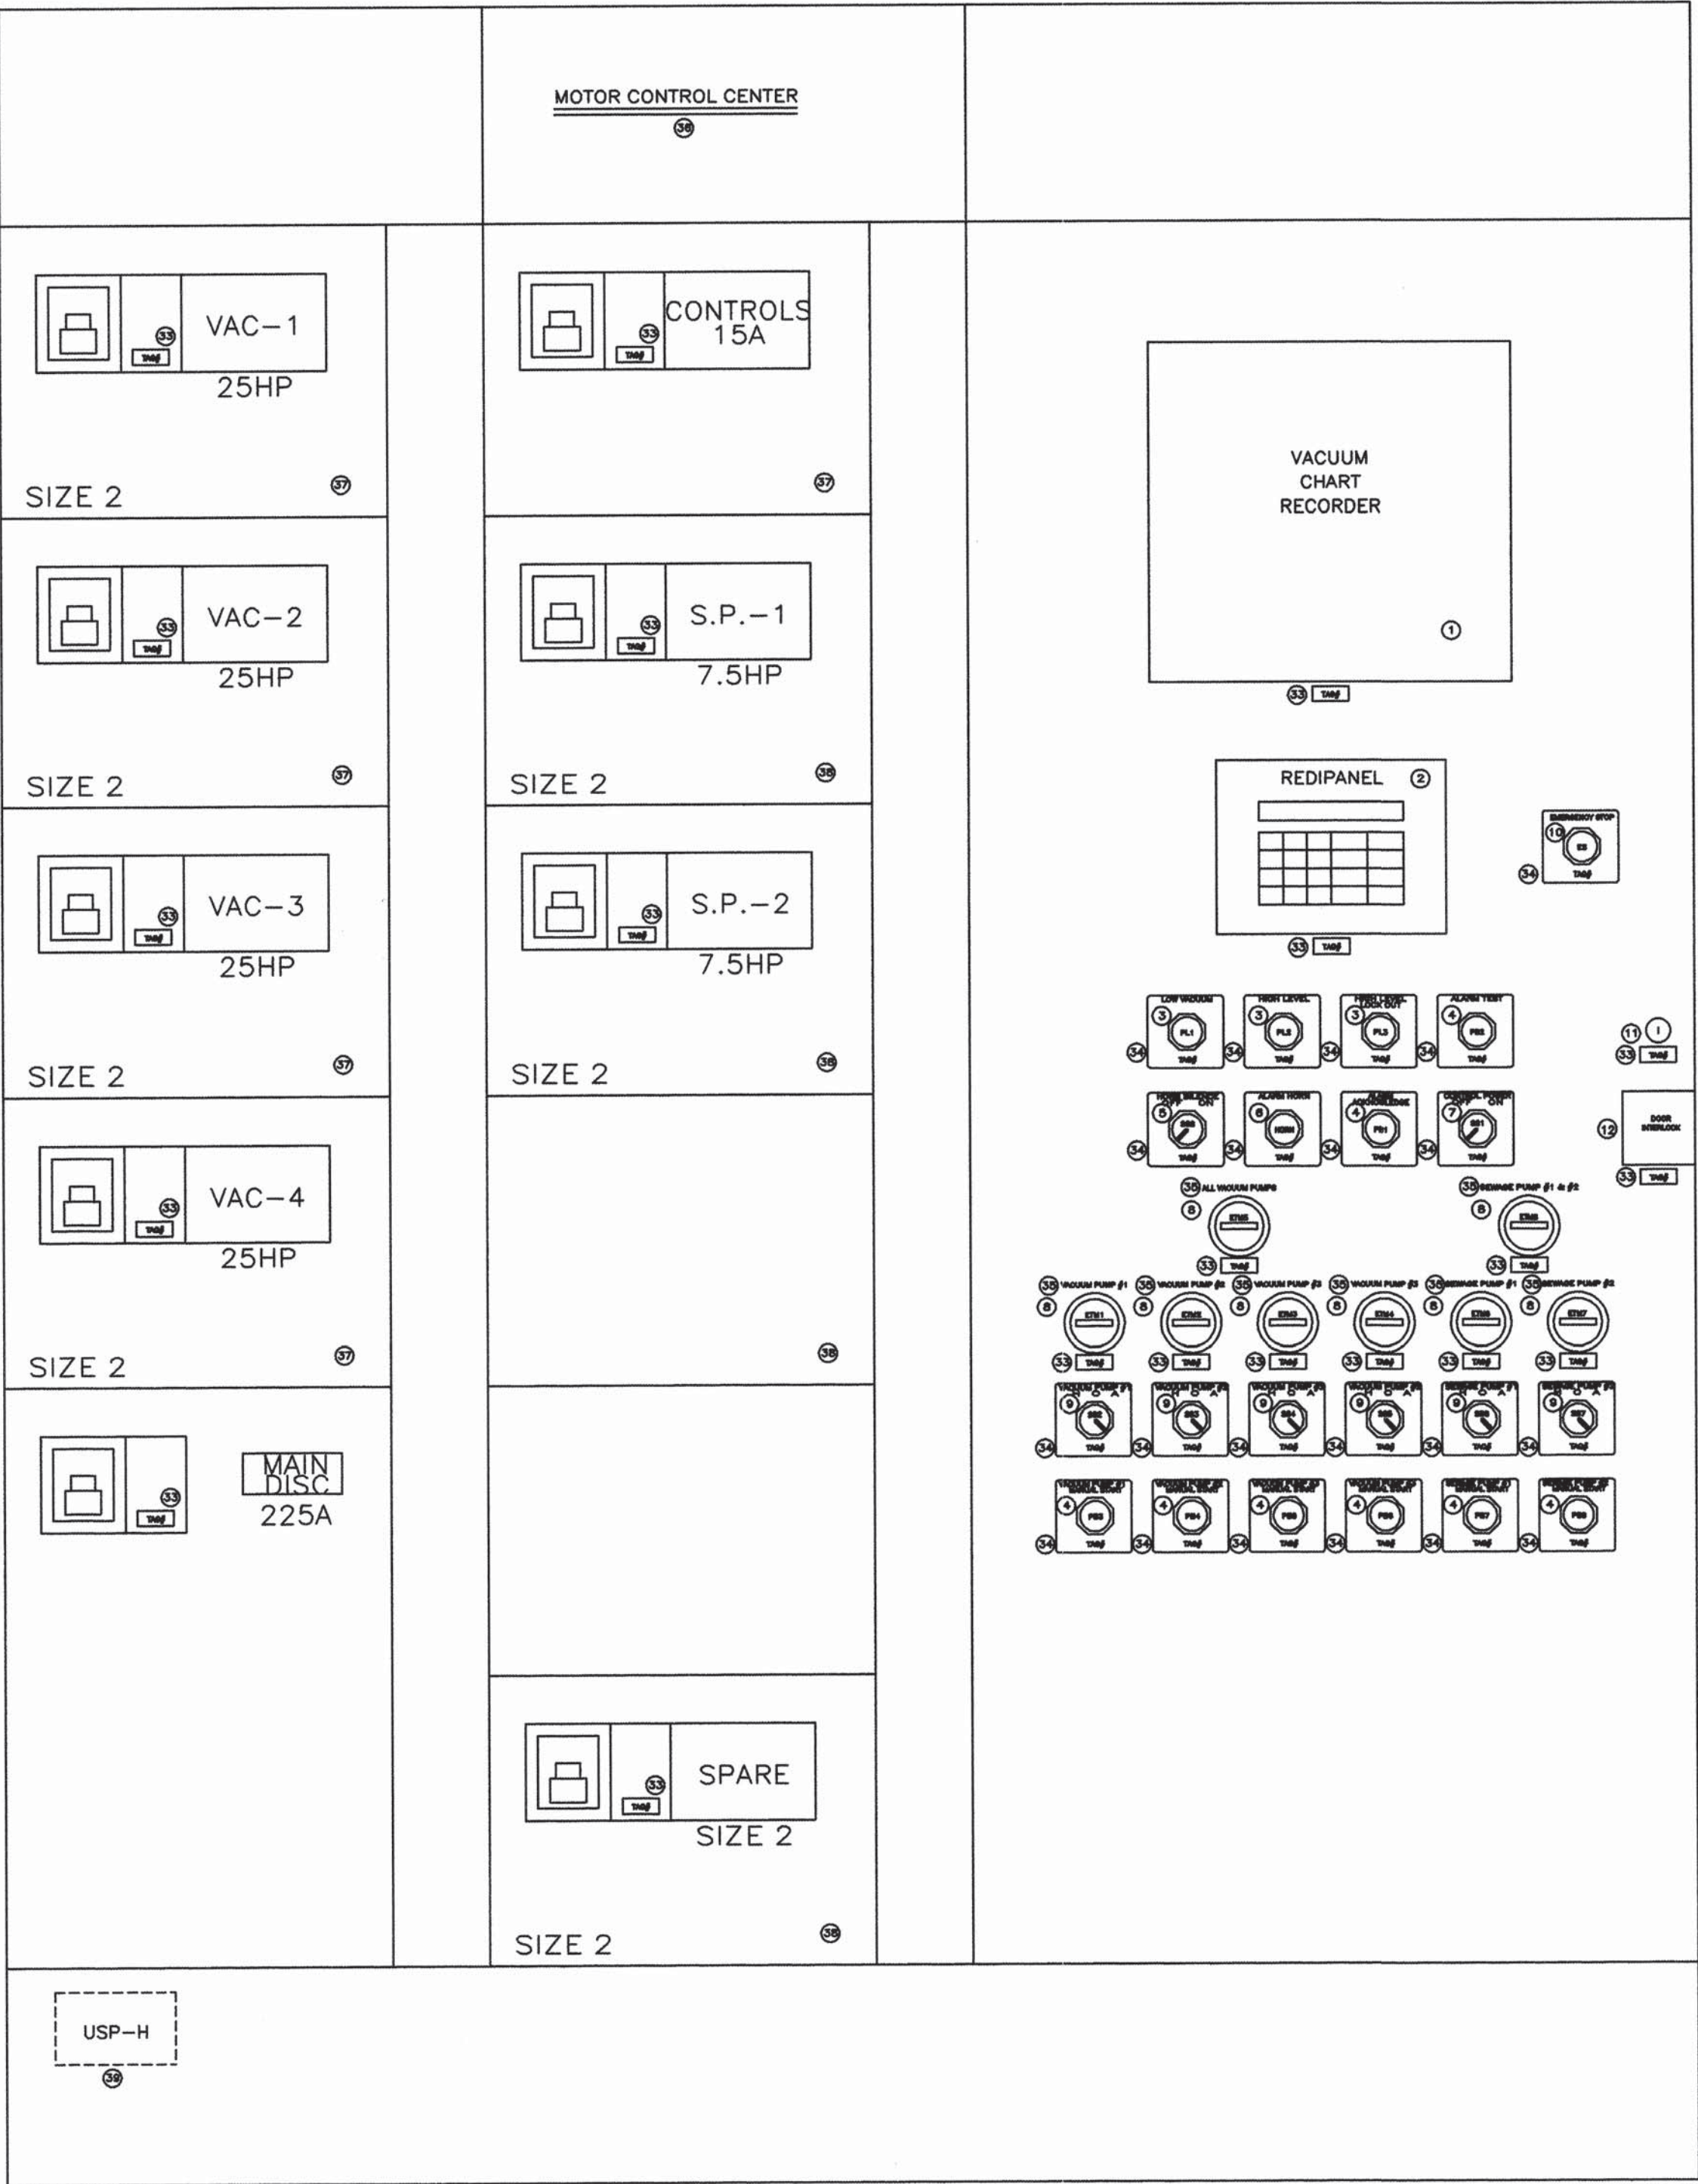

BILL OF MATERIAL						
ITEM	QTY	UNIT	LOCH	PART NUMBER	DESCRIPTION	MANUFACTURER
1	1	EA	P	5001-10A-171-001-323-412-000	VACUUM CHART RECORDER	BRISTOL-BABCOCK
2	1	EA	P	2705-K11C1	OPERATOR INTERFACE	ALLEN BRADLEY
3	3	EA	P	800T-Q24LR	PILOT LIGHT, RED	ALLEN BRADLEY
4	10	EA	P	800T-A2B	PUSHBUTTON, MOMENTARY	ALLEN BRADLEY
5	1	EA	P	800T-H2A	SELECTOR SWITCH, 2 POSITION	ALLEN BRADLEY
6	1	EA	P	SC628ANP	ALARM HORN	MALLORY
7	1	EA	P	800T-16HRL2KB6AX	SELECTOR SWITCH, GREEN, ILL	ALLEN BRADLEY
8	7	EA	P	779565-216	ELAPSED TIME METER	VEEDER-ROOT
9	6	EA	P	800T-24JGL2KB7AX	SELECTOR SWITCH, 3 POS	ALLEN BRADLEY
10	1	EA	P	800T-FX6A5	EMERGENCY STOP, MUSHROOM	ALLEN BRADLEY
11	1	EA	P	800T-N314	PADLOCKING ATTACHMENT	ALLEN BRADLEY
12	1	EA	P	A-EKDF	KEYSWITCH	HOFFMAN
13	1	EA	P	A-EK115NDH	DOOR INTERLOCK	HOFFMAN
14	2	EA	B	BM6033PQ	FUSE BLOCK	BUSSMAN
15	1	EA	B	FNO-R-5	FUSE	BUSSMAN
16	1	EA	B	FNM 15	FUSE	BUSSMAN
17	1	EA	B	50-2000-053	CONTROL TRANSFORMER	DONGAN
18	1	EA	B	800T-H5D1	SELECTOR SW, 2POS SPR FR RT	ALLEN BRADLEY
19	4	EA	B	27A1E0	LEVEL CONTROL	WARRICK
20	7	EA	B	KRPA14DN-24	CONTROL RELAY	POTTER&BRUMFIELD
21	7	EA	B	27E891	SOCKET	POTTER&BRUMFIELD
22	20	EA	B	W115D	POWER SUPPLY, 24VDC	DELTRON
23	1	EA	B	1785-L20B	5/20 CPU	ALLEN BRADLEY
24	4	EA	B	1771-IBD	DIGITAL INPUT MODULE	ALLEN BRADLEY
25	2	EA	B	1771-0BD	DIGITAL OUTPUT MODULE	ALLEN BRADLEY
26	1	EA	B	1771-P4S	POWER SUPPLY	ALLEN BRADLEY
27	1	EA	B	9001-KS11B	GANG SWITCH	SQUARE D
28	1	EA	B	1771-IFE	ANALOG INPUT MODULE	ALLEN BRADLEY
29	1	EA	B	1771-A3B1	MOUNTING RACK	ALLEN BRADLEY
30	1	EA	B	1492-H6	FUSED TERMINAL BLOCK	ALLEN BRADLEY
31	29	EA	B	MDA5	FUSE	BUSSMAN
32	300	EA	B	1492-F8	TERMINAL BLOCKS	ALLEN BRADLEY
33	16	FT	B	E2X3WH6	PLASTIC WIREWAY /W COVER	PANDUIT
34	10	FT	B	E3X3WH6	PLASTIC WIREWAY /W COVER	PANDUIT
35	47	EA	P/B	N/A	PHENOLIC NAMEPLATE (5/8" X 1 1/4") BLACK WITH WHITE LETTERS LINE: TAG# OR NAME	SS&E ENTERPRISES
36	23	EA	P	N/A	PHENOLIC NAMEPLATE (2 1/8" X 2 1/2") BLACK WITH WHITE LETTERS LINE 1: SERVICE DESCRIPTION LINE 2: CONT'D, IF NEEDED LINE 3: TAG #	SS&E ENTERPRISES
37	7	EA	P	N/A	PHENOLIC NAMEPLATE (5/8" X 3") BLACK WITH WHITE LETTERS LINE 1: SERVICE DESCRIPTION	SS&E ENTERPRISES
38	1	EA		SERIES 2100	MOTOR CONTROL CENTER WITH 4 - 25HP STARTERS, 2 - 7 1/2HP STARTERS 1 - 30" RELAY SECTION	ALLEN BRADLEY
39	9	EA	B	W67	OVERLOAD ELEMENTS	ALLEN BRADLEY
40	6	EA	B	W53	OVERLOAD ELEMENTS	ALLEN BRADLEY
41	1	EA	B	USPS-H-277/480-3P5W	SURGE SUPPRESSOR	LEA INTERNATIONAL
42	1	EA	B	6599	GROUND FAULT RECEPTACLE	LEVITON
SPARES:						
43	2	EA	B	FNO-R-5	FUSE	BUSSMAN
44	1	EA	B	FNM 10	FUSE	BUSSMAN
45	2	EA	B	MDA5	FUSE	BUSSMAN
46	3	EA	P	800T-N157	REPLACEMENT BULB	ALLEN BRADLEY
47	1	EA	P	800T-24JGL2KB7AX	SELECTOR SWITCH, 3 POS	ALLEN BRADLEY
48	1	EA	P	800T-H2A	SELECTOR SWITCH, 2 POSITION	ALLEN BRADLEY
49	1	EA	P	800T-A2B	PUSHBUTTON, MOMENTARY	ALLEN BRADLEY
50	3	EA	P	800T-XA	CONTACT BLOCK	ALLEN BRADLEY
51	1	EA	P	779565-206	ELAPSED TIME METER	VEEDER-ROOT
52	3	EA	B	W67	OVERLOAD ELEMENTS	WESTINGHOUSE
53	3	EA	B	W53	OVERLOAD ELEMENTS	WESTINGHOUSE

WILSON PROJECT NUMBER
46-210-034
CITY PROJECT NUMBER
567292
SHEET-22

AIRVAC®

IN CONSIDERATION OF THE RECEIPT OF THIS DOCUMENT, THE RECIPIENT AGREES NOT TO REPRODUCE, COPY, USE, OR TRANSMIT THIS DOCUMENT AND/OR THE INFORMATION THEREIN CONTAINED IN WHOLE OR IN PART, OR TO SUFFER SUCH ACTION BY OTHER, FOR ANY PURPOSE EXCEPT WITH THE WRITTEN PERMISSION OF AIRVAC, INC. AND FURTHER AGREES TO SURRENDER SAME TO AIRVAC, INC. UPON DEMAND.

VACUUM SEWER SYSTEMS

AIRVAC, INC.
P.O. BOX 528, 4217 N. OLD U.S. 31, ROCHESTER, INDIANA 46975 U.S.A.

TELEPHONE (219) 223-3980
FAX (219) 223-5566

The Viable Alternative®

COPYRIGHT © AIRVAC, INC.

AS BUILT

REVISIONS

12-01-99

DATE

TITLE

MATERIAL LIST

CLIENT

AREA B&F: ALBUQUERQUE, NM

DRAWN BY

DATE


06-21-99

SCALE

DRAWING NO.

PJ99-124


POINT TO POINT WIRING

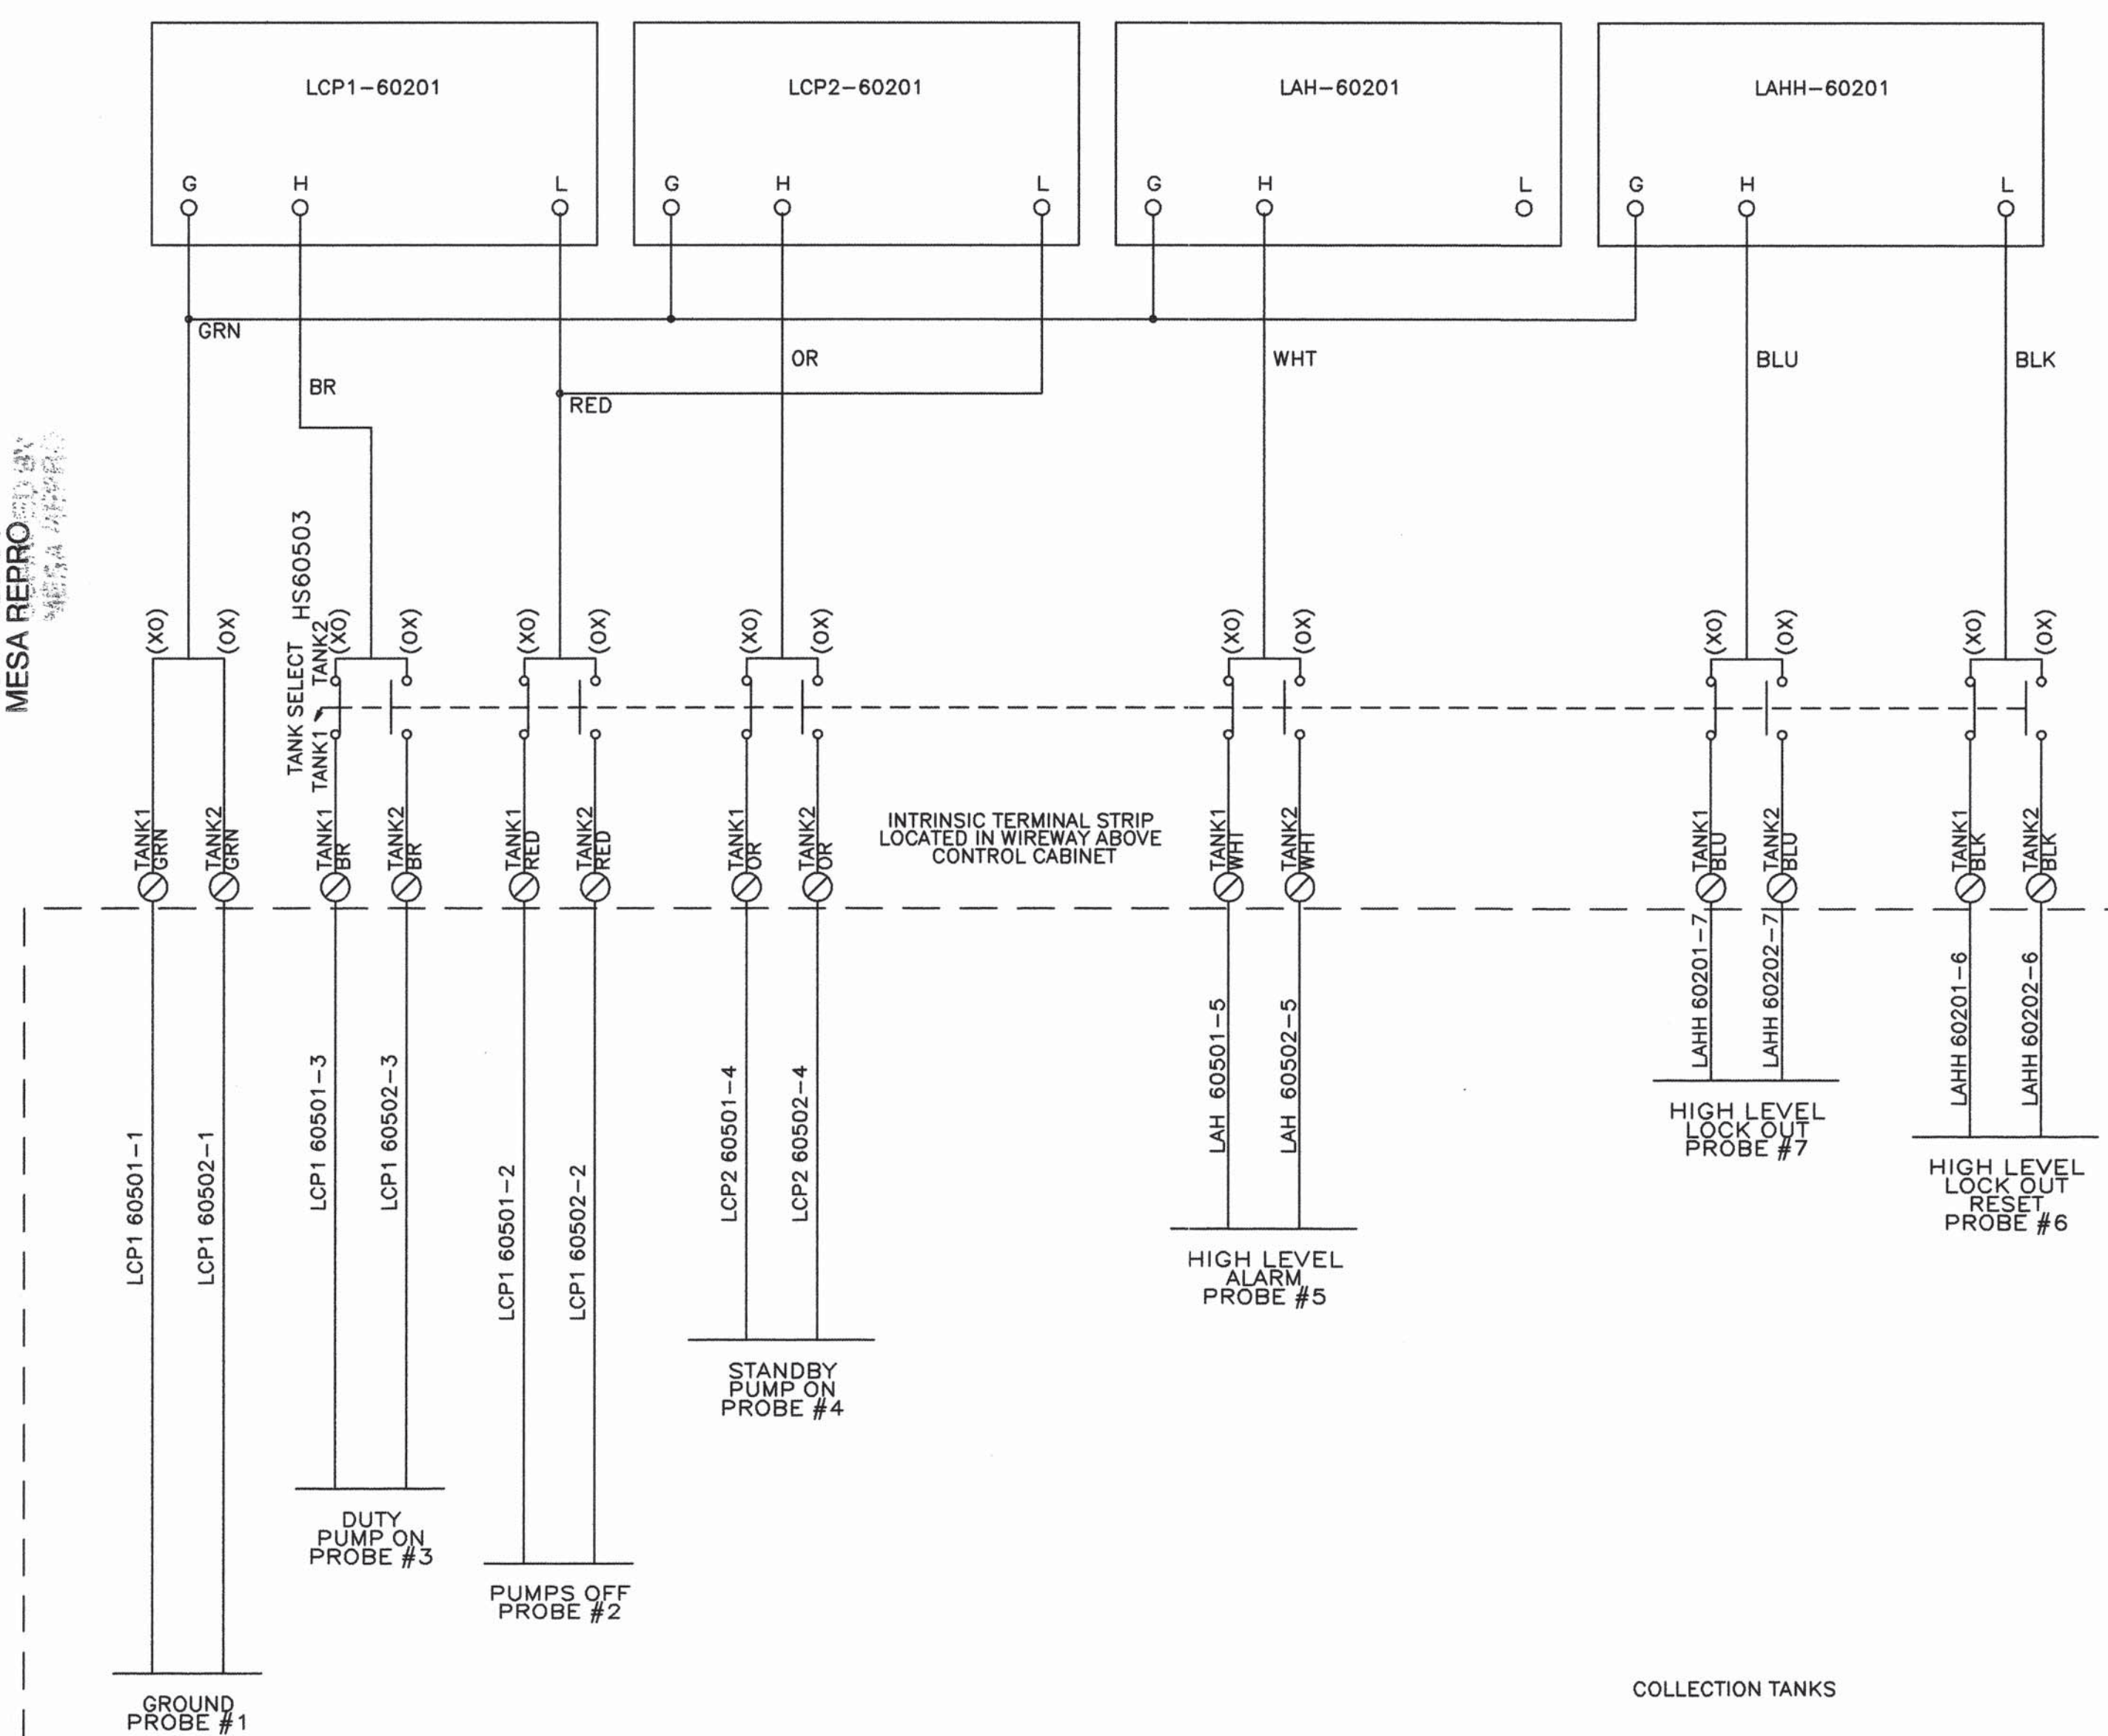[illegible]

SHEET-23



VACUUM SEWER SYSTEMS

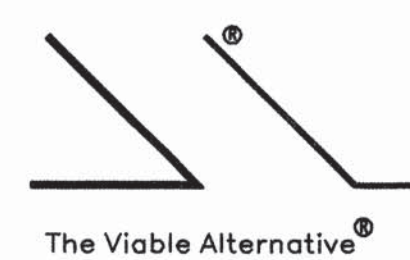


COPYRIGHT © AIRVAC, INC.

TELEPHONE (219) 223-3980
FAX (219) 223-5566

12-01-99
DATE

TITLE	FIELD WIRING POINT TO POINT
CLIENT	AREA B&F: ALBUQUERQUE, NM


9	DRAWN BY	RJB	DATE	06-21-99	SCALE	DRAWING NO.	PJ99-125
	DESIGN BY		COPYRIGHT ©	ALPAC®			

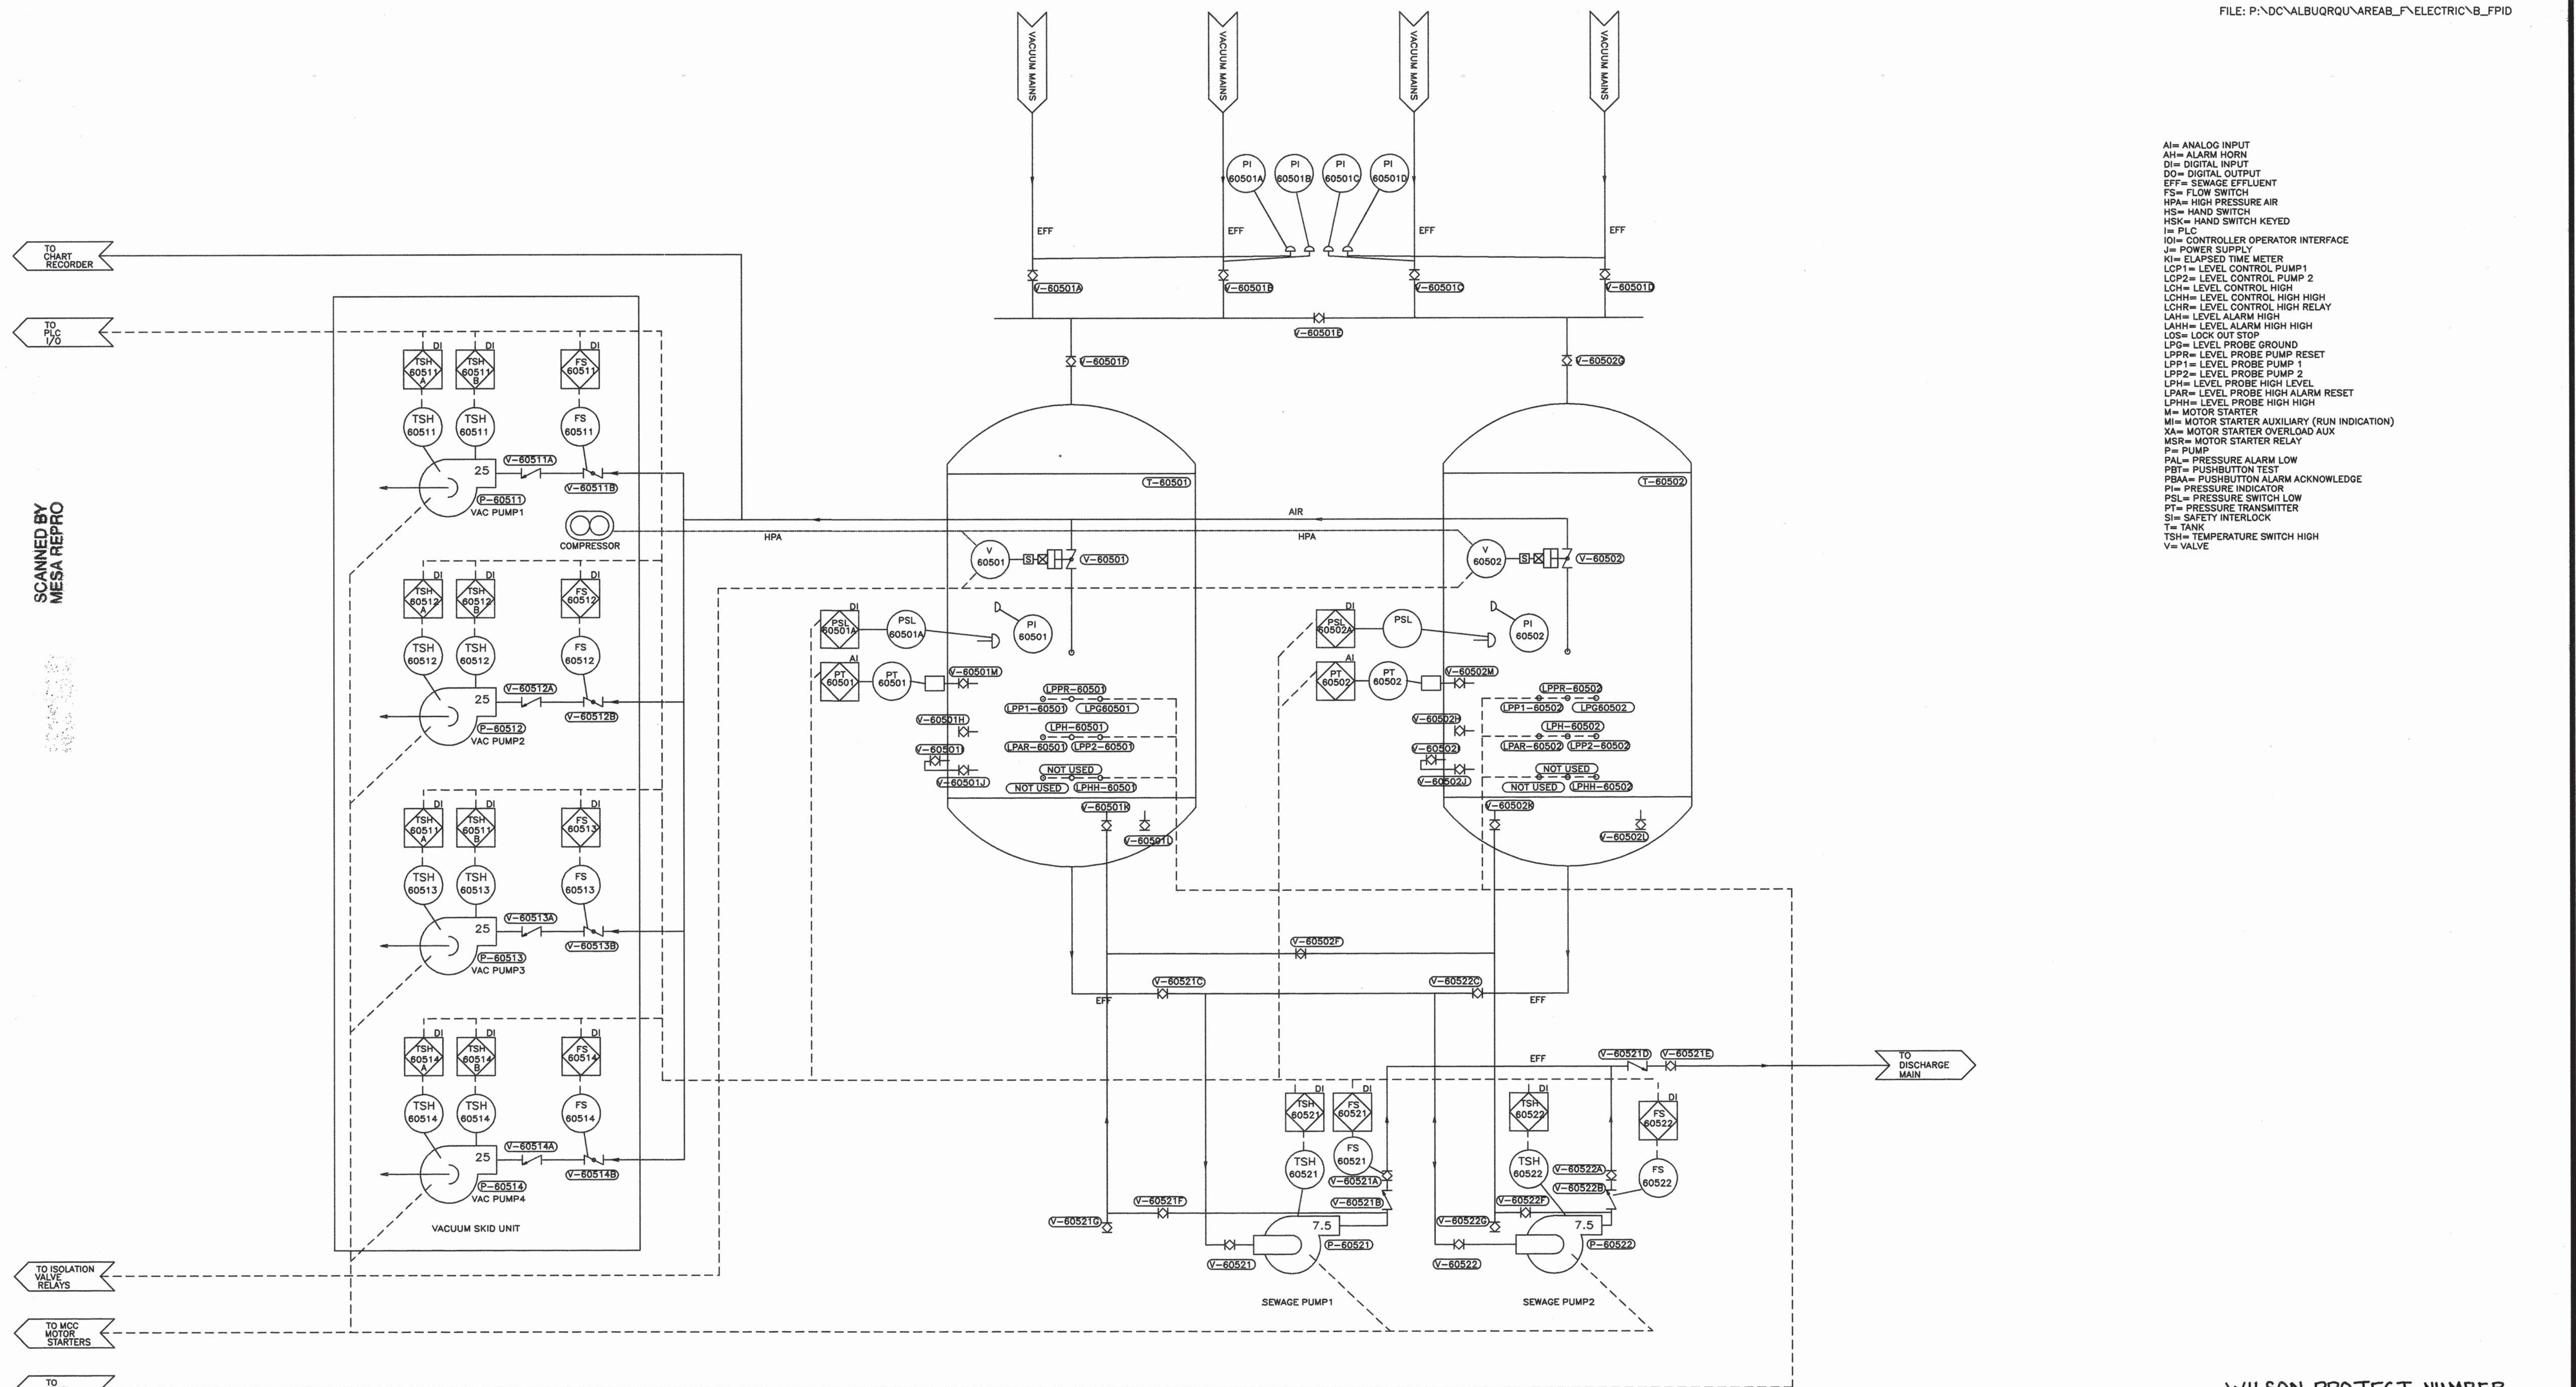

WILSON PROJECT NUMBER
96-210-034
CITY PROJECT NUMBER
567292
SHEET-24

AI= ANALOG INPUT
AH= ALARM HORN
DI= DIGITAL INPUT
DO= DIGITAL OUTPUT
EFF= SEWAGE EFFLUENT
FS= FLOW SWITCH
HS= HAND SWITCH
HSK= HAND SWITCH KEYED
I= PLC
IOI= CONTROLLER OPERATOR INTERFACE
J= POWER SUPPLY
KI= ELAPSED TIME METER
LCP1= LEVEL CONTROL PUMP 1
LCP2= LEVEL CONTROL PUMP 2
LCH= LEVEL CONTROL HIGH
LCHH= LEVEL CONTROL HIGH HIGH
LCHR= LEVEL CONTROL HIGH RELAY
LAH= LEVEL ALARM HIGH
LAHH= LEVEL ALARM HIGH HIGH
LOS= LOCK OUT STOP
LPG= LEVEL PROBE GROUND

LPPR= LEVEL PROBE PUMP RESET
LPP1= LEVEL PROBE PUMP 1
LPP2= LEVEL PROBE PUMP 2
LPH= LEVEL PROBE HIGH LEVEL
LPHH= LEVEL PROBE HIGH HIGH
M= MOTOR STARTER
MI= MOTOR STARTER AUXILIARY (RUN INDICATION)
XA= MOTOR STARTER OVERLOAD AUX
MSR= MOTOR STARTER RELAY
P= PUMP
PAL= PRESSURE ALARM LOW
PBT= PUSHBUTTON TEST
PBAA= PUSHBUTTON ALARM ACKNOWLEDGE
PI= PRESSURE INDICATOR
PSL= PRESSURE SWITCH LOW
PT= PRESSURE TRANSMITTER
SI= SAFETY INTERLOCK
T= TANK
TSH= TEMPERATURE SWITCH HIGH
V= VALVE

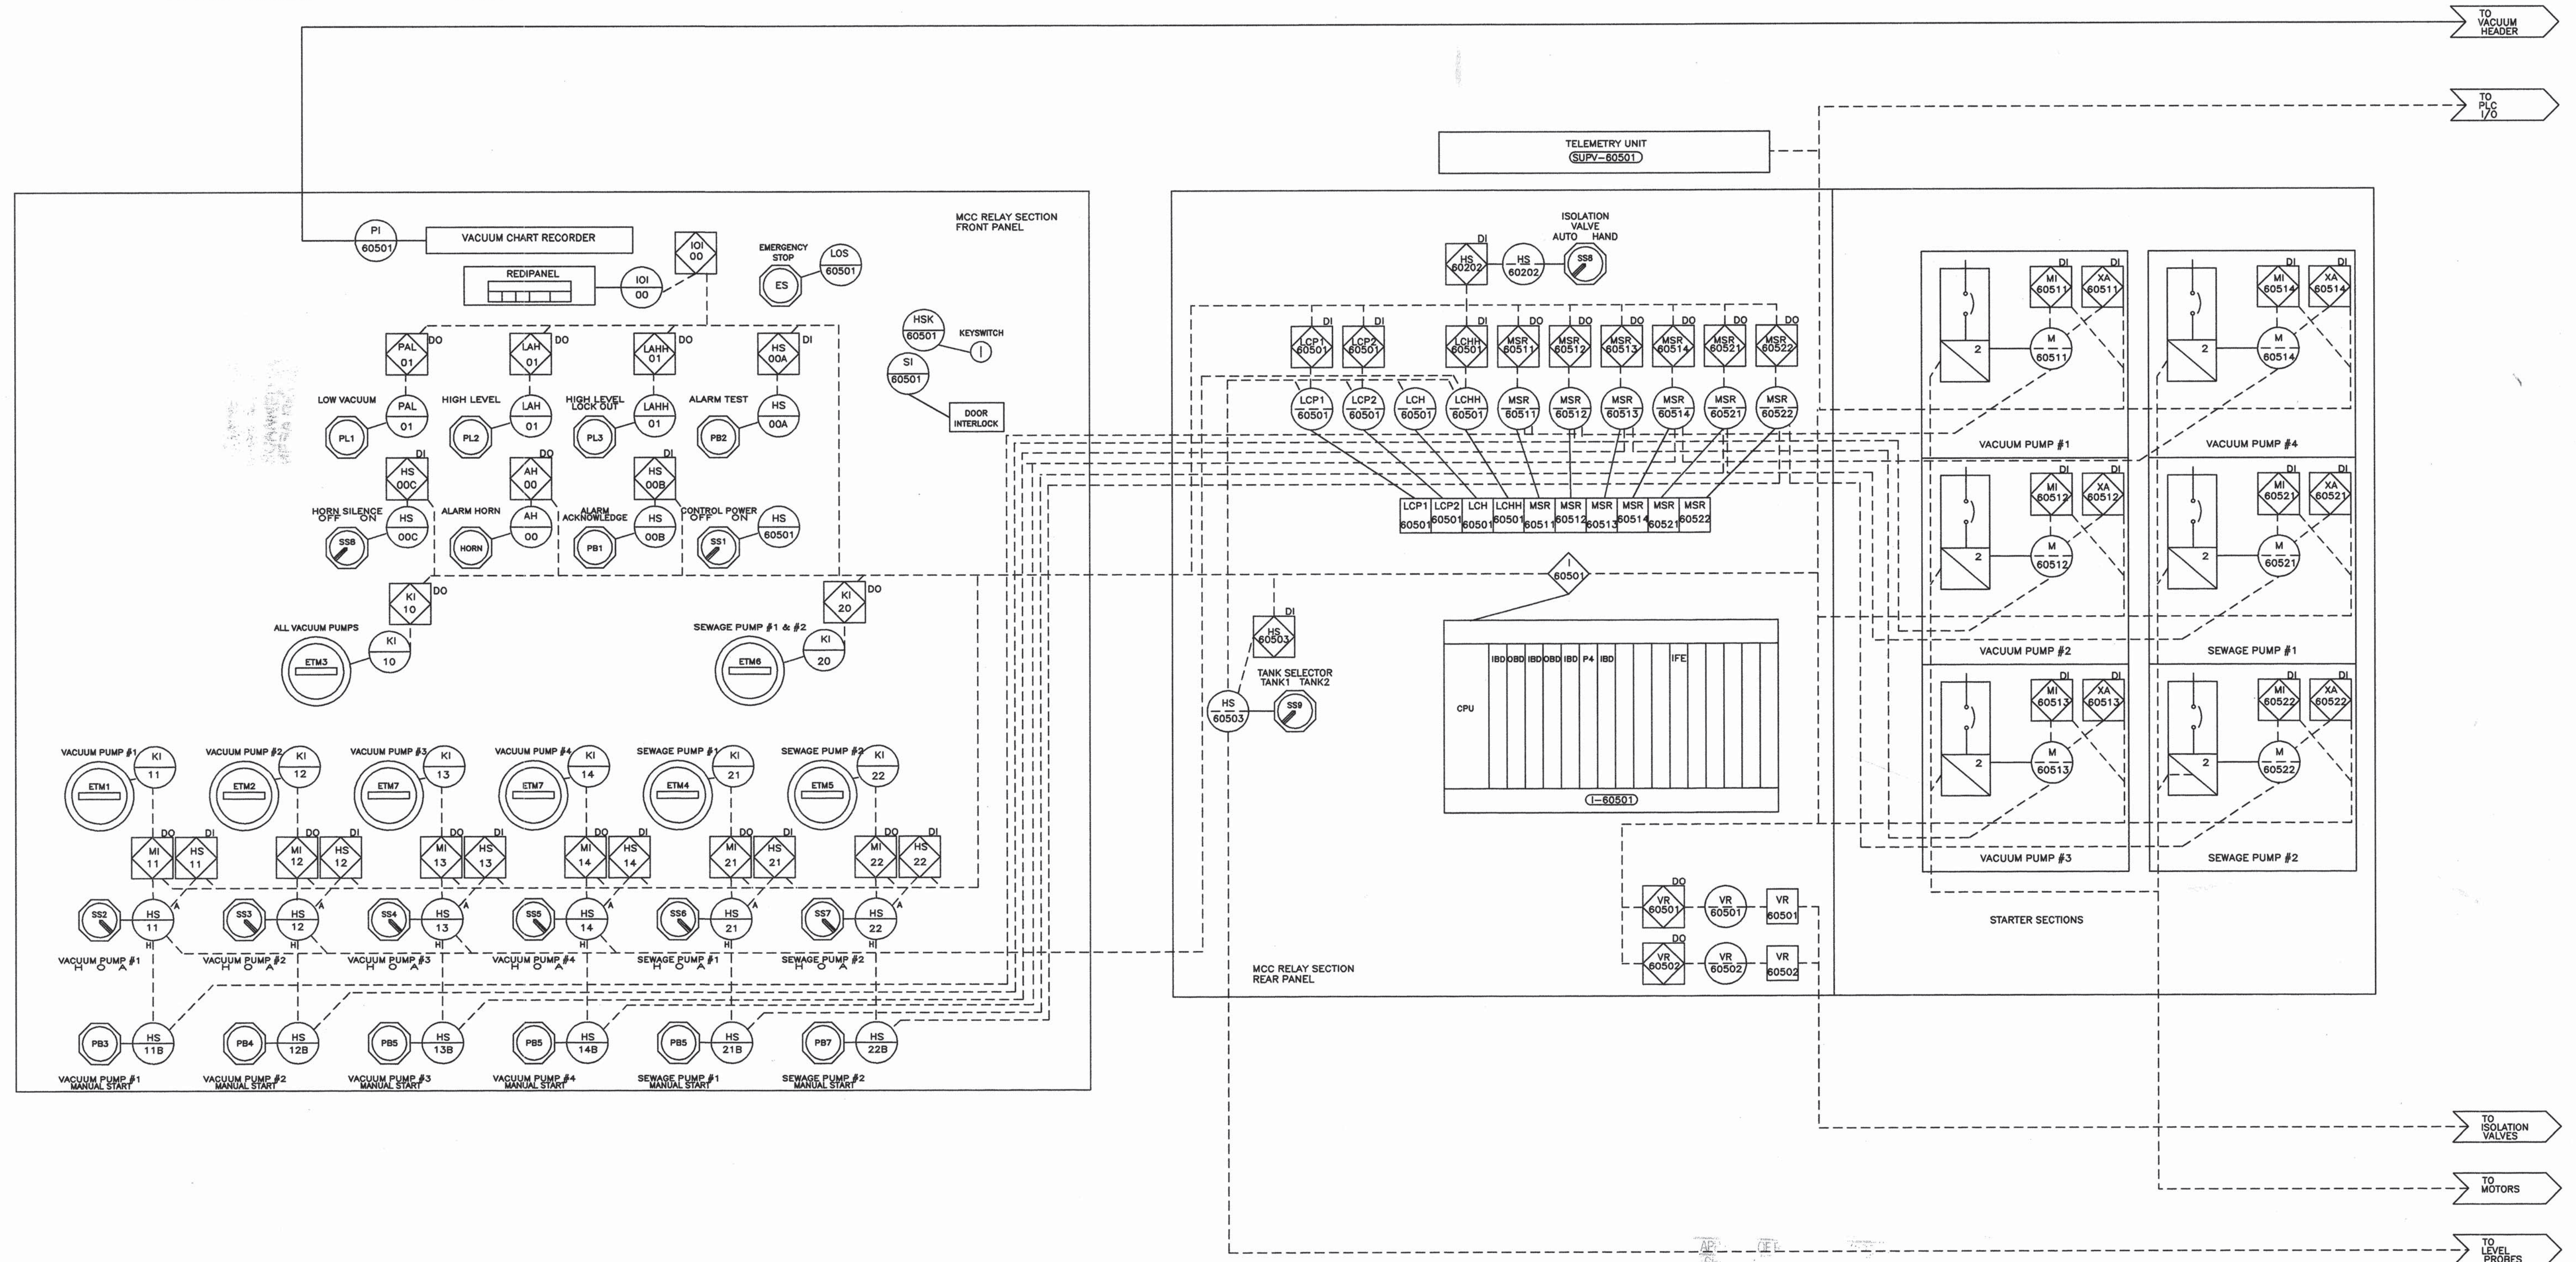


WILSON PROJECT NUMBER
96-210-034
CITY PROJECT NUMBER
567292
SHEET-25

AIRVAC®
VACUUM SEWER SYSTEMS

AIRVAC, INC.
P.O. BOX 528, 4217 N. OLD U.S. 31, ROCHESTER, INDIANA 46975 U.S.A.

TELEPHONE (219) 223-3980
FAX (219) 223-5566

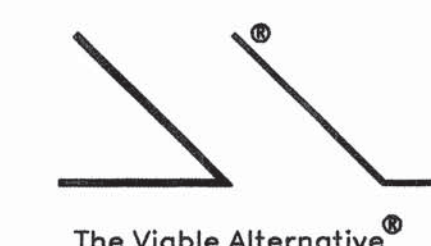

COPYRIGHT © AIRVAC, INC.

NO.		AS BUILT		12-01-99		DATE	
REVISIONS		DATE		DATE		DATE	
TITLE		MCC P&ID		CLIENT		AREA B&F: ALBUQUERQUE, NM	
DRAWN BY		RJB		DATE		06-21-99	
DESIGN BY		COPYRIGHT © AIRVAC		SCALE		PJ99-127	