

LEGEND

MATERIALS

CONCRETE

RIP-RAP

LINES

SUBDIVISION BOUNDARY

PROPERTY LINE (PLAN)

PROPERTY LINE (SECTION)

CENTERLINE

EASEMENT LINE

MATCH LINE

SECTION CUT LINE

EARTHWORK

CONTOUR LINE

SPOT ELEVATION

PROJECT / PHASE BOUNDARY

FLOW LINE

DIRECTION OF FLOW

MISCELLANEOUS UTILITIES

GAS LINE

UNDERGROUND TELEPHONE

UNDERGROUND ELECTRICAL

STORM DRAIN

STORM DRAIN MANHOLE

STORM DRAIN INLET

SANITARY SEWER

SANITARY SEWER LINE

SANITARY SEWER MANHOLE

SAS SERVICE CONNECTIONS

SAS CAP OR PLUG

ENCASEMENT

WATER

WATER LINE

WATER SERVICE CONNECTIONS

GATE VALVE

FIRE HYDRANT

BUTTERFLY VALVE

REDUCER

WATER PRESSURE ZONE BOUNDARY

WATER FITTINGS

CAPS AND PLUGS

ELBOW

CROSS

TEE

MISCELLANEOUS

CHAIN LINK FENCE

FIELD FENCE

COMMON YARD WALL

RETAINING WALL

POWER OR TELEPHONE POLE

RECORD DRAWING


CONSTRUCTION PLANS

for

OCOTILLO SUBDIVISION

ALBUQUERQUE, NEW MEXICO

APRIL, 2004

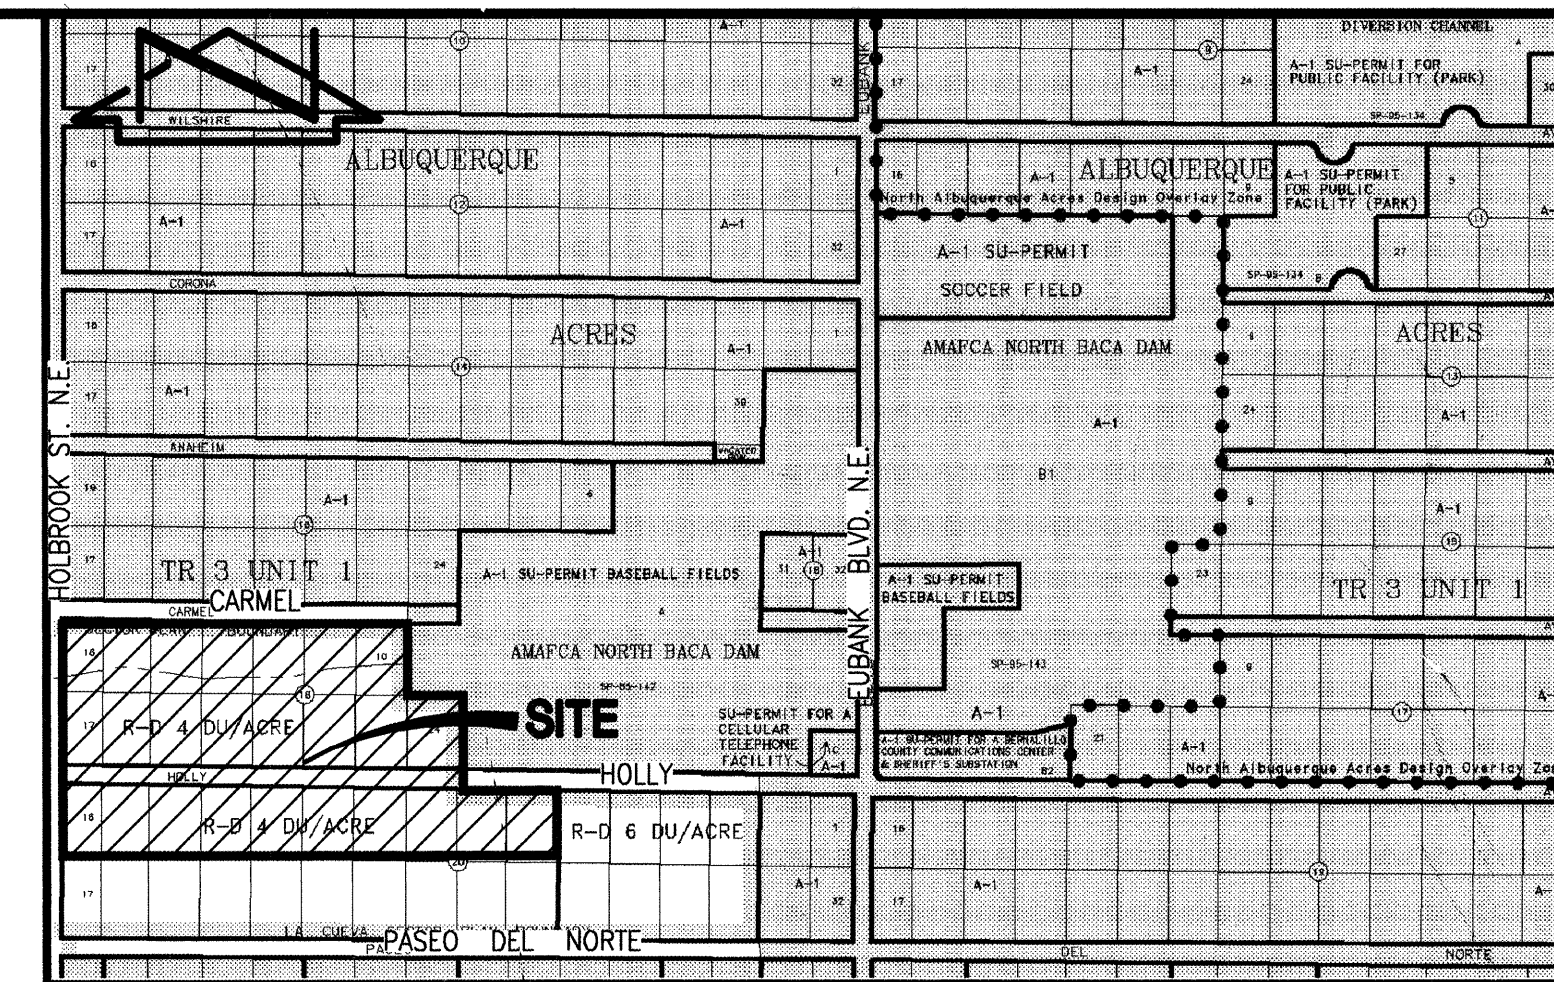

VICINITY MAP

SCALE: 1" = 750'

C-21

GENERAL NOTES:

- ALL WORK DETAILED ON THESE PLANS TO BE PERFORMED UNDER CONTRACT SHALL, EXCEPT AS OTHERWISE STATED OR PROVIDED FOR HEREON, BE CONSTRUCTED IN ACCORDANCE WITH THE CITY OF ALBUQUERQUE STANDARD SPECIFICATIONS-PUBLIC WORKS CONSTRUCTION-1986 - UPDATE NO. 7.
- TWO (2) WORKING DAYS PRIOR TO ANY EXCAVATION, CONTRACTOR MUST CONTACT NEW MEXICO ONE CALL SYSTEM, 280-1990, (ALBUQUERQUE AREA) 1-800-321-ALERT (2537) (STATEWIDE) FOR LOCATION OF EXISTING UTILITIES.
- IF ANY UTILITY LINES, PIPELINES, OR UNDERGROUND UTILITY LINES ARE SHOWN ON THESE DRAWINGS, THEY ARE SHOWN IN AN APPROXIMATE MANNER ONLY, AND SUCH LINES MAY EXIST WHERE NONE ARE SHOWN. IF ANY SUCH EXISTING LINES ARE SHOWN, THE LOCATION IS BASED UPON INFORMATION PROVIDED BY THE OWNER OF SAID UTILITY, AND THE INFORMATION MAY BE INCOMPLETE, OR MAY BE OBSOLETE BY THE TIME CONSTRUCTION COMMENCES. THE ENGINEER HAS CONDUCTED ONLY PRELIMINARY INVESTIGATION OF THE LOCATION, DEPTH, SIZE, OR TYPE OF EXISTING UTILITY LINES, PIPELINES, OR UNDERGROUND UTILITY LINES. THIS INVESTIGATION IS NOT CONCLUSIVE, AND MAY NOT BE COMPLETE, THEREFORE, MAKES NO REPRESENTATION PERTAINING THERETO, AND ASSUMES NO RESPONSIBILITY OR LIABILITY THEREFOR. THE CONTRACTOR SHALL INFORM ITSELF OF THE LOCATION OF ANY UTILITY LINE, PIPELINE, OR UNDERGROUND UTILITY LINE IN OR NEAR THE AREA OF THE WORK IN ADVANCE OF AND DURING EXCAVATION WORK. THE CONTRACTOR IS FULLY RESPONSIBLE FOR ANY AND ALL DAMAGE CAUSED BY ITS FAILURE TO LOCATE, IDENTIFY AND PRESERVE ANY AND ALL EXISTING UTILITIES, PIPELINES, AND UNDERGROUND UTILITY LINES. IN PLANNING AND CONDUCTING EXCAVATION, THE CONTRACTOR SHALL COMPLY WITH STATE STATUTES, MUNICIPAL AND LOCAL ORDINANCES, RULES AND REGULATIONS, IF ANY, PERTAINING TO THE LOCATION OF THESE LINES AND FACILITIES.
- SHOULD A CONFLICT EXIST BETWEEN THESE PLANS AND ACTUAL FIELD CONDITIONS, THE CONTRACTOR SHALL PROMPTLY NOTIFY THE ENGINEER IN WRITING SO THAT THE CONFLICT CAN BE RESOLVED WITH A MINIMUM AMOUNT OF DELAY FOR ALL PARTIES.
- THE CONTRACTOR SHALL MAINTAIN ACCESS TO ADJACENT PROPERTIES DURING CONSTRUCTION.
- ALL WORK ON THIS PROJECT SHALL BE PERFORMED IN ACCORDANCE WITH APPLICABLE FEDERAL, STATE AND LOCAL LAWS, RULES AND REGULATIONS CONCERNING SAFETY AND HEALTH.
- ALL UTILITIES AND UTILITY SERVICE LINES SHALL BE INSTALLED PRIOR TO PAVING.
- BACKFILL COMPACTION SHALL BE ACCORDING TO SPECIFIED STREET USE.
- TACK COAT REQUIREMENTS SHALL BE DETERMINED DURING CONSTRUCTION BY THE PROJECT ENGINEER.
- SIDEWALKS AND WHEELCHAIR RAMPS WITHIN THE CURB RETURNS SHALL BE CONSTRUCTED WHEREVER A NEW CURB RETURN IS CONSTRUCTED.
- IF CURB IS DEEPENED FOR A DRIVEPAD OR A HANDICAP RAMP, THE DRIVEPAD OR RAMP SHALL BE CONSTRUCTED PRIOR TO ACCEPTANCE OF THE CURB AND GUTTER.
- ALL STORM DRAINAGE FACILITIES SHALL BE COMPLETED PRIOR TO FINAL ACCEPTANCE.
- CONTRACTOR SHALL COORDINATE WITH THE WATER SYSTEM DIVISION FOR THE EXECUTION OF THE VALVE SHUT OFF PLAN, NOT LESS THAN SEVEN (7) WORKING DAYS IN ADVANCE OF ANY WORK THAT MAY AFFECT THE EXISTING PUBLIC WATER UTILITIES. ONLY WATER SYSTEM DIVISION PERSONNEL SHALL OPERATE EXISTING VALVES. REFER TO SECTION 18 OF THE SPECIFICATIONS. THE WATER SYSTEM DIVISION PHONE NUMBER IS 857-8200.
- CONTRACTOR SHALL NOTIFY THE CITY SURVEYOR NOT LESS THAN SEVEN (7) DAYS PRIOR TO STARTING WORK IN ORDER THAT THE CITY SURVEYOR MAY TAKE NECESSARY MEASURES TO INSURE THE PRESERVATION OF SURVEY MONUMENTS. CONTRACTOR SHALL NOT DISTURB PERMANENT SURVEY MONUMENTS WITHOUT THE CONSENT OF THE CITY SURVEYOR AND SHALL NOTIFY THE CITY SURVEYOR AND BEAR THE EXPENSE OF REPLACING ANY THAT MAY BE DISTURBED WITHOUT PERMISSION. REPLACEMENT SHALL BE DONE ONLY BY THE CITY SURVEYOR. WHEN A CHANGE IS MADE IN THE FINISHED ELEVATION OF THE PAVEMENT OF ANY ROADWAY IN WHICH A PERMANENT SURVEY MONUMENT IS LOCATED, CONTRACTOR SHALL, AT HIS OWN EXPENSE, ADJUST THE MONUMENT COVER TO THE NEW GRADE UNLESS OTHERWISE SPECIFIED. REFER TO SECTION 4.4 OF THE SPECIFICATIONS.
- FIVE (5) WORKING DAYS PRIOR TO BEGINNING CONSTRUCTION THE CONTRACTOR SHALL SUBMIT TO THE CONSTRUCTION COORDINATION DIVISION A DETAILED CONSTRUCTION SCHEDULE. TWO (2) WORKING DAYS PRIOR TO CONSTRUCTION THE CONTRACTOR SHALL OBTAIN A BARRICADE PERMIT FROM THE CONSTRUCTION COORDINATION DIVISION. CONTRACTOR SHALL NOTIFY BARRICADE ENGINEER (924-3400) PRIOR TO OCCUPYING AN INTERSECTION. CONTRACTOR MUST REFER TO SECTION 19 OF THE STANDARD SPECIFICATION FOR TRAFFIC CONTROL.
- ALL STREET STRIPING ALTERED OR DESTROYED SHALL BE REPLACED WITH PLASTIC REFLECTORIZED STRIPING BY CONTRACTOR TO EXISTING LOCATION OR AS INDICATED BY THIS PLAN SET.
- CAUTION: THESE DRAWINGS DO NOT INCLUDE NECESSARY COMPONENTS FOR CONSTRUCTION SAFETY WHICH SHALL REMAIN THE RESPONSIBILITY OF THE CONTRACTOR. ALL EXCAVATION, TRENCHING AND SHORING ACTIVITIES MUST BE CARRIED-OUT IN ACCORDANCE WITH OSHA 29 CFR 1926, SUBPART P-EXCAVATIONS.
- ANY WORK OCCURRING WITHIN AN ARTERIAL ROADWAY REQUIRES TWENTY-FOUR HOUR CONSTRUCTION.
- CONTRACTOR SHALL MAINTAIN A GRAFFITI-FREE WORK SITE. CONTRACTOR SHALL PROMPTLY REMOVE ANY AND ALL GRAFFITI FROM EQUIPMENT, WHETHER PERMANENT OR TEMPORARY.
- THIS SET OF PLANS SHOWS PRIVATE RETAINING WALLS THAT ARE NOT PART OF THIS WORK ORDER. THOSE WALLS MUST BE REVIEWED, APPROVED AND PERMITTED BY SEPARATE PROCESS. CONTACT 924-3956.
- WHEN APPLICABLE, CONTRACTOR SHALL SECURE "TOPSOIL DISTURBANCE PERMIT" FROM THE CITY AND/OR FILE A NOTICE OF INTENT (N.O.I.) WITH THE EPA PRIOR TO BEGINNING CONSTRUCTION.
- THE CONTRACTOR SHALL MAINTAIN ACCESS TO ALL EXISTING RESIDENTS ALONG CARMEL AVENUE AT ALL TIMES.

INDEX OF DRAWINGS

SHEET	DESCRIPTION
1	COVER SHEET, VICINITY MAP, GENERAL NOTES, LEGEND AND INDEX OF DRAWINGS
2-4	SUBDIVISION PLAT
5	DRB APPROVED GRADING PLAN
PAVING AND STORM DRAINAGE IMPROVEMENTS	
6	PAVING AND STORM DRAINAGE SITE PLAN
7	PAVING AND STORM DRAINAGE SECTIONS AND DETAILS
8	STREET PAVING SECTIONS
9	CARMEL AVENUE N.E.
10	SAND VERBENA TRAIL N.E. (ENTRY)
11	DESERT LILY LANE N.E.
12	SAND VERBENA TRAIL N.E. STA 8+34.71 TO STA 18+50
13	SAND VERBENA TRAIL N.E. STA 18+50 TO STA 25+61.53
14	DATURA TRAIL N.E.
15	DATURA TRAIL N.E./CHIA WAY N.E.
16	DESERT ASTER LANE N.E., DESERT POPPY LANE N.E., DESERT PLUME LANE N.E.
WATER AND SANITARY SEWER EXTENSIONS	
17	WATER AND SANITARY SEWER SITE PLAN; WATER VALVE SHUTOFF PLAN
18	CARMEL AVE. N.E.
19	SAND VERBENA TRAIL N.E. (ENTRY)
20	DESERT LILY LANE N.E.
21	SAND VERBENA TRAIL N.E. STA 9+90 TO STA 18+50
22	SAND VERBENA TRAIL N.E. STA 18+50 TO STA 25+67.01
23	DATURA TRAIL N.E.
24	DATURA TRAIL N.E./CHIA WAY N.E.
25	DESERT ASTER LANE N.E., DESERT POPPY LANE N.E., DESERT PLUME LANE N.E.

CERTIFICATE OF SUBSTANTIAL COMPLIANCE

I, J. GRAEME MEANS, NMPE 13676, OF THE FIRM JEFF MORTENSEN & ASSOCIATES, INC., HEREBY CERTIFY THAT THE INFRASTRUCTURE CONSTRUCTED AS PART OF THIS PROJECT HAS BEEN INSPECTED BY ME OR PERSONNEL UNDER MY DIRECT SUPERVISION AND, TO THE BEST OF MY KNOWLEDGE AND BELIEF, HAS BEEN CONSTRUCTED IN ACCORDANCE WITH THE PLANS AND SPECIFICATIONS AND THE ORIGINAL DESIGN INTENT OF THE CITY ENGINEER APPROVED PLANS. THE RECORD INFORMATION EDITED ONTO THIS ORIGINAL DESIGN DOCUMENT HAS BEEN OBTAINED BY OR UNDER MY DIRECT SUPERVISION AND IS TRUE AND CORRECT TO THE BEST OF MY KNOWLEDGE AND BELIEF. THIS RECORD INFORMATION IS NOT NECESSARILY COMPLETE AND INTENDED ONLY TO VERIFY SUBSTANTIAL COMPLIANCE OF THE DESIGN INTENT OF THIS PROJECT. THOSE RELYING ON THIS DOCUMENT ARE ADVISED TO OBTAIN INDEPENDENT VERIFICATION OF ITS ACCURACY BEFORE USING IT FOR ANY OTHER PURPOSE. THIS CERTIFICATION IS SUBMITTED IN SUPPORT OF A REQUEST FOR ACCEPTANCE OF THE PROJECT BY THE CITY ENGINEER.

J. Graeme Means
J. GRAEME MEANS, NMPE 13676

02/19/2005
DATE

1 2 3 4 5 6 7 8 9 10 11 12 13 14 15
26 27 28 29 30 31 05

APPROVED AS RECORD DRAWINGS
DESIGN REVIEW SECTION
CITY CONSTRUCTION ENGINEER
DATE: 5/12/04

DRB PROJECT #1002885


2002.050.48

REV.	SHEETS	CITY ENGINEER	DATE	USER	DEPARTMENT	DATE	USER	DEPARTMENT	DATE
ENGINEERS STAMP & SIGNATURE		APPROVALS		ENGINEER		DATE		*****	
		DRC Chairman		[Signature]		5-27-04		APPROVED FOR CONSTRUCTION	
		Transportation		[Signature]		4-20-04			
		Water/Wastewater		[Signature]		5/8/04			
		Hydrology		[Signature]		4/30/04			
		C.I.P.		[Signature]		5-27-04			
Const. Mngmt.		[Signature]		[Signature]		[Signature]		City Engineer	
Const. Coord.		[Signature]		[Signature]		[Signature]		Date	
City Project No.		729181		SHEET		1		OF 25	

KEY MAP




NOT TO SCALE

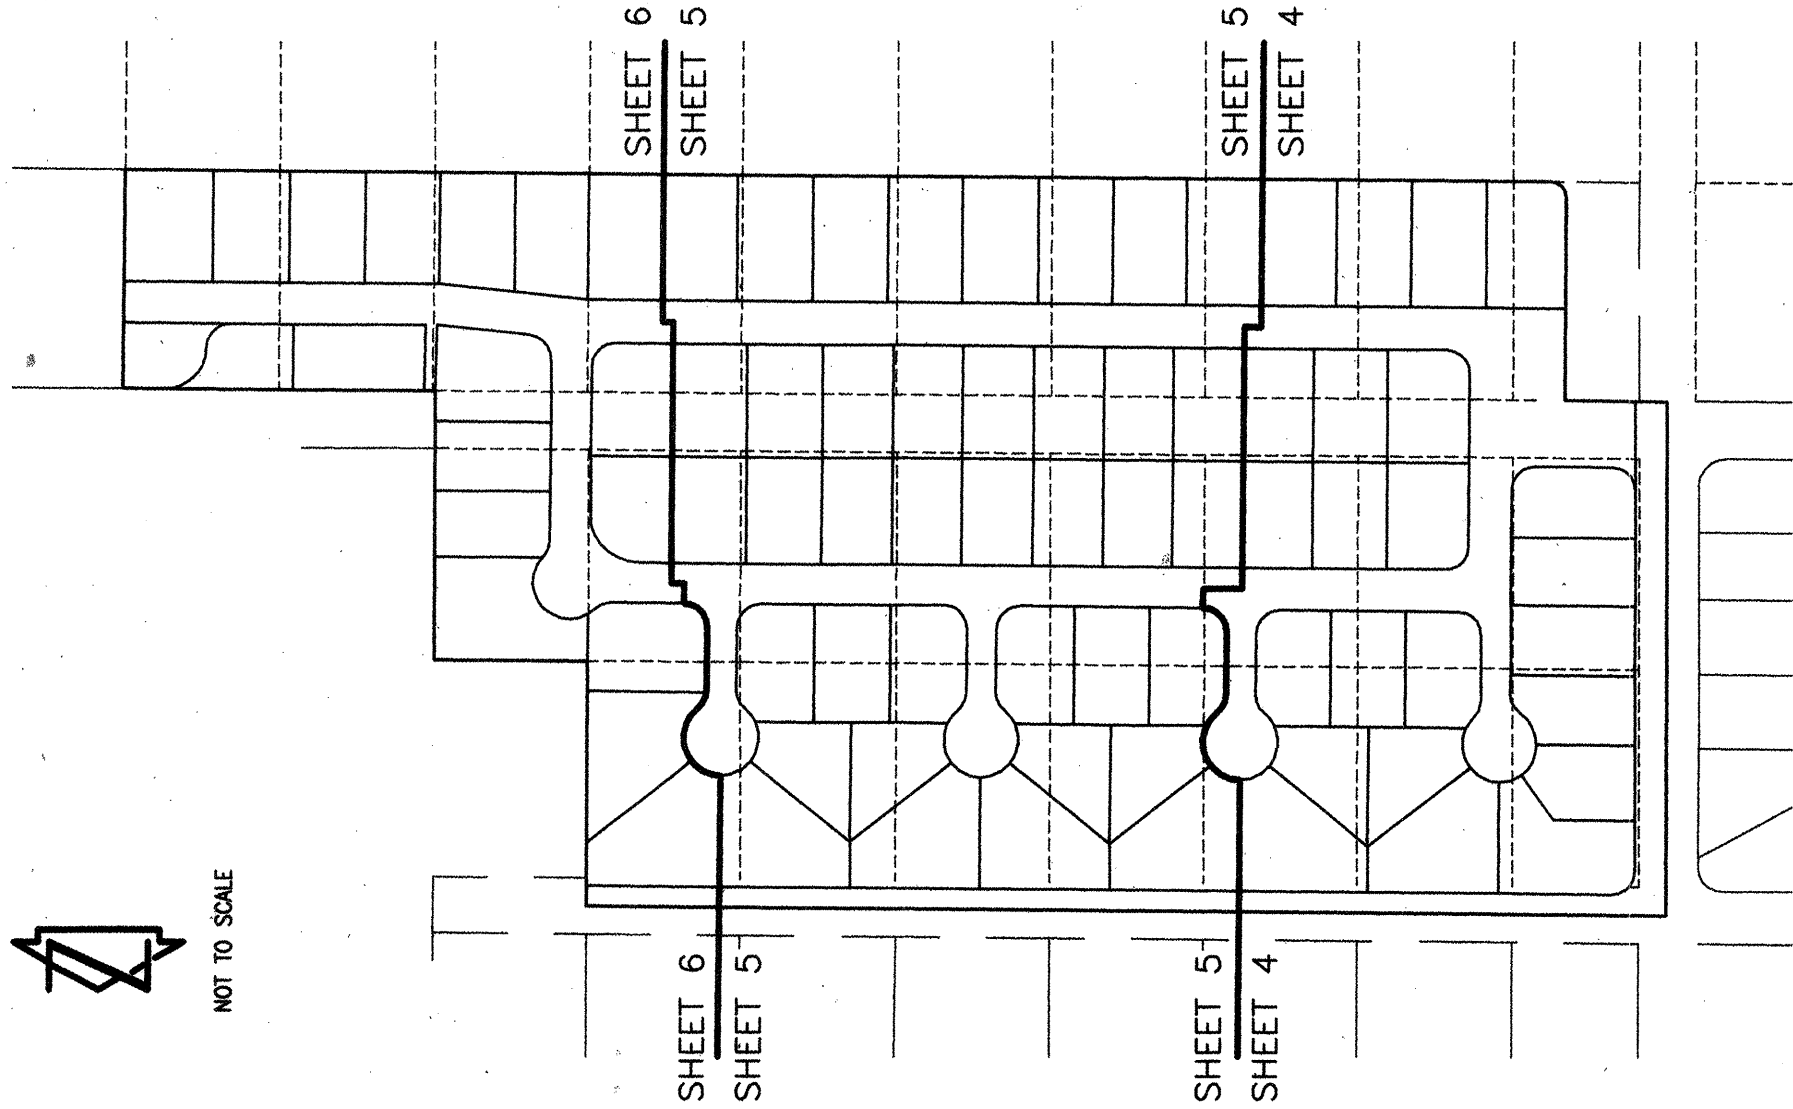

Public utility easements shown on this plat are ten (10) feet wide and are granted for the common and joint use of:

1. The P.N.M. Electric Services for the installation, maintenance, and service of overhead and underground electrical lines, transformers, poles, and other equipment, wires, and structures, and for the installation of facilities reasonably necessary to provide electrical service.
2. The P.N.M. Gas Services for installation, maintenance, and service of natural gas lines, valves and other equipment and facilities reasonably necessary to provide natural gas.
3. Qwest Corporation for the installation, maintenance, and service of all buried and aerial communication lines and other related equipment and facilities reasonably necessary to provide communication services including, but not limited to, above ground pedestals and closures.
4. Comcast Cable Vision of New Mexico, Inc. for the installation, maintenance, and service of such lines, cables, and other related equipment and facilities reasonably necessary to provide cable TV service.

Included, is the right to build, rebuild, construct, reconstruct, locate, relocate, remove, replace, alter, modify, and improve facilities, the easements described herein, and to provide with free access to, from, and over said easements, including sufficient working area space for electric transformers, with the right and privilege to trim and remove trees, shrubs or bushes which interfere with the purposes set forth herein. No building, sign, pool (aboveground or subsurface), hot tub, concrete or wood pool decking, or other structure shall be erected or constructed thereon. Property owners shall be solely responsible for correcting any violations of the National Electric Safety Code caused by construction of pools, decking, or any structures adjacent to within or near easements shown on this plat.

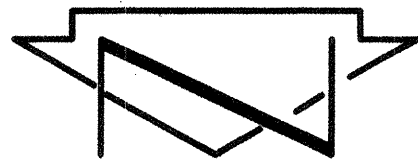

SCALE: 1" = 50'

NOTE: FOR CENTERLINE AND BOUNDARY TABLES SEE SHEET 2 OF 6.
FOR KEYED NOTES SEE SHEET 3 OF 6.

MATCH LINE - FOR CONTINUATION SEE SHEET 5

LOT 19, BLOCK 16
NORTH ALBUQUERQUE ACRES
TRACT 3, UNIT 1
(FILED 02-23-1931, 0-132)

LOT 18, BLOCK 16
NORTH ALBUQUERQUE ACRES
TRACT 3, UNIT 1
(FILED 02-23-1931, 0-132)

LOT 17, BLOCK 16
NORTH ALBUQUERQUE ACRES
TRACT 3, UNIT 1
(FILED 02-23-1931, 0-132)

CARMEL AVENUE N.E.
S 89°32'10" E

LOT 12
0.2006 AC. ±

LOT 11
0.2210 AC. ±

LOT 10
0.2307 AC. ±

LOT 9
0.2233 AC. ±

LOT 8
0.2026 AC. ±

LOT 7
0.3188 AC. ±

LOT 6
0.3070 AC. ±

LOT 5
0.1939 AC. ±

LOT 4
0.2096 AC. ±

LOT 3
0.2283 AC. ±

LOT 2
1.32.37

LOT 1
0.2357 AC. ±

LOT 18, BLOCK 16
NORTH ALBUQUERQUE ACRES
TRACT 3, UNIT 1
(FILED 02-23-1931, 0-132)

LOT 17, BLOCK 16
NORTH ALBUQUERQUE ACRES
TRACT 3, UNIT 1
(FILED 02-23-1931, 0-132)

LOT 16, BLOCK 16
NORTH ALBUQUERQUE ACRES
TRACT 3, UNIT 1
(FILED 02-23-1931, 0-132)

LOT 15, BLOCK 16
NORTH ALBUQUERQUE ACRES
TRACT 3, UNIT 1
(FILED 02-23-1931, 0-132)

LOT 14, BLOCK 16
NORTH ALBUQUERQUE ACRES
TRACT 3, UNIT 1
(FILED 02-23-1931, 0-132)

LOT 13, BLOCK 16
NORTH ALBUQUERQUE ACRES
TRACT 3, UNIT 1
(FILED 02-23-1931, 0-132)

LOT 12, BLOCK 16
NORTH ALBUQUERQUE ACRES
TRACT 3, UNIT 1
(FILED 02-23-1931, 0-132)


SUBDIVISION PLAT OF

OCOTILLO SUBDIVISION

ALBUQUERQUE, BERNALILLO COUNTY, NEW MEXICO

FEBRUARY, 2004

2004032255

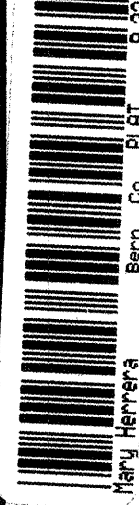

Jeff Mortensen & Associates, Inc.
600-B Highway Park Blvd., N.E.
Albuquerque, NM 87109
Engineers & Surveyors (SOS) 345-4250
Job #2002.050.6 FINAL

Bk. 2004c Pg. 76

COUNTY CLERK FILING DATA

EASEMENT TABLES

LINE	DIRECTION	DISTANCE
E1	S 89°32'10" E	31.58'
E2	S 00°27'50" W	27.16'
E3	N 89°32'10" W	41.07'

CURVE	RADIUS	LENGTH	CHORD BEARING	CHORD	DELTA
EC1	25.00'	39.27'	S 44°32'10" E	35.36'	90°00'00"
EC2	15.00'	23.56'	S 45°27'50" W	21.21'	90°00'00"

MATCH LINE - FOR CONTINUATION SEE SHEET 5

MATCH LINE - FOR CONTINUATION SEE SHEET 5

CARMEL AVENUE N.E.
S 89°32'10" E

LOT 12
0.2006 AC. ±

LOT 11
0.2210 AC. ±

LOT 10
0.2307 AC. ±

LOT 9
0.2233 AC. ±

LOT 8
0.2026 AC. ±

LOT 7
0.3188 AC. ±

LOT 6
0.3070 AC. ±

LOT 5
0.1939 AC. ±

LOT 4
0.2096 AC. ±

LOT 3
0.2283 AC. ±

LOT 2
1.32.37

LOT 1
0.2357 AC. ±

LOT 18, BLOCK 16
NORTH ALBUQUERQUE ACRES
TRACT 3, UNIT 1
(FILED 02-23-1931, 0-132)

LOT 17, BLOCK 16
NORTH ALBUQUERQUE ACRES
TRACT 3, UNIT 1
(FILED 02-23-1931, 0-132)

LOT 16, BLOCK 16
NORTH ALBUQUERQUE ACRES
TRACT 3, UNIT 1
(FILED 02-23-1931, 0-132)

LOT 15, BLOCK 16
NORTH ALBUQUERQUE ACRES
TRACT 3, UNIT 1
(FILED 02-23-1931, 0-132)

LOT 14, BLOCK 16
NORTH ALBUQUERQUE ACRES
TRACT 3, UNIT 1
(FILED 02-23-1931, 0-132)

LOT 13, BLOCK 16
NORTH ALBUQUERQUE ACRES
TRACT 3, UNIT 1
(FILED 02-23-1931, 0-132)

LOT 12, BLOCK 16
NORTH ALBUQUERQUE ACRES
TRACT 3, UNIT 1
(FILED 02-23-1931, 0-132)

OCOTILLO SUBDIVISION

ALBUQUERQUE, BERNALILLO COUNTY, NEW MEXICO
FEBRUARY, 2004

SUBDIVISION PLAT OF

KEYED NOTES

VACATED PUBLIC RIGHTS-OF-WAY AND EASEMENT

- 1 HOLLY AVENUE N.E. VACATED BY 03DRB-01355
- 2 SOUTH 4' OF HOLLY AVENUE N.E. VACATED BY 03DRB-01355
- 3 SOUTH 8' OF HOLLY AVENUE N.E. VACATED BY 03DRB-01355
- 4 SOUTH 8' OF CARMEL AVENUE N.E. VACATED BY 03DRB-01355
- 5 PUBLIC VEHICULAR ACCESS EASEMENT GRANTED BY DOCUMENT FILED 11-18-2002, BOOK A45, PAGE 600, DOC. #2002151009 VACATED BY 03DRB-01356
- 6 THE NONSPECIFIC EASEMENTS AND/OR RIGHT-OF-WAYS FOR ROAD AND/OR PIPELINE PURPOSES (WATER, GAS OR SEWAGE), TELEPHONE AND ELECTRICAL ENERGY AFFECTING THE PROPERTIES PLATTED HEREON, GRANTED BY THE DOCUMENT RECORDED IN BOOK 132, PAGE 249, BOOK 132, PAGE 270, BOOK 124, PAGE 343, BOOK 124, PAGE 451 AND BOOK 124, PAGE 134 VACATED BY 03DRB-01356, ALSO BOOK 124, PAGE 468 VACATED BY 03DRB-01981
- 7 REMAINING PORTION HOLLY AVENUE N.E. VACATED BY 03DRB-01980


NEW EASEMENTS

- 8 PRIVATE ACCESS, PRIVATE STORM DRAINAGE EASEMENTS SERVING LOTS 1-78 AND PARCELS B AND C, AND A CITY OF ALBUQUERQUE PUBLIC WATER AND PUBLIC SANITARY SEWER EASEMENTS GRANTED BY THIS PLAT. MAINTENANCE OF THE PRIVATE EASEMENTS SHALL BE THE RESPONSIBILITY OF THE OCOTILLO SUBDIVISION HOMEOWNERS ASSOCIATION, PURSUANT TO THE DECLARATION OF RESTRICTIVE AND PROTECTIVE COVENANTS FOR OCOTILLO SUBDIVISION FILED ON 03-11-2004, BOOK A34, PAGES 211-218
- 9 PRIVATE ACCESS EASEMENT SERVING LOTS 1-78 AND PARCELS B AND C, AND A CITY OF ALBUQUERQUE PUBLIC WATER AND PUBLIC SANITARY SEWER EASEMENTS GRANTED BY THIS PLAT. MAINTENANCE OF THE PRIVATE EASEMENTS SHALL BE THE RESPONSIBILITY OF THE OCOTILLO SUBDIVISION HOMEOWNERS ASSOCIATION, PURSUANT TO THE DECLARATION OF RESTRICTIVE AND PROTECTIVE COVENANTS FOR OCOTILLO SUBDIVISION FILED ON 03-11-2004, BOOK A34, PAGES 211-218
- 10 CITY OF ALBUQUERQUE PUBLIC STORM DRAINAGE EASEMENT WITHIN PARCEL A GRANTED BY THIS PLAT.
- 11 PUBLIC UTILITY EASEMENT GRANTED BY THIS PLAT
- 12 CITY OF ALBUQUERQUE PUBLIC WATER LINE EASEMENT GRANTED BY THIS PLAT
- 13 CITY OF ALBUQUERQUE PUBLIC STORM DRAINAGE EASEMENT GRANTED BY THIS PLAT
- 14 TEMPORARY PUBLIC VEHICULAR EASEMENT GRANTED BY THIS PLAT UNTIL SUCH TIME THAT HOLLY AVENUE N.E. IS VACATED AND/OR RELOCATED TO THE EAST OF PROPOSED OCOTILLO SUBDIVISION VIA THE STANDARD VACATION AND PLATTING PROCESS OF THE DEVELOPMENT REVIEW BOARD OF THE CITY OF ALBUQUERQUE.
- 15 TEMPORARY PUBLIC DRAINAGE EASEMENT GRANTED BY THIS PLAT TO CONVEY PUBLIC RUNOFF TO THE PUBLIC STORM DRAINAGE SYSTEM WITHIN PARCEL A UNTIL SUCH TIME THAT HOLLY AVENUE N.E. IS VACATED AND/OR RELOCATED TO THE EAST OF PROPOSED OCOTILLO SUBDIVISION VIA THE STANDARD VACATION AND PLATTING PROCESS OF THE DEVELOPMENT REVIEW BOARD OF THE CITY OF ALBUQUERQUE.
- 16 PARCEL C IS GRANTED AS A PRIVATE ACCESS EASEMENT SERVING LOTS 1-78 AND PARCELS B AND C, AND A CITY OF ALBUQUERQUE PUBLIC WATER AND PUBLIC SANITARY SEWER EASEMENTS. FUTURE VACATION AND/OR REALIGNMENT OF THESE EASEMENTS TO A LOCATION EAST OF OCOTILLO SUBDIVISION. MAINTENANCE OF THE PRIVATE ACCESS EASEMENT SHALL BE THE RESPONSIBILITY OF THE OCOTILLO SUBDIVISION HOMEOWNERS ASSOCIATION, PURSUANT TO THE DECLARATION OF RESTRICTIVE AND PROTECTIVE COVENANTS FOR OCOTILLO SUBDIVISION FILED ON 03-11-2004, BOOK A34, PAGES 211-218
- 17 PRIVATE LANDSCAPING EASEMENT GRANTED BY THIS PLAT TO SERVE THE OCOTILLO SUBDIVISION HOMEOWNERS ASSOCIATION. MAINTENANCE OF THE PRIVATE EASEMENT SHALL BE THE RESPONSIBILITY OF THE OCOTILLO SUBDIVISION HOMEOWNERS ASSOCIATION, PURSUANT TO THE DECLARATION OF RESTRICTIVE AND PROTECTIVE COVENANTS FOR OCOTILLO SUBDIVISION FILED ON 03-11-2004, BOOK A34, PAGES 211-218
- 18 TEMPORARY PUBLIC STORM DRAINAGE EASEMENT GRANTED BY THIS PLAT TO ACCEPT AND CONVEY EXISTING OFFSITE FLOWS FROM LOT 6, BLOCK 20, NORTH ALBUQUERQUE ACRES, TRACT 3, UNIT 1 TO PARCEL A UNTIL SUCH TIME THAT DEVELOPMENT ON SAID LOT 6 INTERCEPTS SAID HISTORIC FLOWS. MAINTENANCE OF THE TEMPORARY EASEMENT SHALL BE THE RESPONSIBILITY OF THE OCOTILLO SUBDIVISION HOMEOWNERS ASSOCIATION, PURSUANT TO THE DECLARATION OF RESTRICTIVE AND PROTECTIVE COVENANTS FOR OCOTILLO SUBDIVISION FILED ON 03-11-2004, BOOK A34, PAGES 211-218

RIGHT-OF-WAY DEDICATION

- 19 ADDITIONAL 4' FOR HOLBROOK STREET N.E. DEDICATED BY THIS PLAT, AREA = 0.0437 ACRES-


RECORD DRAWING

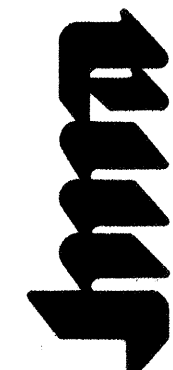

JEFF MORTENSEN & ASSOCIATES, INC.
600-B HIGHWAY PARK BLVD., N.E.
ALBUQUERQUE, NM 87109
ENGINEERS & SURVEYORS (SOS) 345-4250
JOB #2002.050.6 FINAL

SHEET 3 OF 6

2004032255

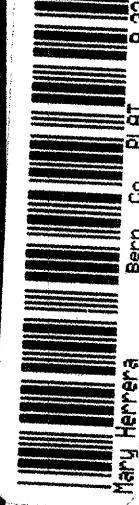

Jeff Mortensen & Associates, Inc.
600-B Highway Park Blvd., N.E.
Albuquerque, NM 87109
Engineers & Surveyors (SOS) 345-4250
Job #2002.050.6 FINAL

Bk. 2004c Pg. 76

COUNTY CLERK FILING DATA

EASEMENT TABLES

LINE	DIRECTION	DISTANCE
E1	S 89°32'10" E	31.58'
E2	S 00°27'50" W	27.16'
E3	N 89°32'10" W	41.07'

CURVE	RADIUS	LENGTH	CHORD BEARING	CHORD	DELTA
EC1	25.00'	39.27'	S 44°32'10" E	35.36'	90°00'00"
EC2	15.00'	23.56'	S 45°27'50" W	21.21'	90°00'00"

MATCH LINE - FOR CONTINUATION SEE SHEET 5

MATCH LINE - FOR CONTINUATION SEE SHEET 5

CARMEL AVENUE N.E.
S 89°32'10" E

LOT 12
0.2006 AC. ±

LOT 11
0.2210 AC. ±

LOT 10
0.2307 AC. ±

LOT 9
0.2233 AC. ±

LOT 8
0.2026 AC. ±

LOT 7
0.3188 AC. ±

LOT 6
0.3070 AC. ±

LOT 5
0.1939 AC. ±

LOT 4
0.2096 AC. ±

LOT 3
0.2283 AC. ±

LOT 2
1.32.37

LOT 1
0.2357 AC. ±

LOT 18, BLOCK 16
NORTH ALBUQUERQUE ACRES
TRACT 3, UNIT 1
(FILED 02-23-1931, 0-132)

LOT 17, BLOCK 16
NORTH ALBUQUERQUE ACRES
TRACT 3, UNIT 1
(FILED 02-23-1931, 0-132)

LOT 16, BLOCK 16
NORTH ALBUQUERQUE ACRES
TRACT 3, UNIT 1
(FILED 02-23-1931, 0-132)

LOT 15, BLOCK 16
NORTH ALBUQUERQUE ACRES
TRACT 3, UNIT 1
(FILED 02-23-1931, 0-132)

LOT 14, BLOCK 16
NORTH ALBUQUERQUE ACRES
TRACT 3, UNIT 1
(FILED 02-23-1931, 0-132)

LOT 13, BLOCK 16
NORTH ALBUQUERQUE ACRES
TRACT 3, UNIT 1
(FILED 02-23-1931, 0-132)

LOT 12, BLOCK 16
NORTH ALBUQUERQUE ACRES
TRACT 3, UNIT 1
(FILED 02-23-1931, 0-132)

CITY PROJECT
No. 729181

NEW MEXICO, CENTRAL ZONE-NAD 1927
A.C.S. 2011.275
Y=1,524,092.46
X=1,524,092.46
COMBINED FACTOR=0.99964740
ELEVATION=5474.310' (NGVD 29)

NEW MEXICO, CENTRAL ZONE-NAD 1927
A.C.S. 2011.275
Y=1,524,092.46
X=1,524,092.46
COMBINED FACTOR=0.99964740
ELEVATION=5474.310' (NGVD 29)

NEW MEXICO, CENTRAL ZONE-NAD 1927
A.C.S. 2011.275
Y=1,524,092.46
X=1,524,092.46
COMBINED FACTOR=0.99964740
ELEVATION=5474.310' (NGVD 29)



NEW MEXICO, CENTRAL ZONE-NAD 1927
A.C.S. 2011.275
Y=1,524,092.46
X=1,524,092.46
COMBINED FACTOR=0.99964740
ELEVATION=5474.310' (NGVD 29)

NEW MEXICO, CENTRAL ZONE-NAD 1927
A.C.S. 2011.275
Y=1,524,092.46
X=1,524,092.46
COMBINED FACTOR=0.99964740
ELEVATION=5474.310' (NGVD 29)



JEFF MORTENSEN & ASSOCIATES, INC.
600-B HIGHWAY PARK BLVD., N.E.
ALBUQUERQUE, NM 87109
ENGINEERS & SURVEYORS (SOS) 345-4250
JOB #2002.050.6 FINAL


SHEET 4 OF 6

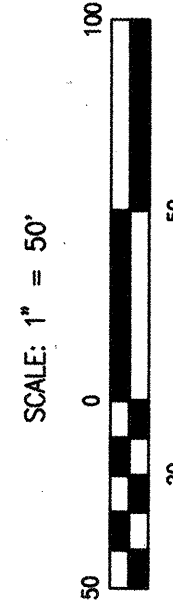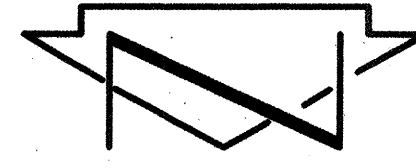

NOTE: FOR CENTERLINE AND BOUNDARY TABLES SEE SHEET 2 OF 6.
FOR KEYED NOTES SEE SHEET 3 OF 6.

FOR CENTERLINE AND BOUNDARY TABLES
FOR KEYED NOTES SEE SHEET 3 OF 6.

MATCH LINE - FOR CONTINUATION SEE SHEET 6

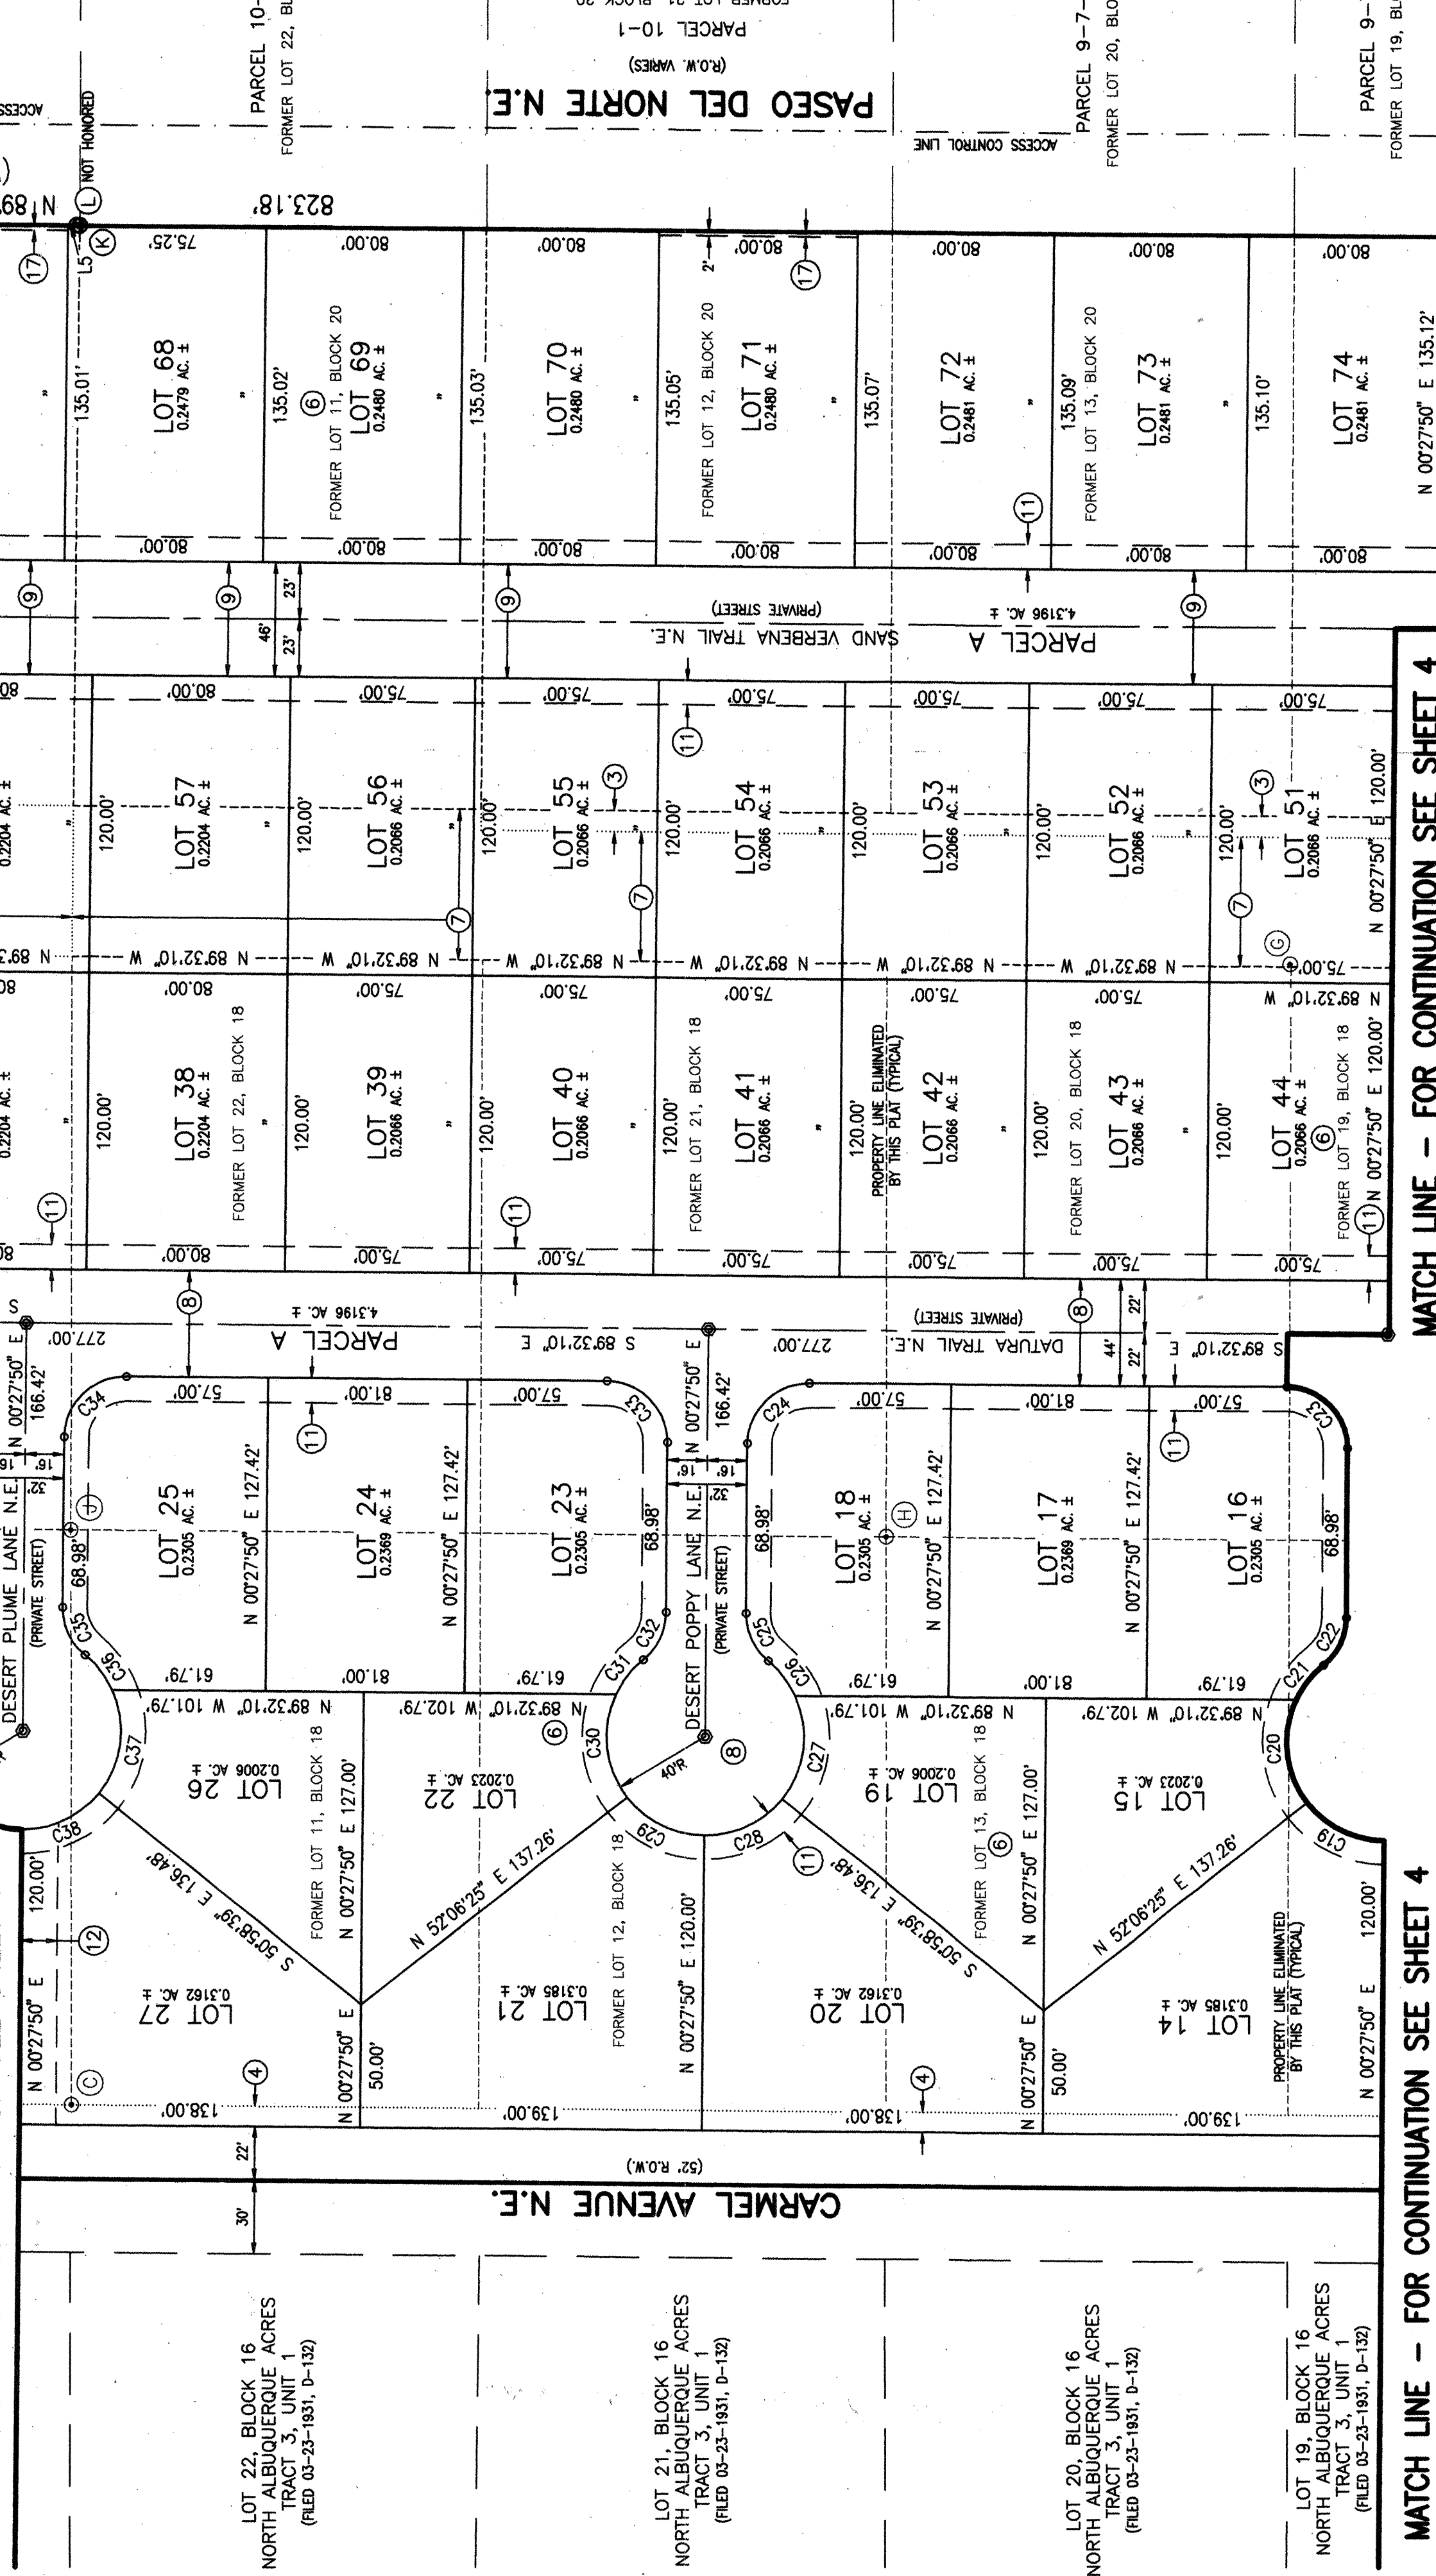

MATCH LINE - FOR CONTINUATION SEE SHEET 4

MATCH LINE - FOR CONTINUATION SEE SHEET 4

MATCH LINE - FOR CONTINUATION SEE SHEET 4



JEFF MORTENSEN & ASSOCIATES, INC.
☐ 6010-B MIDWAY PARK BLVD, N.E.
☐ ALBUQUERQUE ☐ NEW MEXICO 87109
☐ ENGINEERS ☐ SURVEYORS (505) 345-4250
 JOB #2002.050.6 FINAL2

JOB #2002.050.6 FINAL2

SHEET 5 OF 6

SP #2003430380





Mary Herrera
Bern. Co. PLRT R 32 00
83/11/26094 16:33
Page: 6 of 6
8045741
2008032255

SUBDIVISION PLAT OF
OCOTILLO SUBDIVISION
ALBUQUERQUE, BERNALILLO COUNTY, NEW MEXICO
FEBRUARY, 2004

FEBRUARY, 2004

COUNTY CLERK FILING DATA

RECORD DRAWING

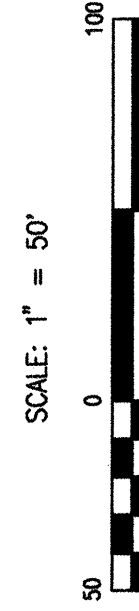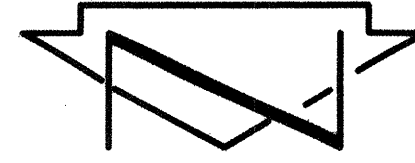


SCALE: 1" = 50'



NOTE: FOR CENTERLINE AND BOUNDARY TABLES SEE SHEET 2 OF 6.

LINE	DIRECTION	DISTANCE	CURVE	RADIUS	LENGTH	CHORD BEARING	CHORD	DELTA
E4	S 89°30'40"	E 93.87'						
E5	N 89°30'40"	W 23.00'						
E6	N 89°30'40"	W 27.00'						
E7	N 00°27'50"	E 35.00'						
			45.00'	60.58'		S 51°52'56"	56.11'	77°08'09"
			EF3					


NOTE: FOR CENTERLINE AND BOUNDARY TABLES SEE SHEET 2 OF 6.
FOR KEYED NOTES SEE SHEET 3 OF 6.

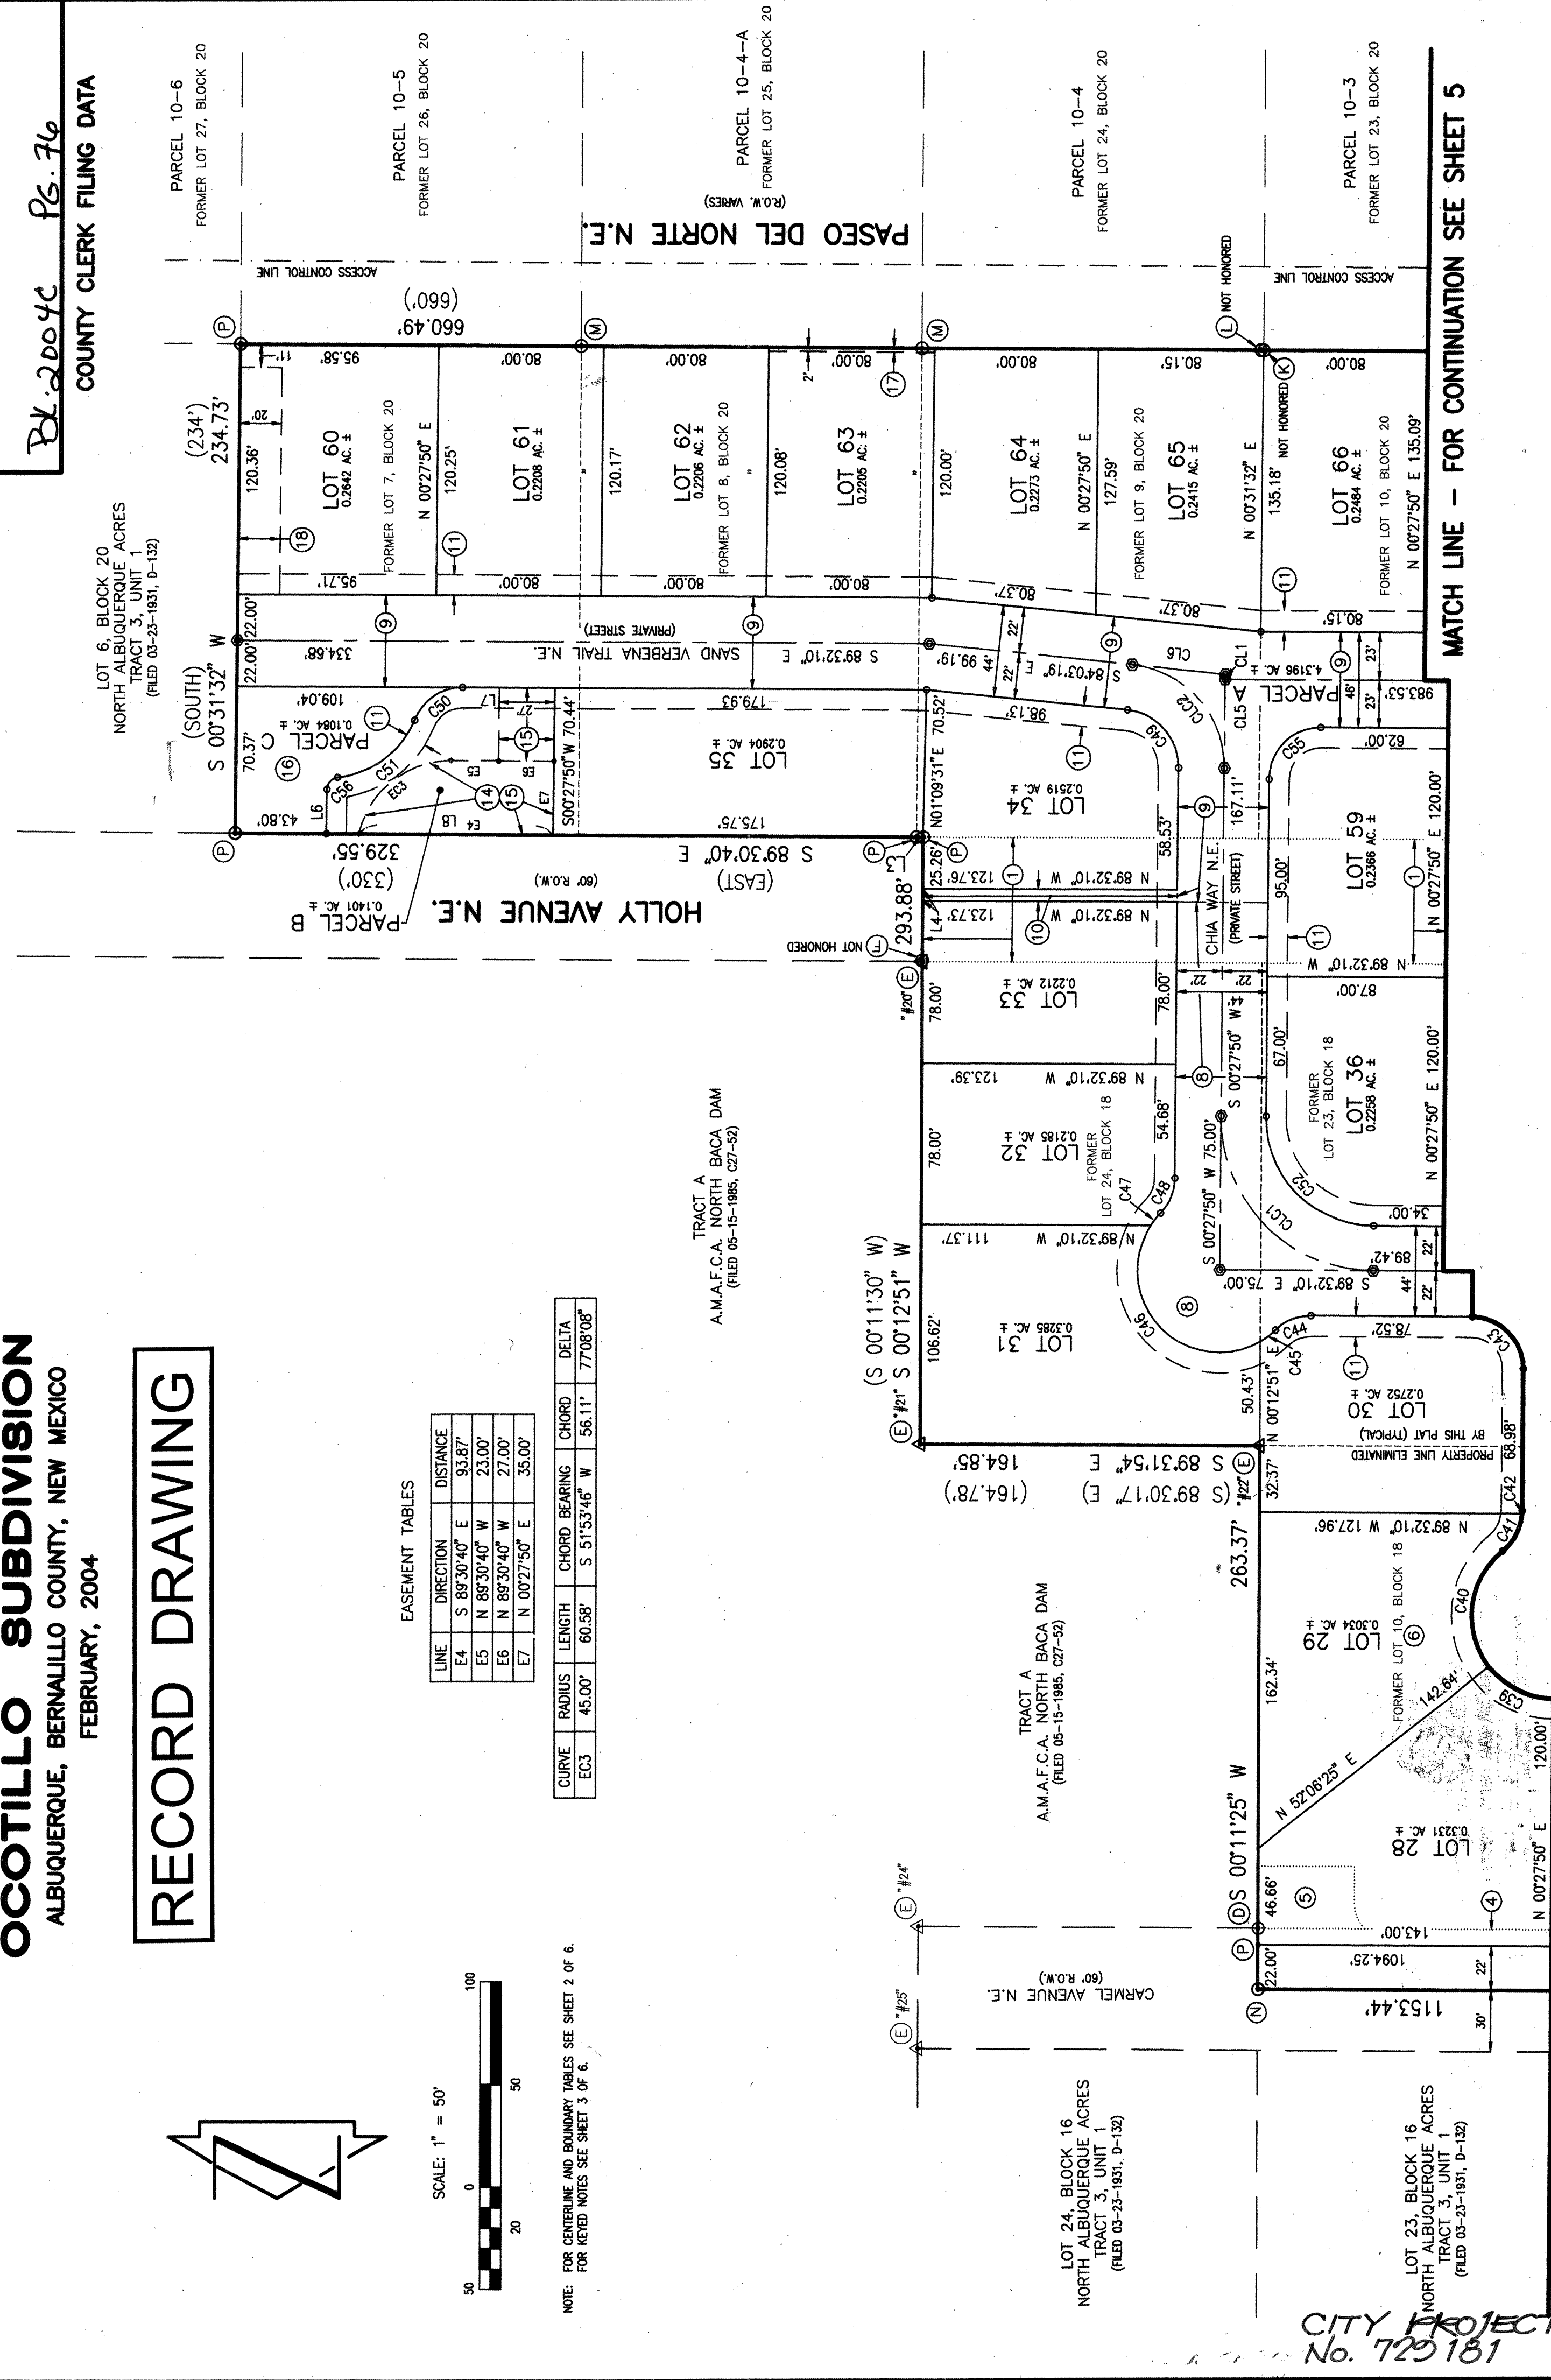

MATCH LINE - FOR CONTINUATION SEE SHEET 5

JEFF MORTENSEN & ASSOCIATES, INC.
☐ 6010-B MIDWAY PARK BLVD. NE.
☐ ALBUQUERQUE ☐ NEW MEXICO 87109
☐ ENGINEERS ☐ SURVEYORS (505) 345-4

SHEET 6 OF 6

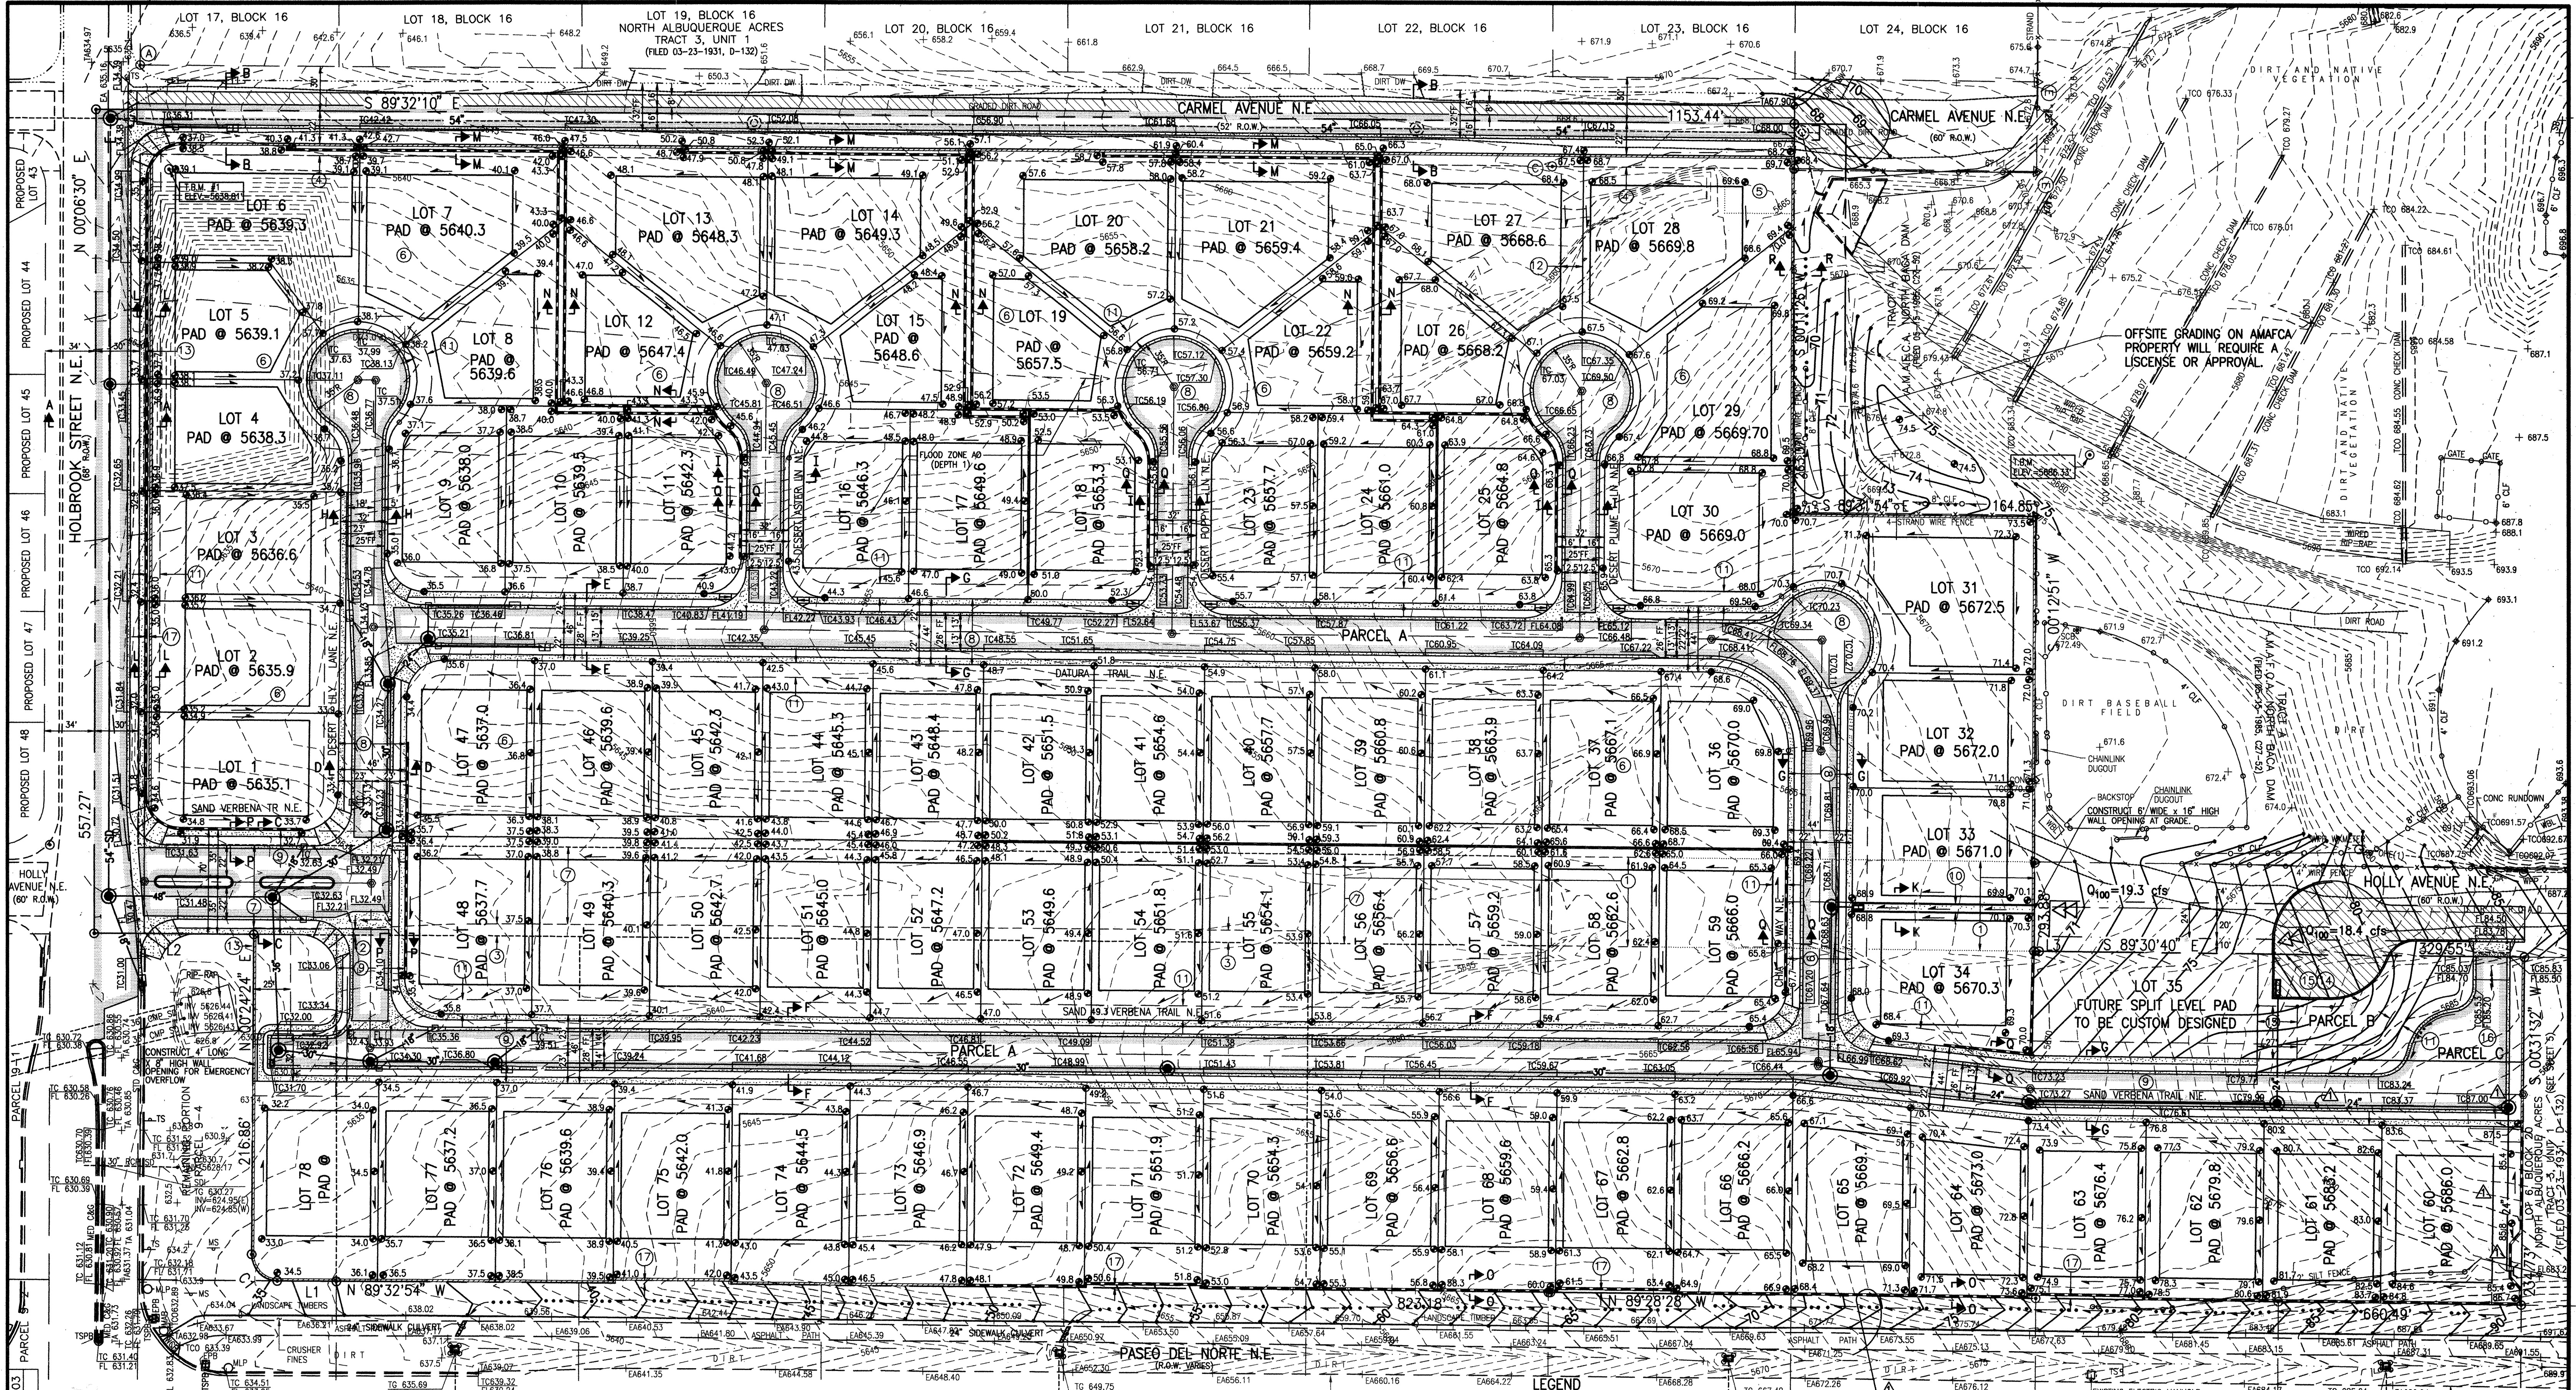


SEE SHEET 1 FOR CERTIFICATION
RECORD DRAWING


- NOTES:**
- 1. SEE SHEETS 3 AND 4 FOR SECTIONS AND DETAILS
 - 2. SEE SHEET 5 FOR BASIN MAP, INLET AND STORM DRAIN INFORMATION
 - 3. THIS IS NOT A BOUNDARY SURVEY. APPARENT PROPERTY CORNERS ARE SHOWN HEREON FOR ORIENTATION PURPOSES ONLY. TOPOGRAPHIC DATA IS FROM A MARCH, 2003 SURVEY CONDUCTED BY THIS OFFICE.
 - 4. SEE SHEET 1 FOR KEYED EASEMENT AND VACATION NOTES.
 - 5. GRADING SOUTH OF SITE IN NMSHTD ROW WILL REQUIRE THEIR APPROVAL.

LEGEND

- NEW PAVEMENT
- TEMP PAVEMENT
- NEW CONCRETE
- SDMH
- FLOWLINE
- SPOT ELEVATION
- DIRECTION OF FLOW
- MOUNTABLE CURB AND GUTTER
- RETAINING WALL
- YARD/GARDEN WALL (18" MAX. RETENTION)

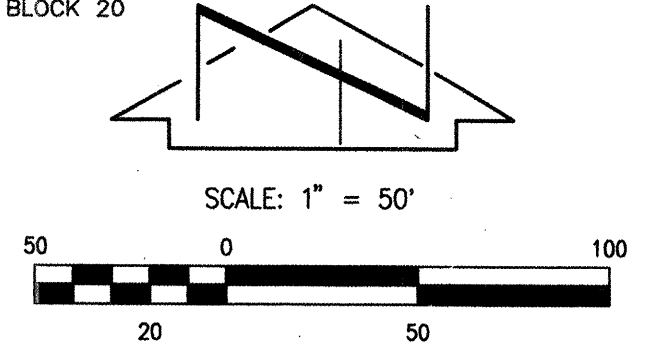

DRB PROJECT # 1002885

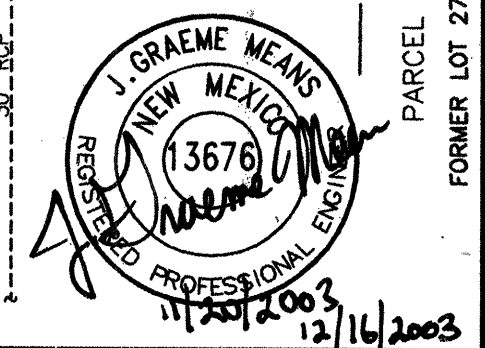

Jma
JEFF MORTENSEN & ASSOCIATES, INC.
6001-B MIDWAY PARK BLVD. N.E.
ALBUQUERQUE, NM 87109
ENGINEERS & SURVEYORS (C80) 345-4230
FAX: 505 345-4254 | Email: jma@jma-inc.com

APPROVED FOR ROUGH GRADING
Brad D. Bjork 12/16/03
CITY HYDROLOGY

GRADING PLAN (AS APPROVED)
OCOTILLO SUBDIVISION

DESIGNED BY: G.M.
DRAWN BY: S.G.H./J.L.P.
APPROVED BY: G.M.

NO.	DATE	BY	REVISIONS	JOB NO.
1	12/16/03	G.M.	ACCEPT OFFSITE FLOWS ON LOT 60; ADD STORM DRAIN, ADD NMSHTD GRADING NOTE	2002.050.3
2	1/10/04		RECORD DRAWING (AS APPROVED)	
				DATE: 11-2003
				SHEET 5 OF 25

CITY PROJECT No. 729181

SCANNED BY
INCSA REPRO

- KEYED NOTES
(SEE PLAT, SHEETS 2-4 FOR MORE INFORMATION REGARDING BOUNDARY AND EASEMENTS)
- SOUTH 8' OF CARMEL AVENUE N.E. VACATED BY 030RB-01355
 - PRIVATE ACCESS, PRIVATE STORM DRAINAGE EASEMENTS SERVING LOTS 1-78 AND PARCELS B AND C, AND CITY OF ALBUQUERQUE PUBLIC WATER AND PUBLIC SANITARY SEWER EASEMENTS. MAINTENANCE OF THE PRIVATE EASEMENTS SHALL BE THE RESPONSIBILITY OF THE OCOTILLO SUBDIVISION HOMEOWNERS ASSOCIATION.
 - PRIVATE ACCESS EASEMENT SERVING LOTS 1-78 AND PARCELS B AND C, AND CITY OF ALBUQUERQUE PUBLIC STORM DRAINAGE, PUBLIC WATER AND PUBLIC SANITARY SEWER EASEMENTS. MAINTENANCE OF THE PRIVATE EASEMENTS SHALL BE THE RESPONSIBILITY OF THE OCOTILLO SUBDIVISION HOMEOWNERS ASSOCIATION.
 - CITY OF ALBUQUERQUE PUBLIC STORM DRAINAGE EASEMENT WITHIN PARCEL A.
 - 10' PUBLIC UTILITY EASEMENT.
 - 15' CITY OF ALBUQUERQUE PUBLIC WATER LINE EASEMENT.
 - 25' CITY OF ALBUQUERQUE PUBLIC STORM DRAINAGE EASEMENT.
 - TEMPORARY PUBLIC VEHICULAR EASEMENT GRANTED UNTIL SUCH TIME THAT HOLLY AVENUE N.E. IS VACATED AND/OR RELOCATED TO THE EAST OF PROPOSED OCOTILLO SUBDIVISION VIA THE STANDARD VACATION AND PLATTING PROCESS OF THE DEVELOPMENT REVIEW BOARD OF THE CITY OF ALBUQUERQUE.
 - TEMPORARY PUBLIC DRAINAGE EASEMENT GRANTED TO CONVEY PUBLIC RUNOFF TO THE PUBLIC STORM DRAINAGE SYSTEM WITHIN PARCEL A UNTIL SUCH TIME THAT HOLLY AVENUE N.E. IS VACATED AND/OR RELOCATED TO THE EAST OF PROPOSED OCOTILLO SUBDIVISION VIA THE STANDARD VACATION AND PLATTING PROCESS OF THE DEVELOPMENT REVIEW BOARD OF THE CITY OF ALBUQUERQUE.
 - PARCEL C IS GRANTED AS A PRIVATE ACCESS EASEMENT SERVING LOTS 1-78 AND PARCELS B AND C, AND A CITY OF ALBUQUERQUE PUBLIC WATER AND PUBLIC SANITARY SEWER EASEMENT. FUTURE VACATION OF HOLLY AVENUE N.E., ADJACENT TO PARCELS B AND C SHALL ALSO REQUIRE VACATION AND/OR REALIGNMENT OF THESE EASEMENTS TO A LOCATION EAST OF OCOTILLO SUBDIVISION. MAINTENANCE OF THE PRIVATE ACCESS EASEMENT SHALL BE THE RESPONSIBILITY OF THE SUBDIVISION HOMEOWNERS ASSOCIATION.
 - PRIVATE LANDSCAPING EASEMENT GRANTED TO SERVE THE OCOTILLO SUBDIVISION HOMEOWNERS ASSOCIATION. MAINTENANCE OF THE PRIVATE EASEMENT SHALL BE THE RESPONSIBILITY OF THE OCOTILLO SUBDIVISION HOMEOWNERS ASSOCIATION.
 - 20' TEMPORARY PUBLIC STORM DRAINAGE EASEMENT TO ACCEPT AND CONVEY EXISTING OFFSITE FLOWS FROM LOT 6, BLOCK 20, NORTH ALBUQUERQUE ACRES, TRACT 3, UNIT 1 TO PARCEL A UNTIL SUCH TIME THAT DEVELOPMENT ON SAID LOT 6 INTERCEPTS SAID HISTORIC FLOWS. MAINTENANCE OF THE TEMPORARY EASEMENT SHALL BE THE RESPONSIBILITY OF THE OCOTILLO SUBDIVISION HOMEOWNERS ASSOCIATION.

PAVING LEGEND

- PROPOSED PERMANENT PAVEMENT
- PROPOSED TEMPORARY PAVEMENT PER C.O.A. STD. DWG. 2415B
- PROPOSED CONCRETE
- PROPOSED STREET LIGHT
- PROPOSED STORM DRAIN MANHOLE
- PROPOSED RETAINING WALL BY SEPARATE PERMIT AND PLAN SET
- PROPOSED GARDEN WALL BY SEPARATE PERMIT AND PLAN SET
- MOUNTABLE CURB AND GUTTER PER COA STD DWG 2415A
- STANDARD CURB AND GUTTER PER COA STD DWG 2415A
- CROWN TRANSITION PER C.O.A. STD DWG 2401

BOUNDARY TABLES

LINE	DIRECTION	DISTANCE
L1	N 89°55'27" W	38.65'
L2	N 89°32'10" W	108.39'
L3	S 89°32'10" E	3.32'

CURVE	RADIUS	LENGTH	CHORD BEARING	CHORD	DELTA
C1	17.50'	27.70'	N 44°33'55" W	24.90'	90°41'57"

SITE PLAN NOTES

- SEE SHEETS 2-4 FOR SUBDIVISION PLAT.
- SEE SHEET 5 FOR APPROVED GRADING PLAN
- SEE SHEET 7 FOR PAVING AND DRAINAGE SECTIONS AND DETAILS
- SEE SHEET 8 FOR STREET SECTIONS
- THIS IS NOT A BOUNDARY SURVEY. APPARENT PROPERTY CORNERS ARE SHOWN HEREON FOR ORIENTATION PURPOSES ONLY. BOUNDARY DATA SHOWN IS FROM SUBDIVISION PLAT PREPARED BY THIS OFFICE (SEE SHEETS 2-4 FOR COPY OF RECORDED PLAT)

RECORD DRAWING

SEE SHEET 1 FOR CERTIFICATION

JMA
2002.050.48

CITY OF ALBUQUERQUE
PUBLIC WORKS DEPARTMENT
ENGINEERING DEVELOPMENT GROUP

TITLE: OCOTILLO SUBDIVISION
PAVING AND STORM DRAINAGE SITE PLAN









Design Review Committee City Engineer Approval

City Project No. 729181 Zone Map No. C-21 Sheet 6 of 25


City Project No. 729181 Zone Map No. C-21 Sheet 6 of 25

City Project No. 729181 Zone Map No. C-21 Sheet 6 of 25

City Project No. 729181 Zone Map No. C-21 Sheet 6 of 25

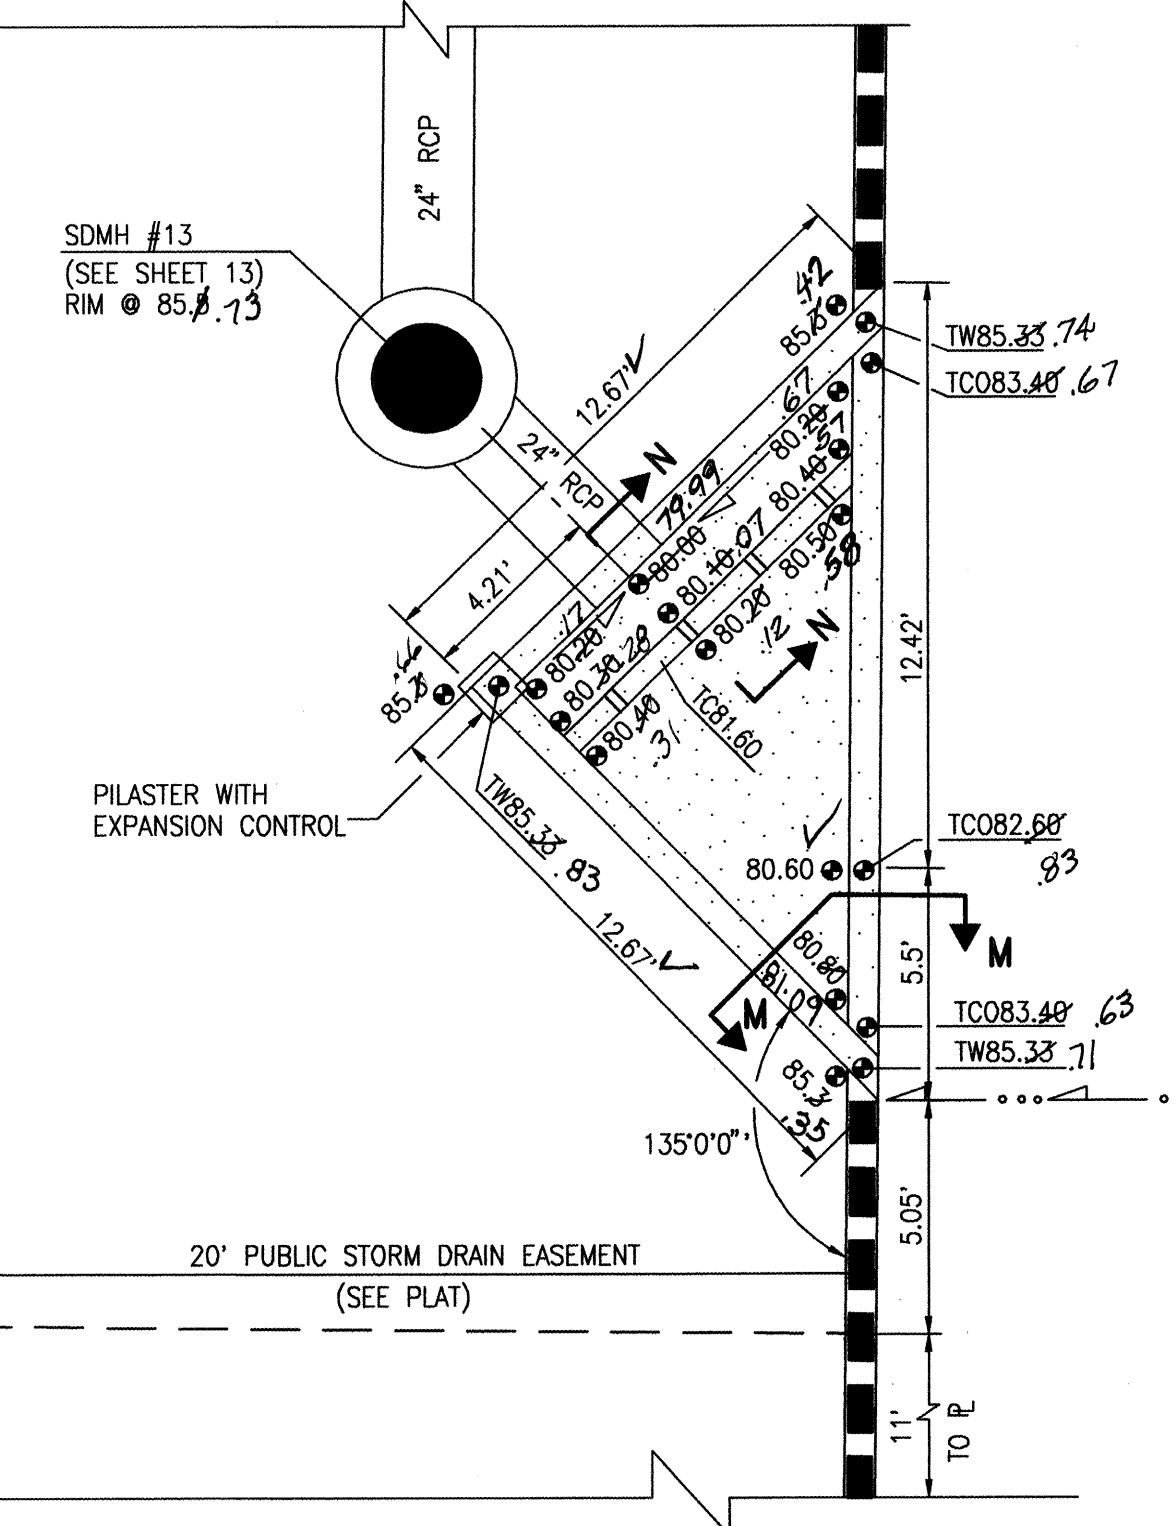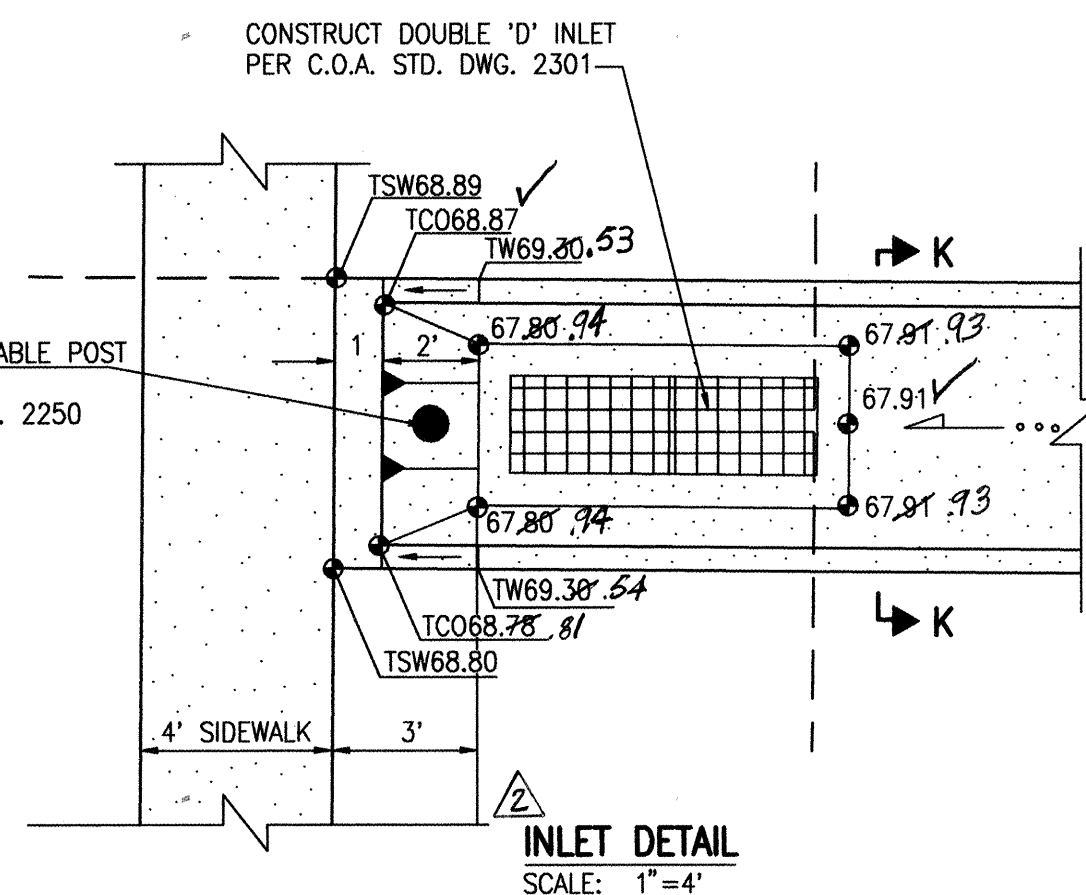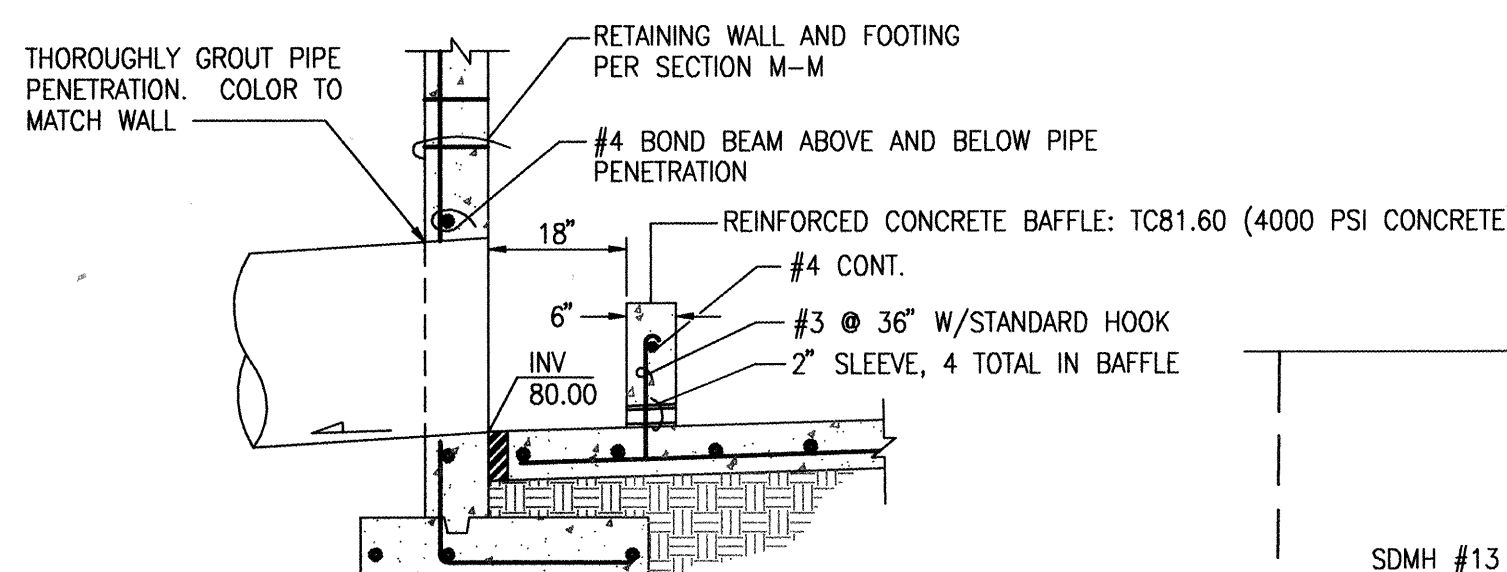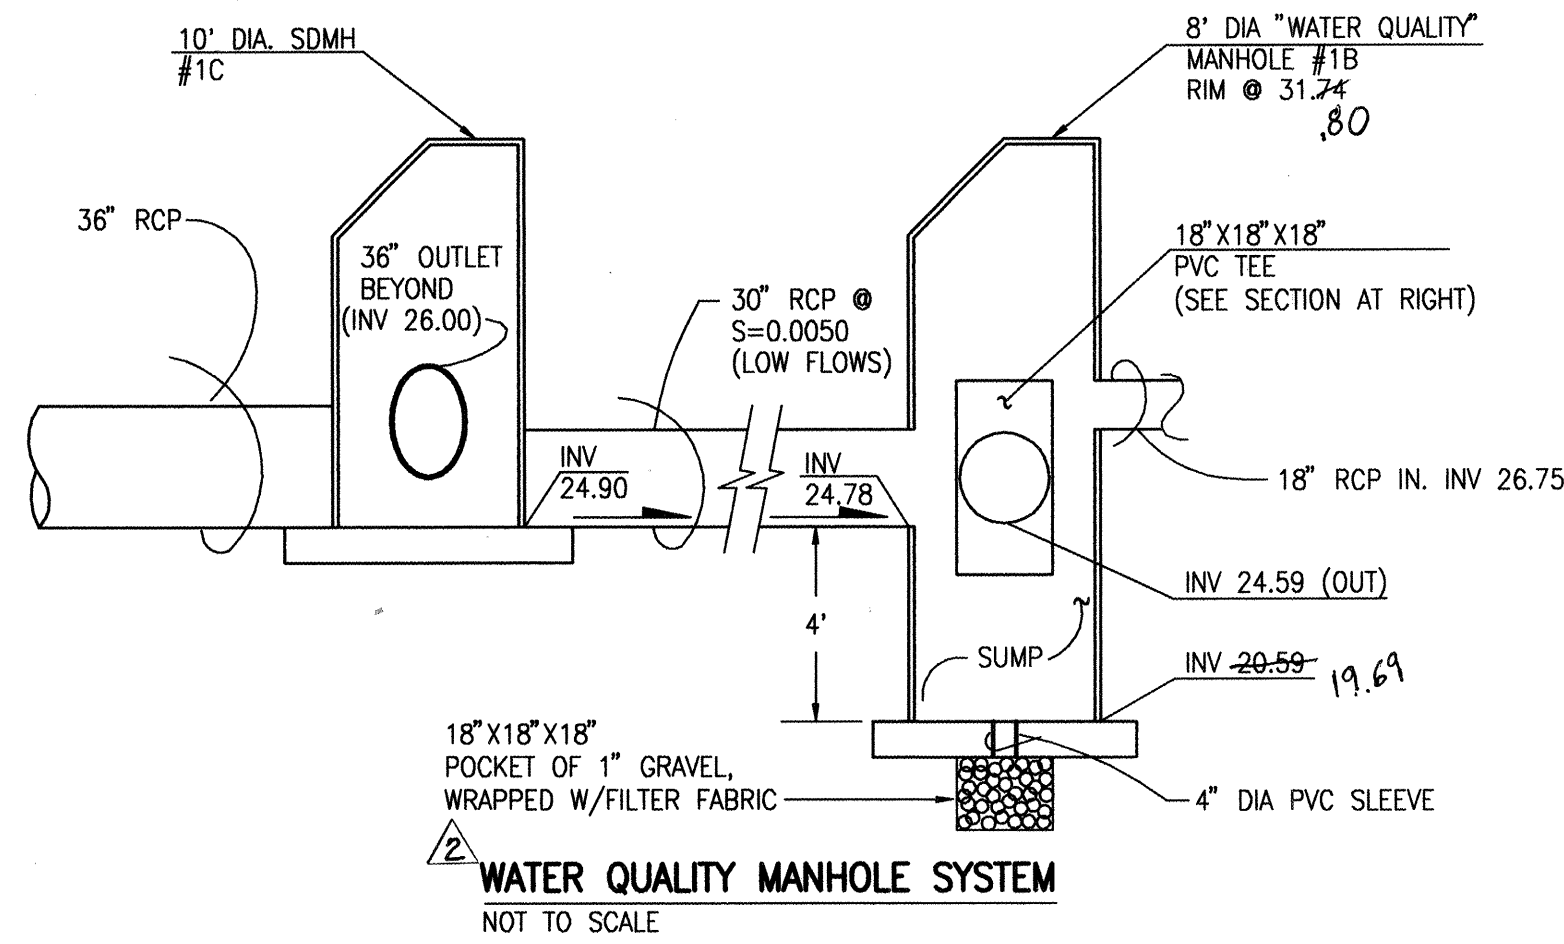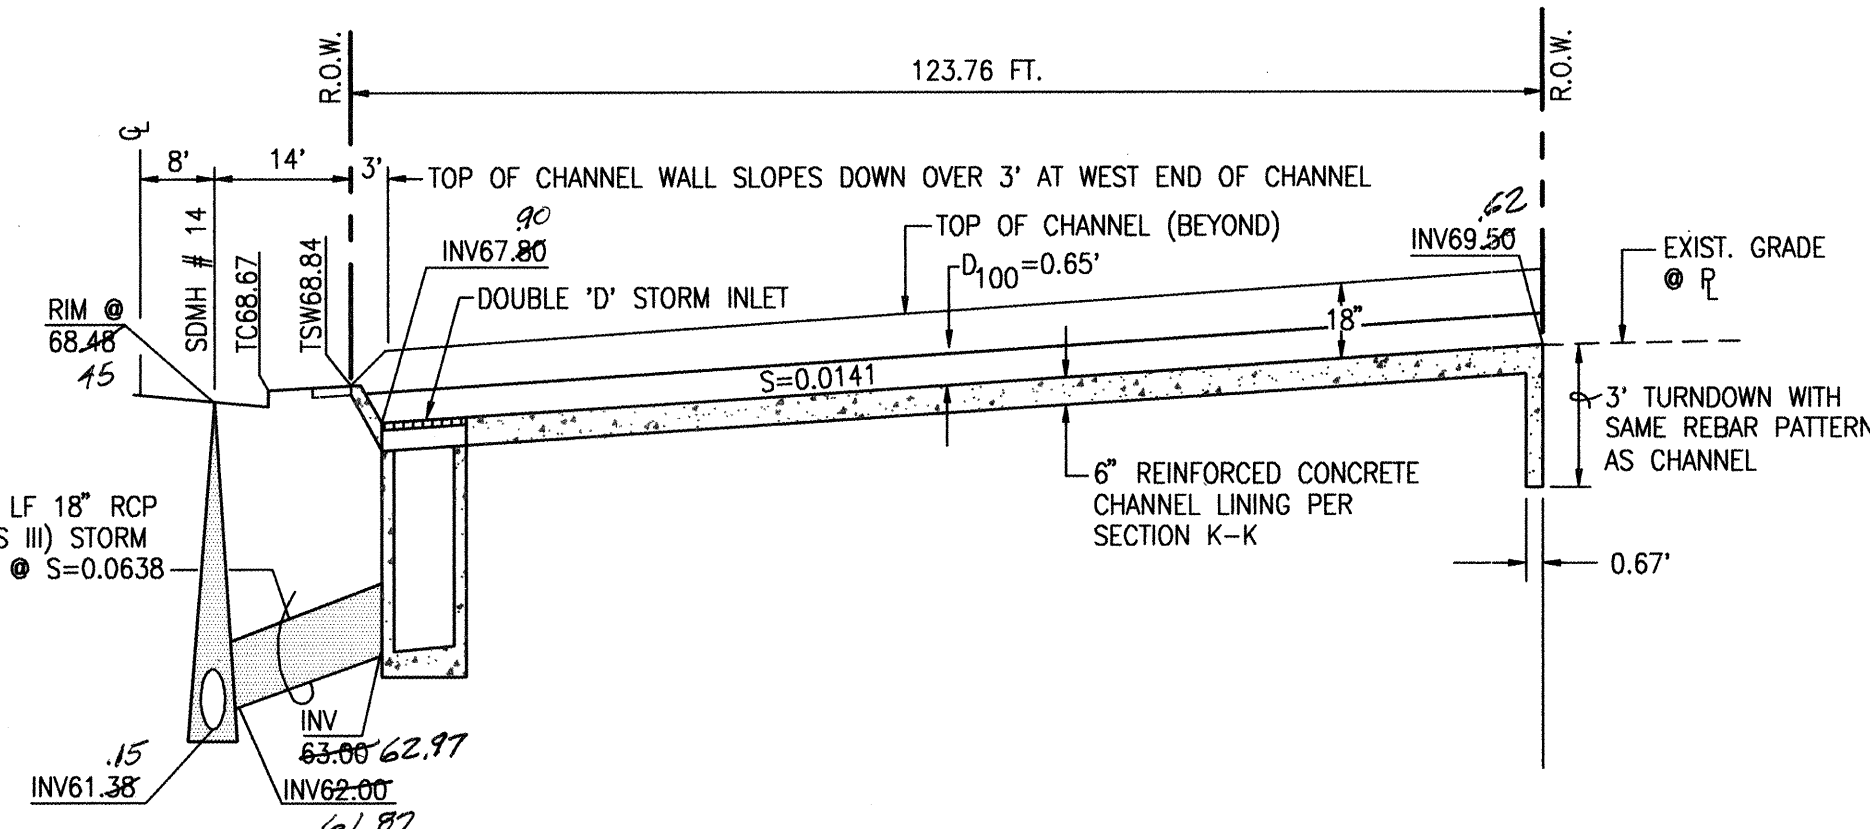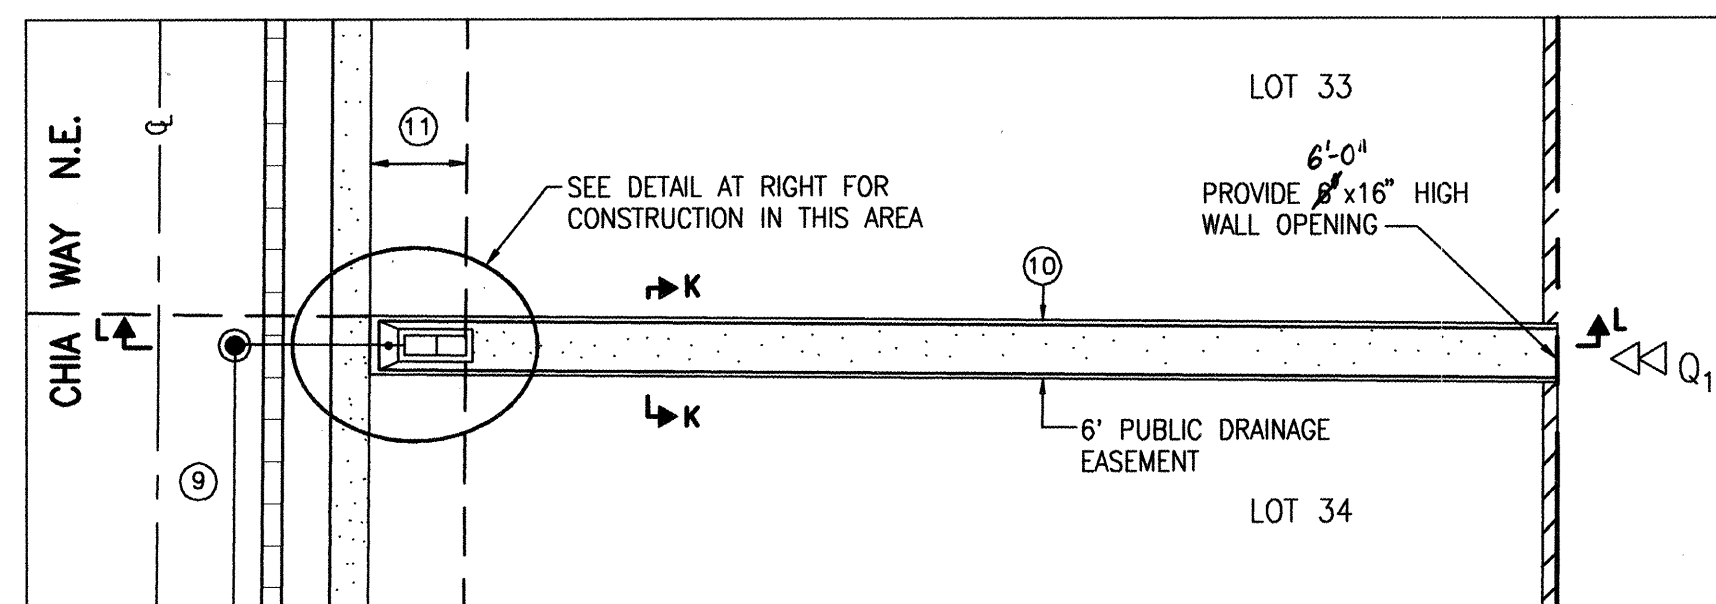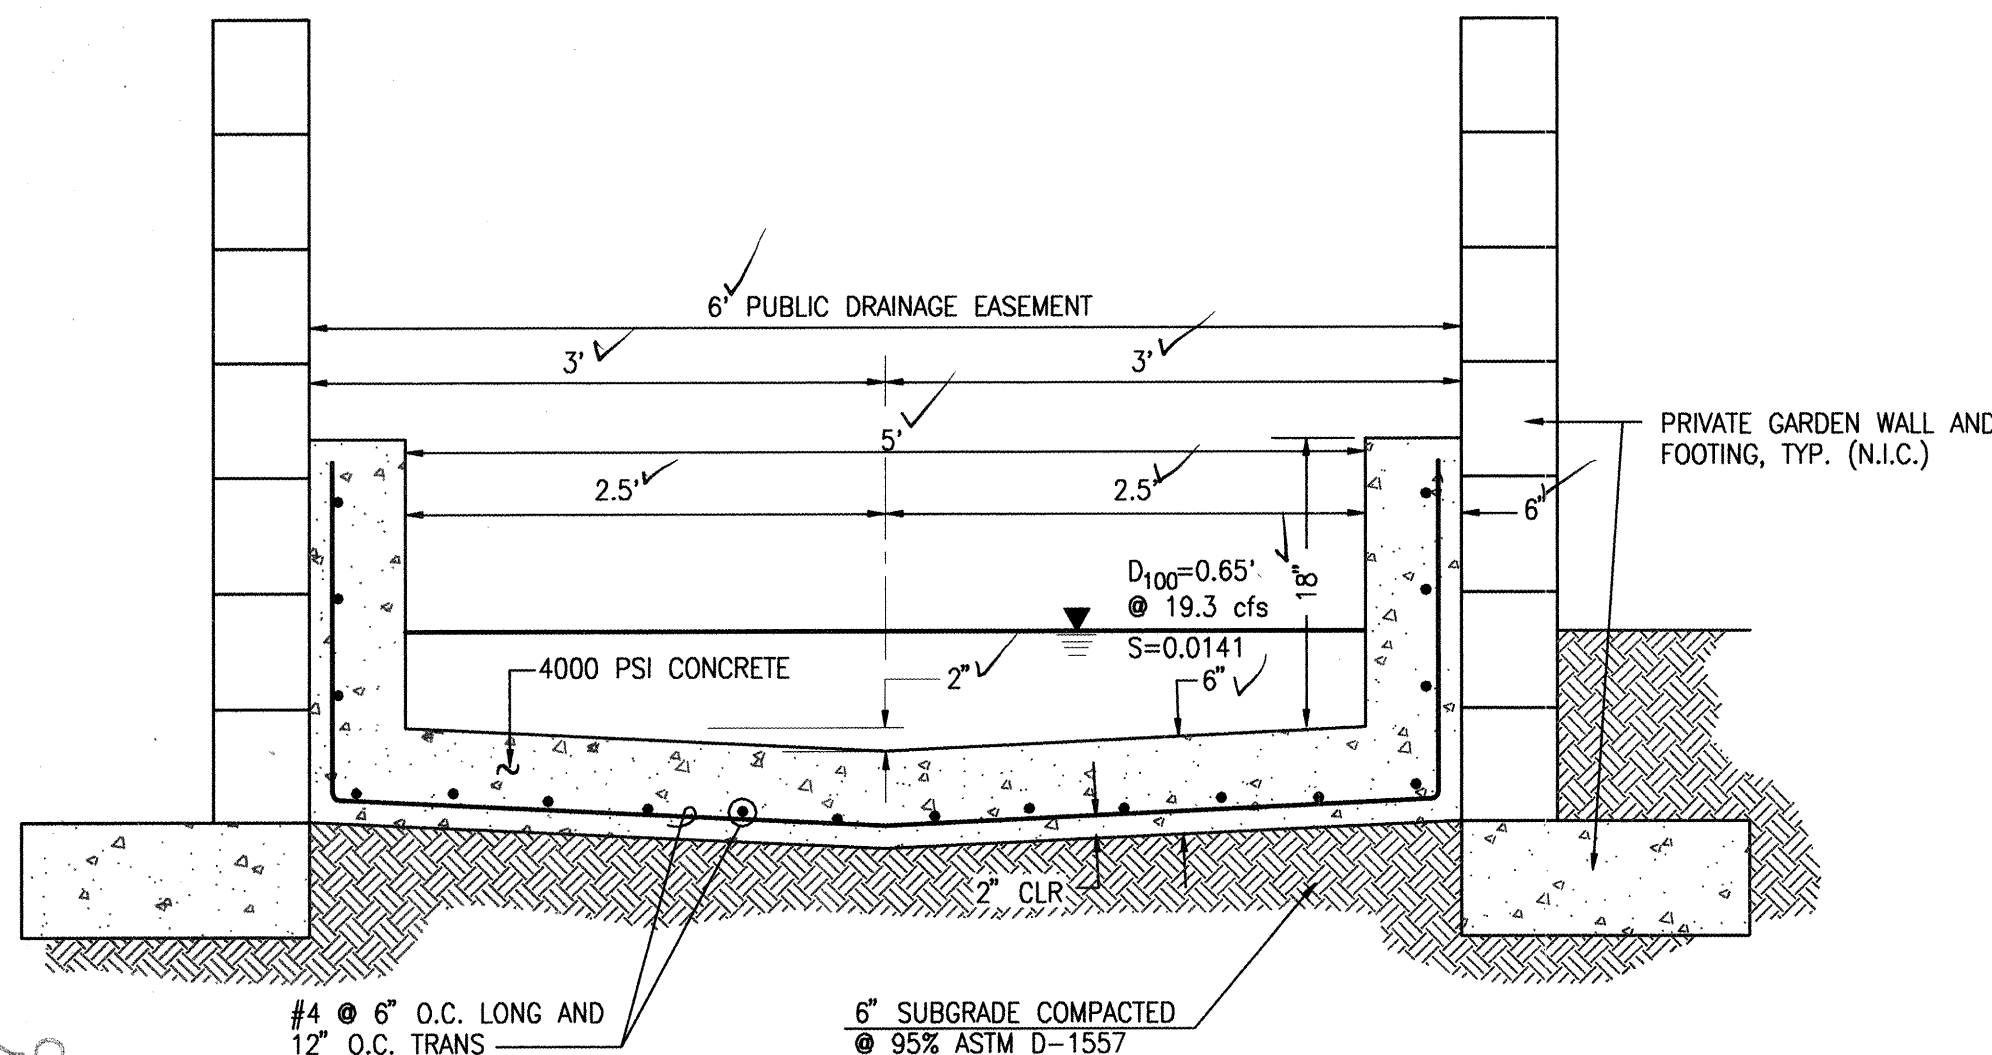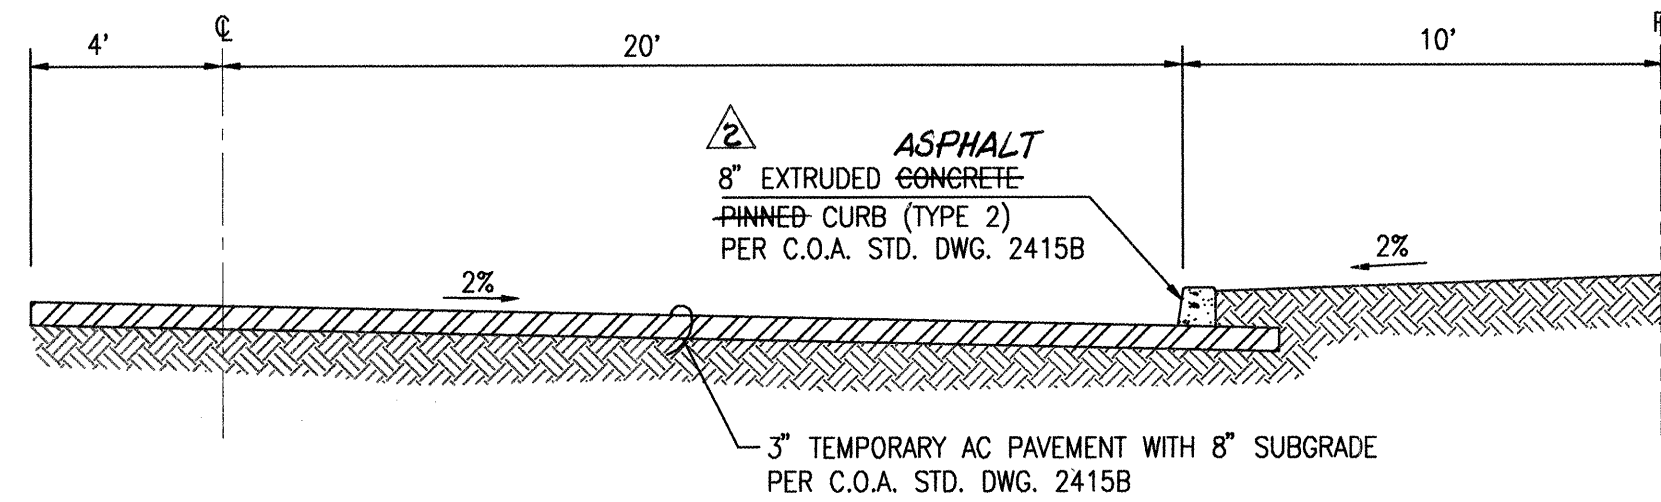


WATER QUALITY MANHOLE OUTLET SECTION
 NOT TO SCALE

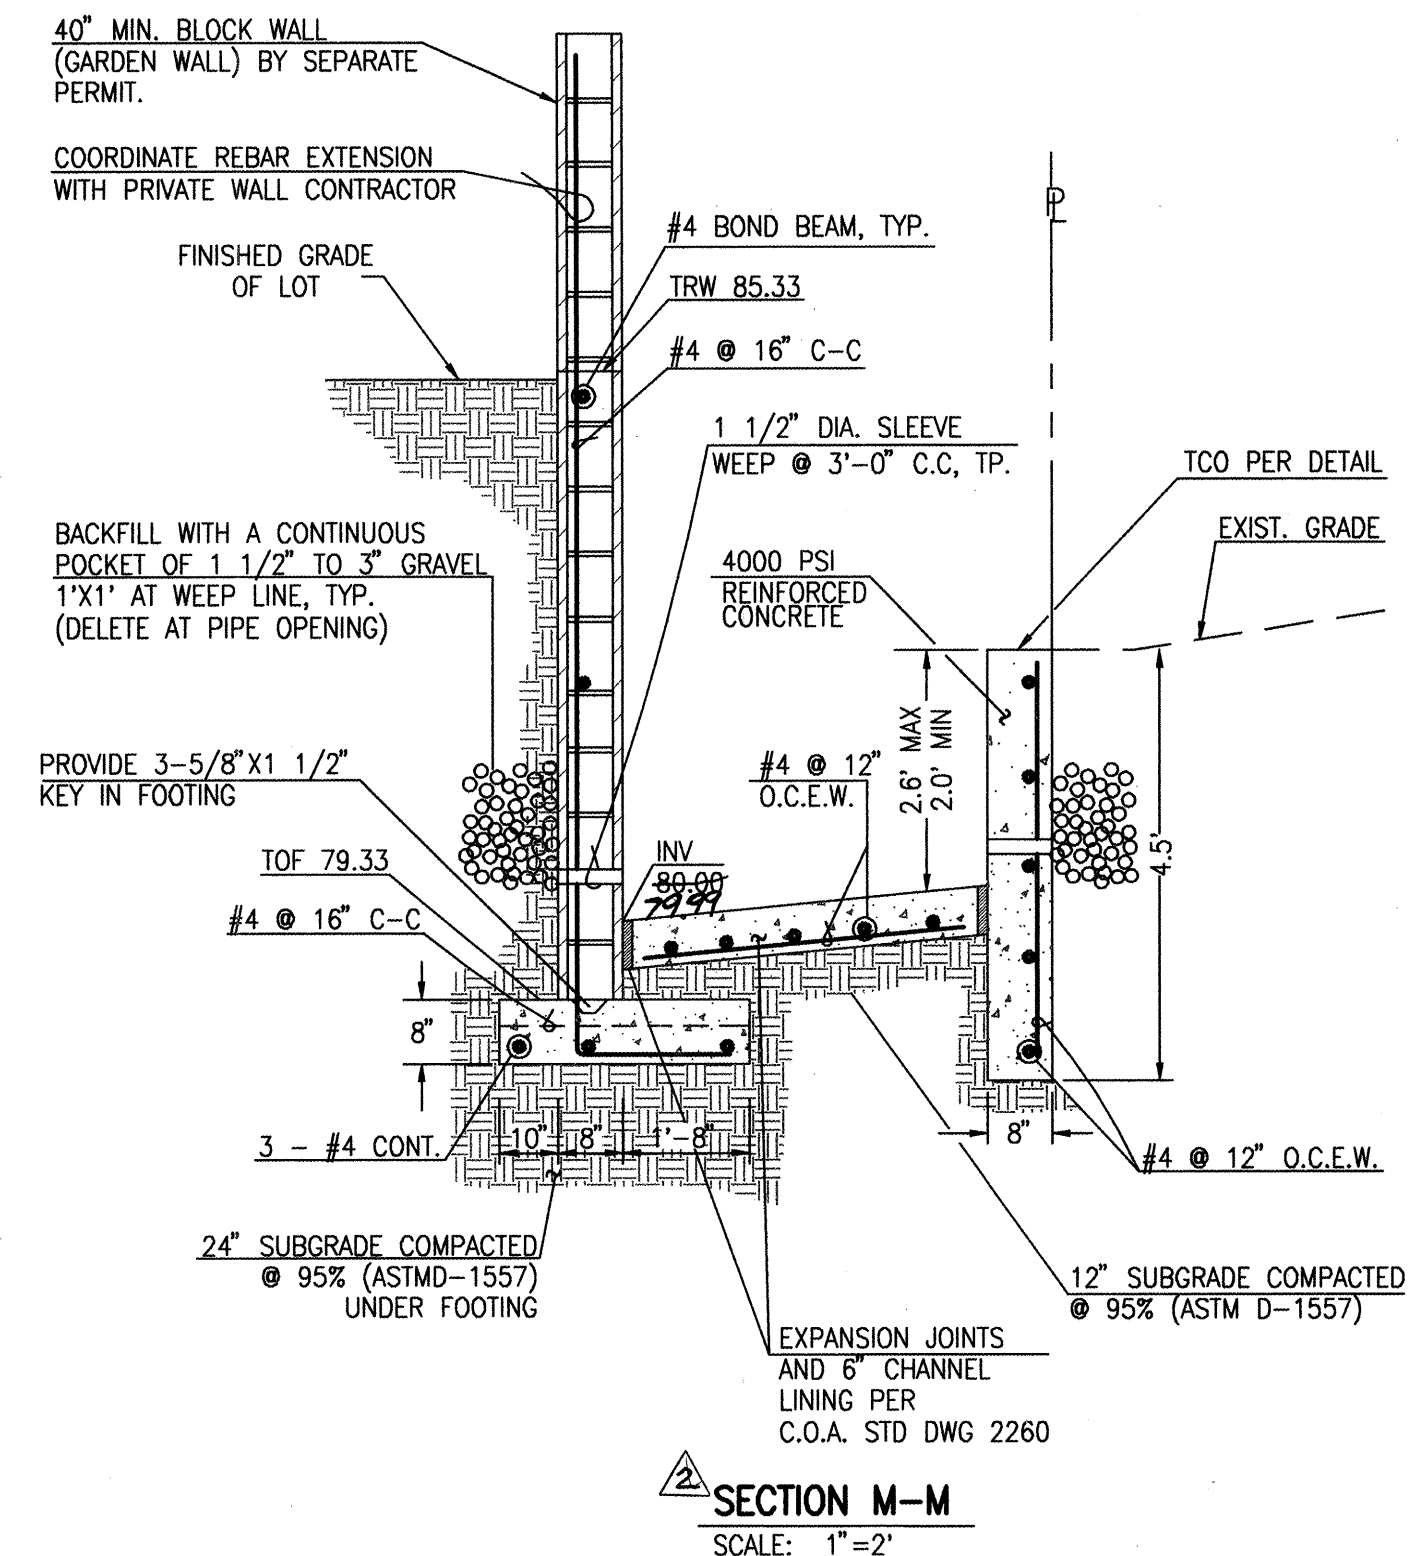

- RETAINING WALL NOTES:
1. 8" X 8" X 16" CMU OF UBC STD. 24-4 OR 24-5.
 2. USE KNOCK-OUT BOND BEAM BLOCK AT 4'-0" MAX C.C., VERTICALLY, AND 1 #4 CONTINUOUS.
 3. FILL ALL BLOCK VOIDS WITH 3000 PSI CONCRETE.
 4. REINFORCING TO BE INTERMEDIATE GRADE STEEL. $f_s=20,000$ psi
 5. IN LIEU OF CONTINUOUS KNOCK-OUT BOND BEAMS, CONTRACTOR MAY INSTALL DUR-O-WALL REINFORCING EVERY SECOND COURSE.
 6. SPLICE SHALL BE 40 BAR DIA. MINIMUM FOR VERTICAL BARS. ALL OTHER SHALL BE 20 BAR DIA. MINIMUM.
 7. CONCRETE FILL SHALL BE 21 DAYS OLD OR ACHIEVE 70% OF DESIGN STRENGTH PRIOR TO BACKFILLING.

HOLBROOK STREET NE

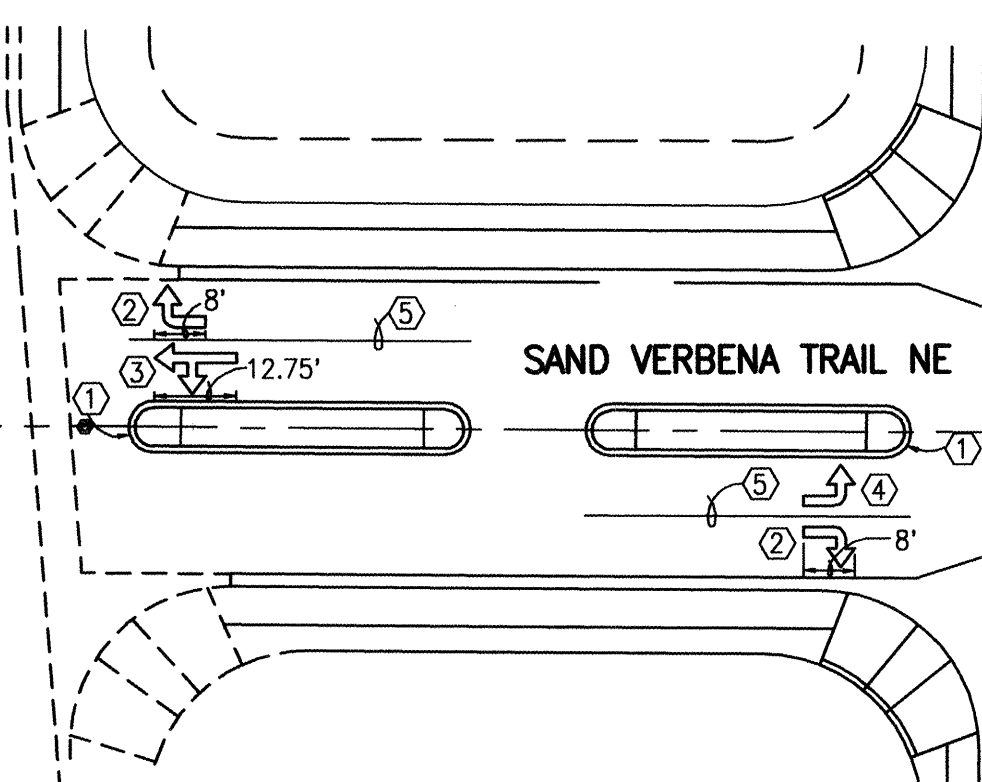

SEE SHEET 1 FOR CERTIFICATION

RECORD DRAWING


AS BUILT INFORMATION		BENCH MARKS		SURVEY INFORMATION		ENGINEER'S SEAL		
CONTRACTOR	C.C.M.	PROJECT BENCHMARK - ACS STATION "HEAVY" (TIED TO PASEO DEL NORTE ROAD - MAY CONSTRUCTION IN 1990) PREVIOUS ELEVATION = 5379.70 FEET (NGD 1929)	DATE	03/03	NO.	20002		
WORK BY	J.M.A.	THIS BENCHMARK HAS BEEN USED TO PROVIDE UNIFORMITY BETWEEN THIS SURVEY AND THE PREVIOUS SURVEYS CONDUCTED FOR RELATED NORTH DOMINGO BACA ARROYO PROJECTS. THE ELEVATION FOR ACS STATION "5-207" AN ACS 1.3/4" ALUMINUM DISK STAMPED "ACS BM 5-207" EXPOSED TO THE TOP OF THE CONCRETE DROP INLET, AT THE INLET CURB RETURN IN THE NORTHEAST QUADRANT OF THE INTERSECTION OF VENTURA STREET AND ANHEIM AVENUE N.E., BASED UPON THIS DATUM	DATE	03/04	DATE	03-2004		
INSPECTED BY	J.M.A.	DATE	03/04	DATE	03-2004	DATE		04-2004
APPROVED BY	J.M.A.	DATE	03/04	DATE	03-2004	DATE		04-2004
MICRO-FILM INFORMATION		RECORDED BY		J.M.A.		J.M.A.		
DATE		DATE		DATE		DATE		
1/1/05		1/1/05		1/1/05		1/1/05		

JMA
 2002.050.4


CITY OF ALBUQUERQUE
 PUBLIC WORKS DEPARTMENT
 ENGINEERING DEVELOPMENT GROUP

TITLE: OCOTILLO SUBDIVISION
 PAVING AND STORM DRAINAGE SECTIONS AND DETAILS


Design Review Committee	City Engineer Approval	City Project No.	Zone Map No.	Sheet	Of
		729181	C-21	7	25

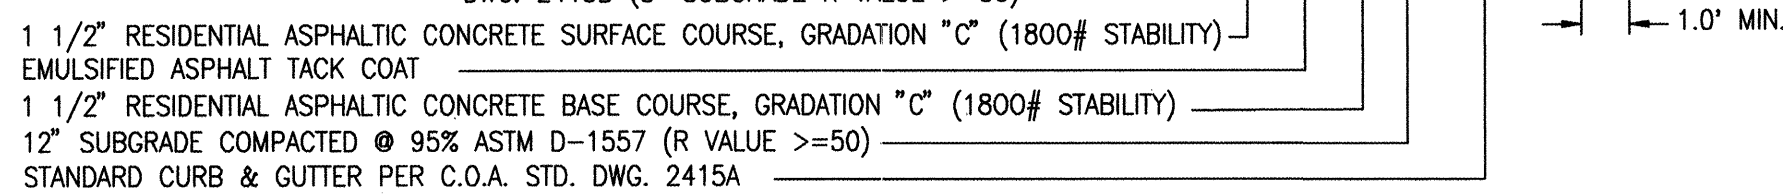


SCALE: 1" = 4'

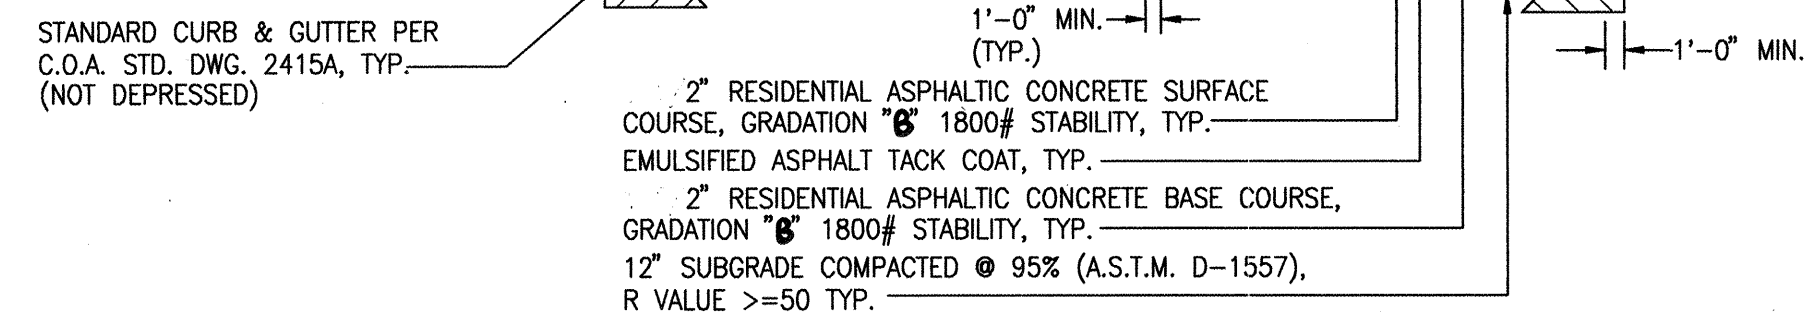


SCALE: 1" = 10' HORIZONTAL
1" = 6' VERTICAL

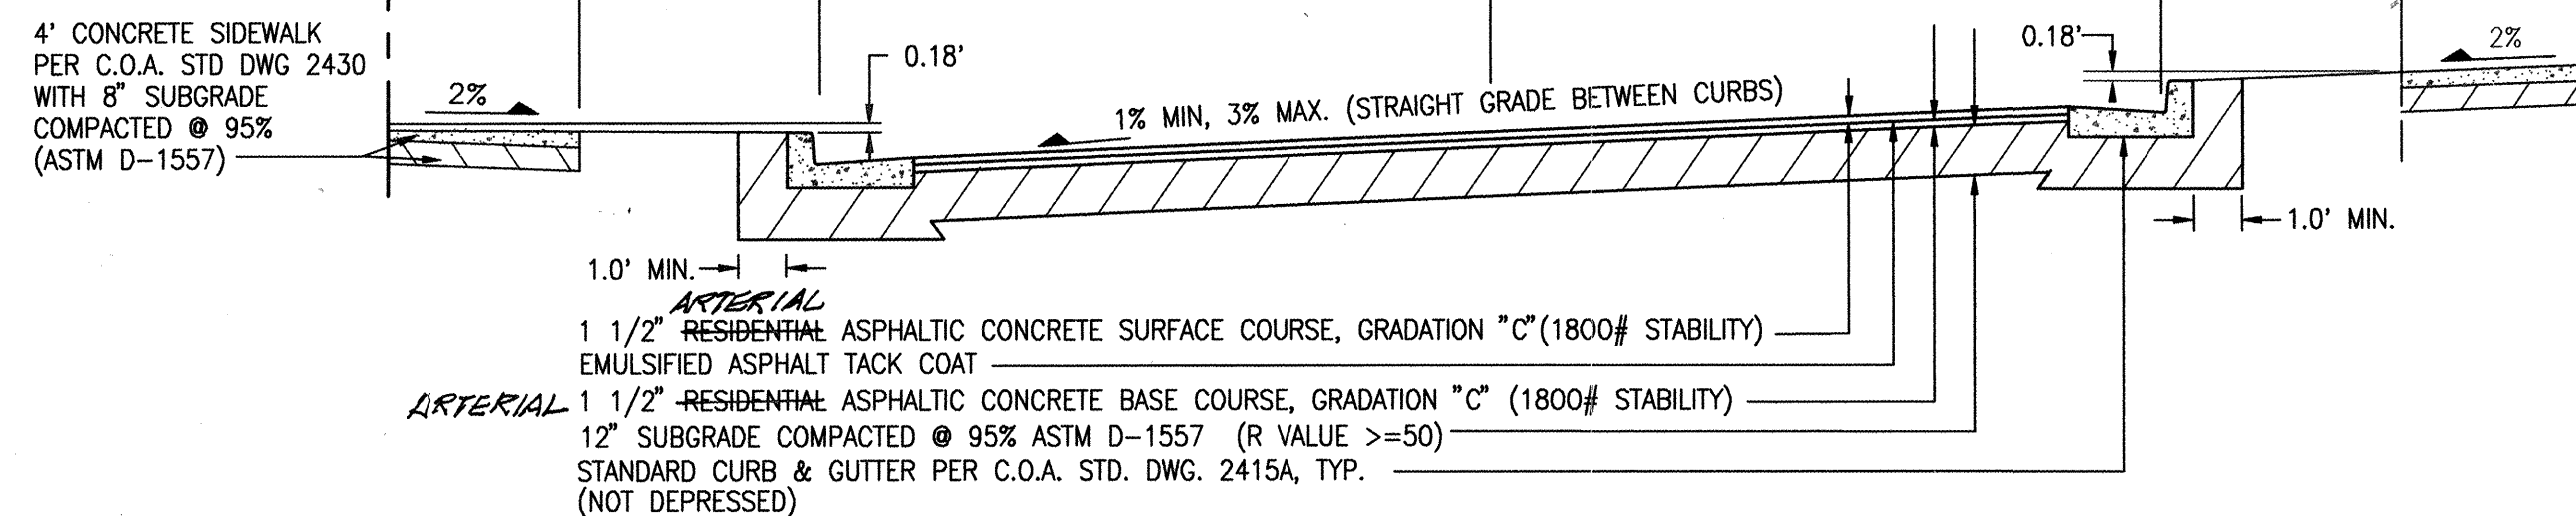


SCALE: 1" = 4'

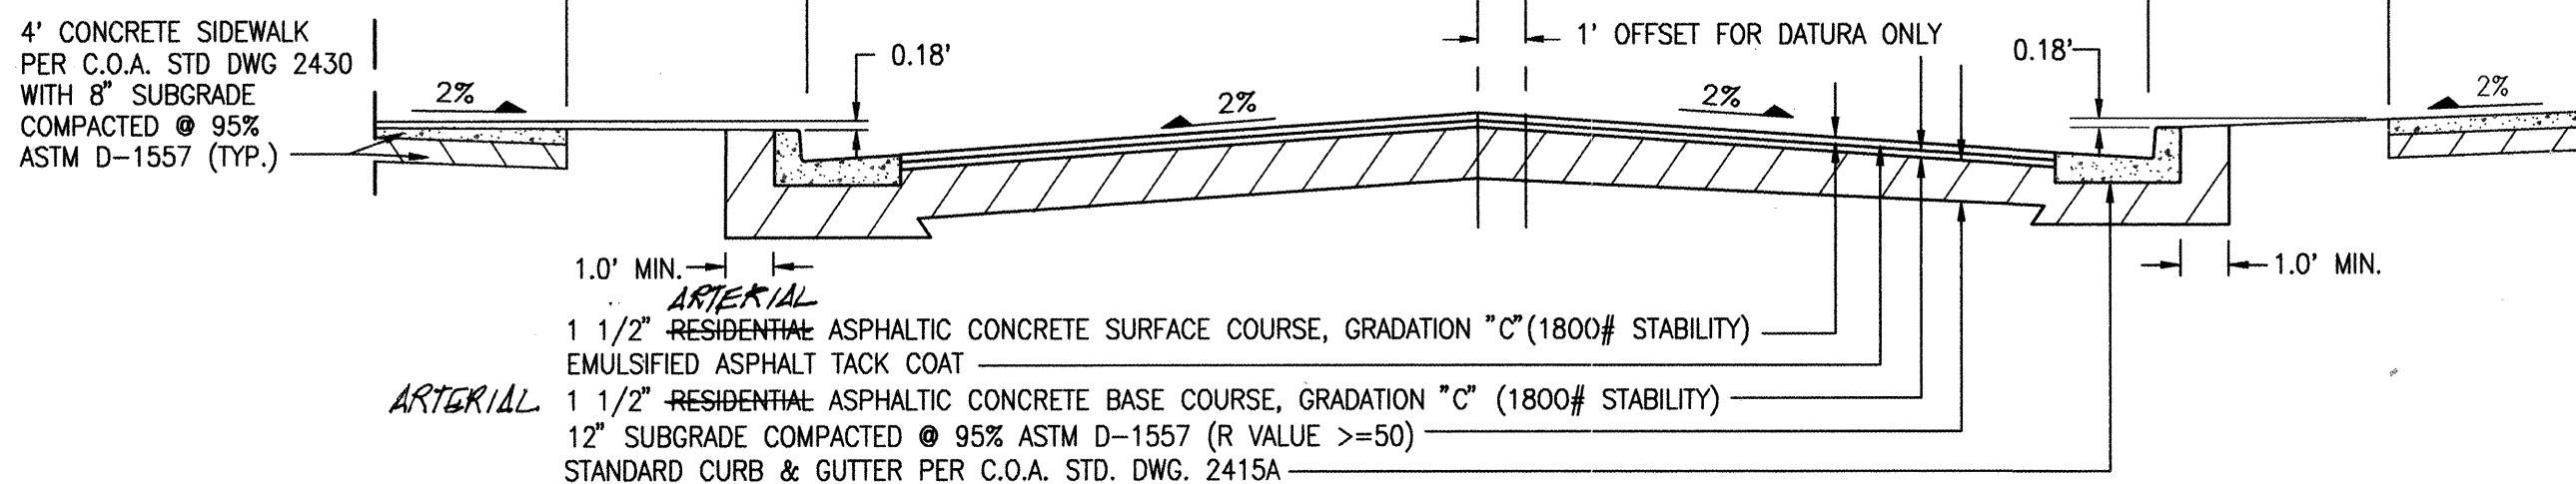


SCALE: 1" = 4'

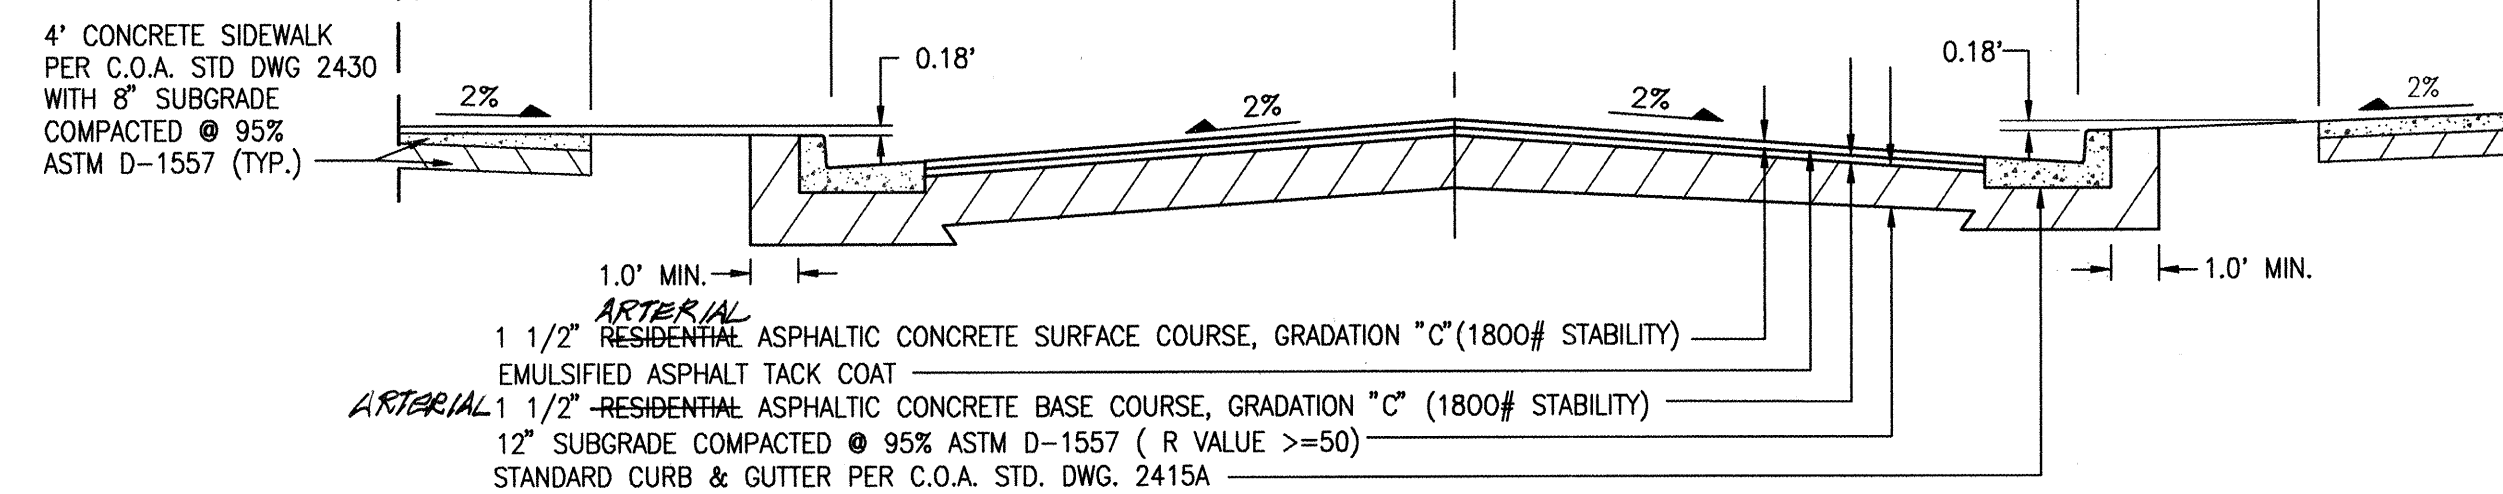


SCALE: 1" = 4'

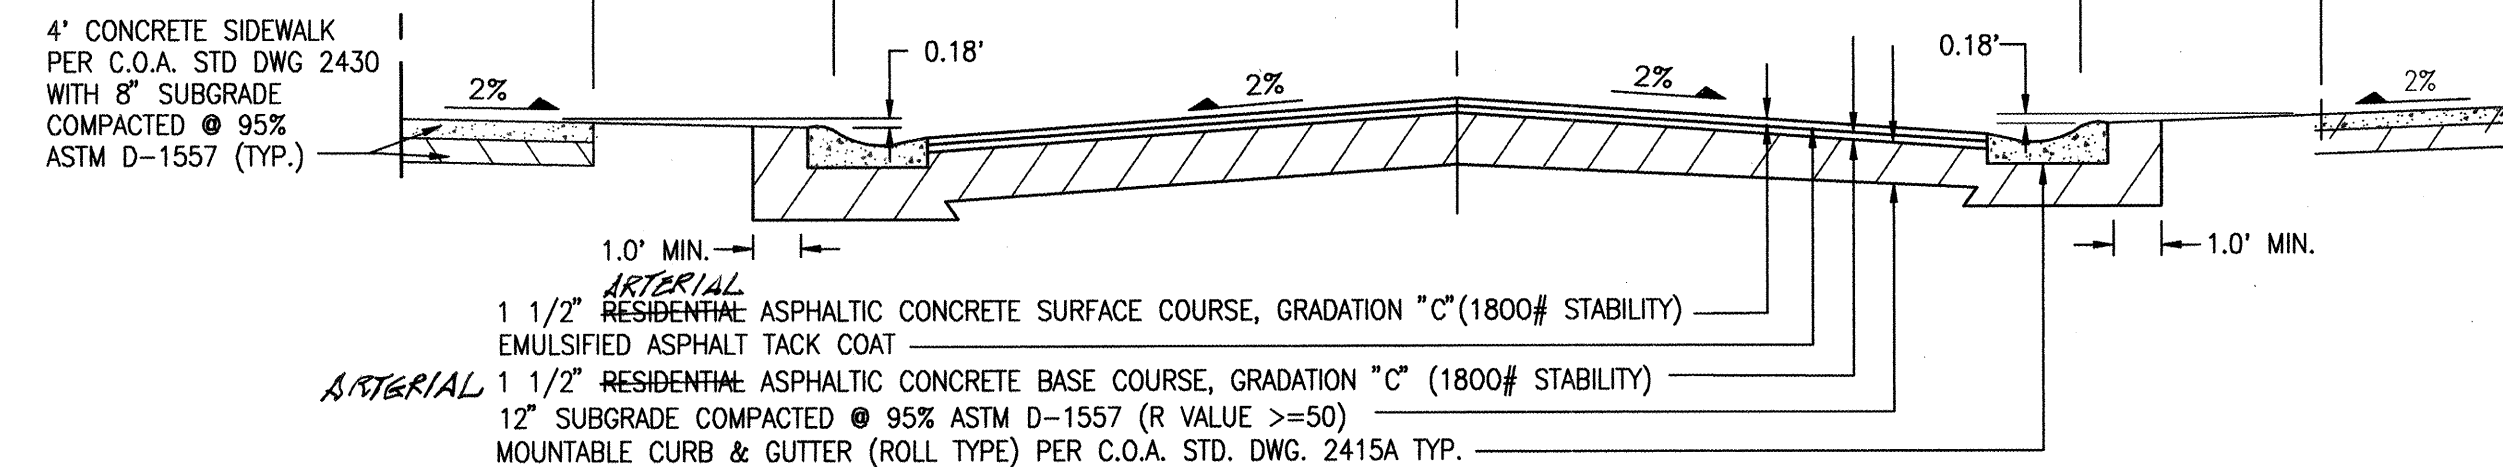

SCALE: 1" = 4'

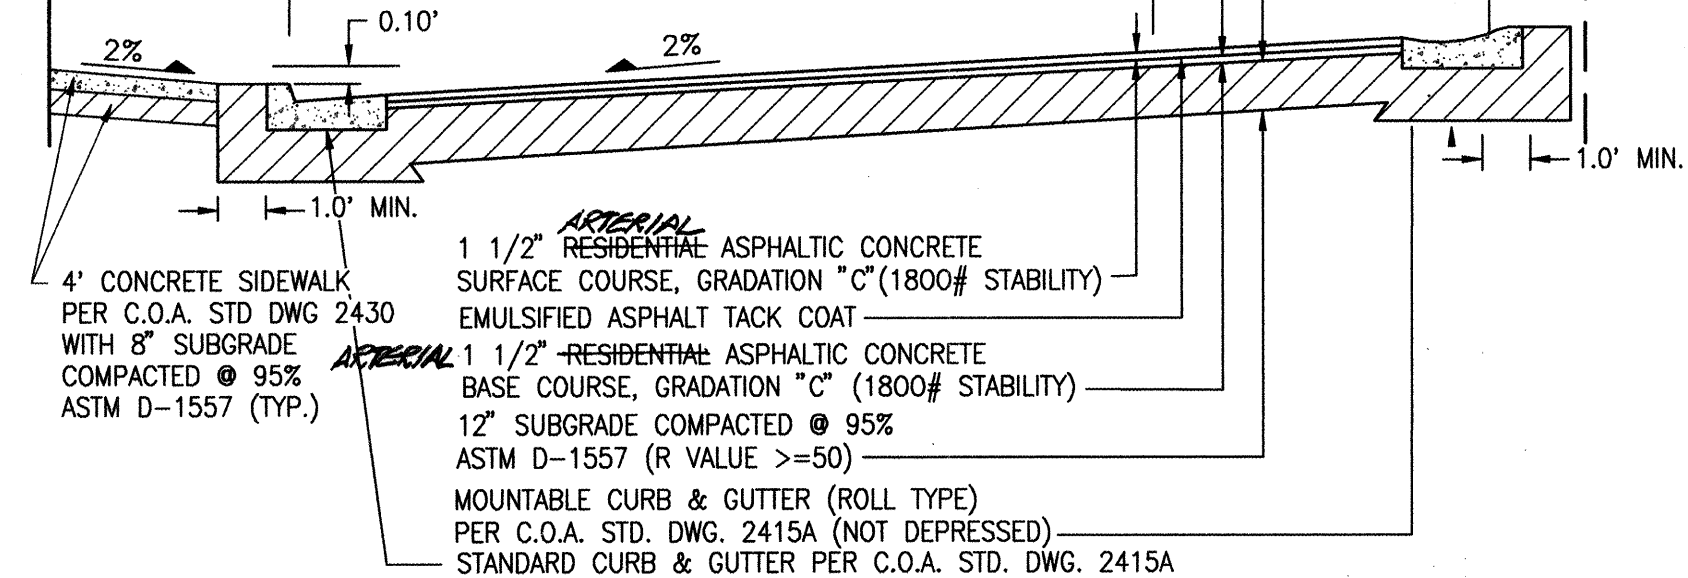

SCALE: 1" = 4'

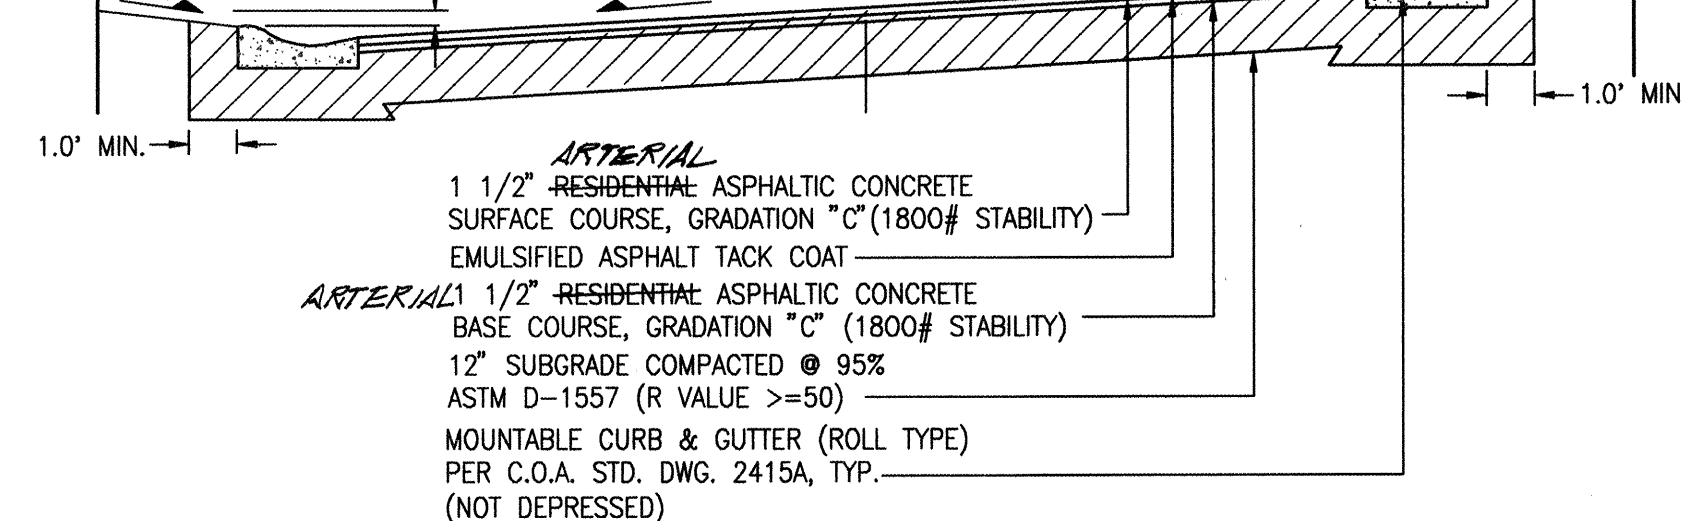

SCALE: 1" = 4'

RECORD DRAWING

[illegible]




Jma
2002.050.4.8

CITY OF ALBUQUERQUE
PUBLIC WORKS DEPARTMENT
ENGINEERING DEVELOPMENT GROUP



TITLE: OCOTILLO SUBDIVISION
STREET PAVING SECTIONS

Design Review Committee	City Engineer Approval	Last Design Update	Mo./Day/Yr.	Mo./Day/Yr.
City Project No.	Zone Map No.	Sheet	Of	
729181	C-21	8	25	

   

LEGEND	
	NEW PERMANENT ASPHALT PAVEMENT
	NEW TEMPORARY ASPHALT PAVEMENT
	NEW CONCRETE
	NEW MOUNTABLE (4") CURB AND GUTTER
	NEW STANDARD (8") CURB AND GUTTER

SEE SHEETS 2-4 FOR KEYS PLATTING NOTES

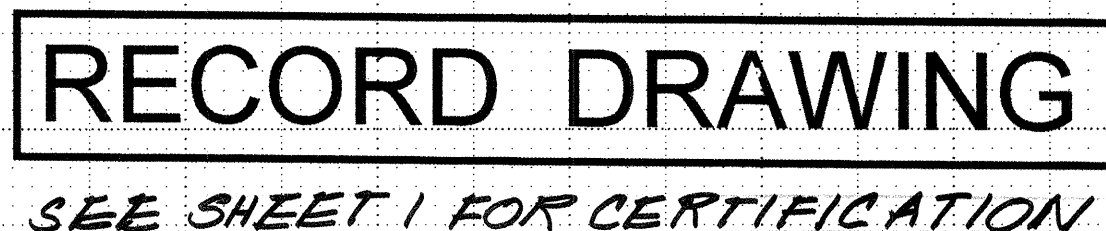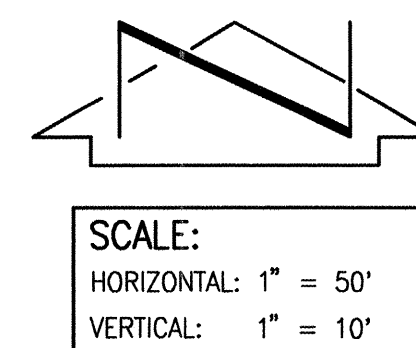

CURVE	RADIUS	LENGTH	DELTA
①	15.00'	13.91'	53°07'48"
②	15.00'	13.91'	53°07'48"
③	30.00'	149.89'	286°15'37"



2002.05048

JEFF MORTENSEN & ASSOCIATES, INC.
☐ 6010-B MIDWAY PARK BLVD. NE.
☐ ALBUQUERQUE ☐ NEW MEXICO 87109
☐ ENGINEERS ☐ SURVEYORS (505) 345-4250
☐ FAX: 505 345-4254 ☐ ESTABLISHED 1977

CITY OF ALBUQUERQUE
PUBLIC WORKS DEPARTMENT
ENGINEERING DEVELOPMENT GROUP

TITLE: OCOTILLO SUBDIVISION
PAVING AND STORM DRAINAGE IMPROVEMENTS PLAN AND PROFILE
CARMEL AVENUE N.E.

Design Review Committee 	City Engineer Approval 	Last Design Update 	Mo./Day/Yr.	Mo./Day/Yr.

City Project No.	729181	Zone Map No.	C-21	Sheet	9	Of	25
------------------	--------	--------------	------	-------	---	----	----

STREET PAVING IMPROVEMENTS

1. ALL SLOPES AS SHOWN ON PROFILES ARE BASED ON STREET CENTERLINE STATIONING EXCEPT CUL-DE-SACS AND EYEBROWS WHERE STATIONING IS ALONG FACE-OF-CURB.
2. WHERE REMOVAL OF EXISTING CURB AND GUTTER, SIDEWALK OR PAVEMENT IS REQUIRED, THE CONTRACTOR SHALL SAWCUT AND/OR REMOVE TO THE NEAREST JOINT. CURB AND GUTTER AND SIDEWALK SHOWN AS EXISTING AND NOT TO BE REMOVED UNDER THIS CONTRACT WHICH IS DAMAGED OR DISPLACED BY THE CONTRACTOR SHALL BE REMOVED AND REPLACED BY THE CONTRACTOR PER C.O.A. STD. DWGS 2415A AND 2430, RESPECTIVELY, AT THE CONTRACTOR'S EXPENSE.
3. ALL DIMENSIONS OF CURB AND CURB RETURNS ARE SHOWN TO FACE-OF-CURB.
4. SIDEWALKS SHOWN HEREON AS "DEFERRED" SHALL BE CONSTRUCTED UNDER SEPARATE PERMIT.
5. ALL WHEELCHAIR RAMPS MUST BE CONSTRUCTED UNDER THIS WORK ORDER.
6. ALL CURB AND GUTTER SHOWN HEREON SHALL BE CONSTRUCTED IN ACCORDANCE WITH CITY OF ALBUQUERQUE STANDARD DRAWING 2415A UNLESS OTHERWISE NOTED.
7. UPON COMPLETION OF CONSTRUCTION, THE CITY OF ALBUQUERQUE WILL PROVIDE AND INSTALL ALL PUBLIC STREET SIGNS.
8. STRIPING BY CONTRACTOR WILL BE REQUIRED PRIOR TO FINAL ACCEPTANCE.

STORM DRAIN NOTES:

1. ALL STORM DRAIN TO BE CLASS II REINFORCED CONCRETE PIPE (RCP) UNLESS OTHERWISE NOTED.
2. ALL MANHOLES SHALL BE 6' DIAMETER TYPE 'C' PER C.O. STANDARD DRAWING 2101 UNLESS OTHERWISE NOTED.
3. ALL STATIONING SHOWN HEREON IS BASED ON STREET CENTERLINE UNLESS OTHERWISE NOTED. SLOPES ARE BASED ON TRUE LENGTH OF PIPE.
4. THE CONTRACTOR SHALL BE RESPONSIBLE FOR SELECTING APPROPRIATE MEANS AND METHODS TO EXCAVATE AND TRENCH AND INSTALL PIPE SO AS TO NOT EXCEED RIGHT-OF-WAY OR EASEMENT LIMITS, AND SO AS NOT TO INTERFERE WITH OTHER UTILITIES. THIS SHALL BE CONSIDERED INCIDENTAL TO TRENCHING, THEREFORE, NO SEPARATE PAYMENT WILL BE MADE.
5. THE CONTRACTOR SHALL BE RESPONSIBLE FOR PROTECTING SURFACING AND ALL OTHER UTILITIES ENCOUNTERED DURING CONSTRUCTION. THIS SHALL BE CONSIDERED INCIDENTAL TO TRENCHING, THEREFORE, NO SEPARATE PAYMENT WILL BE MADE.
6. FOR STORM DRAIN CONSTRUCTION, RCP PIPE JOINTS SHALL NOT BE GROUTED PRIOR TO FINAL INSPECTION. FINAL INSPECTION WILL DETERMINE JOINTS TO BE GROUTED FOR FINAL ACCEPTANCE OF THE CONSTRUCTION.


SURVEY INFORMATION			BENCH MARKS		AS BUILT INFORMATION		
NO.	BY	DATE	PROJECT BENCHMARK	PREVIOUS ELEVATION	CONTRACTOR	WORK STAGED BY	
20502	JMA	03/03	WAY CONSTRUCTION IN 1989	PREVIOUS ELEVATION = 5378.79 FEET (NGD 1929).	CCM	DATE 10/14/2004 2004	
			THIS BENCHMARK HAS BEEN USED TO PROVIDE UNIFORMITY BETWEEN THIS SURVEY			DATE 10/14	
			AND THE PREVIOUS SURVEYS CONDUCTED FOR RELATED NORTH DOMINGO BACA			DATE 12/10/9	
			ARROW POINTS. THE ELEVATION FOR ACS STATION "5-C207" AN ACS 1 3/4"			DATE 10/5	
			ALUMINUM DISK STAMPED "ACS BM, 5-C207, EXPOSED TO THE TOP OF THE CONCRETE				
			SECTION OF VENTURA STREET AND ANHEIM AVENUE N.E., BASED UPON THIS DATUM				
			IS 5552.84 FEET (NGD 1929). THE C.O.A. PUBLISHED ELEV. IS 5552.71" (NGD 1929)				

ENGINEER'S SEAL


 04/21/2004

	10/04	RECORD DRAWING	JMA
NO.	DATE	REMARKS	BY
Revisions			
DESIGN			
Designed By	G.M.	Date	01-2004
Drawn By	S.G.H.	Date	01-2004
Checked By	G.M.	Date	04-2004

File Path:	E:\DATA\AC01014\200504\	Plot Date:	04-20-2004
File Name:	20504P1.DWG	Plot Time:	3:32 pm

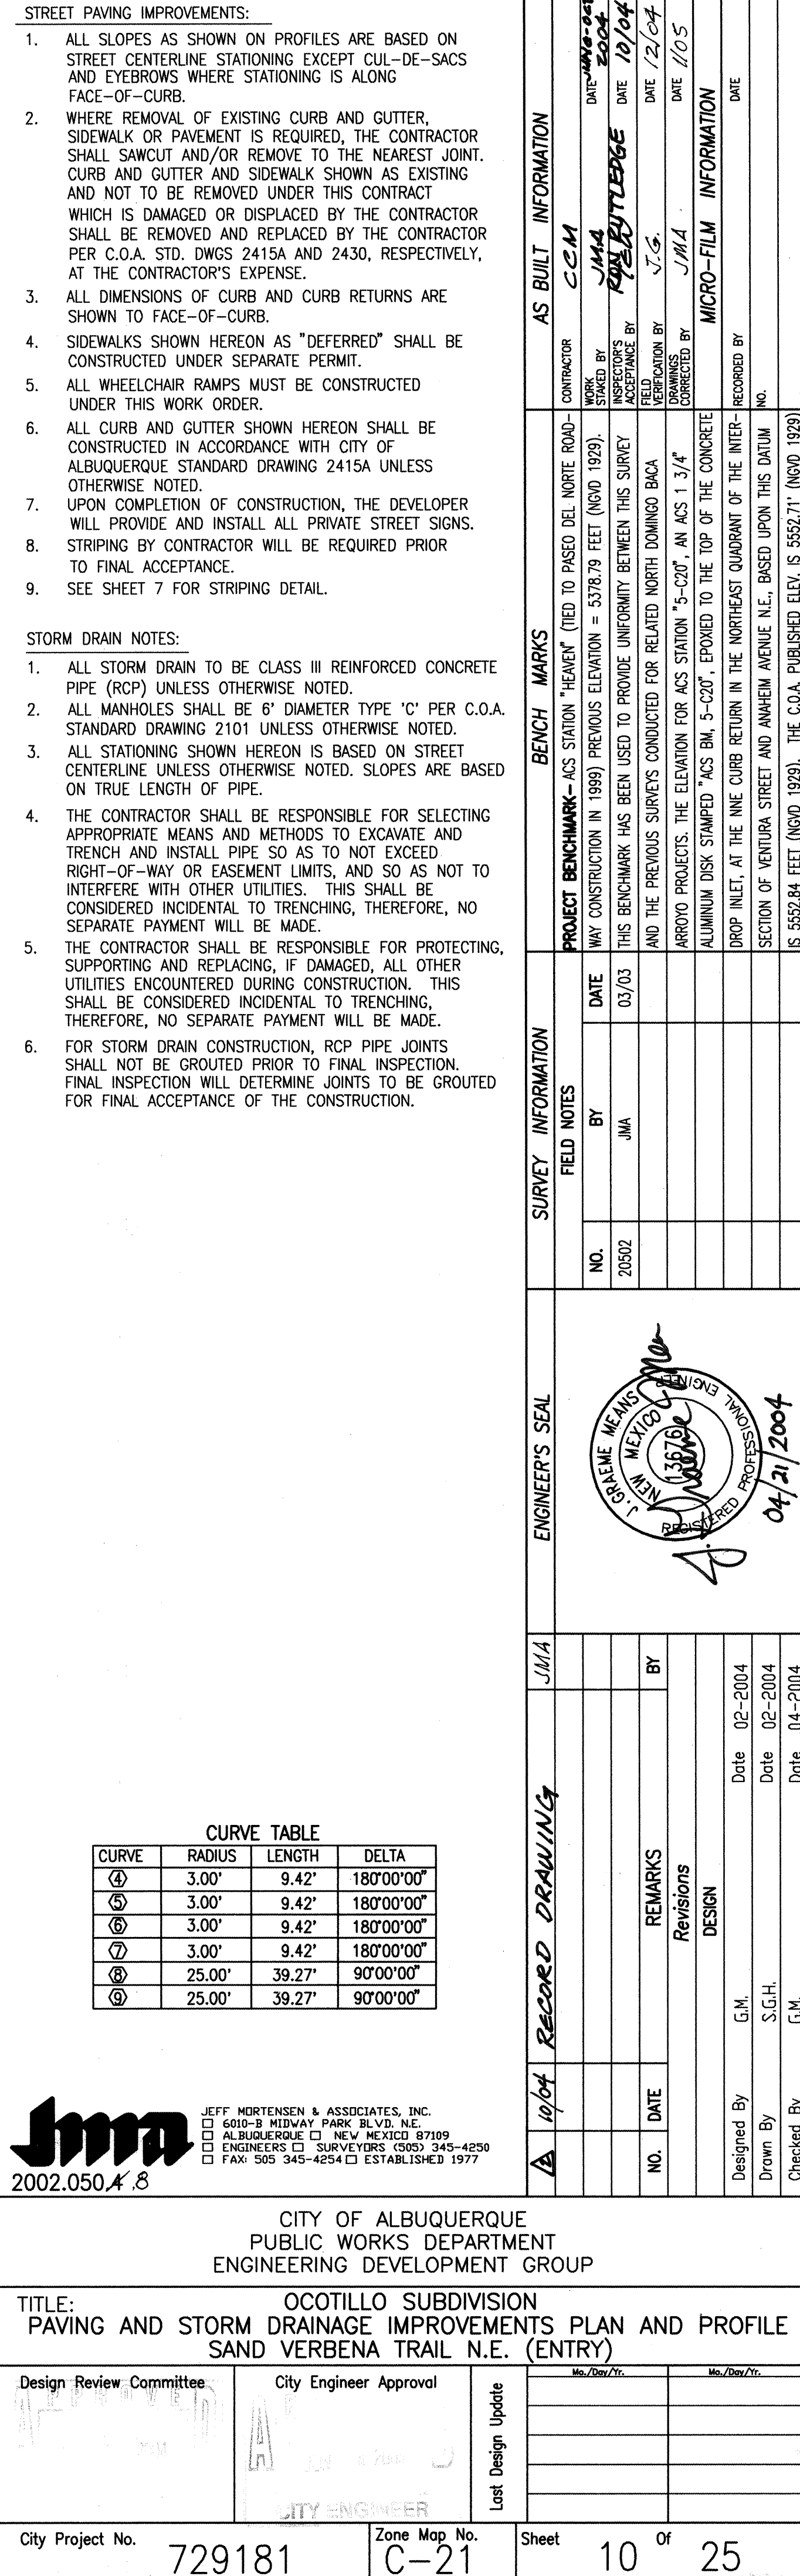

COPIED BY
MEGA REPRO

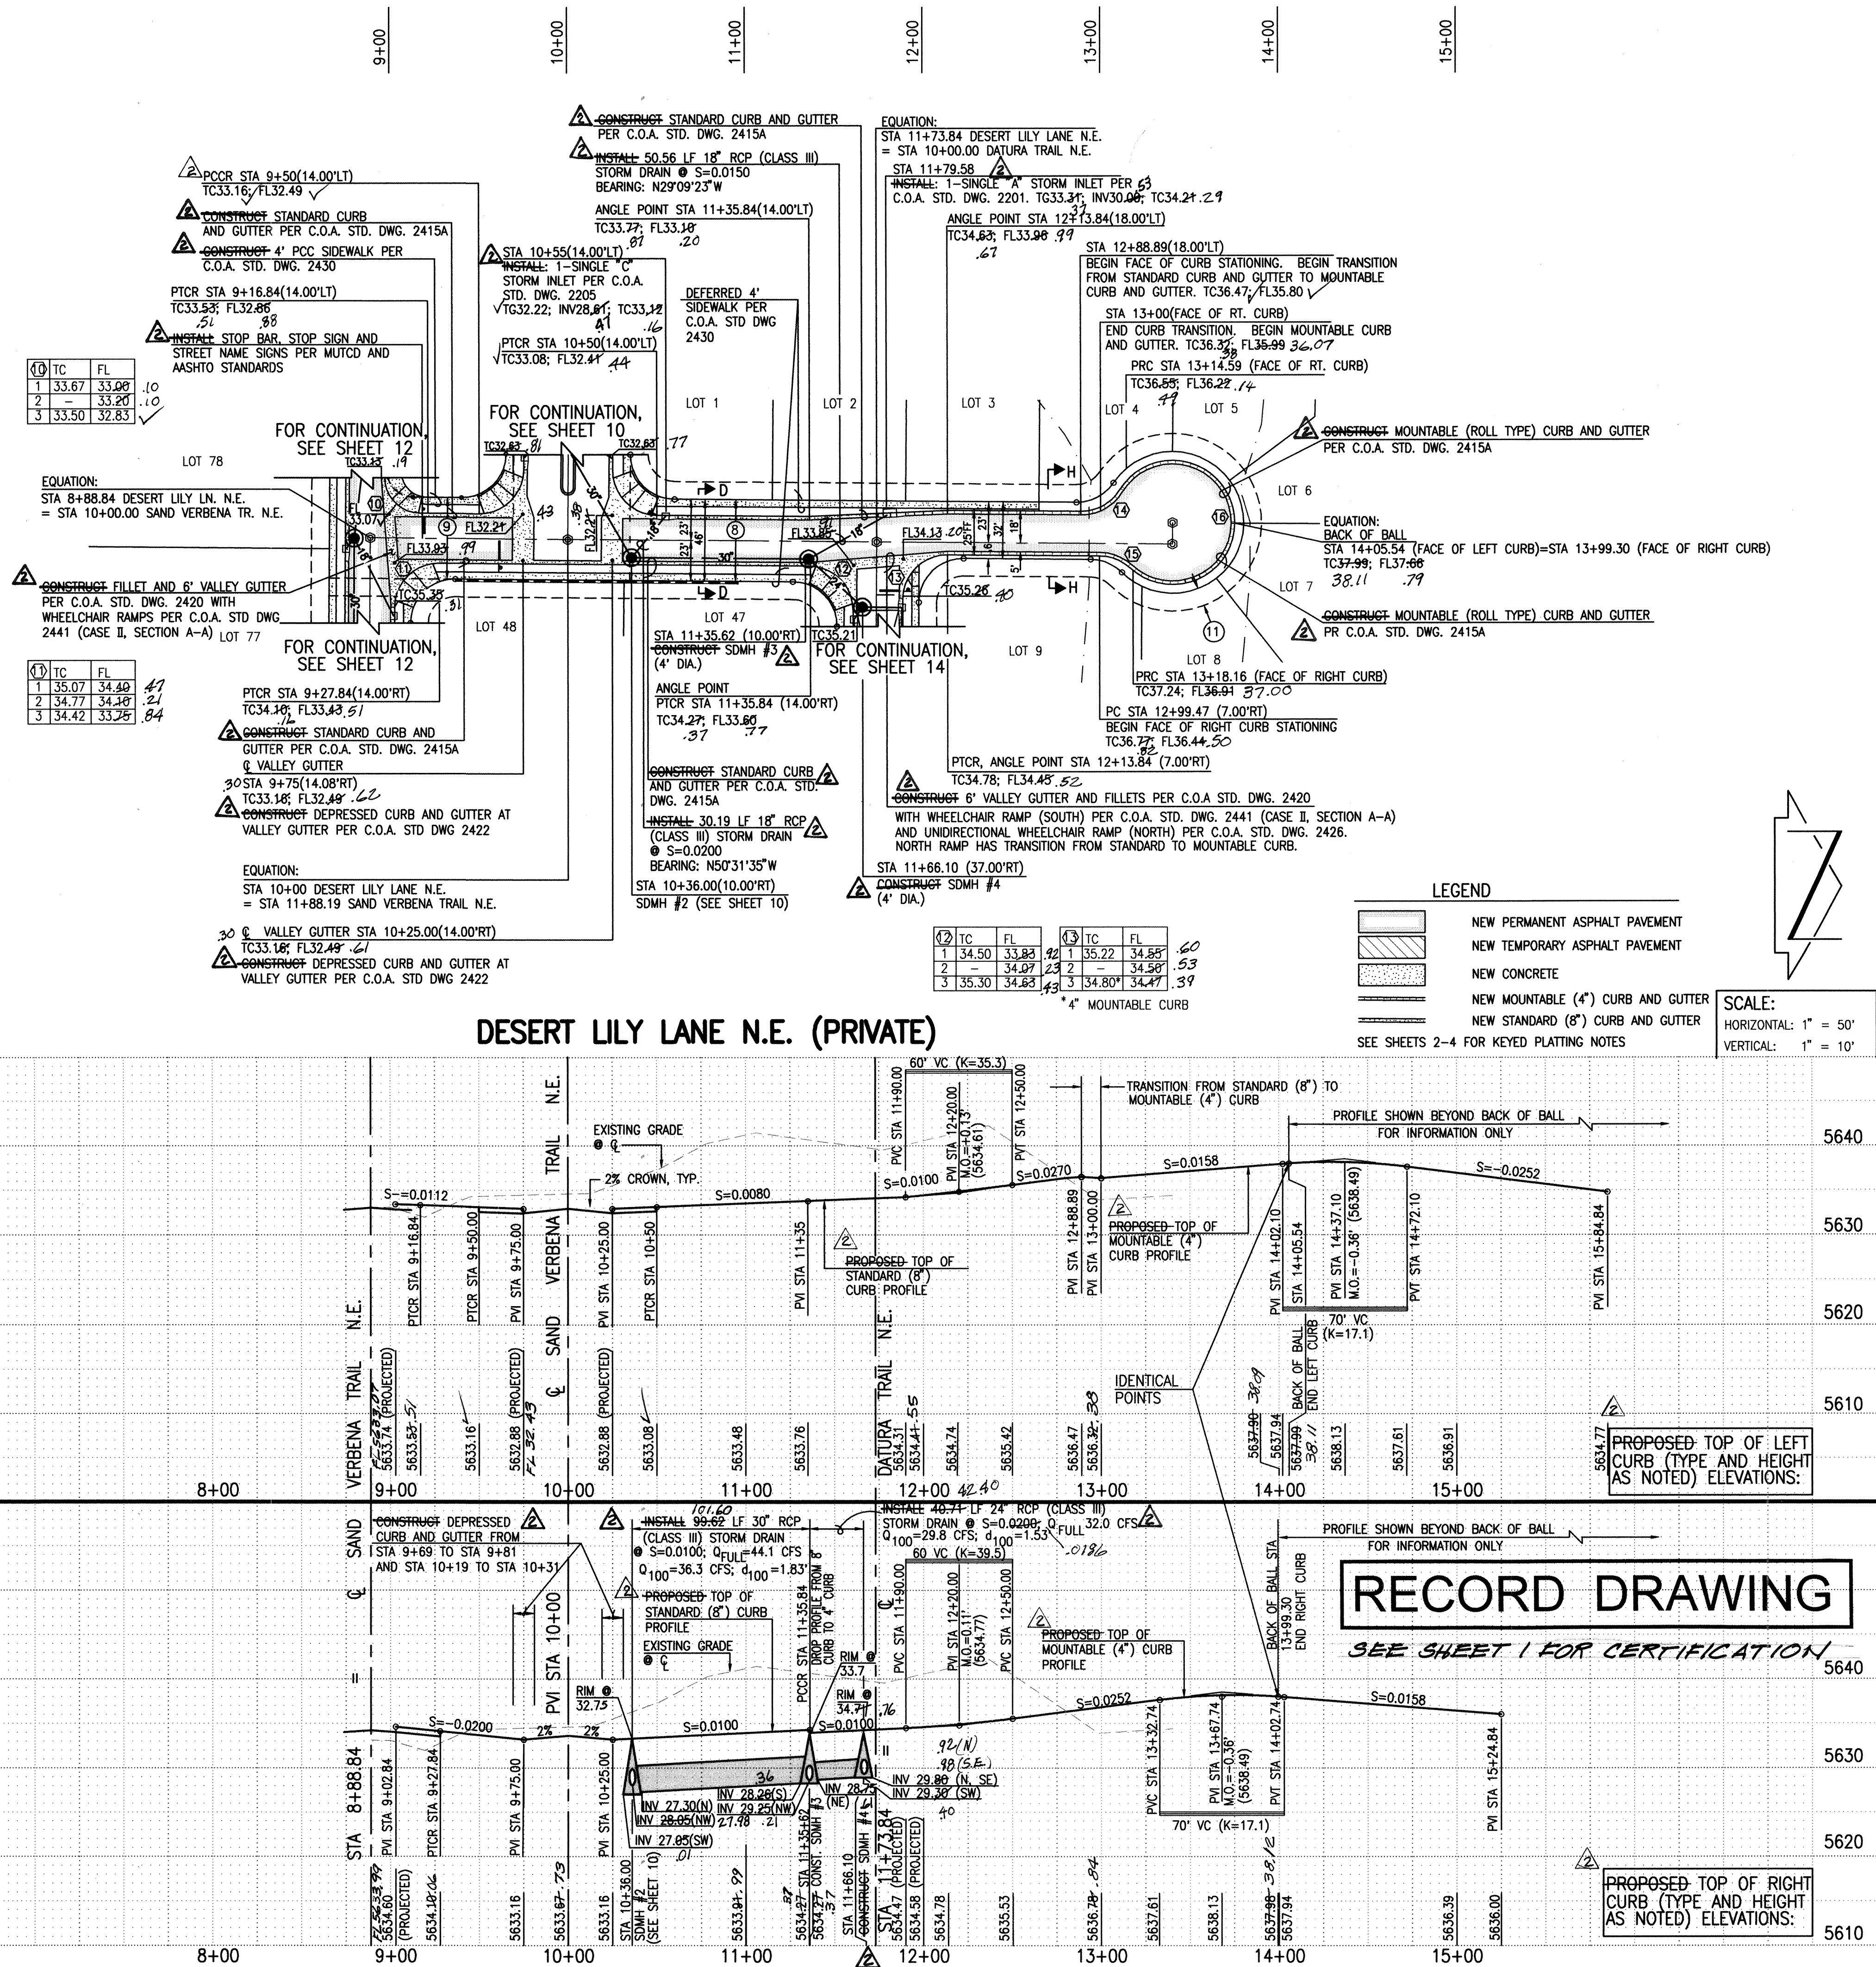

- STREET PAVING IMPROVEMENTS:
1. ALL SLOPES AS SHOWN ON PROFILES ARE BASED ON STREET CENTERLINE STATIONING EXCEPT CUL-DE-SACS AND EYEBROWS WHERE STATIONING IS ALONG FACE-OF-CURB.
 2. WHERE REMOVAL OF EXISTING CURB AND GUTTER, SIDEWALK OR PAVEMENT IS REQUIRED, THE CONTRACTOR SHALL SAWCUT AND/OR REMOVE TO THE NEAREST JOINT. CURB AND GUTTER AND SIDEWALK SHOWN AS EXISTING AND NOT TO BE REMOVED UNDER THIS CONTRACT WHICH IS DAMAGED OR DISPLACED BY THE CONTRACTOR SHALL BE REMOVED AND REPLACED BY THE CONTRACTOR PER C.O.A. STD. DWGS 2415A AND 2430, RESPECTIVELY, AT THE CONTRACTOR'S EXPENSE.
 3. ALL DIMENSIONS OF CURB AND CURB RETURNS ARE SHOWN TO FACE-OF-CURB.
 4. SIDEWALKS SHOWN HEREON AS "DEFERRED" SHALL BE CONSTRUCTED UNDER SEPARATE PERMIT.
 5. ALL WHEELCHAIR RAMPS MUST BE CONSTRUCTED UNDER THIS WORK ORDER.
 6. ALL CURB AND GUTTER SHOWN HEREON SHALL BE CONSTRUCTED IN ACCORDANCE WITH CITY OF ALBUQUERQUE STANDARD DRAWING 2415A UNLESS OTHERWISE NOTED.
 7. UPON COMPLETION OF CONSTRUCTION, THE DEVELOPER WILL PROVIDE AND INSTALL ALL PRIVATE STREET SIGNS.
 8. STRIPING BY CONTRACTOR WILL BE REQUIRED PRIOR TO FINAL ACCEPTANCE.
- STORM DRAIN NOTES:
1. ALL STORM DRAIN TO BE CLASS III REINFORCED CONCRETE PIPE (RCP) UNLESS OTHERWISE NOTED.
 2. ALL MANHOLES SHALL BE 6' DIAMETER TYPE 'C' PER C.O.A. STANDARD DRAWING 2101 UNLESS OTHERWISE NOTED.
 3. ALL STATIONING SHOWN HEREON IS BASED ON STREET CENTERLINE UNLESS OTHERWISE NOTED. SLOPES ARE BASED ON TRUE LENGTH OF PIPE.
 4. THE CONTRACTOR SHALL BE RESPONSIBLE FOR SELECTING APPROPRIATE MEANS AND METHODS TO EXCAVATE AND TRENCH AND INSTALL PIPE SO AS TO NOT EXCEED RIGHT-OF-WAY OR EASEMENT LIMITS, AND SO AS NOT TO INTERFERE WITH OTHER UTILITIES. THIS SHALL BE CONSIDERED INCIDENTAL TO TRENCHING, THEREFORE, NO SEPARATE PAYMENT WILL BE MADE.
 5. THE CONTRACTOR SHALL BE RESPONSIBLE FOR PROTECTING, SUPPORTING AND REPLACING, IF DAMAGED, ALL OTHER UTILITIES ENCOUNTERED DURING CONSTRUCTION. THIS SHALL BE CONSIDERED INCIDENTAL TO TRENCHING, THEREFORE, NO SEPARATE PAYMENT WILL BE MADE.
 6. FOR STORM DRAIN CONSTRUCTION, RCP PIPE JOINTS SHALL NOT BE GROUDED PRIOR TO FINAL INSPECTION. FINAL INSPECTION WILL DETERMINE JOINTS TO BE GROUDED FOR FINAL ACCEPTANCE OF THE CONSTRUCTION.

CURVE TABLE			
CURVE	RADIUS	LENGTH	DELTA
(10)	20.00'	31.42'	90°00'00"
(11)	25.00'	39.27'	90°00'00"
(12)	25.00'	39.27'	90°00'00"
(13)	25.00'	39.27'	90°00'00"
(14)	25.00'	25.70'	58°53'28"
(15)	25.00'	18.69'	42°50'00"
(16)	35.00'	172.10'	281°43'28"

Jim
2002.0504.8
JEFF MORTENSEN & ASSOCIATES, INC.
600-B MIDWAY PARK BLVD. N.E.
ALBUQUERQUE, N.M. 87109
ENGINEERS & SURVEYORS (505) 345-4250
FAX: 505 345-4254 • ESTABLISHED 1977


CITY OF ALBUQUERQUE
PUBLIC WORKS DEPARTMENT
ENGINEERING DEVELOPMENT GROUP



TITLE: OCOTILLO SUBDIVISION
PAVING AND STORM DRAINAGE IMPROVEMENTS PLAN AND PROFILE
DESERT LILY LANE N.E.

Design Review Committee	City Engineer Approval	Last Design Update

City Project No.	Zone Map No.	Sheet	Of
729181	C-21	11	25

AS BUILT INFORMATION		BENCH MARKS		SURVEY INFORMATION		FIELD NOTES		ENGINEER'S SEAL	
CONTRACTOR	DATE	CONTRACTOR	DATE	NO.	DATE	NO.	DATE	NO.	DATE
CCM	10/01/04	CCM	10/01/04	2002	03/03	2002	03/03	2002	03/03
WORK BY	DATE	WORK BY	DATE	BY	DATE	BY	DATE	BY	DATE
REVISIONS	DATE	REVISIONS	DATE	REVISIONS	DATE	REVISIONS	DATE	REVISIONS	DATE
DESIGNED BY	DATE	DESIGNED BY	DATE	DESIGNED BY	DATE	DESIGNED BY	DATE	DESIGNED BY	DATE
CHECKED BY	DATE	CHECKED BY	DATE	CHECKED BY	DATE	CHECKED BY	DATE	CHECKED BY	DATE
RECORDED BY	DATE	RECORDED BY	DATE	RECORDED BY	DATE	RECORDED BY	DATE	RECORDED BY	DATE
NO.		NO.		NO.		NO.		NO.	

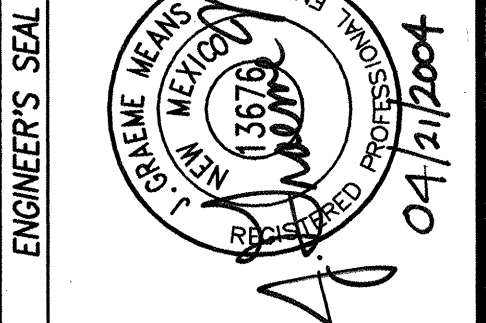

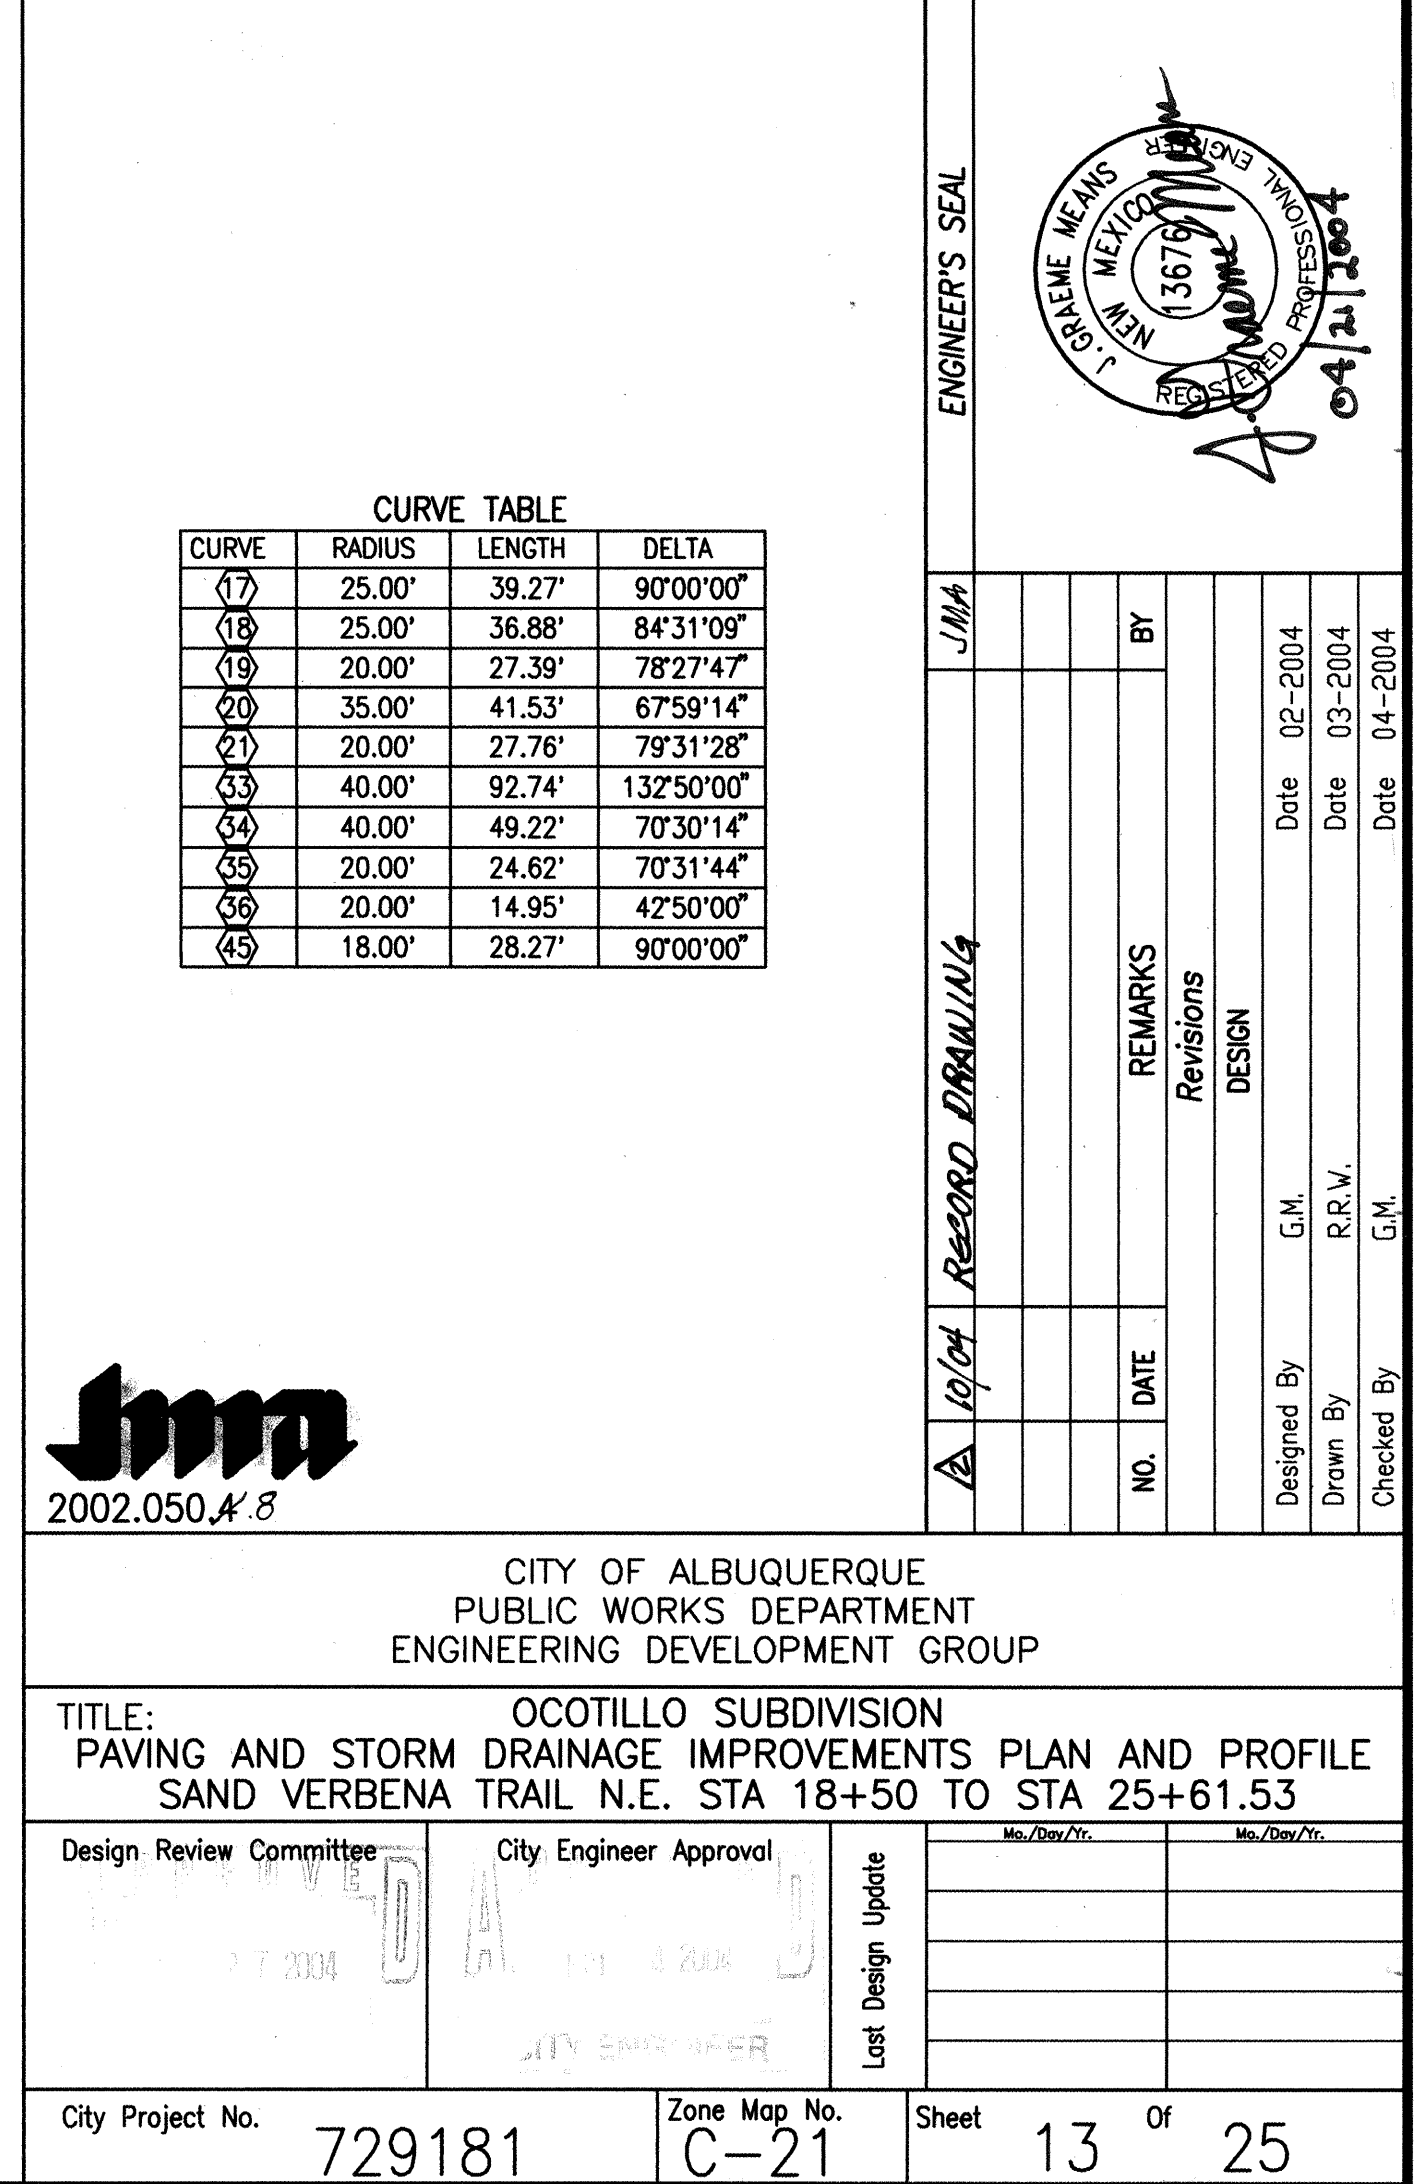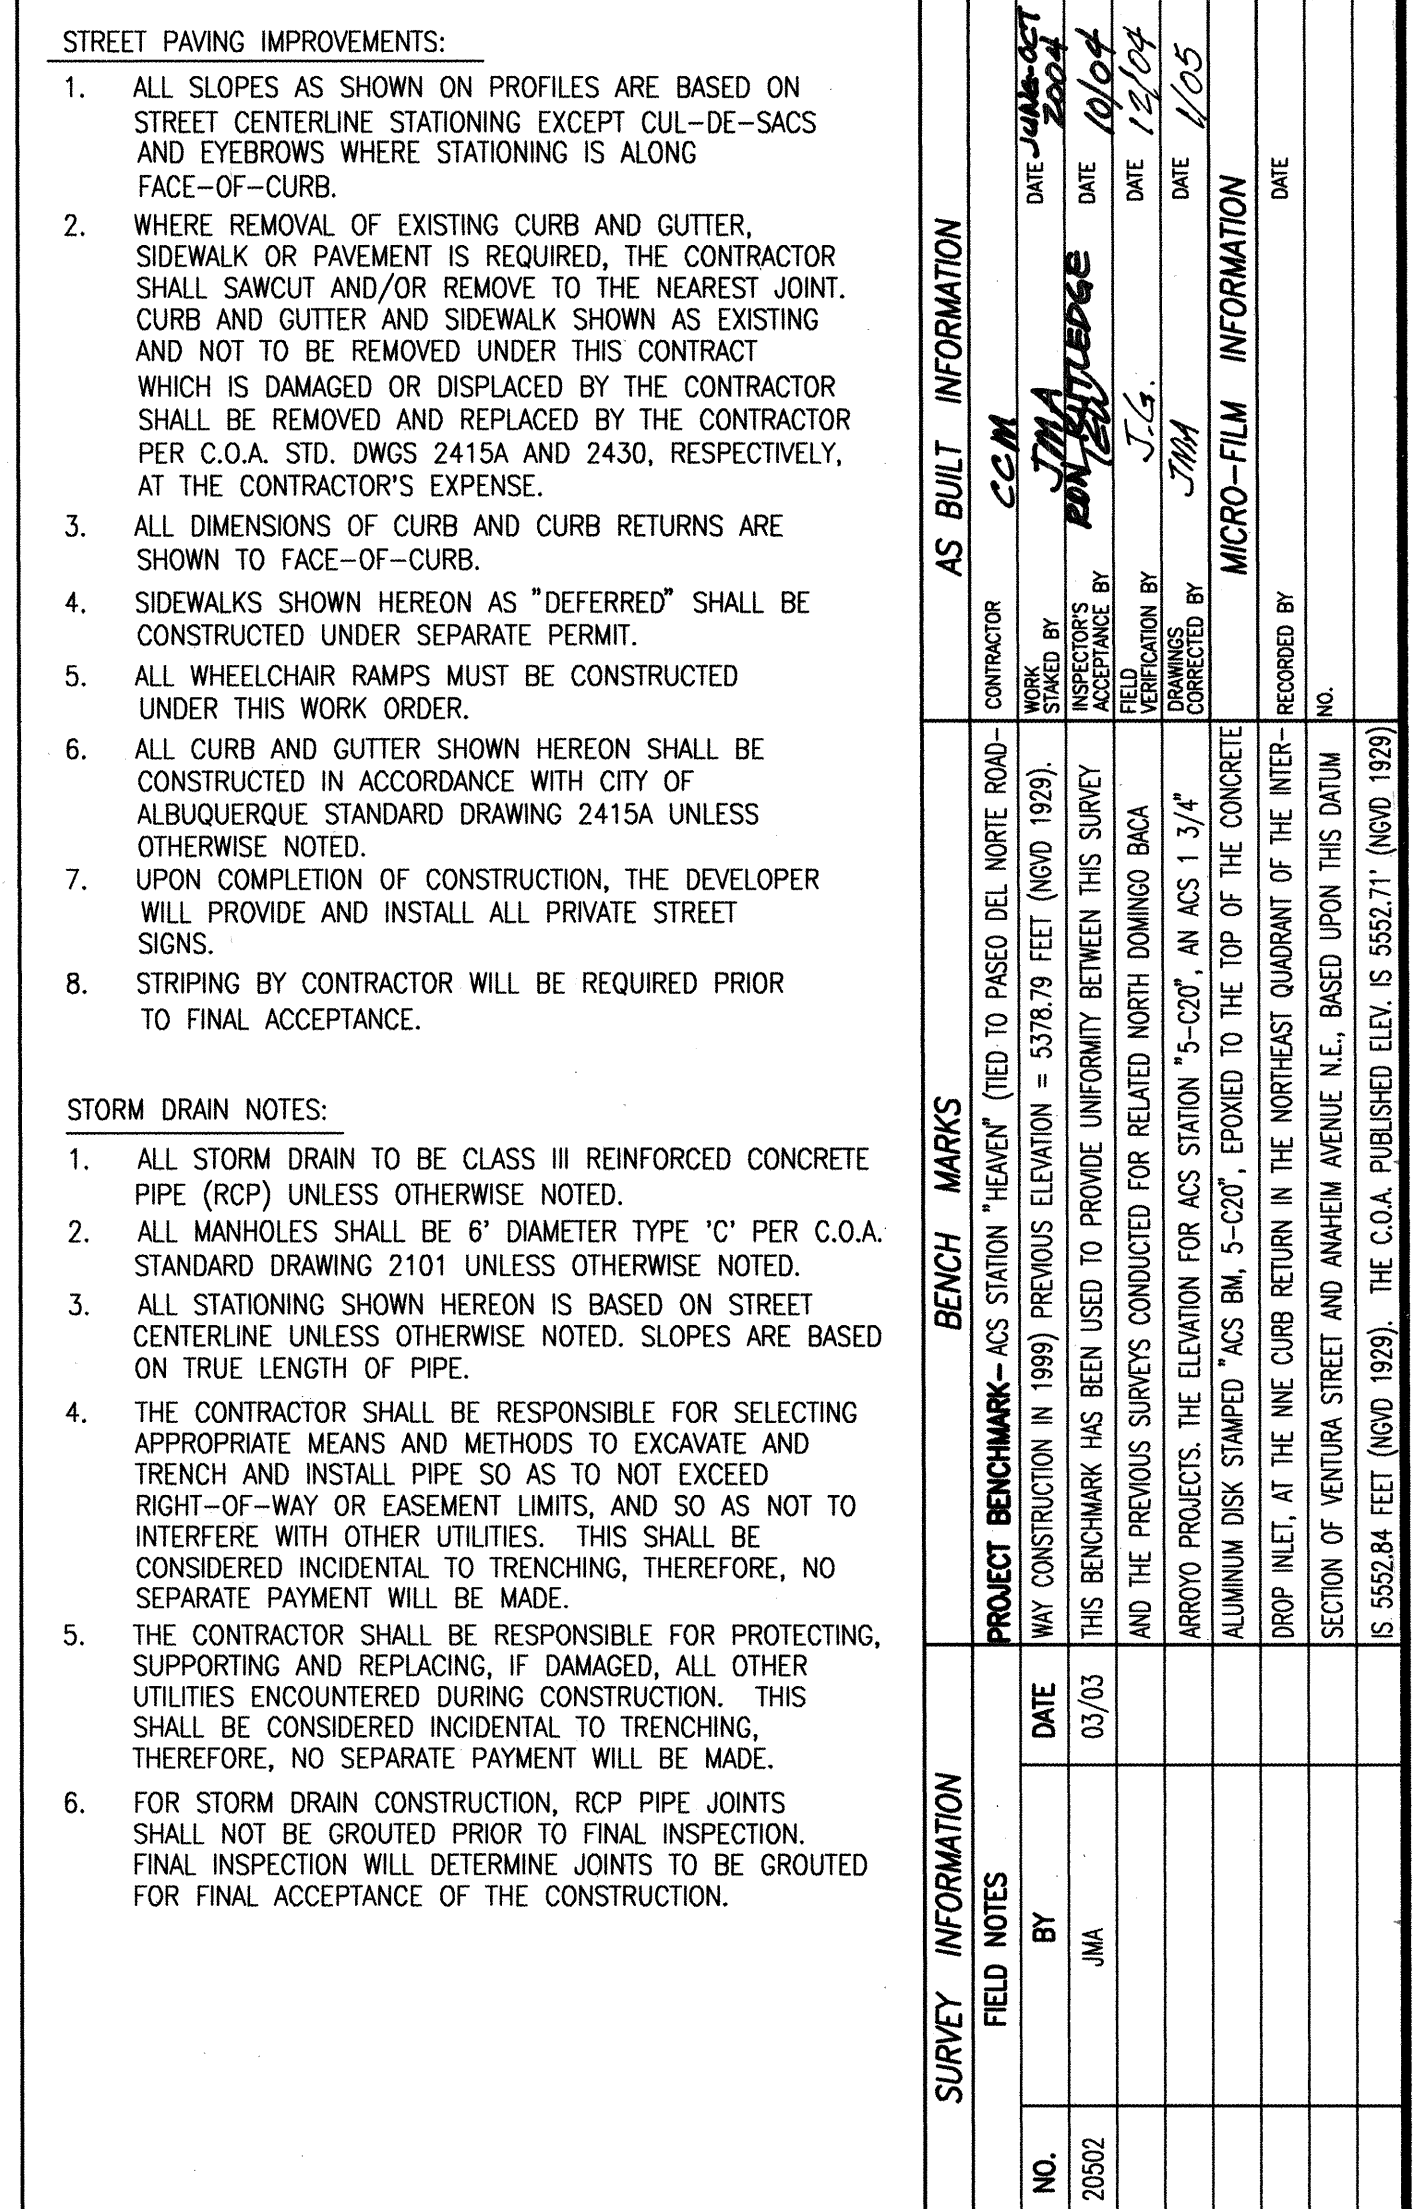


SCANNED BY
VIPA REF NO



SEE SHEET 1 FOR CERTIFICATION

	NEW PERMANENT ASPHALT PAVEMENT
	NEW TEMPORARY ASPHALT PAVEMENT
	NEW CONCRETE
	NEW MOUNTABLE CURB AND GUTTER
	NEW STANDARD CURB AND GUTTER

SEE SHEETS 2-4 FOR KEYED PLATTING NOTES

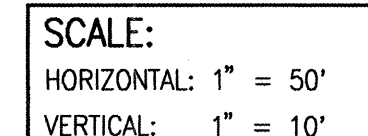

CURVE	RADIUS	LENGTH	DELTA
22	25.00'	39.27'	90°00'00"
23	25.00'	39.27'	90°00'00"
24	25.00'	39.27'	90°00'00"
25	25.00'	39.27'	90°00'00"

JEFF MORTENSEN & ASSOCIATES, INC.
☐ 6010-B MIDWAY PARK BLVD. N.E.
☐ ALBUQUERQUE ☐ NEW MEXICO 87109
☐ ENGINEERS ☐ SURVEYORS (505) 345-4250
☐ FAX: 505 345-4254 ☐ ESTABLISHED 1977

CITY OF ALBUQUERQUE
PUBLIC WORKS DEPARTMENT
ENGINEERING DEVELOPMENT GROUP

TITLE: OCOTILLO SUBDIVISION
PAVING AND STORM DRAINAGE IMPROVEMENTS PLAN AND PROFILE
DATURA TRAIL N.E.

[illegible]

City Project No.	729181	Zone Map No.	C-21	Sheet	14	Of	25
------------------	--------	--------------	------	-------	----	----	----

STREET PAVING IMPROVEMENTS.


1. ALL SLOPES AS SHOWN ON PROFILES ARE BASED ON STREET CENTERLINE STATIONING EXCEPT CUL-DE-SACS AND EYEBROWS WHERE STATIONING IS ALONG FACE-OF-CURB.
2. WHERE REMOVAL OF EXISTING CURB AND GUTTER, SIDEWALK OR PAVEMENT IS REQUIRED, THE CONTRACTOR SHALL SAWCUT AND/OR REMOVE TO THE NEAREST JOINT. CURB AND GUTTERS AND SIDEWALK SHOWN AS EXISTING AND NOT TO BE REMOVED UNDER THIS CONTRACT WHICH IS DAMAGED OR DISPLACED BY THE CONTRACTOR SHALL BE REMOVED AND REPLACED BY THE CONTRACTOR PER C.O.A. STD. DWGS 2415A AND 2430, RESPECTIVELY, AT THE CONTRACTOR'S EXPENSE.
3. ALL DIMENSIONS OF CURB AND CURB RETURNS ARE SHOWN TO FACE-OF-CURB.
4. SIDEWALKS SHOWN HEREON AS "DEFERRED" SHALL BE CONSTRUCTED UNDER SEPARATE PERMIT.
5. ALL WHEELCHAIR RAMPS MUST BE CONSTRUCTED UNDER THIS WORK ORDER.
6. ALL CURB AND GUTTER SHOWN HEREON SHALL BE CONSTRUCTED IN ACCORDANCE WITH CITY OF ALBUQUERQUE STANDARD DRAWING 2415A UNLESS OTHERWISE NOTED.
7. UPON COMPLETION OF CONSTRUCTION, THE DEVELOPER WILL PROVIDE AND INSTALL ALL PRIVATE STREET SIGNS.
8. STRIPING BY CONTRACTOR WILL BE REQUIRED PRIOR TO FINAL ACCEPTANCE.

STORM DRAIN NOTES:

1. ALL STORM DRAIN TO BE CLASS III REINFORCED CONCRETE PIPE (RCP) UNLESS OTHERWISE NOTED.
2. ALL MANHOLES SHALL BE 6' DIAMETER TYPE 'C' PER C.O.A. STANDARD DRAWING 2101 UNLESS OTHERWISE NOTED.
3. ALL STATIONING SHOWN HEREON IS BASED ON STREET CENTERLINE UNLESS OTHERWISE NOTED. SLOPES ARE BASED ON TRUE LENGTH OF PIPE.
4. THE CONTRACTOR SHALL BE RESPONSIBLE FOR SELECTING APPROPRIATE METHODS AND TECHNIQUES TO EXCAVATE AND TRENCH AND INSTALL PIPE SO AS TO NOT EXCEED RIGHT-OF-WAY OR EASEMENT LIMITS, AND SO AS NOT TO INTERFERE WITH OTHER UTILITIES. THIS SHALL BE CONSIDERED INCIDENTAL TO TRENCHING, THEREFORE, NO SEPARATE PAYMENT WILL BE MADE.
5. THE CONTRACTOR SHALL BE RESPONSIBLE FOR PROTECTING, SUPPORTING AND REPLACING, IF DAMAGED, ALL OTHER UTILITIES ENCOUNTERED DURING CONSTRUCTION. THIS SHALL BE CONSIDERED INCIDENTAL TO TRENCHING, THEREFORE, NO SEPARATE PAYMENT WILL BE MADE.
6. FOR STORM DRAIN CONSTRUCTION, RCP PIPE JOINTS SHALL NOT BE GROUTED. FOR SEWER CONSTRUCTION, FINAL INSPECTION WILL DETERMINE JOINTS TO BE GROUTED FOR FINAL ACCEPTANCE OF THE CONSTRUCTION.

SURVEY INFORMATION		FIELD NOTES		PROJECT BENCHMARK - ACS STATION "HEAVEN" (TIED TO PASO DEL NORTE ROAD - BENCH MARK)		AS BUILT INFORMATION	
NO.	BY	DATE				CONTRACTOR	
20362	JMA	03/03		THIS BENCHMARK WAS USED TO PROVIDE UNIFORMITY BETWEEN THIS SURVEY AND THE PREVIOUS SURVEYS CONDUCTED FOR RELATED NORTH DOWNSIDE BACA ARROYO PROJECTS. THE ELEVATION FOR ACS STATION "5-C207," AN ACS 1 3/4" ALUMINUM DISK STAMPED "ACS BM, 5-C207," EXPOSED TO THE TOP OF THE CONCRETE DROP INLET, AT THE NINE CORB RETURN IN THE NORTHEAST QUADRANT OF THE INTER- SECTION OF VENTURA STREET AND ANAHEIM AVENUE N.E., BASED UPON THIS DATUM IS .555084 FEET (NVD 1929). THE C.O.A. PUBLISHED ELEV. IS .555271". (NGVD 1929)		WORK SHOWN BY <i>DRAFTSMAN</i> ACCEPTANCE BY <i>PJG</i> PREPARED BY <i>JLG</i> DRAWINGS CHECKED BY <i>JMA</i>	DATE <i>2004</i> <i>12/04</i> <i>1/05</i>
						MICRO-FILM INFORMATION	
						RECORDED BY	DATE
						NO.	

ENGINEER'S SEAL

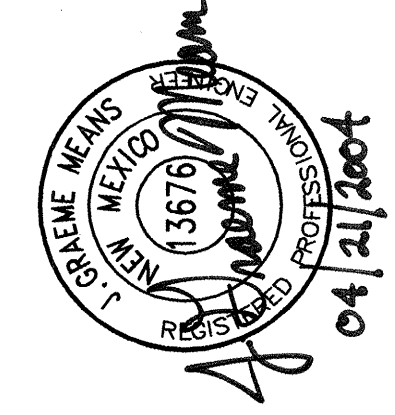

BY		REMARKS		DESIGN	
		Revisions			
NO.	DATE	Designed By	G.M.	Date	02-2004
		Drawn By	S.G.H.	Date	02-2004
		Checked By	G.M.	Date	04-2004

②	12/04	RECORD DRAWING
---	-------	----------------

DESERT ASTER LANE N.E. (PRIVATE)

DESERT POPPY LANE N.E. (PRIVATE)

DESERT PLUME LANE N.E. (PRIVATE)

RECORD DRAWING

SEE SHEET 1 FOR CERTIFICATION

SCALE:
HORIZONTAL: 1" = 50'
VERTICAL: 1" = 10'

LEGEND

	NEW PERMANENT ASPHALT PAVEMENT
	NEW TEMPORARY ASPHALT PAVEMENT
	NEW CONCRETE
	NEW MOUNTABLE CURB AND GUTTER
	NEW STANDARD CURB AND GUTTER

CURVE TABLE

CURVE	RADIUS	LENGTH	DELTA
(33)	25.00'	22.39'	51°19'04"
(34)	25.00'	22.39'	51°19'04"
(35)	35.00'	86.33'	141°19'04"
(36)	35.00'	86.33'	141°19'04"
(37)	25.00'	22.39'	51°19'04"
(38)	25.00'	22.39'	51°19'04"
(39)	35.00'	86.33'	141°19'04"
(40)	35.00'	86.33'	141°19'04"
(41)	25.00'	22.39'	51°19'04"
(42)	25.00'	22.39'	51°19'04"
(43)	35.00'	86.33'	141°19'04"
(44)	35.00'	86.33'	141°19'04"

JEFF MORTENSEN & ASSOCIATES, INC.
600-9 MIDWAY PARK BLVD. N.E.
ALBUQUERQUE, N.M. 87109
ENGINEERS & SURVEYORS (CSD) 345-4256
FAX: 505 345-4254 © ESTABLISHED 1977

CITY OF ALBUQUERQUE
PUBLIC WORKS DEPARTMENT
ENGINEERING DEVELOPMENT GROUP

TITLE: OCOTILLO SUBDIVISION
PAVING AND STORM DRAINAGE IMPROVEMENTS PLAN AND PROFILE
DESERT ASTER LN. N.E., DESERT POPPY LN. N.E., DESERT PLUME LN. N.E.

Design Review Committee	City Engineer Approval	Last Design Update
City Project No. 729181	Zone Map No. C-21	Sheet 16 of 25

- STREET PAVING IMPROVEMENTS:
- ALL SLOPES AS SHOWN ON PROFILES ARE BASED ON STREET CENTERLINE STATIONING EXCEPT CUL-DE-SACS AND EYEBROWS WHERE STATIONING IS ALONG FACE-OF-CURB.
 - WHERE REMOVAL OF EXISTING CURB AND GUTTER, SIDEWALK OR PAVEMENT IS REQUIRED, THE CONTRACTOR SHALL SAWCUT AND/OR REMOVE TO THE NEAREST JOINT. CURB AND GUTTER AND SIDEWALK SHOWN AS EXISTING AND NOT TO BE REMOVED UNDER THIS CONTRACT WHICH IS DAMAGED OR DISPLACED BY THE CONTRACTOR SHALL BE REMOVED AND REPLACED BY THE CONTRACTOR PER C.O.A. STD. DWGS 2415A AND 2430, RESPECTIVELY, AT THE CONTRACTOR'S EXPENSE.
 - ALL DIMENSIONS OF CURB AND CURB RETURNS ARE SHOWN TO FACE-OF-CURB.
 - SIDEWALKS SHOWN HEREON AS "DEFERRED" SHALL BE CONSTRUCTED UNDER SEPARATE PERMIT.
 - ALL WHEELCHAIR RAMPS MUST BE CONSTRUCTED UNDER THIS WORK ORDER.
 - ALL CURB AND GUTTER SHOWN HEREON SHALL BE CONSTRUCTED IN ACCORDANCE WITH CITY OF ALBUQUERQUE STANDARD DRAWING 2415A UNLESS OTHERWISE NOTED.
 - UPON COMPLETION OF CONSTRUCTION, THE CITY OF ALBUQUERQUE WILL PROVIDE AND INSTALL ALL STREET SIGNS.
 - STRIPING BY CONTRACTOR WILL BE REQUIRED PRIOR TO FINAL ACCEPTANCE.
- STORM DRAIN NOTES:
- ALL STORM DRAIN TO BE CLASS III REINFORCED CONCRETE PIPE (RCP) UNLESS OTHERWISE NOTED.
 - ALL MANHOLES SHALL BE 6" DIAMETER TYPE 'C' PER C.O.A. STANDARD DRAWING 2101 UNLESS OTHERWISE NOTED.
 - ALL STATIONING SHOWN HEREON IS BASED ON STREET CENTERLINE UNLESS OTHERWISE NOTED. SLOPES ARE BASED ON TRUE LENGTH OF PIPE.
 - THE CONTRACTOR SHALL BE RESPONSIBLE FOR SELECTING APPROPRIATE MEANS AND METHODS TO EXCAVATE AND TRENCH AND INSTALL PIPE SO AS TO NOT EXCEED RIGHT-OF-WAY OR EASEMENT LIMITS, AND SO AS NOT TO INTERFERE WITH OTHER UTILITIES. THIS SHALL BE CONSIDERED INCIDENTAL TO TRENCHING, THEREFORE, NO SEPARATE PAYMENT WILL BE MADE.
 - THE CONTRACTOR SHALL BE RESPONSIBLE FOR PROTECTING, SUPPORTING AND REPLACING, IF DAMAGED, ALL OTHER UTILITIES ENCOUNTERED DURING CONSTRUCTION. THIS SHALL BE CONSIDERED INCIDENTAL TO TRENCHING, THEREFORE, NO SEPARATE PAYMENT WILL BE MADE.
 - FOR STORM DRAIN CONSTRUCTION, RCP PIPE JOINTS SHALL NOT BE GROUTED PRIOR TO FINAL INSPECTION. FINAL INSPECTION WILL DETERMINE JOINTS TO BE GROUTED FOR FINAL ACCEPTANCE OF THE CONSTRUCTION.

- AS BUILT INFORMATION
- | CONTRACTOR | WORK | DATE |
|------------|--------------|----------|
| JMA | CONSTRUCTION | 04/20/04 |
- CONTRACTOR'S ACCEPTANCE BY: JMA DATE: 04/20/04
- ENGINEER'S ACCEPTANCE BY: JMA DATE: 04/20/04
- RECORD BY: JMA DATE: 04/20/04
- NO. 20502

NO.	DATE	BY
20502	03/03	JMA

DATE: 03/03


BY: JMA

ENGINEER'S SEAL

JEFF MORTENSEN & ASSOCIATES, INC.
13678 N. 1st St.
Albuquerque, NM 87112
04/21/2004

NO.	DATE	REVISIONS
1	03-2004	DESIGN
2	03-2004	DESIGN
3	04-2004	DESIGN

DESIGNED BY	DRAWN BY	CHECKED BY
J.M.	S.C.H.	G.M.

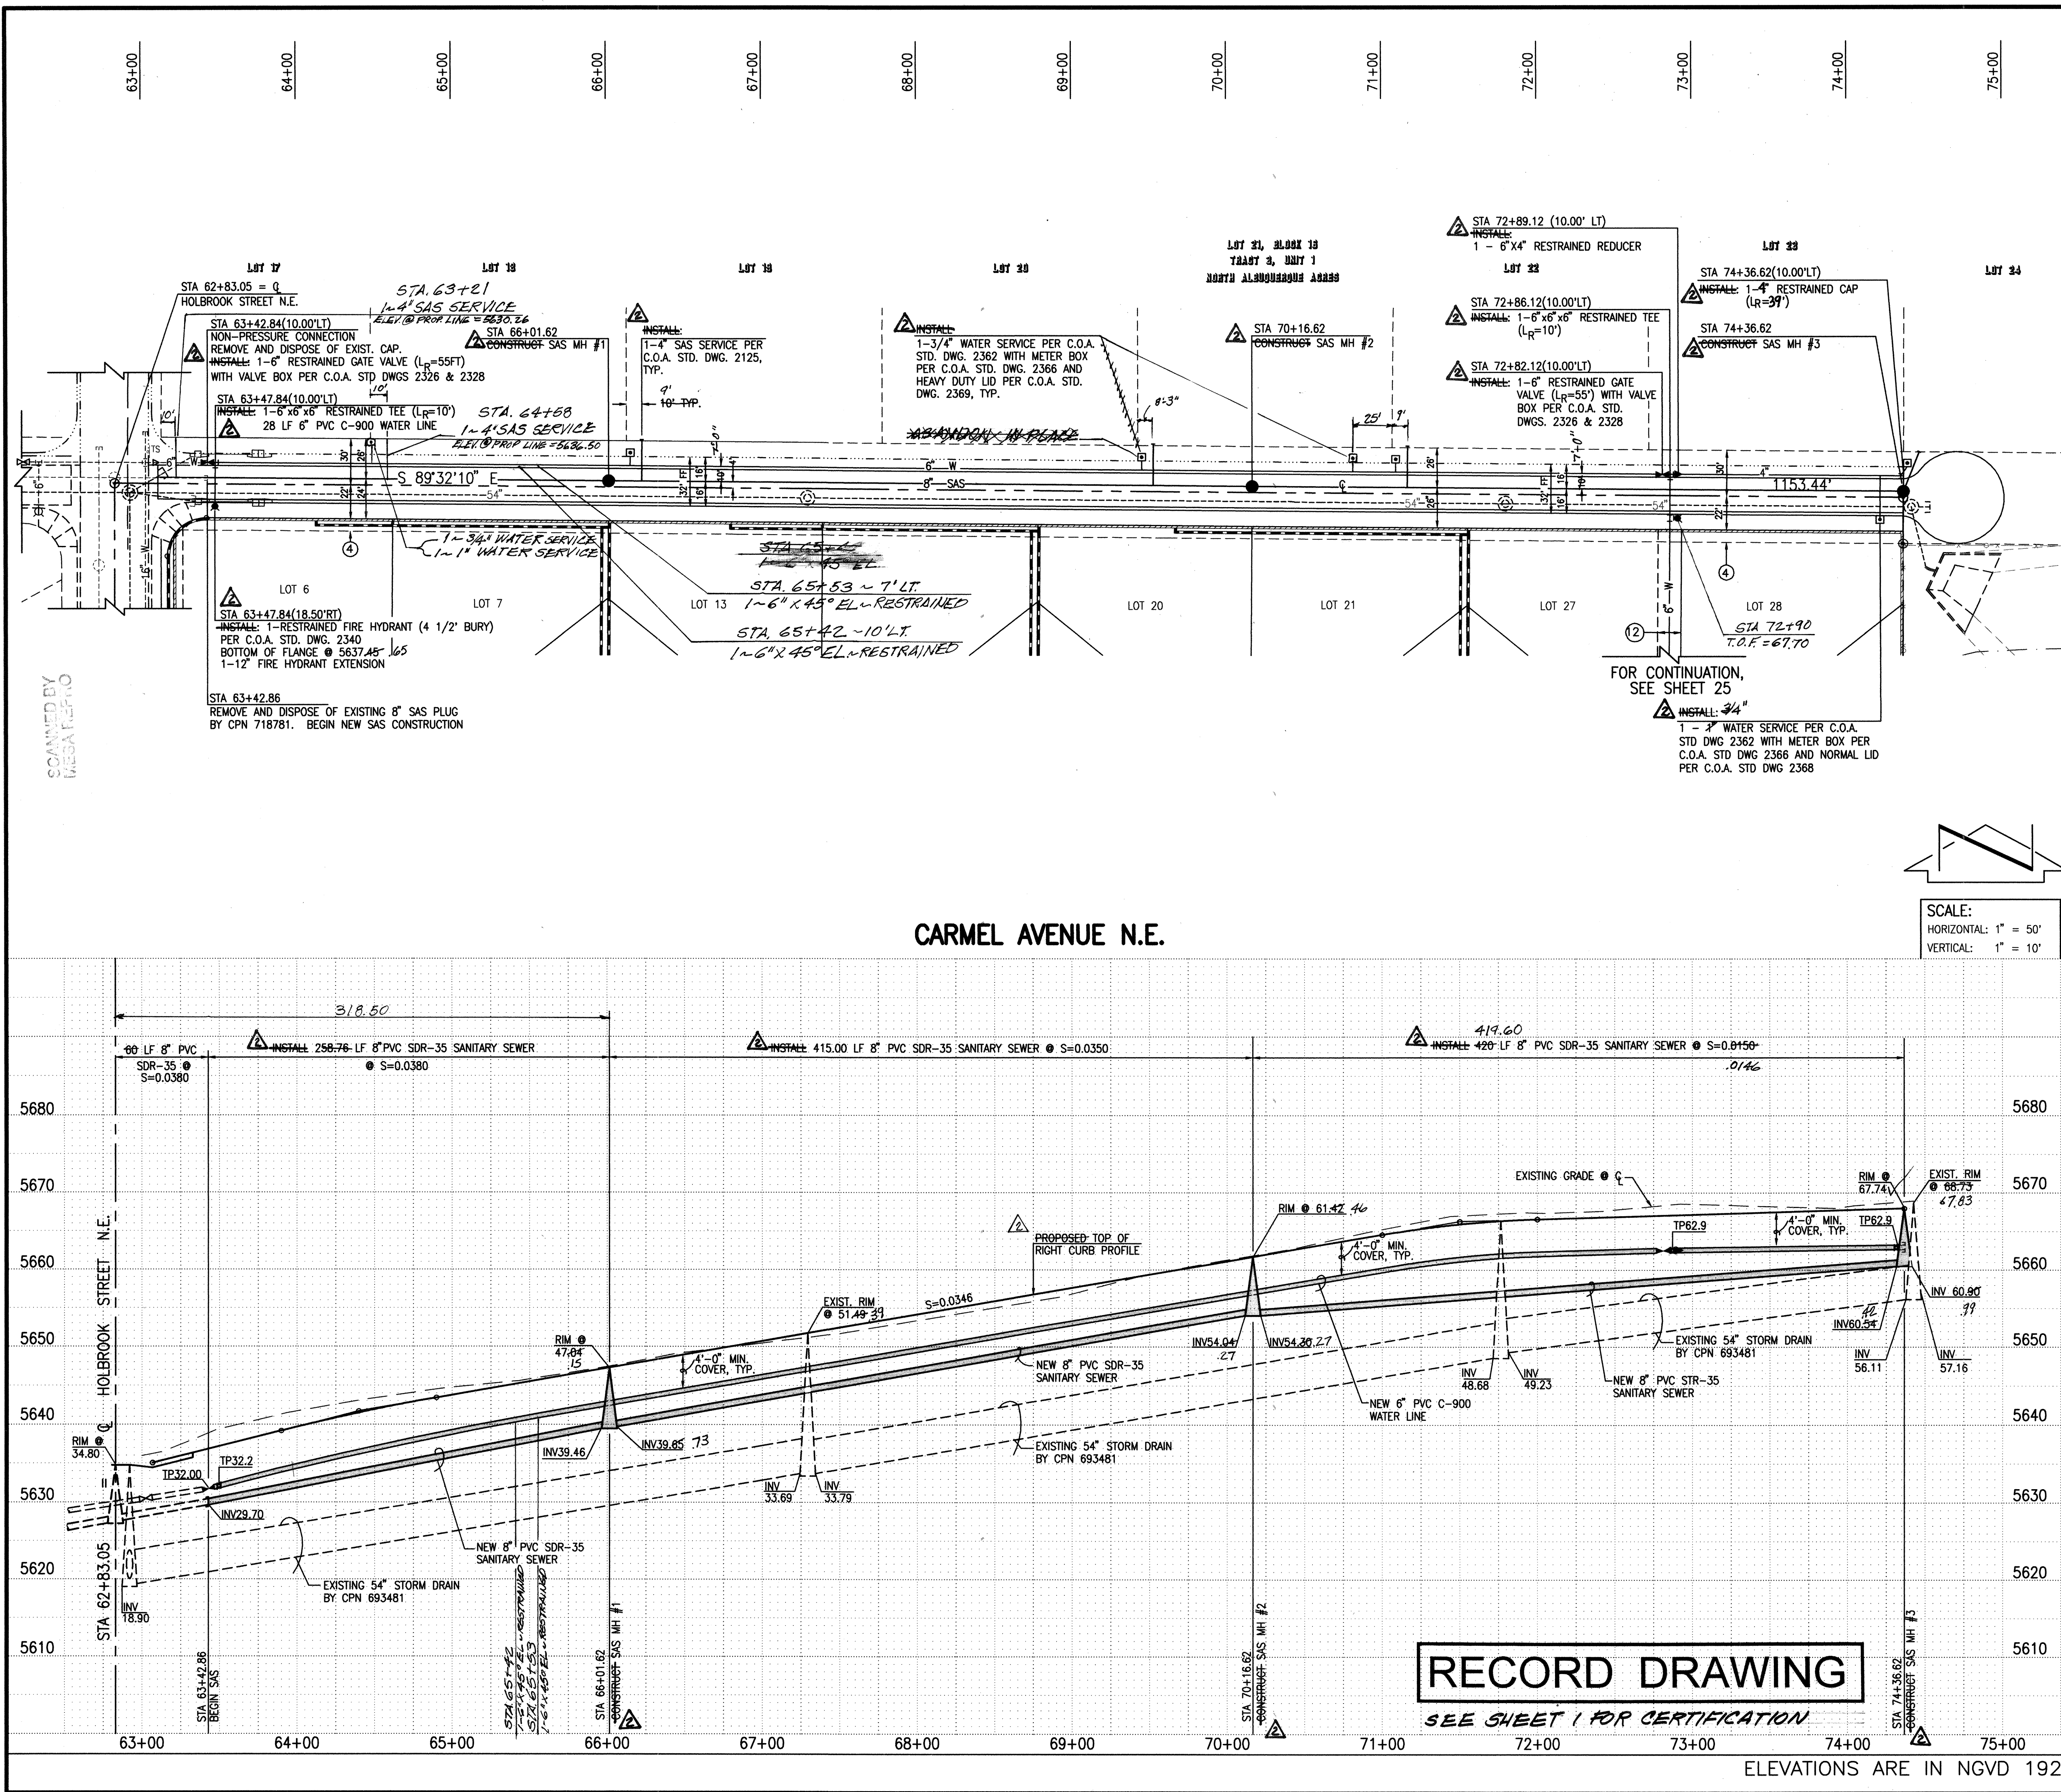

WATER LINE CONSTRUCTION NOTES:

- ALL STATIONING IS BASED ON STREET CENTERLINE UNLESS INDICATED OTHERWISE.
- FOR ALL LINES 12" AND SMALLER, WATER MAIN SHALL BE PVC C-900 PIPE OR AS APPROVED BY THE CITY OF ALBUQUERQUE CITY ENGINEER. DUCTILE IRON IS AN ACCEPTABLE PIPE MATERIAL IN LIEU OF PVC.
- FOR ALL LINES 14" AND LARGER, WATER MAIN SHALL BE DUCTILE IRON OR PVC C-905 OR AS APPROVED BY THE CITY OF ALBUQUERQUE CITY ENGINEER. CONCRETE CYLINDER IS AN ACCEPTABLE PIPE MATERIAL IN LIEU OF DUCTILE IRON.
- WATER LINE SHALL HAVE A MINIMUM COVER OF 3'-0" (FINISHED GRADE TO TOP OF PIPE). EXTRA DEPTH TRENCHING, IF REQUIRED, SHALL BE CONSIDERED INCIDENTAL TO CONSTRUCTION, THEREFORE, NO SEPARATE PAYMENT WILL BE MADE.
- ELECTRONIC MARKER DISCS (EMD) SHALL BE INSTALLED IN ACCORDANCE WITH THE STANDARD SPECIFICATION.
- IN ACCORDANCE WITH SECTION 801 OF THE "STANDARD SPECIFICATIONS", METALIZED DETECTABLE WARNING TAPE SHALL BE INSTALLED 18" ABOVE ALL PVC PIPE INSTALLED ON THIS PROJECT.
- VALVE STEM AND FIRE HYDRANT EXTENSIONS SHALL BE PROVIDED IN ACCORDANCE WITH THE STANDARD SPECIFICATIONS. THE COST OF EACH EXTENSION SHALL BE CONSIDERED INCIDENTAL TO CONSTRUCTION THEREFORE NO SEPARATE PAYMENT WILL BE MADE.
- JOINT RESTRAINT SHALL BE PROVIDED ON ALL JOINTS OF FIRE HYDRANT LEGS FROM TEE TO FIRE HYDRANT INCLUDING THE TEE AND FIRE HYDRANT.
- FOR THE PURPOSES OF THIS PROJECT, ALL RESTRAINED JOINTS AND JOINT RESTRAINT SHALL BE MECHANICALLY RESTRAINED. JOINT RESTRAINT LENGTHS SPECIFIED HEREON ARE THE LENGTHS TO BE RESTRAINED EACH SIDE OF THE FITTING.
- THE CONTRACTOR SHALL BE RESPONSIBLE FOR SELECTING APPROPRIATE MEANS AND METHODS TO EXCAVATE AND TRENCH AND INSTALL PIPE SO AS TO NOT EXCEED RIGHT-OF-WAY OR EASEMENT LIMITS, AND SO AS NOT TO INTERFERE WITH OTHER UTILITIES. THIS SHALL BE CONSIDERED INCIDENTAL TO TRENCHING, THEREFORE, NO SEPARATE PAYMENT WILL BE MADE.
- THE CONTRACTOR SHALL BE RESPONSIBLE FOR PROTECTING, SUPPORTING AND REPLACING, IF DAMAGED, ALL OTHER UTILITIES ENCOUNTERED DURING CONSTRUCTION. THIS SHALL BE CONSIDERED INCIDENTAL TO TRENCHING, THEREFORE, NO SEPARATE PAYMENT WILL BE MADE.
- WHERE WATER AND SANITARY SEWER LINES CROSS, THE SANITARY SEWER LINE SHALL BE INSTALLED AS PRESSURE PIPE BETWEEN MANHOLES IF 18 INCHES OF VERTICAL SEPARATION DOES NOT EXIST.
- ALL FIRE HYDRANTS SHALL BE SECURELY WRAPPED IN BLACK PLASTIC UNTIL SUCH TIME AS THE NEW WATER LINE IS PUT INTO SERVICE BY WATER SYSTEM DIVISION PERSONNEL.

SANITARY SEWER CONSTRUCTION NOTES:

- ALL STATIONING IS BASED ON STREET CENTERLINE UNLESS INDICATED OTHERWISE.
- ALL SEWER PIPE SHALL BE PVC (SDR-35).
- SLOPES SHOWN ON THE PROFILES ARE BASED ON TRUE DISTANCES.
- SEWER SERVICE LATERALS SHALL BE PROVIDED WITH ELECTRONIC MARKER DISCS (EMD) AS PER CITY OF ALBUQUERQUE STANDARD DRAWING 2125. EMD SHALL BE PROVIDED IN ACCORDANCE WITH THE STANDARD SPECIFICATION.
- THE CONTRACTOR SHALL BE RESPONSIBLE FOR SELECTING APPROPRIATE MEANS AND METHODS TO EXCAVATE AND TRENCH AND INSTALL PIPE SO AS TO NOT EXCEED RIGHT-OF-WAY OR EASEMENT LIMITS, AND SO AS NOT TO INTERFERE WITH OTHER UTILITIES. THIS SHALL BE CONSIDERED INCIDENTAL TO TRENCHING, THEREFORE, NO SEPARATE PAYMENT WILL BE MADE.
- THE CONTRACTOR SHALL BE RESPONSIBLE FOR PROTECTING, SUPPORTING AND REPLACING, IF DAMAGED, ALL OTHER UTILITIES ENCOUNTERED DURING CONSTRUCTION. THIS THEREFORE, NO SEPARATE PAYMENT WILL BE MADE.
- WHERE WATER AND SANITARY SEWER LINES CROSS, THE SANITARY SEWER LINE SHALL BE INSTALLED AS PRESSURE PIPE BETWEEN MANHOLES IF 18 INCHES OF VERTICAL SEPARATION DOES NOT EXIST.
- ALL SANITARY SEWER MANHOLES SHALL BE 4' DIAMETER TYPE "C" MANHOLES PER C.O.A. STD. DWG. 2101 UNLESS OTHERWISE NOTED.

LOT	STA	SIZE	TYPE	TC
19	66+14.91	3/4"	SINGLE	47.76
21	69+44.81	3/4"	SINGLE	59.19
22	71+08.67	3/4"	SINGLE	64.86
24	74+38.62	3/4"	SINGLE	68.01
N/A	74+21.62	1"	SINGLE	67.91

LOT	STA	SIZE	INV @ PL
19	66+22.91	4"	5642.00
21	69+52.81	4"	5653.50
22	71+16.67	4"	5659.50
24	74+46.63	4"	5663.00

NOTE: WATER SERVICES TO BE INSTALLED AT FUTURE TOP OF CURB ELEVATION AT BACK OF FUTURE CURB LOCATION.

2002.0504 8

JEFF MORTENSEN & ASSOCIATES, INC.
600-B MIDWAY PARK BLVD. N.E.
ALBUQUERQUE, N.M. 87109
ENGINEERS & SURVEYORS (SOS) 345-4290
FAX: 505 345-4254
ESTABLISHED 1977

CITY OF ALBUQUERQUE
PUBLIC WORKS DEPARTMENT
ENGINEERING DEVELOPMENT GROUP

TITLE: CARMEL AVENUE N.E.
WATER AND SANITARY SEWER IMPROVEMENTS PLAN AND PROFILE
OCOTILLO SUBDIVISION

Design Review Committee	City Engineer Approval	City Project No.	Zone Map No.	Sheet	Of
		729181	C-21	18	25

RECORD DRAWING
SEE SHEET 1 FOR CERTIFICATION

SCANNED BY
USA REFRO

WATER LINE CONSTRUCTION NOTES:

1. ALL STATIONING IS BASED ON STREET CENTERLINE UNLESS INDICATED OTHERWISE.
2. FOR ALL LINES 12" AND SMALLER, WATER MAIN SHALL BE PVC 12-900 PIPE OR AS APPROVED BY THE CITY OF ALBUQUERQUE CITY ENGINEER. DUCTILE IRON IS AN ACCEPTABLE PIPE MATERIAL IN LIEU OF PVC.
3. FOR ALL LINES 14" AND LARGER, WATER MAIN SHALL BE DUCTILE IRON OR PVC C-905 OR AS APPROVED BY THE CITY OF ALBUQUERQUE CITY ENGINEER. CONCRETE CYLINDER IS AN ACCEPTABLE PIPE MATERIAL IN LIEU OF DUCTILE IRON.
4. WATER LINE SHALL HAVE A MINIMUM COVER OF 3'-0" (FINISHED GRADE TO TOP OF PIPE). EXTRA DEPTH TRENCHING, IF REQUIRED, SHALL BE CONSIDERED INCIDENTAL TO CONSTRUCTION, THEREFORE, NO SEPARATE PAYMENT WILL BE MADE.
5. ELECTRONIC MARKER DISCS (EMO) SHALL BE INSTALLED IN ACCORDANCE WITH THE STANDARD SPECIFICATION.
6. IN ACCORDANCE WITH SECTION 801 OF THE "STANDARD SPECIFICATIONS", METALLIZED DETECTABLE WARNING TAPE SHALL BE INSTALLED 18" ABOVE ALL PVC PIPE INSTALLED ON THIS PROJECT.
7. VALVE STEM AND FIRE HYDRANT EXTENSIONS SHALL BE PROVIDED IN ACCORDANCE WITH THE STANDARD SPECIFICATIONS. THE COST OF EACH EXTENSION SHALL BE CONSIDERED INCIDENTAL TO CONSTRUCTION THEREFORE NO SEPARATE PAYMENT WILL BE MADE.
8. JOINT RESTRAINT SHALL BE PROVIDED ON ALL JOINTS OF FIRE HYDRANT LEGS FROM TEE TO FIRE HYDRANT INCLUDING THE TEE AND FIRE HYDRANT.
9. FOR THE PURPOSES OF THIS PROJECT, ALL RESTRAINED JOINTS AND JOINT RESTRAINT SHALL BE MECHANICALLY RESTRAINED. JOINT RESTRAINT LENGTHS SPECIFIED HEREON ARE THE LENGTHS TO BE RESTRAINED EACH SIDE OF THE FITTING.
10. THE CONTRACTOR SHALL BE RESPONSIBLE FOR SELECTING APPROPRIATE MEANS AND METHODS TO EXCAVATE AND TRENCH AND INSTALL PIPE SO AS TO NOT EXCEED RIGHT-OF-WAY OR EASEMENT LIMITS, AND SO AS NOT TO INTERFERE WITH OTHER UTILITIES. THIS SHALL BE CONSIDERED INCIDENTAL TO TRENCHING, THEREFORE, NO SEPARATE PAYMENT WILL BE MADE.
11. THE CONTRACTOR SHALL BE RESPONSIBLE FOR PROTECTING, SUPPORTING AND REPLACING, IF DAMAGED, ALL OTHER UTILITIES ENCOUNTERED DURING CONSTRUCTION. THIS SHALL BE CONSIDERED INCIDENTAL TO TRENCHING, THEREFORE, NO SEPARATE PAYMENT WILL BE MADE.
12. WHERE WATER AND SANITARY SEWER LINES CROSS, THE SANITARY SEWER LINE SHALL BE INSTALLED AS PRESSURE PIPE BETWEEN MANHOLES 18 INCHES OF VERTICAL SEPARATION DOES NOT EXIST.
13. ALL FIRE HYDRANTS SHALL BE SECURELY WRAPPED IN BLACK PLASTIC UNTIL SUCH TIME AS THE NEW WATER LINE IS PUT INTO SERVICE BY WATER SYSTEM DIVISION PERSONNEL.

SANITARY SEWER CONSTRUCTION NOTES:

1. ALL STATIONING IS BASED ON STREET CENTERLINE UNLESS INDICATED OTHERWISE.
2. ALL SEWER PIPE SHALL BE PVC (SDR-35).
3. SLOPES SHOWN ON THE PROFILES ARE BASED ON TRUE DISTANCES.
4. SEWER SERVICE LATERALS SHALL BE PROVIDED WITH ELECTRONIC MARKER DISCS (EMD) AS PER CITY OF ALBUQUERQUE STANDARD DRAWING 2125. EMD SHALL BE PROVIDED IN ACCORDANCE WITH THE STANDARD SPECIFICATION.
5. THE CONTRACTOR SHALL BE RESPONSIBLE FOR SELECTING APPROPRIATE MEANS AND METHODS TO EXCAVATE AND TRENCH AND INSTALL PIPE SO AS TO NOT EXCEED RIGHT-OF-WAY OR EASEMENT LIMITS, AND SO AS NOT TO INTERFERE WITH OTHER UTILITIES. THIS SHALL BE CONSIDERED INCIDENTAL TO TRENCHING, THEREFORE, NO SEPARATE PAYMENT WILL BE MADE.
6. THE CONTRACTOR SHALL BE RESPONSIBLE FOR PROTECTING SUPPORTING AND REPLACING, IF DAMAGED, ALL OTHER UTILITIES ENCOUNTERED DURING CONSTRUCTION. THIS SHALL BE CONSIDERED INCIDENTAL TO TRENCHING, THEREFORE, NO SEPARATE PAYMENT WILL BE MADE.
7. WHERE WATER AND SANITARY SEWER LINES CROSS, THE SANITARY SEWER LINE SHALL BE INSTALLED AS PRESSURE PIPE BETWEEN MANHOLES IF 18 INCHES OF VERTICAL SEPARATION DOES NOT EXIST.
8. ALL SANITARY SEWER MANHOLES SHALL BE 4' DIAMETER TYPE "C" MANHOLES PER C.O.A. STD. DWG. 2101 UNLESS OTHERWISE NOTED.

Jma
2002 05048


JEFF MORTENSEN & ASSOCIATES, INC.
☐ 6010-B MIDWAY PARK BLVD, N.E.
☐ ALBUQUERQUE ☐ NEW MEXICO 87109
☐ ENGINEERS ☐ SURVEYORS (505) 345-4250
☐ FAX: 505 345-4254 ☐ ESTABLISHED 1977

CITY OF ALBUQUERQUE PUBLIC WORKS DEPARTMENT ENGINEERING DEVELOPMENT GROUP	
TITLE:	OCOTILLO SUBDIVISION WATER AND SANITARY SEWER IMPROVEMENTS PLAN AND PROFILE SAND VERBENA TRAIL N.E. (ENTRY)

Design Review Committee	City Engineer Approval	Last Design Update	Mo./Day/Yr.	Mo./Day/Yr.


City Project No.	729181	Zone Map No.	C-21	Sheet	19	Of	25
------------------	--------	--------------	------	-------	----	----	----

SCANNED BY
MESA REFINO

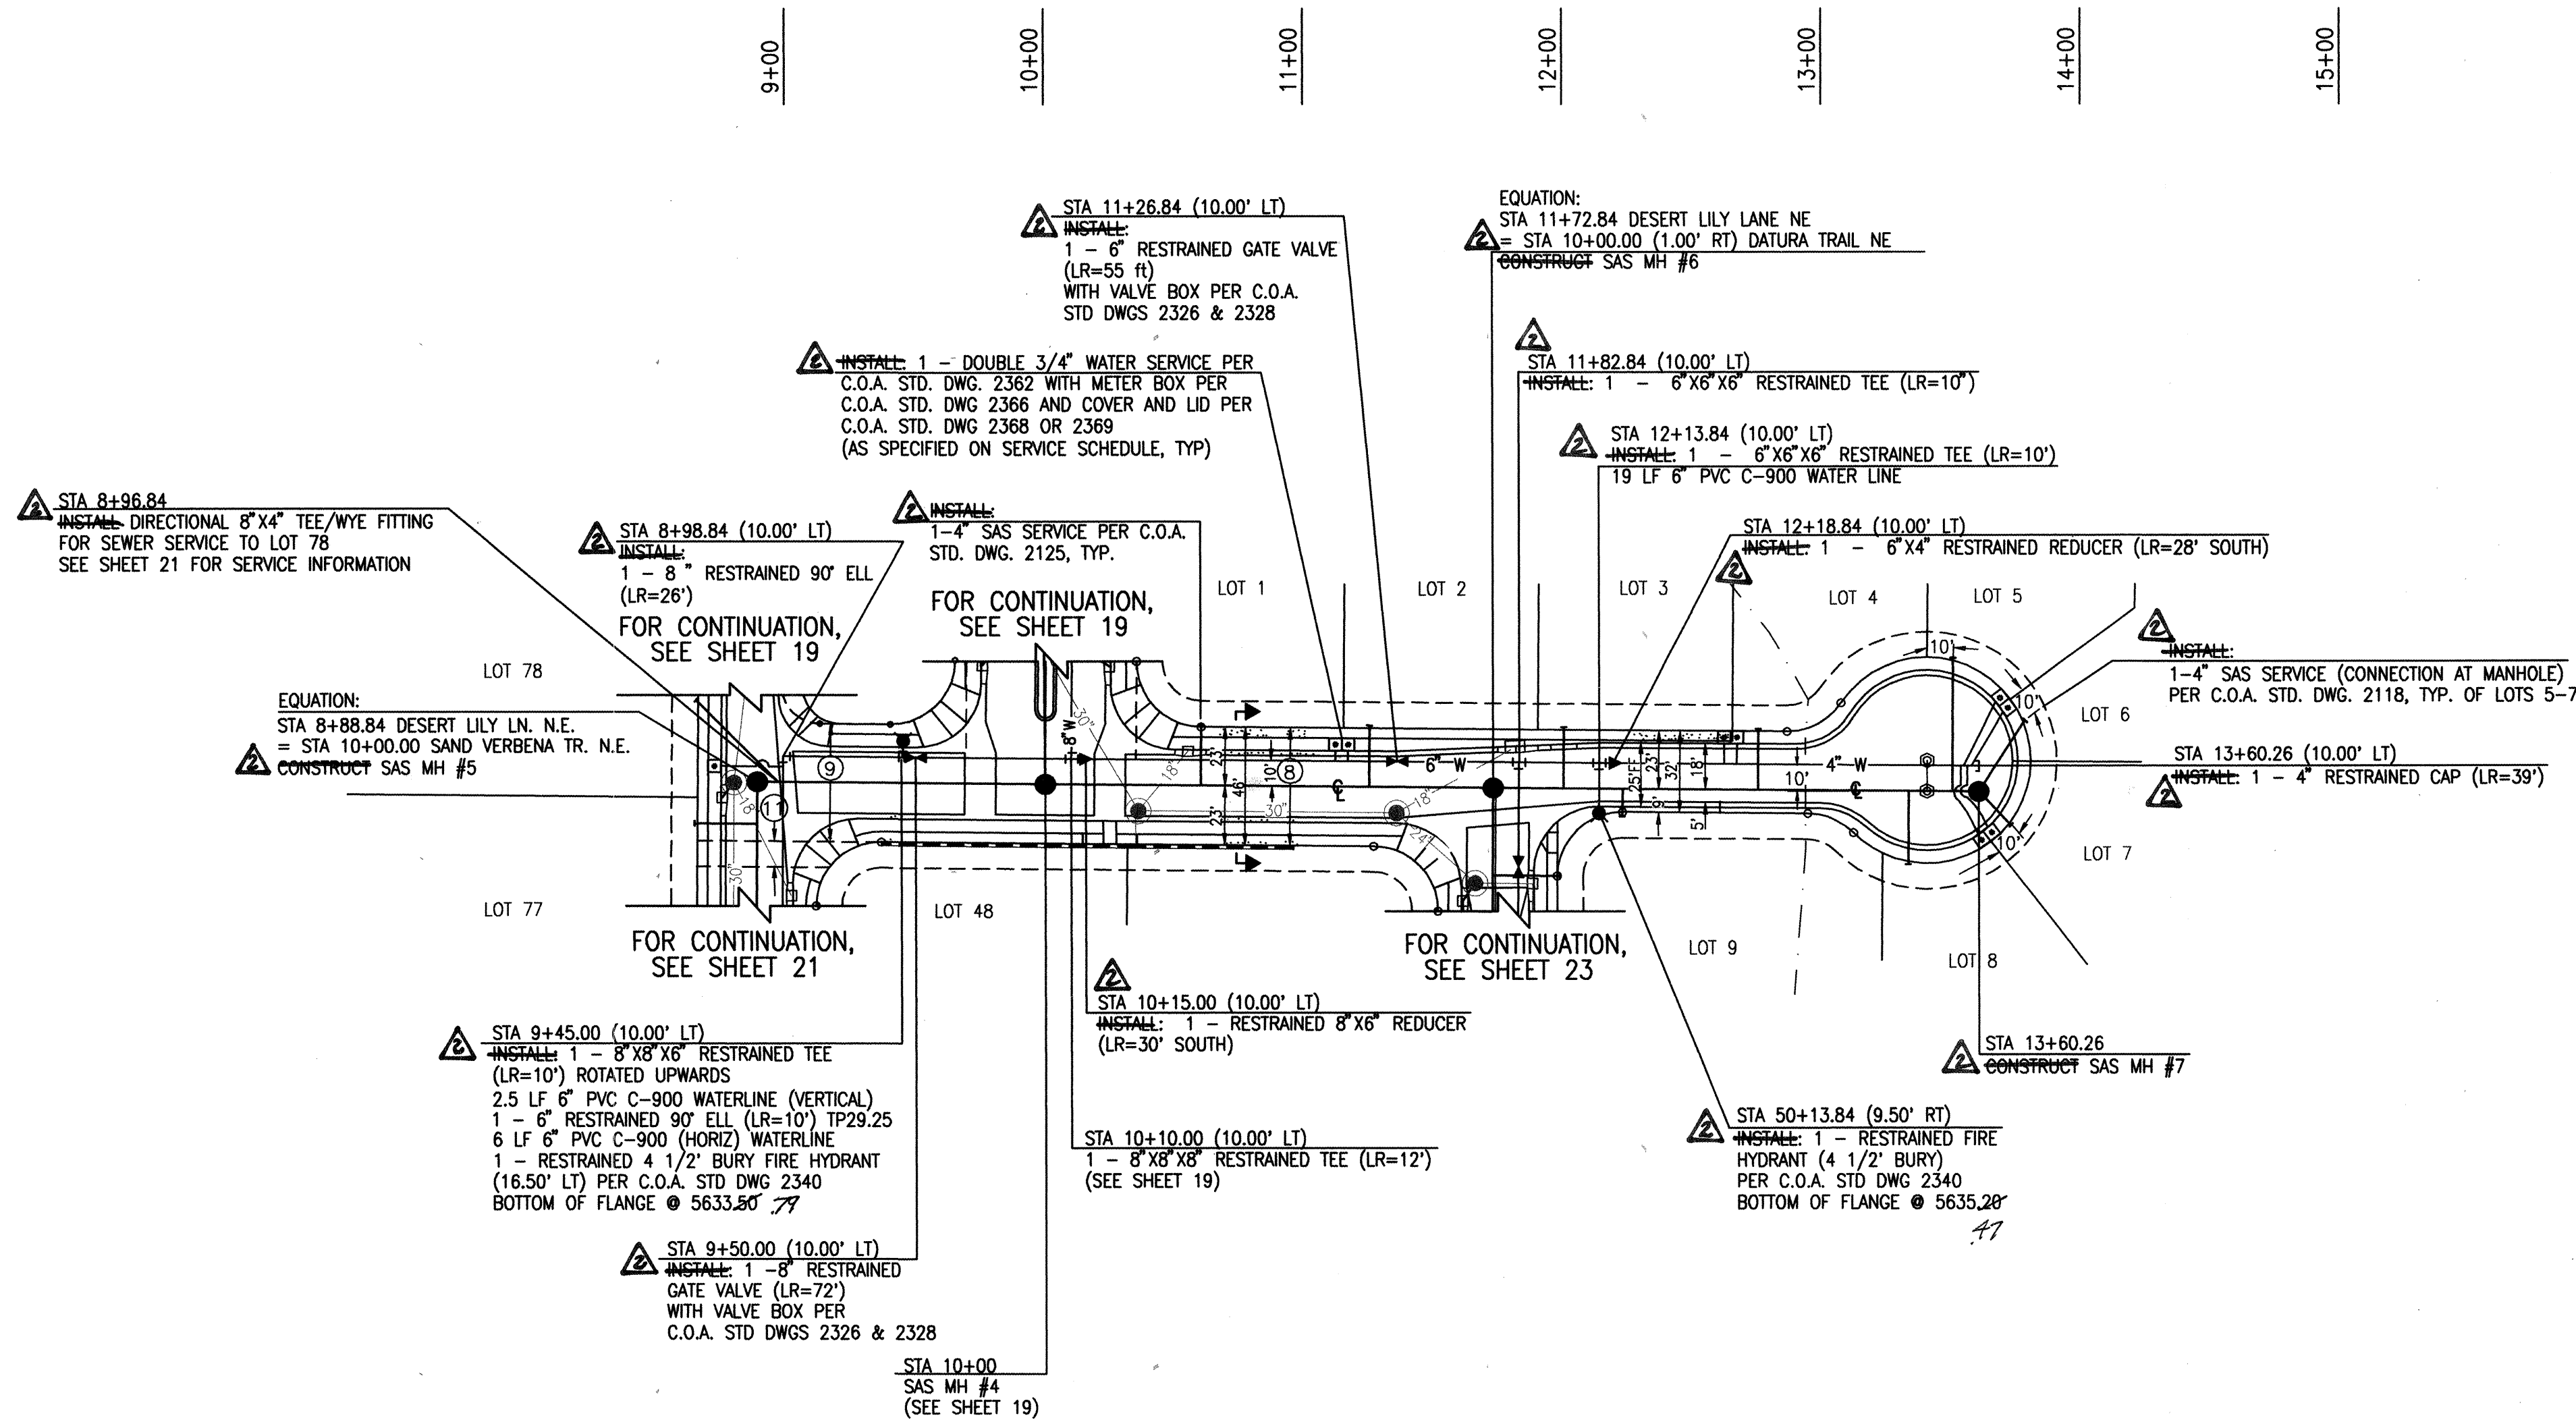

DESERT LILY LANE N.E.

SCALE:
HORIZONTAL: 1" = 50'
VERTICAL: 1" = 10'

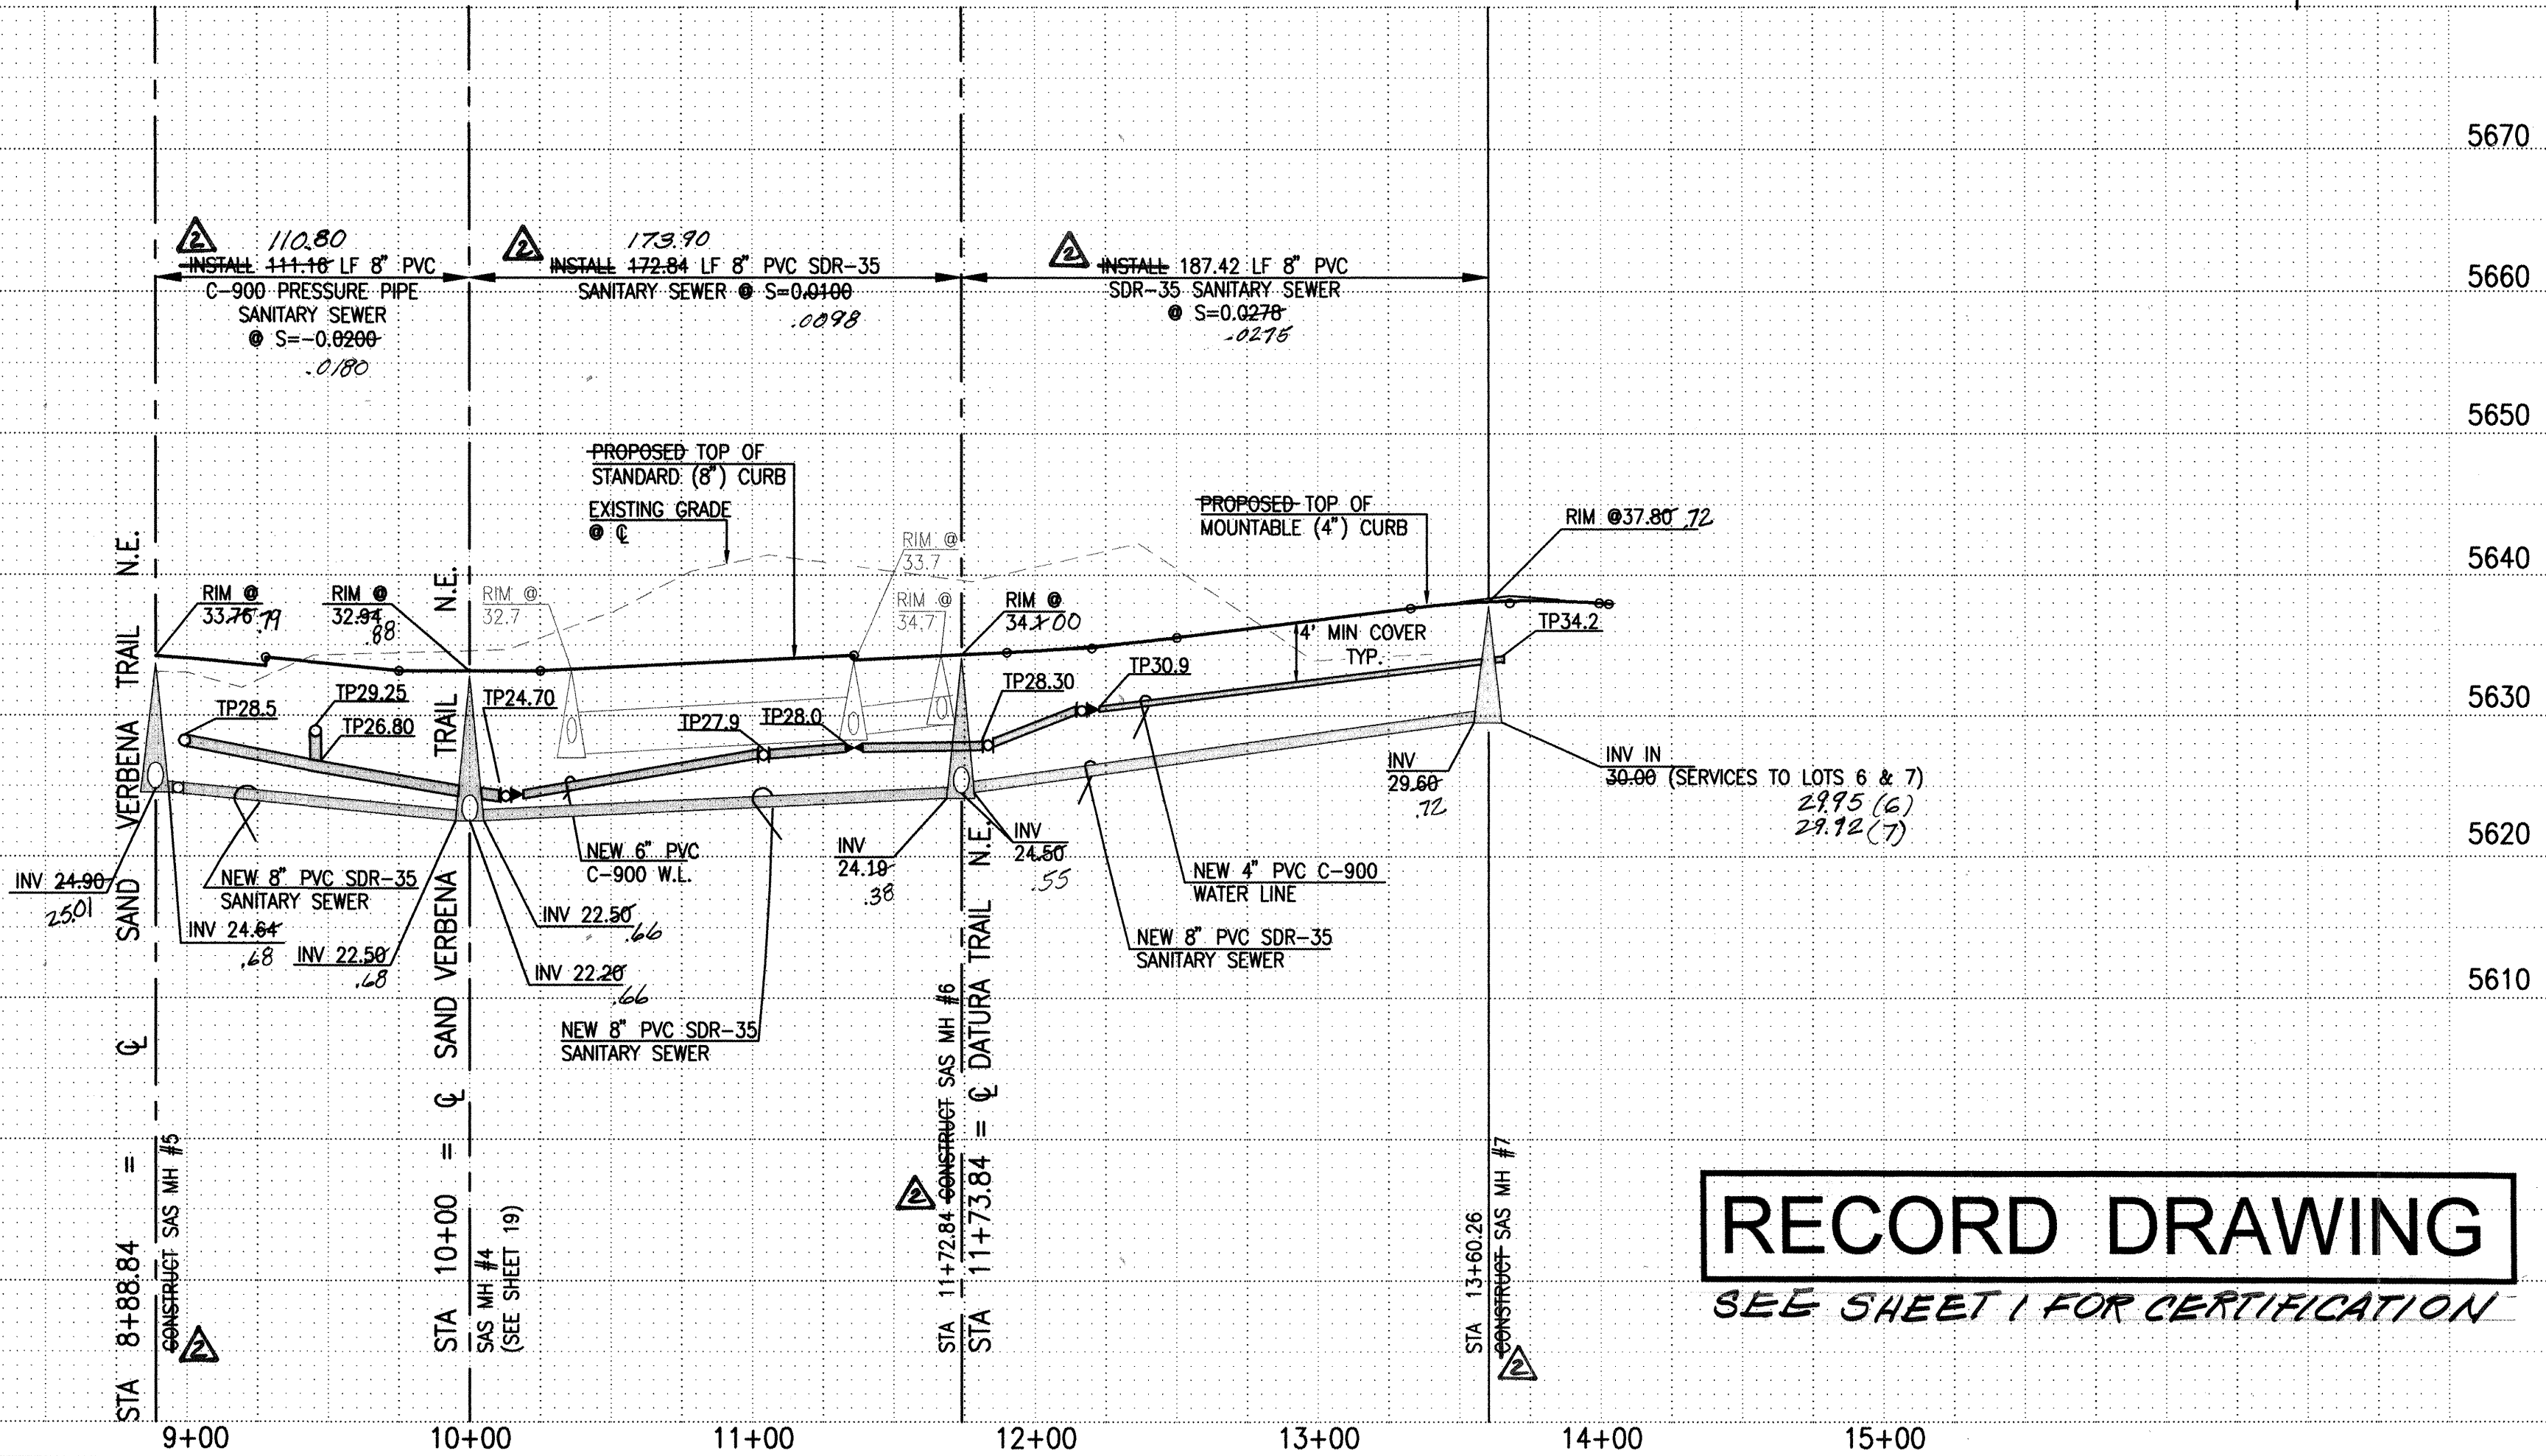

RECORD DRAWING
SEE SHEET 1 FOR CERTIFICATION

- WATER LINE CONSTRUCTION NOTES:
- ALL STATIONING IS BASED ON STREET CENTERLINE UNLESS INDICATED OTHERWISE.
 - FOR ALL LINES 12" AND SMALLER, WATER MAIN SHALL BE PVC C-900 PIPE OR AS APPROVED BY THE CITY OF ALBUQUERQUE CITY ENGINEER. DUCTILE IRON IS AN ACCEPTABLE PIPE MATERIAL IN LIEU OF PVC.
 - FOR ALL LINES 14" AND LARGER, WATER MAIN SHALL BE DUCTILE IRON OR PVC C-905 OR AS APPROVED BY THE CITY OF ALBUQUERQUE CITY ENGINEER. CONCRETE CYLINDER IS AN ACCEPTABLE PIPE MATERIAL IN LIEU OF DUCTILE IRON.
 - WATER LINE SHALL HAVE A MINIMUM COVER OF 3'-0" (FINISHED GRADE TO TOP OF PIPE). EXTRA DEPTH TRENCHING, IF REQUIRED, SHALL BE CONSIDERED INCIDENTAL TO CONSTRUCTION, THEREFORE, NO SEPARATE PAYMENT WILL BE MADE.
 - ELECTRONIC MARKER DISCS (EMD) SHALL BE INSTALLED IN ACCORDANCE WITH THE STANDARD SPECIFICATION.
 - IN ACCORDANCE WITH SECTION 801 OF THE "STANDARD SPECIFICATIONS", METALIZED DETECTABLE WARNING TAPE SHALL BE INSTALLED 18" ABOVE ALL PVC PIPE INSTALLED ON THIS PROJECT.
 - VALVE STEM AND FIRE HYDRANT EXTENSIONS SHALL BE PROVIDED IN ACCORDANCE WITH THE STANDARD SPECIFICATIONS. THE COST OF EACH EXTENSION SHALL BE CONSIDERED INCIDENTAL TO CONSTRUCTION THEREFORE NO SEPARATE PAYMENT WILL BE MADE.
 - JOINT RESTRAINT SHALL BE PROVIDED ON ALL JOINTS OF FIRE HYDRANT LEGS FROM TEE TO FIRE HYDRANT INCLUDING THE TEE AND FIRE HYDRANT.
 - FOR THE PURPOSES OF THIS PROJECT, ALL RESTRAINED JOINTS AND JOINT RESTRAINT SHALL BE MECHANICALLY RESTRAINED. JOINT RESTRAINT LENGTHS SPECIFIED HEREON ARE THE LENGTHS TO BE RESTRAINED EACH SIDE OF THE FITTING.
 - THE CONTRACTOR SHALL BE RESPONSIBLE FOR SELECTING APPROPRIATE MEANS AND METHODS TO EXCAVATE AND TRENCH AND INSTALL PIPE SO AS TO NOT EXCEED RIGHT-OF-WAY OR EASEMENT LIMITS, AND SO AS NOT TO INTERFERE WITH OTHER UTILITIES. THIS SHALL BE CONSIDERED INCIDENTAL TO TRENCHING, THEREFORE, NO SEPARATE PAYMENT WILL BE MADE.
 - THE CONTRACTOR SHALL BE RESPONSIBLE FOR PROTECTING, SUPPORTING AND REPLACING, IF DAMAGED, ALL OTHER UTILITIES ENCOUNTERED DURING CONSTRUCTION. THIS SHALL BE CONSIDERED INCIDENTAL TO TRENCHING, THEREFORE, NO SEPARATE PAYMENT WILL BE MADE.
 - WHERE WATER AND SANITARY SEWER LINES CROSS, THE SANITARY SEWER LINE SHALL BE INSTALLED AS PRESSURE PIPE BETWEEN MANHOLES IF 18 INCHES OF VERTICAL SEPARATION DOES NOT EXIST.
 - ALL FIRE HYDRANTS SHALL BE SECURELY WRAPPED IN BLACK PLASTIC UNTIL SUCH TIME AS THE NEW WATER LINE IS PUT INTO SERVICE BY WATER SYSTEM DIVISION PERSONNEL.

- SANITARY SEWER CONSTRUCTION NOTES:
- ALL STATIONING IS BASED ON STREET CENTERLINE UNLESS INDICATED OTHERWISE.
 - ALL SEWER PIPE SHALL BE PVC (SDR-35).
 - SLOPES SHOWN ON THE PROFILES ARE BASED ON TRUE DISTANCES.
 - SEWER SERVICE LATERALS SHALL BE PROVIDED WITH ELECTRONIC MARKER DISCS (EMD) AS PER CITY OF ALBUQUERQUE STANDARD DRAWING 2125. EMD SHALL BE PROVIDED IN ACCORDANCE WITH THE STANDARD SPECIFICATION.
 - THE CONTRACTOR SHALL BE RESPONSIBLE FOR SELECTING APPROPRIATE MEANS AND METHODS TO EXCAVATE AND TRENCH AND INSTALL PIPE SO AS TO NOT EXCEED RIGHT-OF-WAY OR EASEMENT LIMITS, AND SO AS NOT TO INTERFERE WITH OTHER UTILITIES. THIS SHALL BE CONSIDERED INCIDENTAL TO TRENCHING, THEREFORE, NO SEPARATE PAYMENT WILL BE MADE.
 - THE CONTRACTOR SHALL BE RESPONSIBLE FOR PROTECTING, SUPPORTING AND REPLACING, IF DAMAGED, ALL OTHER UTILITIES ENCOUNTERED DURING CONSTRUCTION. THIS SHALL BE CONSIDERED INCIDENTAL TO TRENCHING, THEREFORE, NO SEPARATE PAYMENT WILL BE MADE.
 - WHERE WATER AND SANITARY SEWER LINES CROSS, THE SANITARY SEWER LINE SHALL BE INSTALLED AS PRESSURE PIPE BETWEEN MANHOLES IF 18 INCHES OF VERTICAL SEPARATION DOES NOT EXIST.
 - ALL SANITARY SEWER MANHOLES SHALL BE 4' DIAMETER TYPE "C" MANHOLES PER C.O.A. STD. DWG. 2101 UNLESS OTHERWISE NOTED.

WATER SERVICE SCHEDULE				
LOT(S)	SIZE	TYPE	STA	COVER/LID DWG
1/2	3/4"	DOUBLE	11+15	2368 (STD)
3/4	3/4"	DOUBLE	12+65	2369 (H/V)
5/6	3/4"	DOUBLE	AS SHOWN	2369 (H/V)
7/8	3/4"	DOUBLE	AS SHOWN	2369 (H/V)

SANITARY SEWER SERVICE SCHEDULE			
LOT	SIZE	STA	INV @ R
1	4"	10+60	5628.00
2	4"	11+25	5629.00
3	4"	12+00	5628.00
9	4"	12+22.84	5630.00
4	4"	12+25	5630.00
8	4"	13+33.26	5631.50
5	4"	13+50.00	5632.00
6	4"	AS SHOWN	5633.00
7	4"	AS SHOWN	5633.50

JMA
2002.0504.8
JEFF MORTENSEN & ASSOCIATES, INC.
600-B MIDWAY PARK BLVD. N.E.
ALBUQUERQUE, N.M. 87109
ENGINEERS & SURVEYORS (505) 345-4250
FAX: 505 345-4254 ESTABLISHED 1977

CITY OF ALBUQUERQUE
PUBLIC WORKS DEPARTMENT
ENGINEERING DEVELOPMENT GROUP


TITLE: OCOTILLO SUBDIVISION
WATER AND SANITARY SEWER IMPROVEMENTS PLAN AND PROFILE
DESERT LILY LANE N.E.

Design Review Committee	City Engineer Approval	Zone Map No.	City Project No.
APPROVED	APPROVED	C-21	729181

Sheet 20 of 25


COPIED BY
MESA EPRNO

SAND VERBENA TRAIL N.E. (PRIVATE)

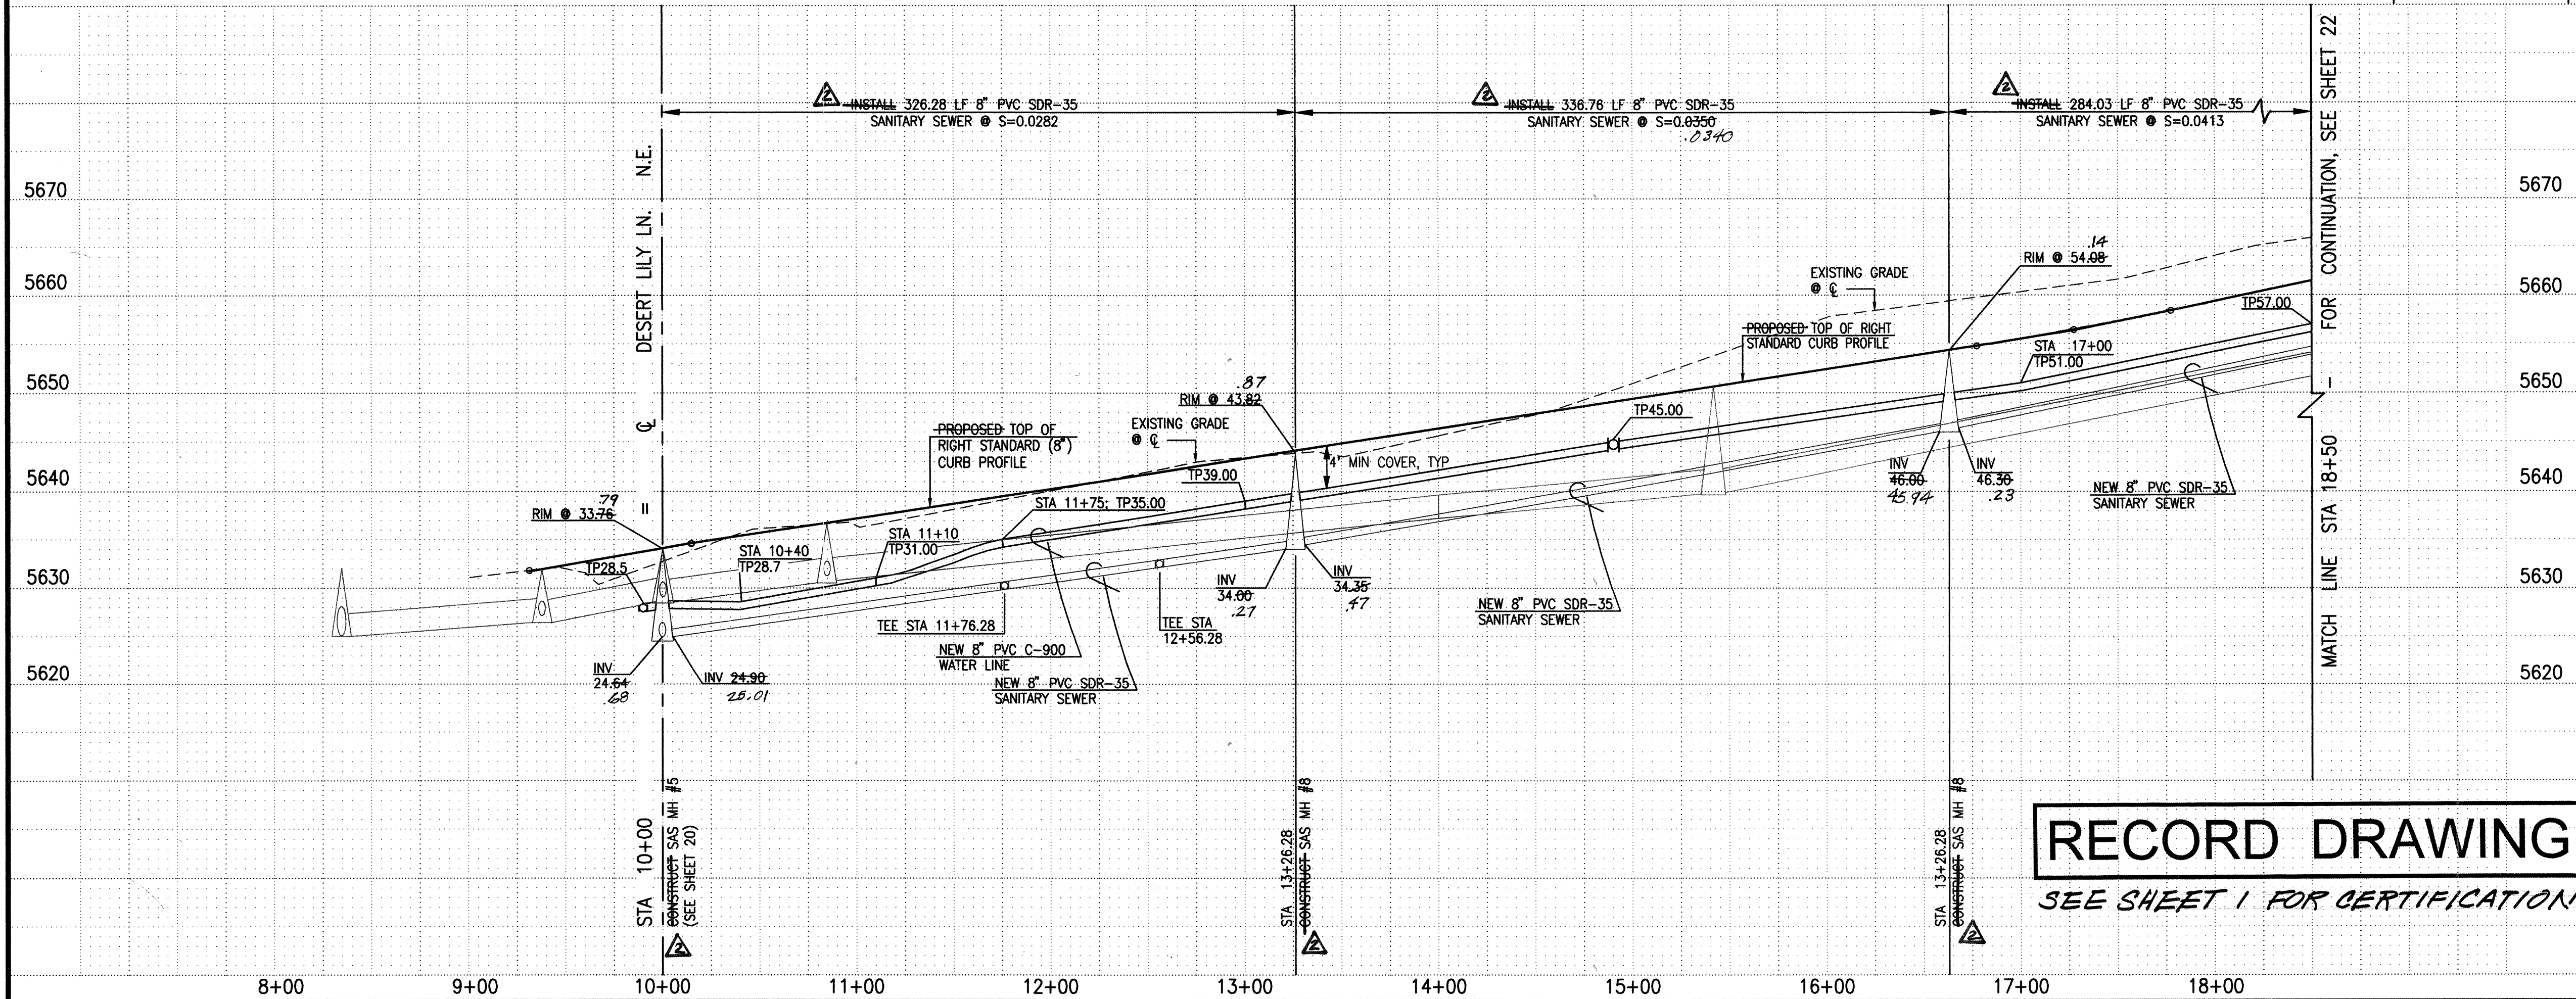

SPECIAL SEWER SERVICE SECTIONS (NTS)

(PROVIDED TO AVOID CONFLICTS WITH STORM DRAIN)

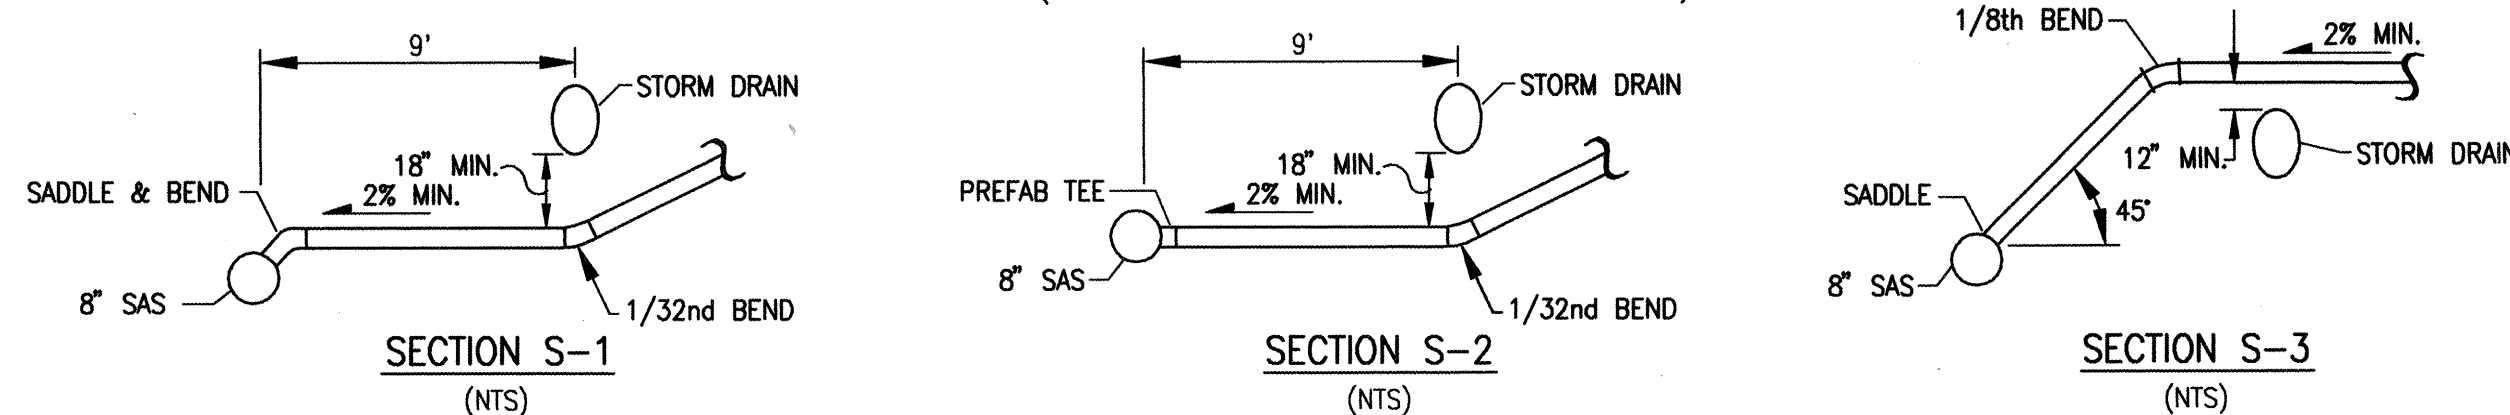

SANITARY SEWER SERVICE SCHEDULE					
LOT	STA	SIZE	INV. @	SECTION	
78	9+69	4"	5627.20	N/A	
77	10+16.28	4"	5630.00	S-1	
48	10+53.00	4"	5631.00	N/A	
76	10+96.28	4"	5632.00	S-1	
49	11+19.53	4"	5633.00	N/A	
75	11+76.28	4"	5634.00	S-2	
50	11+99.53	4"	5634.85	N/A	
74	12+56.28	4"	5635.00	S-2	
51	12+74.53	4"	5637.50	N/A	
73	13+36.28	4"	5640.00	S-3	
52	13+49.53	4"	5639.80	N/A	
72	14+16.28	4"	5642.00	S-3	
53	14+24.53	4"	5642.00	N/A	
71	14+96.28	4"	5644.50	S-3	
54	14+99.53	4"	5644.00	N/A	
55	15+74.53	4"	5646.50	N/A	
70	15+78.28	4"	5647.00	S-3	
56	16+49.53	4"	5649.00	N/A	
69	16+56.28	4"	5650.00	S-3	
57	17+24.53	4"	5651.20	N/A	
68	17+36.28	4"	5652.00	S-3	
58	18+04.53	4"	5654.50	N/A	
67	8+16.28	4"	5654.50	S-3	

SCALE:
HORIZONTAL: 1" = 50'
VERTICAL: 1" = 10'

- WATER LINE CONSTRUCTION NOTES:
- ALL STATIONING IS BASED ON STREET CENTERLINE UNLESS INDICATED OTHERWISE.
 - FOR ALL LINES 12" AND SMALLER, WATER MAIN SHALL BE PVC C-900 PIPE OR AS APPROVED BY THE CITY OF ALBUQUERQUE CITY ENGINEER. DUCTILE IRON IS AN ACCEPTABLE PIPE MATERIAL IN LIEU OF PVC.
 - FOR ALL LINES 14" AND LARGER, WATER MAIN SHALL BE DUCTILE IRON OR PVC C-905 OR AS APPROVED BY THE CITY OF ALBUQUERQUE CITY ENGINEER. CONCRETE CYLINDER IS AN ACCEPTABLE PIPE MATERIAL IN LIEU OF DUCTILE IRON.
 - WATER LINE SHALL HAVE A MINIMUM COVER OF 3'-0" (FINISHED GRADE TO TOP OF PIPE). EXTRA DEPTH TRENCHING, IF REQUIRED, SHALL BE CONSIDERED INCIDENTAL TO CONSTRUCTION, THEREFORE, NO SEPARATE PAYMENT WILL BE MADE.
 - ELECTRONIC MARKER DISCS (EMD) SHALL BE INSTALLED IN ACCORDANCE WITH THE STANDARD SPECIFICATION.
 - IN ACCORDANCE WITH SECTION 801 OF THE "STANDARD SPECIFICATIONS", METALIZED DETECTABLE WARNING TAPE SHALL BE INSTALLED 18" ABOVE ALL PVC PIPE INSTALLED ON THIS PROJECT.
 - VALVE STEM AND FIRE HYDRANT EXTENSIONS SHALL BE PROVIDED IN ACCORDANCE WITH THE STANDARD SPECIFICATIONS. THE COST OF EACH EXTENSION SHALL BE CONSIDERED INCIDENTAL TO CONSTRUCTION THEREFORE NO SEPARATE PAYMENT WILL BE MADE.
 - JOINT RESTRAINT SHALL BE PROVIDED ON ALL JOINTS OF FIRE HYDRANT LEGS FROM TEE TO FIRE HYDRANT INCLUDING THE TEE AND FIRE HYDRANT.
 - FOR THE PURPOSES OF THIS PROJECT, ALL RESTRAINED JOINTS AND JOINT RESTRAINT SHALL BE MECHANICALLY RESTRAINED. JOINT RESTRAINT LENGTHS SPECIFIED HEREON ARE THE LENGTHS TO BE RESTRAINED EACH SIDE OF THE FITTING.
 - THE CONTRACTOR SHALL BE RESPONSIBLE FOR SELECTING APPROPRIATE MEANS AND METHODS TO EXCAVATE AND TRENCH AND INSTALL PIPE SO AS TO NOT EXCEED RIGHT-OF-WAY OR EASEMENT LIMITS, AND SO AS NOT TO INTERFERE WITH OTHER UTILITIES. THIS SHALL BE CONSIDERED INCIDENTAL TO TRENCHING, THEREFORE, NO SEPARATE PAYMENT WILL BE MADE.
 - THE CONTRACTOR SHALL BE RESPONSIBLE FOR PROTECTING, SUPPORTING AND REPLACING, IF DAMAGED, ALL OTHER UTILITIES ENCOUNTERED DURING CONSTRUCTION. THIS SHALL BE CONSIDERED INCIDENTAL TO TRENCHING, THEREFORE, NO SEPARATE PAYMENT WILL BE MADE.
 - WHERE WATER AND SANITARY SEWER LINES CROSS, THE SANITARY SEWER LINE SHALL BE INSTALLED AS PRESSURE PIPE BETWEEN MANHOLES IF 18 INCHES OF VERTICAL SEPARATION DOES NOT EXIST.
 - ALL FIRE HYDRANTS SHALL BE SECURELY WRAPPED IN BLACK PLASTIC UNTIL SUCH TIME AS THE NEW WATER LINE IS PUT INTO SERVICE BY WATER SYSTEM DIVISION PERSONNEL.

- SANITARY SEWER CONSTRUCTION NOTES:
- ALL STATIONING IS BASED ON STREET CENTERLINE UNLESS INDICATED OTHERWISE.
 - ALL SEWER PIPE SHALL BE PVC (SDR-35).
 - SLOPES SHOWN ON THE PROFILES ARE BASED ON TRUE DISTANCES.
 - SEWER SERVICE LATERALS SHALL BE PROVIDED WITH ELECTRONIC MARKER DISCS (EMD) AS PER CITY OF ALBUQUERQUE STANDARD DRAWING 2125. EMD SHALL BE PROVIDED IN ACCORDANCE WITH THE STANDARD SPECIFICATION.
 - THE CONTRACTOR SHALL BE RESPONSIBLE FOR SELECTING APPROPRIATE MEANS AND METHODS TO EXCAVATE AND TRENCH AND INSTALL PIPE SO AS TO NOT EXCEED RIGHT-OF-WAY OR EASEMENT LIMITS, AND SO AS NOT TO INTERFERE WITH OTHER UTILITIES. THIS SHALL BE CONSIDERED INCIDENTAL TO TRENCHING, THEREFORE, NO SEPARATE PAYMENT WILL BE MADE.
 - THE CONTRACTOR SHALL BE RESPONSIBLE FOR PROTECTING, SUPPORTING AND REPLACING, IF DAMAGED, ALL OTHER UTILITIES ENCOUNTERED DURING CONSTRUCTION. THIS SHALL BE CONSIDERED INCIDENTAL TO TRENCHING, THEREFORE, NO SEPARATE PAYMENT WILL BE MADE.
 - WHERE WATER AND SANITARY SEWER LINES CROSS, THE SANITARY SEWER LINE SHALL BE INSTALLED AS PRESSURE PIPE BETWEEN MANHOLES IF 18 INCHES OF VERTICAL SEPARATION DOES NOT EXIST.
 - ALL SANITARY SEWER MANHOLES SHALL BE 4' DIAMETER TYPE "C" MANHOLES PER C.O.A. STD. DWG. 2101 UNLESS OTHERWISE NOTED.


WATER SERVICE SCHEDULE			
LOT(S)	STA	TYPE	SIZE
78	9+94	SINGLE	3/4"
77	10+83.78	SINGLE	3/4"
48/49	11+09.53	DOUBLE	3/4"
76	11+63.78	SINGLE	3/4"
75/74	12+46.28	DOUBLE	3/4"
50/51	12+64.53	DOUBLE	3/4"
73/72	14+06.28	DOUBLE	3/4"
52/53	14+14.53	DOUBLE	3/4"
54/55	15+64.53	DOUBLE	3/4"
71/70	15+66.28	DOUBLE	3/4"
56/57	17+14.53	DOUBLE	3/4"
69/68	17+26.28	DOUBLE	3/4"

JMA
2002.050A-8
JEFF MORTENSEN & ASSOCIATES, INC.
6810-B MIDWAY PARK BLVD. N.E.
ALBUQUERQUE, N.M. 87109
ENGINEERS & SURVEYORS (505) 345-4290
FAX: 505-345-4294 • ESTABLISHED 1977

CITY OF ALBUQUERQUE
PUBLIC WORKS DEPARTMENT
ENGINEERING DEVELOPMENT GROUP


TITLE: OCOTILLO SUBDIVISION
WATER AND SANITARY SEWER IMPROVEMENTS PLAN AND PROFILE
SAND VERBENA TRAIL N.E. STA 9+90.00 TO STA 18+50.00

Design Review Committee	City Engineer Approval	W. G. G. G.	W. G. G. G.
APPROVED	APPROVED		
DATE: MAY 9 2004	DATE: MAY 9 2004		
City Project No. 729181	Zone Map No. C-21	Sheet 21	Of 25

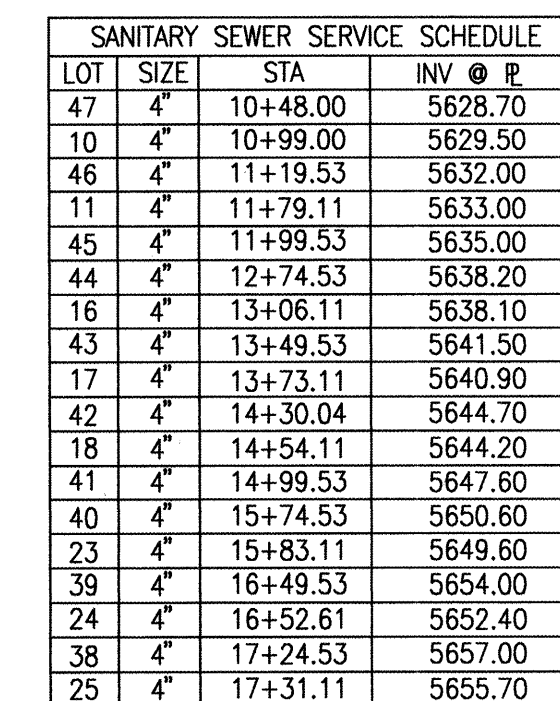

SANITARY SEWER CONSTRUCTION NOTES:

1. ALL STATIONING IS BASED ON STREET CENTERLINE UNLESS INDICATED OTHERWISE.
2. ALL SEWER PIPE SHALL BE PVC (SDR--35).
3. SLOPES SHOWN ON THE PROFILES ARE BASED ON TRUE DISTANCES.
4. SEWER SERVICE LATERALS SHALL BE PROVIDED WITH ELECTRONIC MARKER DISCS (EMD) AS PER CITY OF ALBUQUERQUE STANDARD DRAWING 2125. EMD SHALL BE PROVIDED IN ACCORDANCE WITH THE STANDARD SPECIFICATION.
5. THE CONTRACTOR SHALL BE RESPONSIBLE FOR SELECTING APPROPRIATE MEANS AND METHODS TO EXCAVATE AND TRENCH AND INSTALL PIPE SO AS TO NOT EXCEED RIGHT-OF-WAY OR EASEMENT LIMITS, AND SO AS NOT TO INTERFERE WITH OTHER UTILITIES. THIS SHALL BE CONSIDERED INCIDENTAL TO TRENCHING, THEREFORE, NO SEPARATE PAYMENT WILL BE MADE.
6. THE CONTRACTOR SHALL BE RESPONSIBLE FOR PROTECTING SUPPORTING AND REPLACING, IF DAMAGED, ALL OTHER UTILITIES ENCOUNTERED DURING CONSTRUCTION. THIS SHALL BE CONSIDERED INCIDENTAL TO TRENCHING, THEREFORE, NO SEPARATE PAYMENT WILL BE MADE.
7. WHERE WATER AND SANITARY SEWER LINES CROSS, THE SANITARY SEWER LINE SHALL BE INSTALLED AS PRESSURE PIPE BETWEEN MANHOLE TO TRENCHING, THEREFORE, SEPARATION DOES NOT EXIST.
8. ALL SANITARY SEWER MANHOLES SHALL BE 4' DIAMETER TYPE "C" MANHOLES PER C.O.A. STD. DWG. 2101 UNLESS OTHERWISE NOTED.

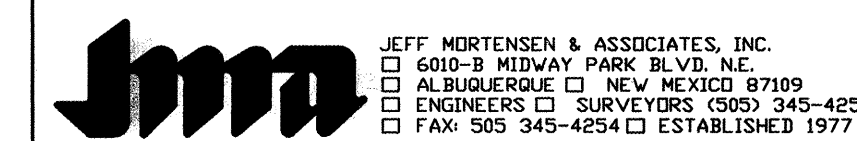



Design Review Committee	City Engineer Approval	Last Design Update	Mo./Day/Yr.	Mo./Day/Yr.
DESIGNED BY: [Signature] DATE: 12-7-2004	APPROVED BY: [Signature] DATE: 12-7-2004 CITY ENGINEER			

ELEVATIONS ARE IN NGVD 1929



City Project No.	729181	Zone Map No.	C-21	Sheet	23	Of	25
------------------	--------	--------------	------	-------	----	----	----



  
STA 9+99.00 - SAS MH #14 (SEE SHEET 23)



STA 999.00 — SAS MH #15 (SEE SHEET 23)

  

STA 9+99 - SAS MH #16 (SEE SHEET 24)

 

SCALE:
HORIZONTAL: 1" = 50'
VERTICAL: 1" = 10'

- SANITARY SEWER CONSTRUCTION NOTES:**
1. ALL STATIONING IS BASED ON STREET CENTERLINE UNLESS INDICATED OTHERWISE.
 2. ALL SEWER PIPE SHALL BE PVC (SDR-35).
 3. SLOPES SHOWN ON THE PROFILES ARE BASED ON TRUE DRAINAGES.
 4. SEWER SERVICE LATERALS SHALL BE PROVIDED WITH ELECTRONIC MARKER DISCS (EMD) AS PER CITY OF ALBUQUERQUE STANDARD DRAWING 2125. EMD SHALL BE PROVIDED IN ACCORDANCE WITH THE STANDARD SPECIFICATION.
 5. THE CONTRACTOR SHALL BE RESPONSIBLE FOR SELECTING APPROPRIATE MEANS AND METHODS TO EXCAVATE AND TRENCH AND INSTALL PIPE SO AS TO NOT EXCEED RIGHT-OF-WAY OR EASEMENT LIMITS, AND SO AS NOT TO INTERFERE WITH OTHER UTILITIES. THIS SHALL BE CONSIDERED INCIDENTAL TO TRENCHING, THEREFORE, NO SEPARATE PAYMENT WILL BE MADE.
 6. THE CONTRACTOR SHALL BE RESPONSIBLE FOR PROTECTING SUPPORTING AND REPLACING, IF DAMAGED, ALL OTHER UTILITIES ENCOUNTERED DURING CONSTRUCTION. THIS SHALL BE CONSIDERED INCIDENTAL TO TRENCHING, THEREFORE, NO SEPARATE PAYMENT WILL BE MADE.
 7. WHERE WATER AND SANITARY SEWER LINES CROSS, THE SANITARY SEWER LINE SHALL BE INSTALLED AS PRESSURE PIPE BETWEEN MANHOLES IF 18 INCHES OF VERTICAL SEPARATION DOES.
 8. ALL SANITARY SEWER MANHOLES SHALL BE 4' DIAMETER TYPE "C" MANHOLES PER C.O.A. STD. DWG. 2101 (UNLESS OTHERWISE NOTED).

ENGINEER'S SEAL

J. GRAEME MEANS
NEW MEXICO
13676
REGISTERED PROFESSIONAL ENGINEER

04/21/2004

SEE SHEET 1 FOR CERTIFICATION

ELEVATIONS ARE IN NGVD 1929

2002.050.48

CITY OF ALBUQUERQUE
PUBLIC WORKS DEPARTMENT
ENGINEERING DEVELOPMENT GROUP

TITLE: OCOTILLO SUBDIVISION
WATER AND SANITARY SEWER IMPROVEMENTS PLAN AND PROFILE
DESERT ASTER LN. N.E., DESERT POPPY LN. N.E., DESERT PLUME LN. N.E.

[illegible]

City Project No.	729181	Zone Map No.	C-21	Sheet	25	Of	25
------------------	--------	--------------	------	-------	----	----	----