

CONSTRUCTION PLANS FOR

PROJECT NO. TS01-20 (SHEETS 1 THROUGH 25)



ZONE ATLAS MAPS: K11, K12, L11, L12 & M-11


MASTER LEGEND:

	EXISTING:	NEW:
Property line	----	----
Building	_____	_____
Edge of pavement	----	----
Pavement striping		----
Fence	— x — x —	— x — x — x — x —
CMU or block wall	=====	=====
Existing easement	----	----
Fiber optic line	_____ FIBER _____	_____ FIBER _____
Overhead electric line	-----EOH-----	-----EOH-----
Gas line	_____ GAS _____	_____ G _____
Water line	-----W-----	-----WL-----
Sanitary sewer line	-----SAS-----	-----SAS-----
Storm drain line	-----SD-----	-----SD-----
Index contours		
Intermediate contours		
Power pole		
Gas Meter		
Light pole		
Water valve		
Fire hydrant		
Water meter		
Sanitary sewer manhole		
Sanitary sewer single cleanout		
Sanitary sewer double cleanout		
Sanitary sewer service		
Sanitary Sewer—Manhole Lift Station		
Ditch Gate Valve		

ABBREVIATIONS:

Invert	INV
Rim	RIM
Estimated Ground Water Surface	

I, THE UNDERSIGNED, A REGISTERED PROFESSIONAL ENGINEER IN THE STATE OF NEW MEXICO, DO HEREBY CERTIFY THAT THE INDICATED RECORD DRAWINGS ARE BASED UPON INFORMATION PROVIDED BY THE CONSTRUCTION CONTRACTOR IN THE FORM OF RED-LINED CONSTRUCTION DRAWING MARKUPS TO THE ORIGINAL DESIGN DRAWINGS. THE TRANSFER OF INFORMATION HEREIN IS VERIFIED AND CORRECT TO THE BEST OF MY KNOWLEDGE AND BELIEF. HOWEVER, I HAVE NOT VERIFIED THE ACCURACY AND/OR COMPLETENESS OF THE INFORMATION PROVIDED BY THE CONSTRUCTION CONTRACTOR AND SHALL NOT BE RESPONSIBLE FOR ERRORS OR OMISSIONS THAT MAY BE INCORPORATED INTO THE RESULT OF ENGINEERING INFORMATION PROVIDED BY OTHERS. INFORMATION INCLUDING VERTICAL AND HORIZONTAL DIMENSIONS SHOULD BE FIELD VERIFIED PRIOR TO USE ON FUTURE PROJECTS.

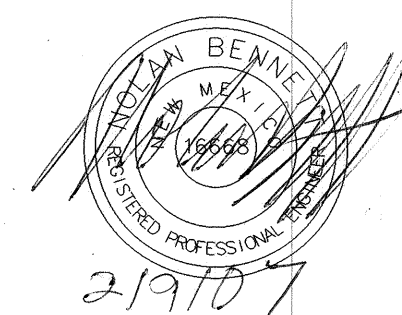


AS-BUILT NOTES

COPY OF ORIGINAL. ORIGINAL SEAL
ON CONTRACTORS AS-BUILT.

COORDINATES ARE LOCAL/PROJECT VALUES BASED ON PUBLISHED COORDINATES OF CITY MONUMENT "NM 45-4A", N=74,722.348 FEET, E=71,839.254 FEET, GEODETIC BEARINGS DETERMINED FROM GPS OBSERVATIONS AT THIS POINT, AND GROUND DISTANCES.

ELEVATIONS ARE BASED ON ELEVATIONS OF PROJECT CONTROL POINTS AND BENCHMARKS, "NM 45-4A" ELEV.=5,003.016 FEET; "17-L12" ELEV.=4,942.877 FEET; AND "AEC CP1" ELEV.=4,944.362 FEET.

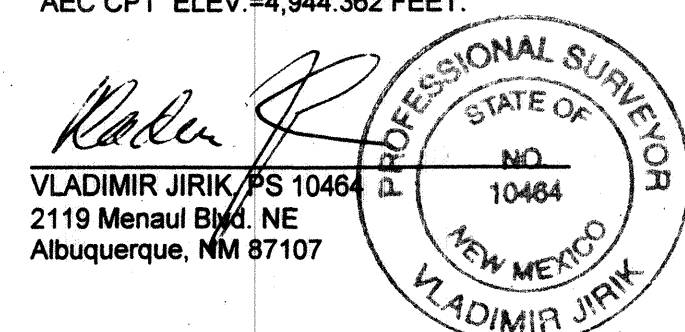


P.W.C.O. 40037

Roxanne Bebe Blatz
BERNALILLO COUNTY PUBLIC WORKS DIVISION

STATE
OF
NEW MEXICO

DRAWING INDEX

PAGE NO.	PAGE NAME	PAGE NO.	PAGE NAME
1	COVER SHEET	14	AREA 411 - FOOTHILL ROAD
2A & 2B	CONSTRUCTION NOTES, LEGEND & INDEX OF DRAWINGS	15	AREA 412 - PRIVATE ROAD
3	OVERALL SITE MAP	16	AREA 415 - PRIVATE ROAD
4	AREA 356 - PRIVATE ROAD #1	17	AREA 422 - PRIVATE ROAD
5	AREA 356 - JARAMILLO RD.	18	AREA 426 - PRIVATE ROAD
6	AREA 356 - ISLETA DRAIN #1	19	AREA 428 - PRIVATE ROAD
7	AREA 356 - ISLETA DRAIN #2	20	UTILITY DETAILS
8	AREA 364 - PRIVATE ROAD	21	TRAFFIC CONTROL NOTES
9	AREA 371 - ISLETA DRAIN	22	TYPICAL TRAFFIC CONTROL AND SIGNING
10	AREA 371 - PRIVATE ROAD	23	LIFT STATION LAYOUT
11	AREA 373 - ISLETA DRAIN	24	LIFT STATION ELECTRICAL #1
12	AREA 373 - PRIVATE ROAD #1	25	LIFT STATION ELECTRICAL #2
13	AREA 373 - PRIVATE ROAD #2		

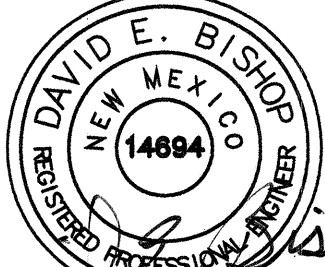REV.	SHEETS	CITY ENGINEER	DATE	USER DEPARTMENT	DATE	USER DEPARTMENT	DATE		
ENGINEERS STAMP & SIGNATURE				APPROVALS	ENGINEER	DATE	APPROVED FOR CONSTRUCTION		
 <i>David E. Bishop</i> 06/21/05				DRC Chairman					
				Transportation					
				Water/Wastewater	<i>[Signature]</i>		7/7/05		
				Hydrology					
				Parks					
				Const. Coord.					
				Record Drawing					
PROJECT MANAGER				CITY PROJECT NO. 747881			SHEET 1 OF 25		
				COUNTY PROJECT NO. TS01-20					

- | | | | |
|----------------------------|--------------|----------|-------|
| City Project No. 747881 | Zone Map No. | Sheet 2A | Of 25 |
| County Project No. TS01-20 | | | |

1. DISPOSAL OF UNSUITABLE MATERIALS & DEBRIS: THE CONTRACTOR SHALL NOTIFY THE PROJECT MANAGER IN WRITING OF THE DETAILS OF THE DISPOSAL OPERATIONS. BORROW, MATERIALS, ROCK WASTE, VEGETATION DEBRIS, ETC., SHALL NOT BE PLACED IN WETLAND AREAS OR AREAS WHICH MAY IMPACT ENDANGERED SPECIES OR ARCHAEOLOGICAL RESOURCES. AN ARCHAEOLOGICAL SURVEY AND ENVIRONMENTAL CLEARANCE SHALL BE COMPLETED AND WILL BE PROVIDED TO THE CONTRACTOR.
2. DISPOSAL SITE FOR ALL EXCESS EXCAVATION MATERIAL, ASPHALT PAVING, CONCRETE PAVING, CURB & GUTTER, SIDEWALKS, DRIVEWAYS AND OTHER REMOVAL ITEMS SHALL BE LOCATED BY THE CONTRACTOR. ALL COST INCURRED IN OBTAINING A DISPOSAL SITE AND HAUL THERE TO SHALL BE CONSIDERED INCIDENTAL TO CONSTRUCTION AND NO DIRECT PAYMENT WILL BE THEREFORE. THE DISPOSAL SITE SHALL BE ENVIRONMENTALLY ACCEPTABLE AND APPROVED BY THE PROJECT MANAGER, ALSO, A PERMITTED FACILITY FOR DISPOSABLE HAZARDOUS WASTE SHALL BE LOCATED AND APPROVED BY PROJECT MANAGER.
3. CONTRACTOR ACTIVITIES IN THE VICINITY OF WATERWAYS: ALL WORK IN THE VICINITY OF LIVE STREAMS, WATER IMPROVEMENTS, WETLANDS, OR IRRIGATION SUPPLIES SHALL BE EFFECTED IN SUCH A MANNER AS TO MINIMIZE VEGETATION REMOVAL, SOILS DISTURBANCES AND EROSION. EROSION, CROSSINGS OF LIVE STREAMS WITH HEAVY EQUIPMENT SHALL BE MINIMIZED. AS DETERMINED BY THE PROJECT MANAGER. EQUIPMENT REFUELING, MAINTENANCE, AND CEMENT DUMPING IN THE VICINITY OF WATER CROSSINGS IS STRICTLY PROHIBITED AND SHALL BE PERFORMED IN PROPER CONTAINMENT AREAS.
4. THE CONTRACTOR SHALL ENSURE THAT DAMAGE TO OR REMOVAL OF VEGETATION WILL BE KEPT TO A MINIMUM AND THAT NO EXTRANEOUS CLEARING, GRUBBING, LAND DISTURBANCE OR EXCAVATION WILL TAKE PLACE. CONSISTENT WITH THE REQUIREMENTS OF THE CITY OF ALBUQUERQUE'S STANDARD SPECIFICATIONS SECTION 107.28 PROTECTION & RESTORATION OF PROPERTY & LANDSCAPING, SECTION 201, CLEARING & GRUBBING, AND SUBSECTION 603.32 CONTRACTOR'S OPERATIONS, THE CONTRACTOR SHALL SEE TO IT THAT TREES AND SHRUBS WITHIN THE RIGHT-OF-WAY AND ALONG THE FENCE LINES ARE NOT OVERRUN OR DAMAGED BY CONSTRUCTION EQUIPMENT. UNNECESSARILY ALL AREAS DISTURBED BY THE CONTRACTOR SHALL HAVE TEMPORARY AND PERMANENT EROSION CONTROL. MEASURES IMPLEMENTED BY THE CONTRACTOR IN ACCORDANCE WITH THE NEW MEXICO WATER UTILITY ACT AND APPLIANCE CLEAN WATER ACT PERMITS AND REGULATIONS, THE CONTRACTOR SHALL BEAR THE FULL COST OF IMPLEMENTATION OF EROSION CONTROL. MEASURES AND VEGETATION REMEDIATION NECESSARY DUE TO THE CONTRACTOR'S NEGLIGENCE AS DETERMINED BY THE PROJECT MANAGER AND THE ENVIRONMENTAL PROGRAM MANAGER'S REPRESENTATIVE. THIS WORK WILL BE CONSIDERED INCIDENTAL TO CONSTRUCTION AND NO MEASUREMENT OR PAYMENT WILL BE MADE.
5. THE CONTRACTOR SHALL BE RESPONSIBLE FOR OBTAINING ANY NPDES PERMIT DURING CONSTRUCTION, FILLING OUT THE NOTICE OF INTENT (NOI) APPLICATION, NOTICE OF TERMINATION APPLICATION, AND FULFILLING ALL OTHER NECESSARY NPDES REQUIREMENTS. THE CONTRACTOR SHALL ALSO BE RESPONSIBLE FOR THE SUBMITTAL OF A POLLUTION PREVENTION PLAN AND INSPECTION REPORTS. THESE ITEMS SHALL BE PAID FOR UNDER THE BID ITEM FOR "NPDES STORM WATER PERMITTING AND SWPPP."
6. ANY CHECK DAMS OR SILT FENCES THAT ARE CALLED FOR ON THE REQUIRED POLLUTION PREVENTION PLAN SHALL BE PAID UNDER THE BID ITEM FOR "NPDES STORM WATER PERMITTING AND SWPPP."
7. THE CONTRACTOR SHALL PROPERLY HANDLE AND DISPOSE OF ALL CLEAN ASPHALT PAVEMENT AND CONCRETE MATERIAL TO BE REMOVED ACCORDING TO THE PLANS. CLEAN ASPHALT IS CLASSIFIED AS FILL MATERIAL AND IS NOT SUBJECT TO THE SOLID WASTE MANAGEMENT REGULATIONS OF THE NEW MEXICO ENVIRONMENTAL DEPARTMENT. CLEAN IS DEFINED AS BEING FREE OF SOLID WASTE OR CONTAMINANTS WHICH HAVE THE POTENTIAL OF MIGRATE INTO SURFACE OR GROUND WATER. THE MATERIAL SHALL BE COVERED WITH TWO FEET OF CLEAN EARTH IMMEDIATELY AFTER DISPOSITION. THE MATERIAL CANNOT BE PLACED IN WATERCOURSE, ARROYO, OR WITHIN 10 FEET OF GROUNDWATER. IF THE ASPHALT AND CONCRETE MATERIAL IS NOT CLEAN IT IS SUBJECT TO THE SOLID WASTE ACT AND MUST BE PLACED IN AN APPROVED LANDFILL. ALL DISPOSAL SITES ARE SUBJECT TO THE APPROVAL OF THE RESPECTIVE LANDOWNER AND THE PROJECT MANAGER.

1. DESCRIPTIONS OF WORK: REMOVE, TRANSPORTATION AND DISPOSAL ALL ASBESTOS CEMENTS (AC) PIPE, IN ACCORDANCE WITH THE PROJECT SPECIFICATIONS. THE WORK SPECIFIED HEREIN SHALL BE THE REMOVAL OF ALL AC PIPE BY COMPETENT PERSONS IN COMPLIANCE WITH ALL FEDERAL, STATE AND LOCAL REGULATIONS. THE CONTRACTOR SHALL VERIFY THE EXISTING AND LOCATION OF ASBESTOS PIPELINE BEFORE PROCEEDING WITH THE WORK. IT SHALL BE THE RESPONSIBILITY OF THE SUCCESSFUL CONTRACTOR TO MAKE PROPER ARRANGEMENT WITH AUTHORIZED AGENCY FOR HANDLING BUT NOT LIMITED TO REMOVAL, TRANSPORTATION AND DISPOSAL OF ALL ASBESTOS PIPES.
2. SUBMITTALS: PROOF, SATISFACTORY TO THE ENGINEER, THAT REQUIRED PERMITS TO HAVE BEEN OBTAINED AND THE ARRANGEMENTS FOR TRANSPORTATION AND DISPOSAL OF ASBESTOS PIPELINE CONTAINING WASTE MATERIALS HAVE BEEN MADE. ALL DUMP RECEIPTS, TRIP TICKETS, TRANSPORTATION MANIFESTS OR OTHER DOCUMENTATION OF DISPOSAL SHALL BE DELIVERED TO THE PROJECT ENGINEER FOR HIS/HER RECORDS. USE A RECORD KEEPING FORMAT THAT UTILIZES A CHAIN OF CUSTODY FORM WHICH INCLUDES THE NAMES AND ADDRESSES OF THE GENERATOR (OWNER), CONTRACTOR, PICKUP SITE, AND DISPOSAL SITE, THE ESTIMATED QUANTITY OF THE ASBESTOS WASTE AND TYPE OF CONTAINER, AND THE DISPOSAL SITE OPERATOR, AS THE RESPONSIBILITY FOR THE MATERIAL CHANGING HANDS. IF A SEPARATE HAULER IS EMPLOYED, HIS NAME, ADDRESS, TELEPHONE NUMBER AND SIGNATURE MUST ALSO BE ALSO APPEAR ON THE FORM. EACH COPY OF THE WASTE MANIFEST IS TO BE SIGNED BY ALL PERSONS INVOLVED IN THE CHAIN OF CUSTODY OF THE ASBESTOS WASTE.
3. MEASUREMENT AND PAYMENT: THE ASBESTOS PIPES SHALL BE REMOVED, TRANSPORTED AND DISPOSED OF BY AN AUTHORIZED AND REGISTERED AGENCY. IF THE CONTRACTOR IS NOT AUTHORIZED TO HANDLE ASBESTOS PIPES HE/SHE SHALL MAKE ARRANGEMENT WITH AUTHORIZED AND REGISTERED AGENCY FOR HANDLING ASBESTOS PIPES. THE PAYMENT FOR REMOVAL, HANDLING, TRANSPORTATION AND DISPOSAL OF EXISTING WATERLINE SHALL BE INCIDENTAL.

1. ANY WORK TO BE PERFORMED WITHIN THE MIDDLE RIO GRANDE CONSERVANCY DISTRICT (M.R.G.C.D.) RIGHT-OF-WAY SHALL BE CLOSELY COORDINATED WITH THE M.R.G.C.D. ENGINEERING DEPARTMENT AND APPROPRIATE FIELD OFFICE. PHONE: (505) 247-0234
2. NO WORK IS TO BE DONE ON FACILITIES OR STRUCTURES BELONGING TO, OR OPERATED BY, THE M.R.G.C.D. BETWEEN MARCH 1 AND OCTOBER 31 INCLUSIVE. HOWEVER, WORK MAY BE PERMITTED BY THE M.R.G.C.D. IF IT CAN BE SHOWN THAT THE WORK WILL NOT INTERFERE WITH OPERATIONS OF THE M.R.G.C.D. FACILITY. ALL WORK TO BE DONE WITHIN THE M.R.G.C.D. FACILITIES MUST BE APPROVED BY THE M.R.G.C.D. ENGINEER PRIOR TO COMMENCING WORK.
3. THE CONTRACTOR SHALL NOT STORE EQUIPMENT, NEW MATERIALS OR DEBRIS WITHIN DISTRICT RIGHT-OF-WAY WHICH MAY INTERFERE WITH OPERATIONS AND MAINTENANCE OF THE M.R.G.C.D. FACILITY.
4. THE CONTRACTOR SHALL NOT SERVICE VEHICLES OR EQUIPMENT WITHIN M.R.G.C.D. RIGHT-OF-WAY.
5. SEEDING OF DISTURBED AREAS WITHIN THE M.R.G.C.D. RIGHTS OF WAY IS REQUIRED PER THE M.R.G.C.D. SEEDING SPECIFICATIONS.
6. THE CONTRACTOR MUST MAINTAIN A MINIMUM COVER OF 3' OVER ALL CULVERT CROSSINGS USED FOR ACCESS TO THE PROJECT SITE.
7. THE CONTRACTOR IS RESPONSIBLE FOR REPAIRING AND/OR REPLACEMENT OF ANY STRUCTURES REMOVED AND/OR DAMAGED DUE TO THE CONTRACTORS ACTIVITIES WITHIN THE DISTRICTS RIGHT-OF-WAY. SHOULD ANY TURNOUTS, CULVERT PIPES, AND/OR STRUCTURES REQUIRE REPLACEMENT DUE TO LEAKAGE AND/OR DAMAGE BY THE CONTRACTOR, NEW TURNOUTS, AND NEW CULVERT PIPES AND/OR NEW STRUCTURES SHALL REPLACE THE DAMAGED ITEM. REPAIRS AND/OR REPLACEMENTS WITHIN THE DISTRICTS RIGHT-OF-WAY MUST COMPLY WITH THE DISTRICTS SPECIFICATIONS.
8. ALL DAMAGED CULVERT CROSSINGS AND CULVERT CROSSINGS REMOVED AND/OR DISTURBED MUST BE RESTORED AND/OR REPLACED TO THE SATISFACTION OF THE M.R.G.C.D. AND COMPLY WITH M.R.G.C.D. SPECIFICATIONS.
9. ALL SALVAGEABLE CULVERTS, IRRIGATION GATES, ETC. MUST BE RETURNED TO M.R.G.C.D..
10. THE CONTRACTOR IS RESPONSIBLE FOR EXECUTING A "SPECIAL USE LICENSE AGREEMENT" WITH THE M.R.G.C.D. PRIOR TO CONSTRUCTION. NO ADDITIONAL COMPENSATION SHALL BE PROVIDED TO THE CONTRACTOR FOR THIS "SPECIAL USE LICENSE AGREEMENT".
11. PRIOR TO CONSTRUCTION, THE CONTRACTOR SHALL CONTACT THE MIDDLE RIO GRANDE CONSERVANCY DISTRICT (M.R.G.C.D.) AT 247-0234 TO PROVIDE NOTICE OF THE SCHEDULE FOR CONSTRUCTION AT THE M.R.G.C.D. FACILITIES. ALL WORK TO BE PERFORMED IN THE M.R.G.C.D. RIGHT-OF-WAY SHALL BE CLOSELY COORDINATED WITH M.R.G.C.D. WILL REQUIRE THE CONTRACTOR TO SIGN A SPECIAL USE PERMIT AND PROVIDE A \$2,500 SECURITY DEPOSIT PRIOR TO WORKING IN M.R.G.C.D. R/W.
12. REINFORCED CONCRETE PIPE CULVERT SHALL CONFORM TO ASTM DESIGNATION 076-72, CLASS III, WALL B, USING "O" RING GASKETED JOINTS.
13. CORRUGATED METAL PIPE CULVERT SHALL CONFORM TO INTERIM FEDERAL SPECIFICATION WW-P-00405, CLASS I AND II, SHAPES 1,2, AND 3.
14. CULVERT CROSSINGS SHALL BE SET AT AN ELEVATION PROVIDING A MAXIMUM BACK WATER EFFECT OF NOT MORE THAN 0.25' AS DETERMINED BY HYDRAULIC COMPUTATIONS.
15. TRANSITIONS SHALL BE PROVIDED AT BOTH INLET AND OUTLET OF THE PIPE AS SHOWN ON THE DRAWINGS. TRANSITIONS MAY BE CONSTRUCTED OF CONCRETE OR GROUTED RIP-RAP.
16. GROUTED RIP-RAP PROTECTION SHALL BE USED ADJACENT TO STRUCTURES IN EARTH-SURFACED WATERWAYS WHERE EROSION MAY OCCUR. RIP-RAP SHALL BE HARD, DENSE, AND DURABLE.
17. ALL BACKFILL SHALL BE COMPACTED TO 90% OF THE MAXIMUM DRY DENSITY AS DETERMINED BY THE ASTM PROCTOR TEST, 95% FOR ROADWAYS.
18. NO CULVERT INSTALLATIONS ARE PERMITTED DURING THE IRRIGATION SEASON (MARCH 1 TO NOVEMBER 1 INCLUSIVE).
19. THE LICENSEE SHALL CLEAN AND REMOVE ALL SILT AND DEBRIS WITHIN THE CULVERT CROSSING ON AN ANNUAL BASIS PRIOR TO MARCH 1st AND THEREAFTER.
20. THE LICENSEE SHALL BE RESPONSIBLE FOR THE MAINTENANCE OF THE CULVERT CROSSING AND ALL ACCESSORIES ON THE CULVERT CROSSING.
21. THE LICENSEE SHALL BE RESPONSIBLE FOR THE CONTROL OF VEGETATION ON AND AROUND THE CULVERT CROSSING.
22. PRIOR TO ANY CONSTRUCTION WITHIN M.R.G.C.D. THE CONTRACTOR MUST SIGN A SPECIAL USE PERMIT AND PAY M.R.G.C.D. AN ASSOCIATED REFUNDABLE SECURITY DEPOSIT TO ENSURE PERFORMANCE.
23. THE ISLETA DRAIN SHALL NOT BE DISTURBED. ANY METHODS NEEDED TO BE EMPLOYED TO ENSURE THAT THE DRAIN IS NOT DISTURBED SHALL BE INCIDENTAL TO THE TRENCHING BID ITEM.

1. IF ANY THREATENED OR ENDANGERED SPECIES OR THEIR HABITATS ARE DISCOVERED DURING CONSTRUCTION, WORK WILL CEASE IMMEDIATELY AND THE EPA WILL BE NOTIFIED IN ORDER THAT APPROPRIATE MEASURES CAN BE TAKEN IN ACCORDANCE WITH THE ENDANGERED SPECIES ACT.
2. CONSTRUCTION MATERIAL AND WASTE PRODUCTS, INCLUDING MACHINERY LEAKAGE, MAINTENANCE MATERIAL AND SPILLS, WILL BE CONTAINED AND PROPERLY DISPOSED PRIOR TO PROJECT COMPLETION.
3. IF HUMAN REMAINS ARE ENCOUNTERED DURING CONSTRUCTION, APPROPRIATE LAW ENFORCEMENT AUTHORITIES AND THE OFFICE OF THE MEDICAL EXAMINER WILL BE CONTACTED.
4. IF CULTURAL MATERIALS ARE DISCOVERED DURING CONSTRUCTION, WORK WILL CEASE IMMEDIATELY AND EPA AND THE NEW MEXICO STATE HISTORIC PRESERVATION OFFICER WILL BE NOTIFIED OF THE DISCOVERY. EPA WILL PROCEED IN ACCORDANCE WITH THE REGULATIONS OF THE ADVISORY COUNCIL ON HISTORIC PRESERVATION PRIOR TO TAKING ANY ACTION WHICH WOULD AFFECT THE CULTURAL RESOURCES.

FOR HOMES ON WELL SWITCHING TO CITY WATER:

- WELL SUPPLY LINE TO RESIDENCE MUST BE CUT AND CAPPED BEFORE CONNECTING TO CITY SERVICE.

EFFECTIVE JULY 1, 2003, THE ALBUQUERQUE-BERNALLILLO WATER UTILITY AUTHORITY WAS ESTABLISHED AS A JOINT CITY OF ALBUQUERQUE-BERNALLILLO COUNTY AGENCY TO ADMINISTER THE WATER AND WASTEWATER UTILITIES CURRENTLY OWNED AND OPERATED BY THE CITY OF ALBUQUERQUE. THIS PROJECT WILL BE CONSTRUCTED DURING THE TRANSITION PERIOD WHILE THE CITY IS TO TRANSFER ALL FUNCTIONS, APPROPRIATIONS, MONEY, RECORDS, EQUIPMENT, AND OTHER REAL AND PERSONAL PROPERTY TO THE AUTHORITY. AT THE TIME THAT THESE PLANS WERE PREPARED, THE SPECIFIC DETAILS OF THE TRANSITION WERE NOT AVAILABLE TO THE ENGINEER OR OWNER. REFERENCES TO THE CITY OF ALBUQUERQUE IN THESE PLANS OR IN THE CITY OF ALBUQUERQUE SPECIFICATIONS TO PLUMBING WORKS CONSTRUCTION, 1986 EDITION THROUGH UPDATE #1, MAY BE AFFECTED, AS SUCH, THE CONTRACTOR WILL BE REQUIRED TO COORDINATE ALL NECESSARY ACTIVITIES WITH THE PROJECT ENGINEER AND THE ALBUQUERQUE-BERNALLILLO COUNTY WATER UTILITY AUTHORITY DURING THE CONSTRUCTION CONTRACT PERIOD, IF NECESSARY.


ENGINEER'S SEAL		SURVEY INFORMATION		BENCH MARKS		AS BUILT INFORMATION	
		FIELD NOTES					
		NO.	BY				
						CONTRACTOR	
						WORK STARTED BY	DATE
						ACCEPTANCE BY	DATE
						FIELD LAYOUT BY	DATE
						DRAWINGS CORRECTED BY	DATE
						MICRO-FILM INFORMATION	
						RECORDED BY	DATE
						NO.	




David E. Bishop 06/21/05

REVISIONS			
DESIGNED BY	— NKB	DATE	— 06/05
DRAWN BY	— PVL	DATE	— 06/05
CHECKED BY	— DEB	DATE	— 06/05

	BERNALILLO COUNTY PUBLIC WORKS DIVISION TECHNICAL SERVICES			
TITLE: FOOTHILL/BRIDGE INFILL AREA SEWER AND WATER IMPROVEMENTS CONSTRUCTION NOTES, LEGEND & INDEX OF DRAWINGS				
Design Review Committee	City Engineer Approval	Last Design Update	Mo./Day/Yr. 	Mo./Day/Yr.
City Project No. 747881		Zone Map No.	Sheet	of 25
County Project No. TS01-20				

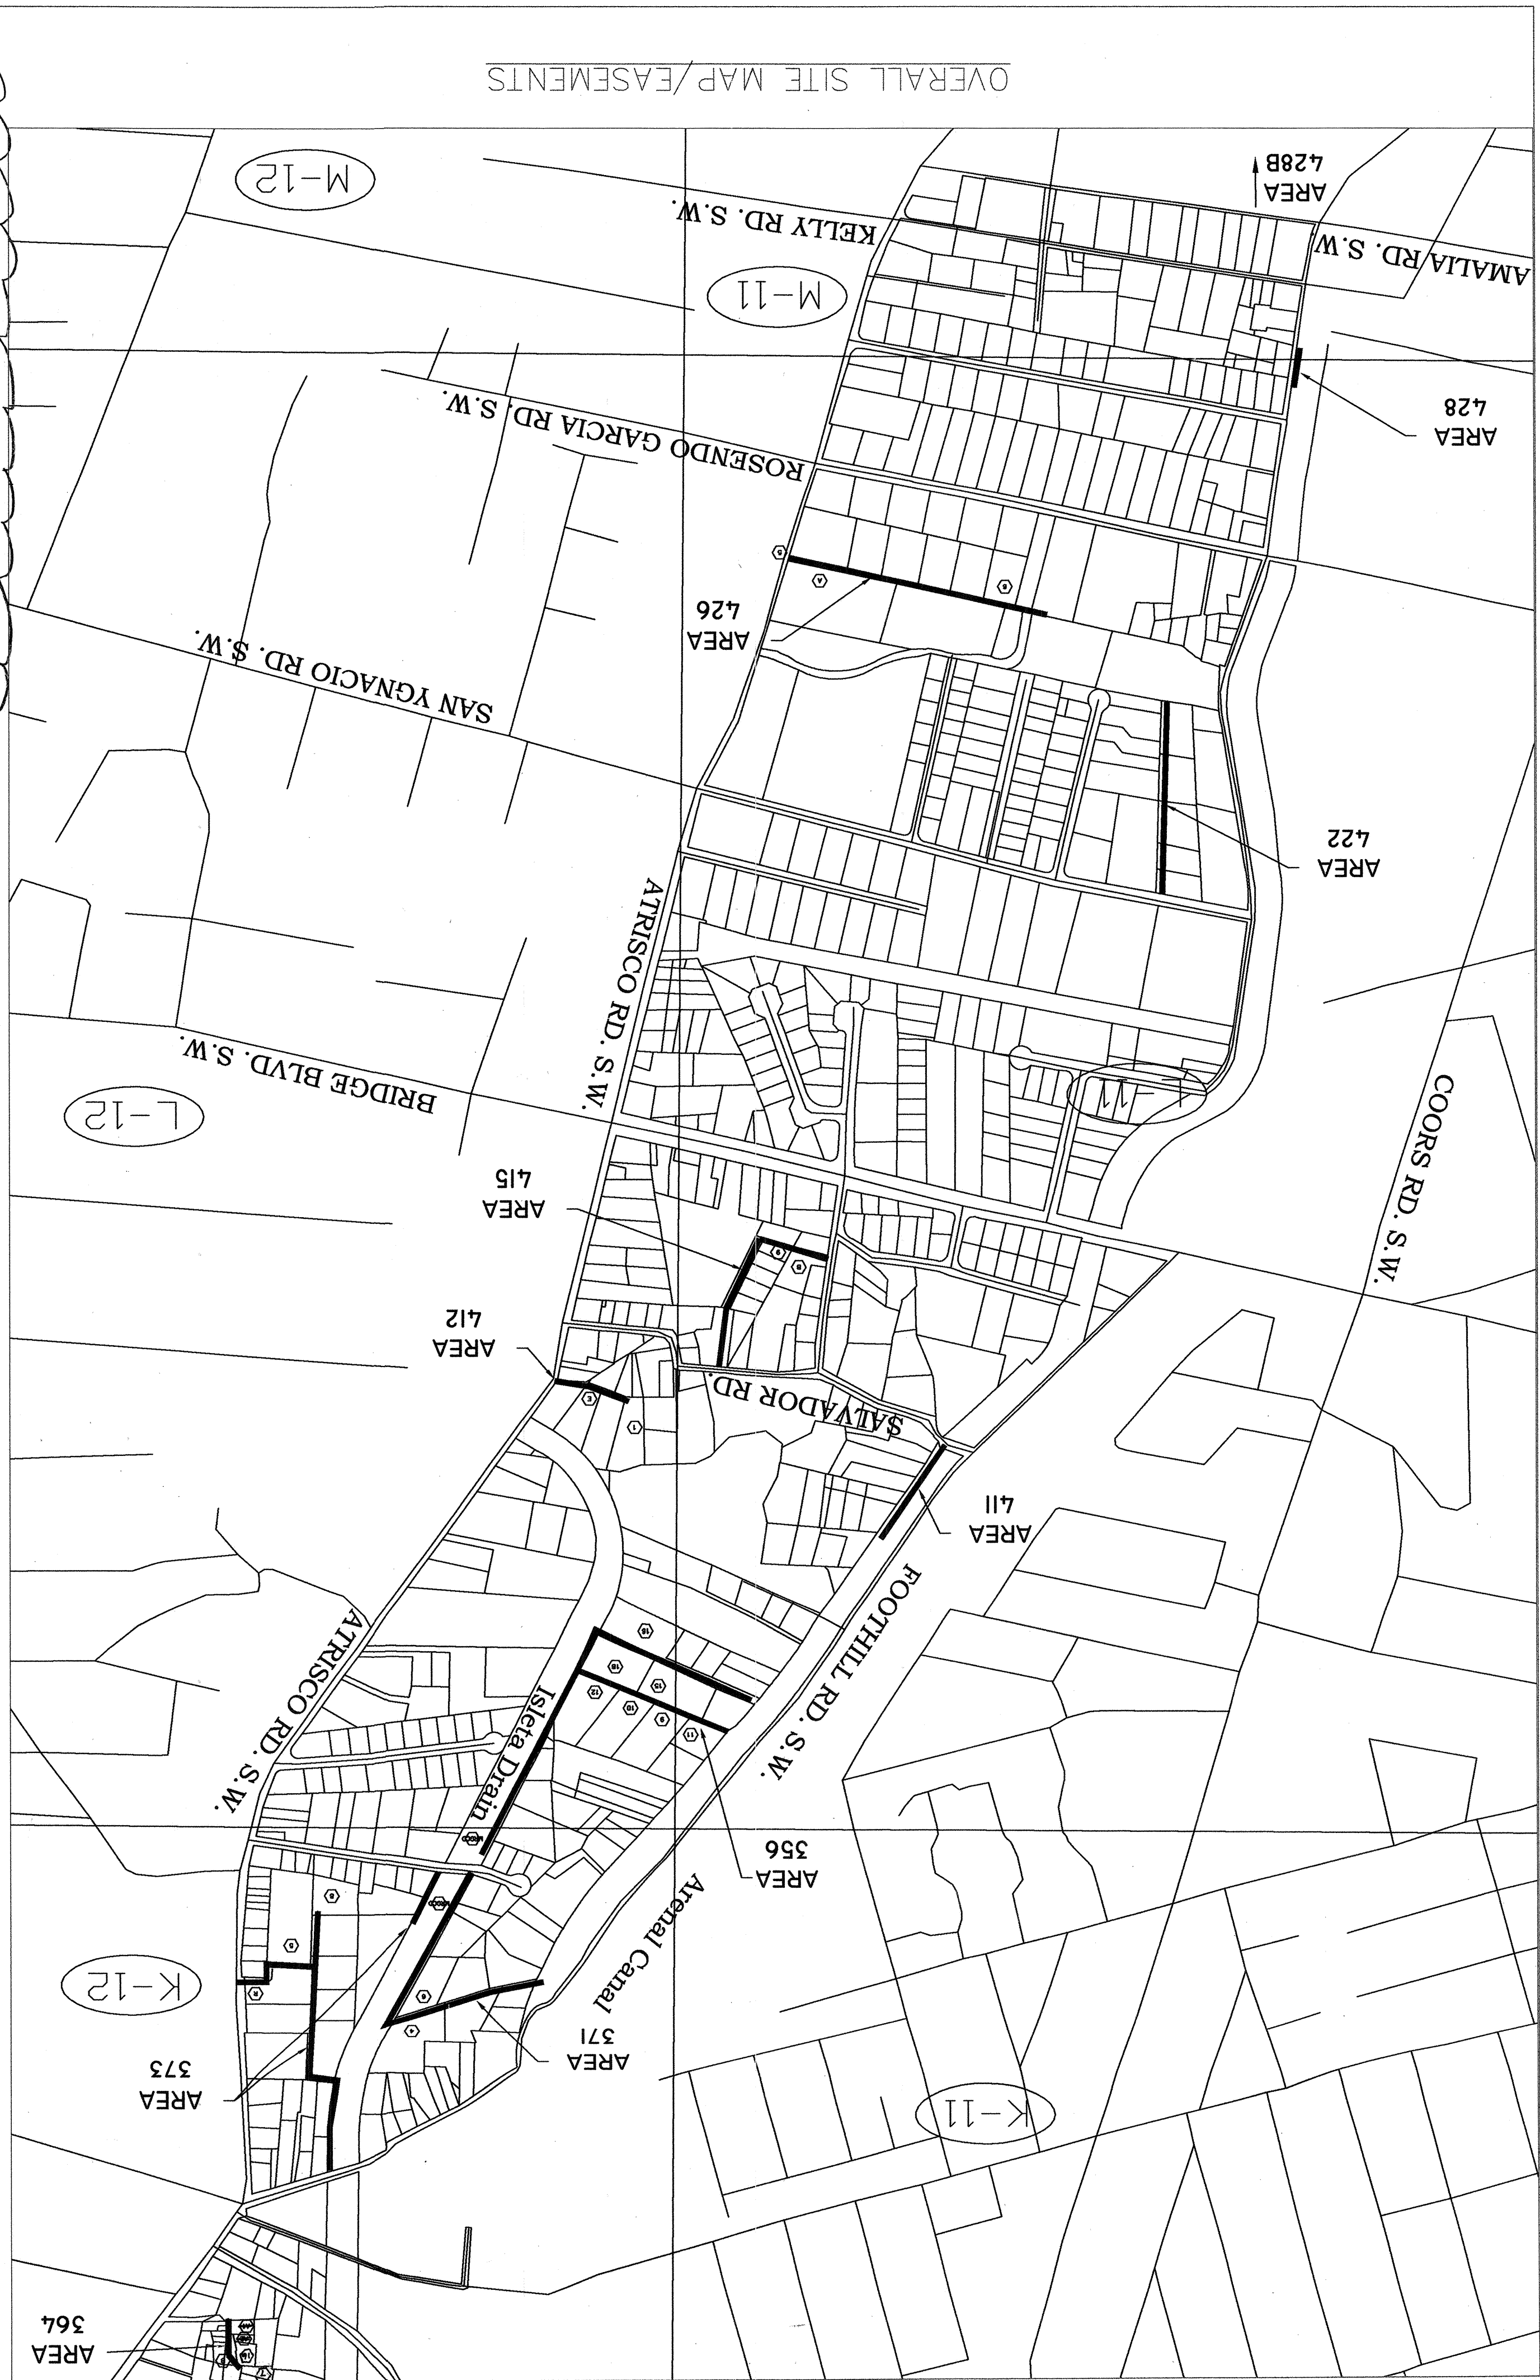

EASEMENT #	NAME	TYPE	WIDTH	VOLUME	FOLIO	DOCUMENT	BOOK	PAGE
368-9	HELEN & MABLE JARAMILLO	PUBLIC WATER & SEWER EASEMENT	12.5		2005029096	BK-A92	8987	
368-10	RAYMOND LEROY JARAMILLO	PUBLIC WATER & SEWER EASEMENT	12.5		2005029097	BK-A92	8988	
368-11	ALBERT T. & MARIANA SANDOVAL	PUBLIC WATER & SEWER EASEMENT	25		2005029098	BK-A92	8989	
368-12	JAMIE DOZAL & CELIA MARTINEZ	PUBLIC WATER & SEWER EASEMENT	25		2005029099	BK-A92	8990	
368-15	LAWRENCE & MARY JOE MARTINEZ	PUBLIC WATER & SEWER EASEMENT	12.5		2005029100	BK-A92	8991	
368-16	FRANK B. & BERTHA E. GURULE	PUBLIC WATER & SEWER EASEMENT	20		2005029102	BK-A92	8993	
368-18	BENNE & CHRISTINE MARTINEZ	PUBLIC WATER & SEWER EASEMENT	12.5		2005029101	BK-A92	8992	
368-44	TOM R. FORTH	LICENSE AGREEMENT			2005068102	BK-A16	7998	
364-42	FELIX & DOLORES LUCERO	PUBLIC WATER & SEWER EASEMENT	20		2006099329	BK-A19	9050	
364-B	LISA EDWINA GREGO	PUBLIC WATER & SEWER EASEMENT	20		2006110972	BK-A21	661	
371-4	RICHARD & EDITH C. ROMERO	PUBLIC WATER & SEWER EASEMENT	24		2006110972	BK-A21	661	
371-B	RICHARD & EDITH C. ROMERO	LICENSE AGREEMENT			2007046842	BK-134	6753	
371-MRGCD	ISLETA DRAIN MRGCD	PUBLIC WATER & SEWER EASEMENT	25		2004173889	BK-A88	3392	
373-8	LOURDES DUEÑAS	PUBLIC WATER & SEWER EASEMENT	25		2005029103	BK-A92	8994	
373-8	LOURDES DUEÑAS	LICENSE AGREEMENT			2007046843	BK-A134	6754	
373-R	CARLOTA ROAD	PLAT			1983-5796	VOL-988	PG-132	
412-E	ISLETA DRAIN MRGCD	LICENSE AGREEMENT	40		2007046843	BK-A134	6754	
412-1	CORINA T. BACA	SEWER EASEMENT	20		1995029962	BK-A85	76528	
415-B	JOE & MARGARET MARQUEZ	LETTER REFERENCES DGC ABOVE	20		2007073876	BK-A137	3723	
415-9	CLORINDA BARROS	LETTER (2)	20		2006061937	BK-A116	1744	
422	NIEVES T. BACA, JUAN HERRERA	PUBLIC WATER & SEWER EASEMENT	20		2007046843	BK-A134	6754	
426-5	COUNTY OF BERNALILLO	QUIT CLAIM DEED	12		2005153865	BK-A105	3433	
416-FIRE HYD	MARIA SAIZ	LETTER (3)	20		2007068939	BK-A136	8801	
373-4	DAVID JUAN SEDILLO	PUBLIC WATER & SEWER EASEMENT	25		200606056189	BK-A115	5071	
373-4	ALFONS & ANGELINA SAAYEDRA	PUBLIC WATER & SEWER EASEMENT	25		200603036594	BK-113	6469	
373-1	ALICE BALDONADO	PUBLIC WATER & SEWER EASEMENT	25		200603036596	BK-113	6469	
373-3	JESUS & JUANA TARANGO	PUBLIC WATER & SEWER ESM.T.	25		2007046844	BK-A134	6755	

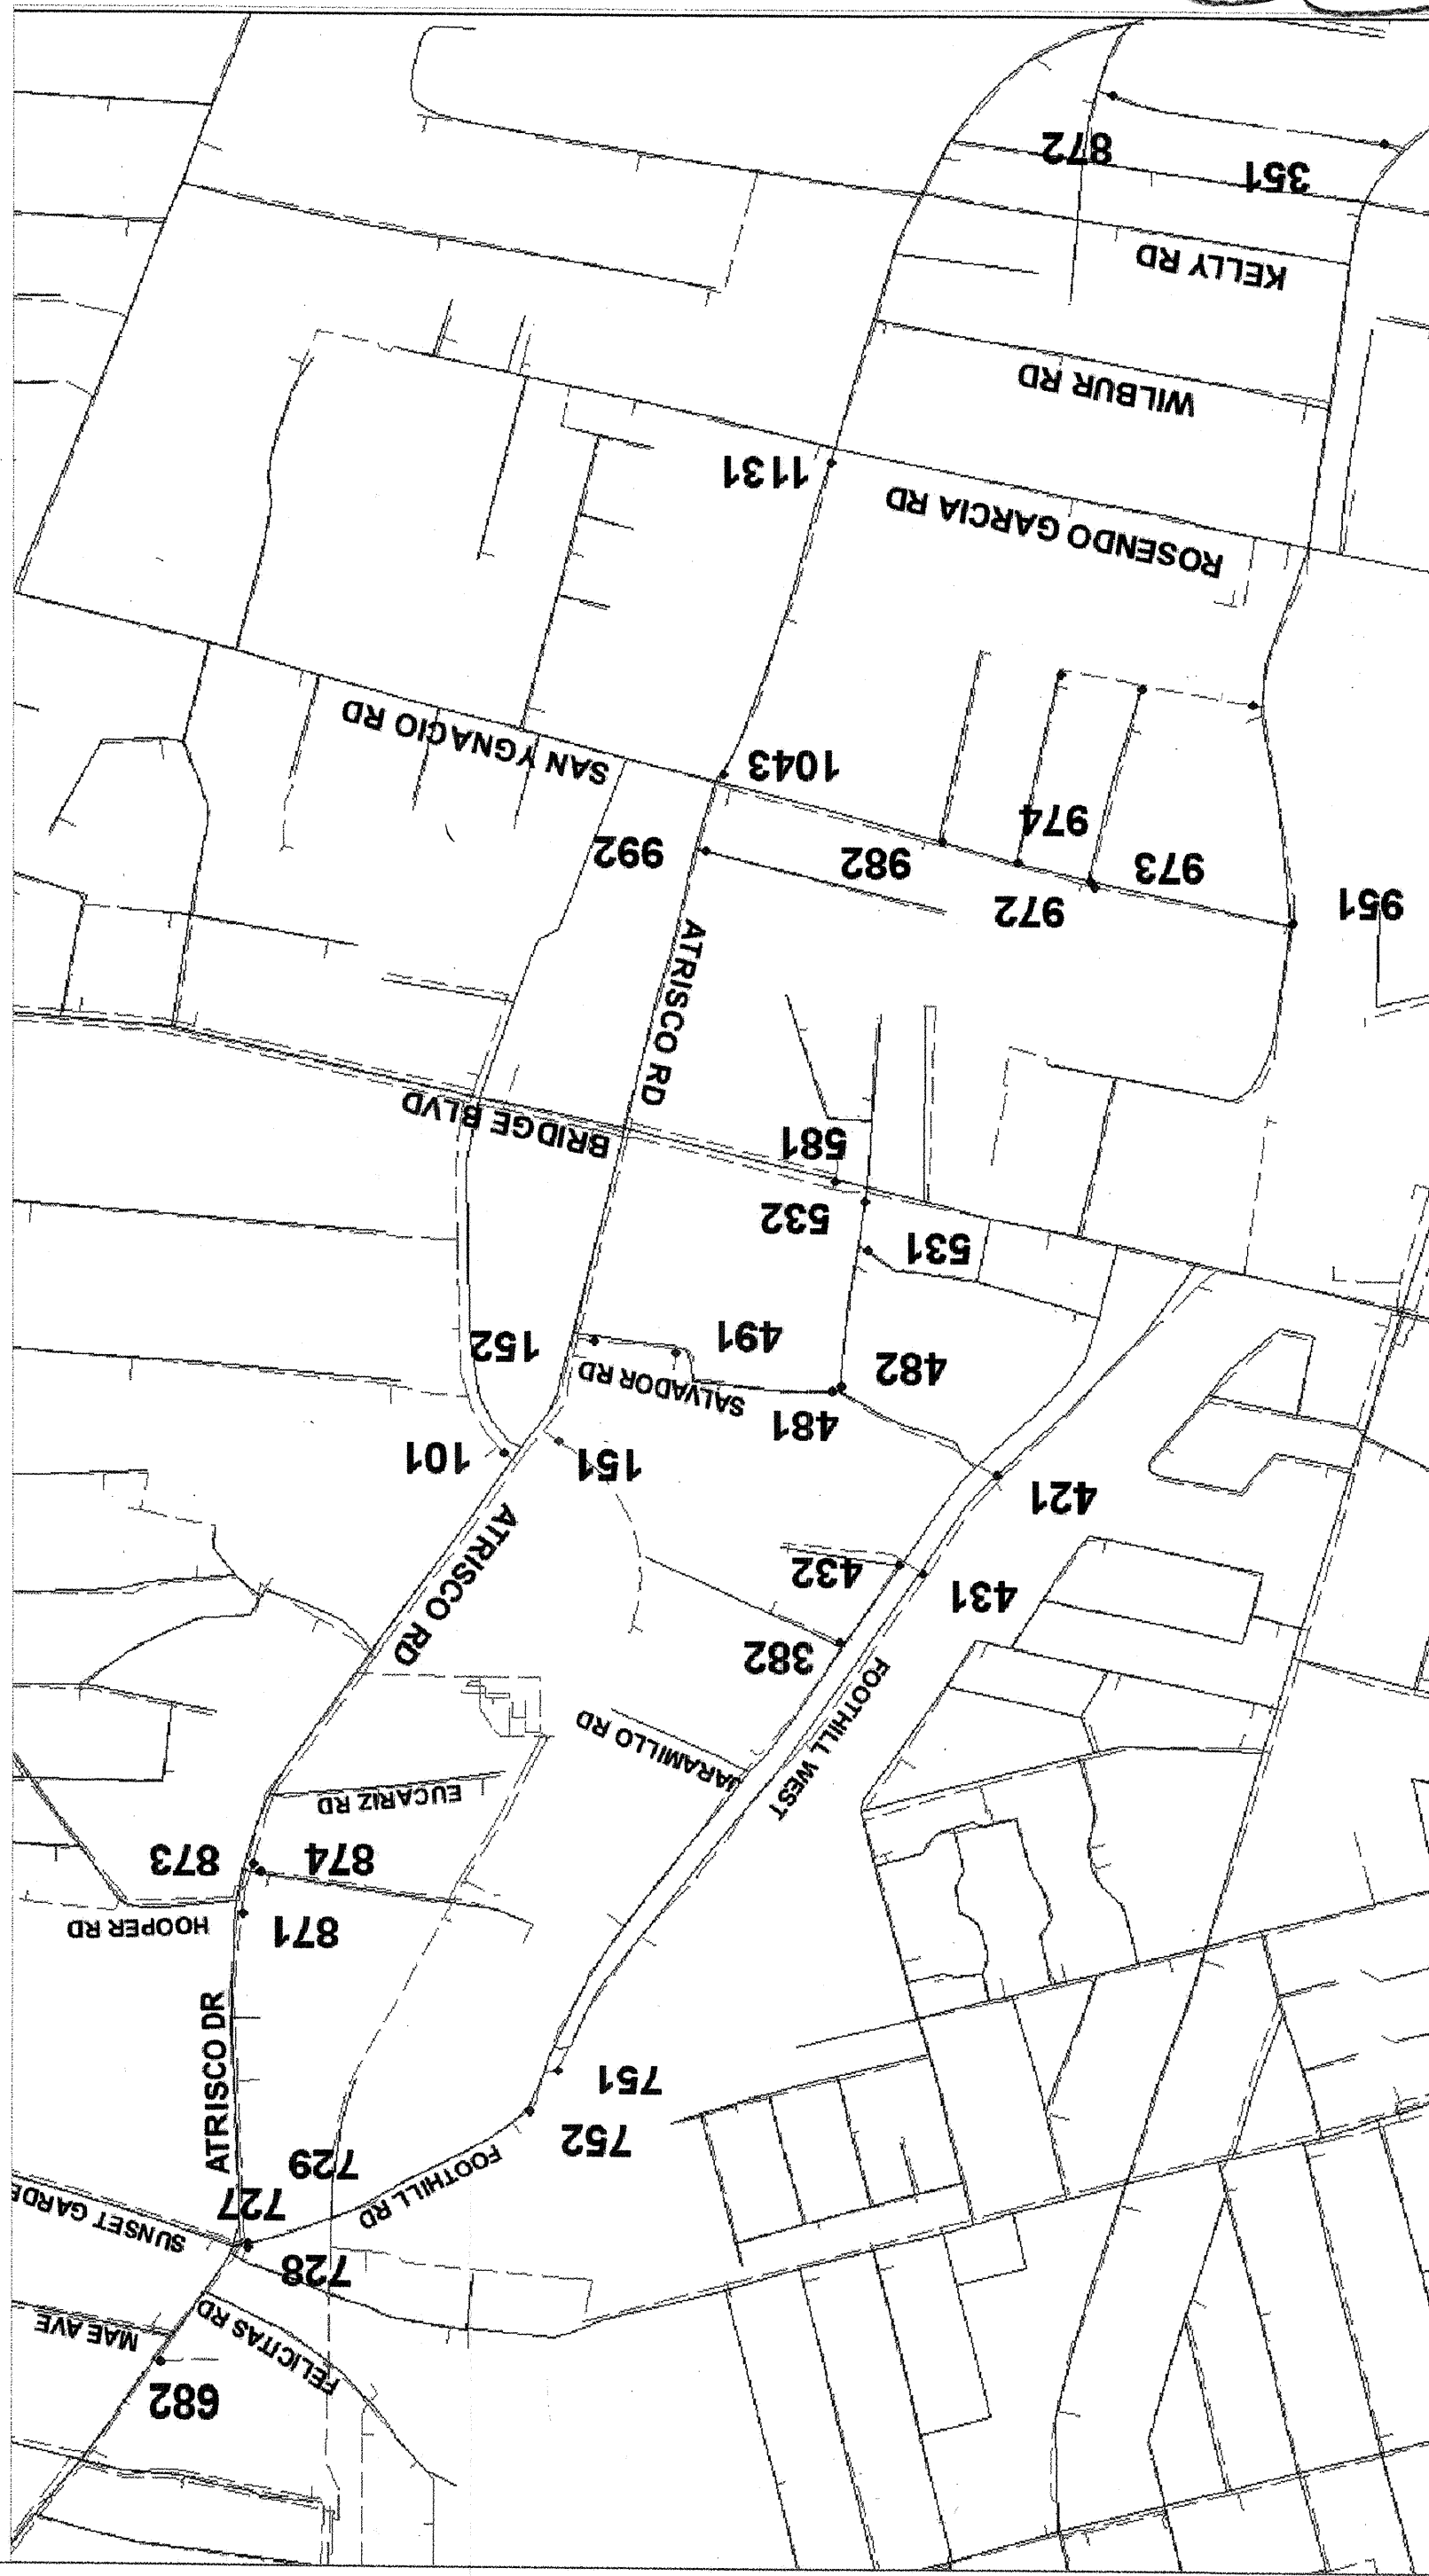

- LETTER REFERENCE INFORMATION
- ① PLAT 8613781, BK C29 PG.130
 - ② DDC # 200416007, BK-A86, PG.9632
 - ③ BK MISC-81, PG.619

BERNALILLO COUNTY
PUBLIC WORKS DIVISION
TECHNICAL SERVICES

FILE: FOOTHILL BRIDGE INFILL AREA SEWER AND WATER IMPROVEMENTS

OVERALL SITE MAP

Design Review Committee City Engineer Approval Mo./Day/Yr. Mo./Day/Yr.

Last Design Update

Zone Map No. K-12, L11 & L12

City Project No. 747881

County Project No. T501-20

Sheet 3 of 25

ENGINEER'S SEAL

DAVID E. BISHOP
Professional Engineer
No. 10000
Exp. 12/31/05

AS BUILT INFORMATION

CONTRACTOR

STARTED BY

DATE

INSPECTED BY

DATE

FIELD JUNE BY

DATE

VERIFICATION BY

DATE

CHECKED BY

DATE

REVISIONS

NO.

DATE

BY

REMARKS

AS BUILT

9/06

DESIGNED BY - NKB


DRAWN BY - PVL

CHECKED BY - DEB

DATE - 06/05

DATE - 06/05


DATE - 06/05

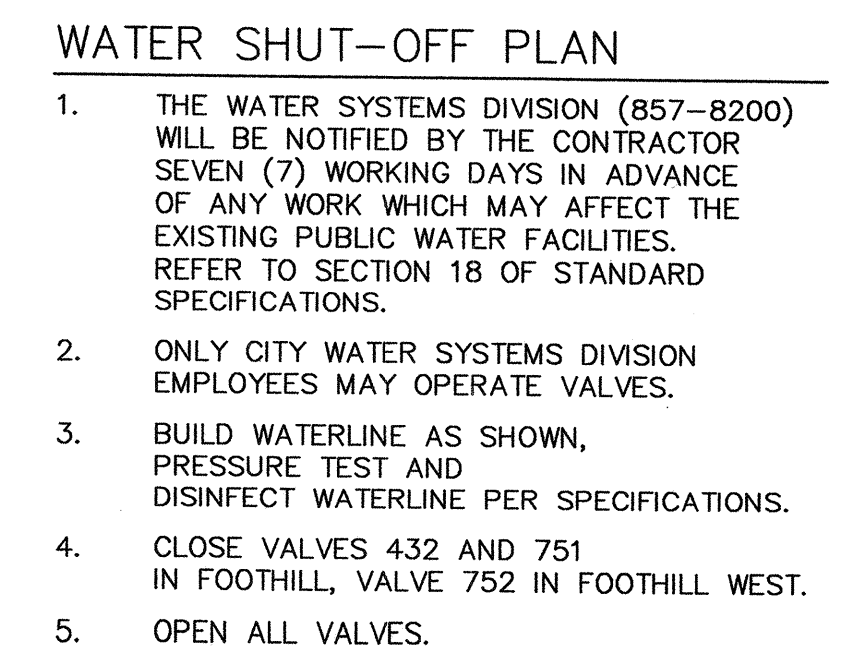

1. IF DITCH DISTURBED DURING CONSTRUCTION, IT MUST BE REPLACED TO ORIGINAL CONDITION.
2. EXTEND 8" LINE 10' SOUTH OF MANHOLE AND CAP.



SCALE: 1"=40'

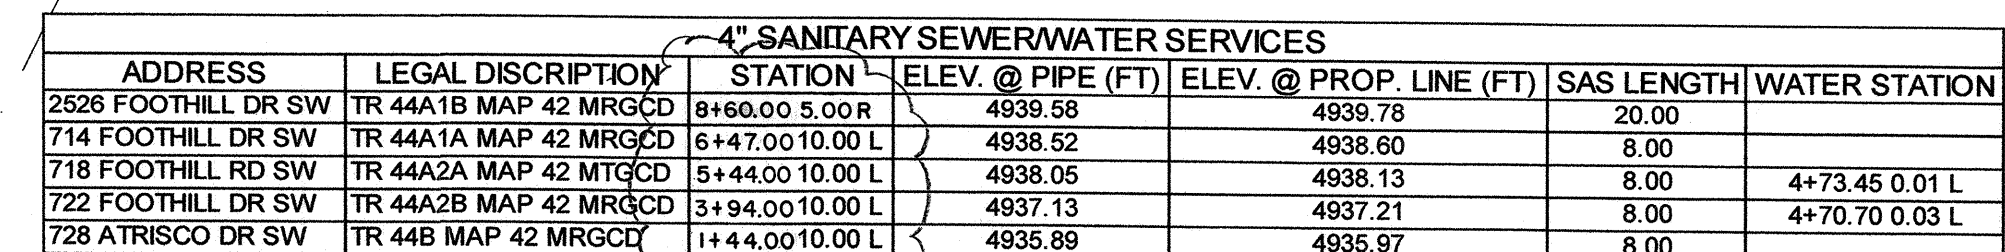

CONTROL POINT DATA TABLE (GROUND COORDINATES)				
POINT NAME	COUNTY PROJ #	NORTHING	EASTING	ELEVATION
AEC CP1	356	76,383.983	74,165.472	4944.362
AEC CP2	356	76,268.499	74,071.630	4944.996

MONUMENT DATA TABLE			
CITY MONUMENT	NORTHING	EASTING	ELEVATION
NM 45-4A	74,722.348	71,839.254	5003.016

1- ALL CONTROL POINTS ARE 2" ALUM CAP STAMPED AEC CP 1 OR 2.
2- COORDINATES ARE IN THE WGS 1984/NAD27 DATUM AND
ELEVATIONS ARE IN THE NGVD29 DATUM.






BERNALILLO COUNTY
PUBLIC WORKS DIVISION
TECHNICAL SERVICES

TITLE: FOOTHILL/BRIDGE INFILL AREA SEWER AND WATER IMPROVEMENTS
AREA 356 - PRIVATE ROAD #1

Design Review Committee	City Engineer Approval	Last Design Update	Mo./Day/Yr.	Mo./Day/Yr.
City Project No. 747881	Zone Map No. K-12, L11 & L12	Sheet 4	Of 25	
County Project No. TS01-20				


SCALE:
HORIZ: 1"=40'
VERT: 1"=4'

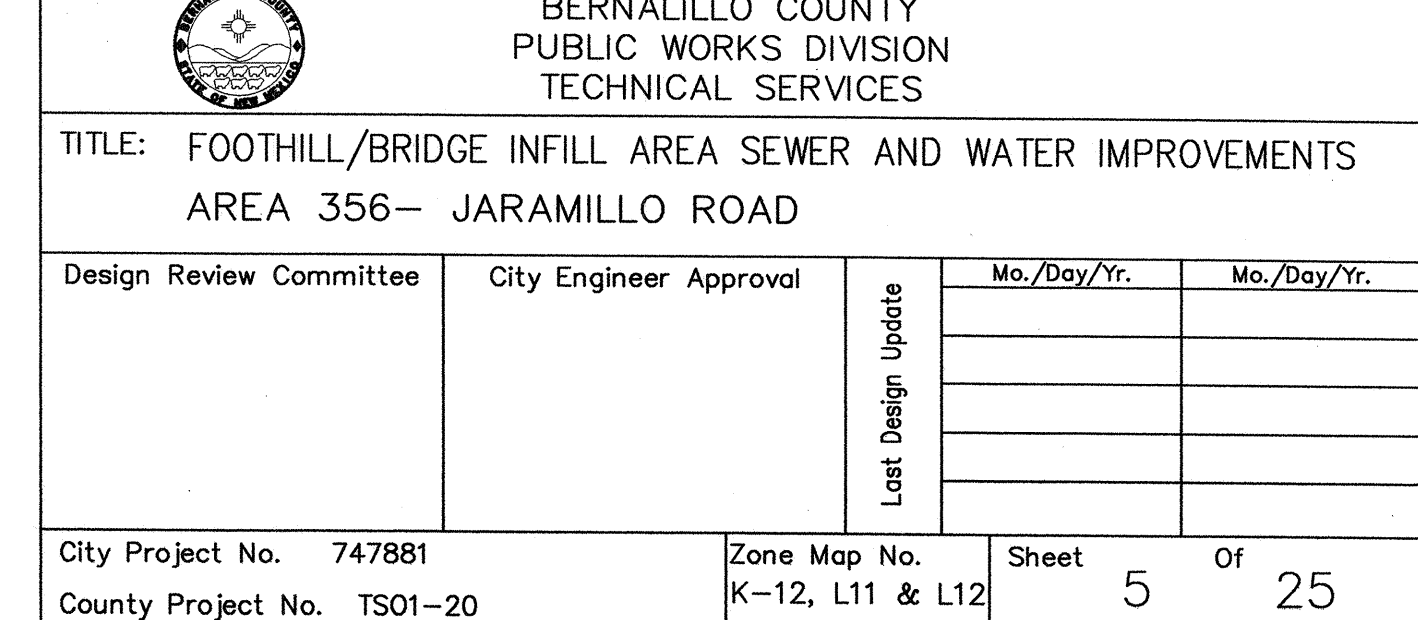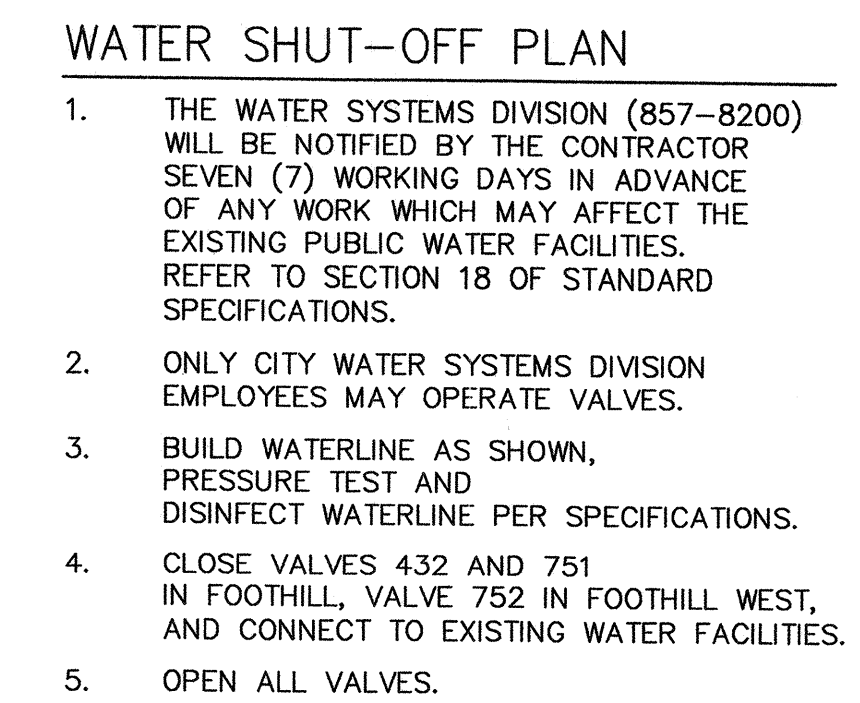

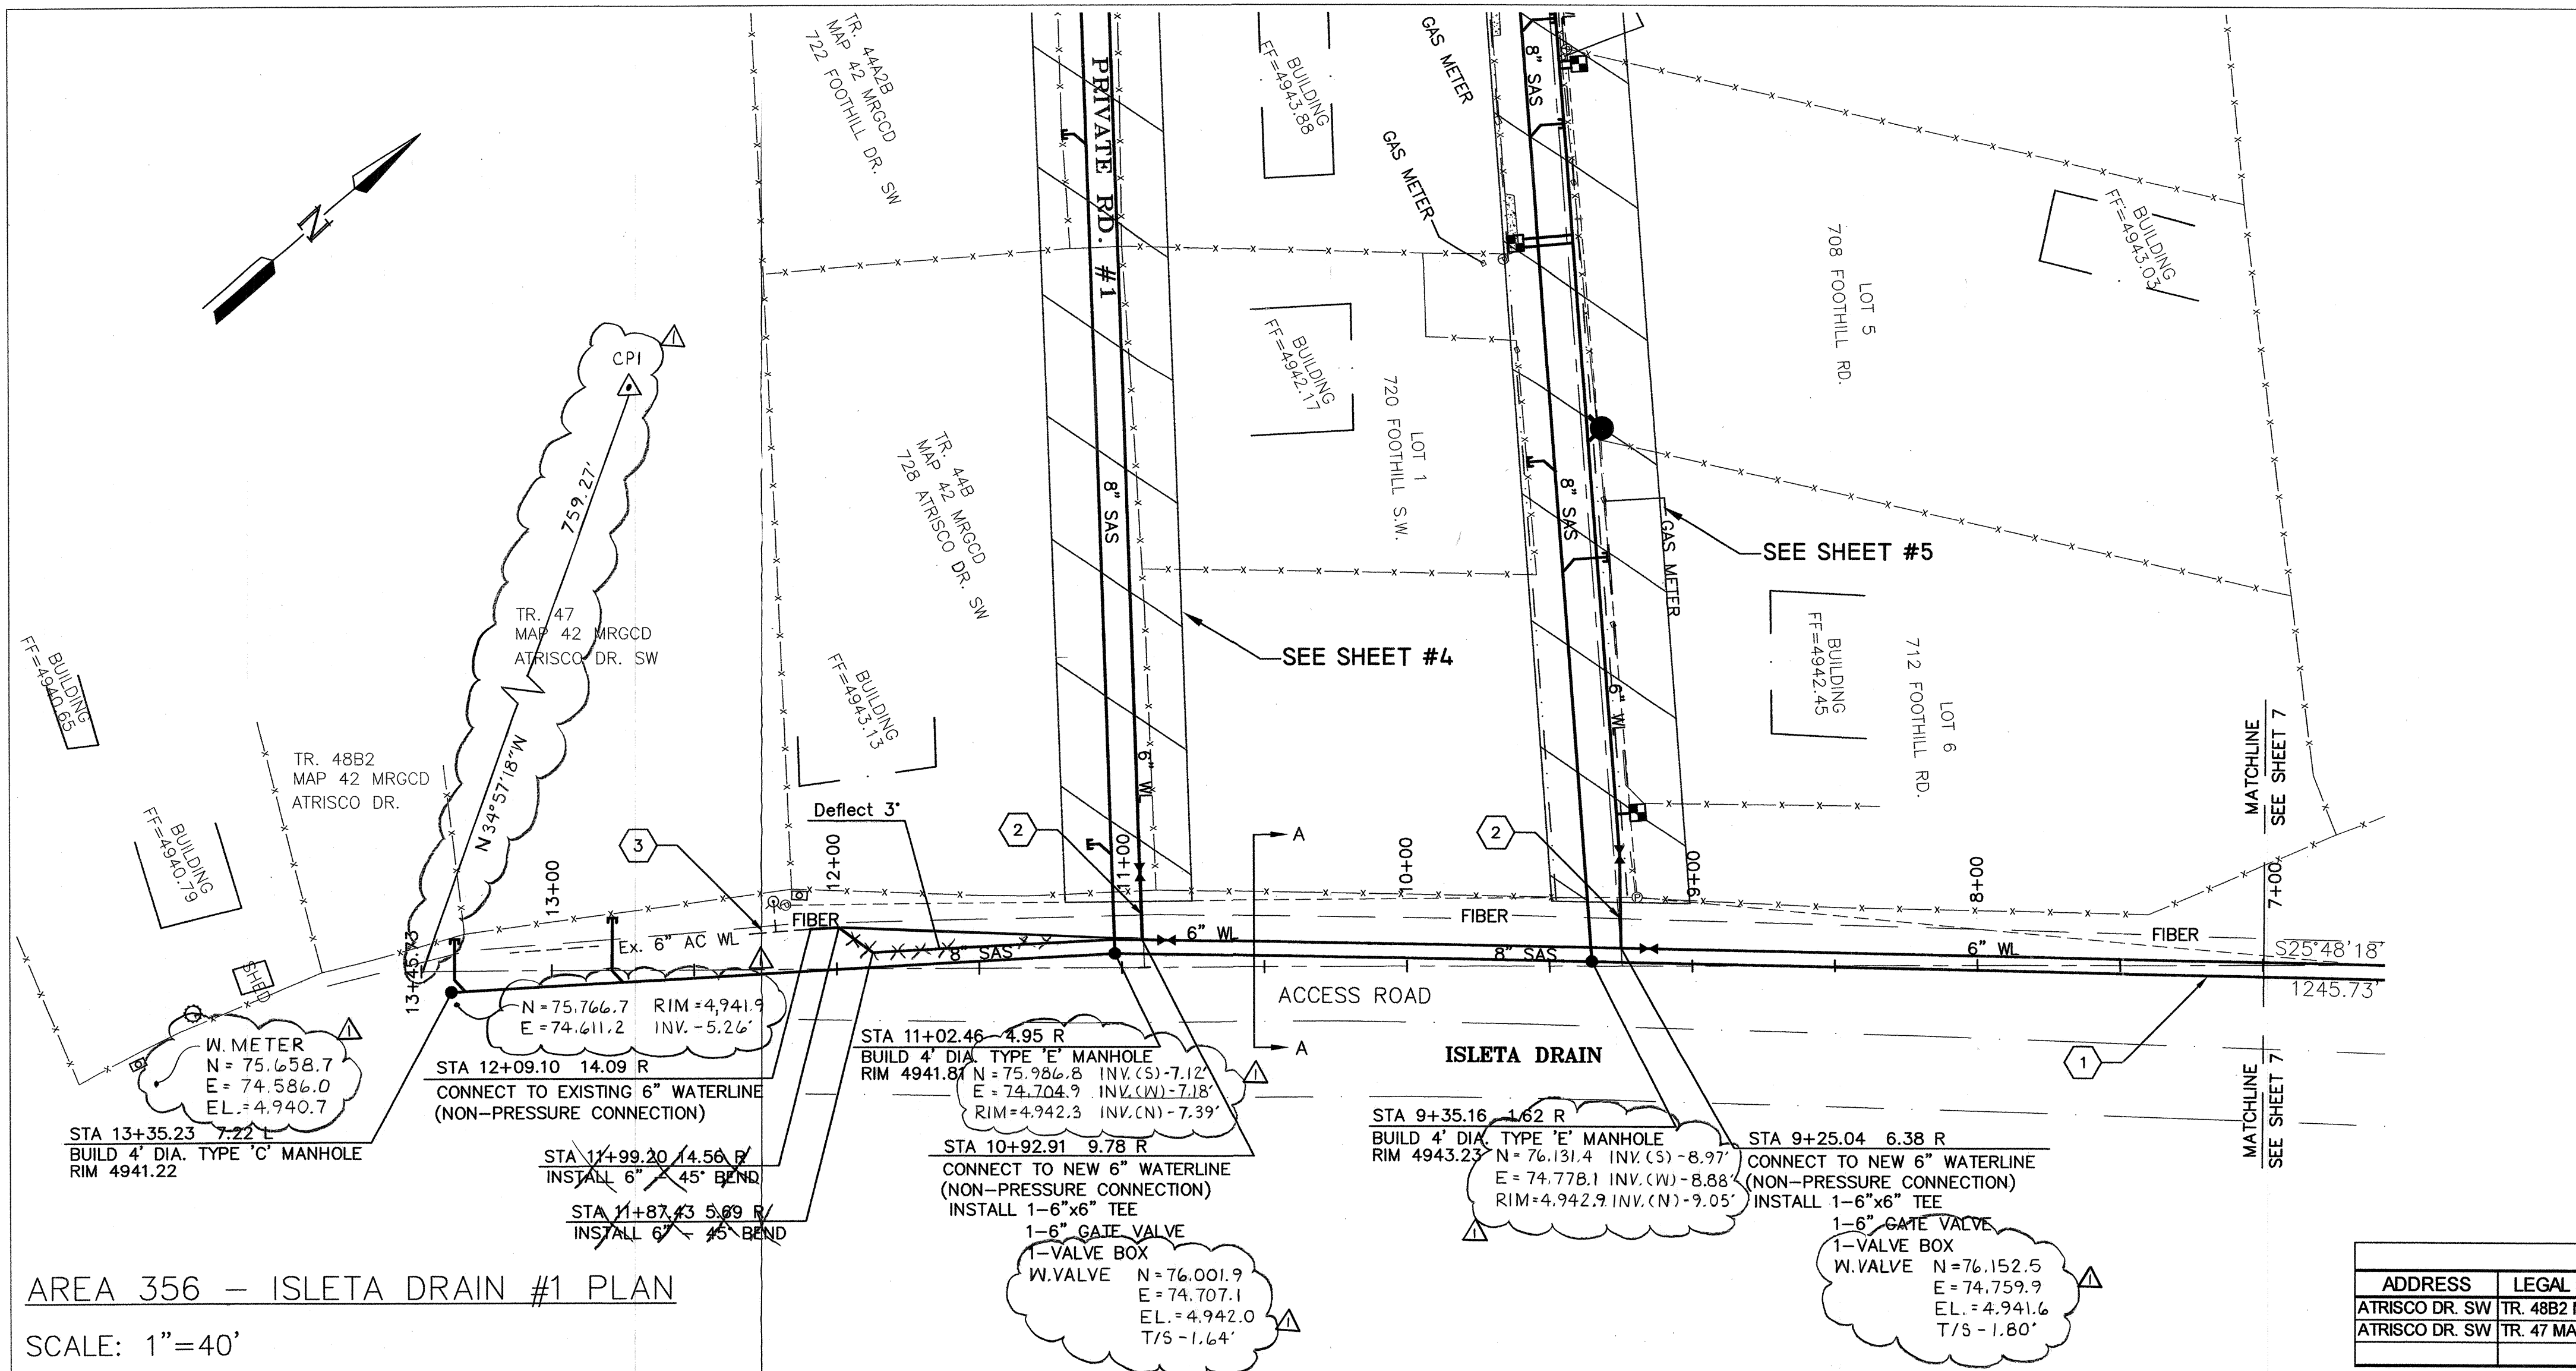

AREA 356 - ISLETA DRAIN #1 PLAN

SCALE: 1"=40'

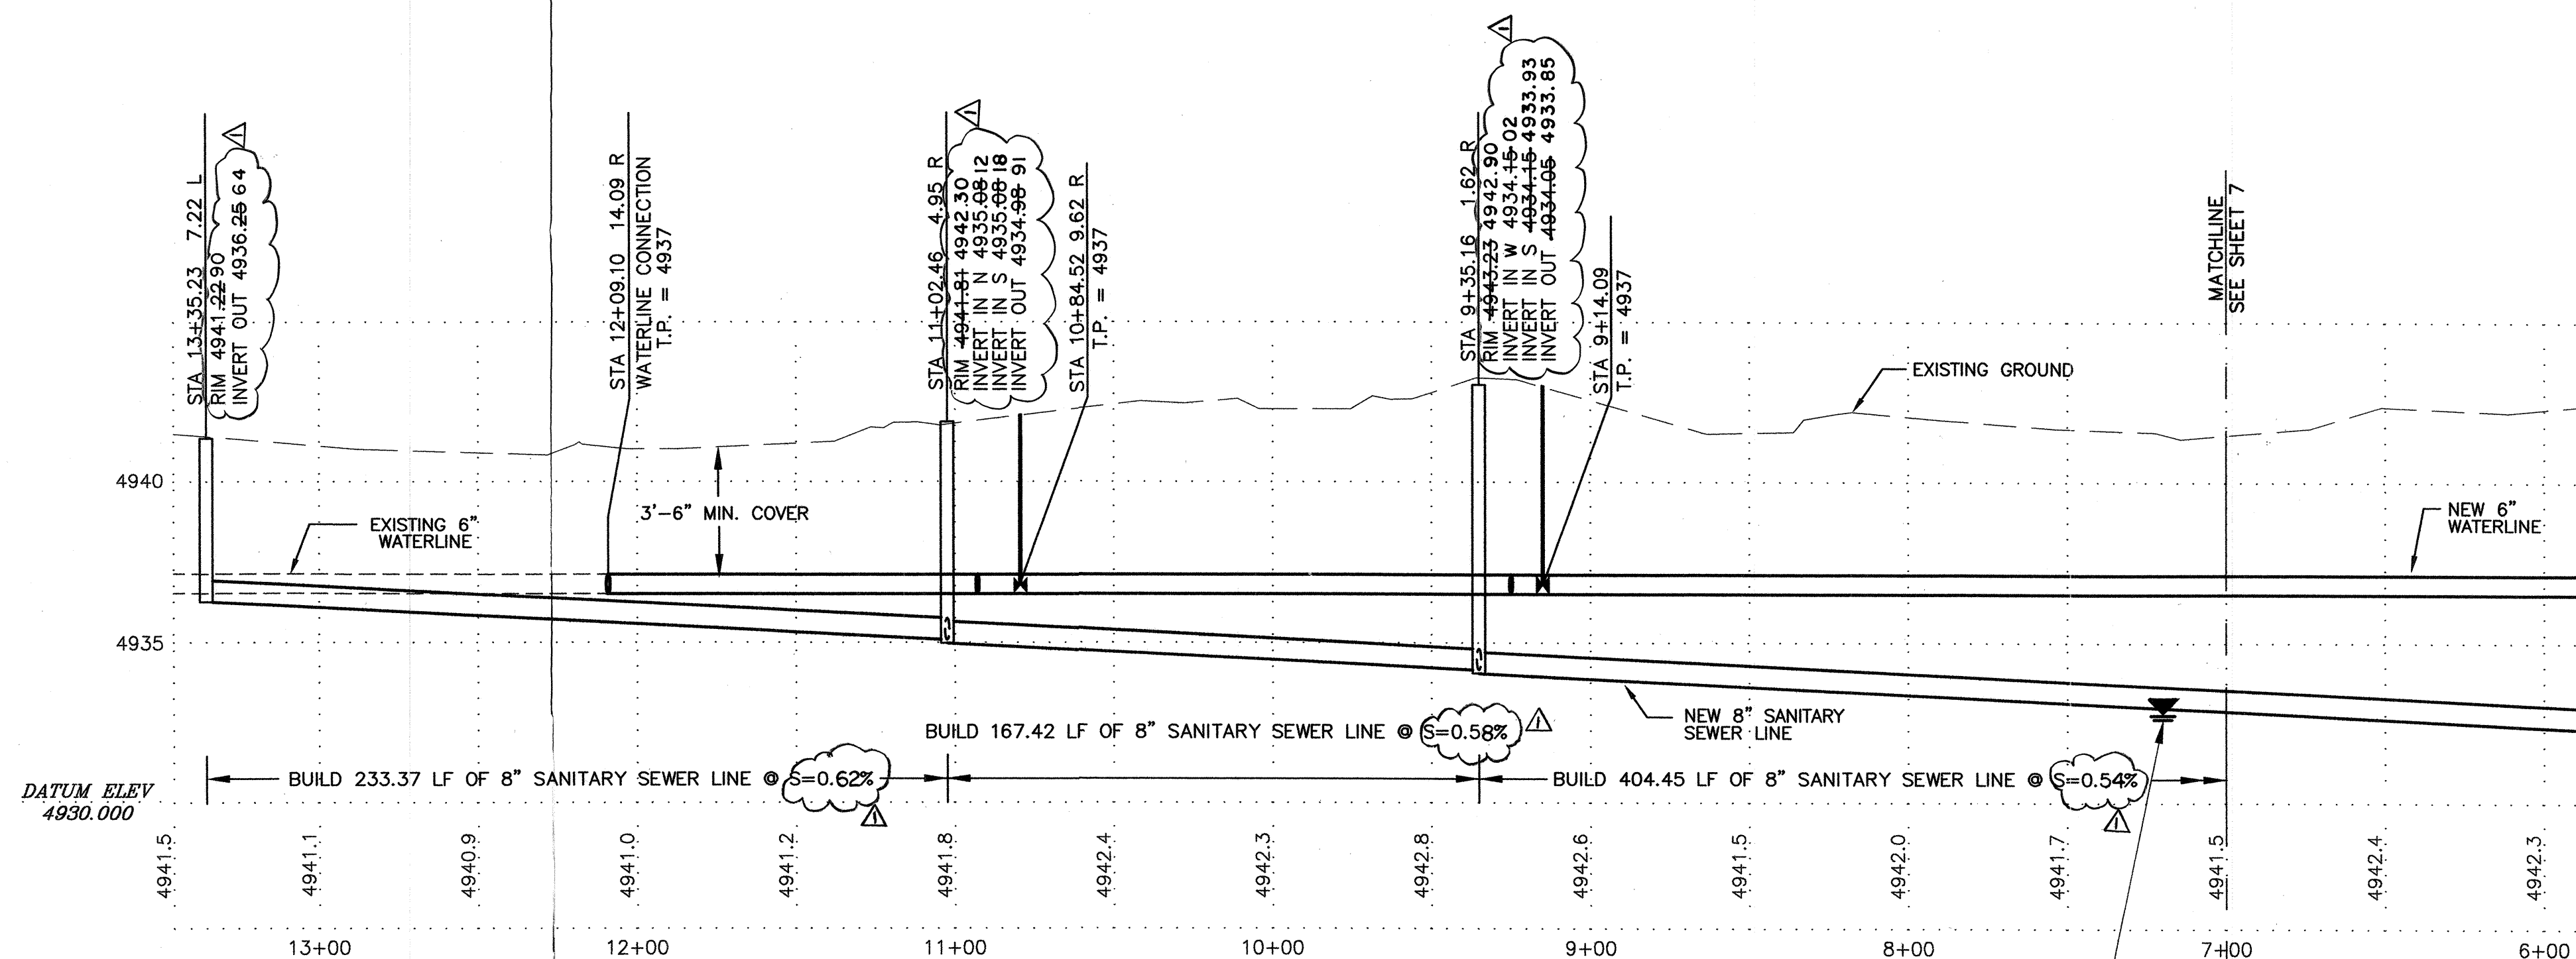

AREA 356 - ISLETA DRAIN #1 PROFILE


SCALE:
HORIZ: 1"=40'
VERT: 1"=4'

WATER SHUT-OFF PLAN

1. THE WATER SYSTEMS DIVISION (857-8200) WILL BE NOTIFIED BY THE CONTRACTOR SEVEN (7) WORKING DAYS IN ADVANCE OF ANY WORK WHICH MAY AFFECT THE EXISTING PUBLIC WATER FACILITIES. REFER TO SECTION 18 OF STANDARD SPECIFICATIONS.
2. ONLY CITY WATER SYSTEMS DIVISION EMPLOYEES MAY OPERATE VALVES.
3. BUILD WATERLINE AS SHOWN, PRESSURE TEST AND DISINFECT WATERLINE PER SPECIFICATIONS.
4. CLOSE VALVE 151 IN ISLETA DRAIN AND CONNECT TO EXISTING WATER FACILITIES.
5. OPEN ALL VALVES.

CONSTRUCTION NOTES

1. SEWER PIPE FROM STA 7+00 TO STA 13+35.49 SHALL BE PRESSURE RATED (125 psi) PLASTIC PIPE AND BE PRESSURE TESTED TO ASSURE WATER TIGHTNESS.
2. MUST CALL AT&T IF WITHIN 2' OF FIBER OPTIC (AMOS WILSON 362-2743).
3. APPROXIMATE WATERLINE LOCATION (REPEAT OF GEN. NOTE #4).

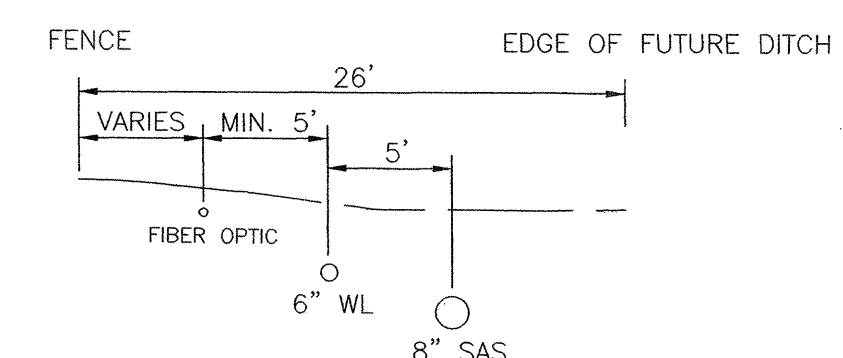

SECTION A - A

NTS: PUBLIC EASEMENT VARIES

4" SANITARY SEWER SERVICES						
ADDRESS	LEGAL DISCRPTION	STATION	ELEV. @ PIPE (FT)	ELEV. @ PROP. LINE (FT)	SAS LENGTH	WATER STATION
ATRISCO DR. SW TR. 48B2 MAP 42 MRGCD		13+22 2.23 L	4936.91	4937.21	18.0'	
ATRISCO DR. SW TR. 47 MAP 42 MRGCD		12+62 0.92 R	4936.62	4936.92	22.0'	

CONTROL POINT DATA TABLE (GROUND COORDINATES)				
POINT NAME	COUNTY PROJ #	NORTHING	EASTING	ELEVATION
AEC CP1	356	76,383.983	74,165.472	4944.362
AEC CP2	356	76,268.499	74,071.630	4944.996

MONUMENT DATA TABLE			
CITY MONUMENT	NORTHING	EASTING	ELEVATION
NM 45-4A	74,722.348	71,839.254	5003.016

- 1- ALL CONTROL POINTS ARE 2" ALUM CAP STAMPED AEC CP 1 OR 2
- 2- COORDINATES ARE IN THE WGS 1984/NAD27 DATUM AND ELEVATIONS ARE IN THE NGVD29 DATUM.

		TITLE: FOOTHILL/BRIDGE INFILL AREA SEWER AND WATER IMPROVEMENTS AREA 356 - ISLETA DRAIN #1	
		Design Review Committee	City Engineer Approval
City Project No. 747881 County Project No. TS01-20	Zone Map No. K-12, L11 & L12	Sheet 6 Of 25	Mo./Day/Yr.
			Mo./Day/Yr.
Last Design Update		DATE - 06/05	DATE - 06/05
DESIGNED BY - NKB		DATE - 06/05	DATE - 06/05
DRAWN BY - PVL		DATE - 06/05	DATE - 06/05
CHECKED BY - DEB		DATE - 06/05	DATE - 06/05


AS BUILT INFORMATION		BENCH MARKS		SURVEY INFORMATION		ENGINEER'S SEAL	
CONTRACTOR	NM UNDERGROUND	NO.	DATE	NO.	DATE	NO.	DATE
INSPECTOR	ALB SURVEYING CODE 12/05	NO.	DATE	NO.	DATE	NO.	DATE
ACCEPTANCE BY	BCPW	NO.	DATE	NO.	DATE	NO.	DATE
VERIFICATION BY	BCPW	NO.	DATE	NO.	DATE	NO.	DATE
DESIGNED BY	BCPW	NO.	DATE	NO.	DATE	NO.	DATE
DRAWN BY	BCPW	NO.	DATE	NO.	DATE	NO.	DATE
RECORDED BY	BCPW	NO.	DATE	NO.	DATE	NO.	DATE
MICRO-FILM INFORMATION		PLANE COORDINATES:		X - 365169.46		Y - 1480226.55	

AREA 356 - ISLETA DRAIN #2 PLAN

SCALE: 1"=40'

AREA 356 - ISLETA DRAIN #2 PROFILE

SCALE:
HORIZ: 1"=40'
VERT: 1"=4'

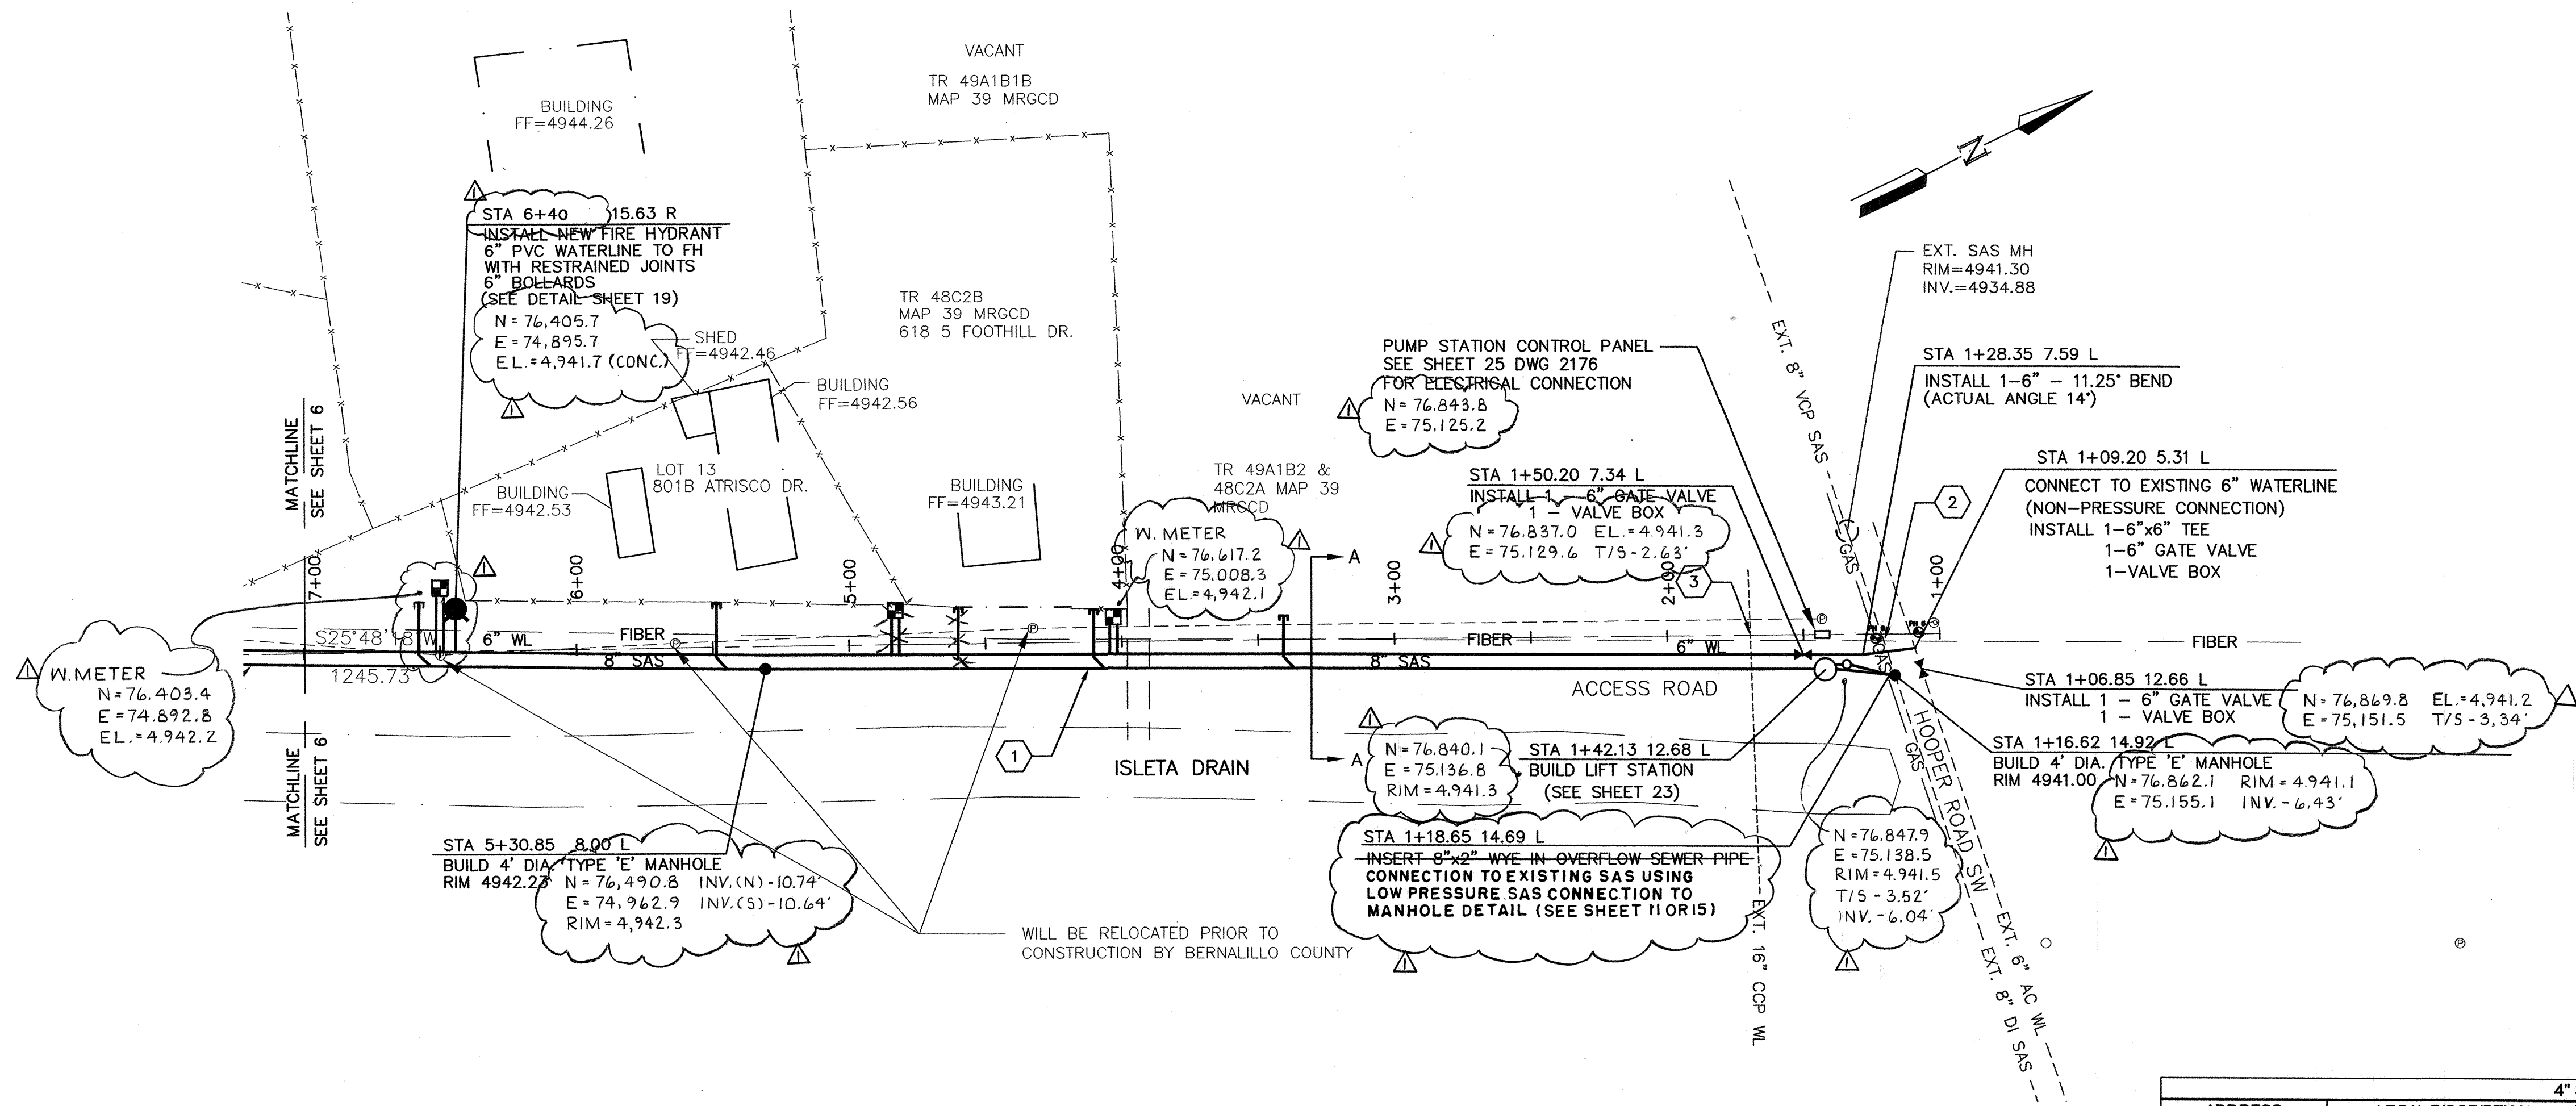


WATER SHUT-OFF PLAN

1. THE WATER SYSTEMS DIVISION (857-8200) WILL BE NOTIFIED BY THE CONTRACTOR SEVEN (7) WORKING DAYS IN ADVANCE OF ANY WORK WHICH MAY AFFECT THE EXISTING PUBLIC WATER FACILITIES. REFER TO SECTION 18 OF STANDARD SPECIFICATIONS.
2. ONLY CITY WATER SYSTEMS DIVISION EMPLOYEES MAY OPERATE VALVES.
3. BUILD WATERLINE AS SHOWN, PRESSURE TEST AND DISINFECT WATERLINE PER SPECIFICATIONS.
4. CLOSE VALVES 432 AND 751 IN FOOTHILL, VALVE 752 IN FOOTHILL WEST, VALVE 151 IN ISLETA DRAIN, VALVE 874 IN HOOPER, AND CONNECT TO EXISTING WATER FACILITIES.
5. OPEN ALL VALVES.


CONSTRUCTION NOTES

1. SEWER PIPE FROM STA 7+00 TO STA 1+42.13 SHALL BE PRESSURE RATED (125 ps) PLASTIC PIPE AND BE PRESSURE TESTED TO ASSURE WATER TIGHTNESS.
2. APPROXIMATE LOCATION WHERE EXISTING 8" SAS CHANGES FROM VCP TO DI.
3. APPROXIMATE WATERLINE LOCATION (REPEAT OF GEN. NOTE #4).

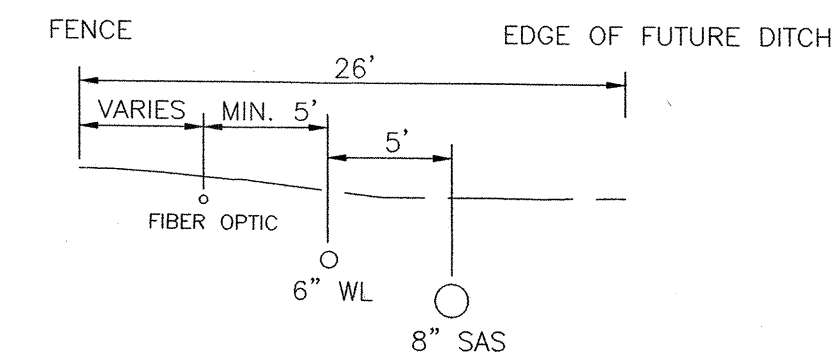

SECTION A - A
NTS: PUBLIC EASEMENT VARIES

4" SANITARY SEWER / WATER SERVICES							
ADDRESS	LEGAL DISCRIPTION	STATION	ELEV. @ PIPE (FT)	ELEV. @ PROP. LINE (FT)	SAS LENGTH	WATER STATION	
801 B ATRISCO DR SW	013 ROBERT I GRIEGO ADDN NO 2A	5+53 2.67 L	4932.76	4933.00	24.00	6+34	126 L
618 S FOOTHILL RD SW	TR48C2B MRGCD MAP 39	4+07 8.85 L	4932.19	4932.41	22.00	3+93	141 L
VACANT	TR49A1B1B MRGCD MAP 39	6+52 9.42 L	4931.97	4932.18	21.00	3+93	
VACANT	TR 49A1B2 & 48C2A	3+02 10.21 L	4931.19	4931.36	17.00	6+34	

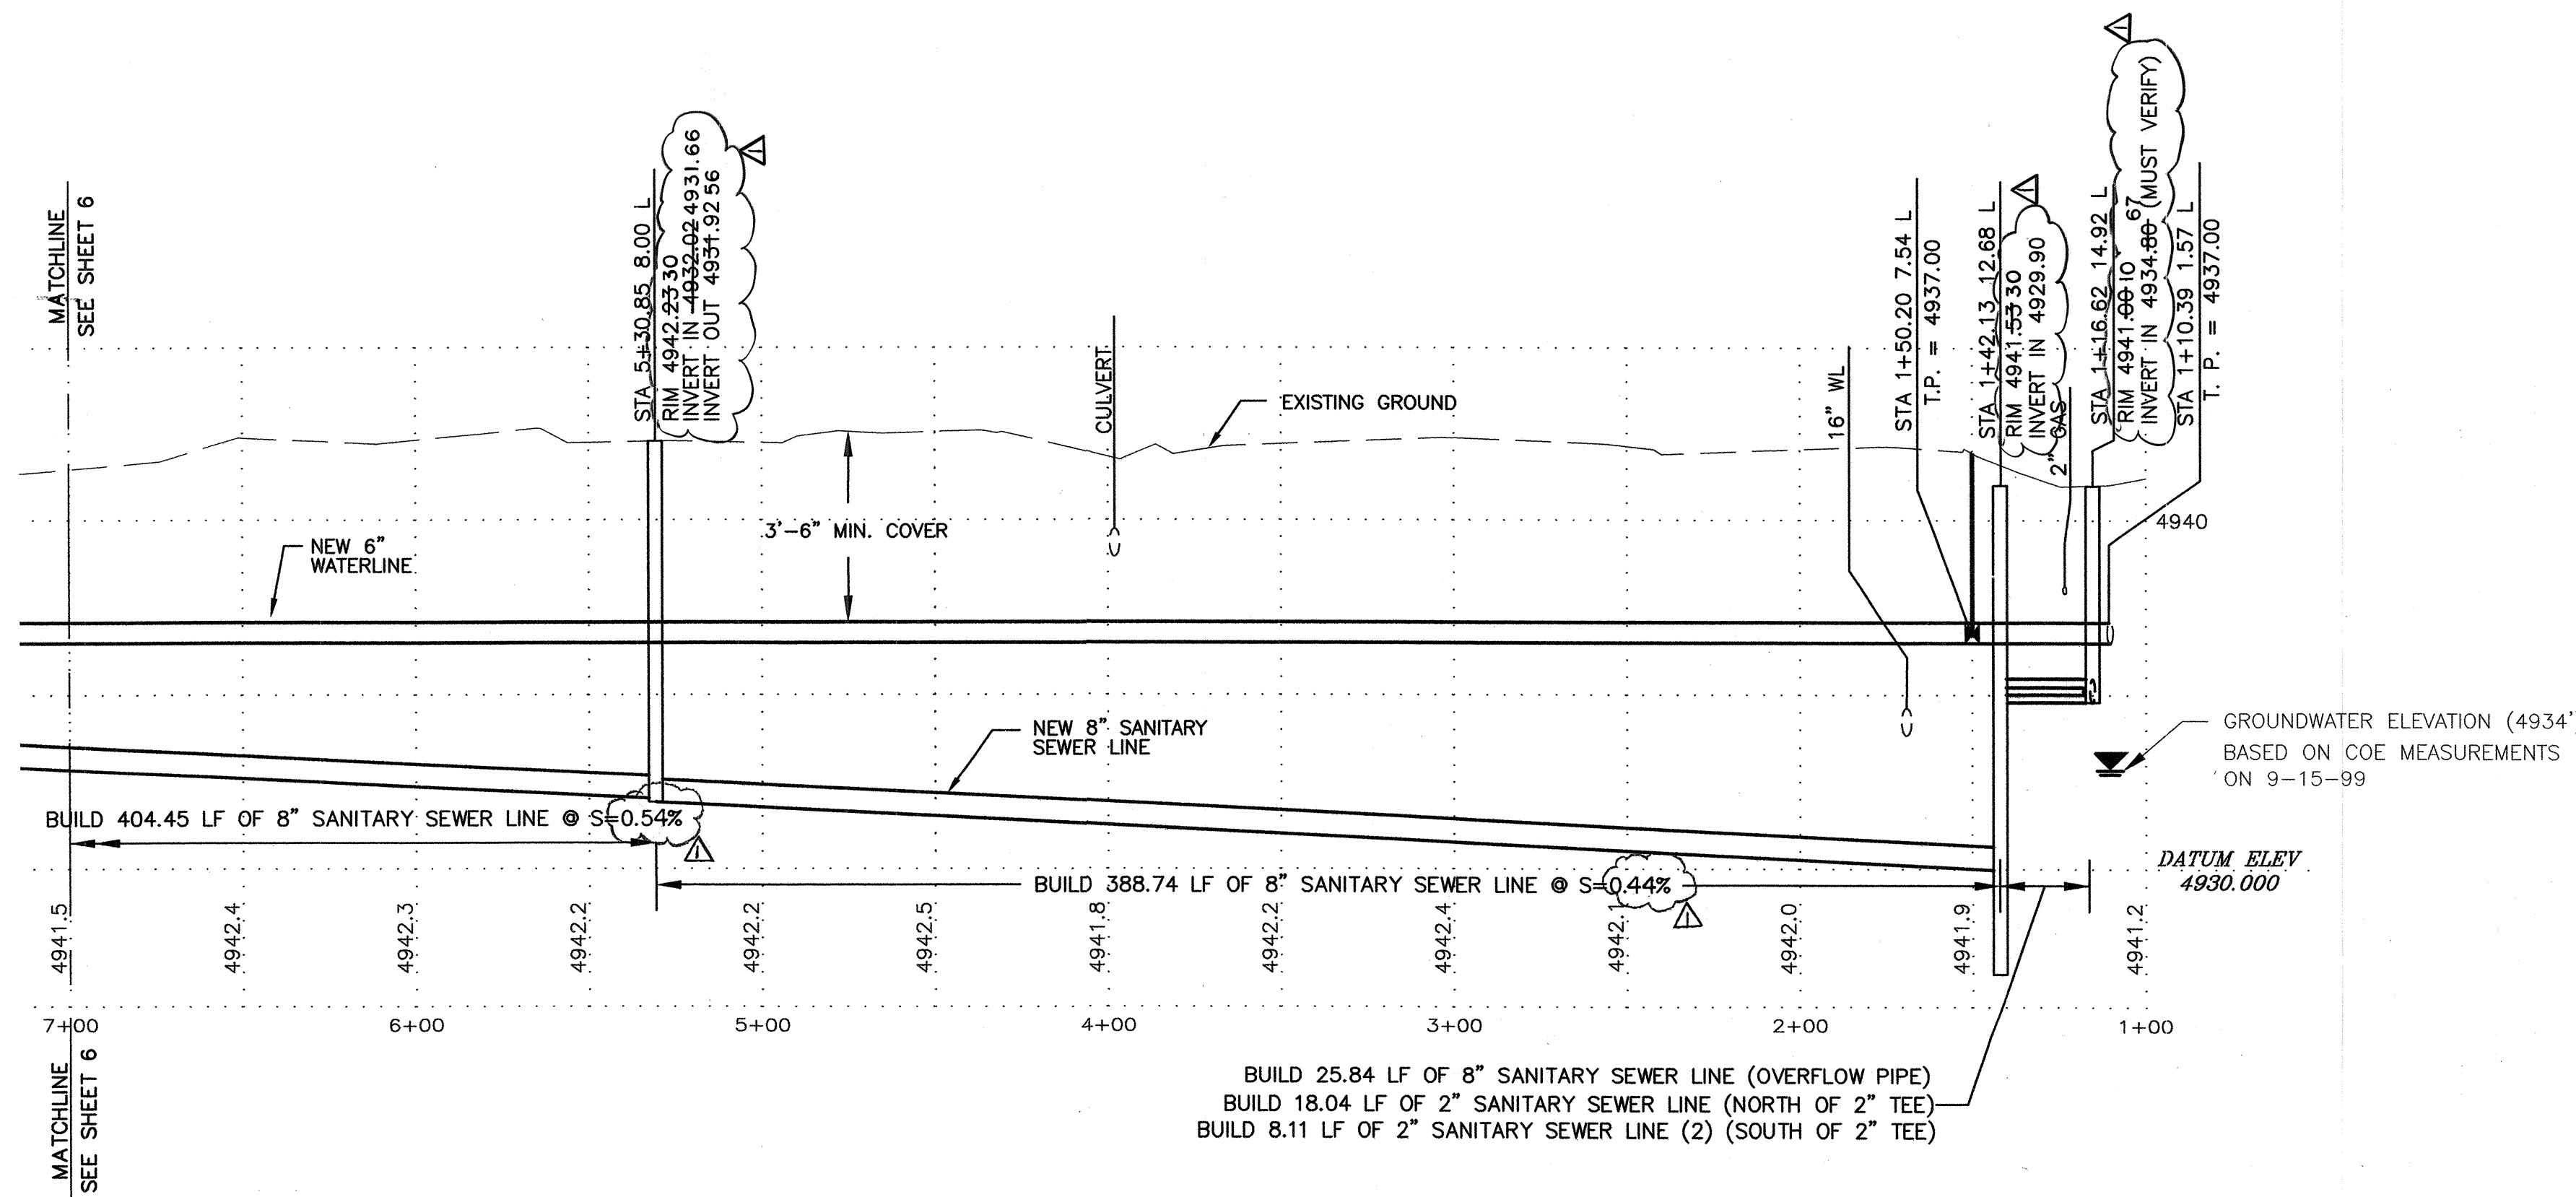


CONTROL POINT DATA TABLE (GROUND COORDINATES)				
POINT NAME	COUNTY PROJ #	NORTHING	EASTING	ELEVATION
AEC CP1	356	76,383.983	74,165.472	4944.362
AEC CP2	356	76,268.499	74,071.630	4944.996

MONUMENT DATA TABLE			
CITY MONUMENT	NORTHING	EASTING	ELEVATION
NM 45-4A	74,722.348	71,839.254	5003.016

- 1- ALL CONTROL POINTS ARE 2" ALUM CAP STAMPED AEC CP 1 OR 2.
- 2- COORDINATES ARE IN THE WGS 1984/NAD27 DATUM AND ELEVATIONS ARE IN THE NGVD29 DATUM.

		BERNALILLO COUNTY PUBLIC WORKS DIVISION TECHNICAL SERVICES	
TITLE: FOOTHILL/BRIDGE INFILL AREA SEWER AND WATER IMPROVEMENTS AREA 356 - ISLETA DRAIN # 2			
Design Review Committee	City Engineer Approval	Mo./Day/Yr.	Mo./Day/Yr.
Last Design Update			
City Project No. 747881	Zone Map No. K-12, L11 & L12	Sheet 7	Of 25
County Project No. TS01-20			

 

1. THE WATER SYSTEMS DIVISION (857-8200) WILL BE NOTIFIED BY THE CONTRACTOR SEVEN (7) WORKING DAYS IN ADVANCE OF ANY WORK WHICH MAY AFFECT THE EXISTING PUBLIC WATER FACILITIES. REFER TO SECTION 18 OF STANDARD SPECIFICATIONS.
2. ONLY CITY WATER SYSTEMS DIVISION EMPLOYEES MAY OPERATE VALVES.
3. BUILD WATERLINE AS SHOWN, PRESSURE TEST AND DISINFECT WATERLINE PER SPECIFICATIONS.
4. CLOSE VALVE 682 IN ATRISCO AND CONNECT TO EXISTING WATER FACILITIES.
5. OPEN ALL VALVES.

1. INSTALL NEW SERVICE LINES AND ABANDON EXISTING SERVICE LINES.
2. ABANDON MANHOLE IN PLACE PER STANDARD SPECIFICATION SECTION 920.6. ABANDONMENT SHALL TAKE PLACE AFTER EXISTING SERVICES ARE TRANSFERRED TO NEW SEWER LINE. ABANDON 8" SAS FROM NEW MANHOLE TO EXISTING MANHOLE.

4" SANITARY SEWER / WATER SERVICES						
ADDRESS	LEGAL DISCRPTION	STATION	ELEV. @ PIPE (FT)	ELEV. @ PROP. LINE (FT)	SAS LENGTH	WATER STATION
415 ATRISCO DR. SW	TRS 99a1b2b2 & 99a1b2b1	3+43.00 4.86 R	4941.50	4941.50	19.0'	3+42.00 5.10 L
415 ATRISCO DR. SW	TRS 99a1b2a MRGCD Map #39	3+43.00 4.86 R	4941.10	4941.40	20.0'	3+42.00 5.10 L


SCALE: 1"=40'



SCALE:
HORIZ: 1"=40'
VERT: 1"=4'

[illegible]

		BERNALILLO COUNTY PUBLIC WORKS DIVISION TECHNICAL SERVICES		10/1/2010	
				10/1/2010	
TITLE: FOOTHILL/BRIDGE INFILL AREA SEWER AND WATER IMPROVEMENTS AREA 364 – PRIVATE ROAD					
Design Review Committee		City Engineer Approval		Last Design Update	Mo./Day/Yr.
					Mo./Day/Yr.
					Mo./Day/Yr.
					Mo./Day/Yr.
					Mo./Day/Yr.
City Project No. 747881		Zone Map No. K-12		Sheet 8 Of 25	
County Project No. TS01-20					

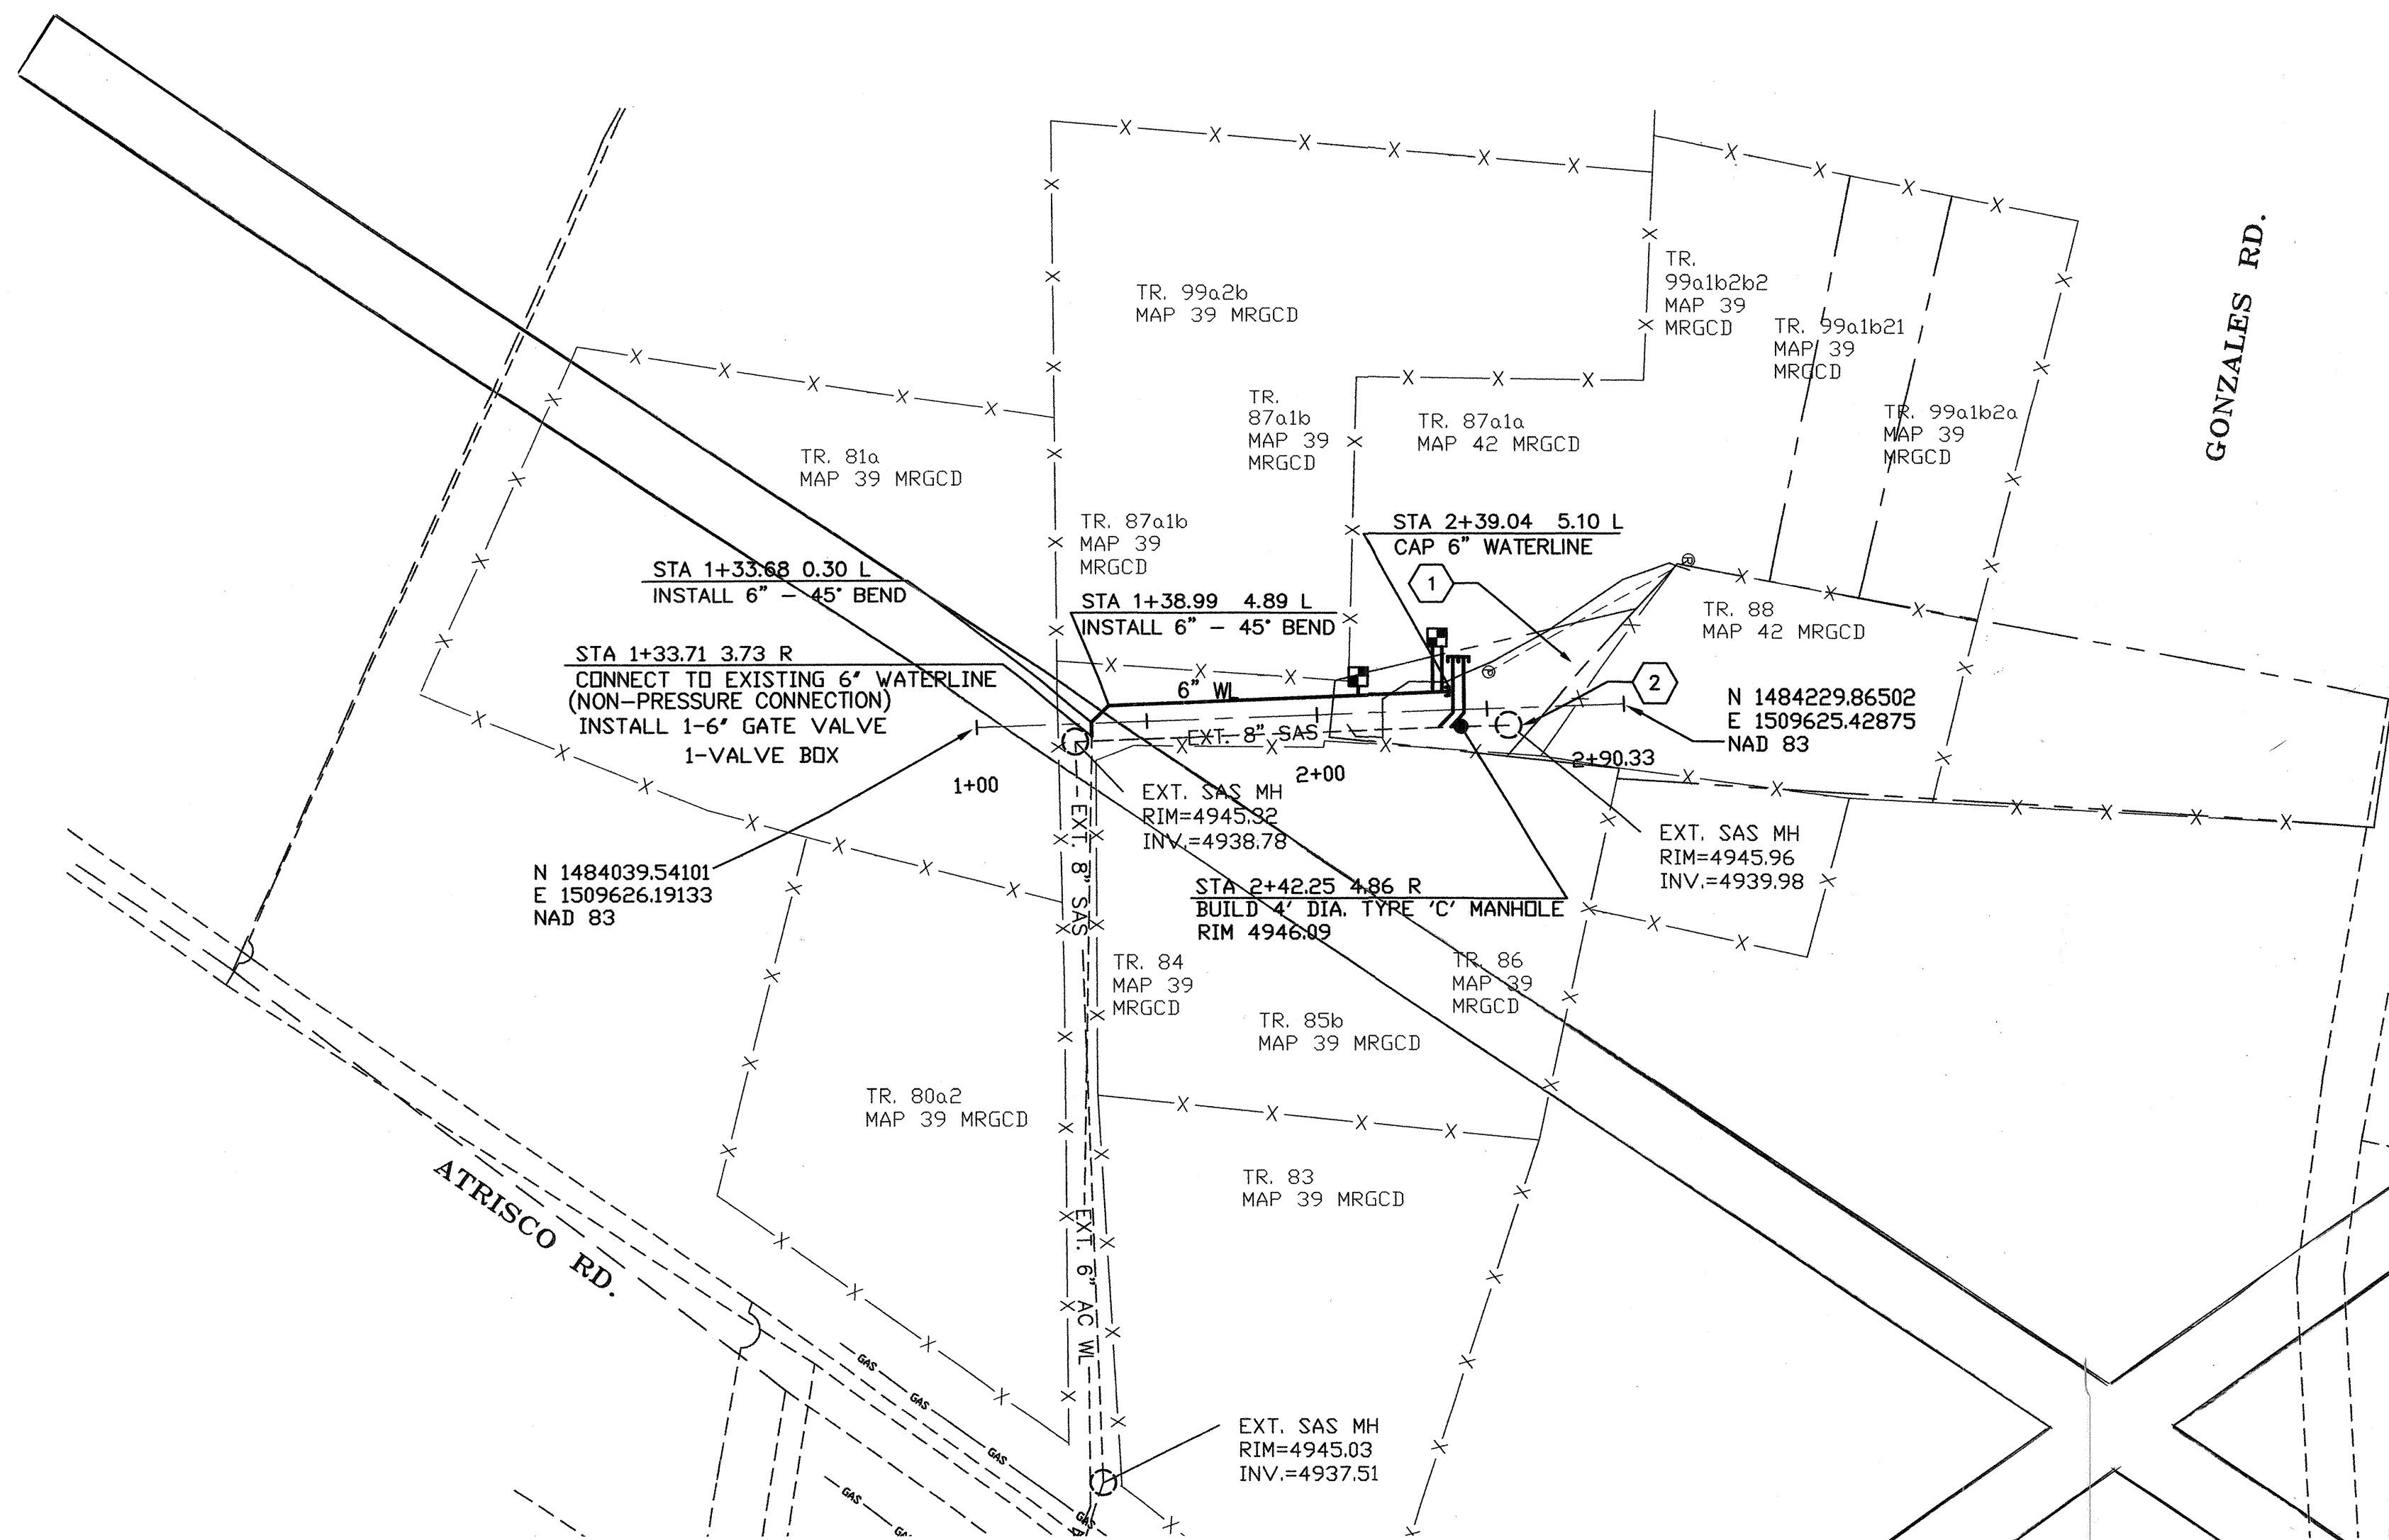

WATER SHUT-OFF PLAN

1. THE WATER SYSTEMS DIVISION (857-8200) WILL BE NOTIFIED BY THE CONTRACTOR SEVEN (7) WORKING DAYS IN ADVANCE OF ANY WORK WHICH MAY AFFECT THE EXISTING PUBLIC WATER FACILITIES. REFER TO SECTION 18 OF STANDARD SPECIFICATIONS.
2. ONLY CITY WATER SYSTEMS DIVISION EMPLOYEES MAY OPERATE VALVES.
3. BUILD WATERLINE AS SHOWN, PRESSURE TEST AND DISINFECT WATERLINE PER SPECIFICATIONS.
4. CLOSE VALVE 682 in ATRISCO AND CONNECT TO EXISTING WATER FACILITIES.
5. OPEN ALL VALVES.


CONSTRUCTION NOTES

1. INSTALL NEW SERVICE LINES AND ABANDON EXISTING SERVICE LINES.
2. ABANDON MANHOLE IN PLACE PER STANDARD SPECIFICATION SECTION 920.6. ABANDONMENT SHALL TAKE PLACE AFTER EXISTING SERVICES ARE TRANSFERRED TO NEW SEWER LINE. ABANDON 8" SAS FROM NEW MANHOLE TO EXISTING MANHOLE.

4" SANITARY SEWER / WATER SERVICES						
ADDRESS	LEGAL DISCRPTION	STATION	ELEV. @ PIPE (FT)	ELEV. @ PROP. LINE (FT)	SAS LENGTH	WATER STATION
415 ATRISCO DR. SW	TRS 99a1b2b2 & 99a1b2b1	2+80.78 0.00 R	4940.34	4940.64	19.0'	2+34.26 5.11 L
415 ATRISCO DR. SW	TRS 99a1b2a MRGCD Map #39	2+81.68 0.61 L	4940.36	4940.66	20.0'	2+36.97 5.10 L
VACANT	TRS 87a1a MRGCD Map #39	2+78.77 2.75 R	4940.13	4940.43		2+12.31 5.04 L

AREA 364 - PRIVATE ROAD PLAN

SCALE: 1"=40'

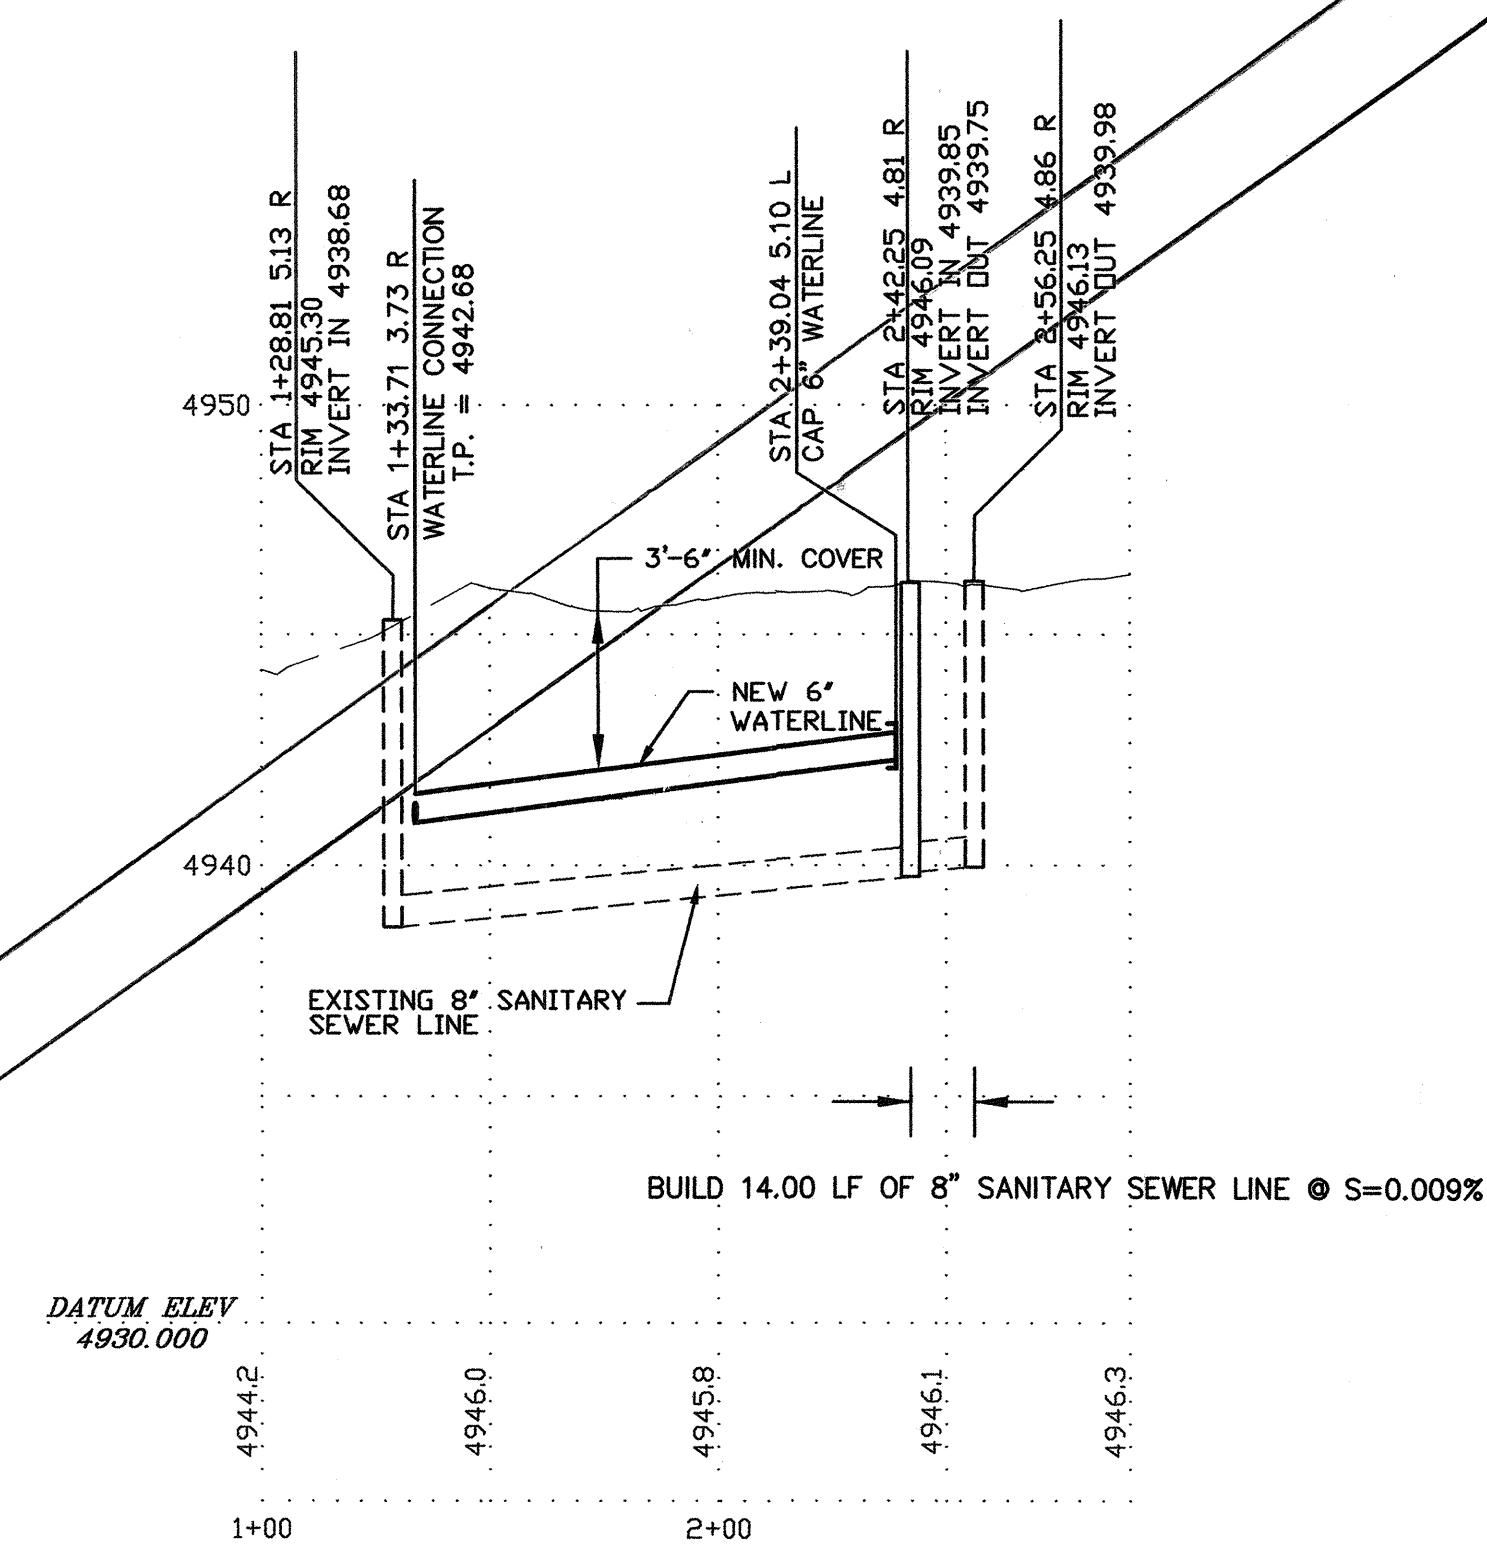

AREA 364 - PRIVATE ROAD PROFILE

SCALE:
HORIZ: 1"=40'
VERT: 1"=4'

REPLACE SEE NEXT SH.


AS BUILT INFORMATION		BENCH MARKS		SURVEY INFORMATION		ENGINEER'S SEAL	
CONTRACTOR	DATE	SURVEY TO CALL ENGINEER	DATE	FIELD NOTES	NO.	BY	DATE
INSPECTOR'S	DATE						
FIELD VERIFICATION BY	DATE						
COMPLETED BY	DATE						
MICRO-FILM INFORMATION	DATE						
RECORDED BY	NO.						

DESIGNED BY	DATE	REVISIONS
DRAWN BY	DATE	
CHECKED BY	DATE	

BERNALILLO COUNTY PUBLIC WORKS DIVISION TECHNICAL SERVICES	
TITLE: FOOTHILL BRIDGE INFILL AREA SEWER AND WATER IMPROVEMENTS AREA 364 - PRIVATE ROAD	
Design Review Committee	City Engineer Approval
Mo./Day/Yr.	Mo./Day/Yr.
City Project No. 747881	Zone Map No. K-12
County Project No. TS01-20	Sheet 8 of 25


AREA 371 - ISLETA DRAIN PLAN

SCALE: 1"=40'

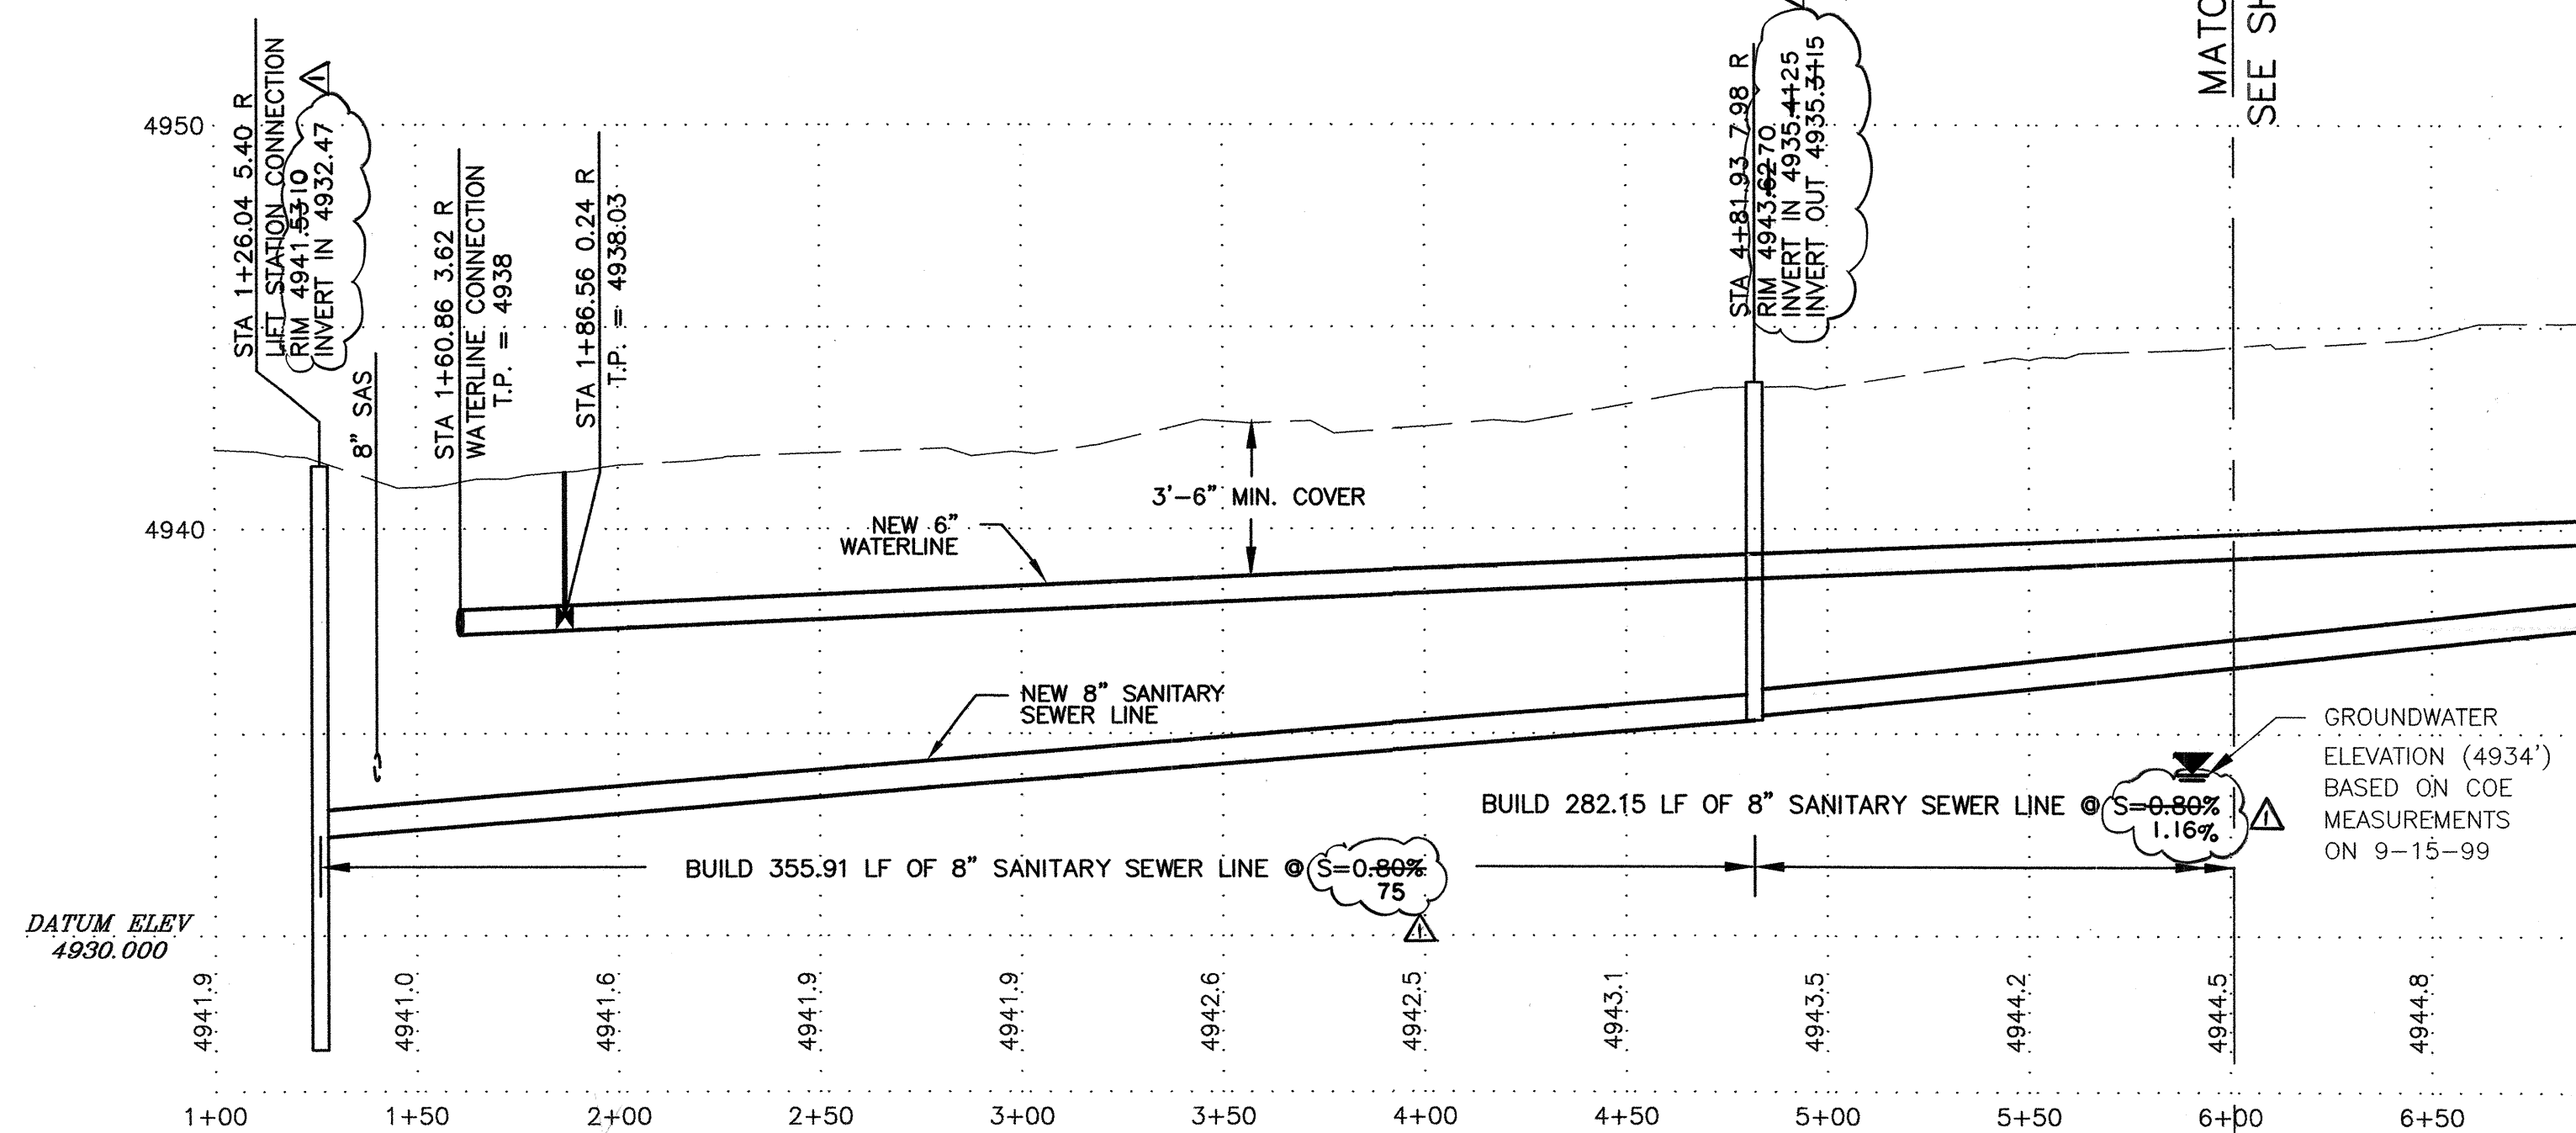

AREA 371 - ISETA DRAIN PROFILE

SCALE:
HORIZ: 1"=40'
VERT: 1"=4'

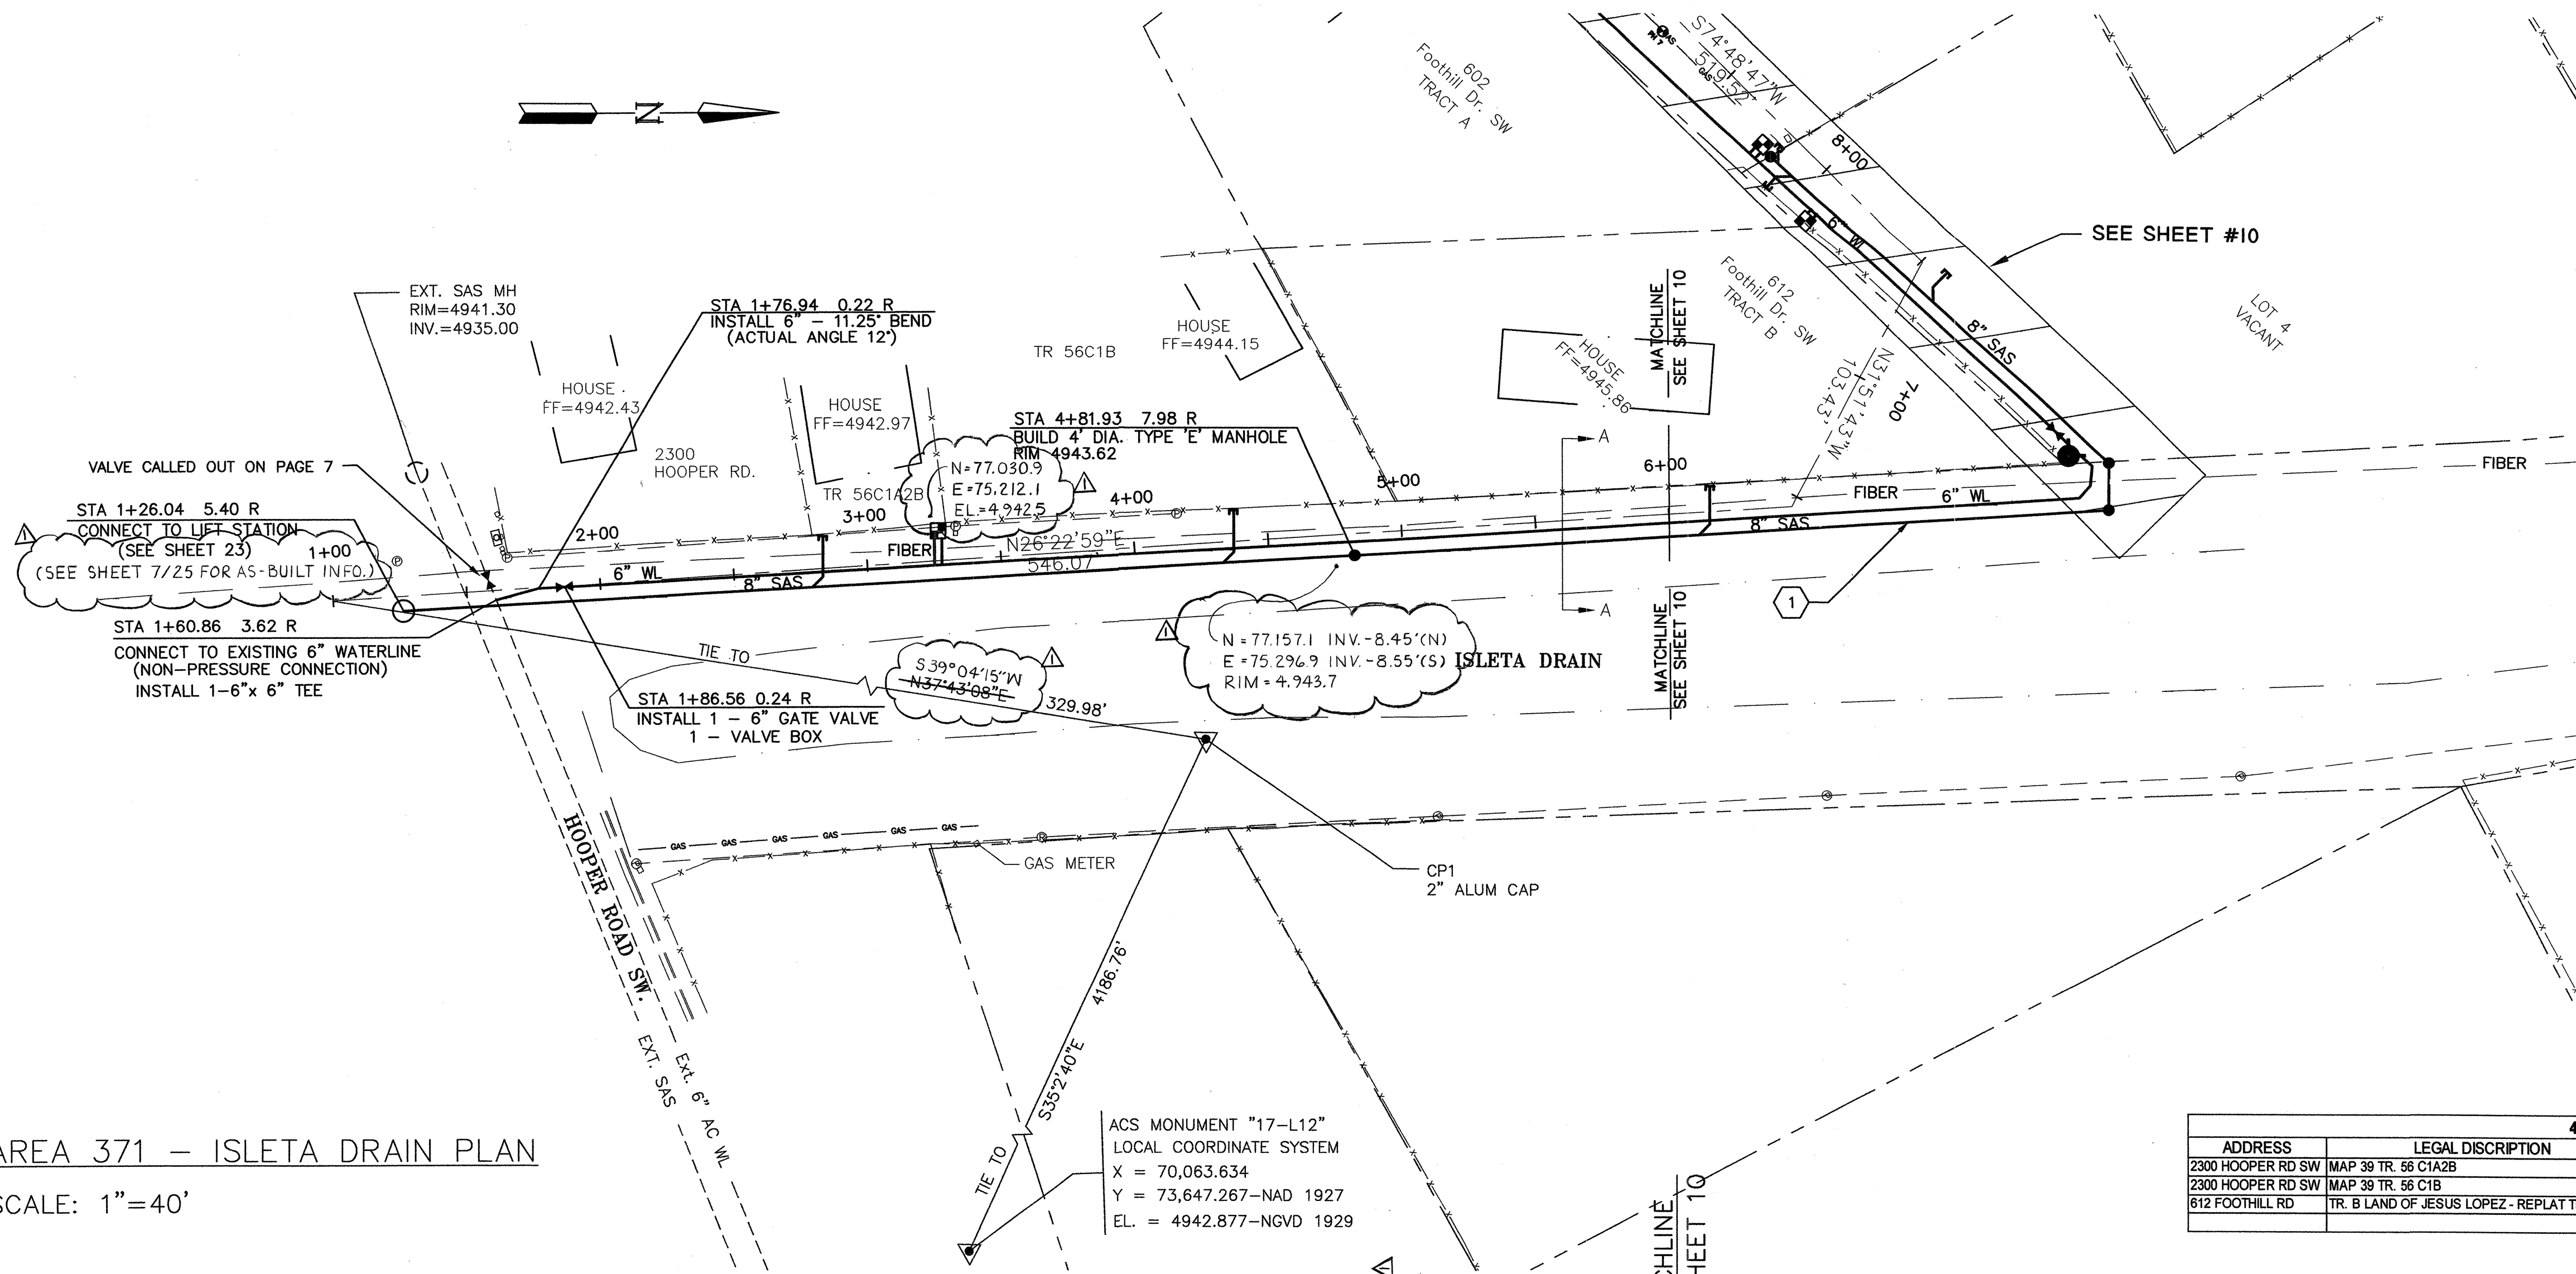


WATER SHUT-OFF PLAN

1. THE WATER SYSTEMS DIVISION (857-8200) WILL BE NOTIFIED BY THE CONTRACTOR SEVEN (7) WORKING DAYS IN ADVANCE OF ANY WORK WHICH MAY AFFECT THE EXISTING PUBLIC WATER FACILITIES. REFER TO SECTION 18 OF STANDARD SPECIFICATIONS.
2. ONLY CITY WATER SYSTEMS DIVISION EMPLOYEES MAY OPERATE VALVES.
3. BUILD WATERLINE AS SHOWN, PRESSURE TEST AND DISINFECT WATERLINE PER SPECIFICATIONS.
4. CLOSE VALVES 432 AND 751 IN FOOTHILL, VALVE 752 IN FOOTHILL WEST, VALVE 874 IN HOOPER, AND CONNECT TO EXISTING WATER FACILITIES.
5. OPEN ALL VALVES.

CONSTRUCTION NOTES

1. SEWER PIPE FROM STA 1+26.04 TO STA 6+00 SHALL BE PRESSURE RATED (125 psi) PLASTIC PIPE AND BE PRESSURE TESTED TO ASSURE WATER TIGHTNESS.

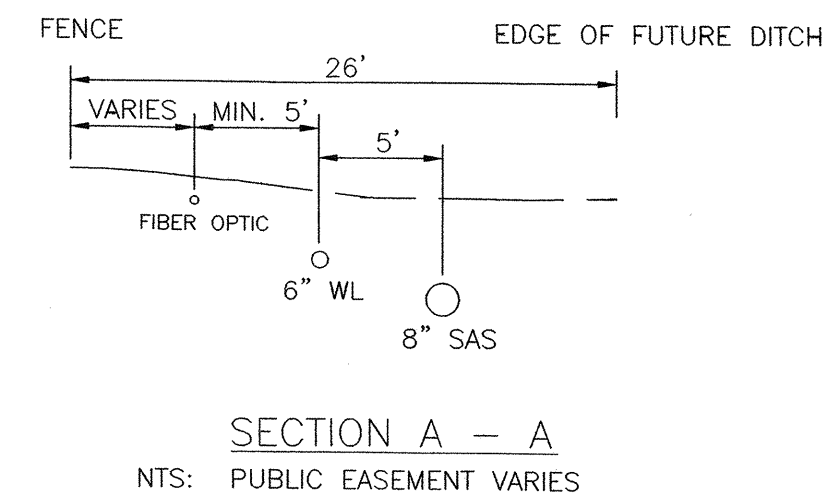

4" SANITARY SEWER / WATER SERVICES						
ADDRESS	LEGAL DESCRIPTION	STATION	ELEV. @ PIPE (FT)	ELEV. @ PROP. LINE (FT)	SAS LENGTH	WATER STATION
2300 HOOPER RD SW	MAP 39 TR. 56 C1A2B	2+82 6.51 L	4936.57	4936.87	18.00	3+25 1.52 R
2300 HOOPER RD SW	MAP 39 TR. 56 C1B	4+87 5.25 L	4937.46	4937.76	19.00	3+25 1.54 R
612 FOOTHILL RD	TR. B LAND OF JESUS LOPEZ - REPLAT TR 56-C2	5+90 7.16 L	4938.43	4938.73	18.00	9+45 14.46 L


CONTROL POINT DATA TABLE (GROUND COORDINATES)				
POINT NAME	COUNTY PROJ #	NORTHING	EASTING	ELEVATION
AEC CP1	371	77,074.994	75,327.407	4943.214
AEC CP2	371	77,643.306	75,597.407	4944.903

MONUMENT DATA TABLE			
CITY MONUMENT	NORTHING	EASTING	ELEVATION
17-L12	73,647.267	77,731.490	4942.877

- 1- ALL CONTROL POINTS ARE 2" ALUM CAP STAMPED AEC CP 1 OR 2.
- 2- COORDINATES ARE IN THE WGS 1984/NAD27 DATUM AND ELEVATIONS ARE IN THE NGVD29 DATUM.


		BERNALILLO COUNTY PUBLIC WORKS DIVISION TECHNICAL SERVICES	
		TITLE: FOOTHILL/BRIDGE INFILL AREA SEWER AND WATER IMPROVEMENTS AREA 371 - ISLETA DRAIN	
Design Review Committee	City Engineer Approval	Mo./Day/Yr.	Mo./Day/Yr.
City Project No. 747881 County Project No. TS01-20		Zone Map No. K-12	Sheet 9 of 25

AS BUILT INFORMATION		BENCH MARKS		SURVEY INFORMATION		ENGINEER'S SEAL	
CONTRACTOR	NM UNDERGROUND	ASC 3 1/4" ALUMINUM CAP STAMPED "NM 17"	DATE	NO.	BY	NO.	BY
INSPECTED BY	DATE	INSPECTED BY	DATE	NO.	BY	NO.	BY
VERIFIED BY	DATE	VERIFIED BY	DATE	NO.	BY	NO.	BY
RECORDED BY	DATE	RECORDED BY	DATE	NO.	BY	NO.	BY
MICRO-FILM INFORMATION		PLANE COORDINATES:		X - 371056.24		Y - 1479124.60	

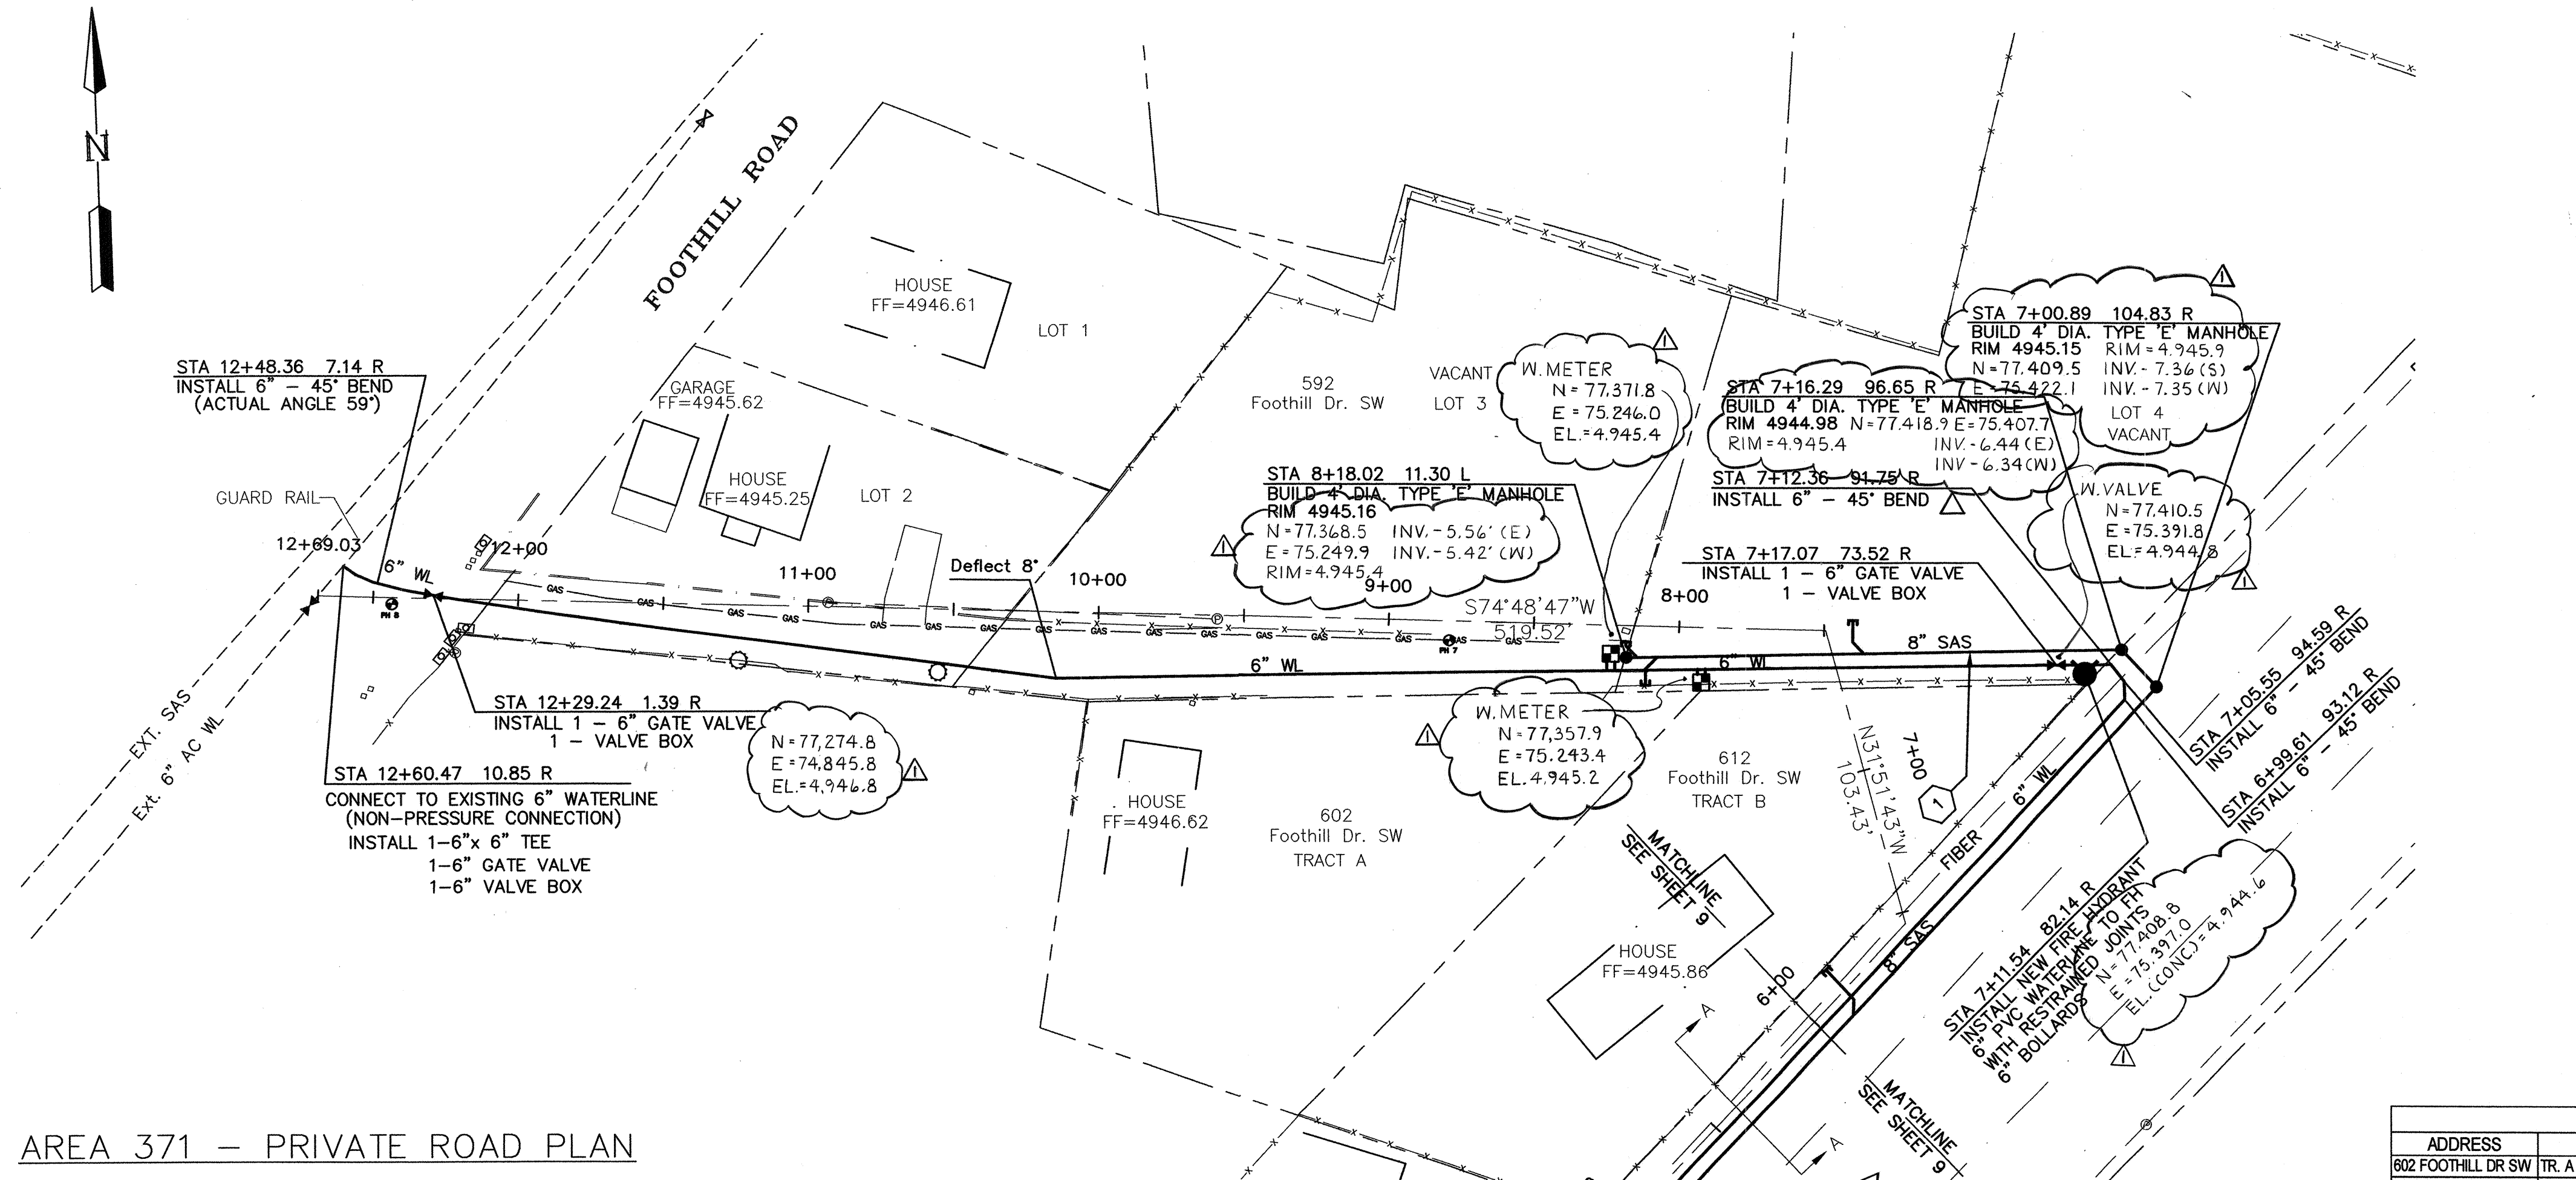

AREA 371 - PRIVATE ROAD PLAN

SCALE: 1"=40'

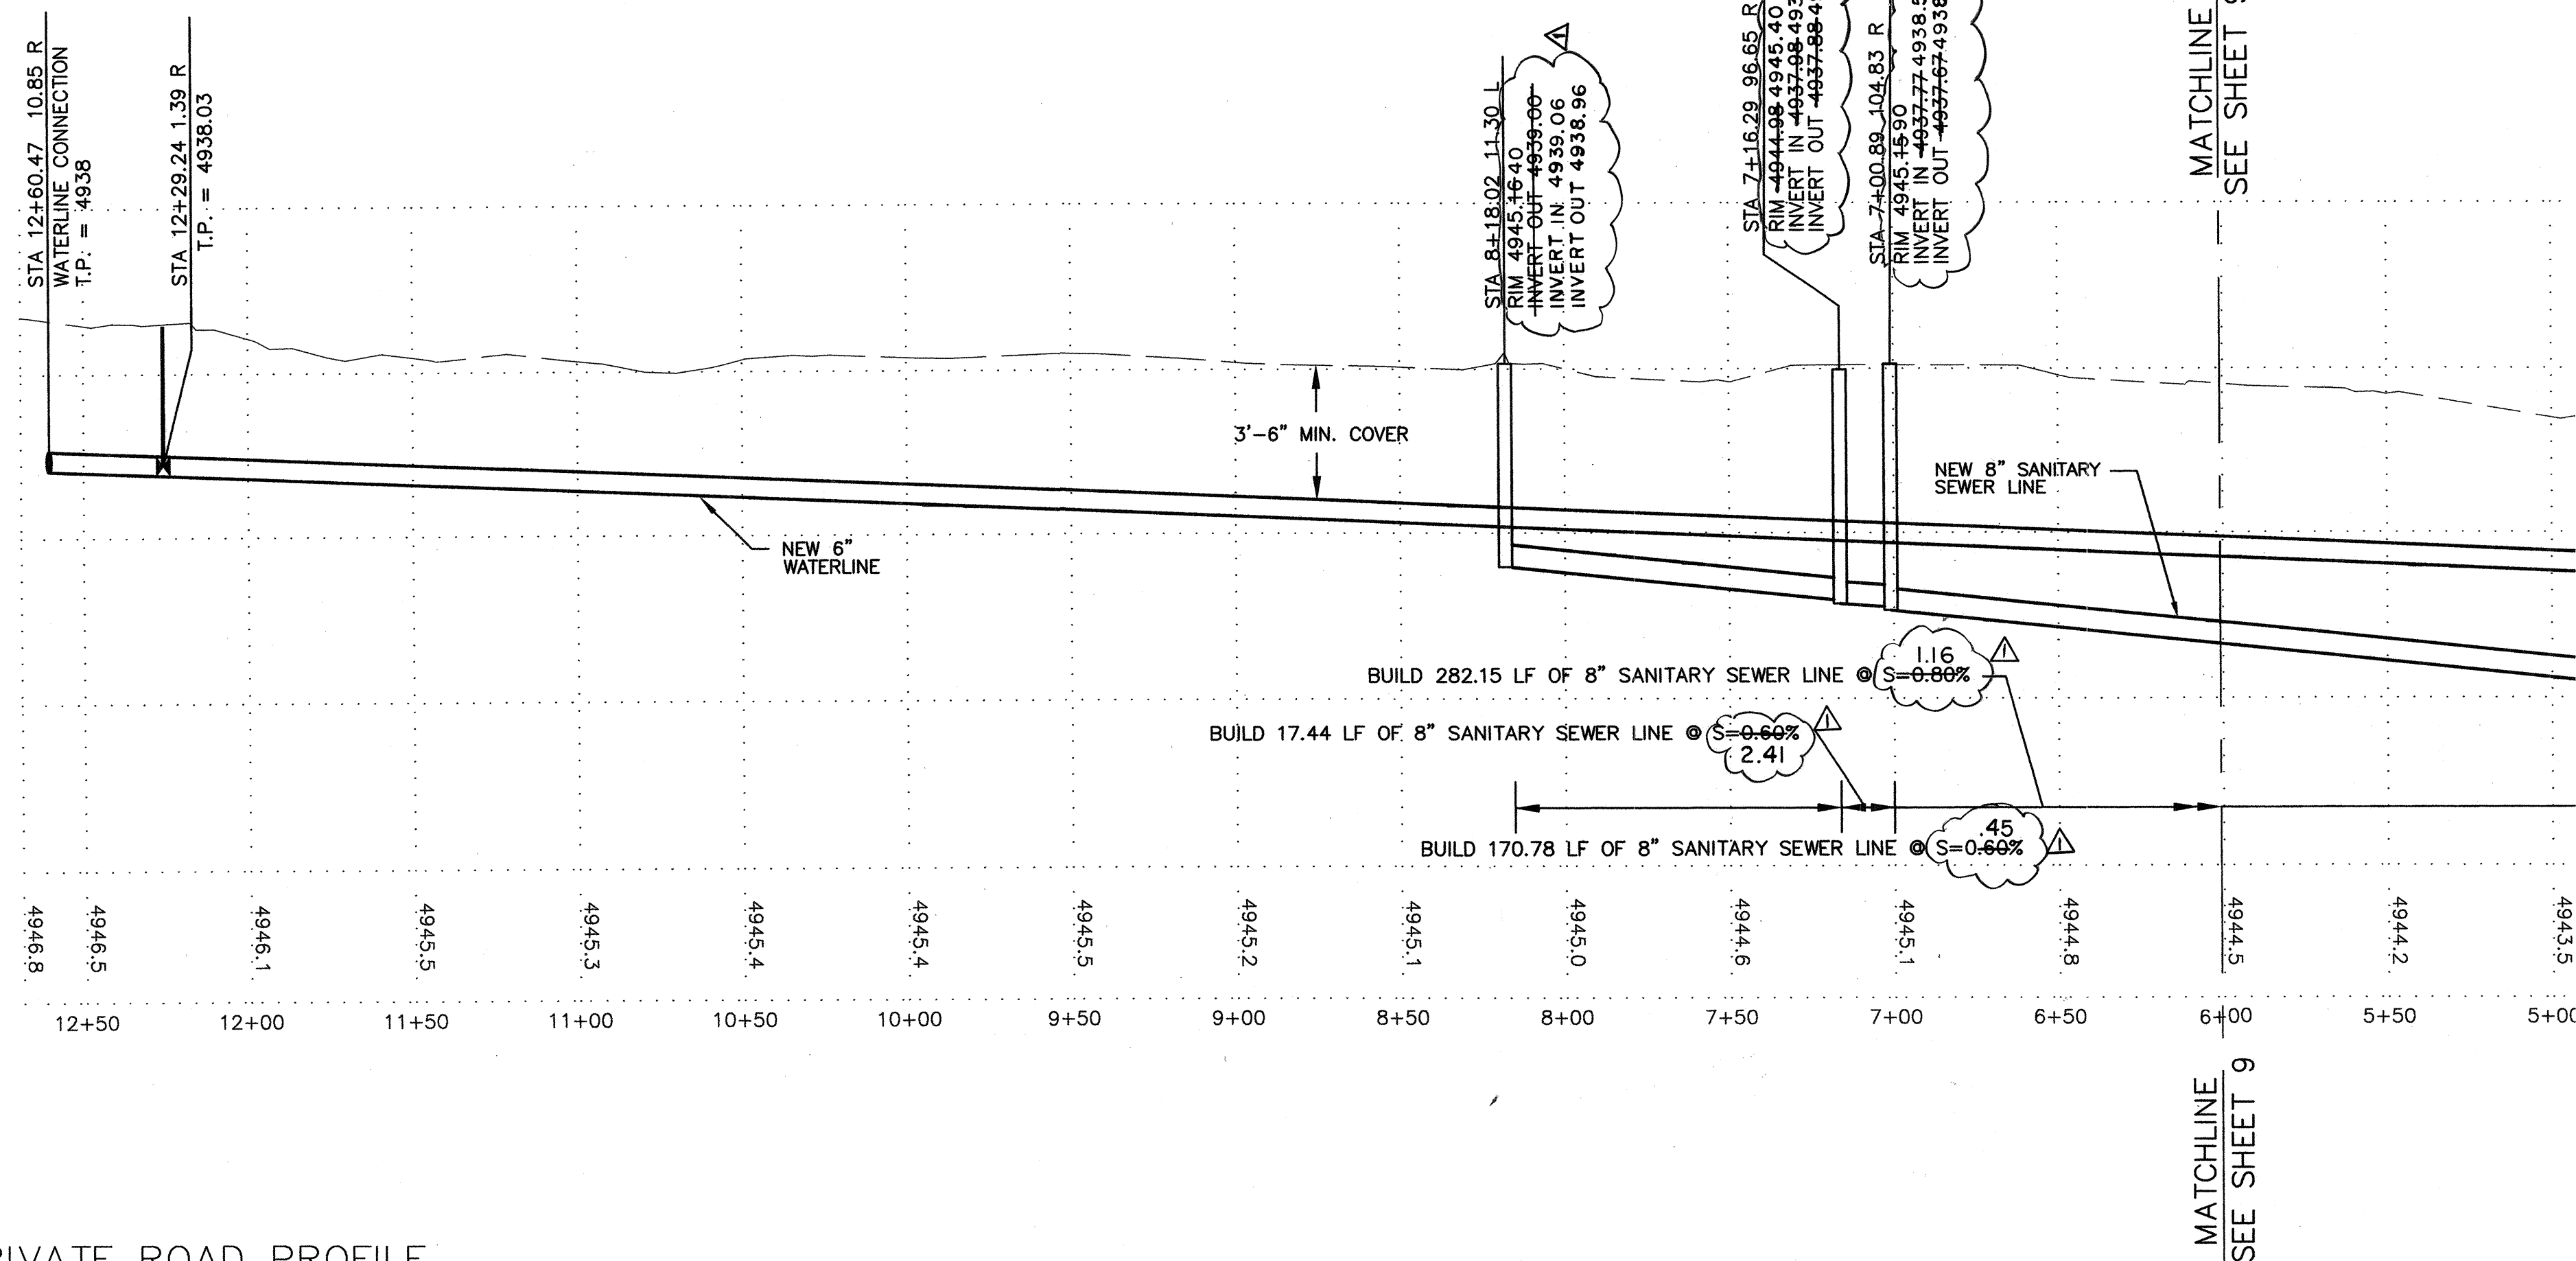

AREA 371 - PRIVATE ROAD PROFILE

SCALE:
HORIZ: 1"=40'
VERT: 1"=4'

WATER SHUT-OFF PLAN

- THE WATER SYSTEMS DIVISION (857-8200) WILL BE NOTIFIED BY THE CONTRACTOR SEVEN (7) WORKING DAYS IN ADVANCE OF ANY WORK WHICH MAY AFFECT THE EXISTING PUBLIC WATER FACILITIES. REFER TO SECTION 18 OF STANDARD SPECIFICATIONS.
- ONLY CITY WATER SYSTEMS DIVISION EMPLOYEES MAY OPERATE VALVES.
- BUILD WATERLINE AS SHOWN, PRESSURE TEST AND DISINFECT WATERLINE PER SPECIFICATIONS.
- CLOSE VALVES 432 AND 751 IN FOOTHILL, VALVE 752 IN FOOTHILL WEST, AND CONNECT TO EXISTING WATER FACILITIES.
- OPEN ALL VALVES.

CONSTRUCTION NOTES

- SEWER PIPE FROM STA 6+00 TO STA 8+18.02 SHALL BE PRESSURE RATED (125 psi) PLASTIC PIPE AND BE PRESSURE TESTED TO ASSURE WATER TIGHTNESS.


4" SANITARY SEWER / WATER SERVICES						
ADDRESS	LEGAL DESCRIPTION	STATION	ELEV. @ PIPE (FT)	ELEV. @ PROP. LINE (FT)	SAS LENGTH	WATER STATION
602 FOOTHILL DR SW	TR. A LAND OF JESUS LOPEZ - REPLAT TR 56-C-2	8+18 10.85 R	4942.97	4943.27	15.0'	8+38 14.85 L
582 FOOTHILL RD	LT 3 LAND OF FRANK BACA REPLAT OF TR 56-D-1	8+24 11.14 L	4944.15	4944.45	12.0'	8+45 15.81 L
FOOTHILL RD	LT 4 LAND OF FRANK BACA REPLAT OF TR 56-D-1	7+56 10.58 R	4944.62	4944.92	12.0'	8+38 15.81 L

CONTROL POINT DATA TABLE (GROUND COORDINATES)				
POINT NAME	COUNTY PROJ #	NORTHING	EASTING	ELEVATION
AEC CP1	371	77,074.994	75,327.407	4943.214
AEC CP2	371	77,643.306	75,597.407	4944.903

MONUMENT DATA TABLE			
CITY MONUMENT	NORTHING	EASTING	ELEVATION
17-L12	73,647.267	77,731.490	4942.877

- ALL CONTROL POINTS ARE 2" ALUM CAP STAMPED AEC CP 1 OR 2.
- COORDINATES ARE IN THE WGS 1984/NAD27 DATUM AND ELEVATIONS ARE IN THE NGVD29 DATUM.

		BERNALILLO COUNTY PUBLIC WORKS DIVISION TECHNICAL SERVICES	
TITLE: FOOTHILL/BRIDGE INFILL AREA SEWER AND WATER IMPROVEMENTS AREA 371 - PRIVATE RD			
Design Review Committee	City Engineer Approval	Mo./Day/Yr.	Mo./Day/Yr.
Last Design Update			
City Project No. 747881	Zone Map No. K-12	Sheet 10	Of 25
County Project No. TS01-20			


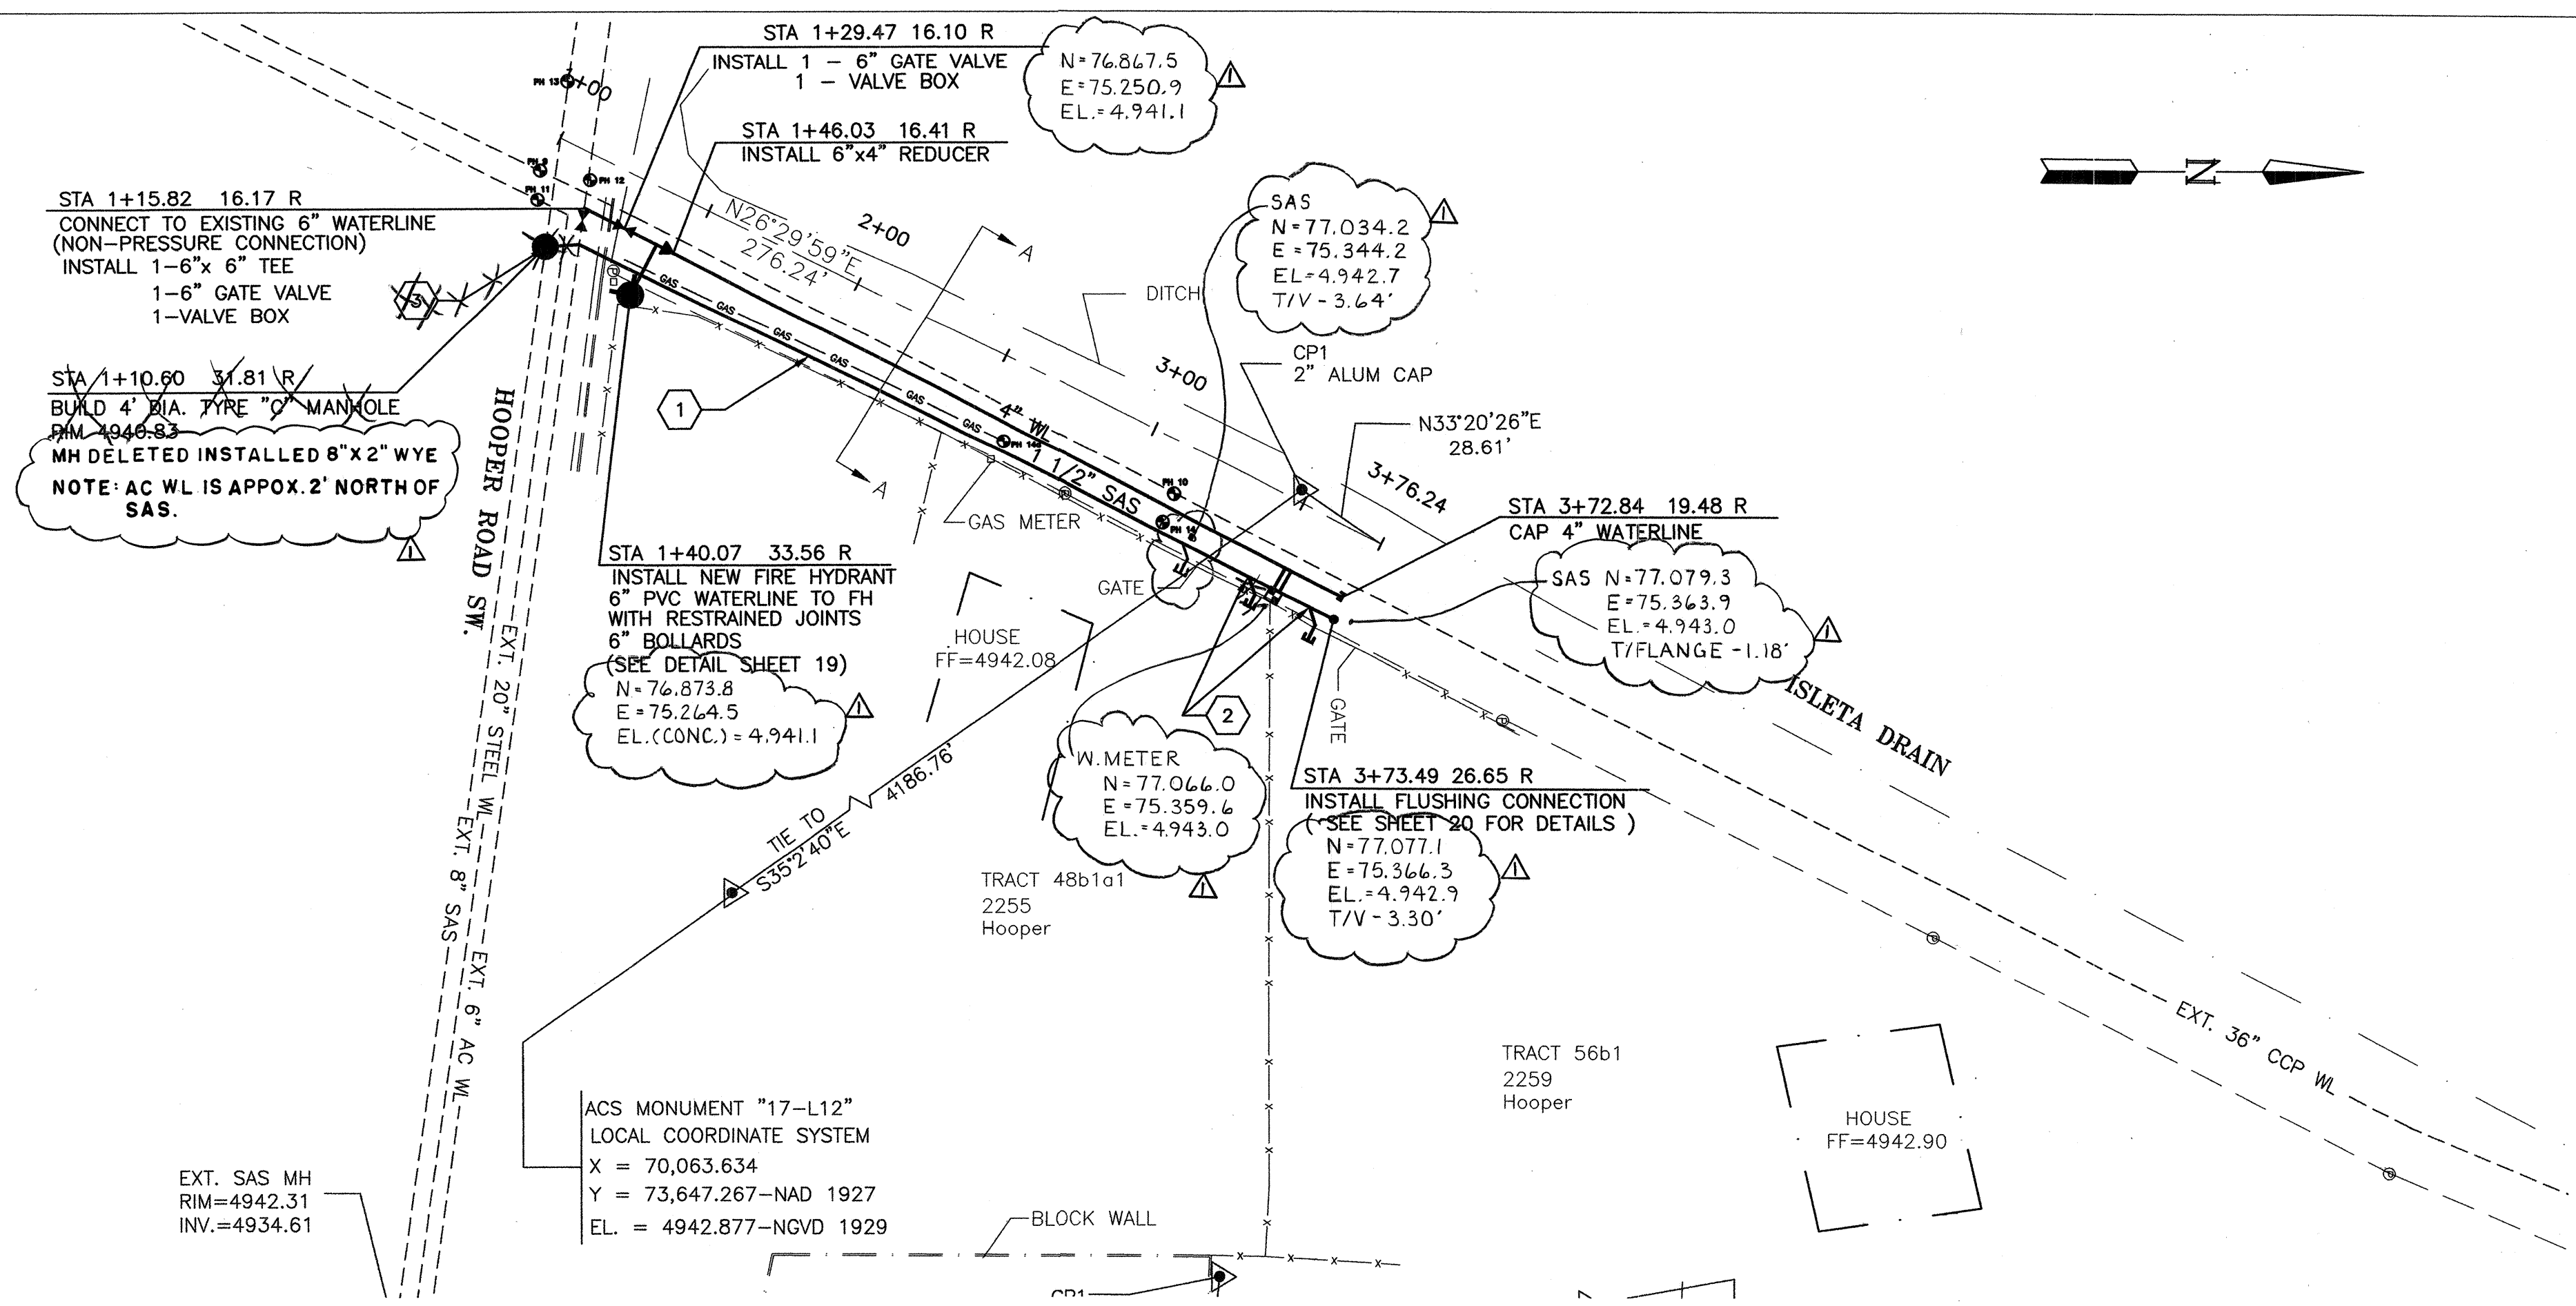


WATER SHUT-OFF PLAN

1. THE WATER SYSTEMS DIVISION (857-8200) WILL BE NOTIFIED BY THE CONTRACTOR SEVEN (7) WORKING DAYS IN ADVANCE OF ANY WORK WHICH MAY AFFECT THE EXISTING PUBLIC WATER FACILITIES. REFER TO SECTION 18 OF STANDARD SPECIFICATIONS.
2. ONLY CITY WATER SYSTEMS DIVISION EMPLOYEES MAY OPERATE VALVES.
3. BUILD WATERLINE AS SHOWN, PRESSURE TEST AND DISINFECT WATERLINE PER SPECIFICATIONS.
4. CLOSE VALVES 432 AND 751 IN FOOTHILL, VALVE 752 IN FOOTHILL WEST, VALVE 874 IN HOPPER, AND CONNECT TO EXISTING WATER FACILITIES.
5. OPEN ALL VALVES.

CONSTRUCTION NOTES

1. INSTALL 1 1/2" LOW PRESSURE SEWER LINE.
2. LOW PRESSURE SEWER LATERAL (SEE SHEET 20 FOR DETAIL).
3. MANHOLE CONNECTION (SEE DETAIL BELOW).

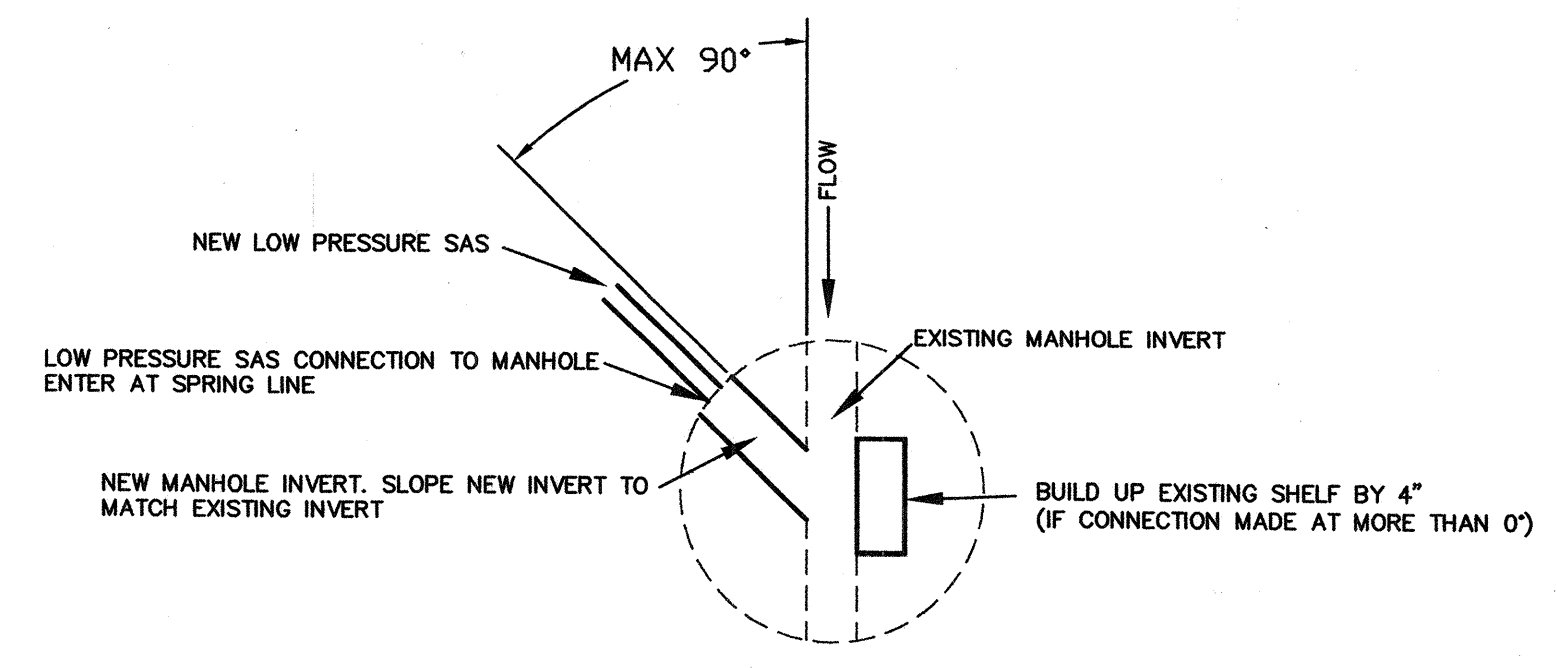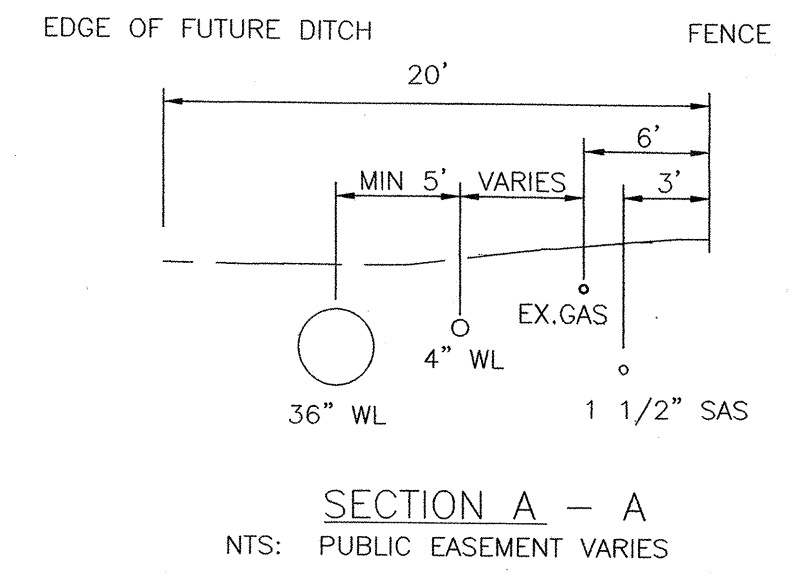

LOW PRESSURE SAS CONNECTION TO MANHOLE

SANITARY SEWER SERVICES						
WATER STA	ADDRESS	LEGAL DISCRPTION	STATION	ELEV. @ PIPE (FT)	ELEV. @ PROP. LINE (FT)	SAS LENGTH
3+62	2255 HOPPER SW	TR 48B1A MAP 39 MRGCD	3+62.39 8.30 R	4937.00	4937.30	30.0'
3+62	2259 HOPPER SW	TR 55B1 MAP 39 MRGCD	3+62.71 0.00 R			30.0'


CONTROL POINT DATA TABLE (GROUND COORDINATES)			
POINT NAME	COUNTY PROJ #	NORTHING	EASTING
AEC CP1	373	77,074.994	75,327.407
AEC CP2	373	77,643.306	75,597.407

MONUMENT DATA TABLE		
CITY MONUMENT	NORTHING	EASTING
17-L12	73,647.267	76,063.634
		77,731.490

- 1- ALL CONTROL POINTS ARE 2" ALUM CAP STAMPED AEC CP 1 OR 2.
- 2- COORDINATES ARE IN THE WGS 1984/NAD27 DATUM AND ELEVATIONS ARE IN THE NGVD29 DATUM.

AREA 373 - ISLETA DRAIN PLAN

SCALE: 1"=40'

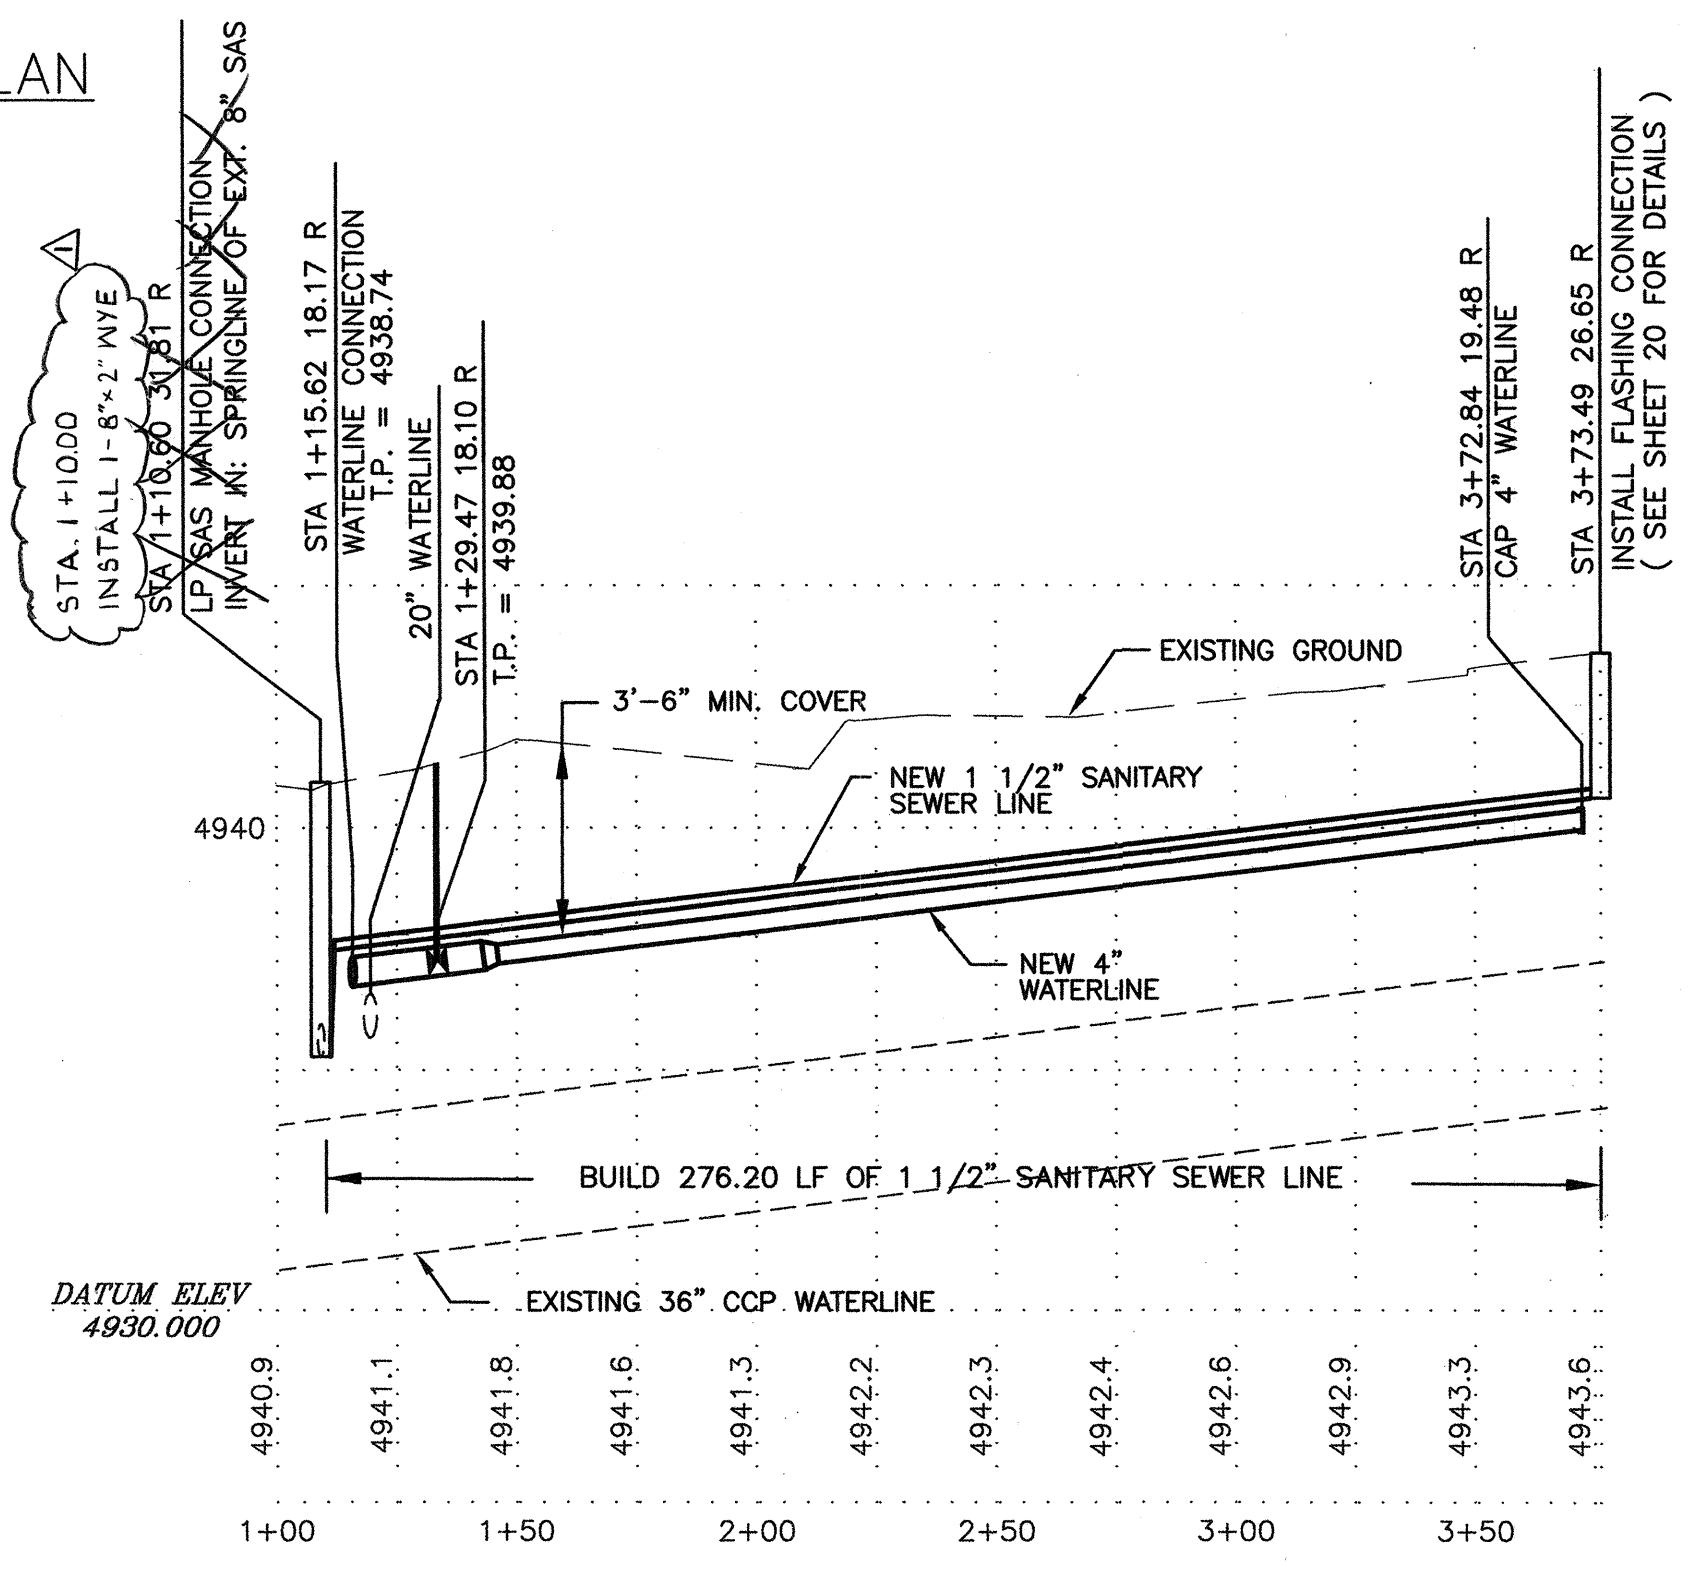

AREA 373 - ISLETA DRAIN PROFILE



SCALE:
HORIZ: 1"=40'
VERT: 1"=4'

BERNALILLO COUNTY PUBLIC WORKS DIVISION TECHNICAL SERVICES			
TITLE: FOOTHILL/BRIDGE INFILL AREA SEWER AND WATER IMPROVEMENTS AREA 373 - ISLETA DRAIN			
Design Review Committee	City Engineer Approval	Mo./Day/Yr.	Mo./Day/Yr.
City Project No. 747881		Zone Map No. L-11	Sheet 11 of 25
County Project No. TS01-20			

AS BUILT INFORMATION			
CONTRACTOR	NM UNDERGROUND	DATE	12/05
INSPECTOR	BY	DATE	6/06
VERIFICATION	BY	DATE	6/06
CHECKED	BY	DATE	9/06
MICRO-FILM INFORMATION			
RECORDED BY		DATE	
NO.			
BENCH MARKS			
ASC 3 1/4" ALUMINUM CAP STAMPED "NM 17"			
-L12" THE CAP IS SET FLUSH WITH THE CURB IN CONCRETE 0.5' ABOVE THE GROUND.			
THE STATION IS LOCATED 2.4 MILES SOUTHWEST OF DOWNTOWN ALBUQUERQUE.			
PLANE COORDINATES:			
X - 371056.24			
Y - 1479124.60			
SURVEY INFORMATION			
FIELD NOTES	NO.	BY	DATE
ASC 3 1/4" ALUMINUM CAP STAMPED "NM 17"			
-L12" THE CAP IS SET FLUSH WITH THE CURB IN CONCRETE 0.5' ABOVE THE GROUND.			
THE STATION IS LOCATED 2.4 MILES SOUTHWEST OF DOWNTOWN ALBUQUERQUE.			
PLANE COORDINATES:			
X - 371056.24			
Y - 1479124.60			
ENGINEER'S SEAL			
NO.	BY	DATE	
REMARKS			
AS BUILT			
9/06			
DESIGNED BY	- NKB	DATE	06/05
DRAWN BY	- PVL	DATE	06/05
CHECKED BY	- DEB	DATE	06/05



		BERNALILLO COUNTY PUBLIC WORKS DIVISION TECHNICAL SERVICES		10		11		12		13		14		15			
				16		17		18		19		20					
TITLE: FOOTHILL/BRIDGE INFILL AREA SEWER AND WATER IMPROVEMENTS AREA 373 – PRIVATE ROAD #1																	
Design Review Committee				City Engineer Approval				Last Design Update		Mo./Day/Yr.				Mo./Day/Yr.			
City Project No. 747881								Zone Map No. L-11				Sheet 12 Of 25					
County Project No. TS01-20																	

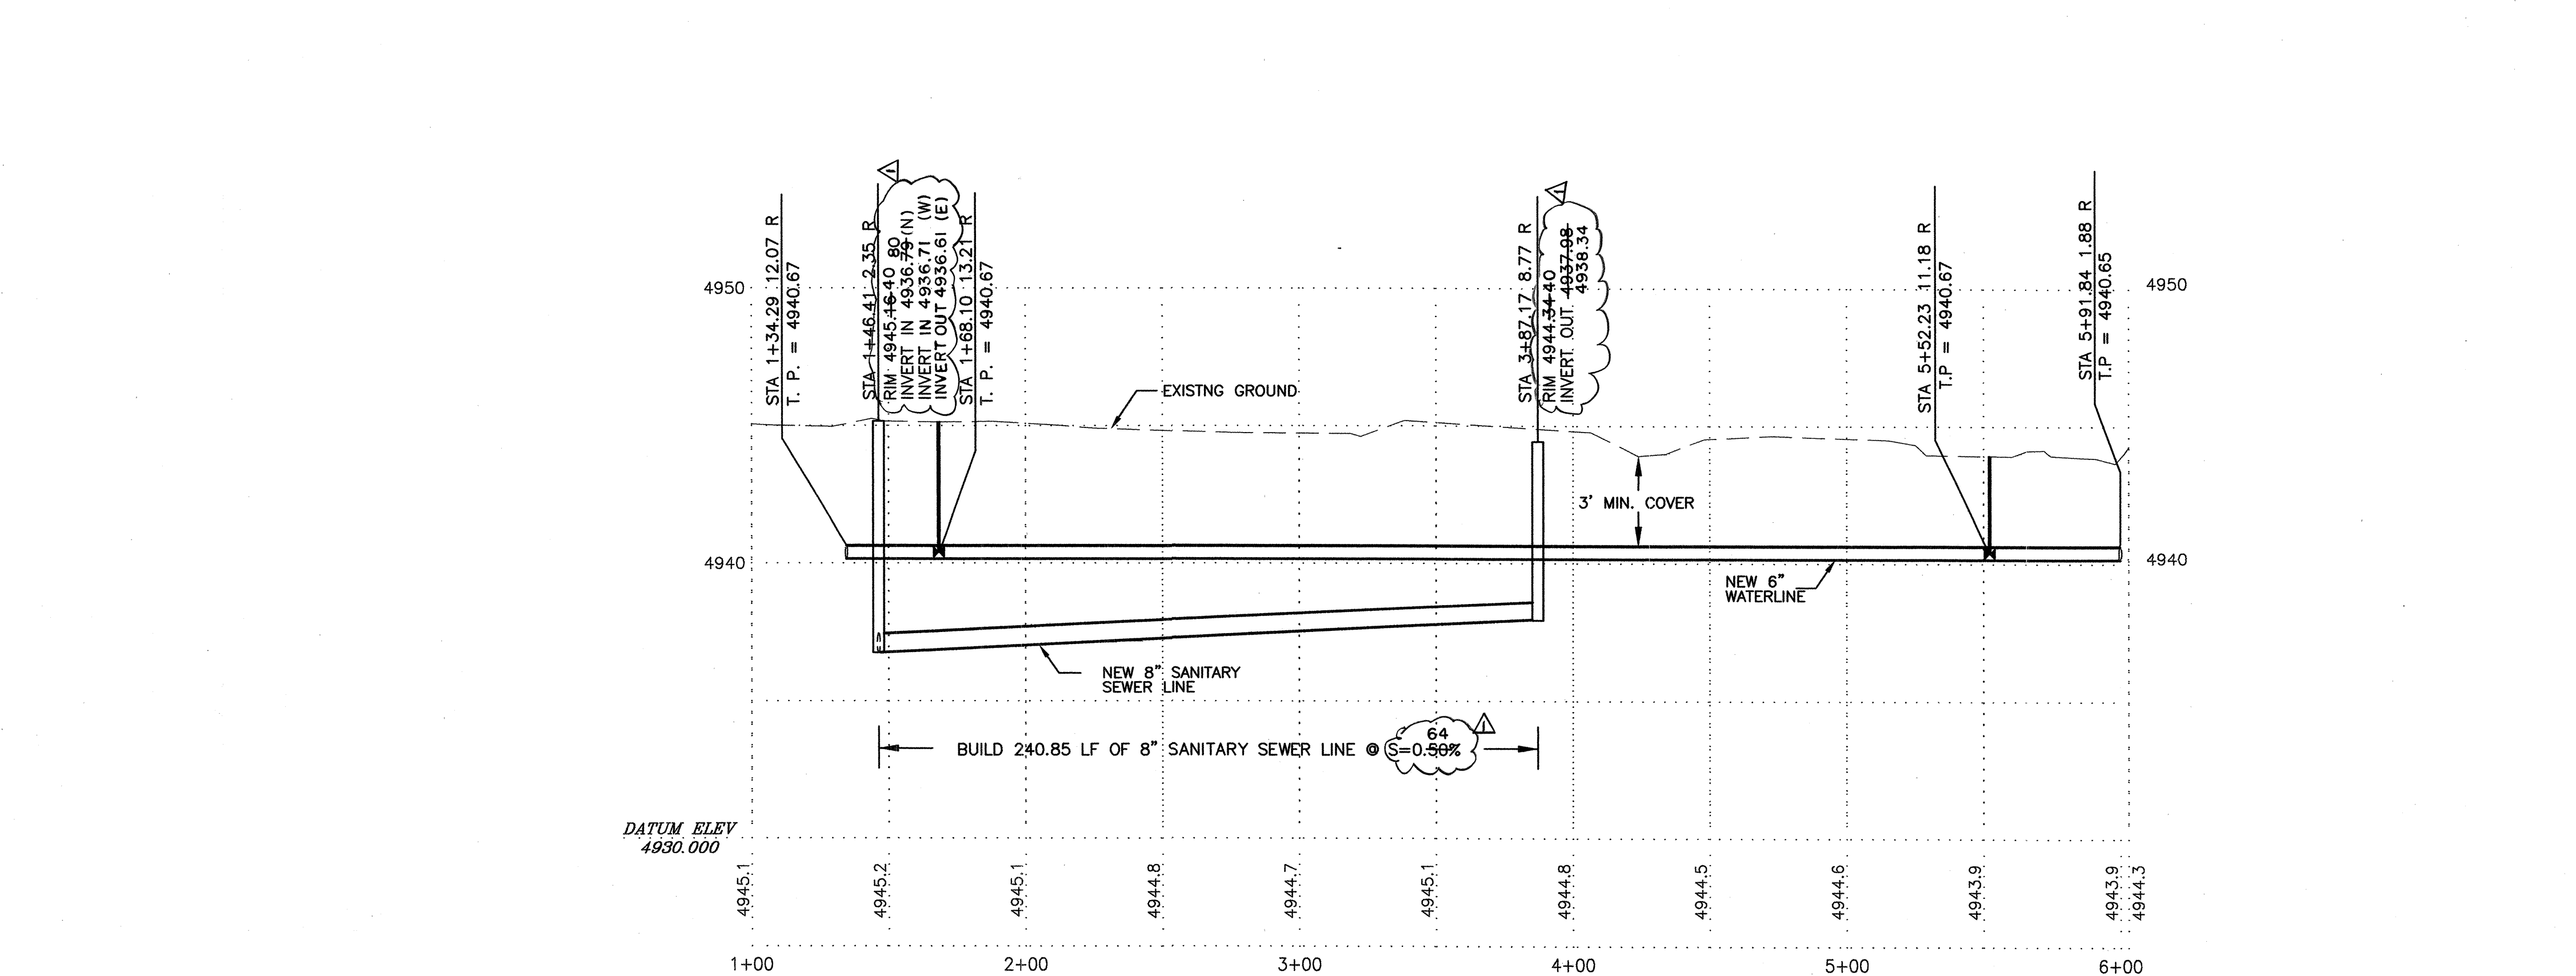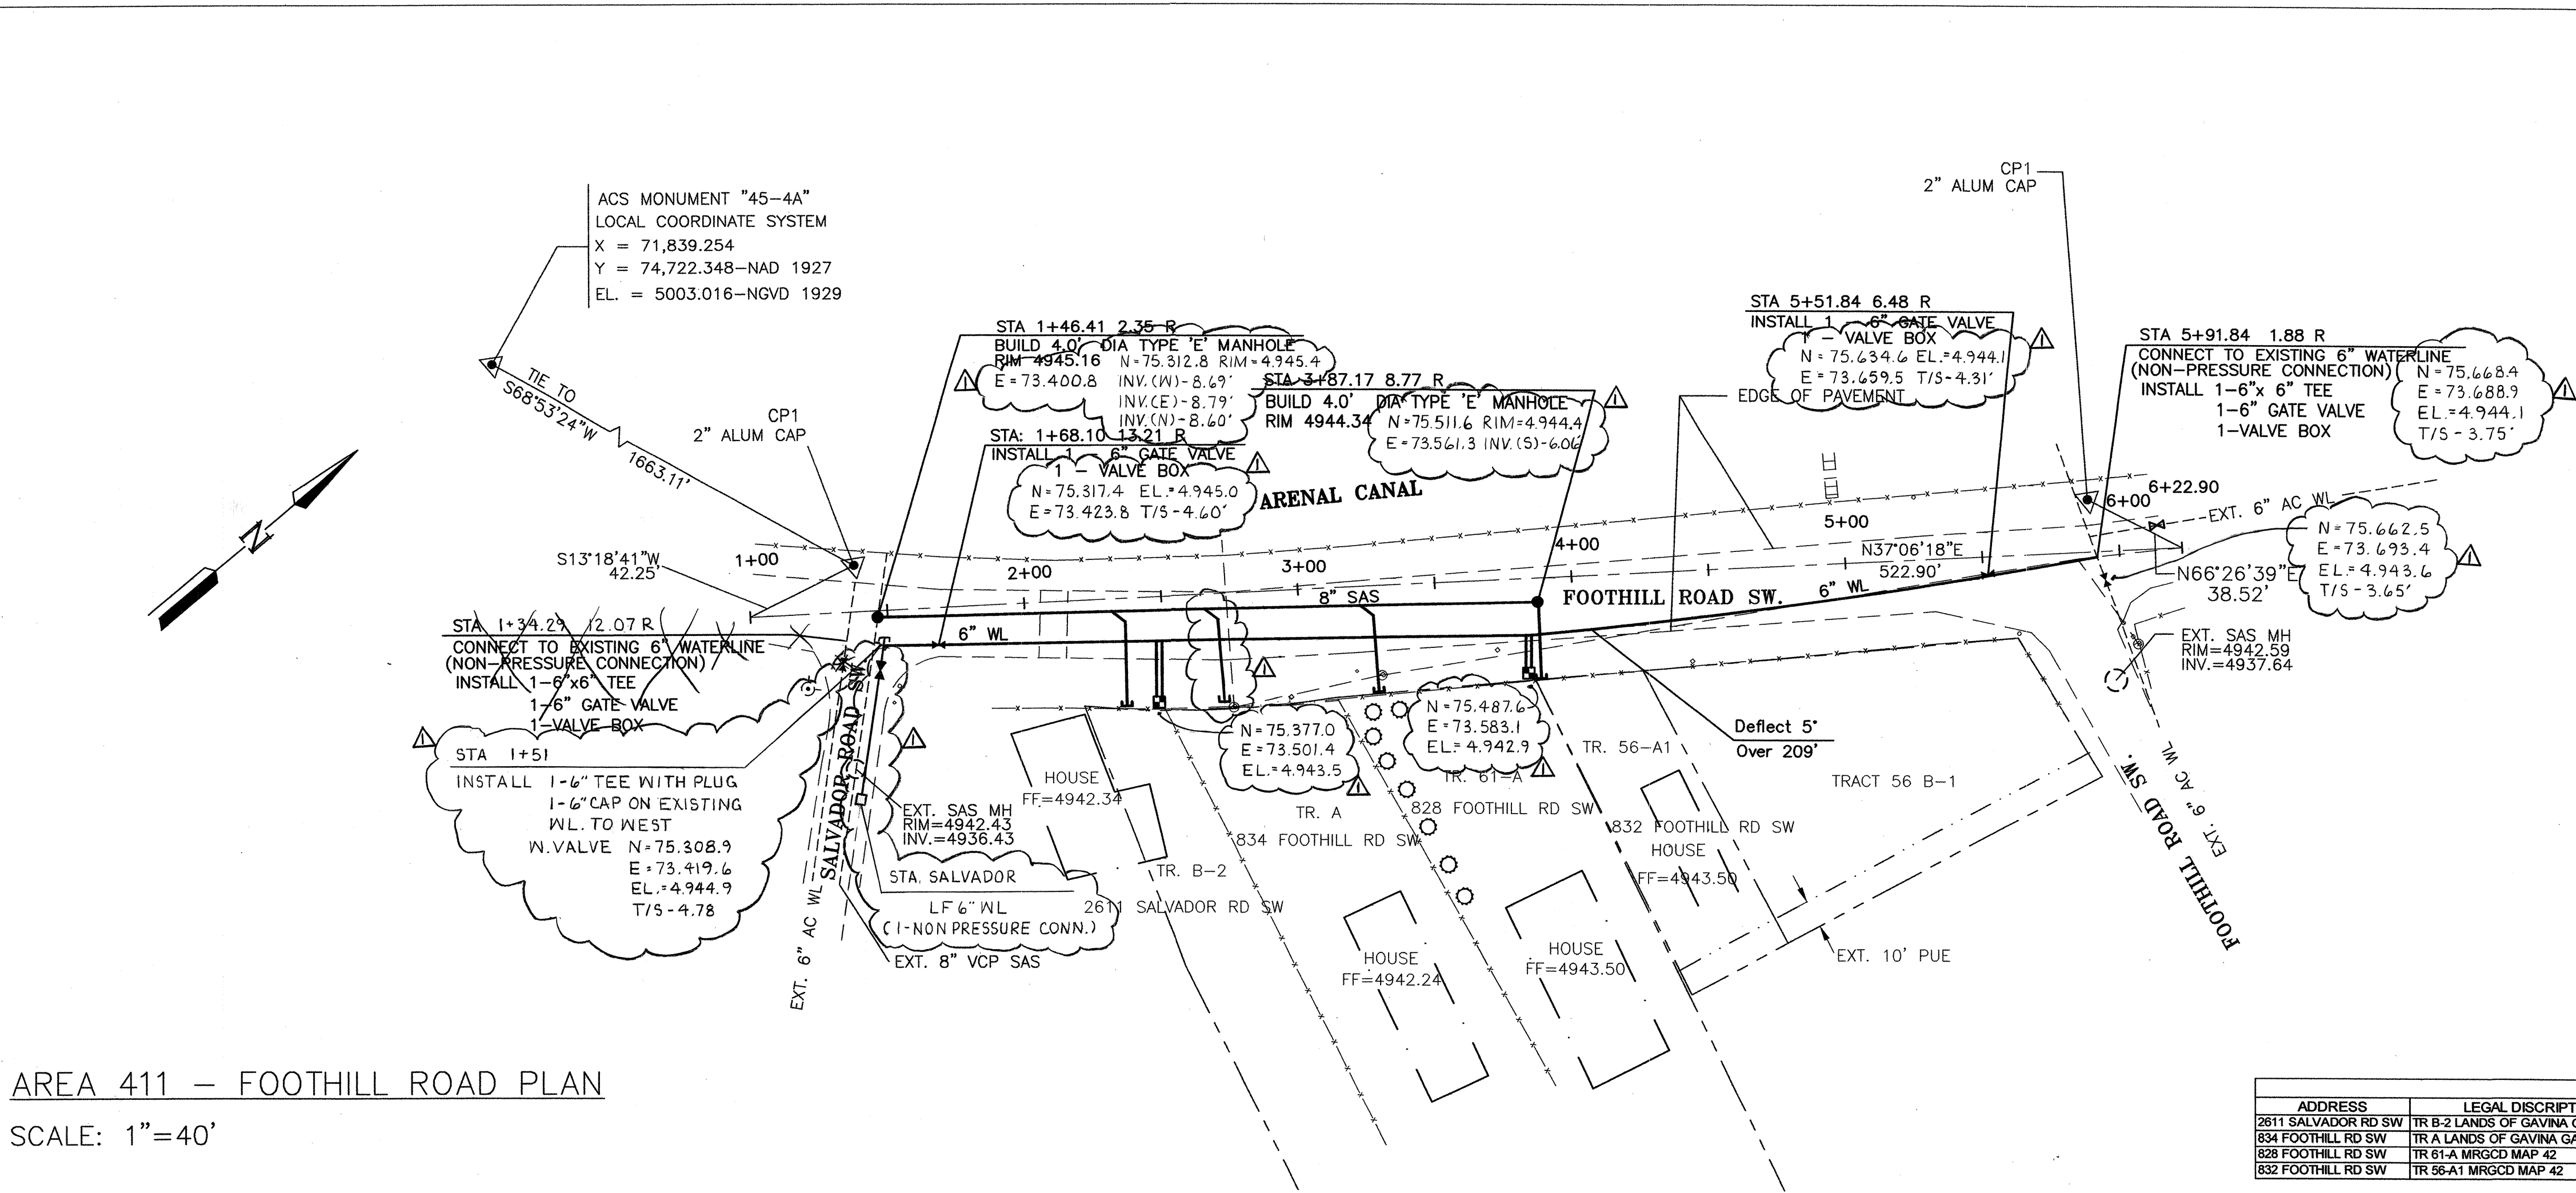

WATER SHUT-OFF PLAN

- 1 THE WATER SYSTEMS DIVISION (857-8200) WILL BE NOTIFIED BY THE CONTRACTOR SEVEN (7) WORKING DAYS IN ADVANCE OF ANY WORK WHICH MAY AFFECT THE EXISTING PUBLIC WATER FACILITIES. REFER TO SECTION 18 OF STANDARD SPECIFICATIONS.
- 2 ONLY CITY WATER SYSTEMS DIVISION EMPLOYEES MAY OPERATE VALVES.
- 3 BUILD WATERLINE AS SHOWN, PRESSURE TEST AND DISINFECT WATERLINE PER SPECIFICATIONS.
- 4 CLOSE VALVES 481 AND 482 IN SALVADOR, VALVE 421 IN FOOTHILL WEST, VALVE 431 IN FOOTHILL WEST, AND VALVE 432 IN FOOTHILL AND CONNECT TO EXISTING WATER FACILITIES.
- 5 OPEN ALL VALVES.



4" SANITARY SEWER / WATER SERVICES					
ADDRESS	LEGAL DESCRIPTION	STATION	ELEV. @ PIPE (FT)	ELEV. @ PROP. LINE (FT)	SAS LENGTH
2611 SALVADOR RD SW	TR B-2 LANDS OF GAYNA GALLEGOS	2+35 4.54 R	4937.88	4938.09	21.50
834 FOOTHILL RD SW	TR A LANDS OF GAYNA GALLEGOS	2+72 5.56 L	4938.16	4938.37	21.00
828 FOOTHILL RD SW	TR 61-A MRGCD MAP 42	3+32 6.85 R	4938.33	4938.53	20.00
832 FOOTHILL RD SW	TR 56-A1 MRGCD MAP 42	3+76 8.27 L	4937.98	4938.13	15.00

CONTROL POINT DATA TABLE (GROUND COORDINATES)				
POINT NAME	COUNTY PROJ. #	NORTHING	EASTING	ELEVATION
AEC CP1	411	75,321.329	73,390.751	4945.891
AEC CP2	411	75,681.842	73,661.164	4944.927

MONUMENT DATA TABLE		
CITY MONUMENT	NORTHING	EASTING
NM 45-4A	74,722.348	77,731.490
	73,647.267	77,731.490


- 1- ALL CONTROL POINTS ARE 2" ALUM CAP STAMPED AEC CP 1 OR 2.
2- COORDINATES ARE IN THE WGS 1984/NAD27 DATUM AND ELEVATIONS ARE IN THE NGVD29 DATUM.

TITLE: FOOTHILL/BIDGE INFILL AREA SEWER AND WATER IMPROVEMENTS AREA 411 - FOOTHILL ROAD	
Design Review Committee	City Engineer Approval
City Project No. 747881	Zone Map No. L-11
County Project No. TS01-20	Sheet 14 of 25

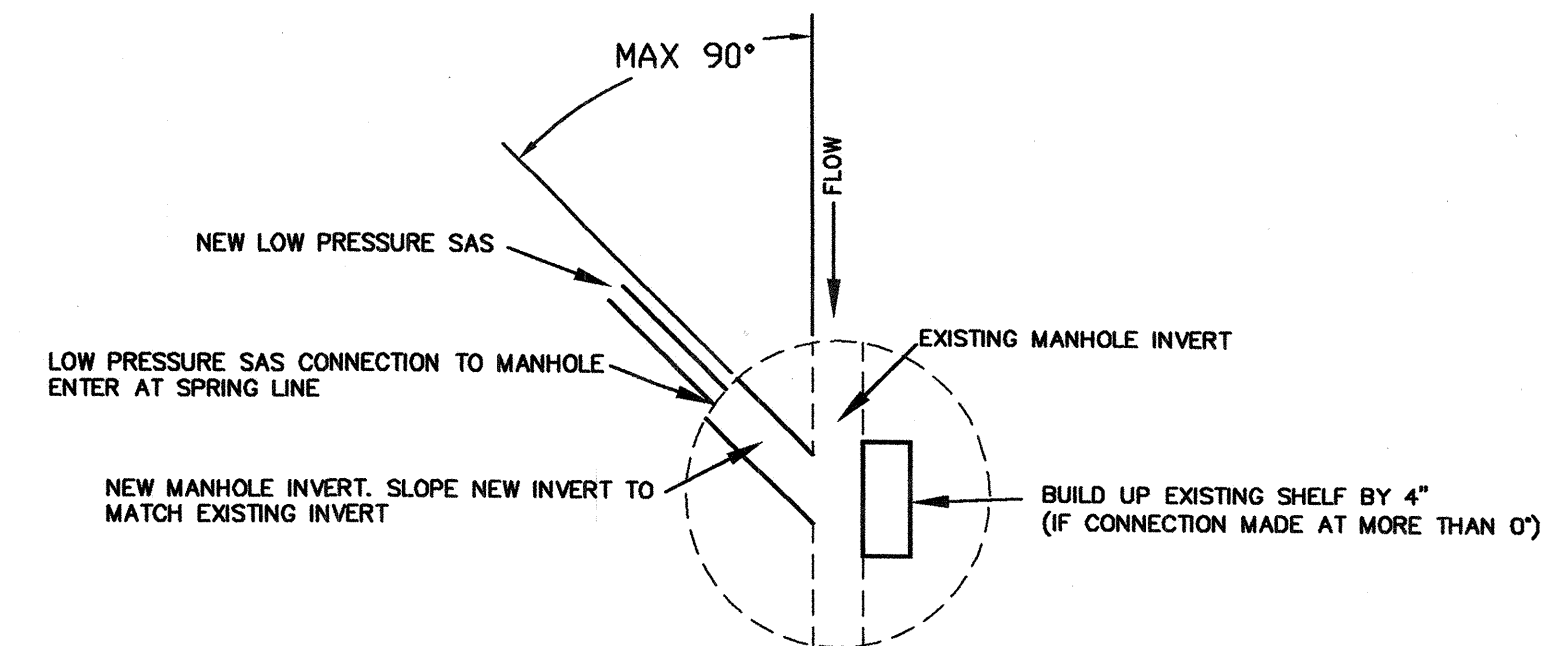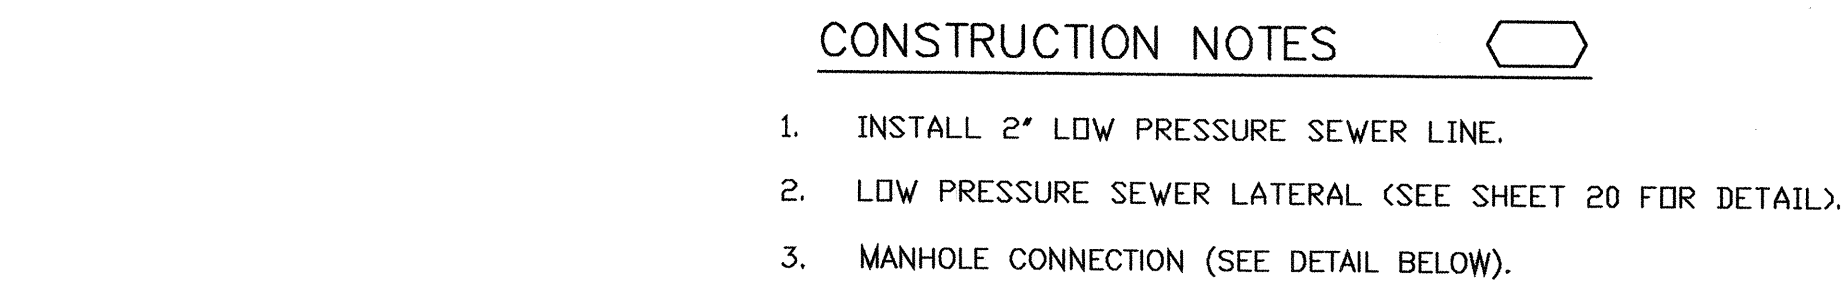

LOW PRESSURE SAS CONNECTION TO MANHOLE

SCALE: 1"=40'

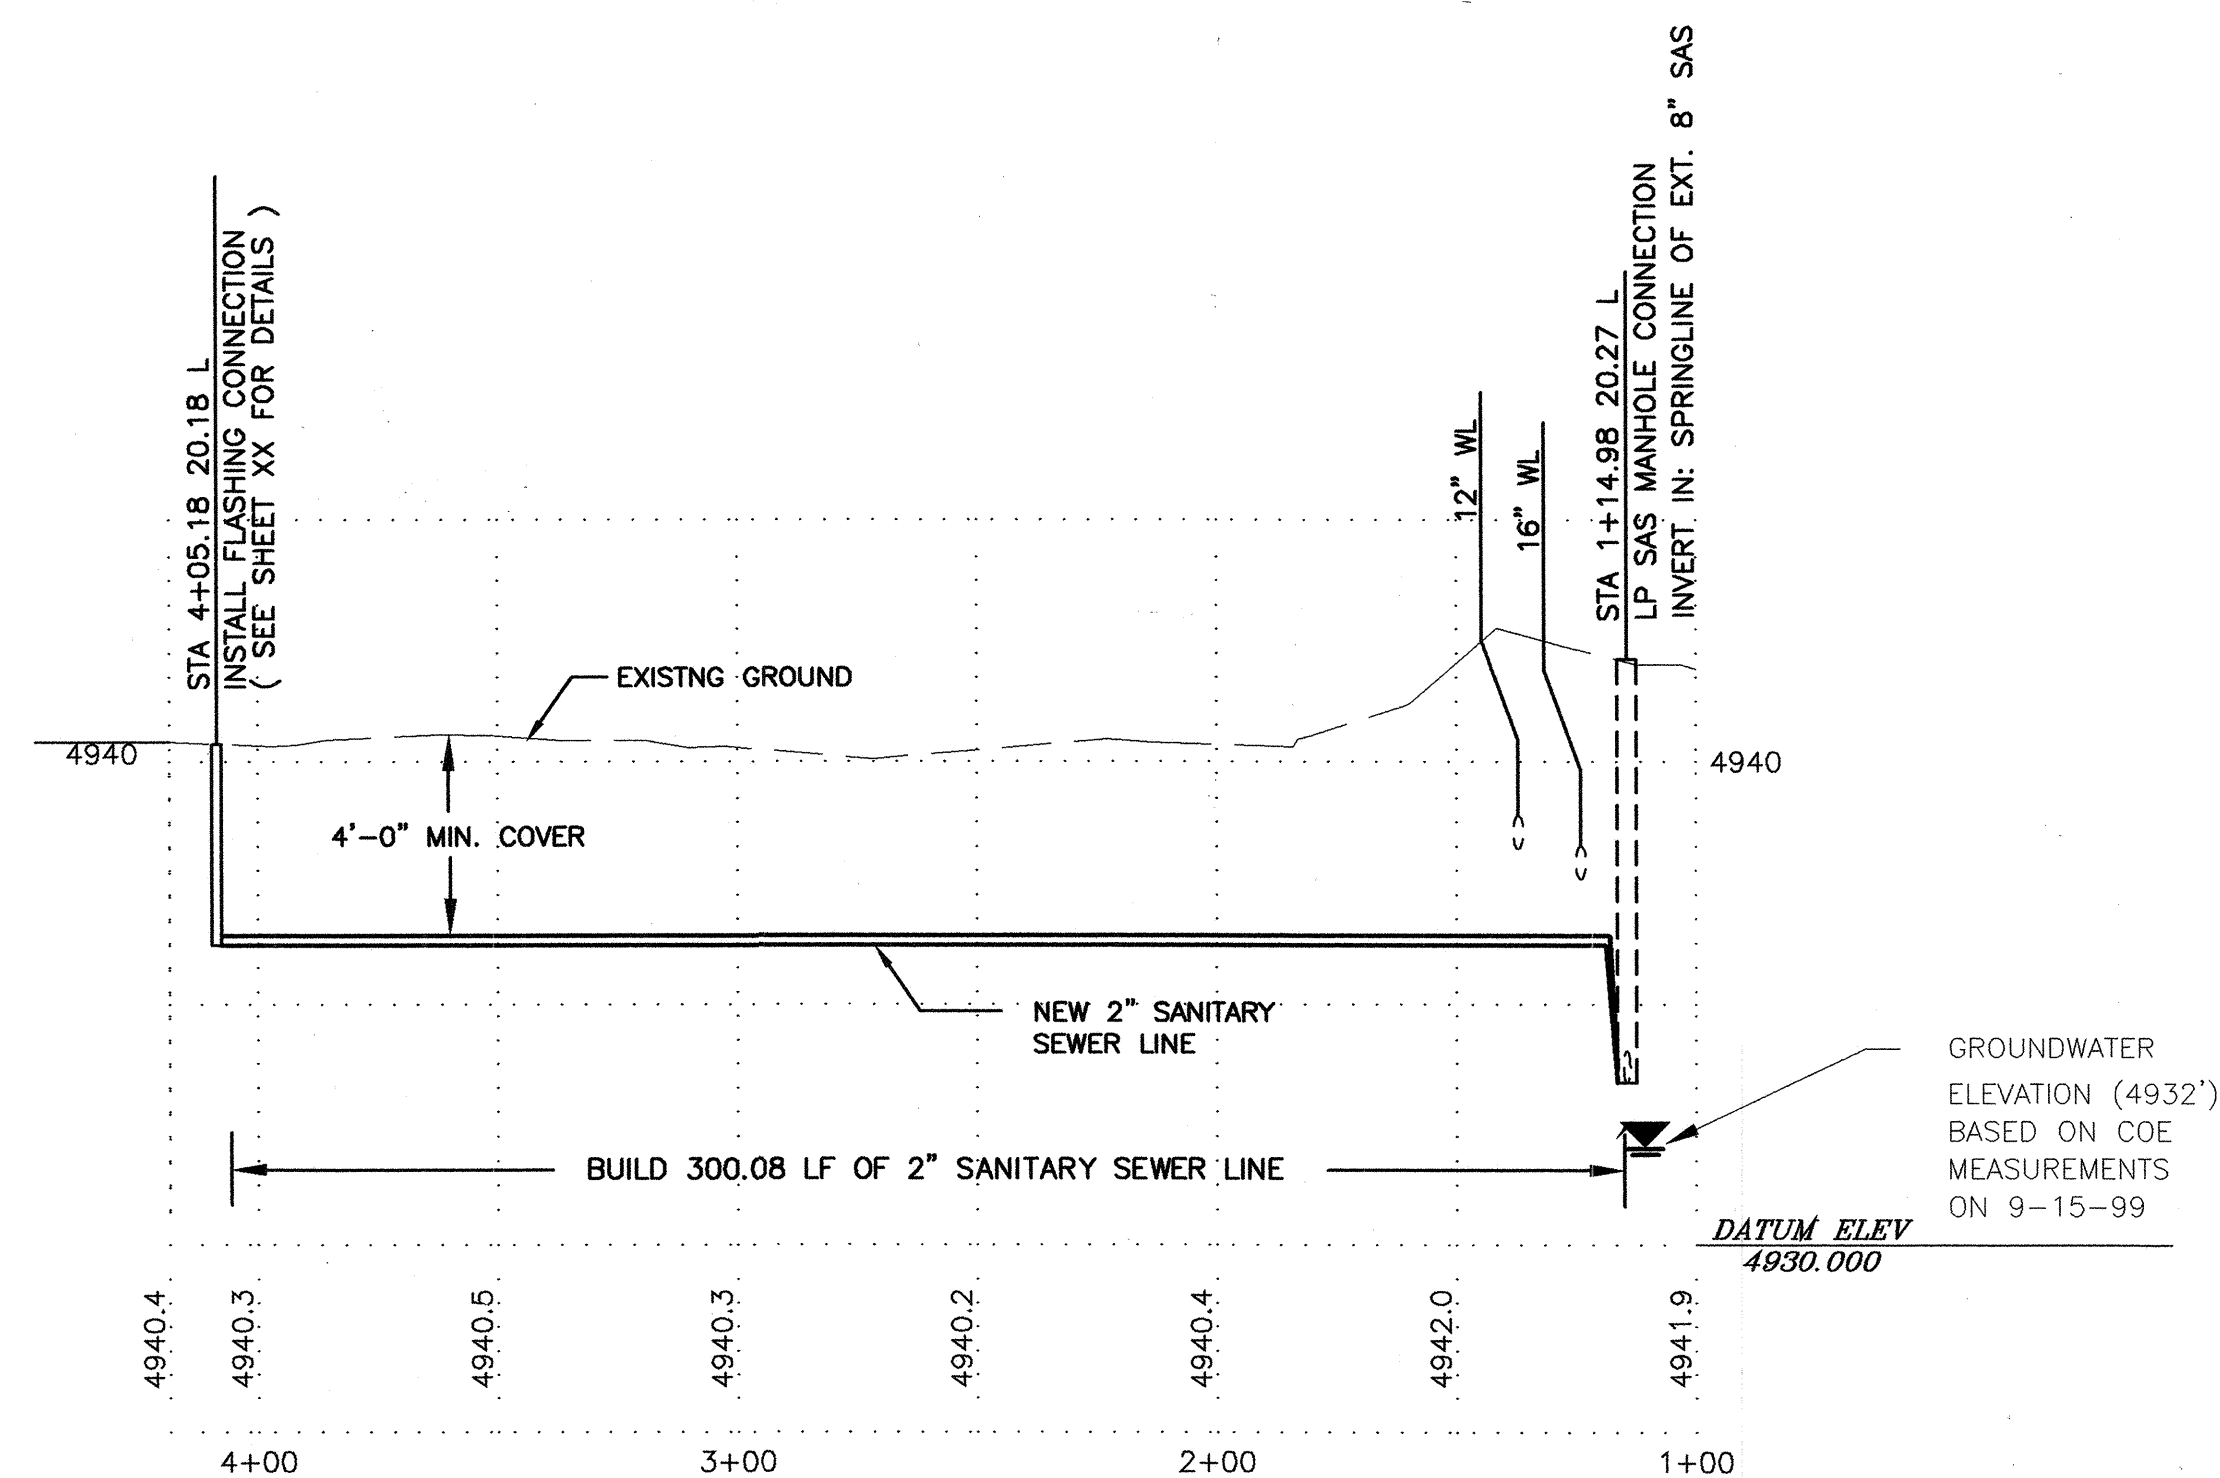

SCALE:
HORIZ: 1"=40'
VERT: 1"=4'


4" SANITARY SEWER / WATER SERVICES						
ADDRESS	LEGAL DISCRPTION	STATION	ELEV. @ PIPE (FT)	ELEV. @ PROP. LINE (FT)	SAS LENGTH	WATER STATION
803 ATRISCO RD SW	TR A LANDS OF	1+63.52 to 2+51.1			6.00	N/A
807 ATRISCO RD SW	TR B LANDS OF	2+12.48 to 2+63.6	4936.50	4935.00	8.00	N/A
811 ATRISCO RD SW	TR 65A3 & 65B1C MRGCD MAP 42	3+00.57 to 3+06.6	4936.50	4935.00	11.00	N/A
803 ATRISCO RD SW	TR 36B 65A2 & 65B1B MRGCD MAP 42	3+06.60 to 2+78.1	4936.50	4935.00	11.00	N/A

CONTROL POINT DATA TABLE (GROUND COORDINATES)				
POINT NAME	COUNTY PROJ #	NORTHING	EASTING	ELEVATION
AEC CP1	412	75,185.686	74,574.108	4940.514
AEC CP2	412	75,105.493	74,863.663	4942.647

MONUMENT DATA TABLE			
CITY MONUMENT	NORTHING	EASTING	ELEVATION
17-L12	73,647.267	77,731.490	4942.877
NM 45-4A	74,722.348	71,839.254	5003.016

1- ALL CONTROL POINTS ARE 2" ALUM CAP STAMPED AEC CP 1 OR 2.
2- COORDINATES ARE IN THE WGS 1984/NAD27 DATUM AND
ELEVATIONS ARE IN THE NAVD29 DATUM.

	BERNALILLO COUNTY PUBLIC WORKS DIVISION TECHNICAL SERVICES			
TITLE: FOOTHILL/BRIDGE INFILL AREA SEWER AND WATER IMPROVEMENTS AREA 412 – PRIVATE ROAD				
Design Review Committee	City Engineer Approval	Last Design Update	Mo./Day/Yr.	Mo./Day/Yr.
City Project No. 747881 County Project No. TS01-20		Zone Map No. L12	Sheet 15 Of 25	

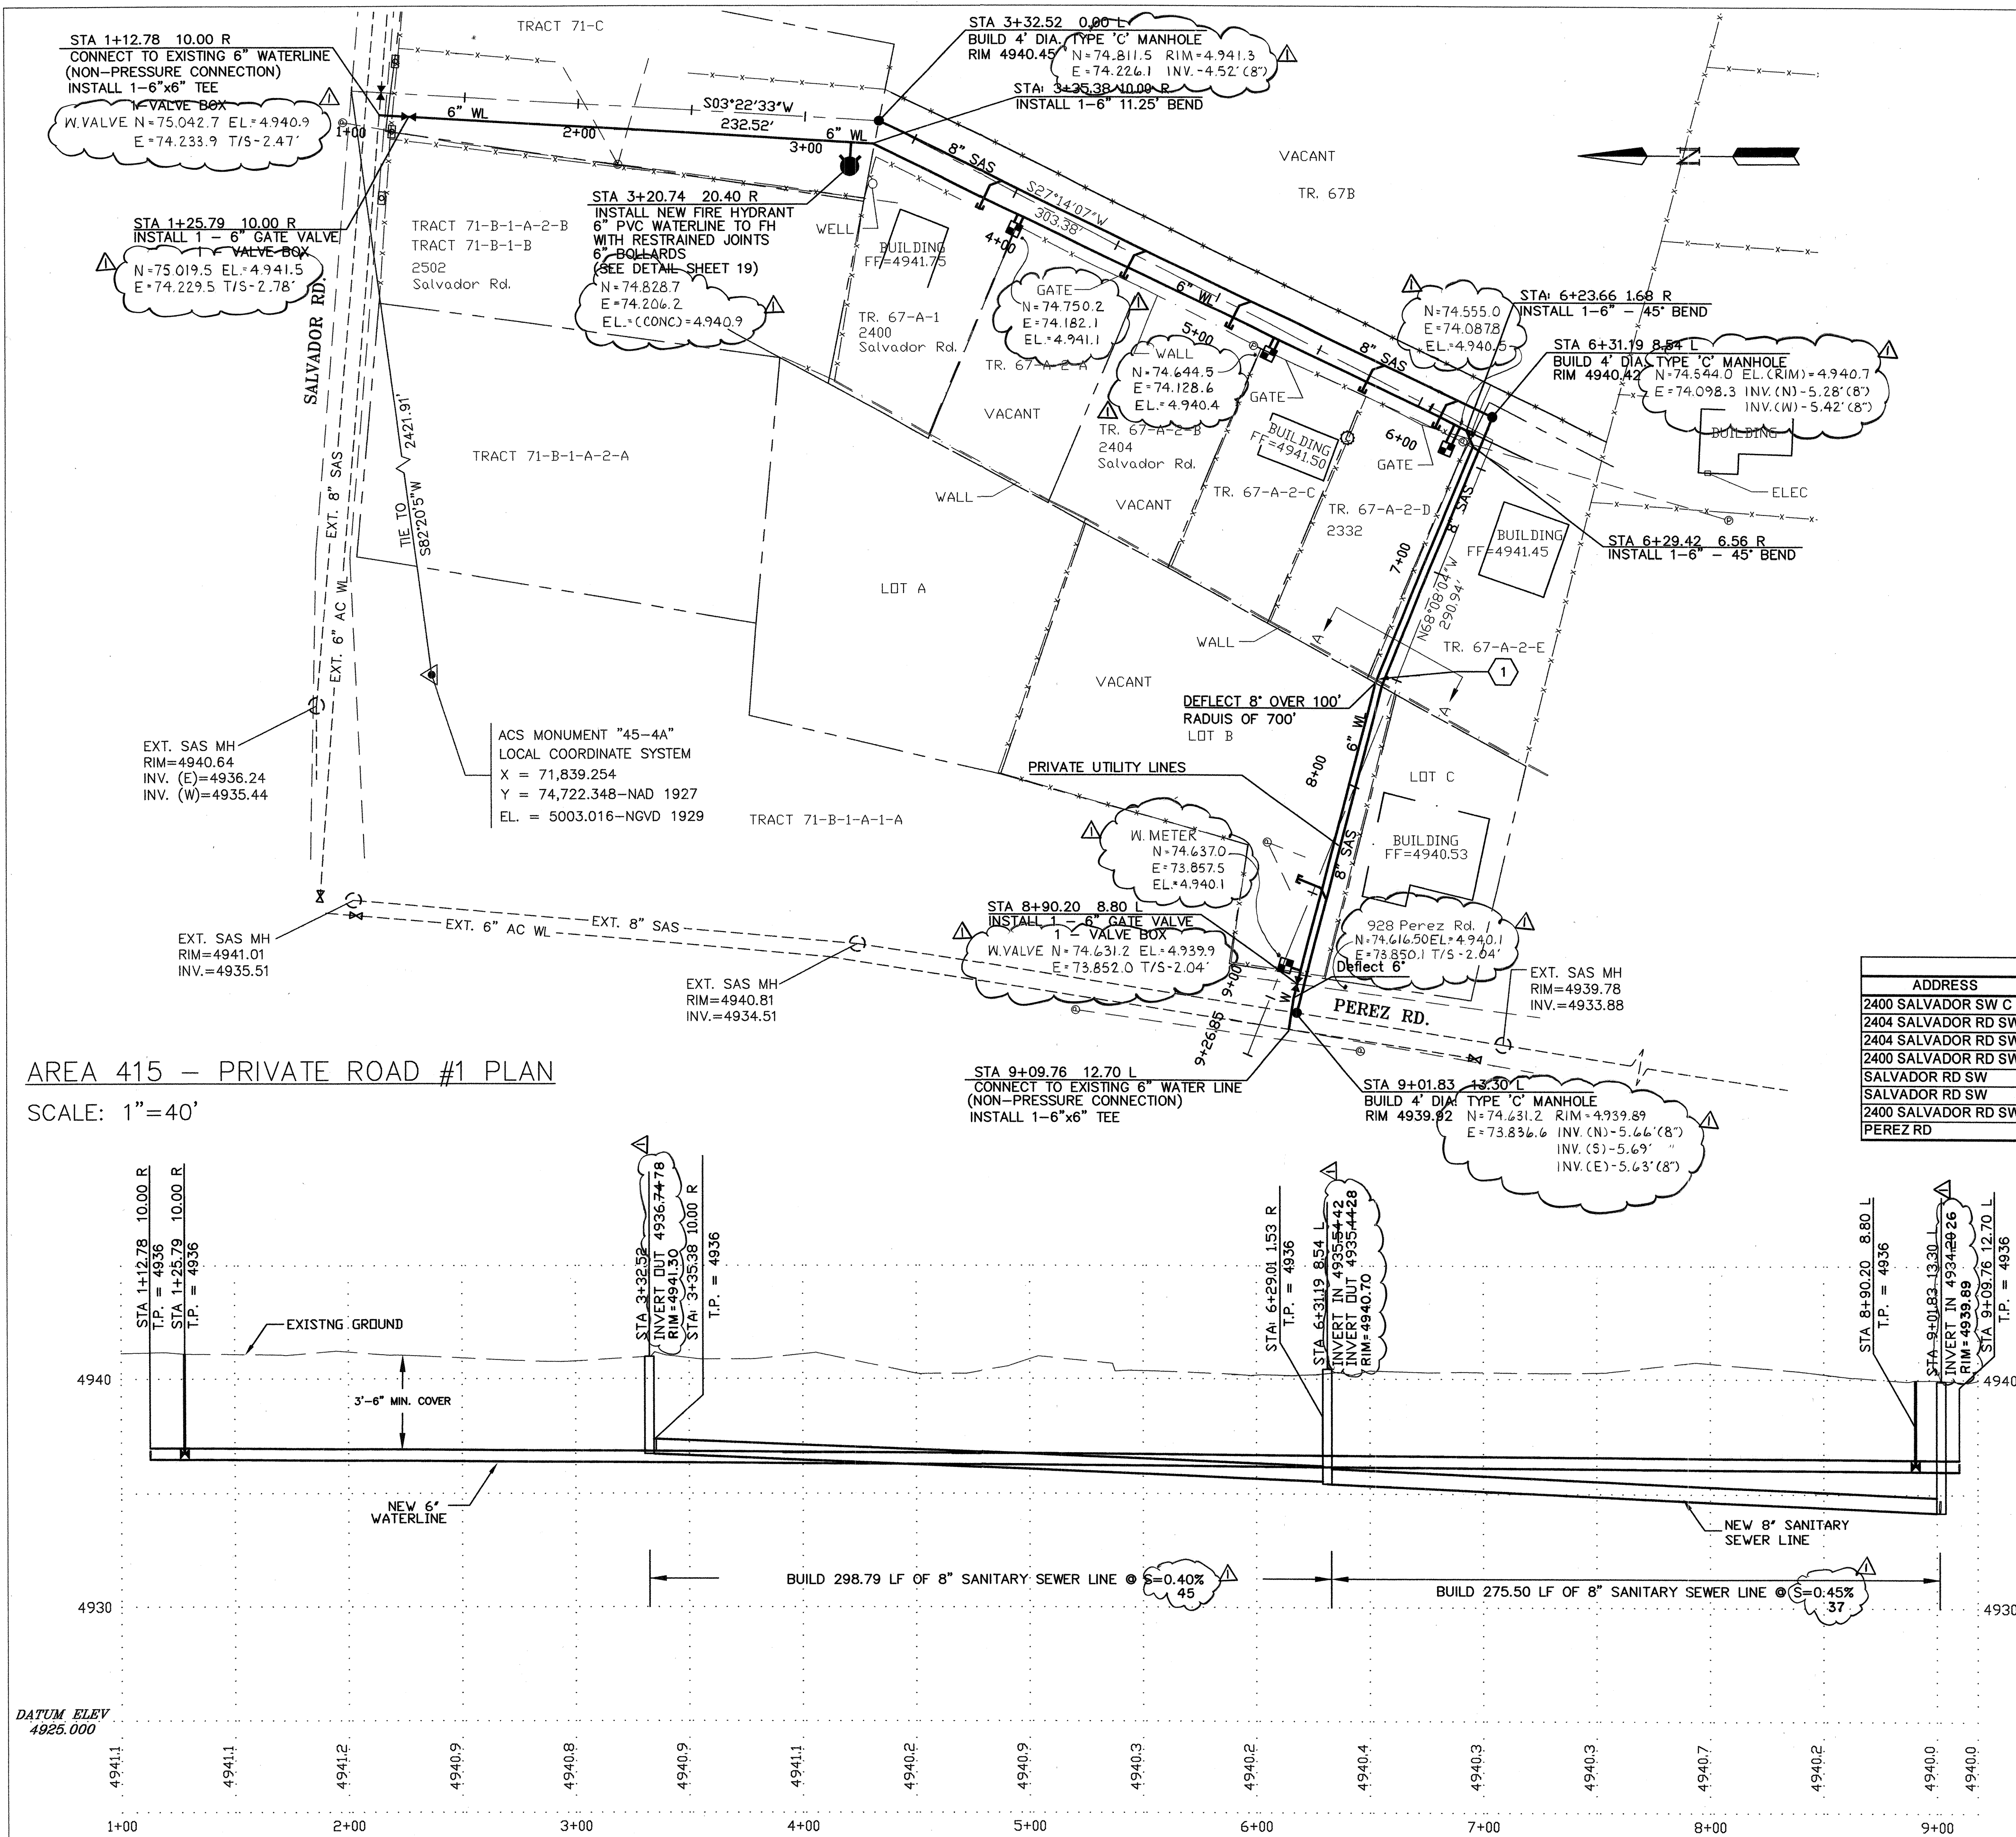

AREA 415 - PRIVATE ROAD #1 PROFILE


SCALE:
HORIZ: 1"=40'
VERT: 1"=4'

WATER SHUT-OFF PLAN

1. THE WATER SYSTEMS DIVISION (857-8200) WILL BE NOTIFIED BY THE CONTRACTOR SEVEN (7) WORKING DAYS IN ADVANCE OF ANY WORK WHICH MAY AFFECT THE EXISTING PUBLIC WATER FACILITIES. REFER TO SECTION 18 OF STANDARD SPECIFICATIONS.
2. ONLY CITY WATER SYSTEMS DIVISION EMPLOYEES MAY OPERATE VALVES.
3. BUILD WATERLINE AS SHOWN, PRESSURE TEST AND DISINFECT WATERLINE PER SPECIFICATIONS.
4. CLOSE VALVES 532 IN PEREZ, 481, 482 & 152 SALVADOR AND CONNECT TO EXISTING WATER FACILITIES.
5. OPEN ALL VALVES.

CONSTRUCTION NOTES

1. SEWER PIPE FROM STA 6+32.99 TO STA 9+01.22 SHALL BE PRESSURE RATED (125 psi) PLASTIC PIPE AND BE PRESSURE TESTED TO ASSURE WATER TIGHTNESS.

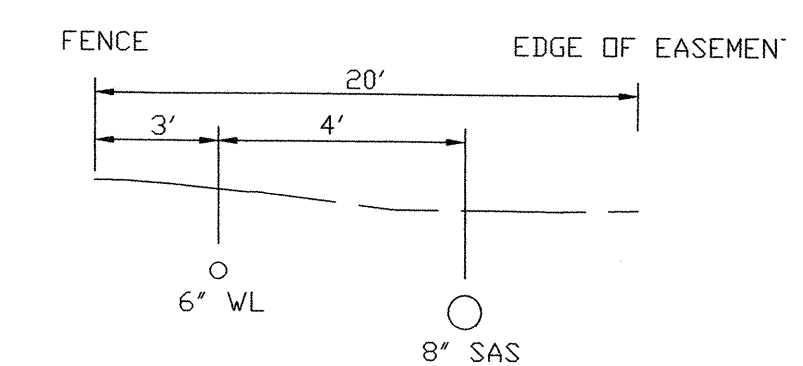


4" SANITARY SEWER / WATER SERVICES						
ADDRESS	LEGAL DISCRPTION	STATION	ELEV. @ PIPE (FT)	ELEV. @ PROP. LINE (FT)	SAS LENGTH	WATER STATION
2400 SALVADOR SW C	MAP 42 TR 67 A1	3+42.391.71 L	4937.17	4937.30	13.00	4+14.23 7.97 R
2404 SALVADOR RD SW	MAP 42 TR 67 A2A	4+52.48 3.71 L	4936.88	4937.01	13.00	4+14 7.89 R
2404 SALVADOR RD SW	MAP 42 TR 67 A2B	4+89.77 5.18 L	4936.68	4936.81	13.00	5+32.84 4.38 R
2400 SALVADOR RD SW	MAP 42 TR 67 A2C	5+29.71 7.04 L	4936.42	4936.55	13.00	5+32.33 4.31 R
SALVADOR RD SW	MAP 42 TR 67B	6+01.83 7.70 L	4936.34	4936.47	13.00	6+05.39 2.21 R
SALVADOR RD SW	MAP 42 TR 67 A2D	5+92.57 8.06 L	4936.28	4936.41	13.00	6+29.78 1.85 R
2400 SALVADOR RD SW	MAP 42 TR 67 A2E	7+09.66 2.81 L	4936.11	4936.24	13.00	6+29.48 1.78 R
PEREZ RD	" B LANDS OF ONOFRE	8+11.34 6.57 L	4934.80	4934.93	13.00	8+87.15 8.04 L

CONTROL POINT DATA TABLE (GROUND COORDINATES)				
POINT NAME	COUNTY PROJ #	NORTHING	EASTING	ELEVATION
AEC CP1	415	75,046.844	74,251.427	4941.173
AEC CP2	415	75,067.316	73,913.862	4940.804

MONUMENT DATA TABLE			
CITY MONUMENT	NORTHING	EASTING	ELEVATION
NM 45-4A	74,722.348	71,839.254	5003.016

1- ALL CONTROL POINTS ARE 2" ALUM CAP STAMPED AEC CP 1 OR 2.
2- COORDINATES ARE IN THE WGS 1984/NAD27 DATUM AND ELEVATIONS ARE IN THE NGVD29 DATUM.


		BERNALILLO COUNTY PUBLIC WORKS DIVISION TECHNICAL SERVICES	
TITLE: FOOTHILL/BRIDGE INFILL AREA SEWER AND WATER IMPROVEMENTS AREA 415 - PRIVATE ROAD #1			
Design Review Committee	City Engineer Approval	Mo./Day/Yr.	
Last Design Update		Mo./Day/Yr.	
City Project No. 747881	Zone Map No. L-11 & 12	Sheet 16	Of 25
County Project No. TS01-20			

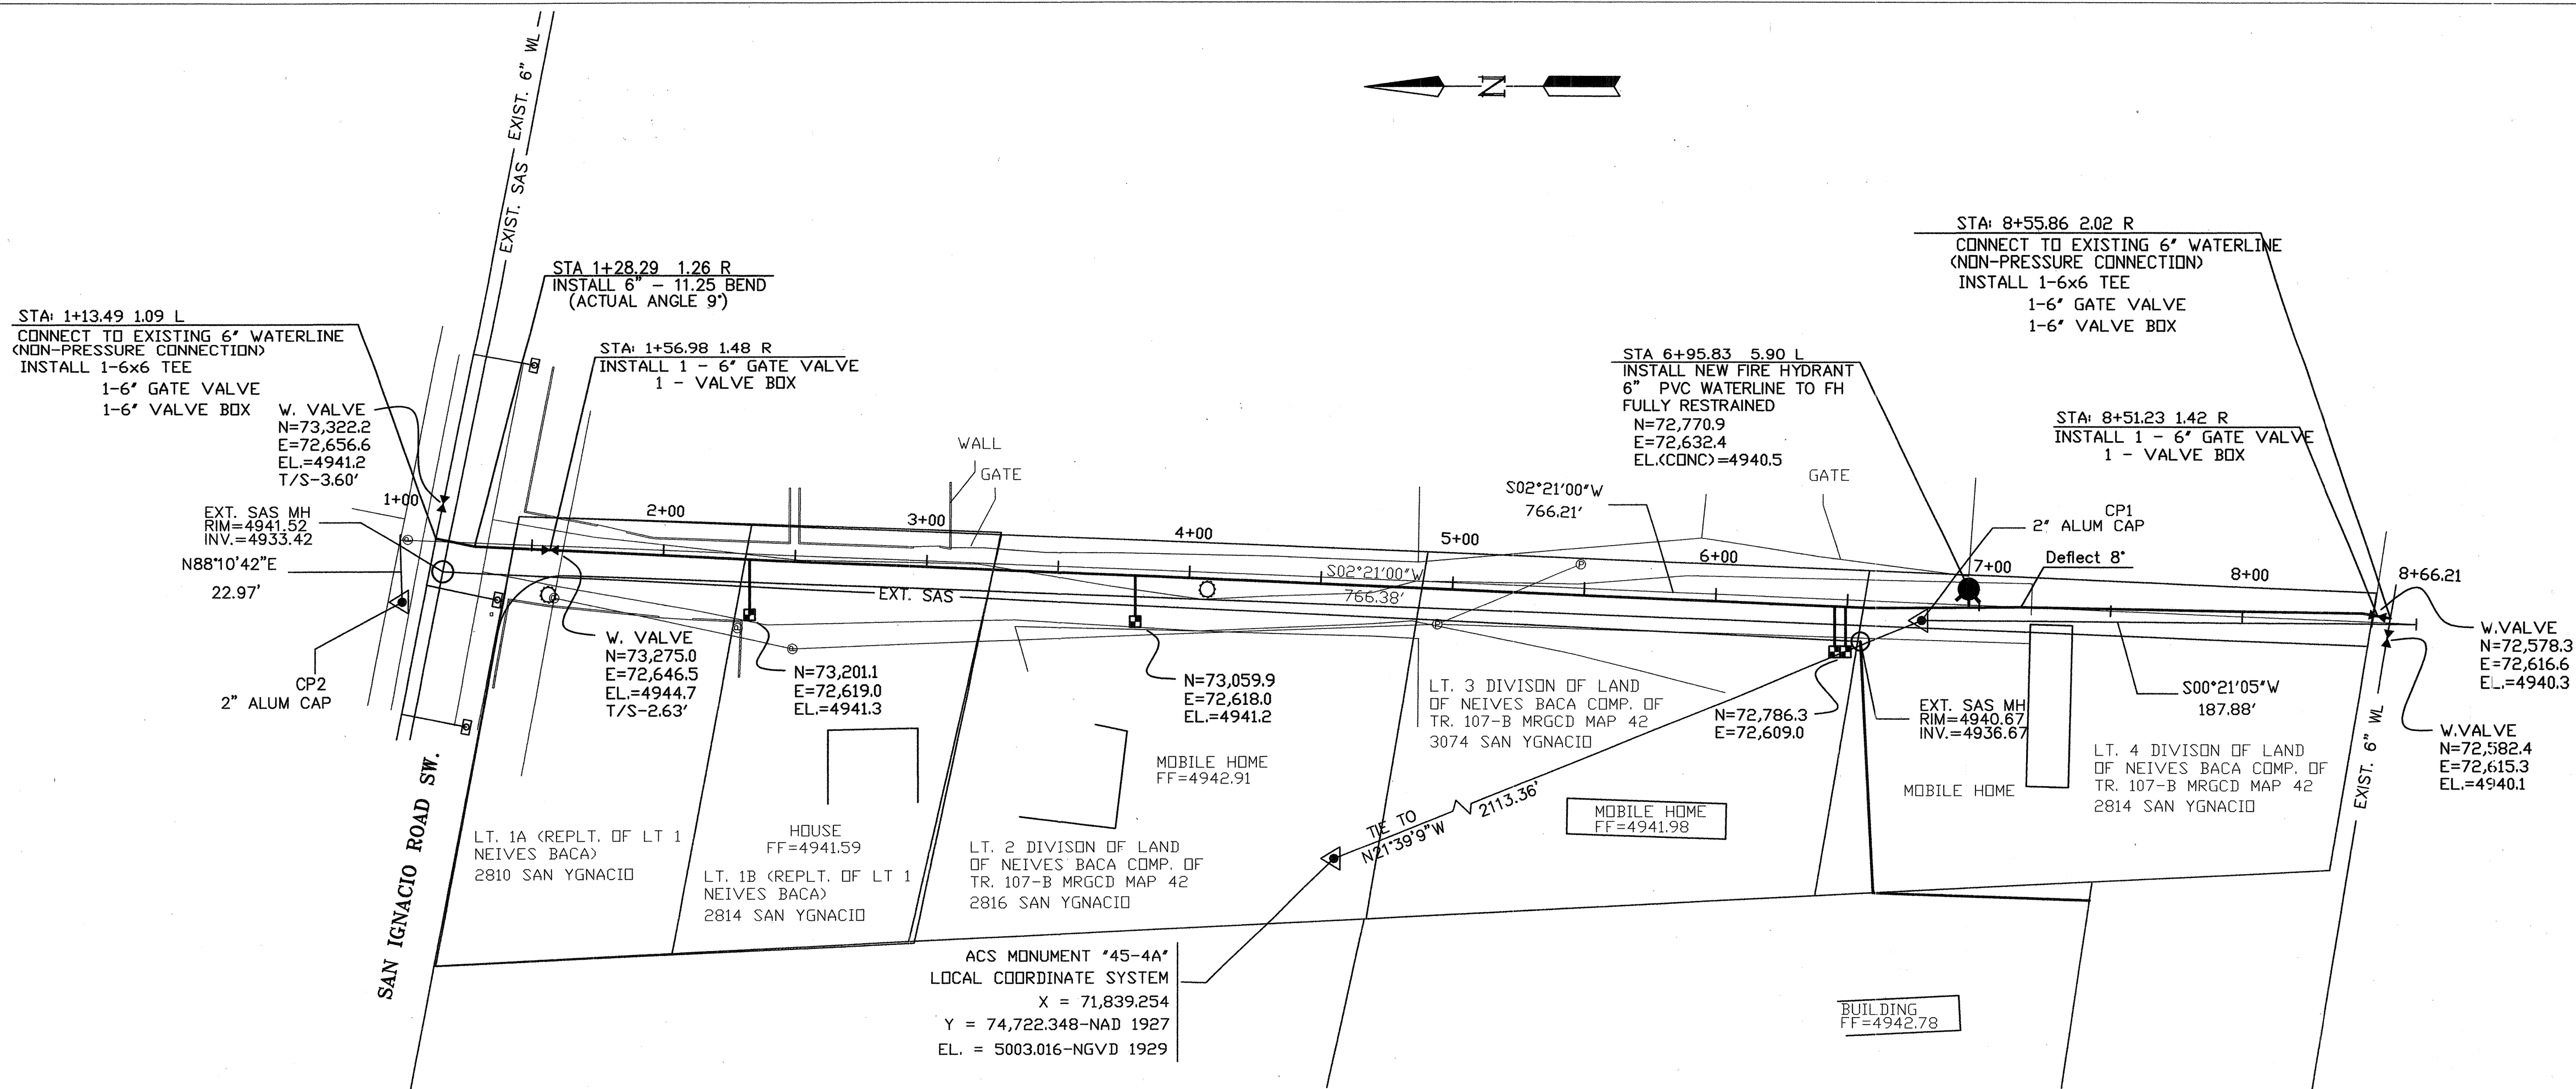

AREA 422 - PRIVATE ROAD PLAN

SCALE:
HORIZ: 1"=40'

WATER SERVICES				
ADDRESS	LEGAL DISCRPTION	ELEV. @ PIPE (FT)	ELEV. @ PROP. LINE (FT)	WATER STATION
2814 SAN YGNACIO SW	LT. 1B (REPLT. CF LT. 1 NERVES BACA)	4940.70	4941.00	2+32.80 2.08 R
2814 SAN YGNACIO SW	LT. 2 DIVISION OF LAND OF NEIVES BACA	4940.63	4940.64	3+78.47 2.32 R
3074 SAN YGNACIO SW	LT. 3 DIVISON OF LAND OF NEIVES BACA	4940.41	4940.66	6+45.17 2.65 R
2814 SAN YGNACIO SW	LT. 4 DIVISON OF LAND OF NEIVES BACA	4940.39	4940.66	6+49.34 2.63 R

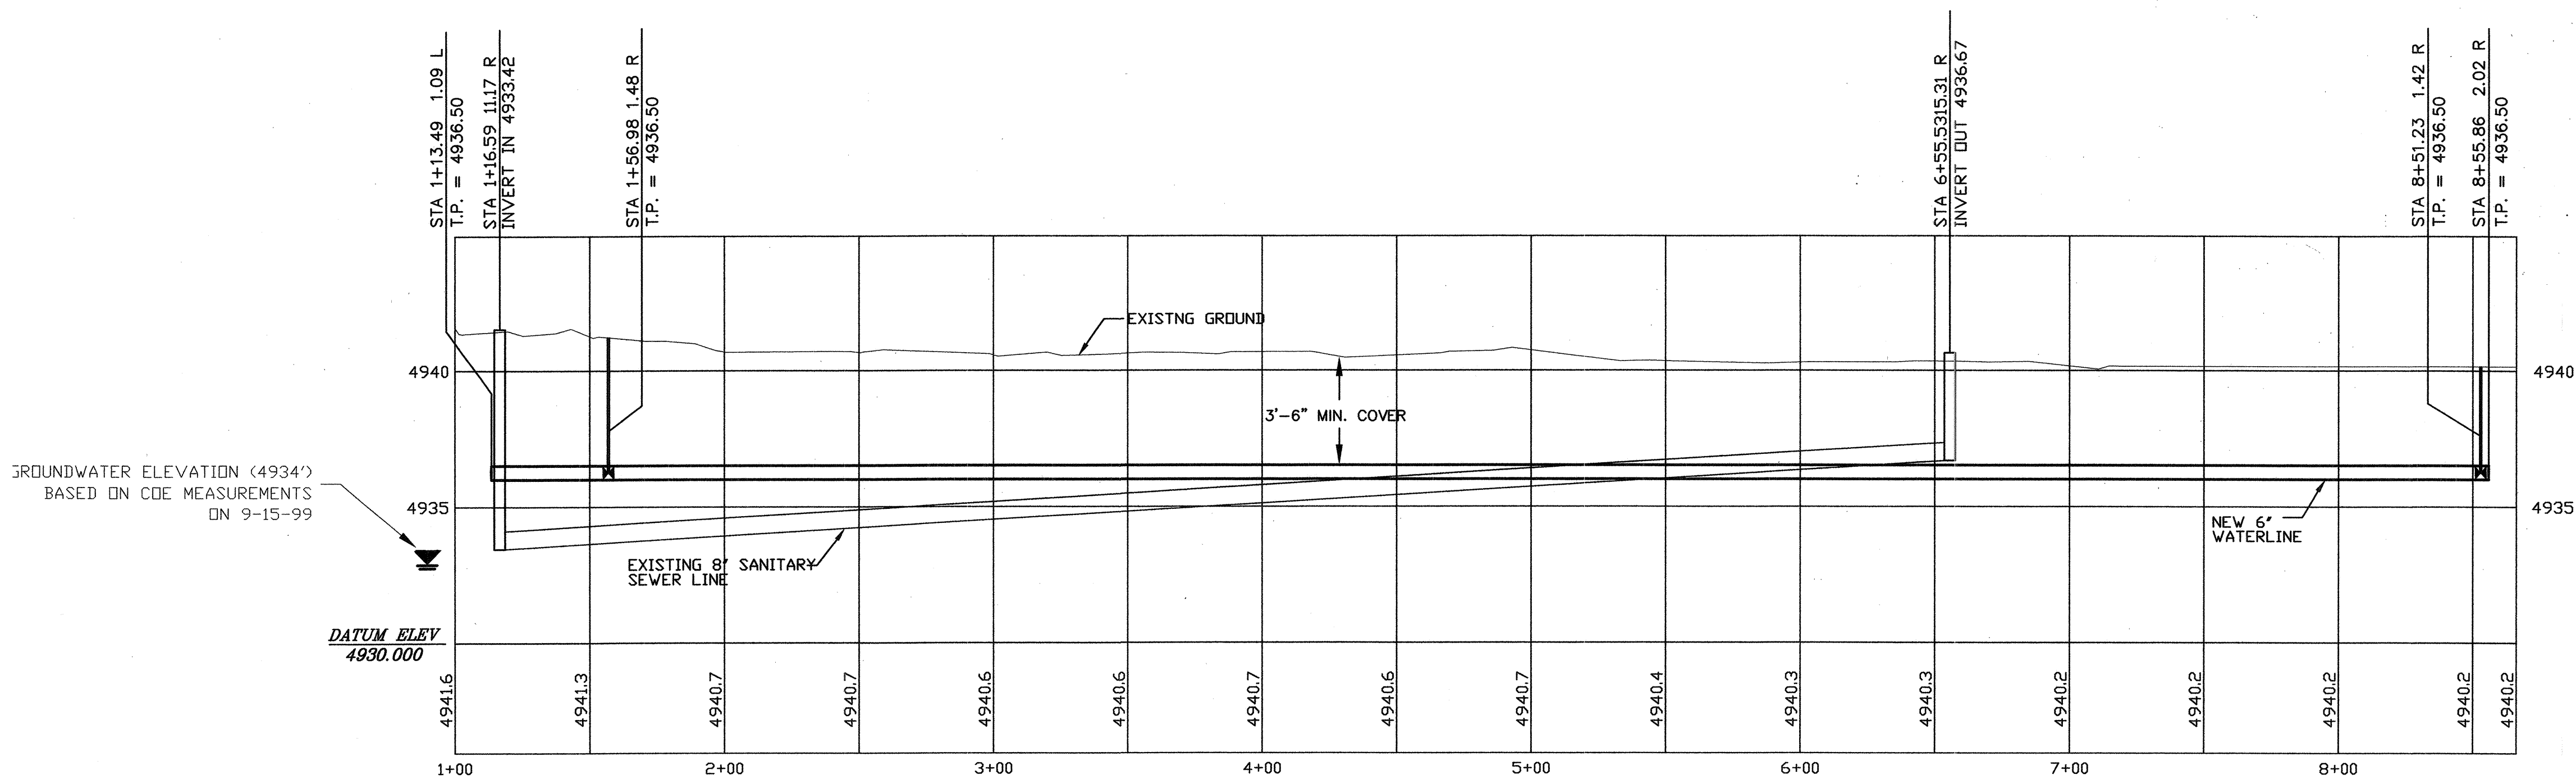

AREA 422 - PRIVATE ROAD PROFILE

SCALE:
HORIZ: 1"=40'
VERT: 1"=4'

WATER SHUT-OFF PLAN

- 1 THE WATER SYSTEMS DIVISION (857-8200) WILL BE NOTIFIED BY THE CONTRACTOR SEVEN (7) WORKING DAYS IN ADVANCE OF ANY WORK WHICH MAY AFFECT THE EXISTING PUBLIC WATER FACILITIES. REFER TO SECTION 18 OF STANDARD SPECIFICATIONS.
- 2 ONLY CITY WATER SYSTEMS DIVISION EMPLOYEES MAY OPERATE VALVES.
- 3 BUILD WATERLINE AS SHOWN, PRESSURE TEST AND DISINFECT WATERLINE PER SPECIFICATIONS.
- 4 CLOSE VALVES 561 IN JUSTO, 951 AND 972 IN SAN YGNACIO, 1072 IN BENNY, 1062 IN JUANITA, 1011 IN FOOTHILL AND CONNECT TO EXISTING WATER FACILITIES.
- 5 OPEN ALL VALVES.

AS BUILT INFORMATION				BENCH MARKS				SURVEY INFORMATION				ENGINEER'S SEAL			
CONTRACTOR	NM UNDERGROUND	WORKED BY	ALB SURVEYING CO	DATE	12/05	NO.	DATE	NO.	DATE	NO.	DATE	NO.	DATE	NO.	
INSPECTOR'S ACCEPTANCE BY	BCPW	DATE	6/06	DATE	6/06	DATE	6/06	DATE	6/06	DATE	6/06	DATE	6/06	DATE	
DRAWING BY	BCPW	DATE	9/06	DATE	9/06	DATE	9/06	DATE	9/06	DATE	9/06	DATE	9/06	DATE	
MICRO-FILM INFORMATION				RECORDING BY				NO.							



CONTROL POINT DATA TABLE (GROUND COORDINATES)				
POINT NAME	COUNTY PROJ #	NORTHING	EASTING	ELEVATION
AEC CP1	422	72,619.034	72,758.113	4940.448
AEC CP2	422	72,626.341	73,335.065	4940.765

MONUMENT DATA TABLE			
CITY MONUMENT	NORTHING	EASTING	ELEVATION
7-M1	70,469.374	70,536.426	4966.013
NM 45-4A	74,722.348	71,839.254	5003.016

- 1- ALL CONTROL POINTS ARE 2" ALUM CAP STAMPED AEC CP 1 OR 2.
2- COORDINATES ARE IN THE WGS 1984/NAD27 DATUM AND ELEVATIONS ARE IN THE NGVD29 DATUM.

BERNALILLO COUNTY PUBLIC WORKS DIVISION TECHNICAL SERVICES			
TITLE: FOOTHILL/BRIDGE INFILL AREA SEWER AND WATER IMPROVEMENTS AREA 422-PRIVATE ROAD			
Design Review Committee	City Engineer Approval	Mo./Day/Yr.	Mo./Day/Yr.
City Project No. 747881	Zone Map No. L-11	Sheet 17	Of 25
County Project No. TS01-20			

ADD TO CONTRACT SEE NEXT SH.

WATER SHUT-OFF PLAN

1. THE WATER SYSTEMS DIVISION (857-8200) WILL BE NOTIFIED BY THE CONTRACTOR SEVEN (7) WORKING DAYS IN ADVANCE OF ANY WORK WHICH MAY AFFECT EXISTING PUBLIC WATER FACILITIES. REFER TO SECTION 18 OF THE SPECIFICATIONS.
2. ONLY CITY WATER SYSTEMS DIVISION EMPLOYEES MAY OPERATE VALVES.
3. BUILD WATER SHUT-OFF TRENCHES SHOWN, PRESSURE MAINS AND DISCHARGE MAINS PER SPECIFICATIONS.
4. OPEN ALL VALVES 561 IN JUSTO, 951 AND 972 IN SAN YGNACIO, 1072 IN BENNY, 1022 IN JUANITA, 1011 IN FOOTHILL AND CONNECT TO EXISTING WATER FACILITIES. OPEN ALL VALVES.

STA: 1+13.49 1.09 L
CONNECT TO EXISTING 6" WATERLINE
(NON-PRESSURE CONNECTION)
INSTALL 1-6" GATE VALVE
1-6" VALVE BOX


STA: 1+28.29 1.26 R
INSTALL 6" - 11.25 BEND
(ACTUAL ANGLE 9°)

STA: 1+56.98 1.48 R
INSTALL 1-6" GATE VALVE
1-6" VALVE BOX

STA: 8+55.86 2.02 R
CONNECT TO EXISTING 6" WATERLINE
(NON-PRESSURE CONNECTION)
INSTALL 1-6x6 TEE
1-6" GATE VALVE
1-6" VALVE BOX


STA: 6+55.53 5.22 R
INSTALL NEW FIRE HYDRANT
6" PVC WATERLINE TO FH
FUEL RESTRAINED

STA: 8+51.23 1.42 R
INSTALL 1-6" GATE VALVE
1-6" VALVE BOX

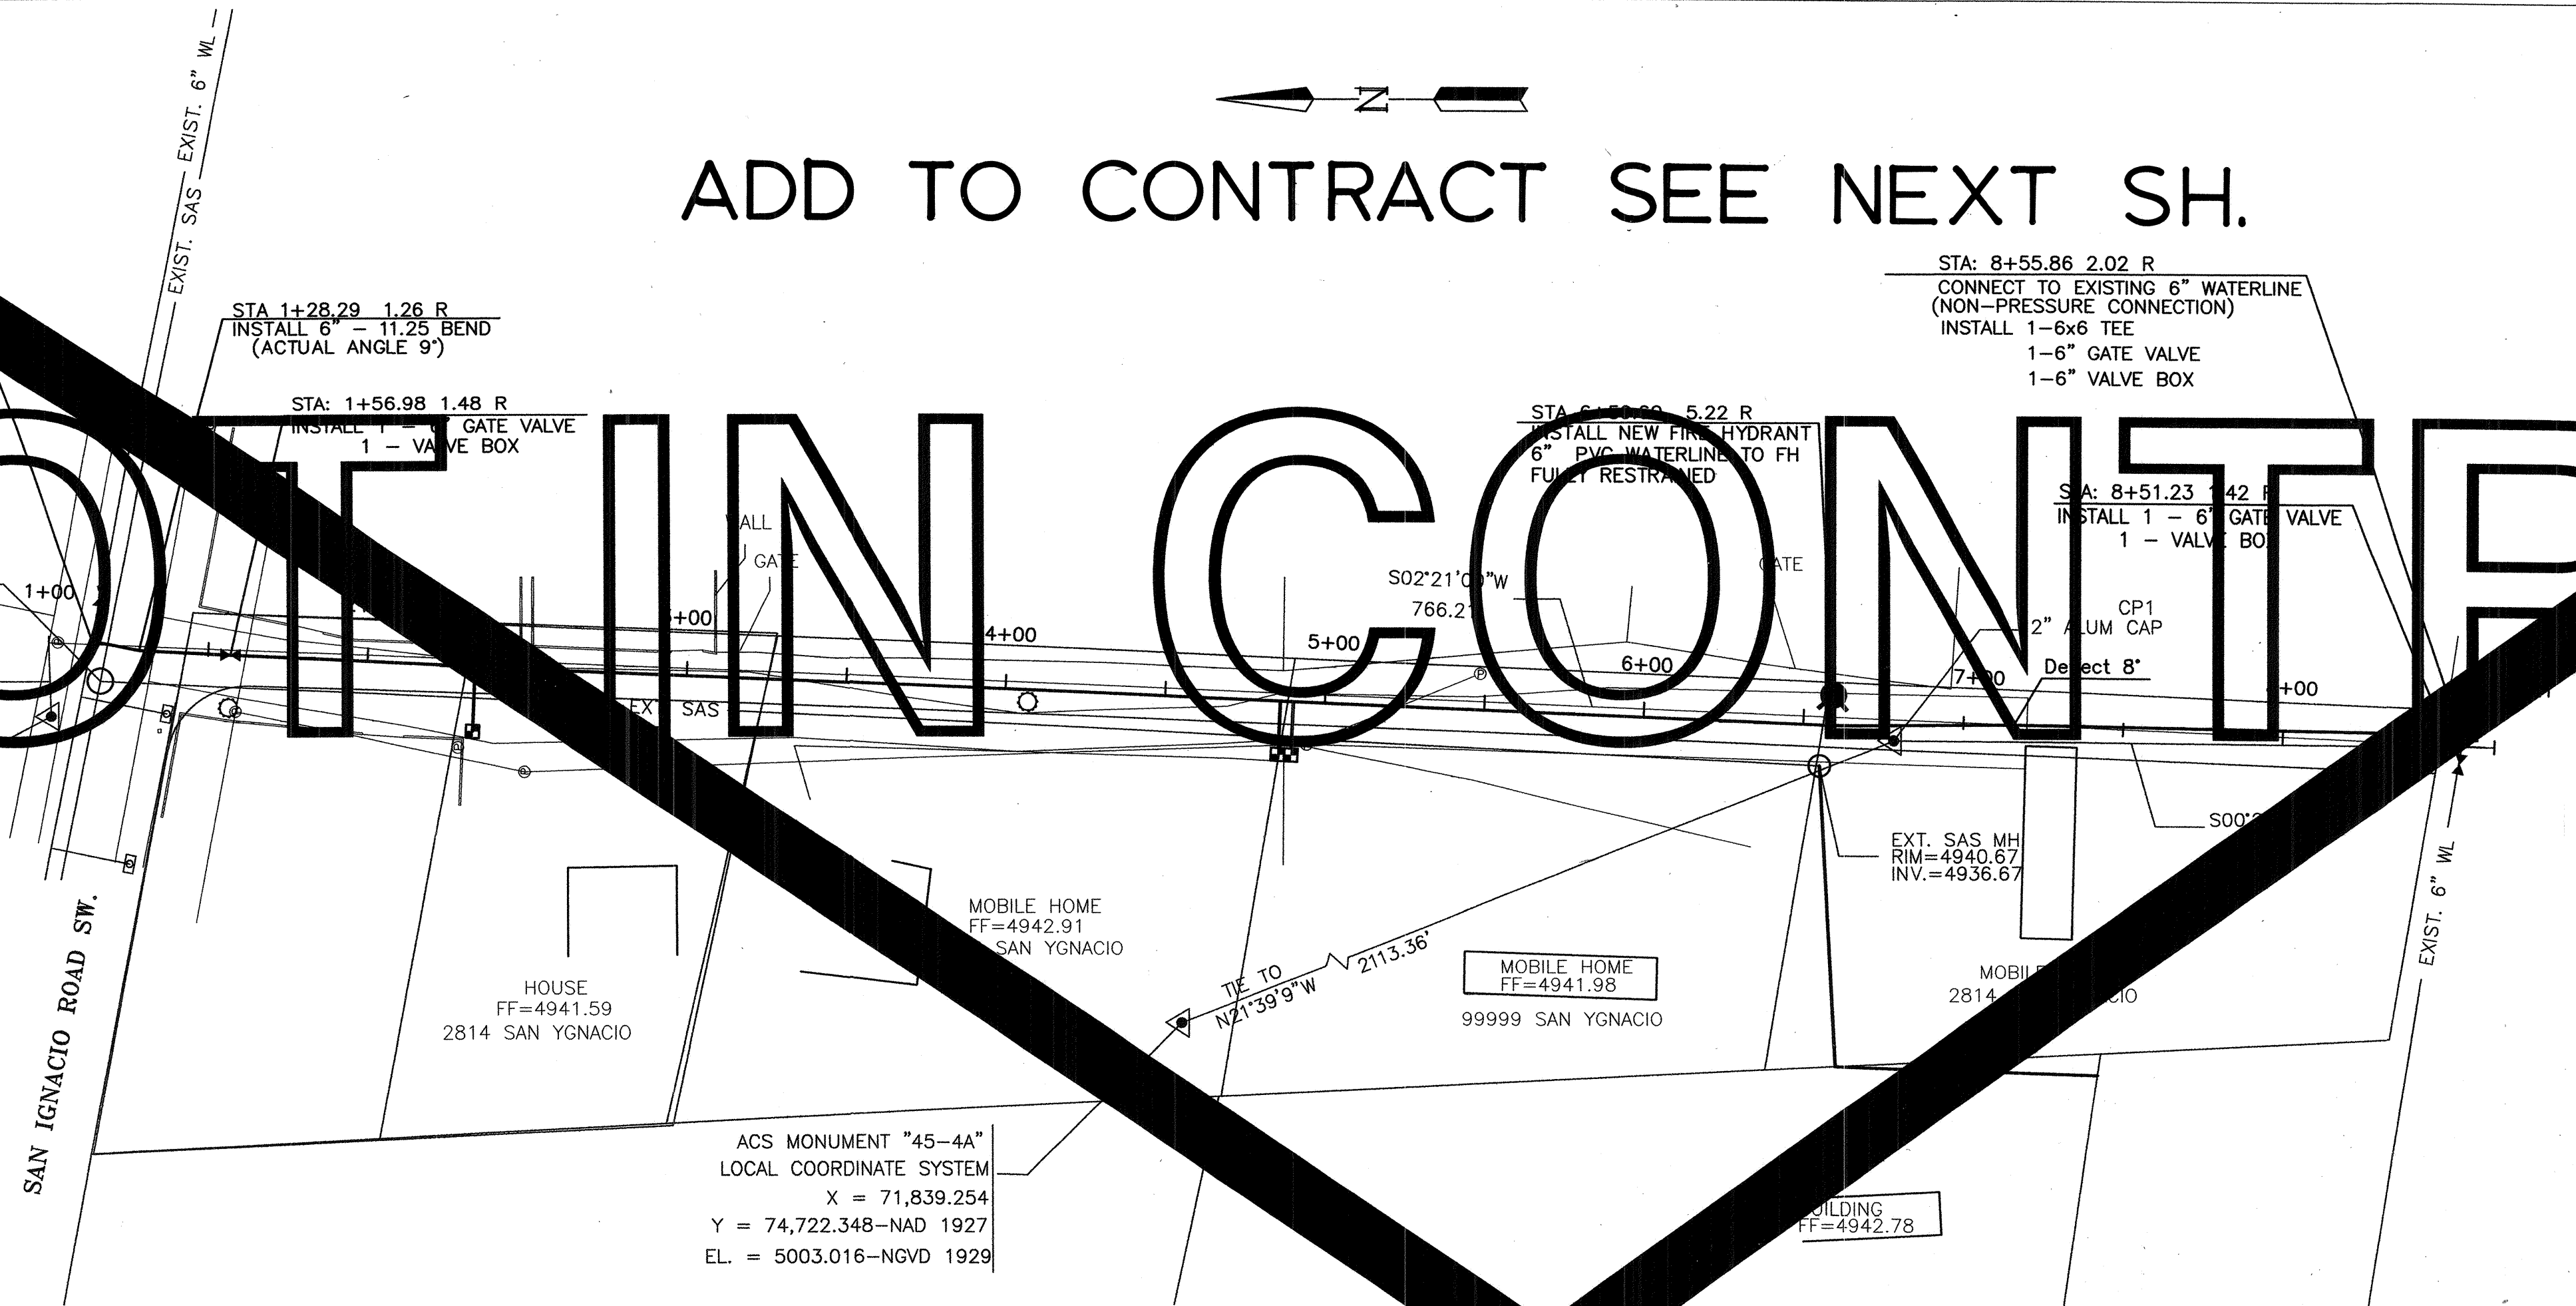

AREA 422 - PRIVATE ROAD PLAN

SCALE:
HORIZ: 1"=40'

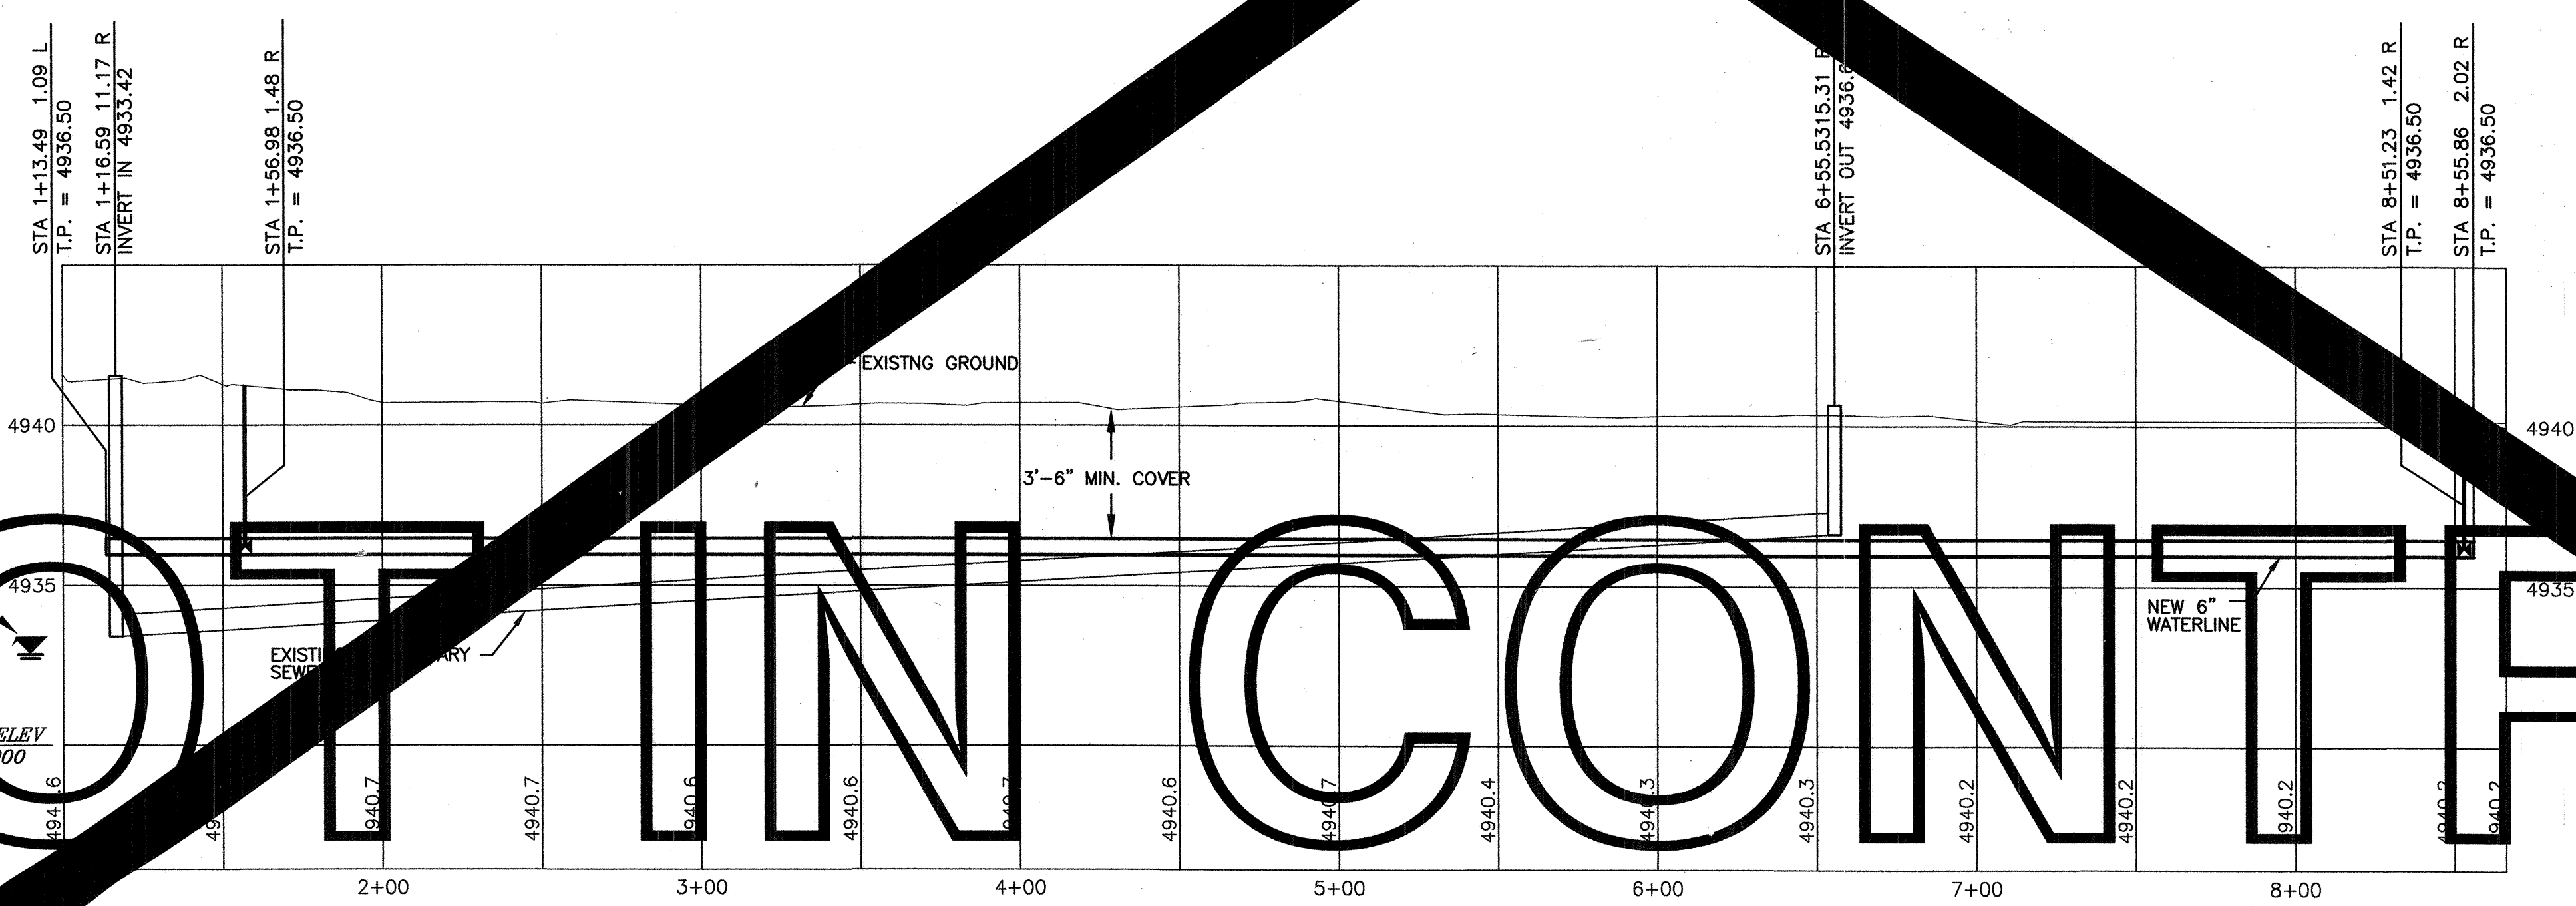

AREA 422 - PRIVATE ROAD PROFILE


SCALE:
HORIZ: 1"=40'
VERT: 1"=4'

CONTROL POINT DATA TABLE (GROUND COORDINATES)			
POINT NAME	COUNTY PROJ #	NORTHING	EASTING
AEC CP1	42	72,619.03	72,758.113
AEC CP2	42	72,629.341	72,758.113

MONUMENT DATA TABLE			
CITY PROJ #	NORTHING	EASTING	ELEVATION
7-1	70,693.34	70,536.42	4966.013
NM 45-2A	72,629.34	71,839.25	5003.016

1- ALL CONTROL POINTS SHALL BE STAMPED AEC CP 1 OR 2.
2- COORDINATES ARE IN FEET, DECIMALS 1/100 AND 1/1000.
ELEVATIONS ARE IN FEET, DECIMALS 1/100 AND 1/1000.


BERNALILLO COUNTY PUBLIC WORKS DIVISION TECHNICAL SERVICES			
TITLE: FOOTHILL BRIDGE INFRASTRUCTURE AND WATER IMPROVEMENTS AREA 422 - PRIVATE ROAD			
Design Review Committee	City Engineer Approval	Mo./Day/Yr.	Mo./Day/Yr.
Last Design			
City Project No. 747881	Zone Map No. L-11	Sheet 17	
County Project No. TS01-20			

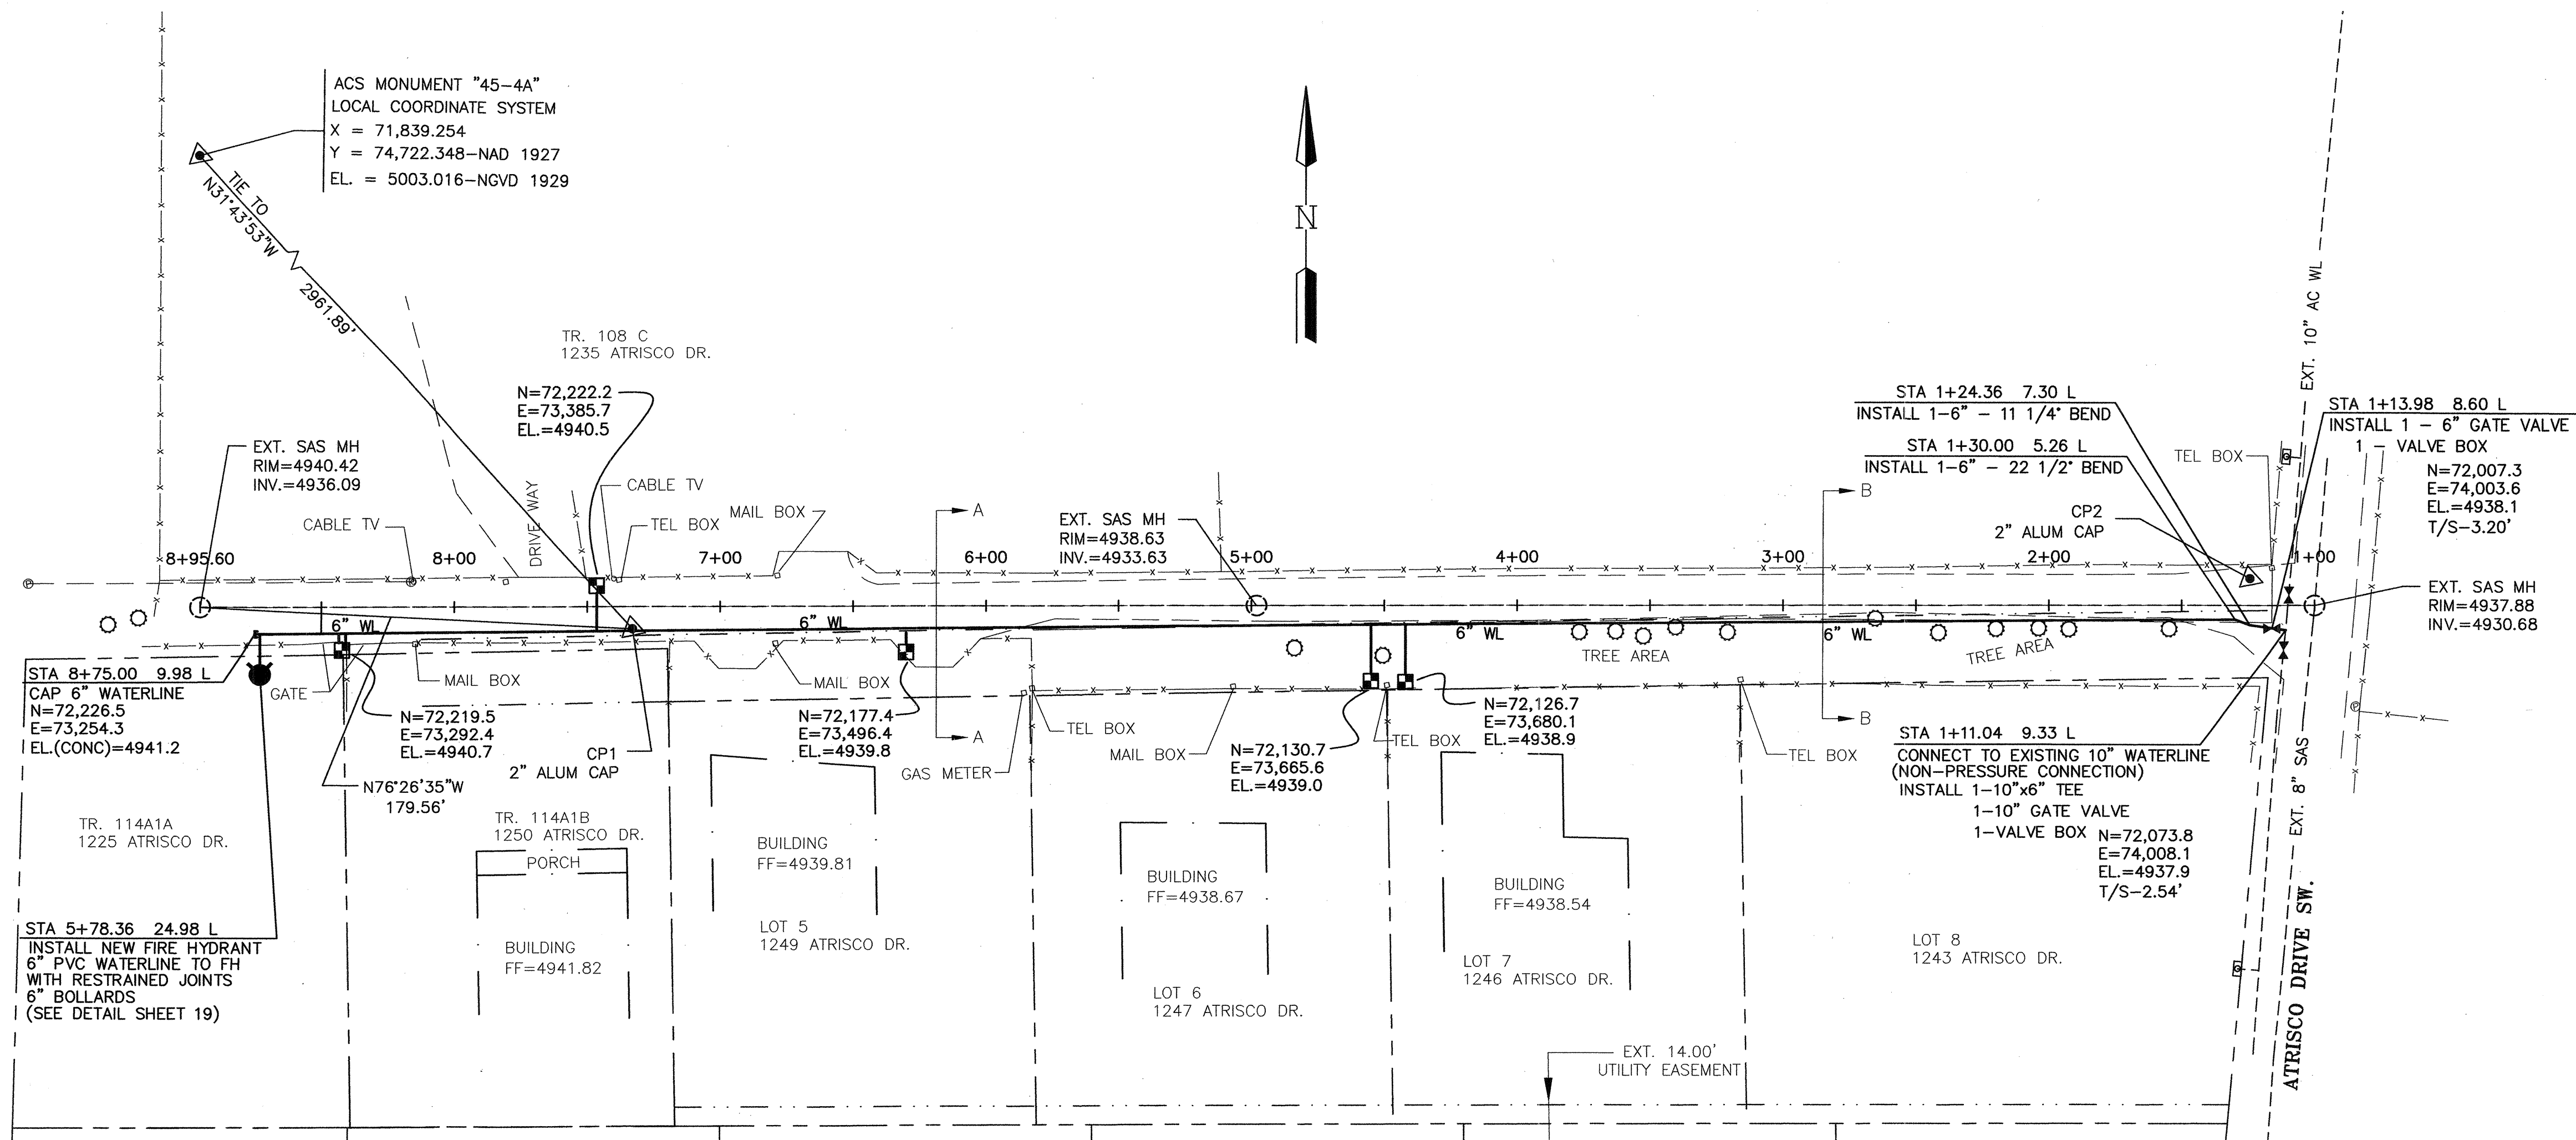

AREA 426 - PRIVATE ROAD PLAN

SCALE:
HORIZ: 1"=40'

WATER SERVICES					
ADDRESS	LEGAL DISCRIPTION	ELEV. @ PIPE (FT)	ELEV. @ PROP. LINE (FT)	SAS LENGTH	WATER STATION
1225 ATRISCO DR SW	TR. 114A1A MRCD MAP 42	N/A	N/A	N/A	8+37.38 9.98 L
1250 ATRISCO DR SW	TR. 114A1B MRCD MAP 42	N/A	N/A	N/A	8+37.87 9.98 L
1249 ATRISCO DR SW	LOT 5 PATRICIO ADDITION	N/A	N/A	N/A	7+47.72 9.50 L
1247 ATRISCO DR SW	LOT 6 PATRICIO ADDITION	N/A	N/A	N/A	4+55.01 9.55 L
1246 ATRISCO DR SW	LOT 7 PATRICIO ADDITION	N/A	N/A	N/A	4+42.01 9.86 L
1235 ATRISCO DR SW	TR. 108 C MRCD MAP 42	N/A	N/A	N/A	7+46.38 9.94 R

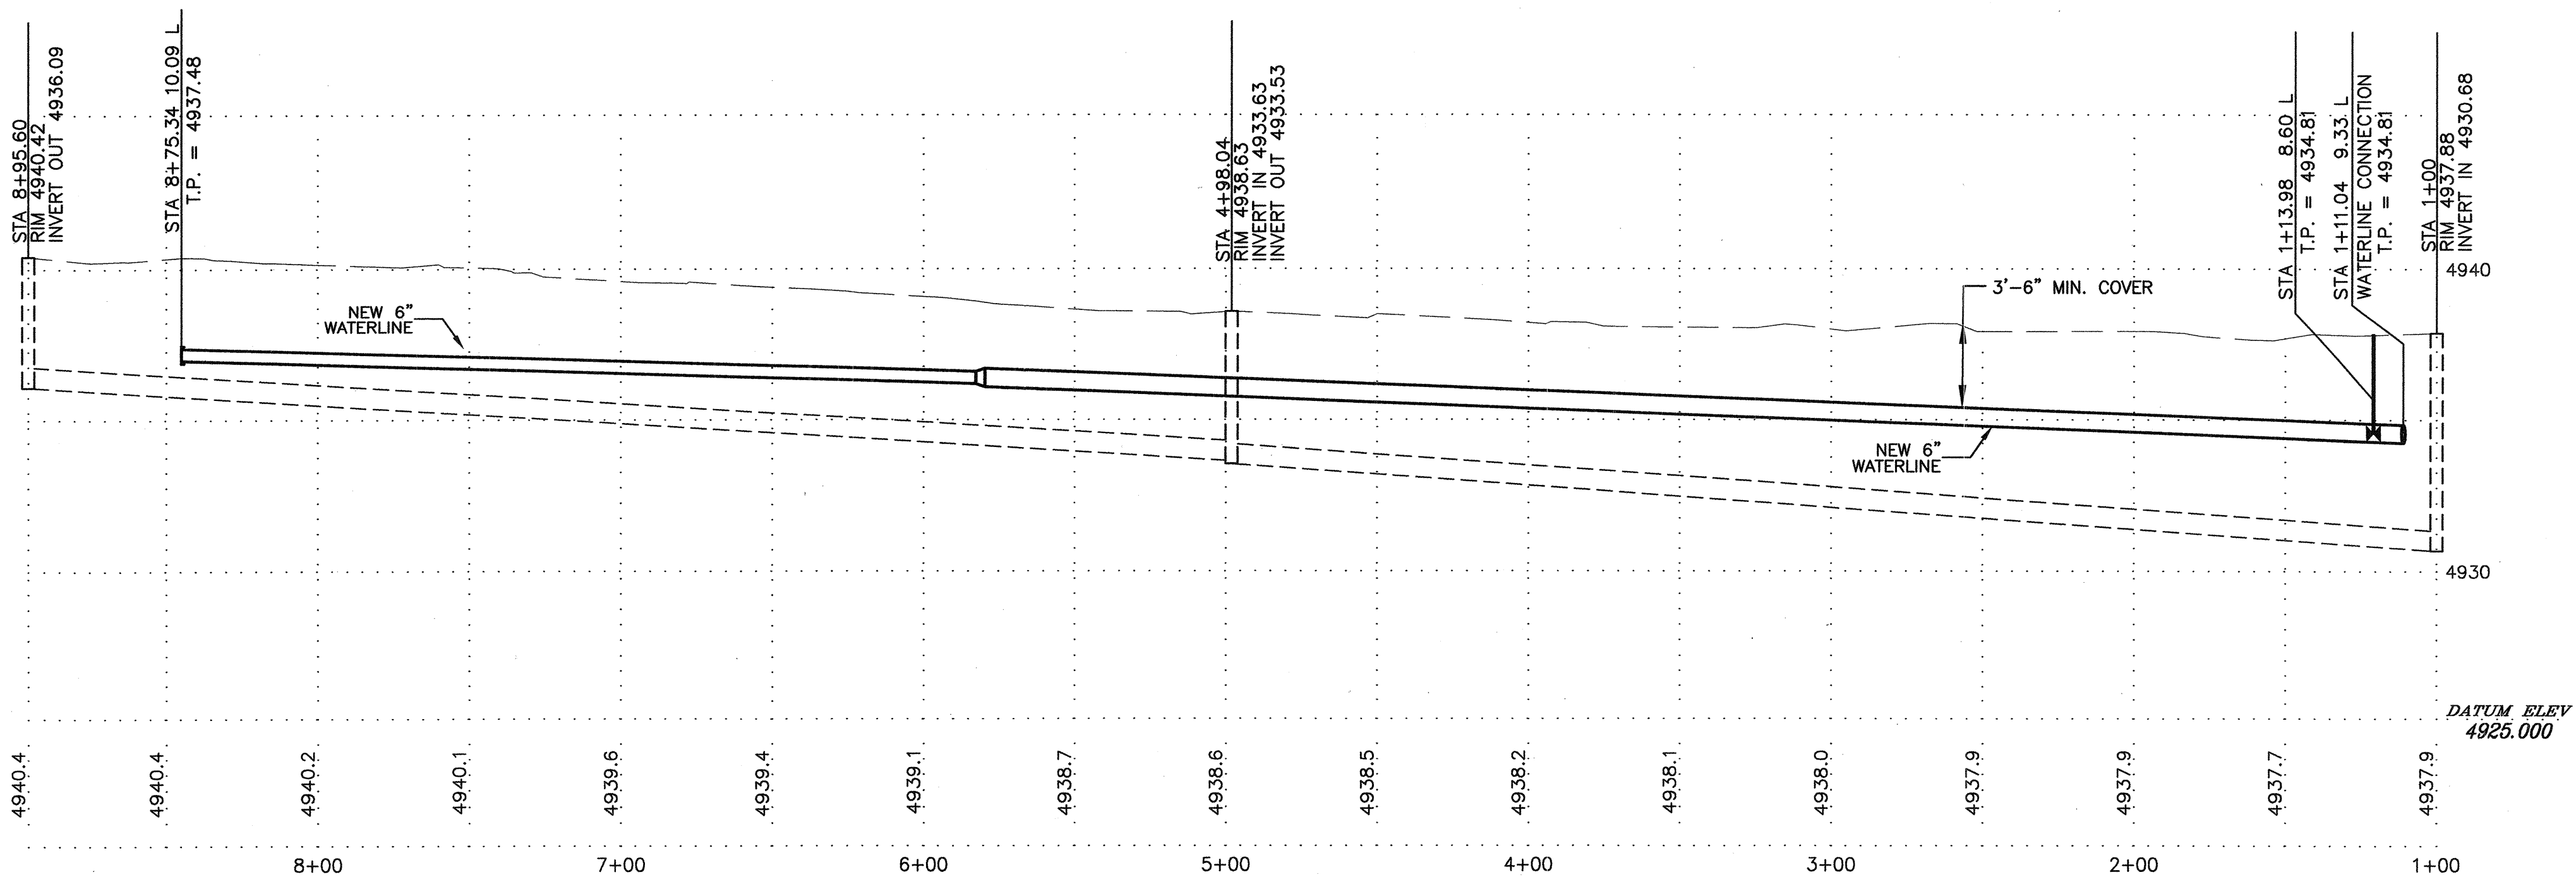


AREA 426 - PRIVATE ROAD PROFILE

SCALE:
HORIZ: 1"=40'
VERT: 1"=4'

WATER SHUT-OFF PLAN

1. THE WATER SYSTEMS DIVISION (857-8200) WILL BE NOTIFIED BY THE CONTRACTOR SEVEN (7) WORKING DAYS IN ADVANCE OF ANY WORK WHICH MAY AFFECT THE EXISTING PUBLIC WATER FACILITIES. REFER TO SECTION 18 OF STANDARD SPECIFICATIONS.
2. ONLY CITY WATER SYSTEMS DIVISION EMPLOYEES MAY OPERATE VALVES.
3. BUILD WATERLINE AS SHOWN, PRESSURE TEST AND DISINFECT WATERLINE PER SPECIFICATIONS.
4. CLOSE VALVES 1043 AND 1131 IN ATRISCO, AND CONNECT TO EXISTING WATER FACILITIES.
5. OPEN ALL VALVES.

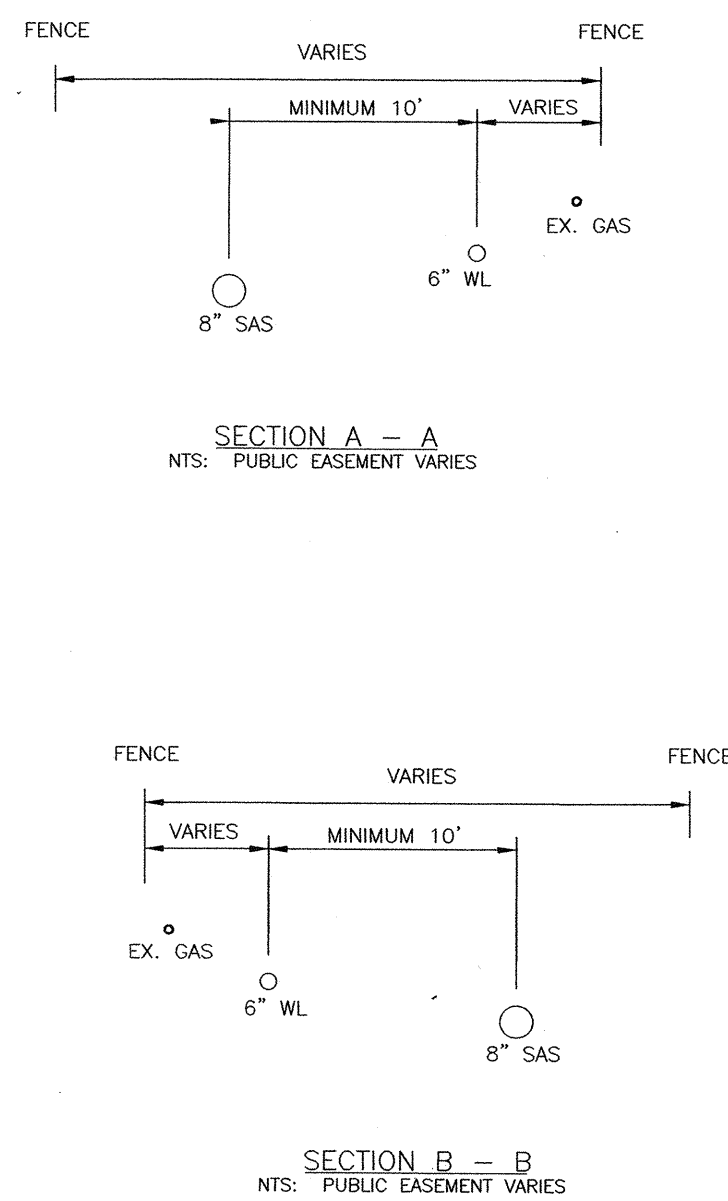


CONTROL POINT DATA TABLE (GROUND COORDINATES)				
POINT NAME	COUNTY PROJ. #	NORTHING	EASTING	ELEVATION
AEC CP1	426	72,203.193	73,397.026	4940.023
AEC CP2	426	72,106.351	73,998.258	4937.781

MONUMENT DATA TABLE			
CITY MONUMENT	NORTHING	EASTING	ELEVATION
7-MT	70,469.374	70,536.426	4966.013
NM 45-4A	74,722.348	71,839.254	5003.016

- 1- ALL CONTROL POINTS ARE 2" ALUM CAP STAMPED AEC CP 1 OR 2.
2- COORDINATES ARE IN THE WCS 1984/NAD27 DATUM AND ELEVATIONS ARE IN THE NGVD29 DATUM.

			
BERNALILLO COUNTY PUBLIC WORKS DIVISION TECHNICAL SERVICES			
TITLE: FOOTHILL/BRIDGE INFILL AREA SEWER AND WATER IMPROVEMENTS AREA 426 - PRIVATE ROAD			
Design Review Committee	City Engineer Approval	Mo./Day/Yr.	Mo./Day/Yr.
City Project No. 747881	Zone Map No. L12	Sheet 18	Of 25
County Project No. TS01-20			

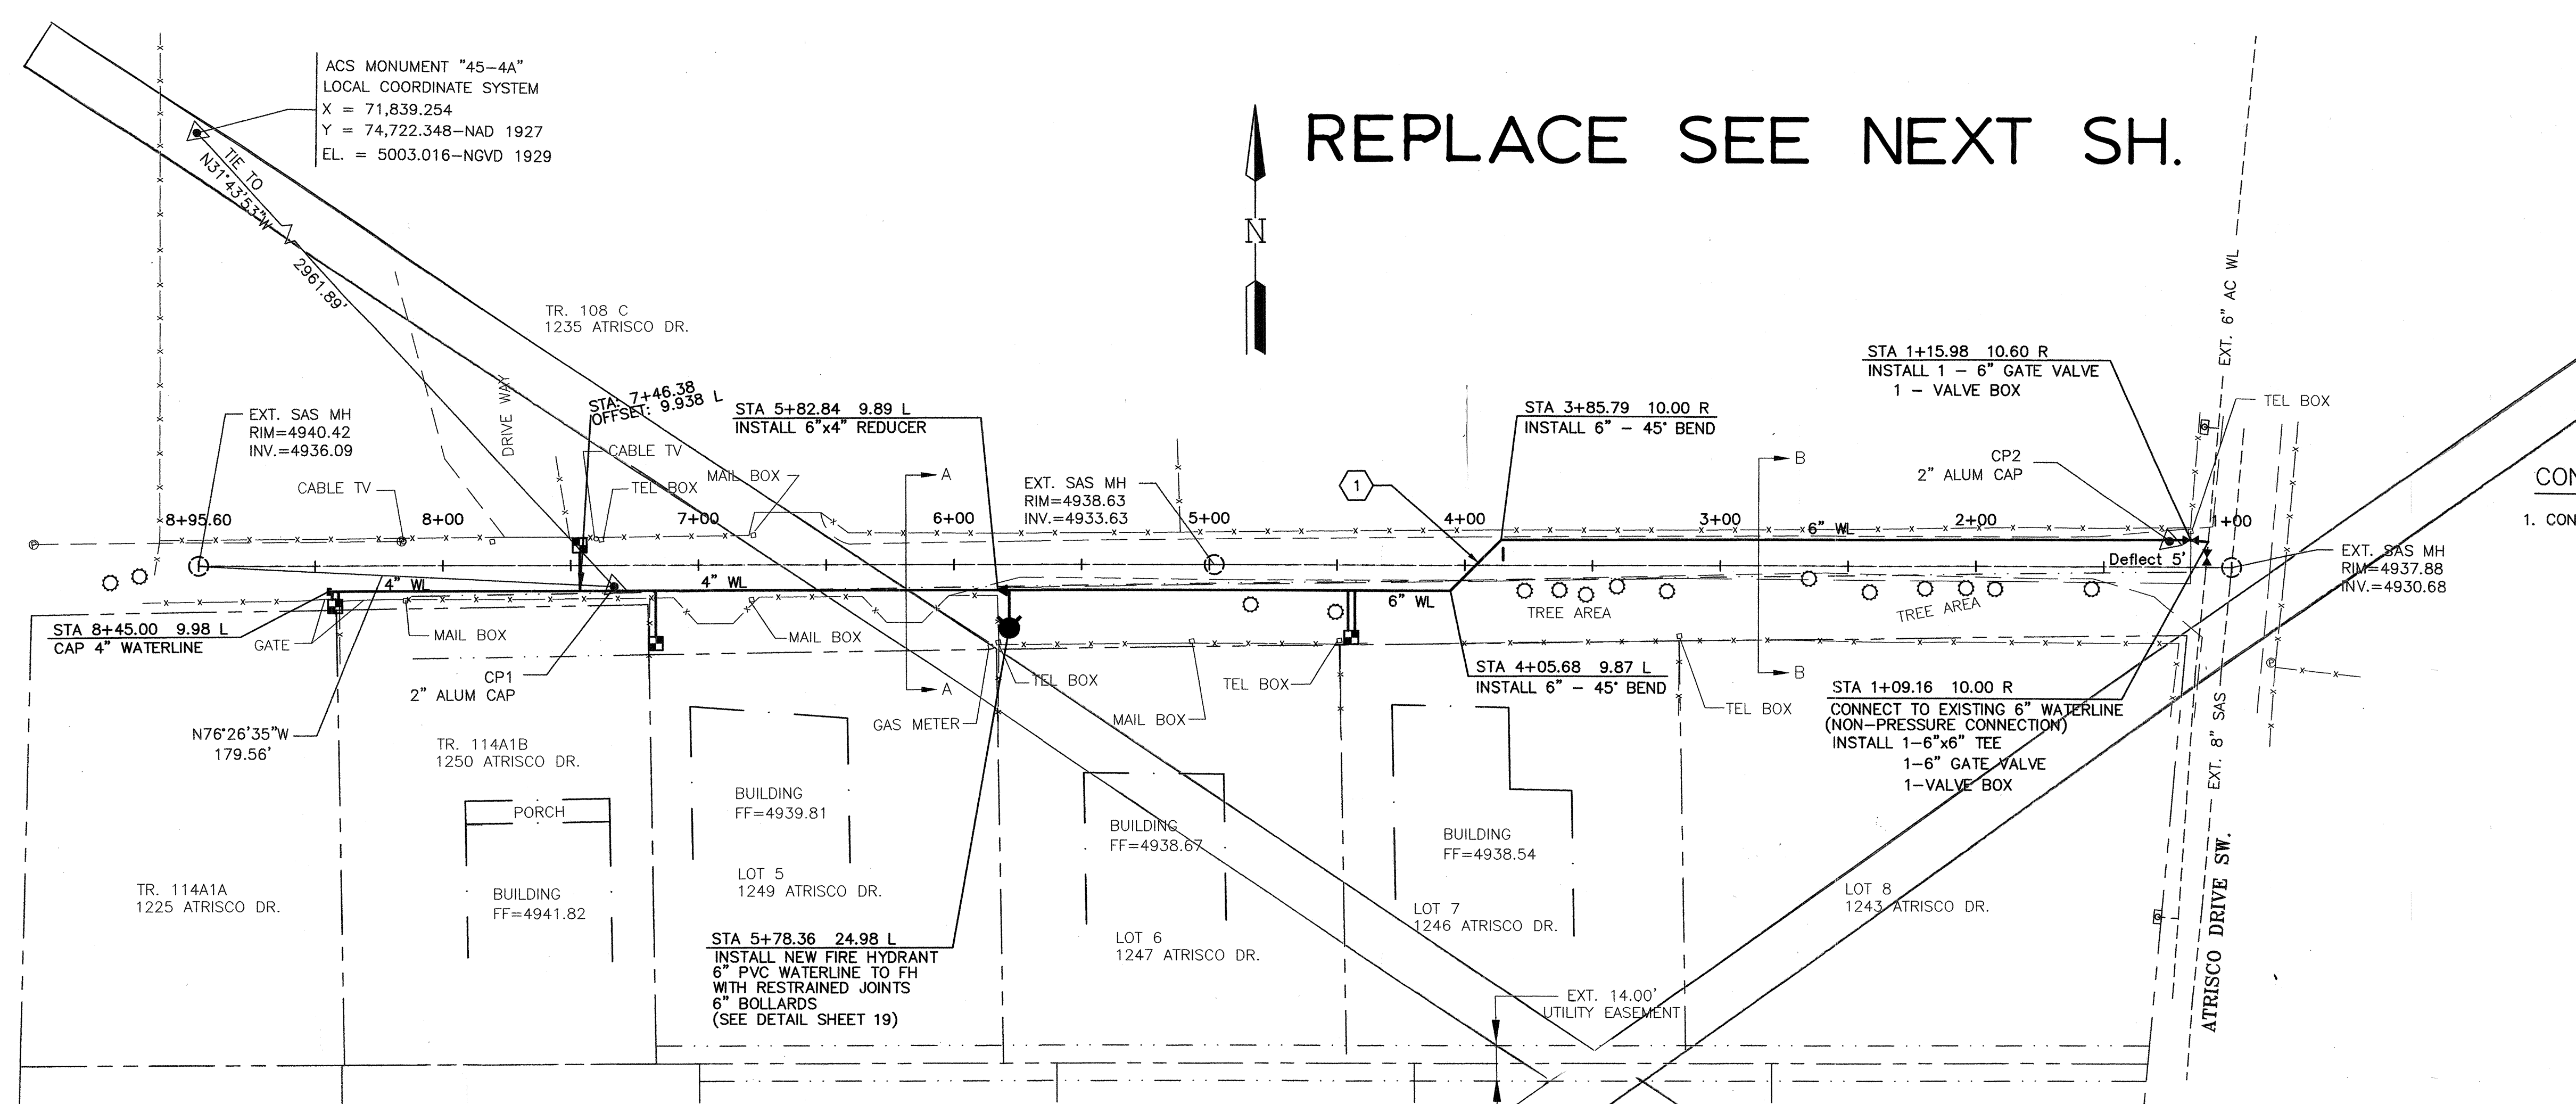



REPLACE SEE NEXT SH.

WATER SHUT-OFF PLAN

1. THE WATER SYSTEMS DIVISION (857-8200) WILL BE NOTIFIED BY THE CONTRACTOR SEVEN (7) WORKING DAYS IN ADVANCE OF ANY WORK WHICH MAY AFFECT THE EXISTING PUBLIC WATER FACILITIES. REFER TO SECTION 18 OF STANDARD SPECIFICATIONS.
2. ONLY CITY WATER SYSTEMS DIVISION EMPLOYEES MAY OPERATE VALVES.
3. BUILD WATERLINE AS SHOWN, PRESSURE TEST AND DISINFECT WATERLINE PER SPECIFICATIONS.
4. CLOSE VALVES 1043 AND 1131 IN ATRISCO, AND CONNECT TO EXISTING WATER FACILITIES.
5. OPEN ALL VALVES.

CONSTRUCTION NOTES


1. CONCRETE INCASING FROM STA. 3+85.79 10.00R TO 4+05.68 9.87L

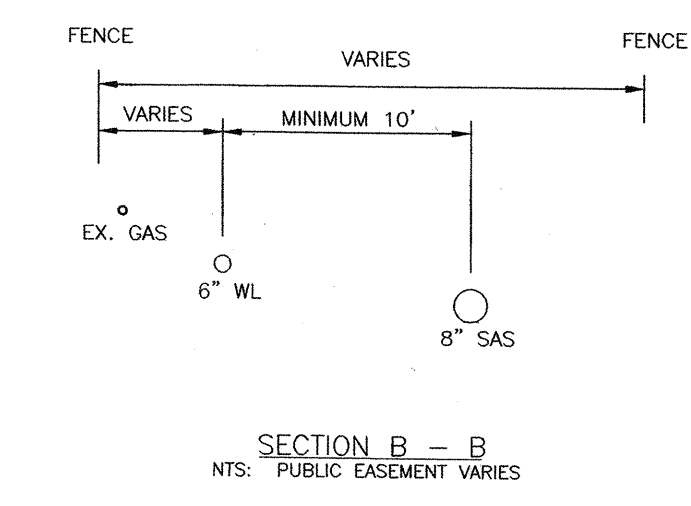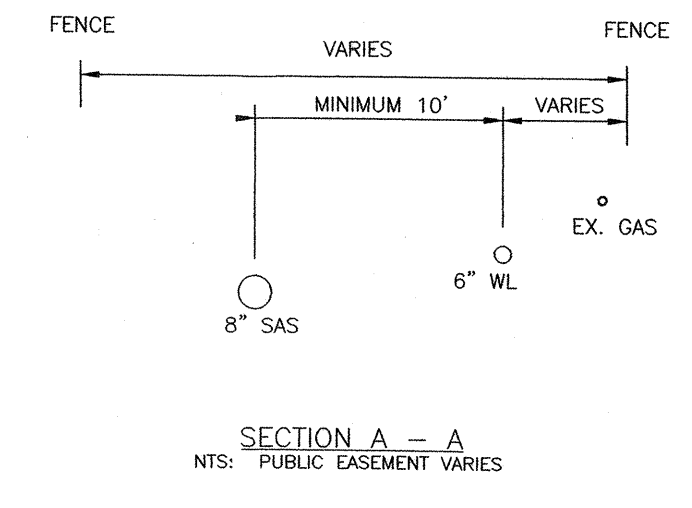

WATER SERVICES						
ADDRESS	LEGAL DISCRIPTION	ELEV. @ PIPE (FT)	ELEV. @ PROP. LINE (FT)	SAS LENGTH	WATER STATION	
1225 ATRISCO DR SW	TR. 114A1A MRGCD MAP 42	N/A	N/A	N/A	8+43.38 9.98 L	
1250 ATRISCO DR SW	TR. 114A1B MRGCD MAP 42	N/A	N/A	N/A	8+40.87 9.98 L	
1249 ATRISCO DR SW	LOT 5 PATRICIO ADDITION	N/A	N/A	N/A	7+16.72 12.50 L	
1247 ATRISCO DR SW	LOT 6 PATRICIO ADDITION	N/A	N/A	N/A	4+45.64 9.86 L	
1246 ATRISCO DR SW	LOT 7 PATRICIO ADDITION	N/A	N/A	N/A	4+42.96 9.86 L	
1235 ATRISCO DR SW	TR. 108 C MRGCD MAP 42	N/A	N/A	N/A	7+46.38 9.94 L	

AREA 426 - PRIVATE ROAD PLAN

SCALE:
HORIZ: 1"=40'

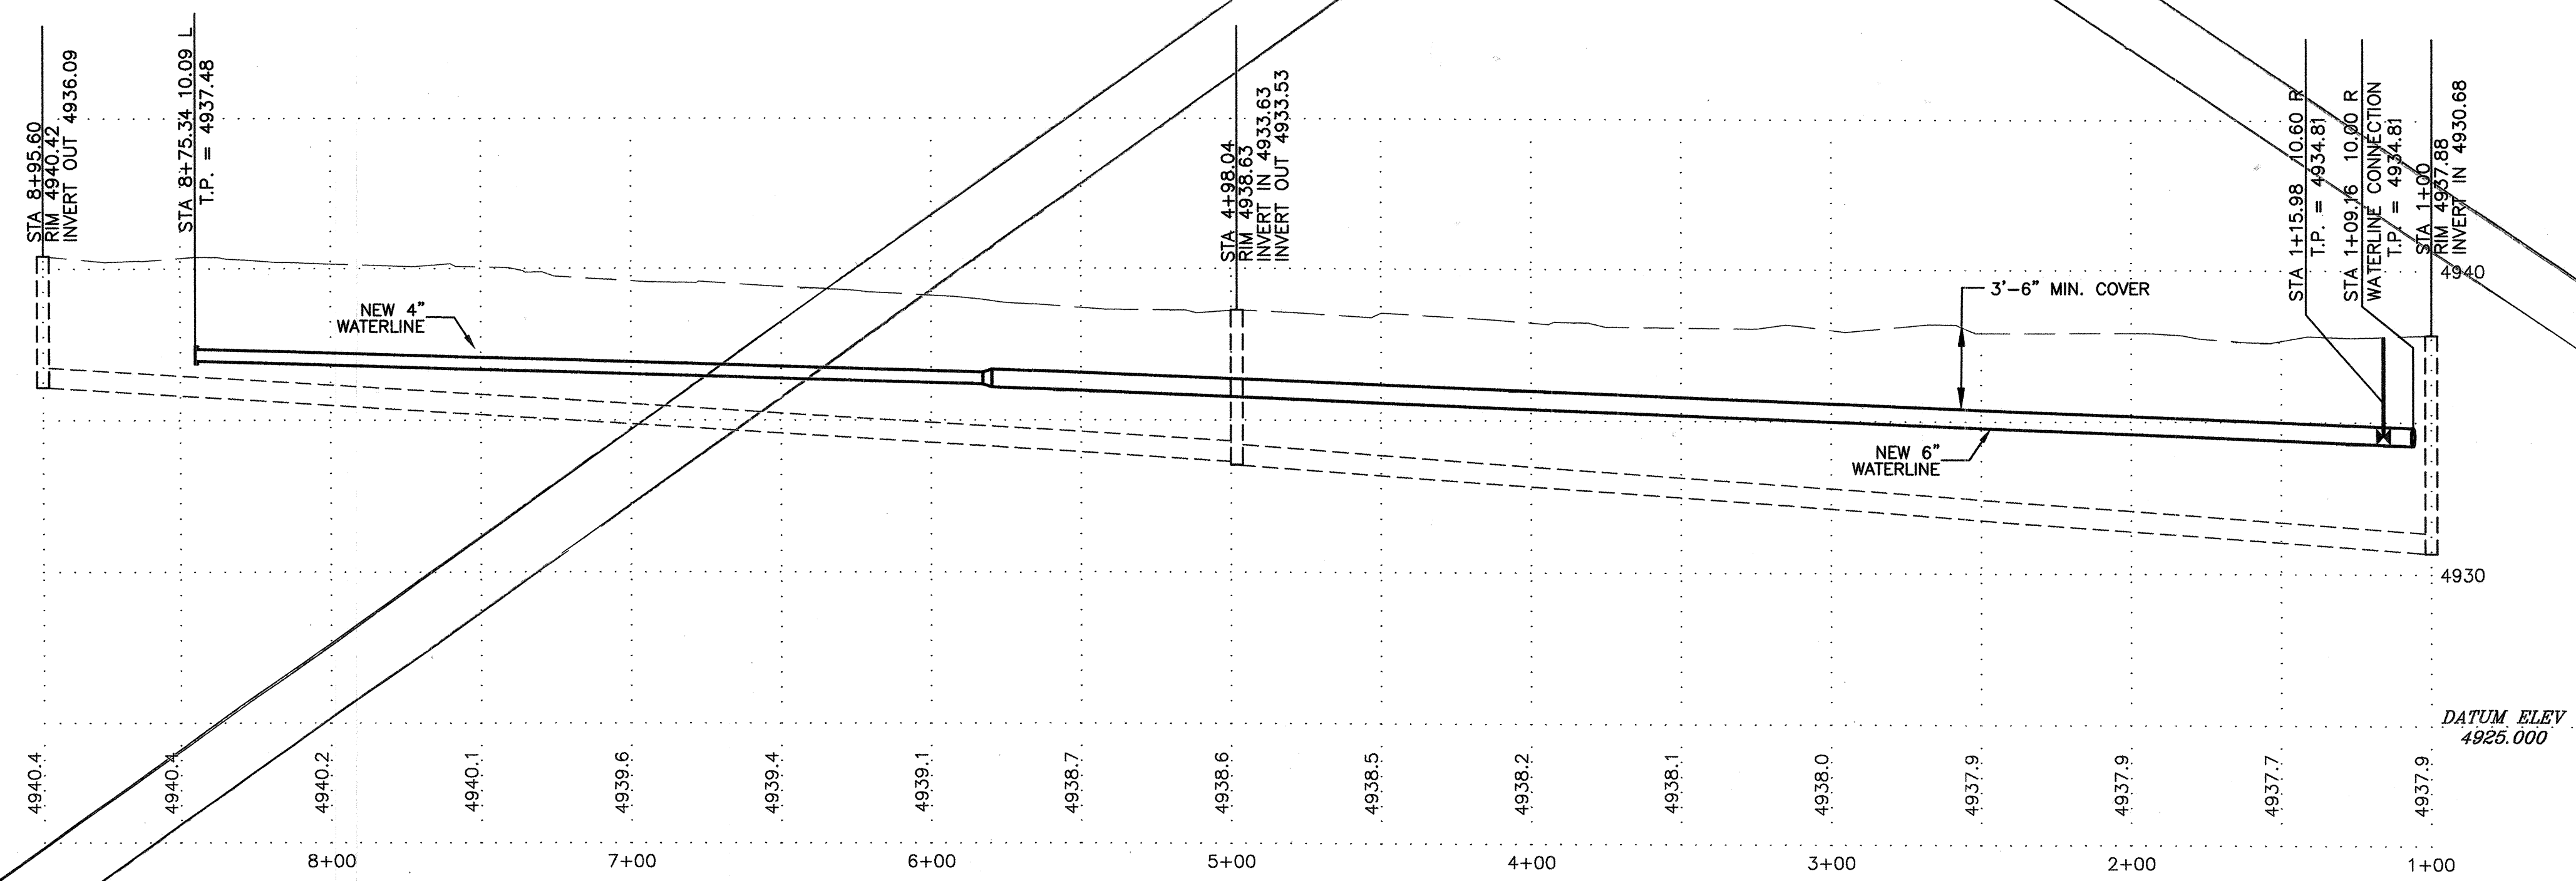

AREA 426 - PRIVATE ROAD PROFILE


SCALE:
HORIZ: 1"=40'
VERT: 1"=4'

CONTROL POINT DATA TABLE (GROUND COORDINATES)				
POINT NAME	COUNTY PROJ #	NORTHING	EASTING	ELEVATION
AEC CP1	426	72,203.193	73,397.026	4940.023
AEC CP2	426	72,106.351	73,998.258	4937.781

MONUMENT DATA TABLE			
MONUMENT	NORTHING	EASTING	ELEVATION
NM 45-4A	70,469.374	70,536.426	4966.013
NM 45-4A	74,722.348	71,839.254	5003.016

1- ALL CONTROL POINTS ARE 2" ALUM CAP STAMPED AEC CP 1 OR 2.
2- COORDINATES ARE IN THE WGS 1984/NAD27 DATUM AND ELEVATIONS ARE IN THE NGVD29 DATUM.


		BERNALILLO COUNTY PUBLIC WORKS DIVISION TECHNICAL SERVICES	
TITLE: FOOTHILL/BRIDGE INFILL AREA SEWER AND WATER IMPROVEMENTS AREA 426 - PRIVATE ROAD			
Design Review Committee	City Engineer Approval	Mo./Day/Yr.	Mo./Day/Yr.
City Project No. 747881 County Project No. TS01-20		Zone Map No. L12	Sheet 18 Of 25

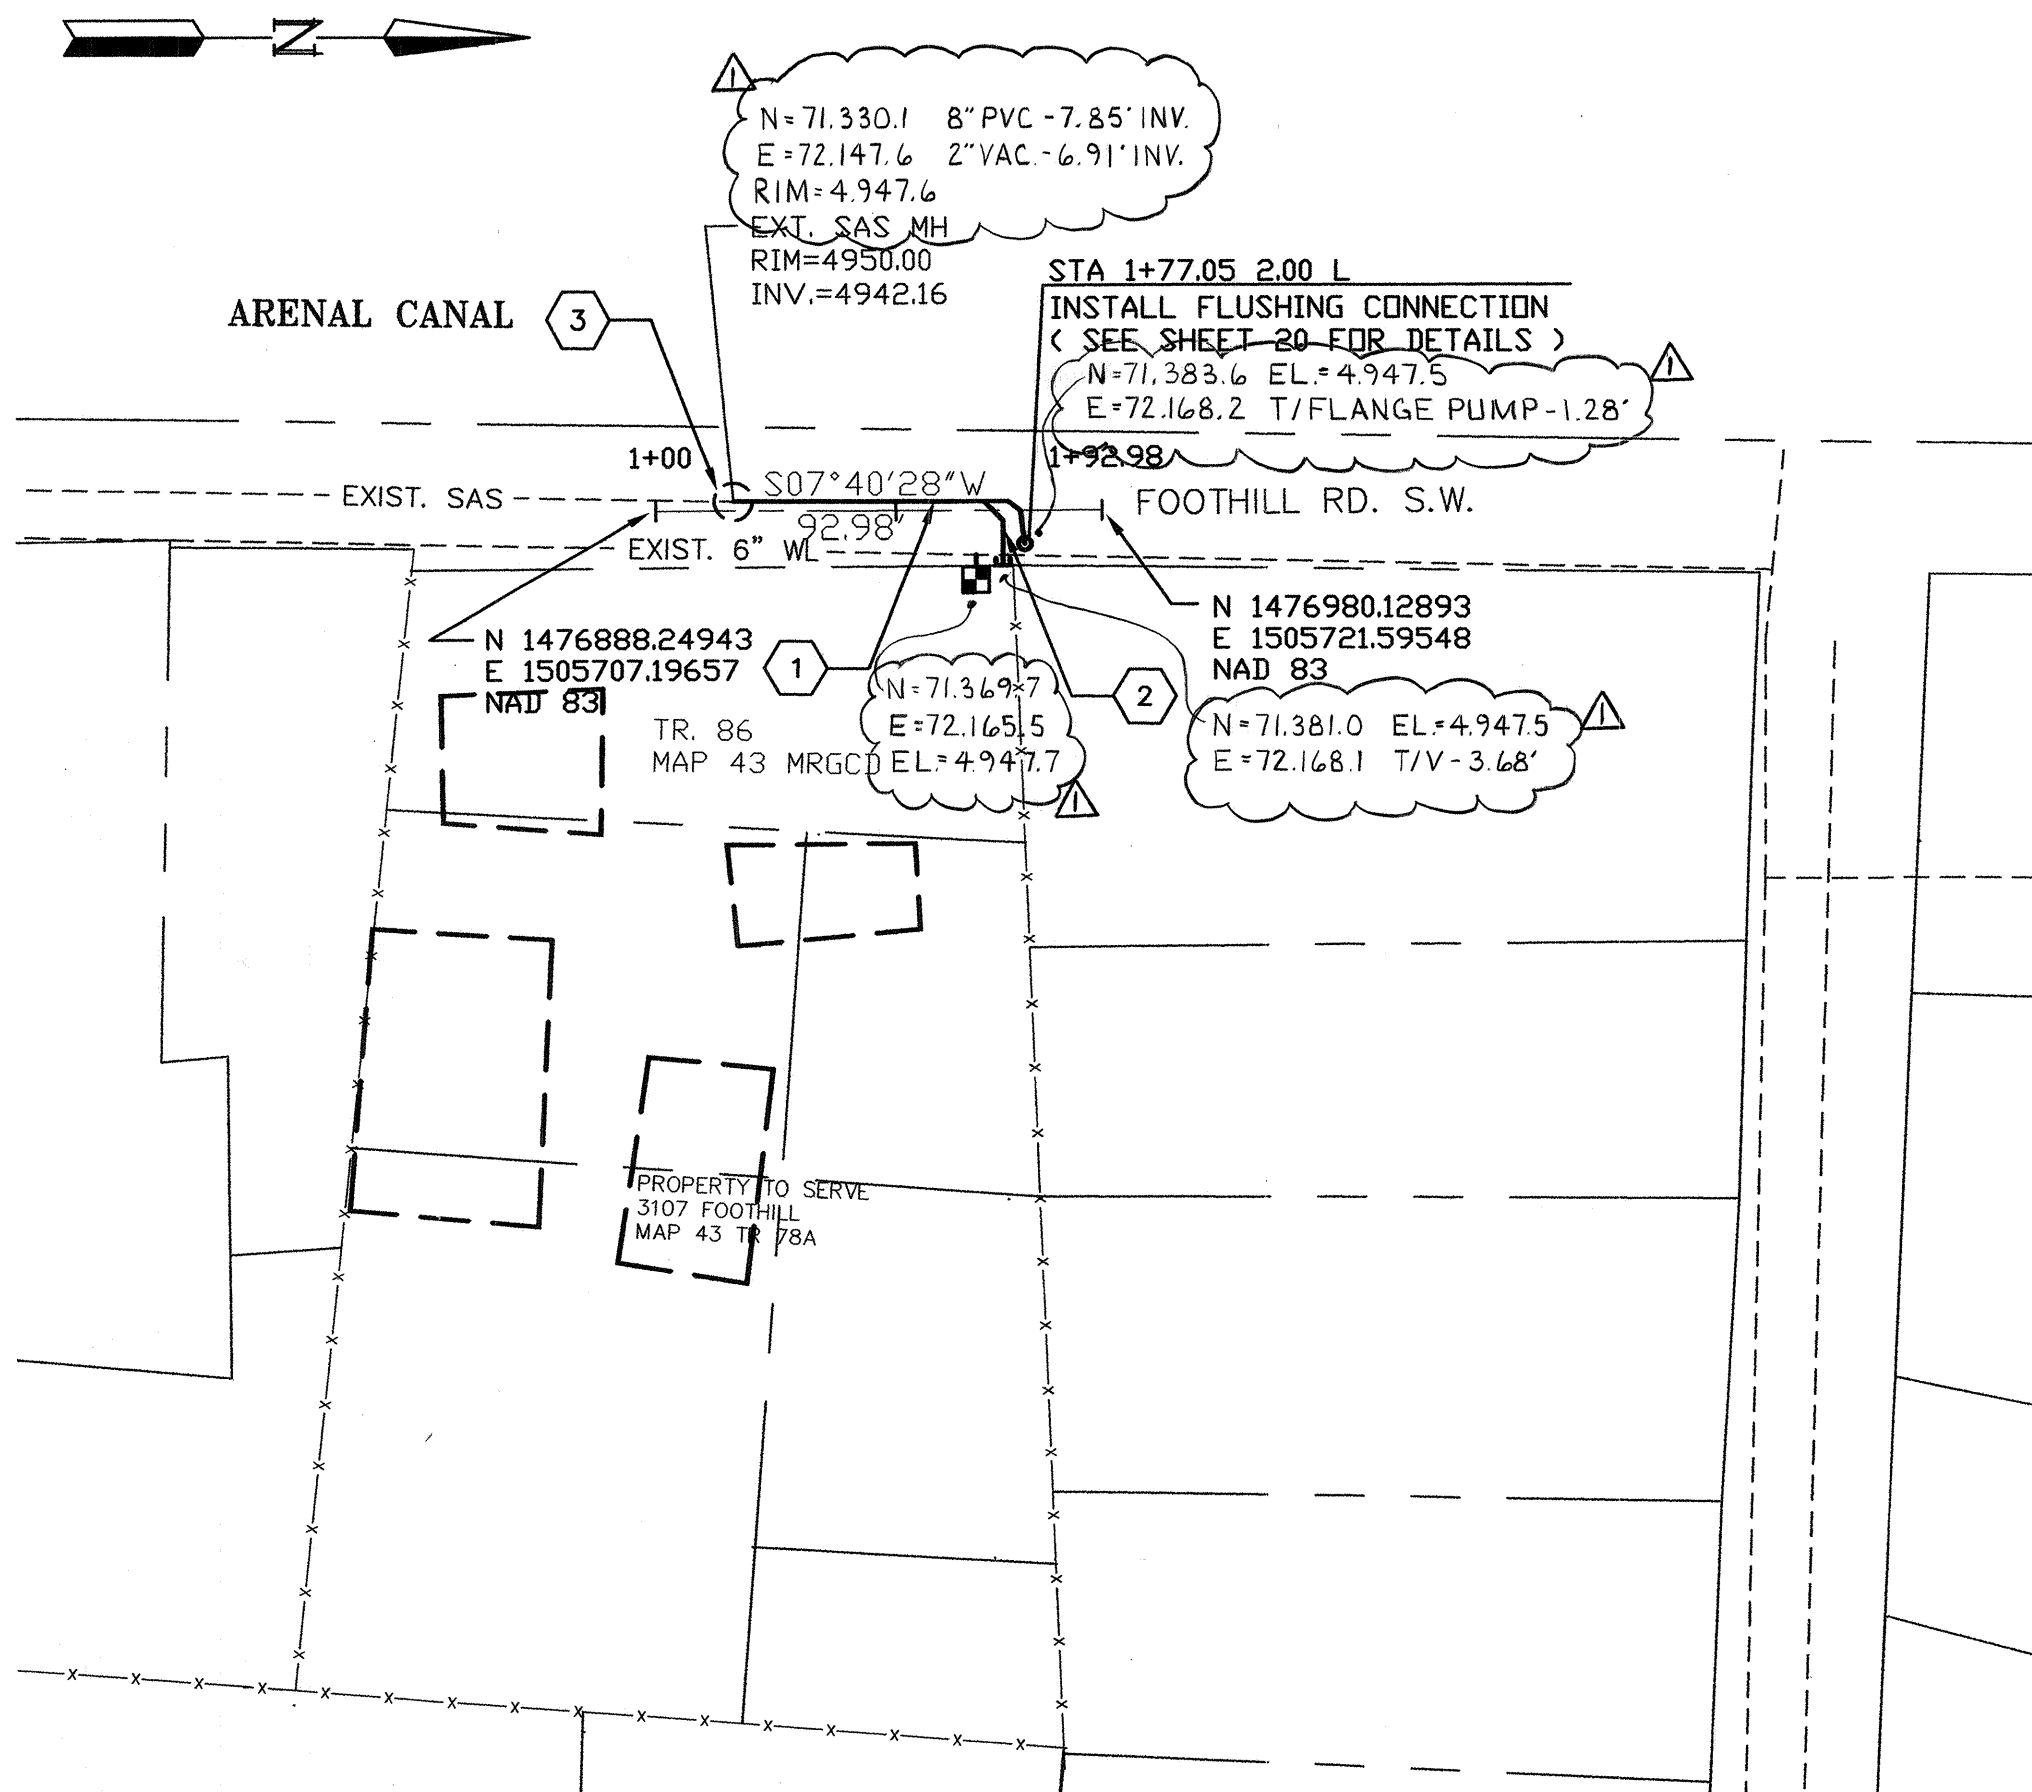

AREA 428 - FOOTHILL ROAD PLAN

SCALE: 1"=40'

4" SANITARY SEWER / WATER SERVICES						
ADDRESS	LEGAL DISCRPTION	STATION	ELEV. @ PIPE (FT)	ELEV. @ PROP. LINE (FT)	SAS LENGTH	WATER STATION
1412 FOOTHILL DR. SW	TR 86 MRGCD MAP 43	2+80.78 0.00 R	4943.43	4943.73	13.0'	2+62.26 3.11 R

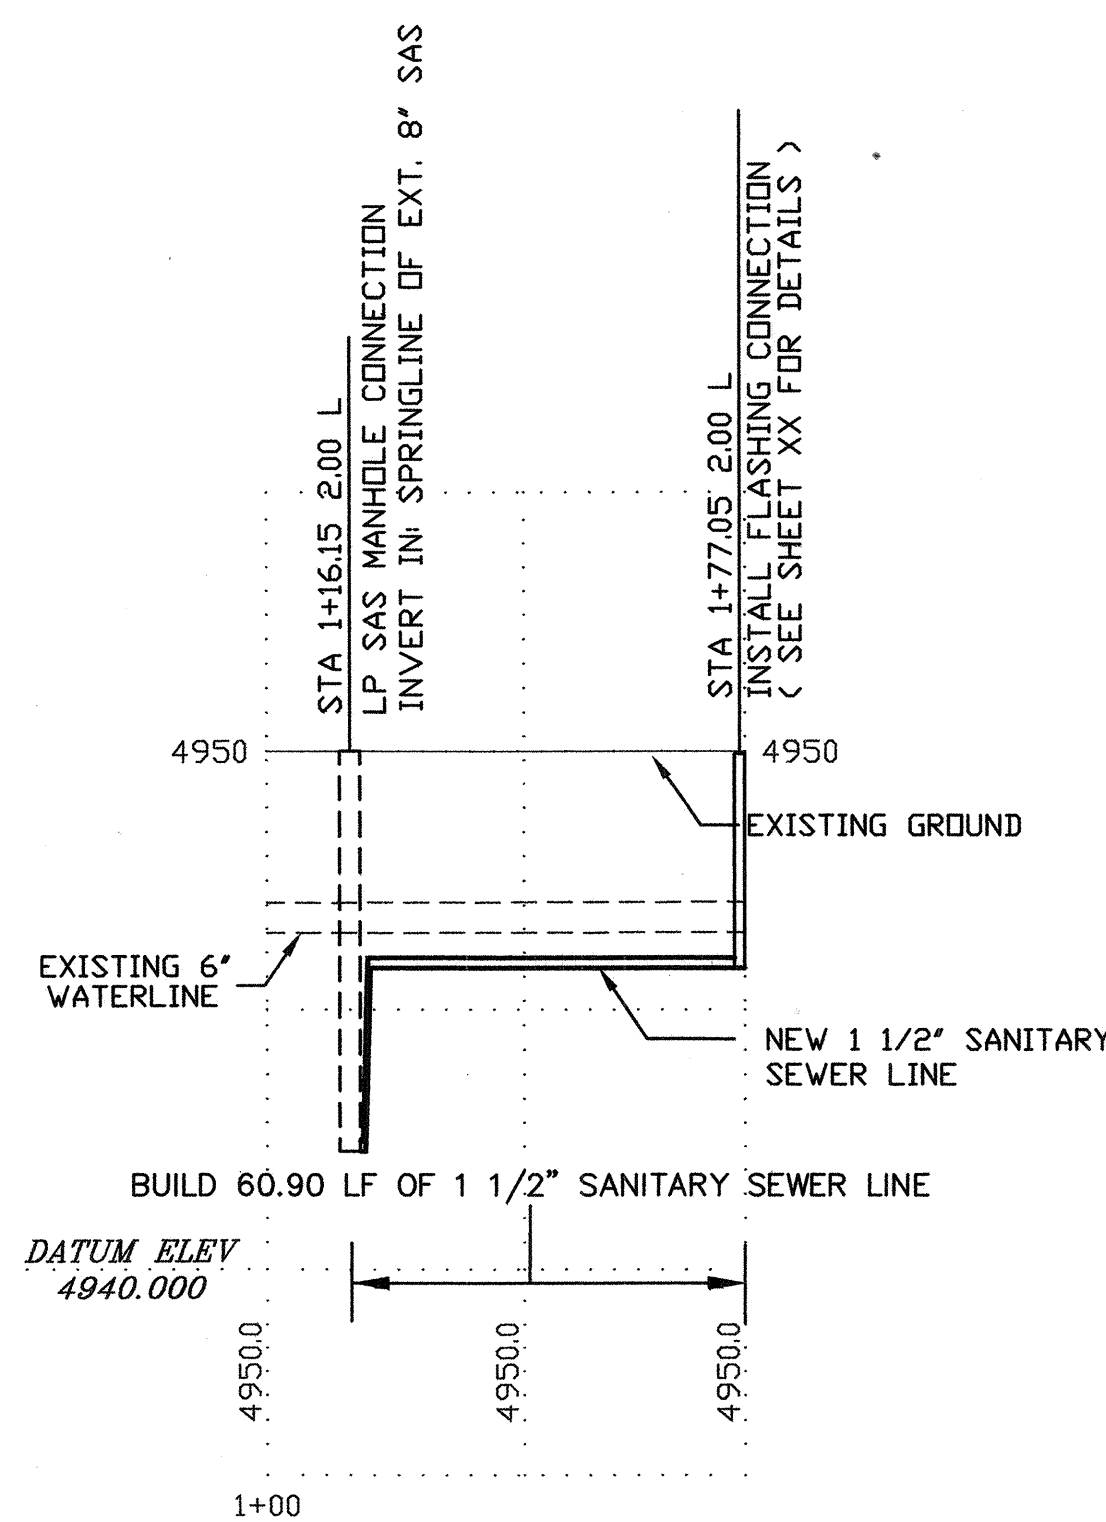


AREA 428 - FOOTHILL ROAD PROFILE


SCALE:
HORIZ: 1"=40'
VERT: 1"=4'

CONSTRUCTION NOTES


1. INSTALL 1½" LOW PRESSURE SEWER LINE. MAXIMUM TRENCH WIDTH OF 4 FEET.
2. LOW PRESSURE SEWER LATERAL (SEE SHEET 20 FOR DETAILS).
3. MANHOLE CONNECTION (SEE DETAIL BELOW).

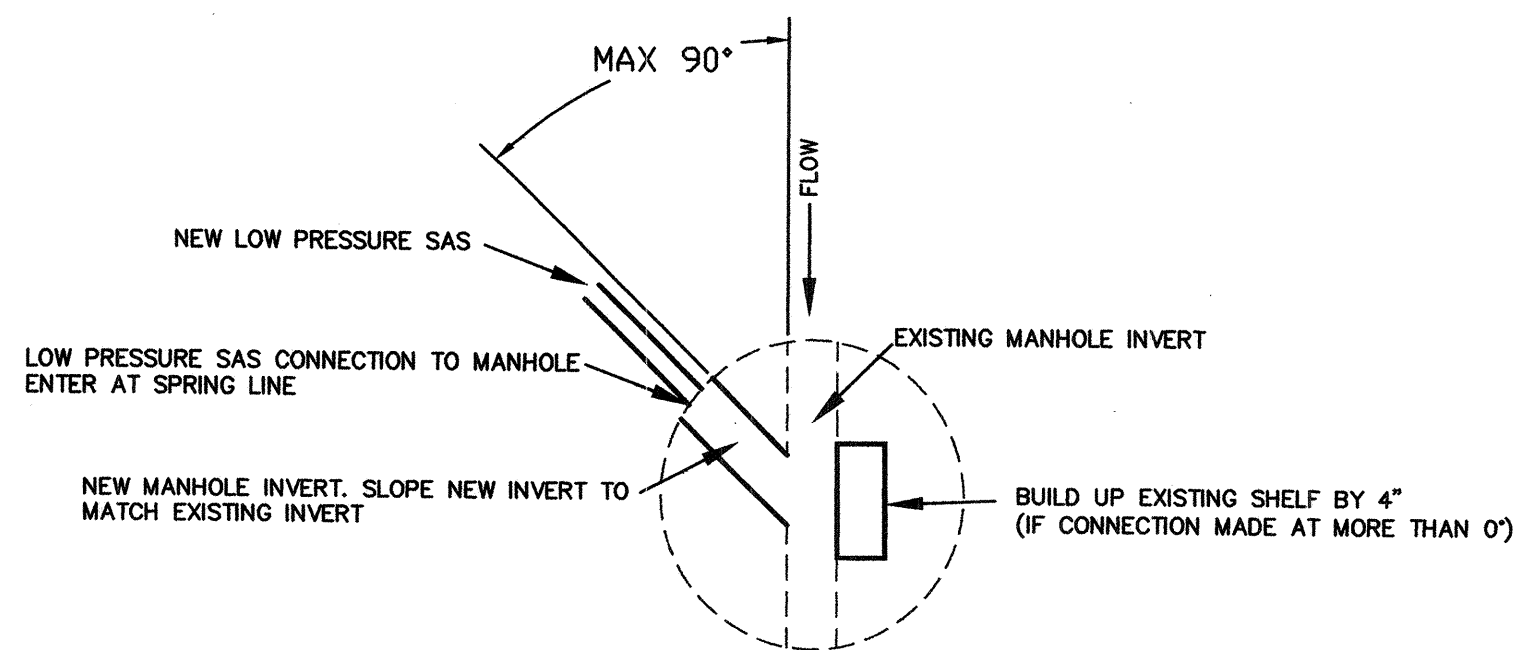


LOW PRESSURE SAS CONNECTION TO MANHOLE

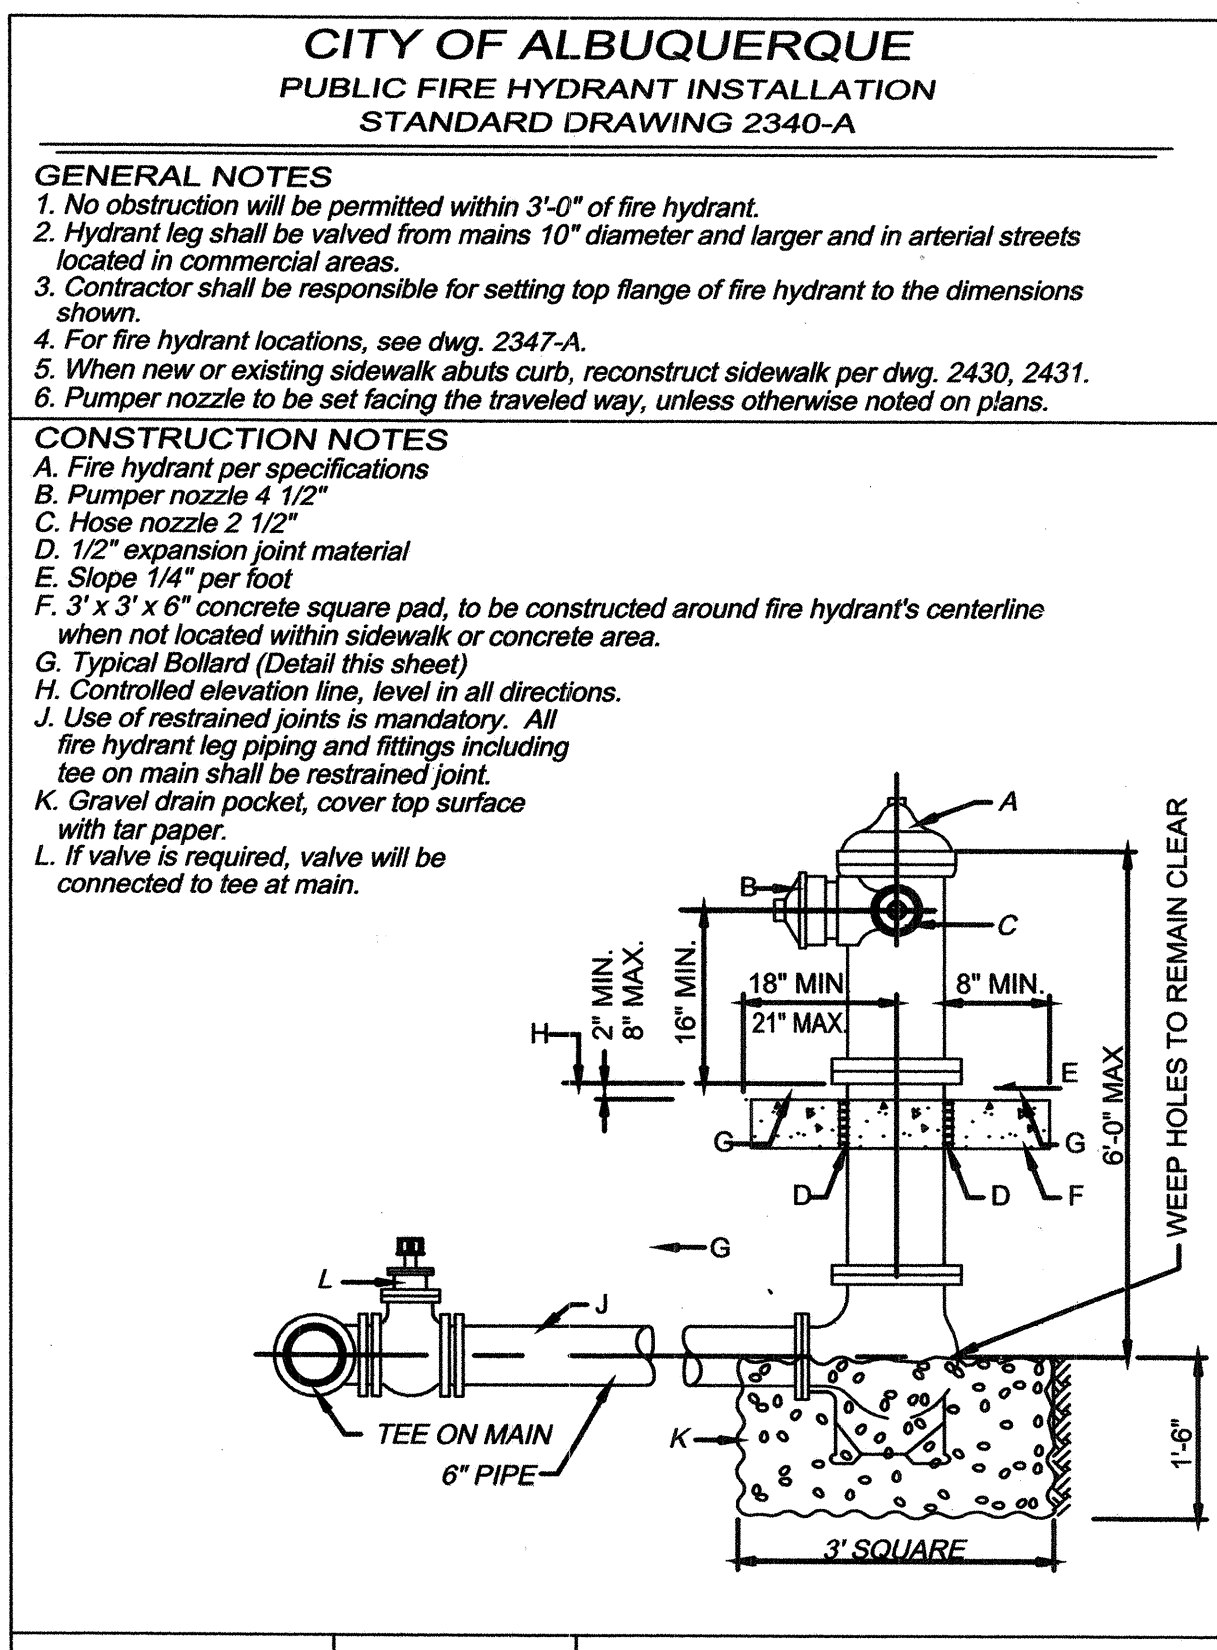

TYPICAL FIRE HYDRANT AND BOLLARD LAYOUT
SCALE: NTS

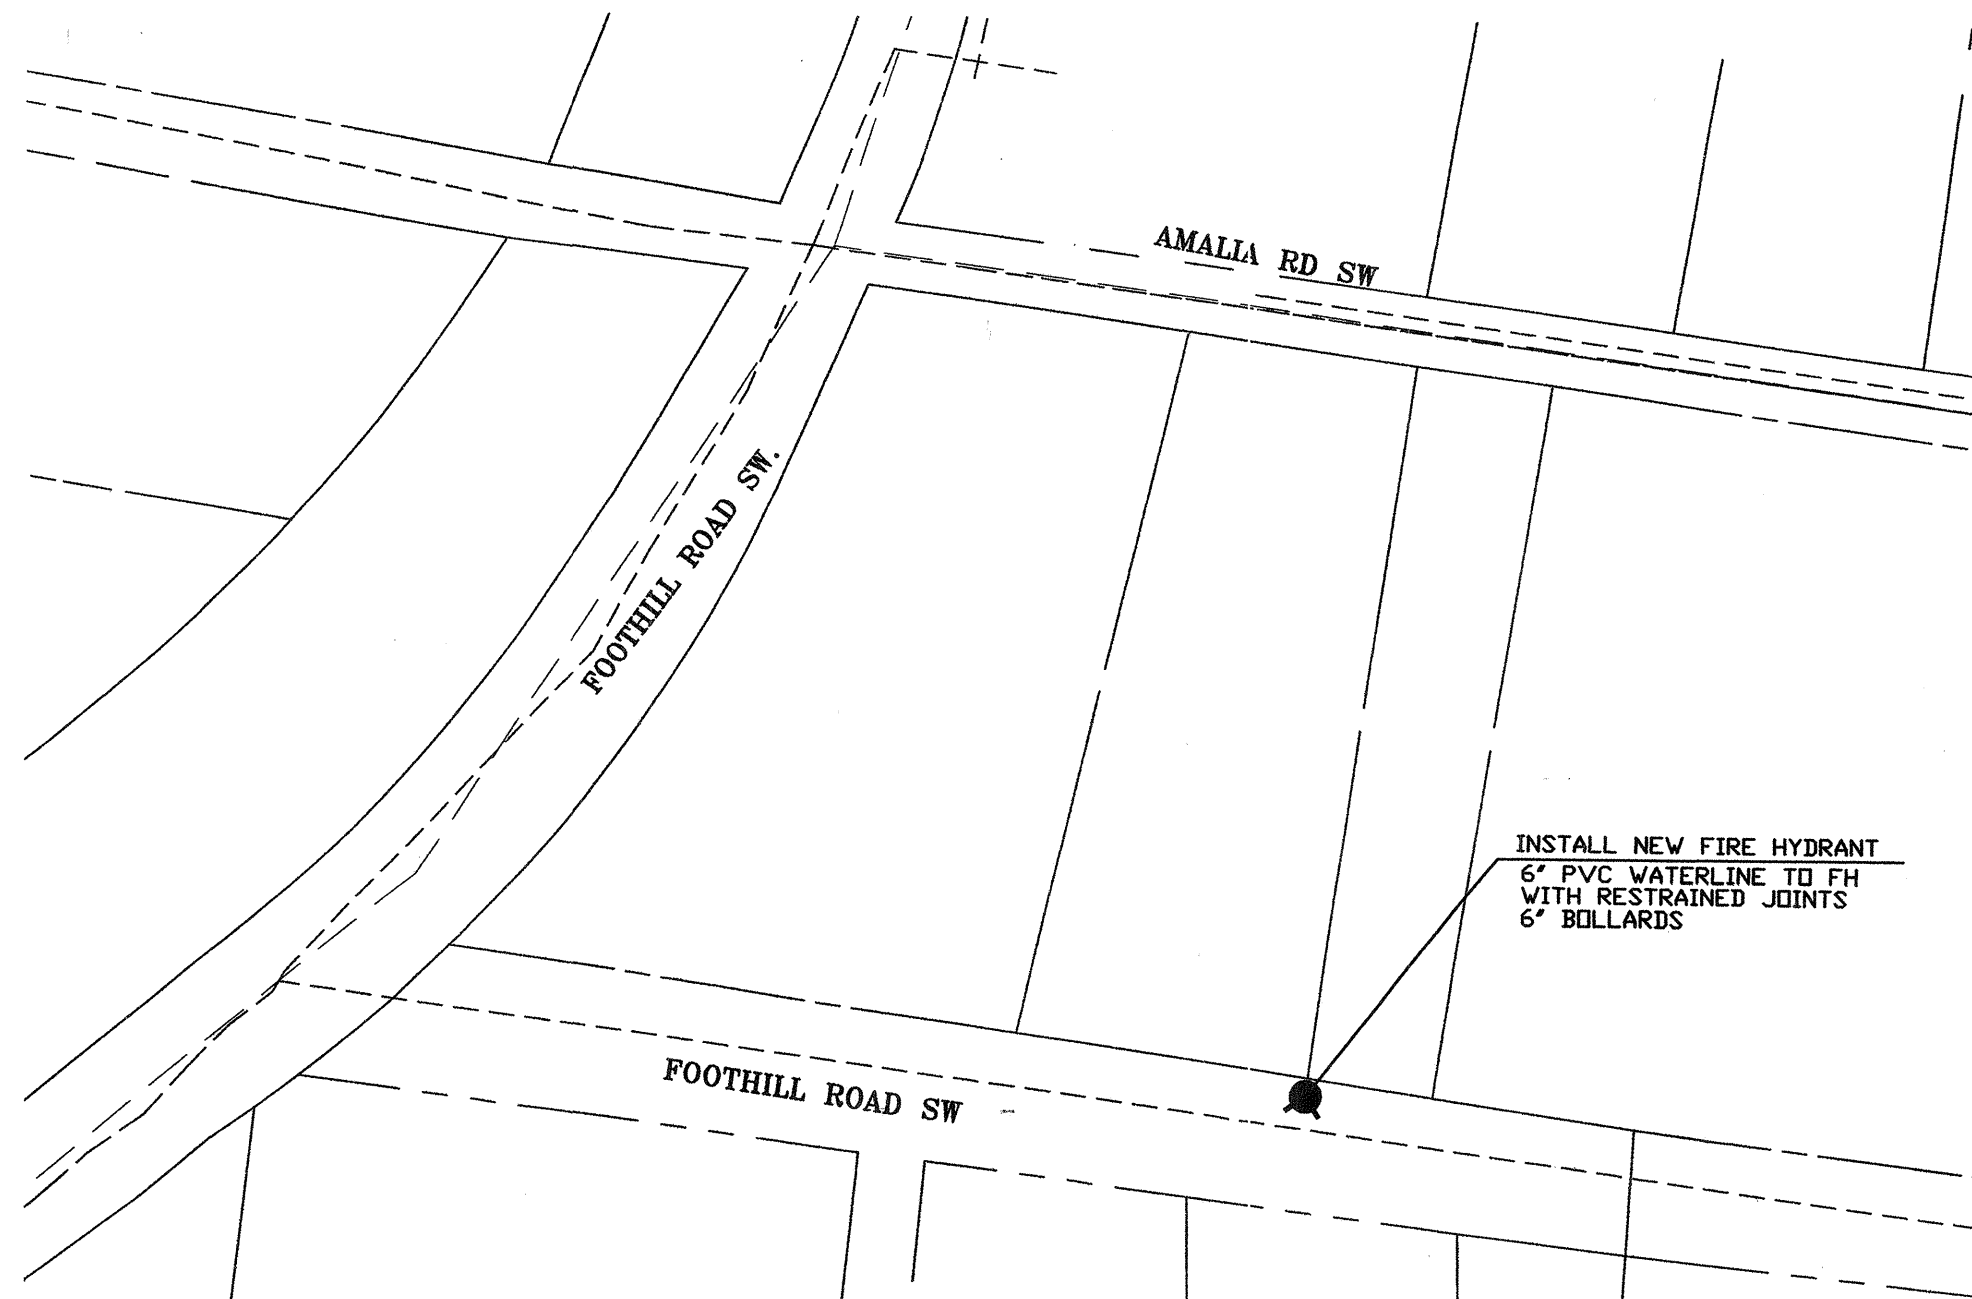


AREA 428B - FOOTHILL RD FIRE HYDRANT (AREA 499)

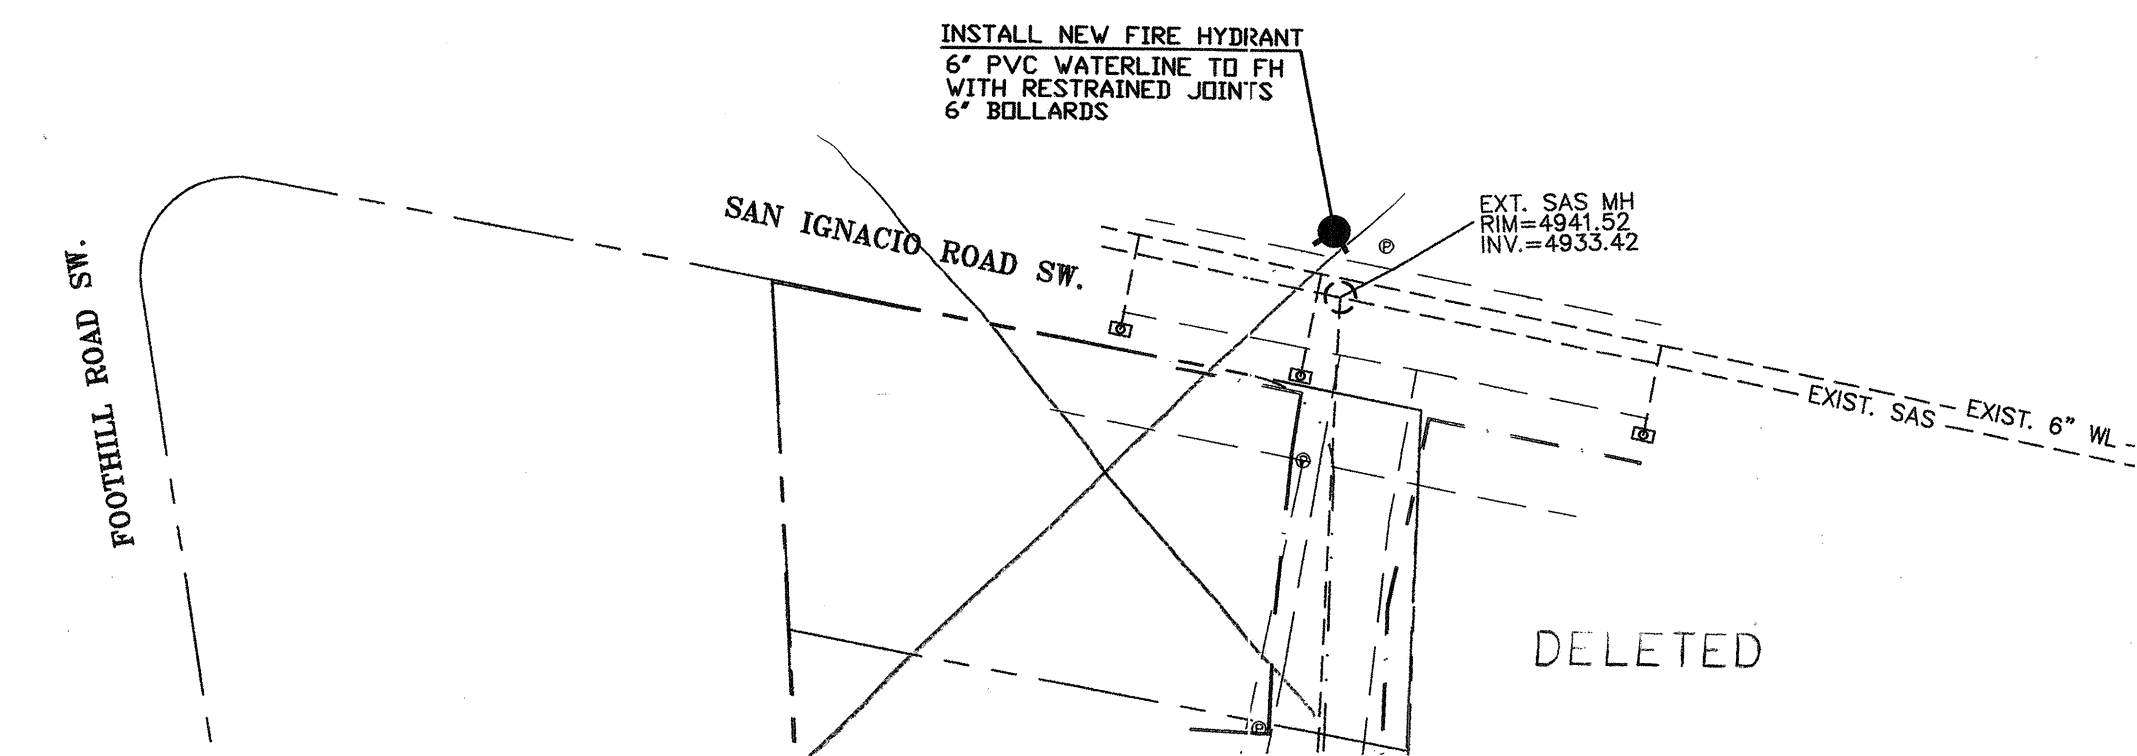

AREA 428C - SAN YGNACIO FIRE HYDRANT (AREA 422)

WATER SHUT-OFF PLAN

1. THE WATER SYSTEMS DIVISION (857-8200) WILL BE NOTIFIED BY THE CONTRACTOR SEVEN (7) WORKING DAYS IN ADVANCE OF ANY WORK WHICH MAY AFFECT THE EXISTING PUBLIC WATER FACILITIES. REFER TO SECTION 18 OF STANDARD SPECIFICATIONS.
2. ONLY CITY WATER SYSTEMS DIVISION EMPLOYEES MAY OPERATE VALVES.
3. BUILD WATERLINE AS SHOWN, PRESSURE TEST AND DISINFECT WATERLINE PER SPECIFICATIONS.
4. AREA 428: CLOSE VALVES 304 AND 1104 IN FOOTHILL, 302 AND 303 IN AMALIA, 301 IN KELLY, AND 1152 IN WILBUR. AREA 428 B (AREA 499): CLOSE VALVE 351 IN FOOTHILL AND 372 IN ARMIN. AREA 428C (AREA 422): CLOSE VALVES 561 IN JUSTO, AND 951 AND 972 IN SAN YGNACIO.
5. OPEN ALL VALVES.

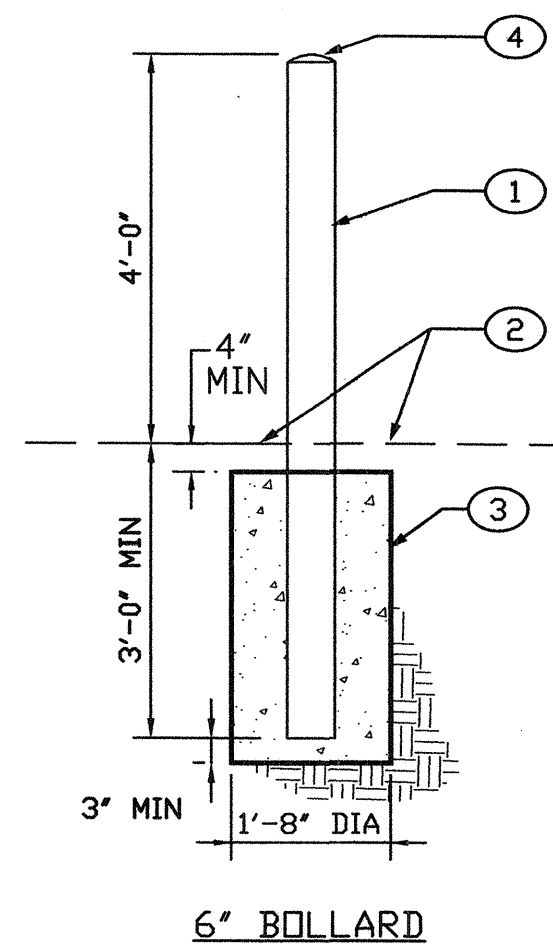

6" BOLLARD

- KEYED NOTES:
1. 6" DIA. STEEL PIPE W/REFLECTORIZED RED PAINT (CONC. FILLED W/SMOOTH EDGES).
 2. PAVEMENT SECTION OR FINISHED GRADE - SEE PLANS.
 3. CONCRETE FOOTING (3500 psi).
 4. ROUNDED CONCRETE.

TYPICAL BOLLARDS
SCALE: NTS

		BERNALILLO COUNTY PUBLIC WORKS DIVISION TECHNICAL SERVICES	
		TITLE: FOOTHILL/BRIDGE INFILL AREA SEWER AND WATER IMPROVEMENTS AREA 428 - FOOTHILL ROAD	
Design Review Committee	City Engineer Approval	Mo./Day/Yr.	Mo./Day/Yr.
Last Design Update _____		9/06	AS BUILT
		NO.	DATE
		REMARKS	BY
DESIGNED BY - NKB	DATE - 06/05		
DRAWN BY - PVL	DATE - 06/05		
CHECKED BY - DEB	DATE - 06/05		
City Project No. 747881	Zone Map No. L11	Sheet 19	Of 25
County Project No. TS01-20			


AS BUILT INFORMATION		BENCH MARKS		SURVEY INFORMATION		ENGINEER'S SEAL	
CONTRACTOR	NM UNDERGROUND	SURVEYOR TO CALL	ENGINEER	NO.	DATE	NO.	DATE
WORKED BY	VALS SURVEYING CO. 12/05	INSPECTED BY	BCPW	DATE	6/06	INSPECTED BY	BCPW
ACCEPTANCE BY	DATE 6/06	VERIFICATION BY	BCPW	DATE	6/06	VERIFICATION BY	BCPW
DESIGNED BY	DATE 9/06	RECORDED BY	DATE	DATE		RECORDED BY	DATE
MICRO-FILM INFORMATION				NO.			

RESTRAINING JOINT TABLE

FITTING TYPE	LENGTH OF RESTRAINED JOINTS (FT.)			
	4"	6"	8"	10"
6"x6" TEE	---	1	---	---
8"x6" TEE	---	1	1	---
10"x6" TEE	---	2	---	6
6"x4" REDUCER	---	28	---	---
8"x6" REDUCER	---	---	30	---
10"x4" REDUCER	---	---	---	70
10"x6" REDUCER	---	---	---	53
90° HORIZ. REDUCER	18	25	32	38
45° HORIZ. BEND	7	10	13	16
22.5° HORIZ. BEND	4	5	6	8
11.25° HORIZ. BEND	2	2	3	4
GATE VALVE /CAP	39	55	72	86
45° VER. BEND (UPPER)	16	23	30	36
45° VERT. BEND (LOWER)	11	15	19	22


NOTES

- ALL JOINTS SHALL BE RESTRAINED AT THE FITTING.
- THE CONTRACTOR SHALL RESTRAIN ALL PIPE JOINTS IN THE SPECIFIED DISTANCE LISTED IN THE TABLE ABOVE (SEE NOTE 2).
- THE CONTRACTOR SHALL RESTRAIN ALL FIRE HYDRANTS JOINTS FROM THE TEE ON THE MAIN TO THE FIRE HYDRANT FLANGES.
- RESTRAINED LENGTH IS ON LARGE SIDE ON ALL REDUCERS.
- RESTRAIN ALL JOINTS BETWEEN UPPER AND LOWER VERTICAL BENDS.
- IN PROXIMITY OF EXISTING PIPE WHICH MAY NOT BE RESTRAINED, CONCRETE BLOCKING IS REQUIRED TO ENSURE RESTRAIN WITHIN RESTRAIN LENGTH OF THE TIE-IN.

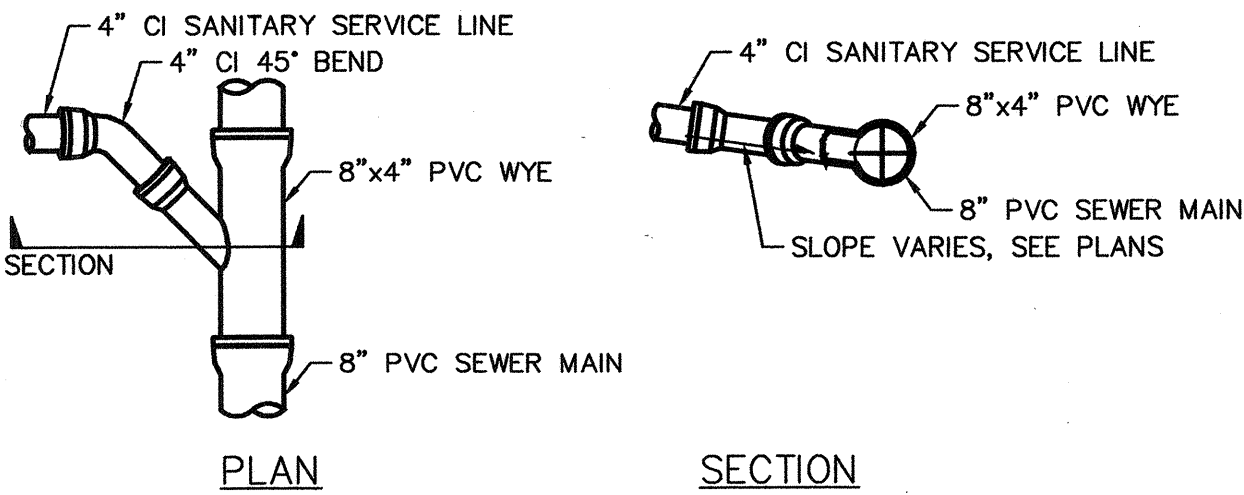


SHALLOW SEWER TAP DETAIL

SCALE: NONE

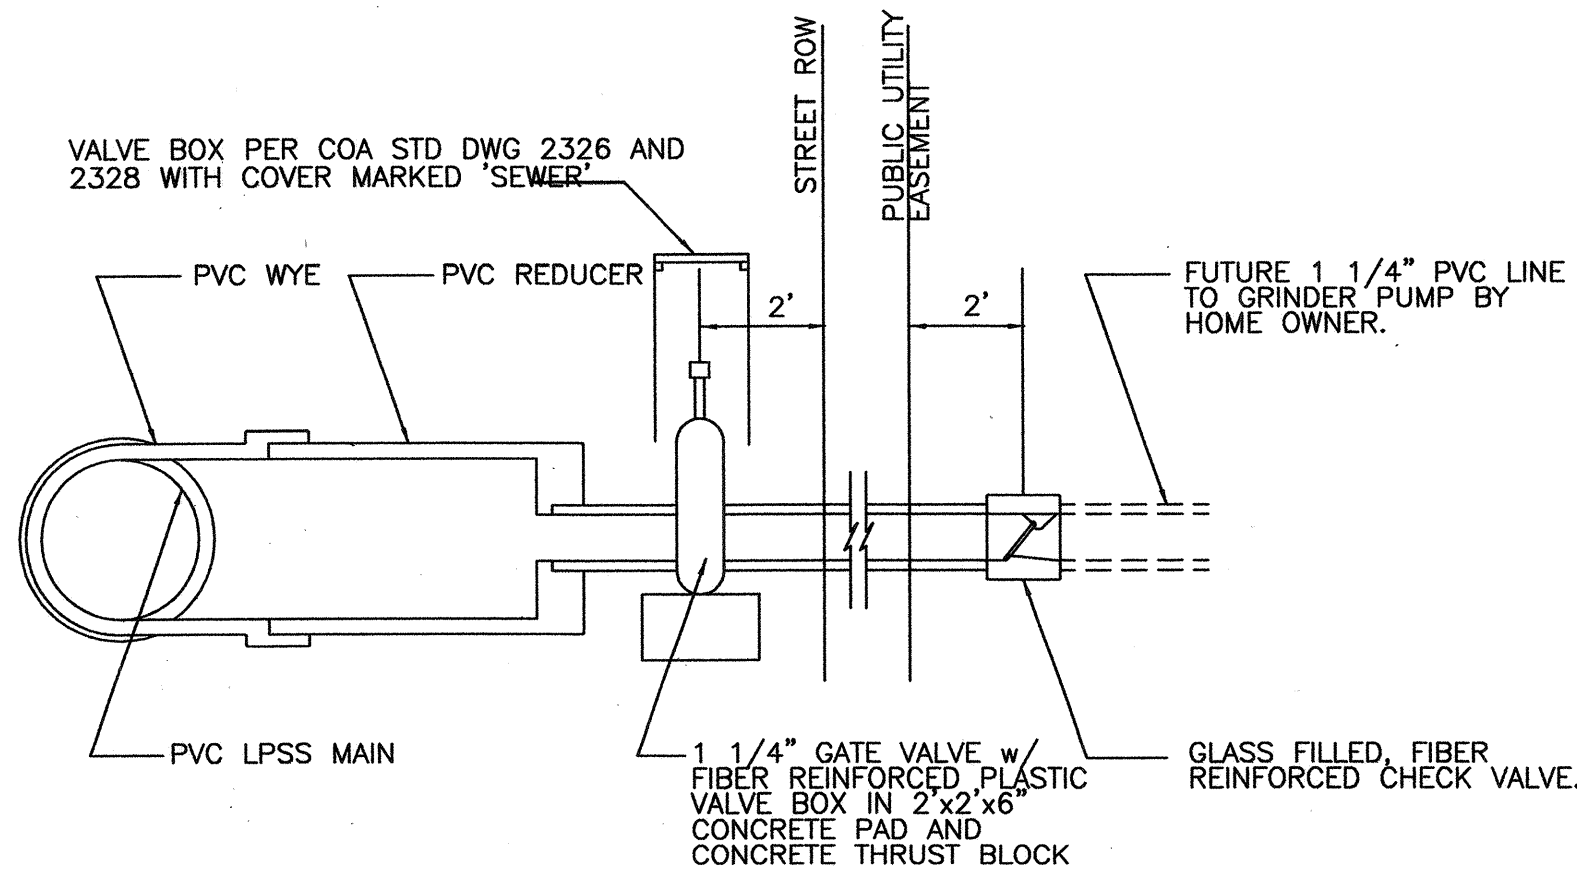

SEWER SERVICE LATERAL
N.T.S.

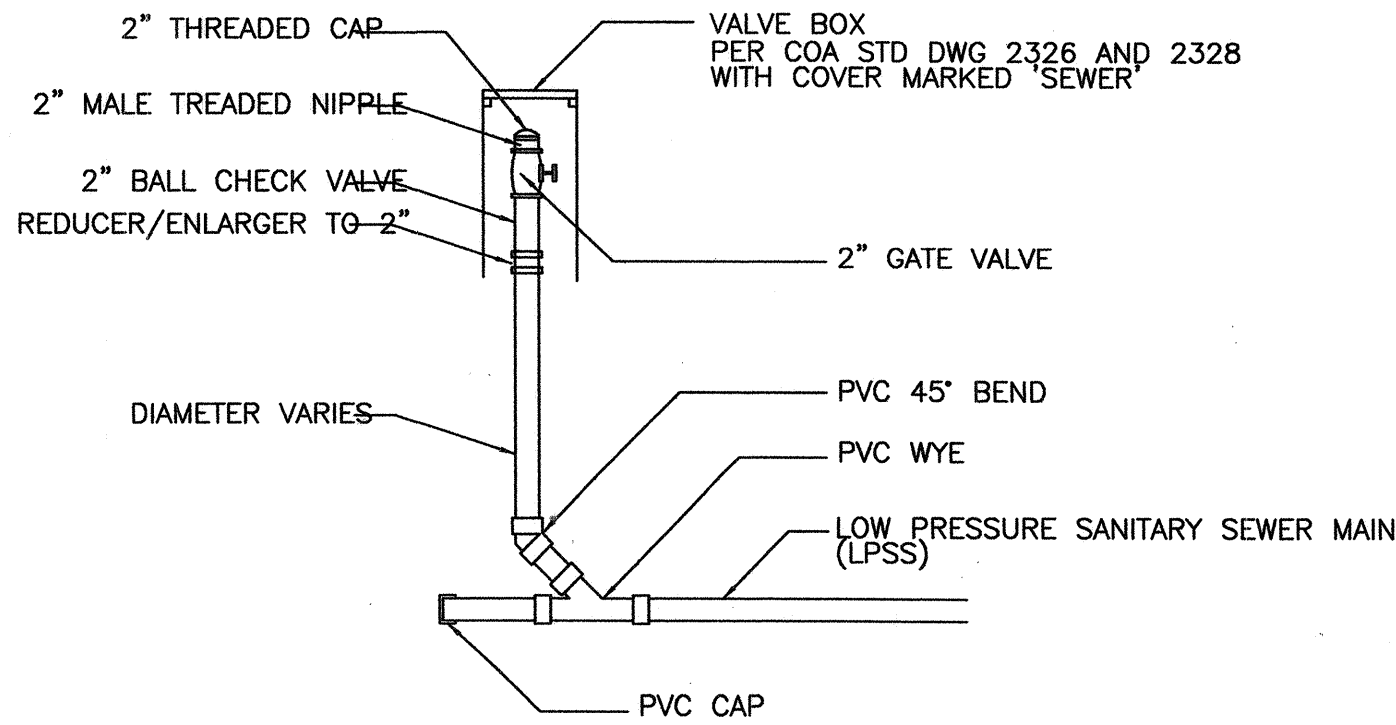

FLUSHING CONNECTION
N.T.S.

TYPICAL ROADWAY SECTION


SCALE: N.T.S.

3" RAP ROADWAY SECTION

INSTALL 3" RECYCLED ASPHALT BASE COURSE. UNPAVED ROADWAY RESTORATION TO EXISTING LINE AND GRADE SHALL BE CONSIDERED INCIDENTAL TO CONSTRUCTION.

3" BASE COURSE (BC) ROADWAY SECTION

INSTALL 3" BASE COURSE. UNPAVED ROADWAY RESTORATION TO EXISTING LINE AND GRADE SHALL BE CONSIDERED INCIDENTAL TO CONSTRUCTION.

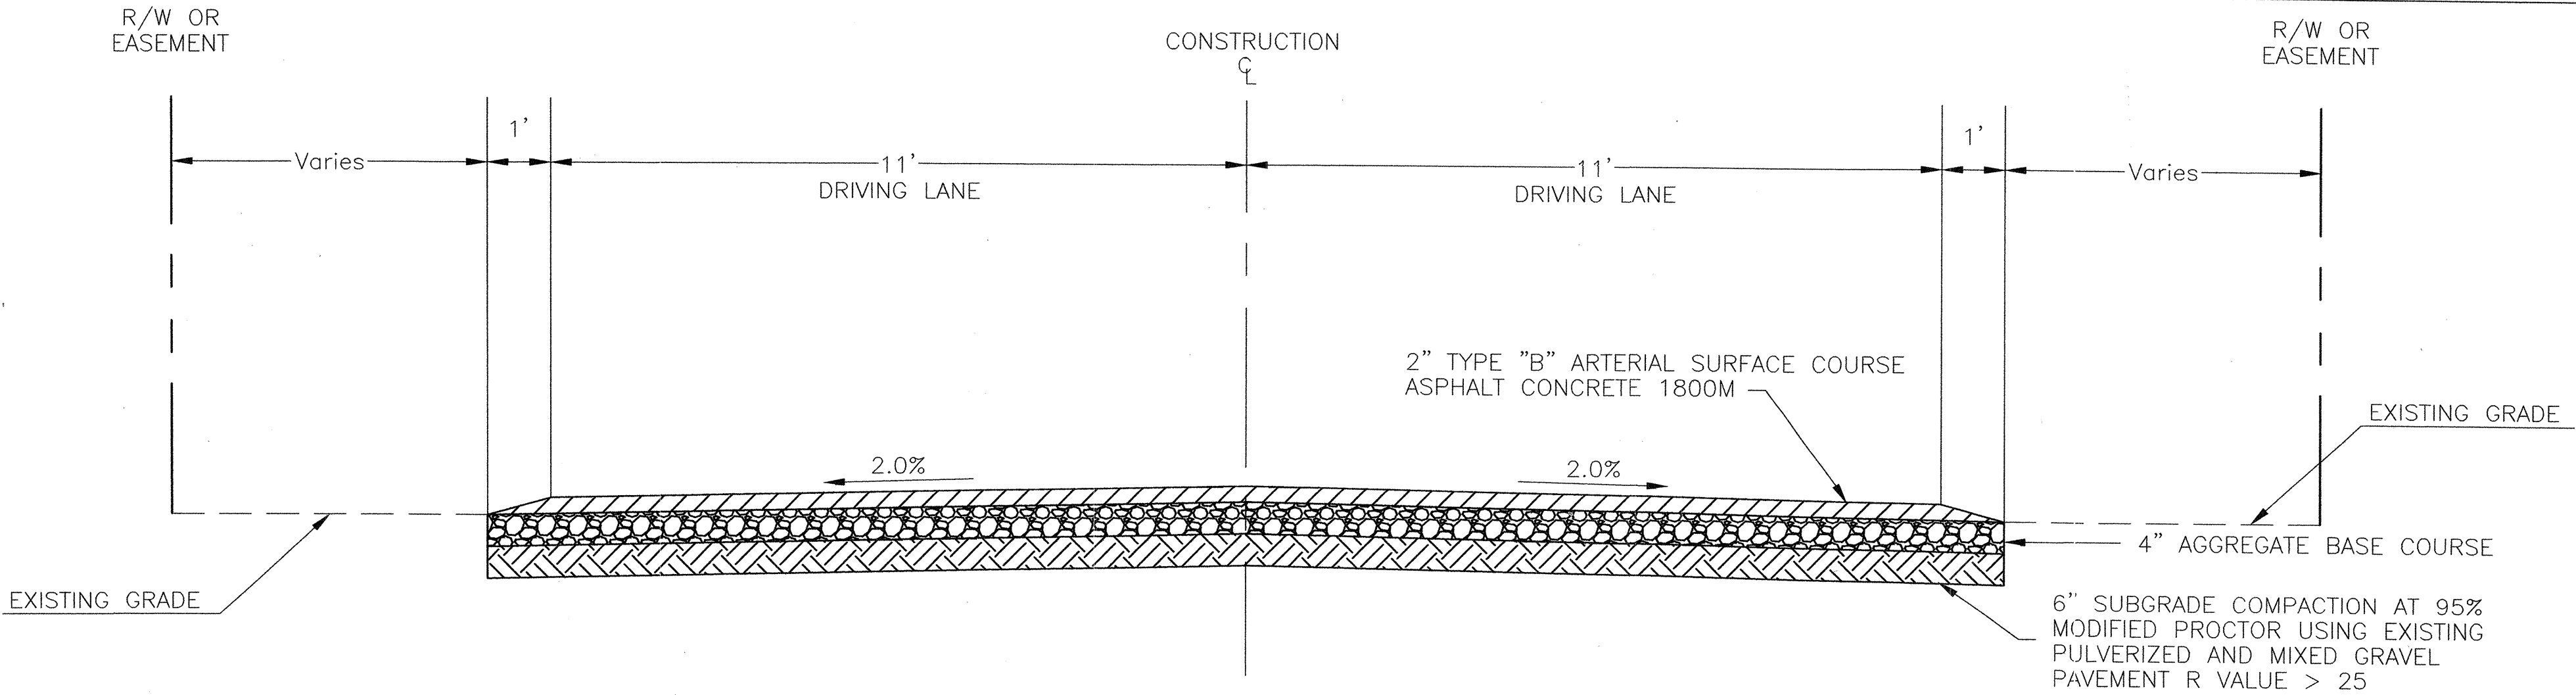

ROADWAY REHABILITATION								
SHEET	STREET OR BRANCH NAME	STREET WIDTH (FEET)	STREET LENGTH (FEET)	EXISTING PAVEMENT SECTION TYPE	PROPOSED PAVEMENT SECTION TYPE	STRIPING (Y=YES / N=NO)	ACCESS TYPE E=EASEMENT/LETTER L=LICENSE/PERMIT ROW=RIGHT-OF-WAY	COMMENTS
4	356 PRIVT. RD.	20	660	GRAVEL	3" RAP	N	E	
4	FOOTHILL RD.	25	160	TYPICAL	TYPICAL	Y	BERN CO. ROW	
5	JARAMILLO RD.	25	600	TYPICAL	TYPICAL	N	BERN CO. ROW	
5	FOOTHILL RD.	15	15	TYPICAL	TYPICAL	Y	BERN CO. ROW	PAVEMENT CUT*
6 & 7	ISLETA DRAIN	20	1230	GRAVEL	BC	N	L	
7	HOOPER RD.	25	30	TYPICAL	TYPICAL	Y	BERN CO. ROW	PAVEMENT CUT*
8	364 PRIVT. RD.	20	160	GRAVEL	3" RAP	N	E	
9	ISLETA DRAIN	20	680	GRAVEL	BC	N	L	
10	371 PRIVT.RD.	25	560	GRAVEL	3" RAP	N	E	
10	FOOTHILL RD.	15	15	TYPICAL	TYPICAL	Y	BERN CO. ROW	PAVEMENT CUT*
11	ISLETA DRAIN	20	280	GRAVEL	BC	N	L	
11	HOOPER RD.	25	30	TYPICAL	TYPICAL	Y	BERN CO. ROW	PAVEMENT CUT*
12 & 13	373 PRIVT. RD.	25	1300	GRAVEL	3" RAP	N	E	
12	FOOTHILL RD.	25	15	TYPICAL	TYPICAL	Y	BERN CO. ROW	PAVEMENT CUT*
13	ATRISCO RD.	25	25	TYPICAL	TYPICAL	Y	CABQ ROW	4" THICKNESS - PAVEMENT CUT*
14	FOOTHILL RD.	25	470	TYPICAL	TYPICAL	Y	BERN CO. ROW	ONE SPEED HUMP
15	412 PRIVT. RD.	20	290	TYPICAL	TYPICAL	N	E	
15	ATRISCO RD.	25	20	TYPICAL	TYPICAL	Y	BERN CO. ROW	4" THICKNESS - PAVEMENT CUT*
16	415 PRIVT	25	520	GRAVEL	3" RAP	N	E	
16	415 ESMT	20	150	GRAVEL	BC	N	E	
16	SALVADOR RD.	20	20	TYPICAL	TYPICAL	Y	BERN CO. ROW	PAVEMENT CUT*
16	PEREZ RD.	20	20	TYPICAL	TYPICAL	Y	BERN CO. ROW	PAVEMENT CUT*
18	426 PRIVT. RD.	25	750	GRAVEL	3" RAP	N	E	
18	ATRISCO RD.	15	15	TYPICAL	TYPICAL	Y	BERN CO. ROW	4" THICKNESS - PAVEMENT CUT*
19	FOOTHILL RD.	10	100	TYPICAL	TYPICAL	Y	BERN CO. ROW	
19	SAN YGNACIO RD	15	15	TYPICAL	TYPICAL	Y	BERN CO. ROW	PAVEMENT CUT*
* THE PAVEMENT CUT LISTED IS THE MAXIMUM CUT. PAVEMENT CUTS WILL BE REDUCED BASED ON FIELD CONDITIONS								

* THE PAVEMENT CUT LISTED IS THE MAXIMUM CUT. PAVEMENT CUTS WILL BE REDUCED BASED ON FIELD CONDITIONS

FOOTHILL / BRIDGE

POTHOLE RESULTS

AREA	PAGE	POTHOLE #	STATION	OFFSET	SIZE	TYPE	MATERIAL	TOP OF PIPE
356	4	1	8+82.65	5.38 L	6"	WATER	CCP	48"
356	4	1a	8+82.31	10.43 L	1"	CATV	D.B. Cable	20"
356	4	2	7+59.66	6.96 R		WATER	No Locate	Cird. to 8'
356	5	3	7+26.79	8.24 R		WATER	No Locate	Cird. to 8'
356	4	4	7+97.70	12.38 L	2"	GAS	METALLIC	34"
356	7	5	1+07.69	0.56 R		WATER	No Locate	Cird. to 8'
356	7	6	1+23.46	1.61 L	2"	GAS	METALLIC	40"
371-2	10	7	8+79.10	6.92 L	2"	GAS	METALLIC	37"
371-2	10	8	12+43.56	2.23 L		WATER	No Locate	Cird. to 8'
373-2	11	9	00+98.80	11.65 R	36"	WATER	CCP	80"
373-2	11	10	3+13.86	14.84 R	36"	WATER	CCP	59"
373-2	11	11	1+02.09	19.94 R	20"	WATER	CCP	37"
373-2	11	12	1+13.63	7.41 R		WATER	No Locate	Cird. to 8'
373-2	11	13	00+94.42	16.21 L	5"	GAS	METALLIC	64"
373-2	11	14a	2+60.78	23.65 R	2"	GAS	Poly	30"
373-2	11	14	3+14.41	23.72 R		GAS	No Locate	Cird. to 8'
373-2	12	18	8+48.38	5.86 L	36"	WATER	CCP	64"
412	15	19	1+32.92	3.28 R		WATER	No Locate	Cird. to 8'
373-2	13	21	4+57.42	40.13 R	2"	GAS	METALLIC	27"
412	15	20	1+28.54	7.23 R	16"	WATER	METALLIC	42"
373-2	13	22	4+60.30	1.64 L	6"whp	GAS	METALLIC	38"
373-2	13	24	4+56.73	1.97 L	16"	WATER	AC	48"
373-2	13	25	4+62.46	3.27 L	12"	WATER	METALLIC	34"
373-2	13	26	4+62.54	33.55 L	2"	WATER	METALLIC	34"



BERNALILLO COUNTY
PUBLIC WORKS DIVISION
TECHNICAL SERVICES

TITLE: FOOTHILL/BRIDGE INFILL AREA SEWER AND WATER IMPROVEMENTS

UTILITY DETAILS


Design Review Committee	City Engineer Approval	Mo./Day/Yr.	Mo./Day/Yr.
City Project No. 747881	Zone Map No.	Sheet 20	Of 25
County Project No. TS01-20			

CONSTRUCTION TRAFFIC CONTROL GENERAL NOTES


1. PROJECT IS SUBJECT TO THE REQUIREMENTS OF COUNTY ORDINANCE NO. 95-12 AND COUNTY ORDINANCE NO. 96-3. THE CONTRACTOR IS RESPONSIBLE FOR ACQUIRING ALL PERMITS NECESSARY. CONTRACTOR SHALL CALL 848-1504 FOR MORE INFORMATION.
2. THE CONTRACTOR SHALL SUBMIT A TRAFFIC CONTROL PLAN TO THE COUNTY TRAFFIC CONTROL ADMINISTRATOR AT LEAST 72 HOURS PRIOR TO COMMENCEMENT OF WORK. TRAFFIC CONTROL PLANS SHALL BE PREPARED IN ACCORDANCE WITH THE MANUAL ON UNIFORM TRAFFIC CONTROL DEVICES (MUTCD), LATEST EDITION AND BY CERTIFIED PERSONNEL AND MUST BE APPROVED PRIOR TO COMMENCEMENT OF WORK ON THE PROJECT. CALL 848-1504 FOR FURTHER INFORMATION.
3. A DAILY TRAFFIC CONTROL LOG SHALL BE MAINTAINED BY THE CONTRACTOR REFLECTING THE TYPES AND LOCATIONS OF ALL TRAFFIC CONTROL DEVICES, SIGNS, BARRICADES, ETC. BEING USED ON THE PROJECT IN COMPLIANCE WITH THE APPROVED TRAFFIC CONTROL PLAN. THIS LOG SHALL BE SUBMITTED TO THE BERNALILLO COUNTY TRAFFIC CONTROL ADMINISTRATOR UPON COMPLETION OF THE PROJECT CONSTRUCTION OR WHEN SO REQUESTED BY THE PROJECT MANAGER OR THE BERNALILLO COUNTY TRAFFIC CONTROL ADMINISTRATOR.
4. CONTRACTOR SHALL PROVIDE A WEEKLY CONSTRUCTION ACTIVITY SCHEDULE TO BERNALILLO COUNTY PUBLIC WORKS DIVISION ATTN: PROJECT MANAGER
5. THE CONTRACTOR SHALL FILE A WEEKLY WRITTEN REPORT TO THE TRAFFIC CONTROL ADMINISTRATOR DESCRIBING THE TRAFFIC CONTROL PLAN THAT WILL BE IN EFFECT FOR THE FOLLOWING WEEK.
6. SUBJECT TO THE APPROVED TRAFFIC CONTROL PLAN, AT LEAST ONE LANE SHALL BE OPEN TO TRAFFIC AT ALL TIMES. CONTRACTOR SHALL PROVIDE PROPER SIGNAGE AND FLAGMAN AND SHALL MAINTAIN THE TRAFFIC LANE IN SUCH A MANNER AS TO ASSURE PROPER SAFETY TO THE TRAVELING PUBLIC AT ALL TIMES, EXCEPT WHEN GRADING, EXCAVATION AND BACKFILL OPERATIONS ARE BEING CONDUCTED IMMEDIATELY IN FRONT OF THE PROPERTY, IN WHICH CASE ACCESS WILL NOT BE DENIED FOR MORE THAN 4 HOURS WITHOUT APPROVAL BY THE COUNTY.
7. TRAFFIC LANES PROVIDED DURING CONSTRUCTION SHALL BE MAINTAINED, IN SUCH A CONDITION UNDER ALL WEATHER CONDITIONS, SO AS TO PERMIT THE REASONABLE PASSAGE OF PASSENGER VEHICLES, AND SHALL BE KEPT GRADED AND SMOOTH, AND WATERED SEVERAL TIMES DAILY TO CONTROL DUST.
8. TYPICAL TRAFFIC CONTROL PLANS DO NOT REFLECT THE EXISTING TOPOGRAPHY SUCH AS DRIVEWAYS, LANE WIDTHS, AND BUSINESS/RESIDENTIAL ACCESSES. EVERY LOCATION THAT REQUIRES CONSTRUCTION TRAFFIC CONTROL SHALL HAVE A DETAILED TRAFFIC CONTROL PLAN SHOWING ALL EXISTING TOPOGRAPHY.
9. CONSTRUCTION SHALL NOT BEGIN UNLESS A TRAFFIC CONTROL PLAN HAS BEEN APPROVED AND VERIFIED BY BERNALILLO COUNTY TRAFFIC ENGINEERING.
10. ALL CONSTRUCTION TRAFFIC CONTROL DEVICES SHALL COMPLY WITH THE MANUAL ON UNIFORM TRAFFIC CONTROL DEVICES (MUTCD), LATEST EDITION. IT IS THE RESPONSIBILITY OF THE CONTRACTOR TO INSTALL, SERVICE AND MAINTAIN ALL TRAFFIC CONTROL DEVICES. TRAFFIC CONTROL DEVICES SHALL NOT BE REMOVED OR ALTERED IN ANY WAY WITHOUT THE APPROVAL OF THE COUNTY TRAFFIC CONTROL ADMINISTRATOR, PER SECTION 6A-4 OF THE MUTCD, LATEST EDITION.
11. THE CONSTRUCTION TRAFFIC CONTROL INITIAL SET-UP FOR EACH PHASE SHALL BE BY AN AMERICAN TRAFFIC SAFETY SERVICES ASSOCIATION (ATSSA) CERTIFIED WORKSITE TRAFFIC SUPERVISOR. THE MAINTENANCE AND SERVICING SHALL ALSO BE DONE BY AN ATSSA CERTIFIED WORKSITE TRAFFIC SUPERVISOR OR EQUIVALENT.
12. CONTRACTOR IS RESPONSIBLE TO MAINTAIN AND SERVICE ALL TRAFFIC CONTROL DEVICES 24 HOURS A DAY, 7 DAYS A WEEK THROUGHOUT LENGTH OF PROJECT. CONTRACTOR IS RESPONSIBLE THAT ALL TRAFFIC CONTROL DEVICES COMPLY WITH THE MUTCD, LATEST EDITION.
13. ALL ADVANCE WARNING SIGNS SHALL BE DOUBLE INDICATED WHENEVER THERE ARE MULTI-LANE TRAFFIC IN ANY ONE GIVEN DIRECTION AND THERE IS SUFFICIENT MEDIAN SPACE.

14. ALL BARRICADES IN ALL TAPERS AND TANGENTS SHALL BE PLACED APART, A DISTANCE MEASURED IN FEET, EQUAL TO THAT OF THE POSTED SPEED LIMIT. NO EXCEPTIONS UNLESS APPROVED BY BERNALILLO COUNTY TRAFFIC ENGINEERING PER MUTCD SECTION 6A-4.
15. ALL WORK IN ARTERIAL ROADWAYS SHALL BE ON A CONTINUOUS 24 HOUR PER DAY BASIS UNTIL COMPLETED.
16. EQUIPMENT OR MATERIALS SHALL NOT BE STORED WITHIN 15 FEET OF A TRAVELED TRAFFIC LANE DURING NON-WORKING HOURS WITHOUT THE APPROVAL OF BERNALILLO COUNTY TRAFFIC ENGINEERING.
17. CONTRACTOR SHALL PROVIDE AND MAINTAIN A SAFE AND ADEQUATE MEANS OF CHANNELIZING PEDESTRIAN TRAFFIC AROUND AND THROUGH THE CONSTRUCTION AREA.
18. CONTRACTOR IS RESPONSIBLE FOR OBLITERATION OF ANY CONFLICTING STRIPING AND RESPONSIBLE FOR ALL TEMPORARY STRIPING.
19. CONTRACTOR SHALL MAINTAIN ACCESS TO ALL FACILITIES, BUSINESSES AND/OR RESIDENTS AT ALL TIMES.
20. CONTRACTOR SHALL PROVIDE ACCESS SIGNS FOR BUSINESSES LOCATED WITHIN THE CONSTRUCTION AREA UNDER THE SUPERVISION OF BERNALILLO COUNTY TRAFFIC ENGINEERING. EACH ACCESS SIGN SHALL HAVE 5 INCH, WHITE LETTERING ON BLUE BACKGROUND. SHOPPING CENTERS AND MALLS SHALL BE LISTED AS SUCH.
21. 48 HOURS PRIOR TO OCCUPYING OR CLOSING OF A RIGHT-OF-WAY, CONTRACTOR SHALL NOTIFY: POLICE, FIRE DEPARTMENT, SCHOOLS, HOSPITALS, TRANSIT AUTHORITY, BUSINESSES AND/OR RESIDENTS THAT WILL BE AFFECTED BY THE CONSTRUCTION.
22. ANY FIELD ADJUSTMENTS SHALL BE APPROVED BY BERNALILLO COUNTY TRAFFIC ENGINEERING.
23. EXCAVATIONS SHALL BE PLATED, TEMPORARILY PATCHED OR RESURFACED PRIOR TO OPENING OF TRAFFIC. A MINIMUM OF 11 FEET, SHALL BE PROVIDED FOR TRAFFIC IN ANY GIVEN DIRECTION. CONTRACTOR IS RESPONSIBLE FOR ANY WORK INVOLVED IN SATISFYING THESE REQUIREMENTS.

SIGN FACE DETAILS

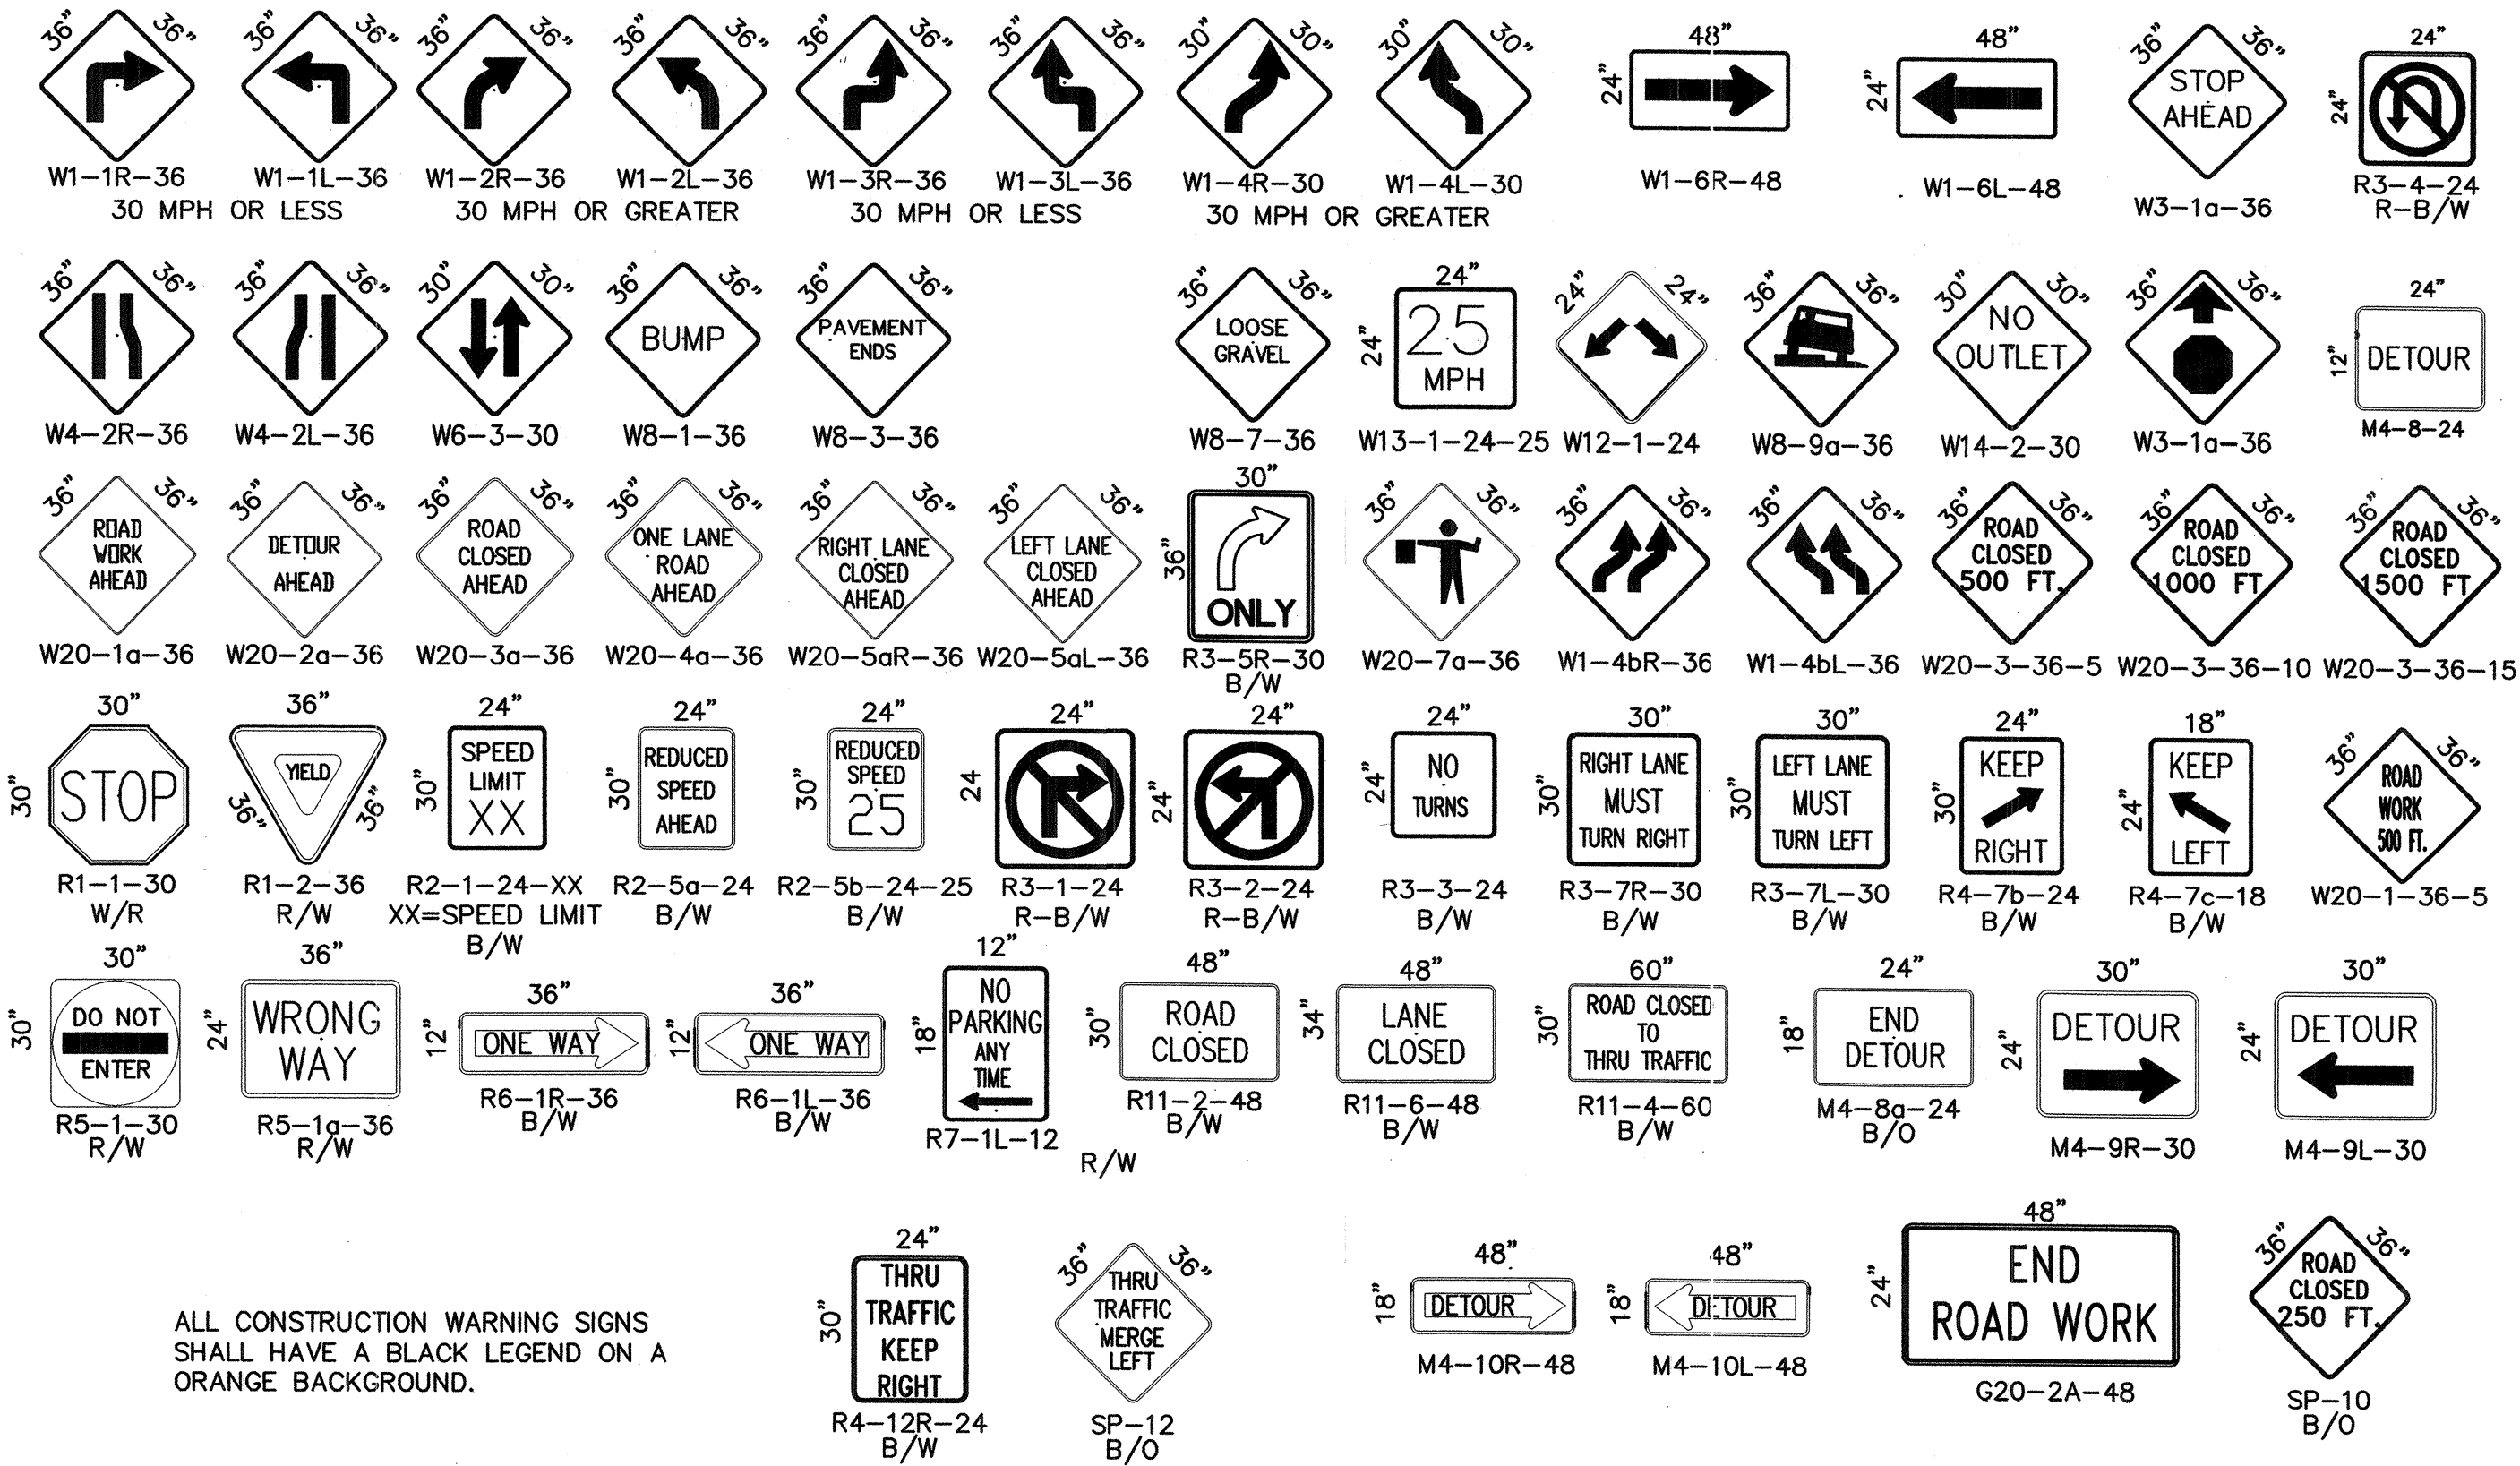


ALL CONSTRUCTION WARNING SIGNS SHALL HAVE A BLACK LEGEND ON A ORANGE BACKGROUND.

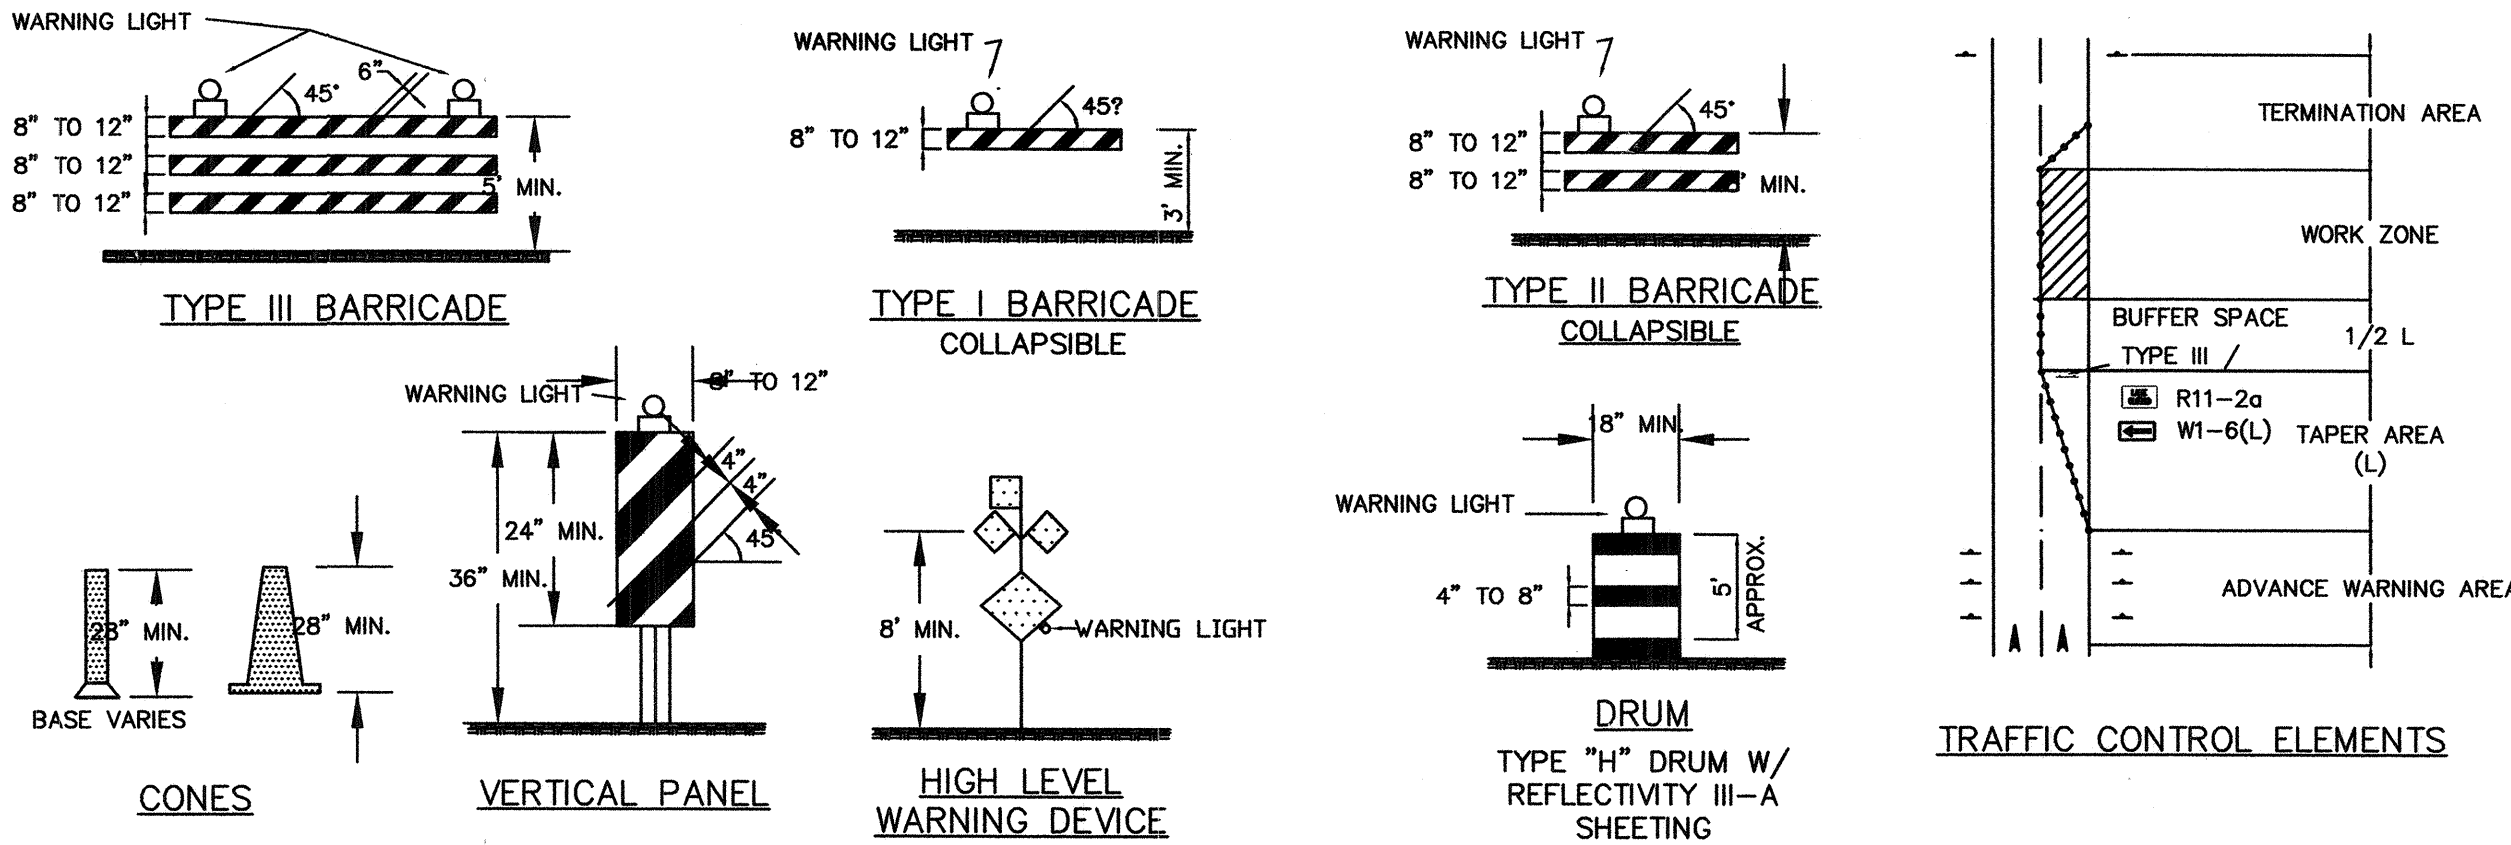

LEGEND


- WORK AREA
- BARRICADE - TYPE I, TYPE II, OR TYPE "H" DRUM W/ REFLECTIVITY III-A SHEETING
 - BARRICADE - TYPE III
 - VERTICAL PANEL
 - WARNING SIGN
 - DISTANCE BETWEEN SIGNS - A DISTANCE MEASURED IN FEET EQUAL TO A VALUE OF TEN TIMES THE SPEED LIMIT OF THE STREET
 - FLAGMAN POSITION
 - SPACING BETWEEN BARRICADES- A DISTANCE MEASURED IN FEET EQUAL TO THE SPEED LIMIT OF THE STREET
 - TAPER LENGTH - SEE CHART BELOW
- THE TANGENT LENGTH IS EQUAL TO THE TAPER LENGTH FOR A GIVEN STREET.

TITLE: FOOTHILL/BRIDGE INFILL AREA SEWER AND WATER IMPROVEMENTS TRAFFIC CONTROL NOTES			
Design Review Committee	City Engineer Approval	Mo./Day/Yr.	Mo./Day/Yr.
Last Design Update			
City Project No. 747881	Zone Map No.	Sheet 21	Of 25
County Project No. TS01-20			

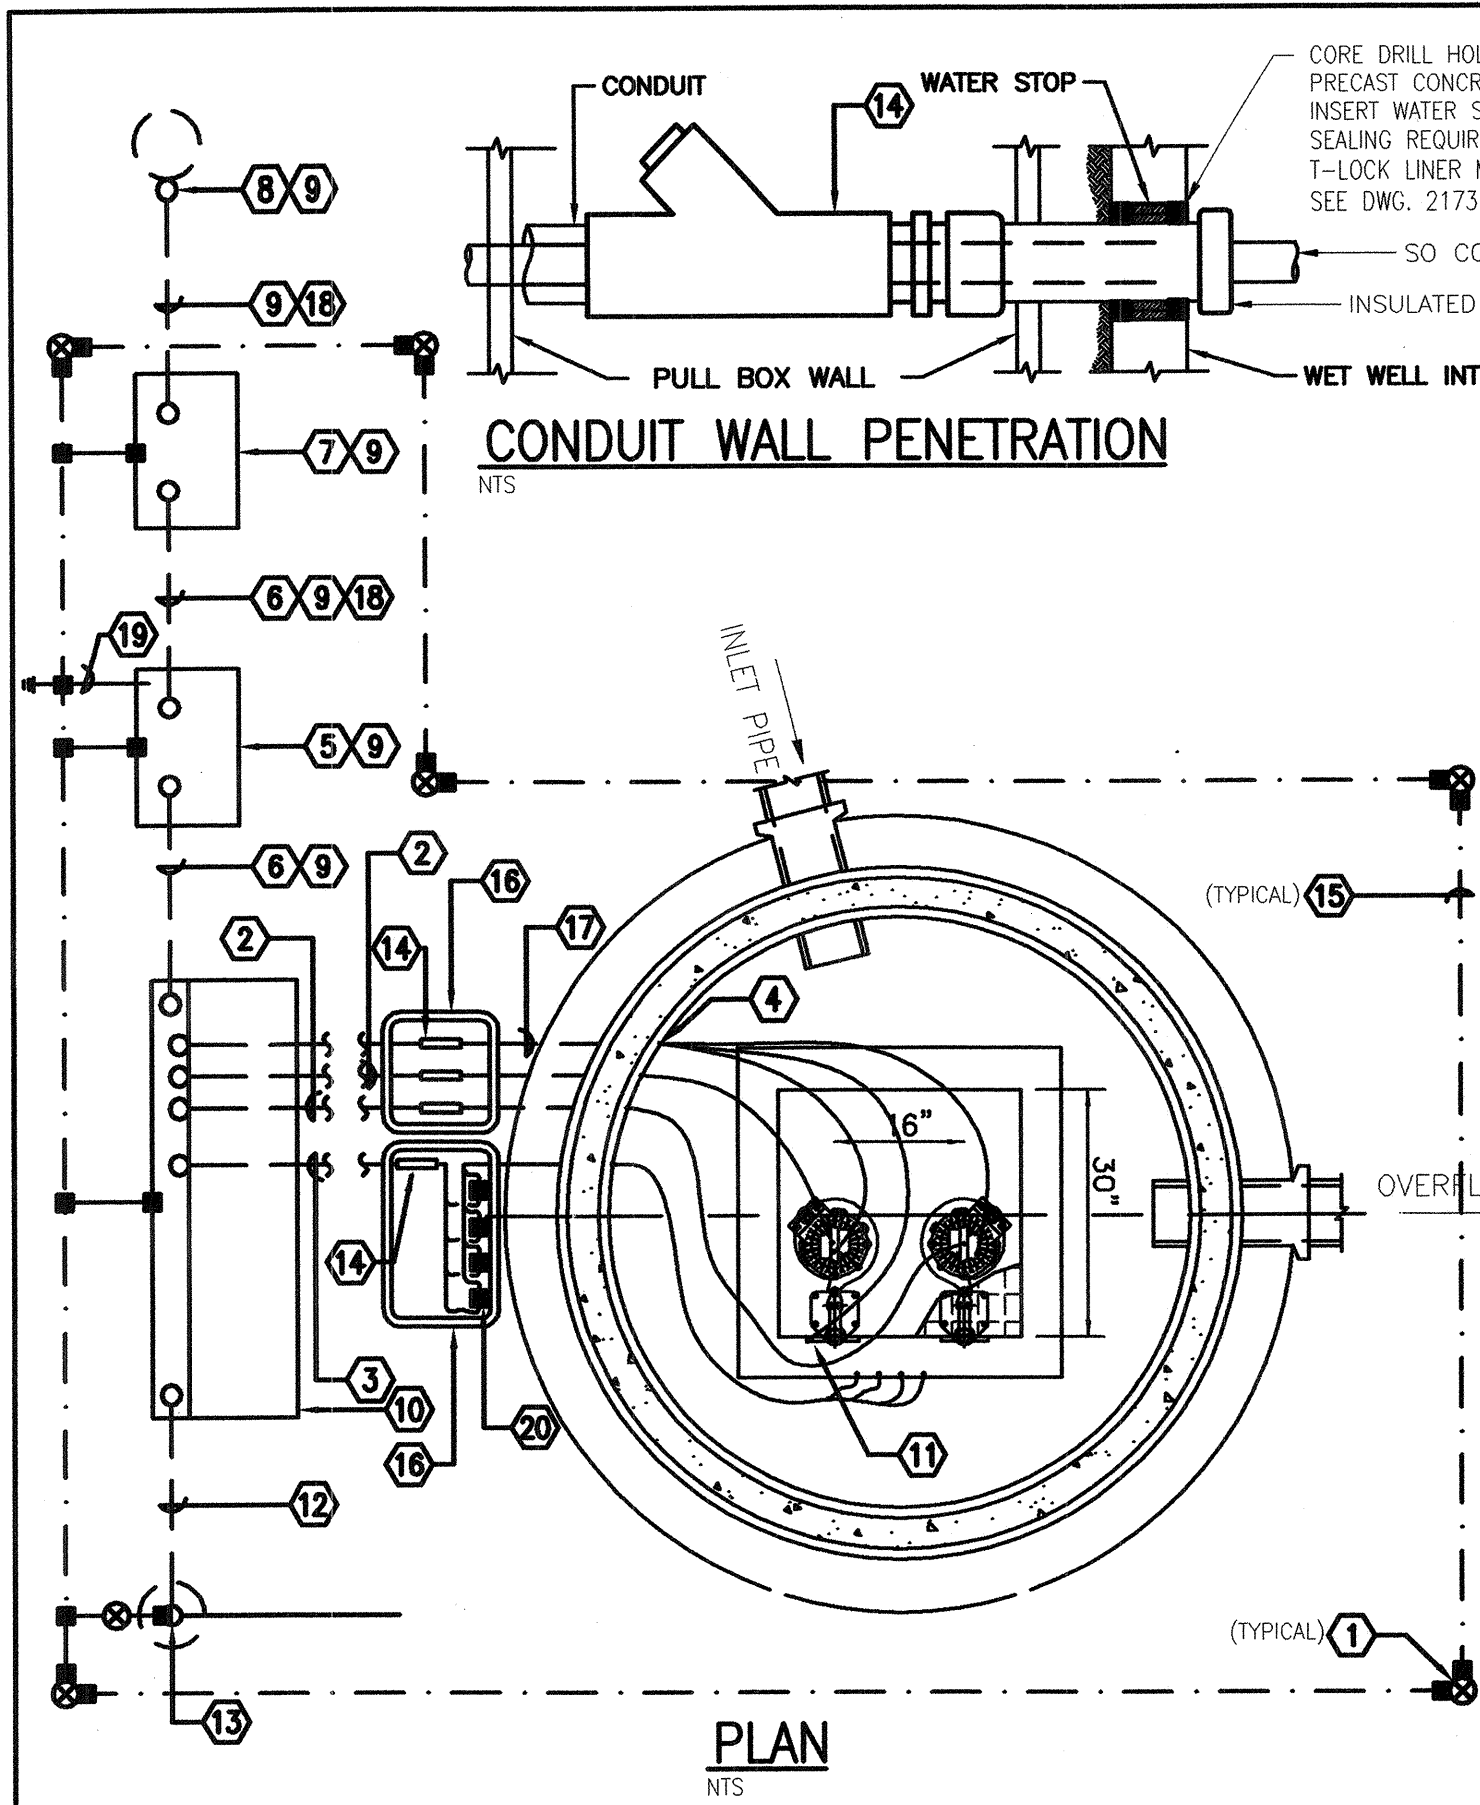

- KEYED NOTES**
- GROUND ROD, 3/4" X 10'-0". ALL CONNECTION SHALL BE CADWELDED. EACH GROUND ROD TO BE ACCESSIBLE BY MEANS OF A TRAFFIC RATED MONUMENT LID. LID WILL HAVE THE WORDS "GROUND WELL" CAST INTO LID.
 - PVC COATED RIGID CONDUIT WITH (1) 5 CONDUCTOR SO CORD SUPPLIED WITH PUMPS.
 - PVC COATED RIGID CONDUIT, WITH (1) 6-CONDUCTOR SO CORD SUPPLIED WITH EACH LEVEL SWITCH. (TOTAL 4 SWITCHES)
 - WET WELL WALL PENETRATION FOR ENLARGED VIEW SEE DETAIL ON THIS SHEET.
 - SERVICE DISCONNECT, HEAVY DUTY, NEMA 3R, 30A/3P, 480 VOLT FUSIBLE. SIZE FUSES PER EQUIPMENT MANUF. RECOMMENDATION. LOCKABLE COVER AND LOCKABLE SWITCH IN ON AND/OR OFF POSITION.
 - SERVICE CONDUIT AND CONDUCTOR - 4#6, 1#10 GROUND, 1" C.
 - METER ENCLOSURE PER PNM REQUIREMENTS. PNM DWG. MS-2-6.0.
 - SERVICE RISER PER PNM REQUIREMENTS. PNM DWG. DS-4-9.5.
 - BASED ON 480 VOLT, 3 PHASE SERVICE AND CONNECTED LOAD.
 - LIFT STATION CONTROL PANEL.
 - MAN HOLE INTRUSION LIMIT SWITCH, SPOT, HEAVY DUTY, CLASS 1, DIVISION II, TOP PLUNGER, 1NO, 1NC CONTACTS, SEALED MAGNET ACTIVATED SWITCH. INSTALL ON ANGLE IRON MOUNTED ON LARGE MAN HOLE COVER. USE ONLY SS316 HARDWARE AND NUTS. BOLTS OR SCREWS.
 - 1-1/2" C. (1) 1/2" HELIAX TRANSMISSION LINE.
 - ANTENNA MAST PER SUPPL. DWG. 2178.
 - CROUSE-HINDS CGSP SEALING CORD AND CABLE FITTING PROVIDED BY THIS CONTRACTOR. SIZED FOR CORD AND CONDUIT. SEALING COMPOUND WILL BE PROVIDED BY COA.
 - 1/0 BARE STRANDED COPPER GROUND CONDUCTOR. 2'-0" MIN. BURY. ALL CONNECTION SHALL BE CADWELDED.
 - TRAFFIC RATED BOX AND COVER PER SUPPL. DWG. 2179.
 - 1" PVC COATED RIGID CONDUIT WITH 14/2 SO CORD TO 1 INTRUSION ALARM SWITCH AND 2-12/4 SO CORD MOTOR OVERLOADS.
 - 4#6 IN 1" CONDUIT.
 - GROUND PER NEC.
 - PROVIDE 4-6 POLE TERMINAL BLOCKS MOUNTED TO SIDE OF BOX ON MOUNTING TRACKS. TERMINATE CONDUCTORS FROM LEVEL SWITCHES ON ONE SIDE AND CONTINUE LEVEL SWITCH CIRCUIT FROM OTHER SIDE TO CONTROL PANEL.

REVISIONS	CITY OF ALBUQUERQUE
	SEWER
	LIFT STATION - ELECTRIC PLAN
	SUPPL. DWG. 2175
	JULY 2005

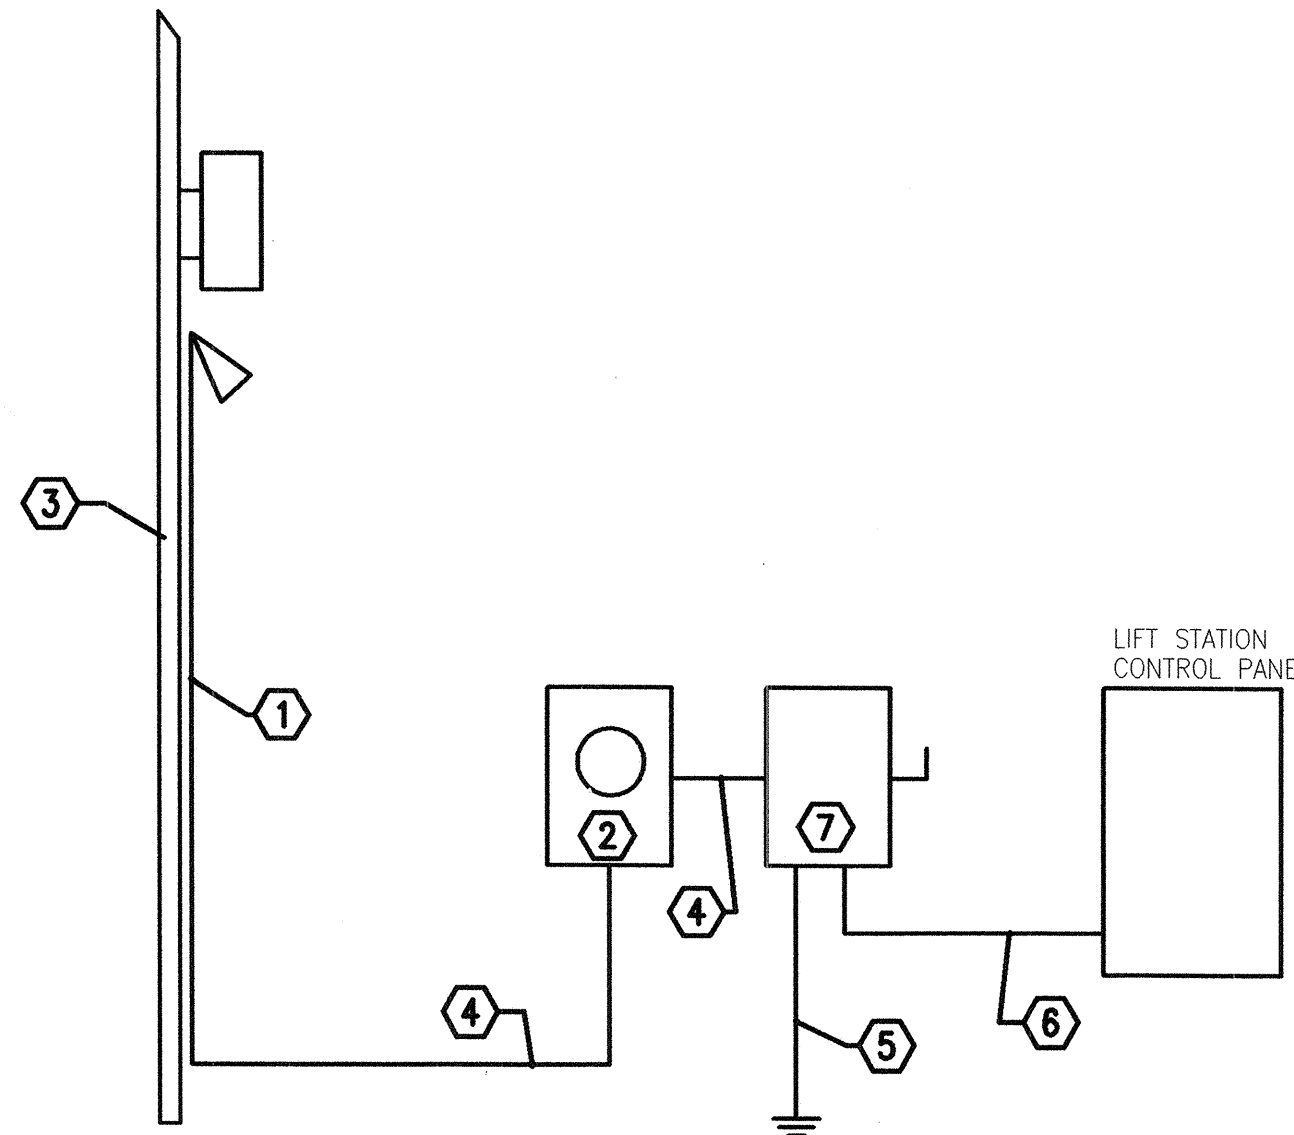

KEYED NOTES




- SERVICE RISER PER PNM REQUIREMENTS. PNM DWG. DS-4-9.5.
- METER ENCLOSURE PER PNM REQUIREMENTS. PNM DWG. MS-2-6.0.
- NEW POLE WITH TRANSFORMERS. COORDINATE INSTALLATION WITH PNM.
- 4#6 IN 1" CONDUIT.
- GROUND PER NEC.
- SERVICE CONDUIT AND CONDUCTOR - 4#6, 1#10 GROUND, 1" C.
- SERVICE DISCONNECT, HEAVY DUTY, NEMA 3R, 30A/3P, 480 VOLT FUSIBLE. SIZE FUSES PER EQUIPMENT MANUF. RECOMMENDATION. LOCKABLE COVER AND LOCKABLE SWITCH IN ON AND/OR OFF POSITION.
- BASED ON 480 VOLT, 3 PHASE SERVICE AND CONNECTED LOAD.

LOAD SUMMARY	
AREA "H" LIFT STATION 2-PUMPS EACH AT 3.4	6.8 KVA
TOTAL	6.8 KVA
8.2 AMPS AT 480/277V	
MINIMUM SERVICE CAPACITY 125% X TOTAL EXISTING LOAD	8.5 KVA
11 AMPS AT 480/277V-3Ø-4W	
MINIMUM RECOMMENDED SERVICE	30 AMPS

POWER RISER DIAGRAM ⑧


NTS

REVISIONS	CITY OF ALBUQUERQUE
	SEWER
	LIFT STATION - POWER RISER
	AND LOAD SUMMARY
	SUPPL. DWG. 2182
	JUNE 2005

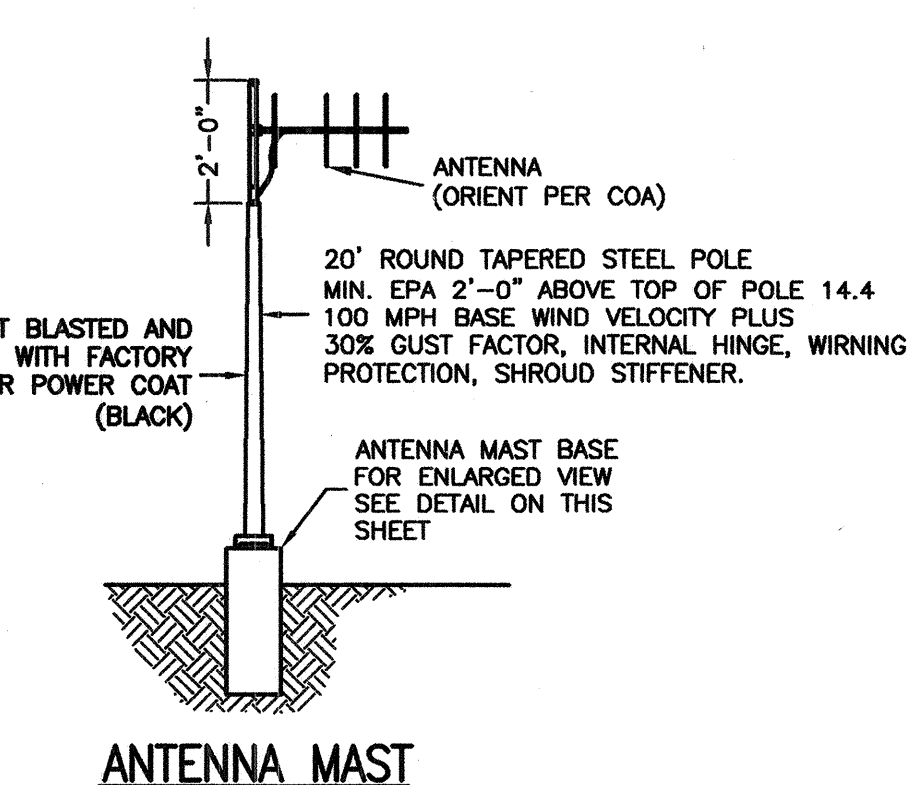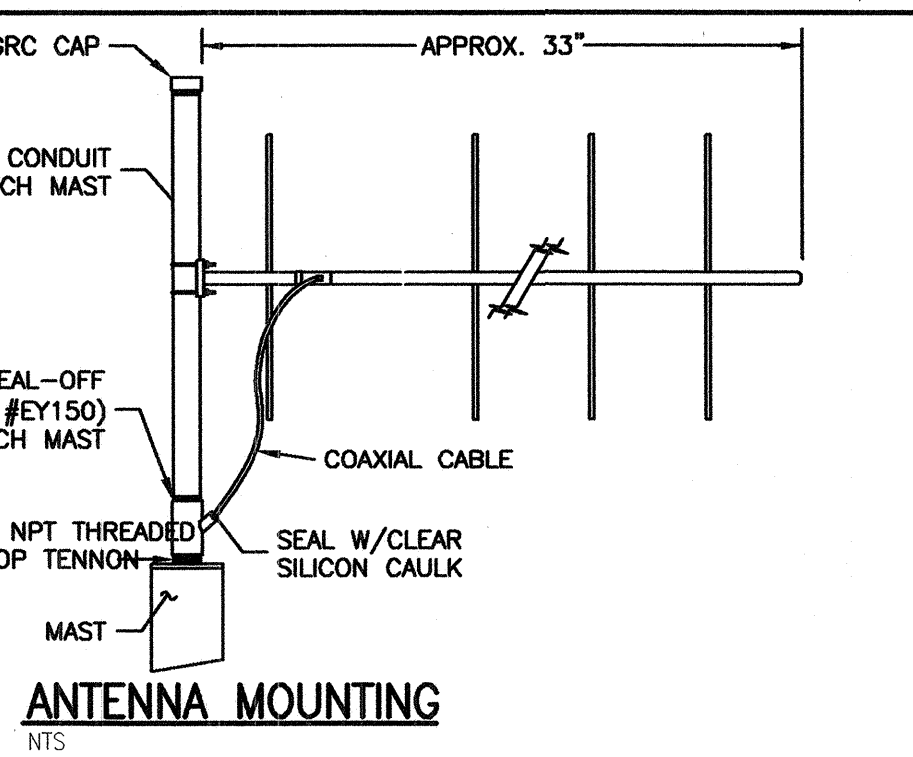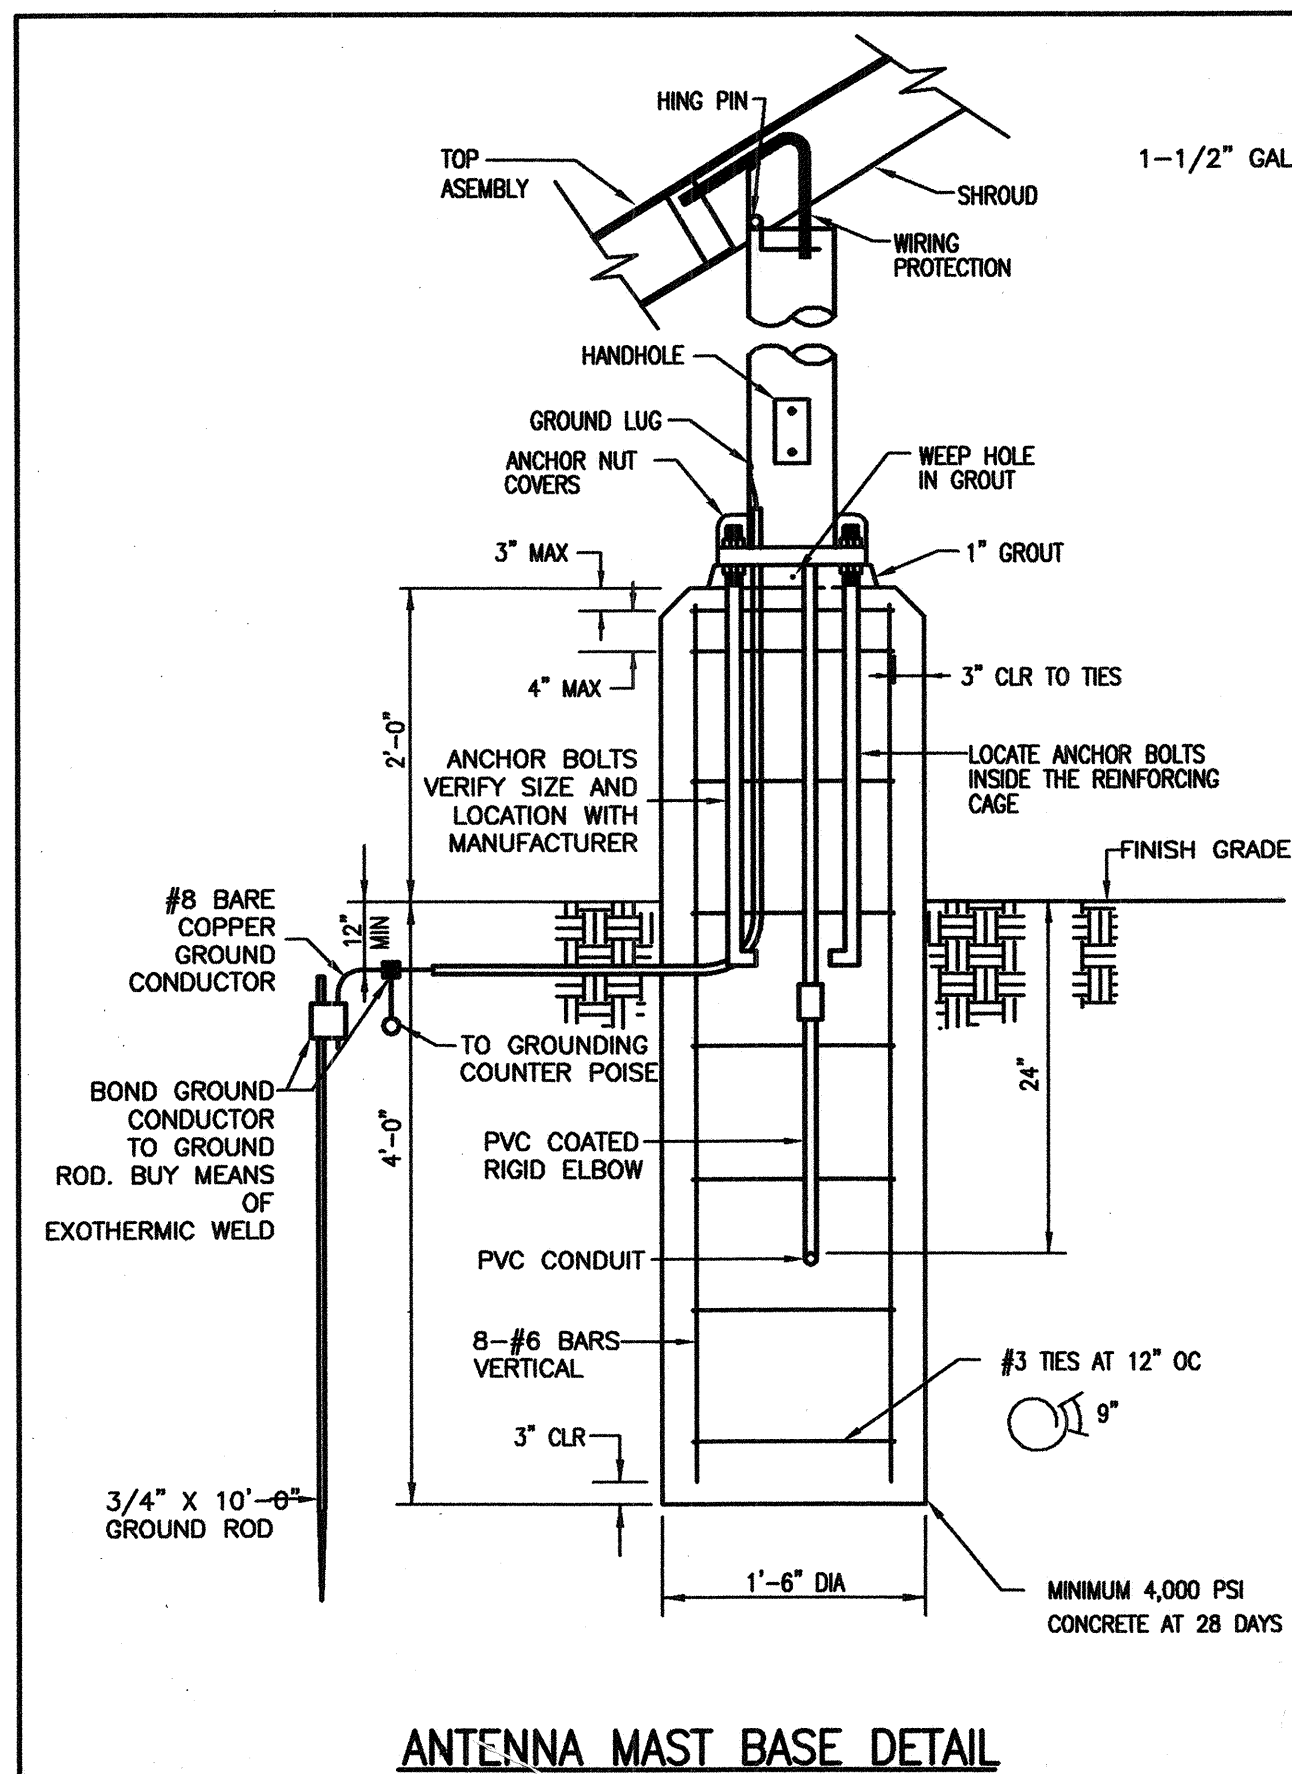

REVISIONS	CITY OF ALBUQUERQUE
	SEWER
	LIFT STATION - ANTENNA
	SUPPL. DWG. 2178
	JULY 2005

LEGEND FOR ELECTRICAL SCHEMATICS	
SYMBOLS	DESCRIPTION
	CIRCUIT BREAKER
	MAINTAINED SELECTOR SWITCH
	SWITCH
	MOMENTARY PUSH-BUTTON SWITCH, NORMALLY CLOSED
	LIQUID LEVEL SWITCH
	LIMIT SWITCH
	OVERLOAD/OVERTEMP ELEMENT
	RELAY, CONTACTOR, OR TIMER CONTACT, NORMALLY OPEN
	RELAY, CONTACTOR, OR TIMER CONTACT, NORMALLY CLOSED
	RELAY, CONTACTOR, OR TIMER COIL
	MOTOR
	INDICATOR LAMP (R=RED) (G=GREEN)
	FIELD DEVICE TERMINATION
	EXTERNAL CONDUIT/CONDUCTORS
	INTERNAL WIRING
	TRANSFORMER
	TEMPERATURE ACTIVATED SWITCH
	GROUND ROD
	EXOTHERMIC CONNECTION
	UNDERGROUND COUNTERPOISE CONDUCTOR

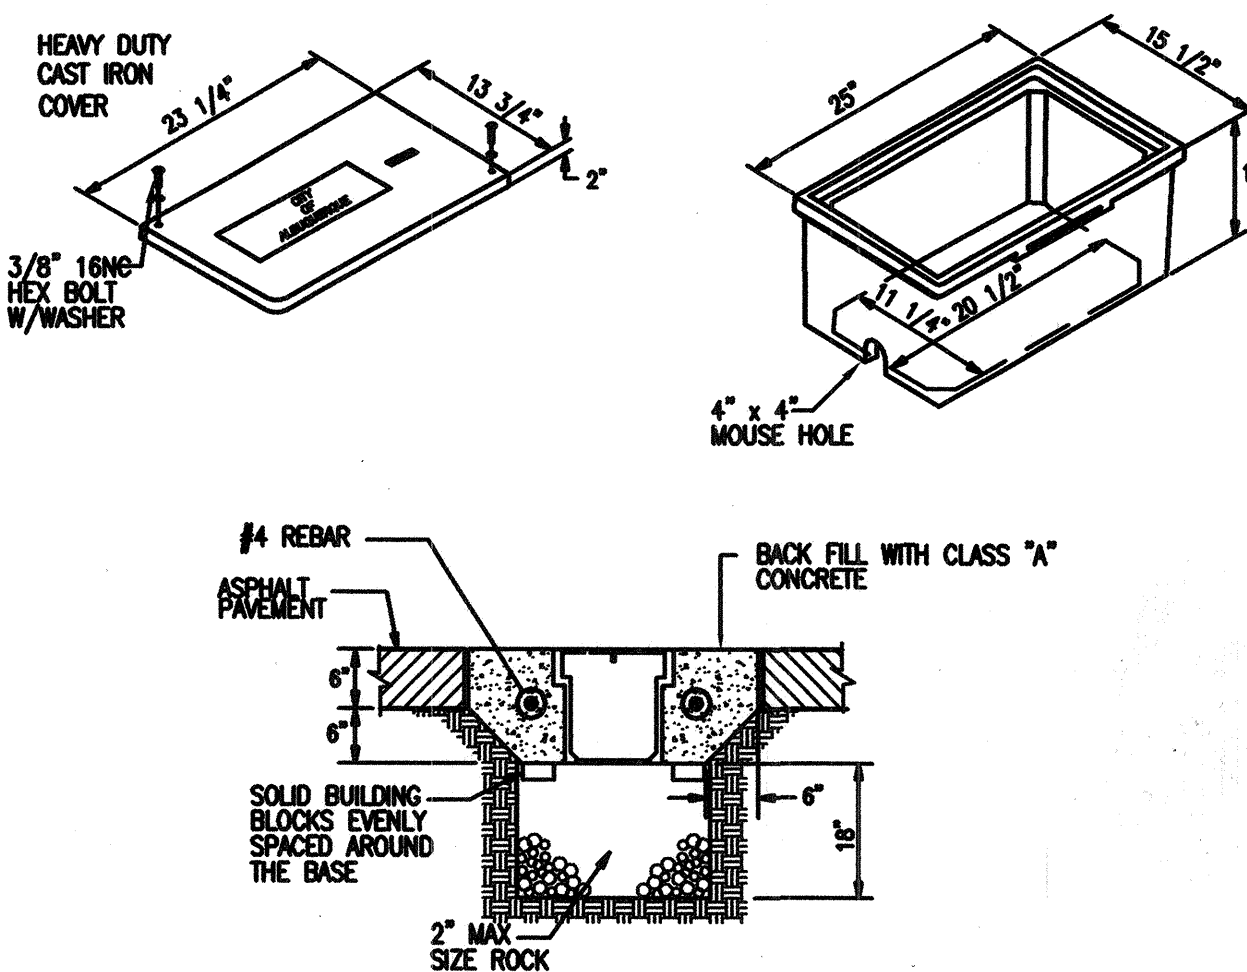

PULL BOX NOTES:

- MECHANICAL PROPERTIES: COMPRESSIVE STRENGTH - 11,000 PSI, TENSILE STRENGTH - 1,700 PSI, FLEXURAL STRENGTH - 7,500 PSI, FRP.
- SERVICE LOAD OF 22,568 LBS OVER 10" SQUARE (255 PSI).
- THE DIMENSIONS OF THE PULL BOXES SHOWN ARE NOMINAL DIMENSIONS AND MAY VARY AS TO THE MANUFACTURER'S RECOMMENDATIONS.
- PULL BOX TYPE AND LOGO TO BE APPROVED BY THE ENGINEER.

REVISIONS	CITY OF ALBUQUERQUE
	SEWER
	LIFT STATION - PULL BOX
	SUPPL. DWG. 2179
	JULY 2005

BERNALILLO COUNTY PUBLIC WORKS DIVISION TECHNICAL SERVICES			
TITLE: FOOTHILL BRIDGE INFILL AREA SEWER AND WATER IMPROVEMENTS LIFT STATION ELECTRICAL #2			
Design Review Committee	City Engineer Approval	Mo./Day/Yr.	Mo./Day/Yr.
City Project No. 747881	Zone Map No.	Sheet 25	Of 25
County Project No. TS01-20			