



LEGEND:	
	PROPERTY LINE
(i)	WATER METER
6	IRRIGATION METER
00	GREASE TRAP
<u> </u>	SINGLE CLEANOUT
T O	TWO-WAY CLEANOUT
XFRM	TRANSFORMER
	STORM INLET
	STORM MANHOLE
• 	LIGHT POLE
- A DOWE	PROPOSED TRAFFIC SIGN
DRIVE THRU	PAVEMENT STRIPING
(25)	PARKING STALL COUNT
—— F ——	FIRE LINE
——— WTR———	WATER LINE
SAN	SANITARY SEWER
—— G ——	GAS SERVICE
—— E ——	ELECTRIC SERVICE
— т —	TELEPHONE SERVICE
	STORM SEWER
	PROPOSED MAJOR CONTOU
5555	PROPOSED MINOR CONTOU
ST	EX STORM MANHOLE
S	EX SANITARY MANHOLE
	EX STORM INLET
\$	EX LIGHT POLE
UE	EX UNDERGROUND ELECTR
—— G ——	EX GAS SERVICE
W	EX WATER LINE
SD	EX STORM SEWER
SS	EX SANITARY SEWER
UT	EX TELEPHONE SERVICE
	EX GUARDRAIL
	EX FIRE HYDRANT
- 0 -	EX TRAFFIC SIGN
— <i>- 5555</i> — —	EX MAJOR CONTOUR
<i>5555</i>	EX MINOR CONTOUR
***	EX TREE
JR IR	EX IRRIGATION VALVE
	EX WATER VALVE
	EX TELEPHONE BOX
E	EX ELECTRIC BOX
	EX RECLAIMED WATER MAIN
	EX STORM SEWER

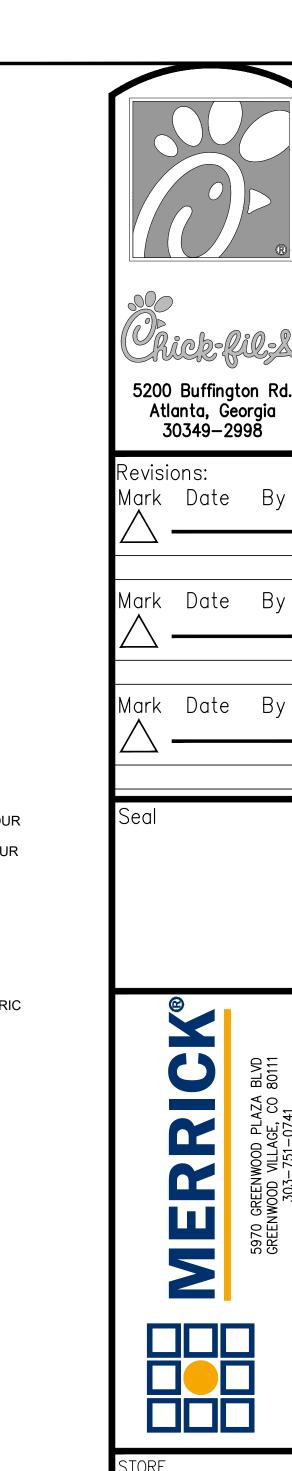

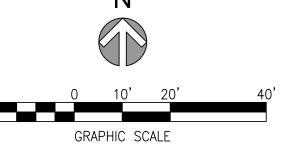

UTILITY PLAN

4001 COORS BLVD NW ALBUQUERQUE, NM

CHICK-FIL-A FSU #04107 COORS BLVD.

SHEET TITLE

DWG EDITION ---

Job No. : <u>65119594</u> Store : <u>04107</u> Date : <u>8/1/19</u>

Drawn By : <u>LV</u> Checked By:<u>KW</u>

Sheet

4