




Storm








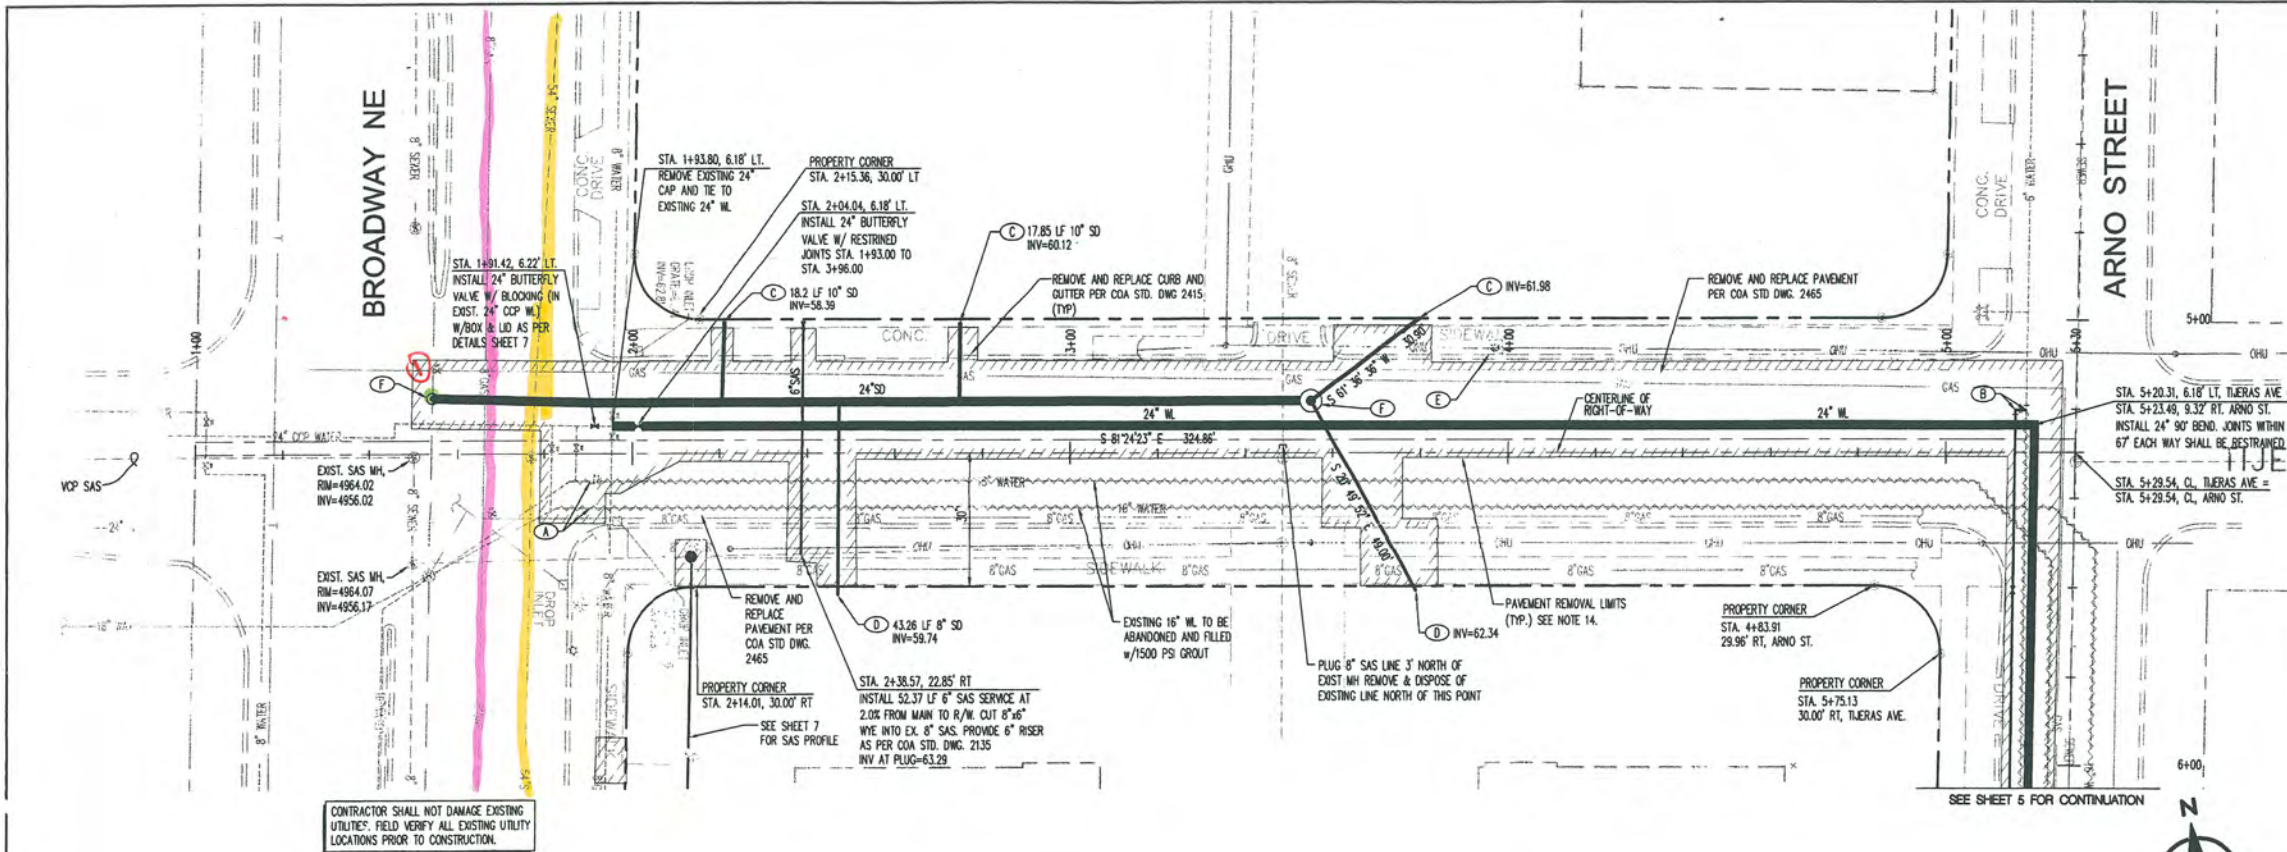



PROFILE	SURVEYED <u>L</u>	BY	DATE
NOTE BOOK	PLOTTED		
NO.	GADOLDS CHECKED		
	B. M.'S. NOTED		
	STRUCTURE NOTATIONS CH. NO.		

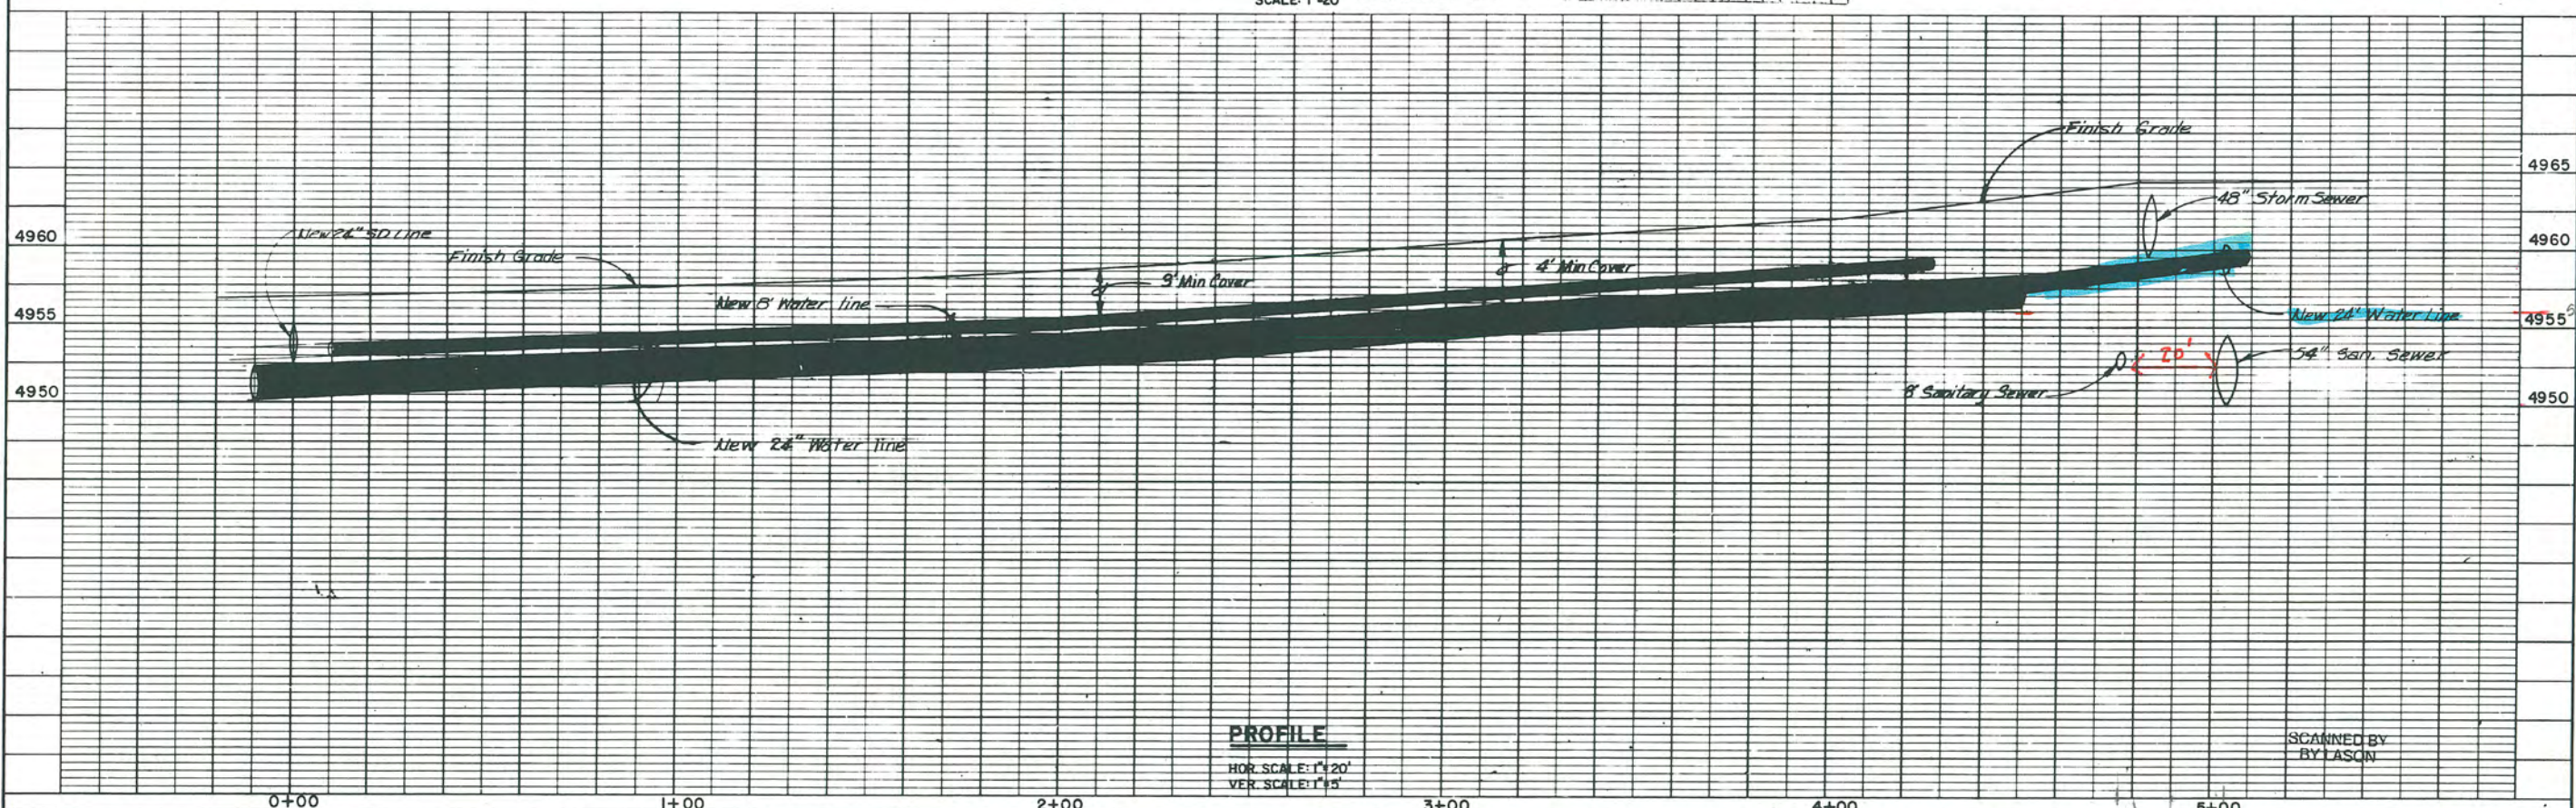

PLAN	DATE
REVISIONS	BY
NOTED	DATE
NOTE BOOK	ALIGNED CHECKED
NO.	PT. OF WAY CHECKED


KODOL & POLS ENGINEERING
1115 CORP. RD. ALBANY, N.Y. 12219

PROFILE	DATE
REVISIONS	BY
NOTED	DATE
NOTE BOOK	ALIGNED CHECKED
NO.	STRUCTURE NOTATION CH. 10

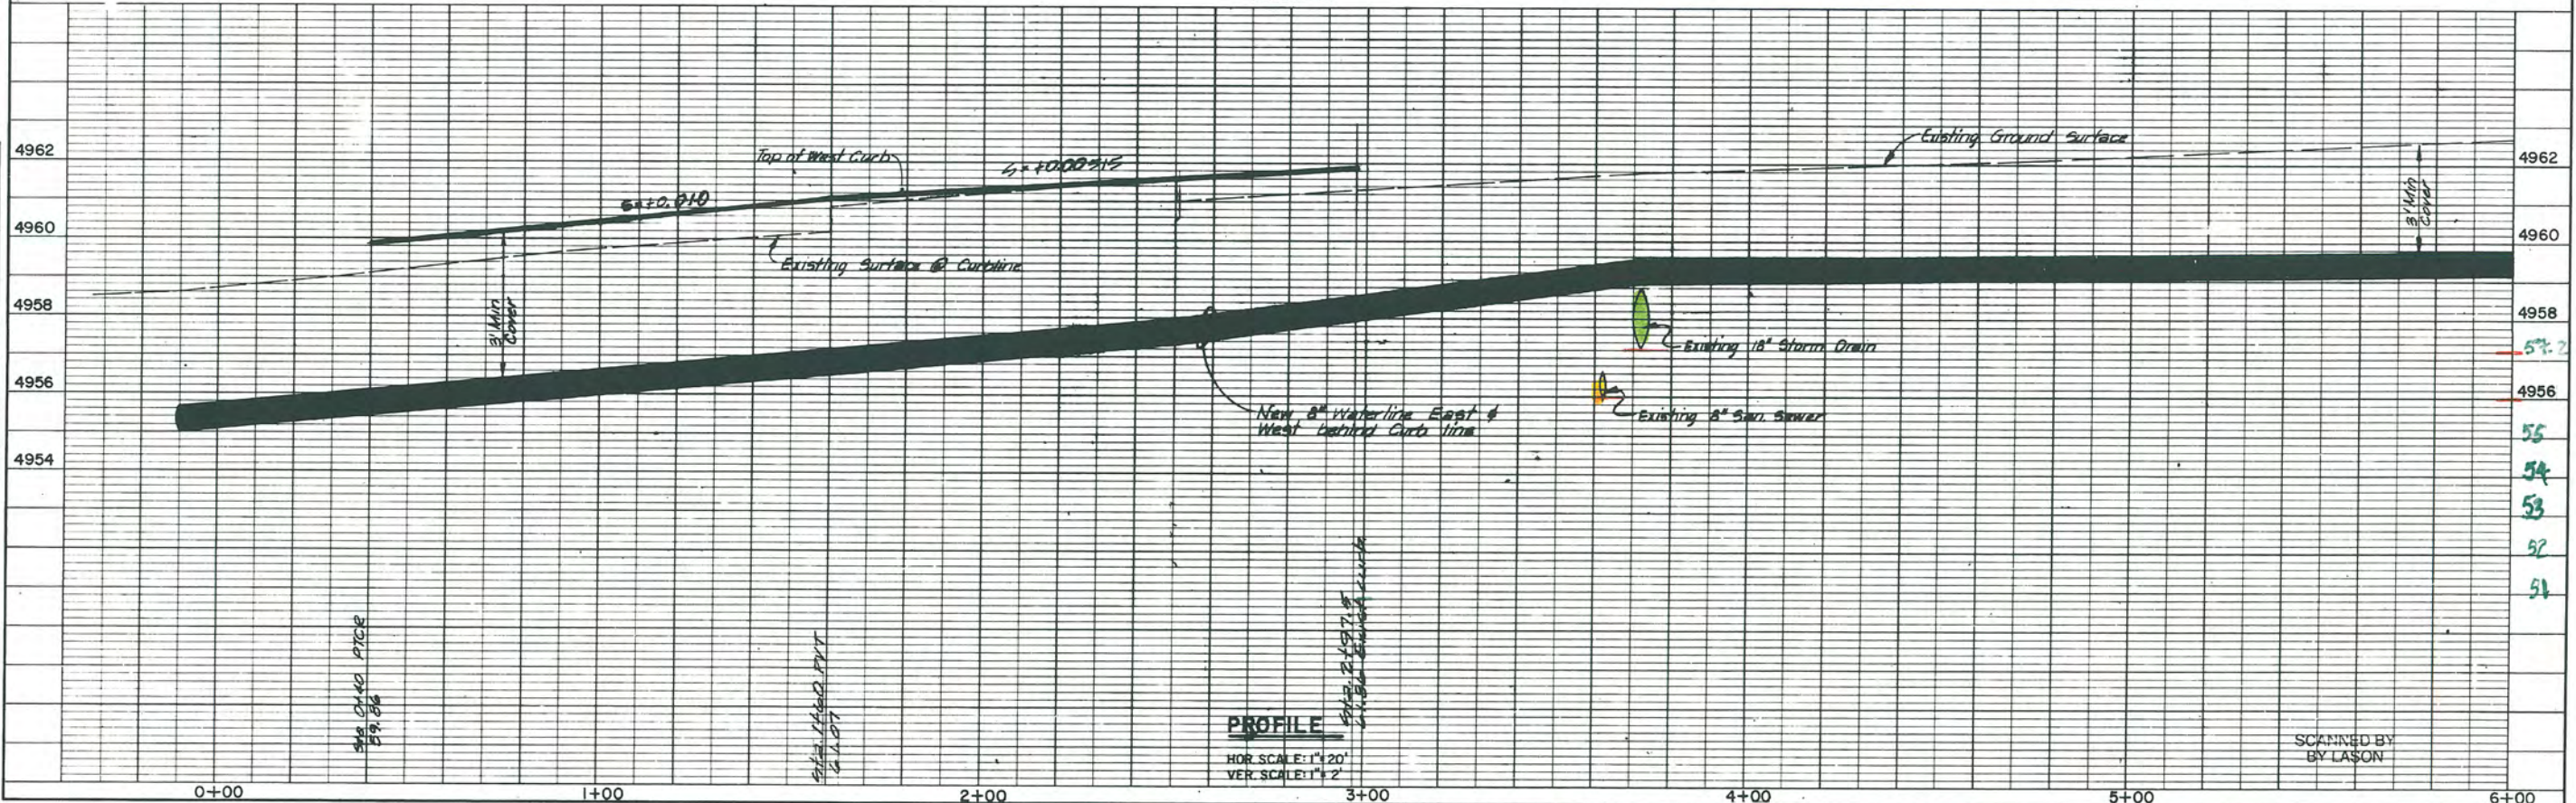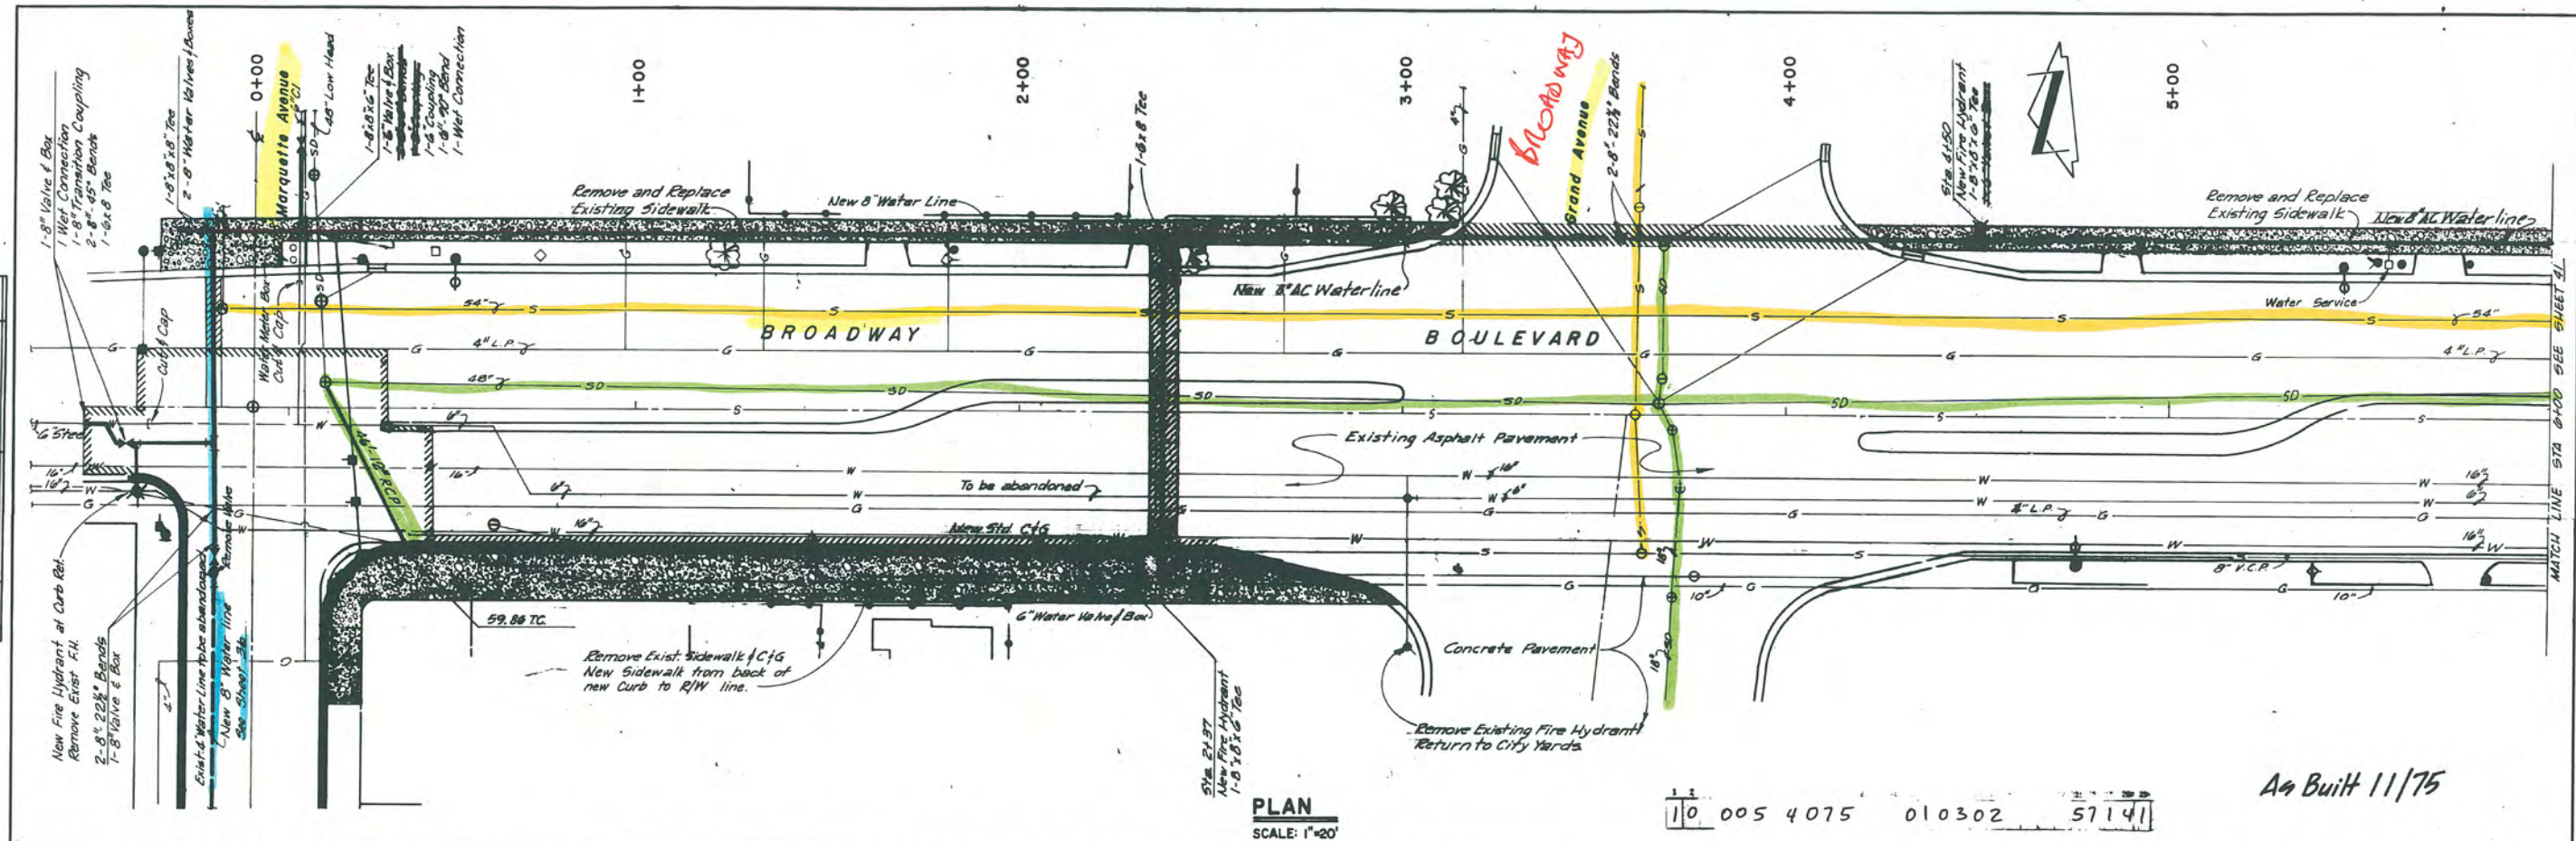

PLAN
NOTE BOOK
NO



PROFILE
NOTE BOOK
NO

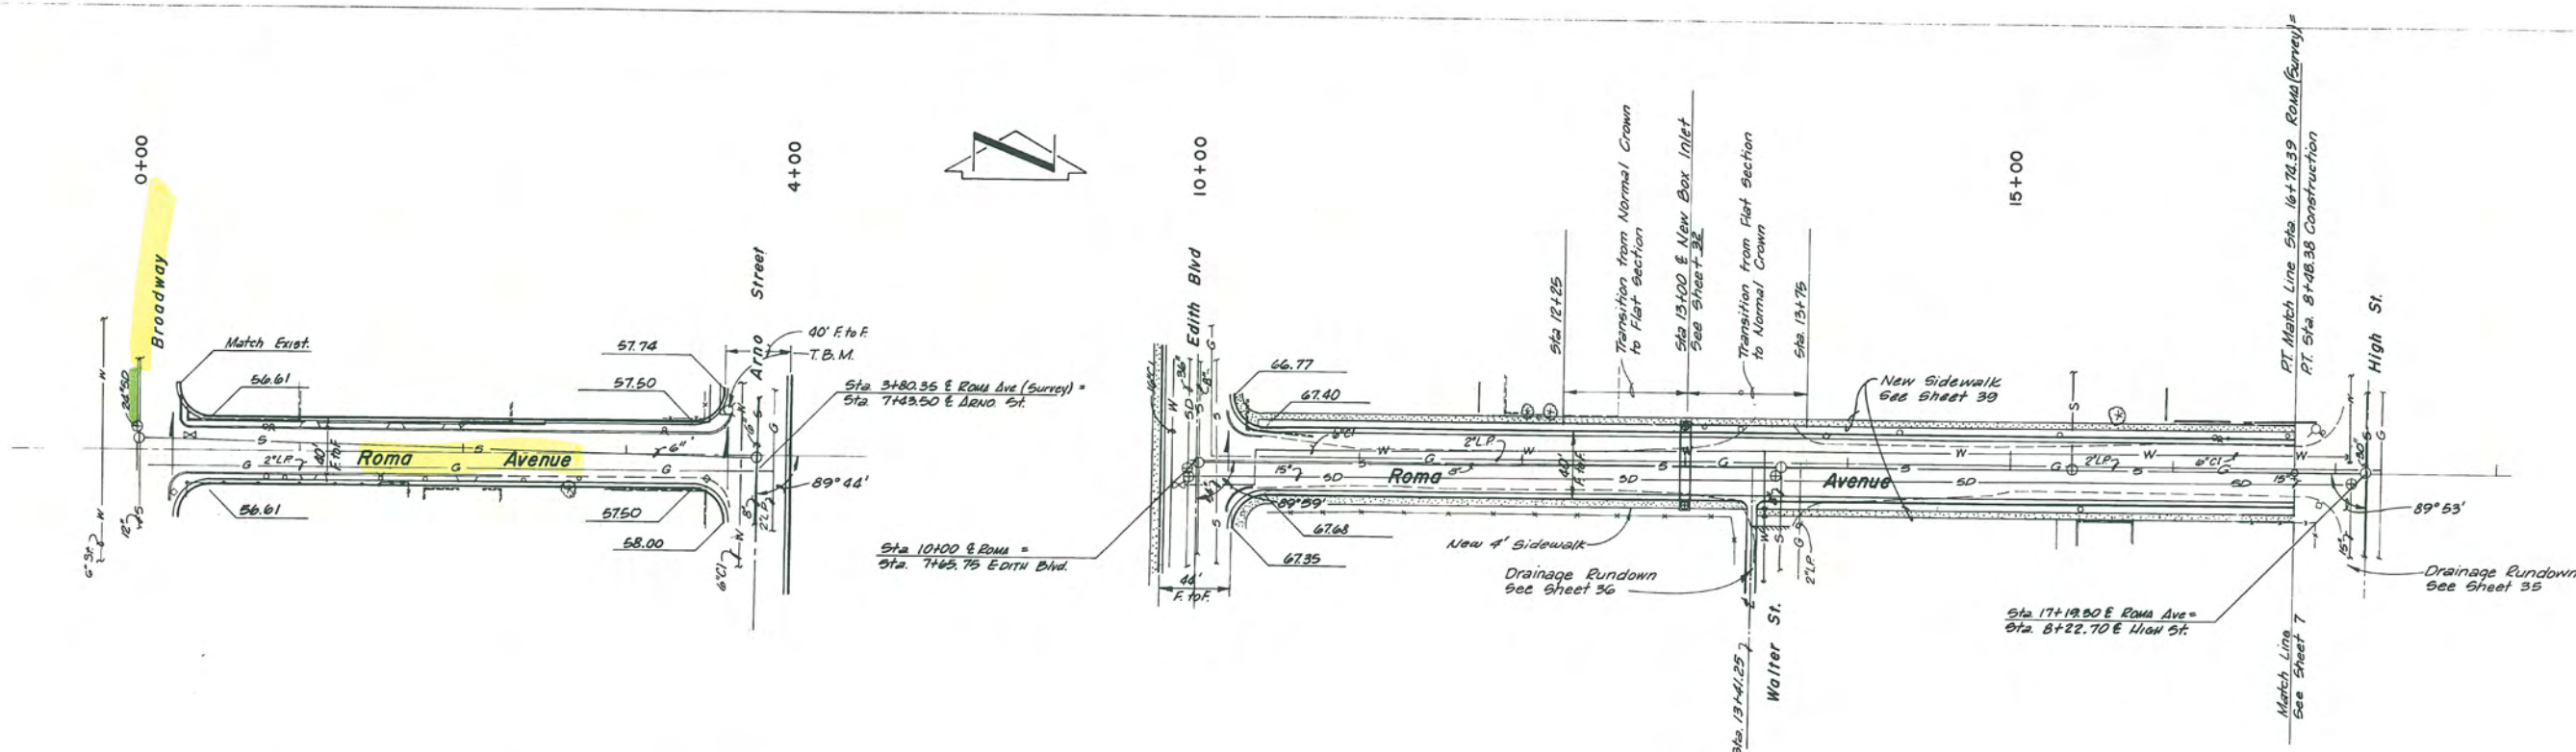

T.B.M.
Top of Fire Hydrant Bolt
Mark "x" on South Northwest
Corner Arno & Roma 89° 59.32

PLAN
SCALE: 1" = 50'



AS BUILT

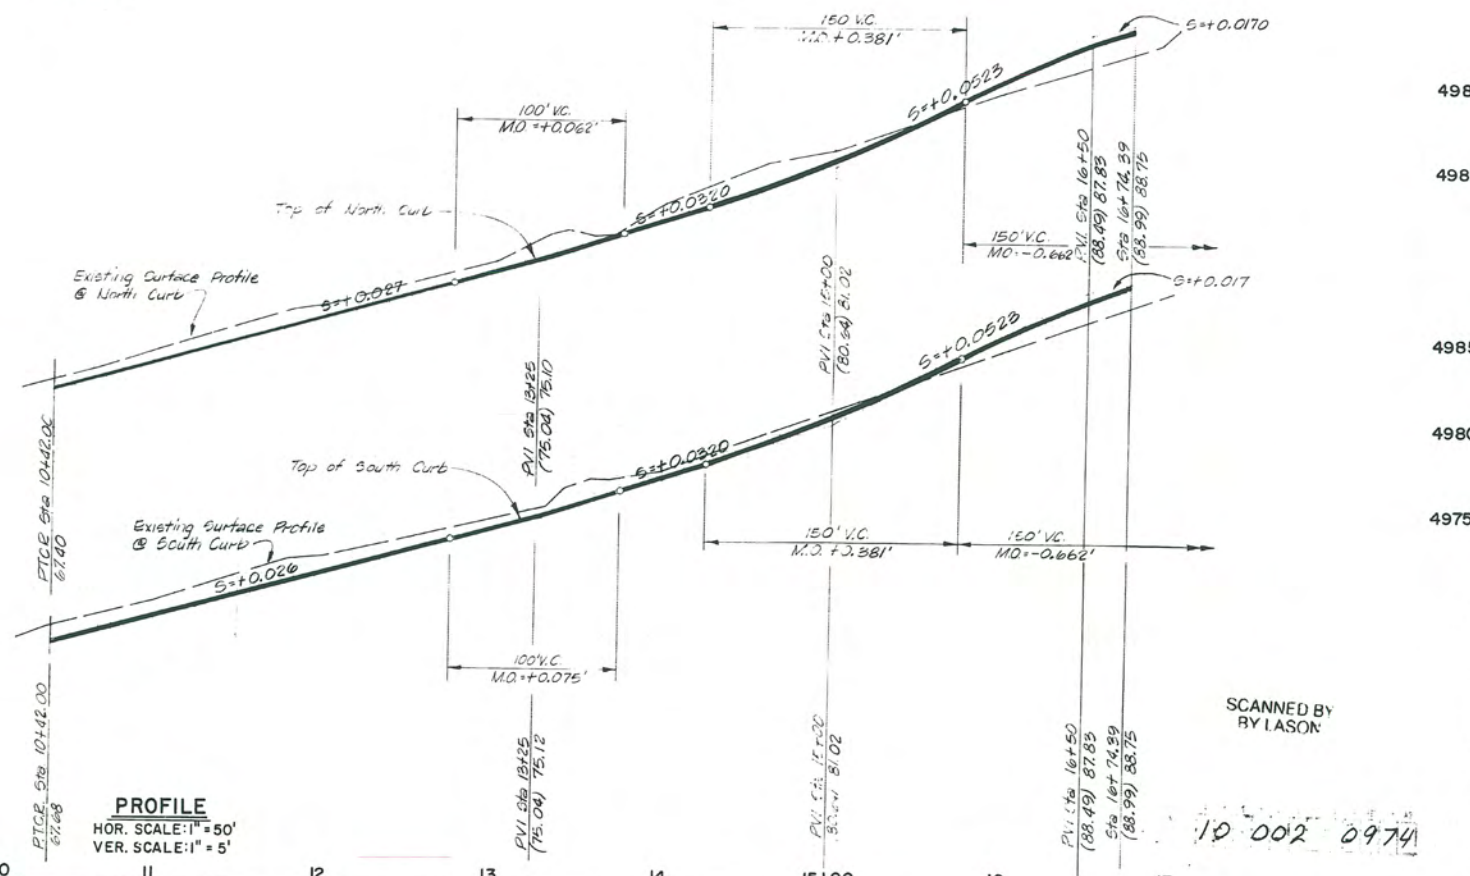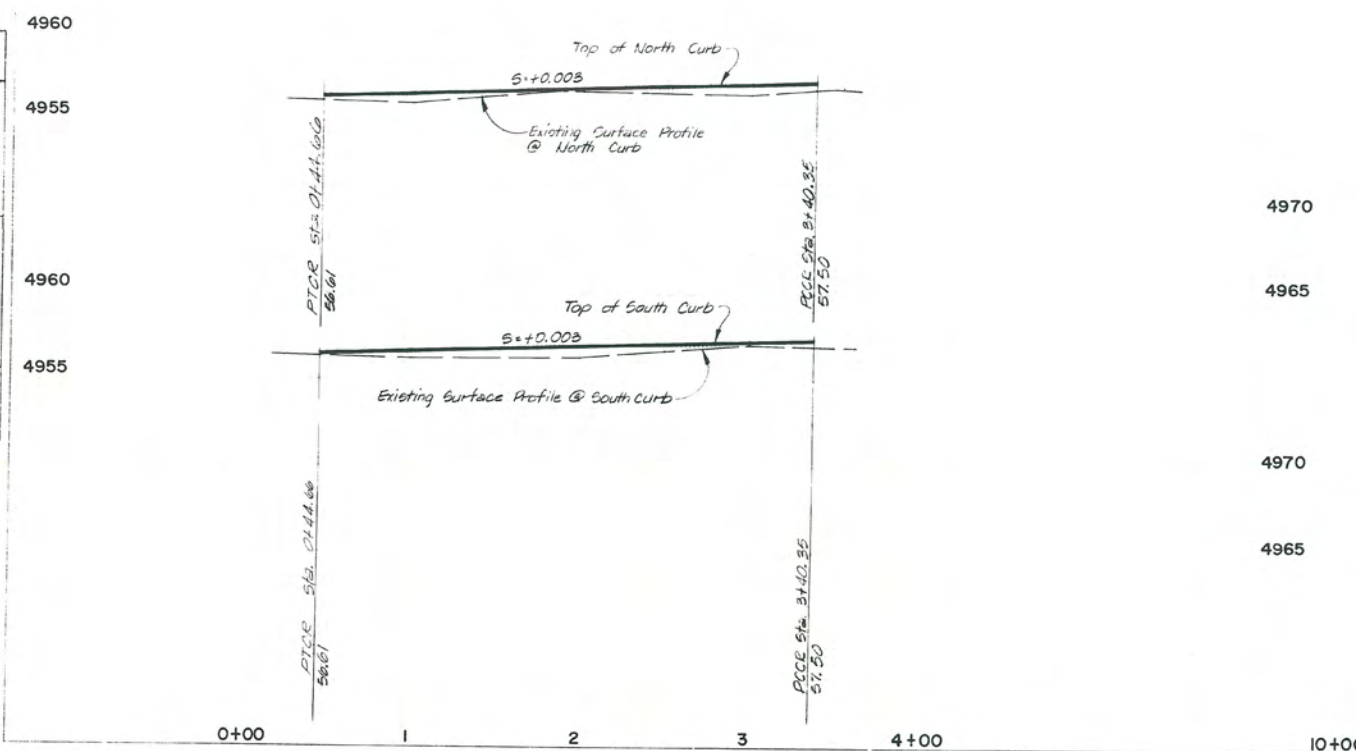

PROFILE
HOR. SCALE: 1" = 50'
VER. SCALE: 1" = 5'



SCANNED BY
BY LASON

10 002 0974

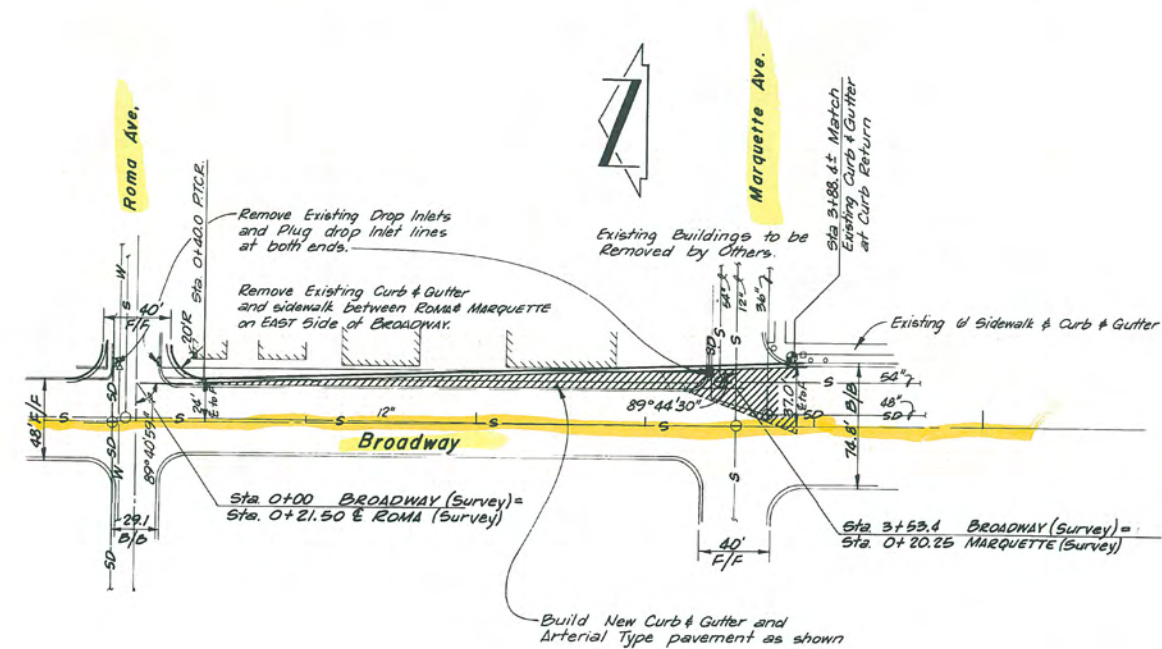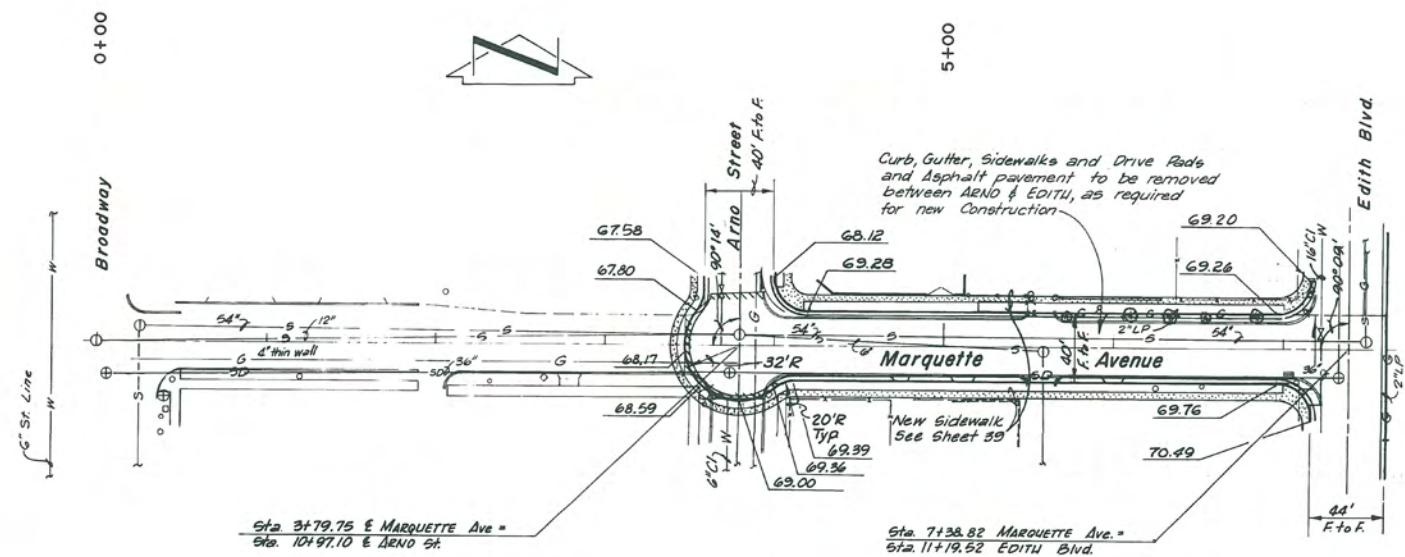

PLAN
SCALE: 1" = 50'


Brass Cap #7-K14
N.E. Corner of BROADWAY & MARQUETTE
Elev 4961.64

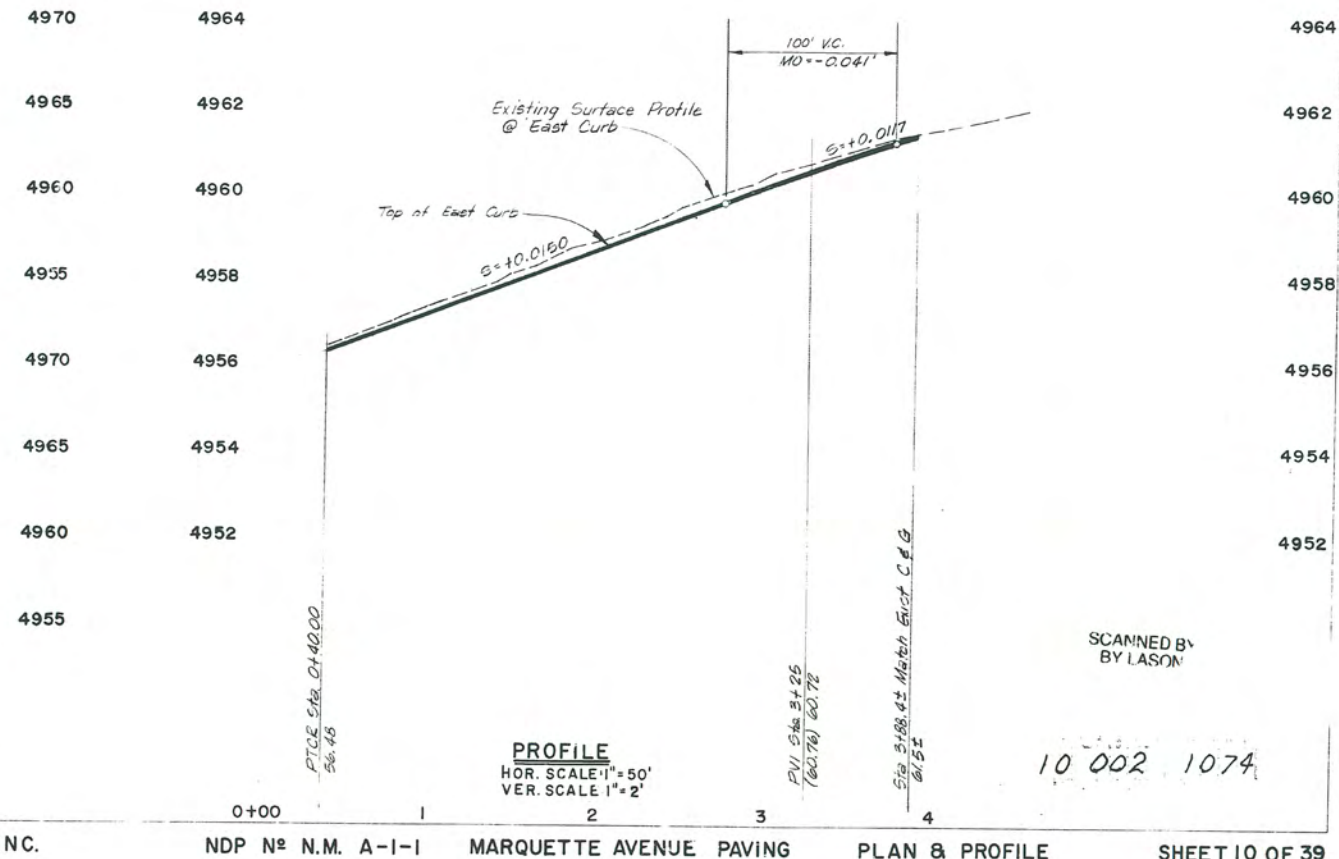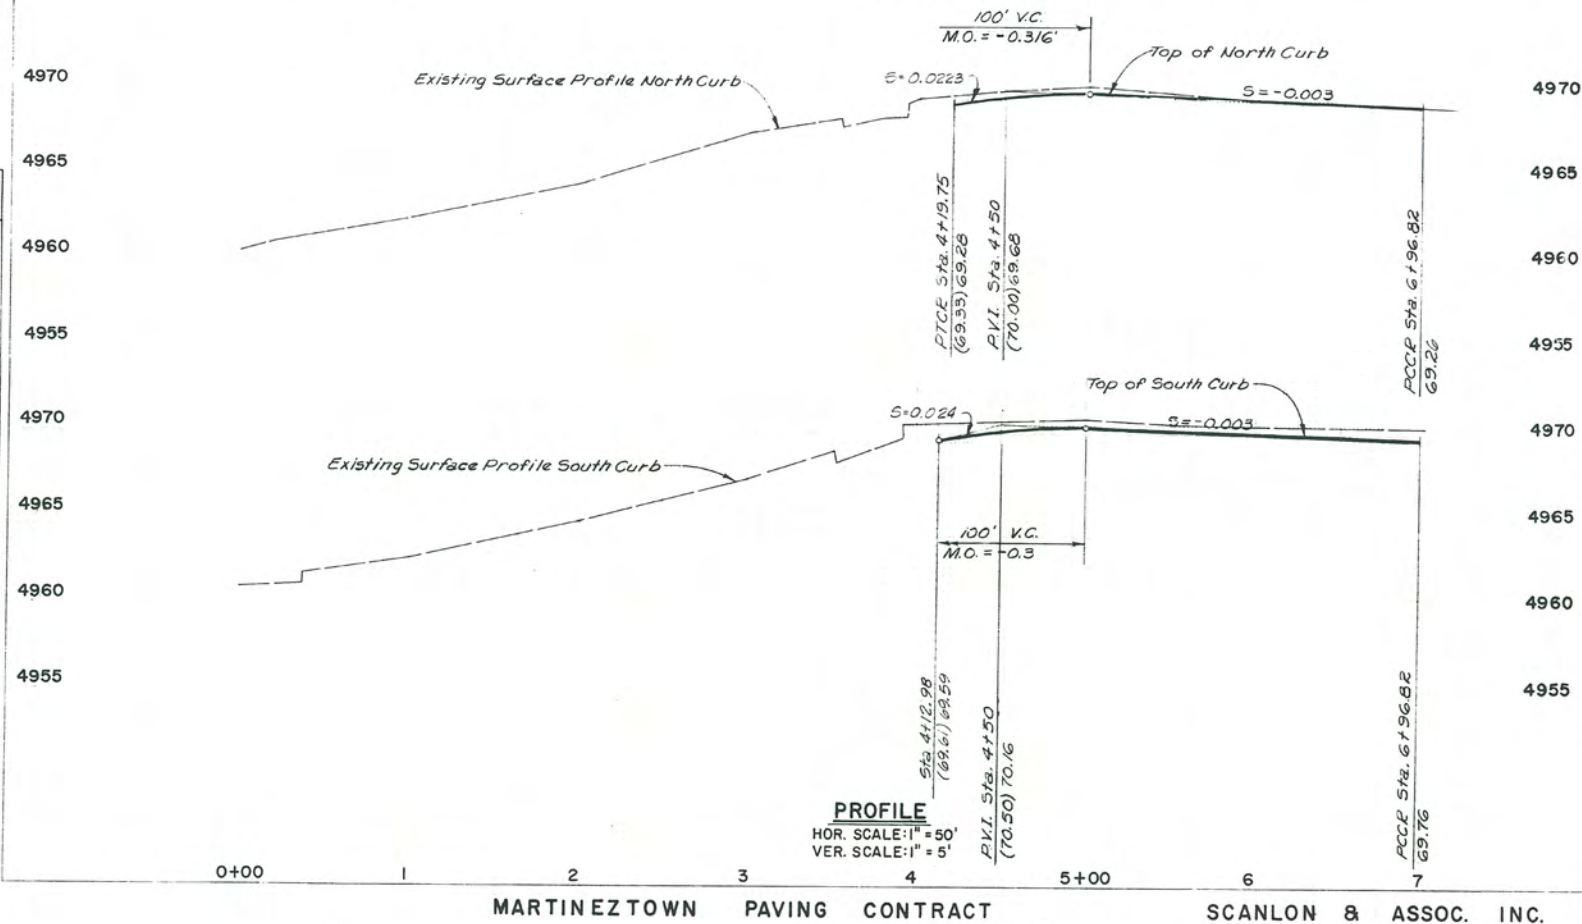

AS BUILT

SCANNED BY
BY LASON

10 002 1074

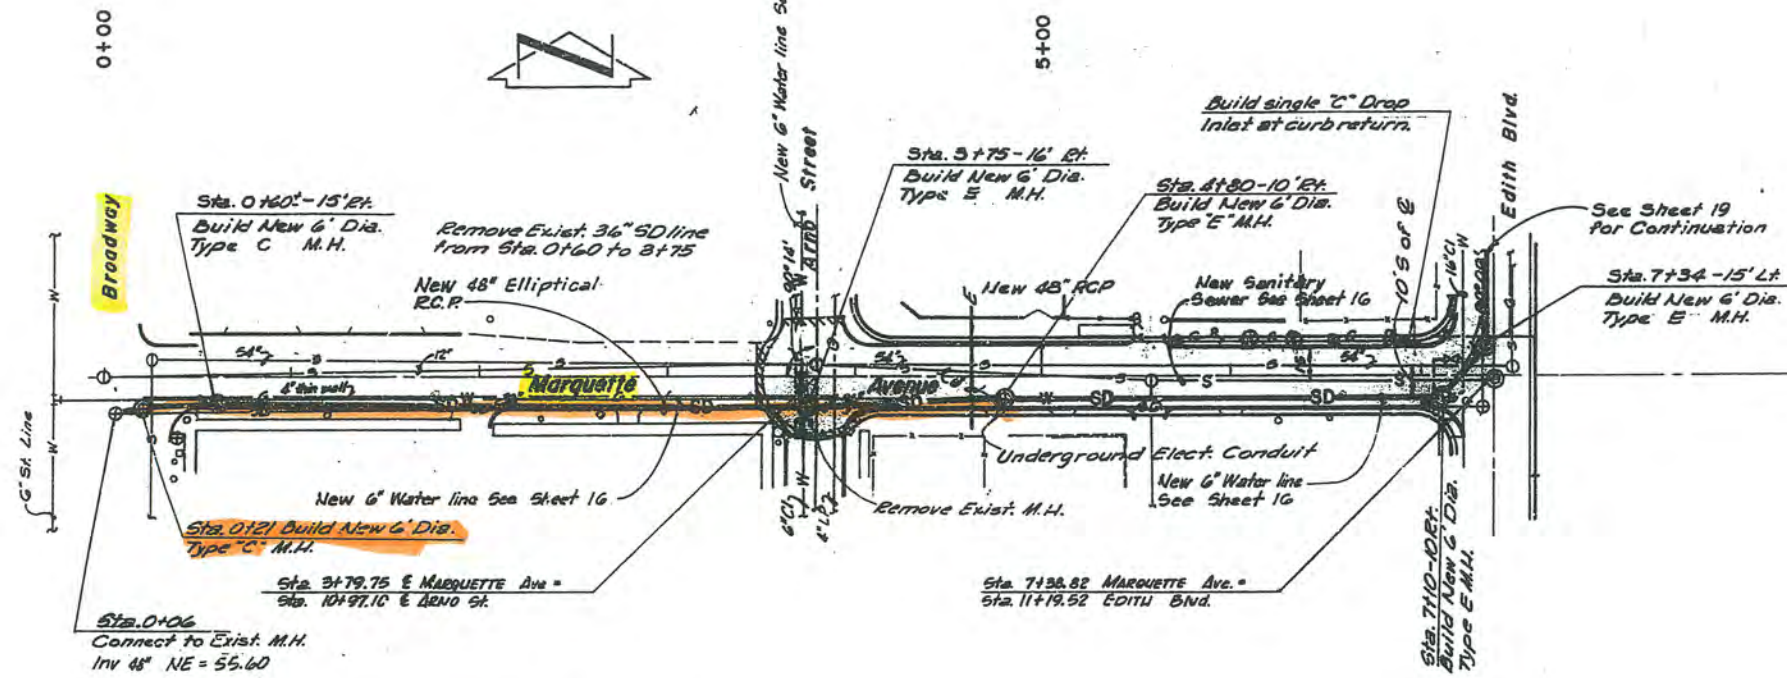


NOTE:
Due to the shallow Slope of the New
Storm Drain on MARQUETTE Ave. A
Laser shall be used to set the grade.

PLAN
SCALE 1" = 50'


10 002 2344
10 002 2344

AS BUILT

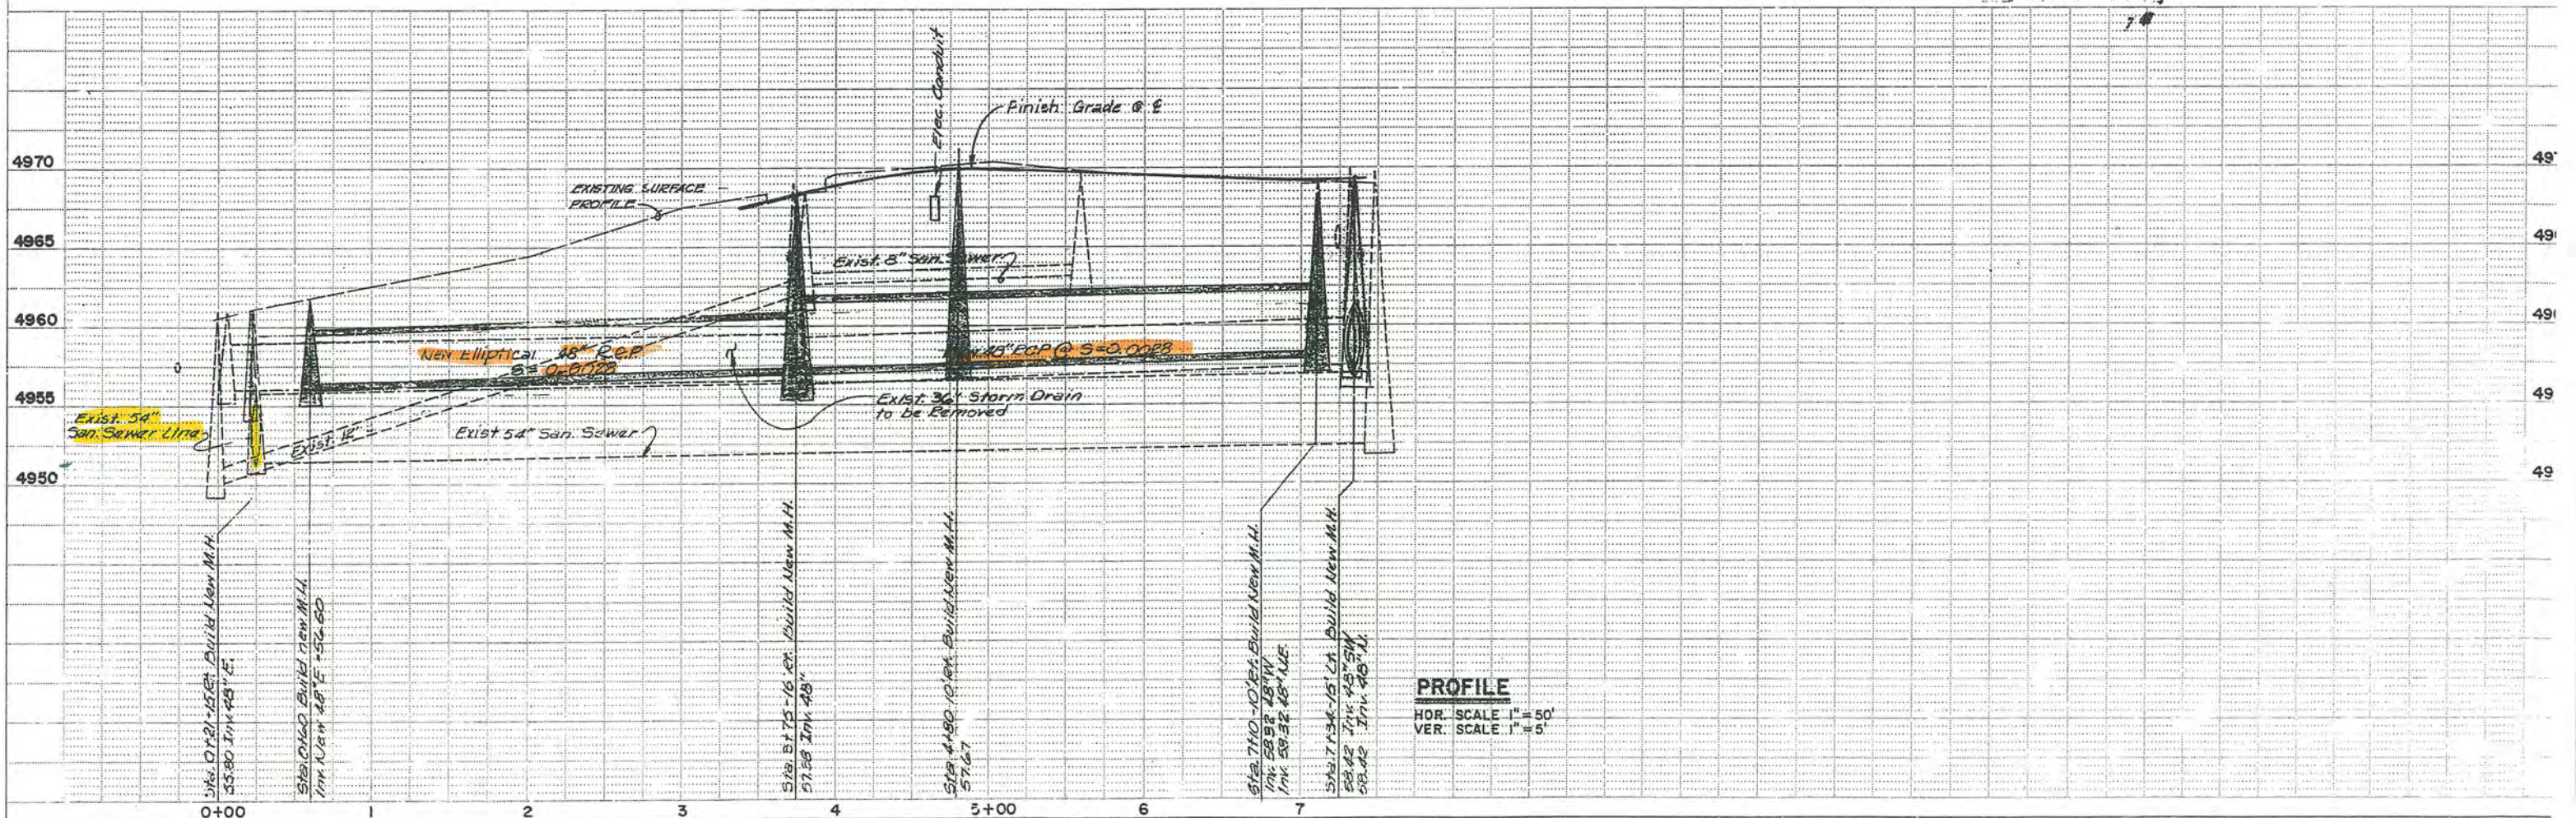

PROFILE
HOR. SCALE 1" = 50'
VER. SCALE 1" = 5'

BROADWAY AND MARQUETTE.

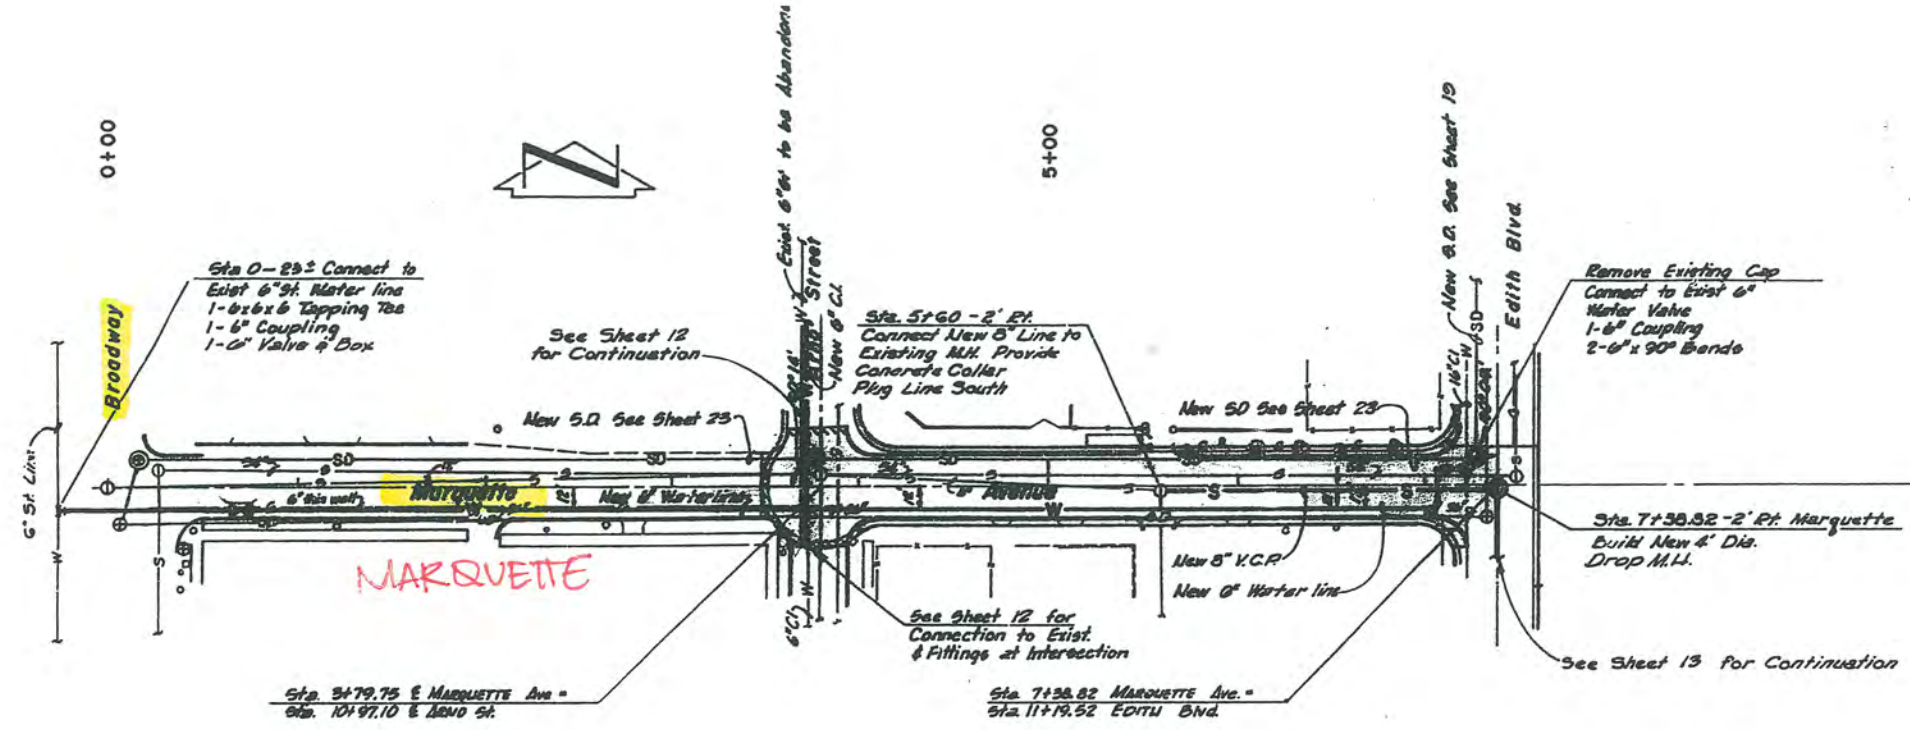


NOTE:
1. See Sheet 25 for Storm Drain Improvements This Area.



PLAN
SCALE: 1" = 50'

110 002 1674

AS BUILT

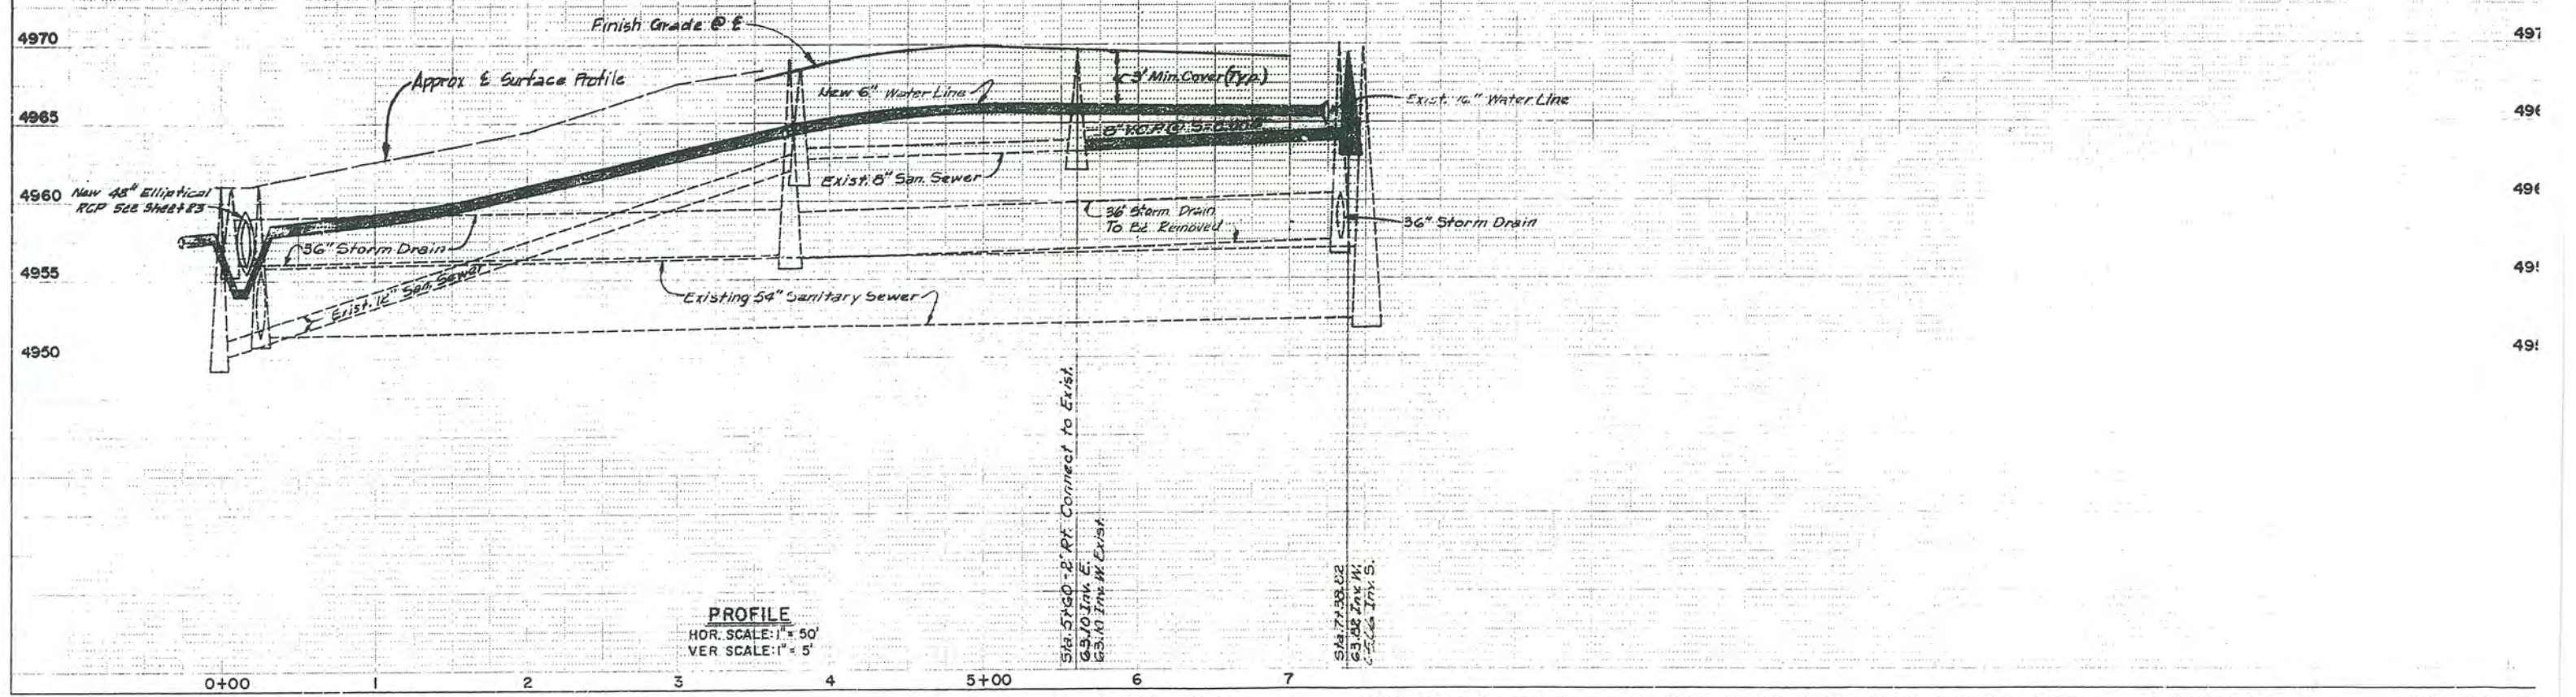

PROFILE
HOR. SCALE: 1" = 50'
VER. SCALE: 1" = 5'

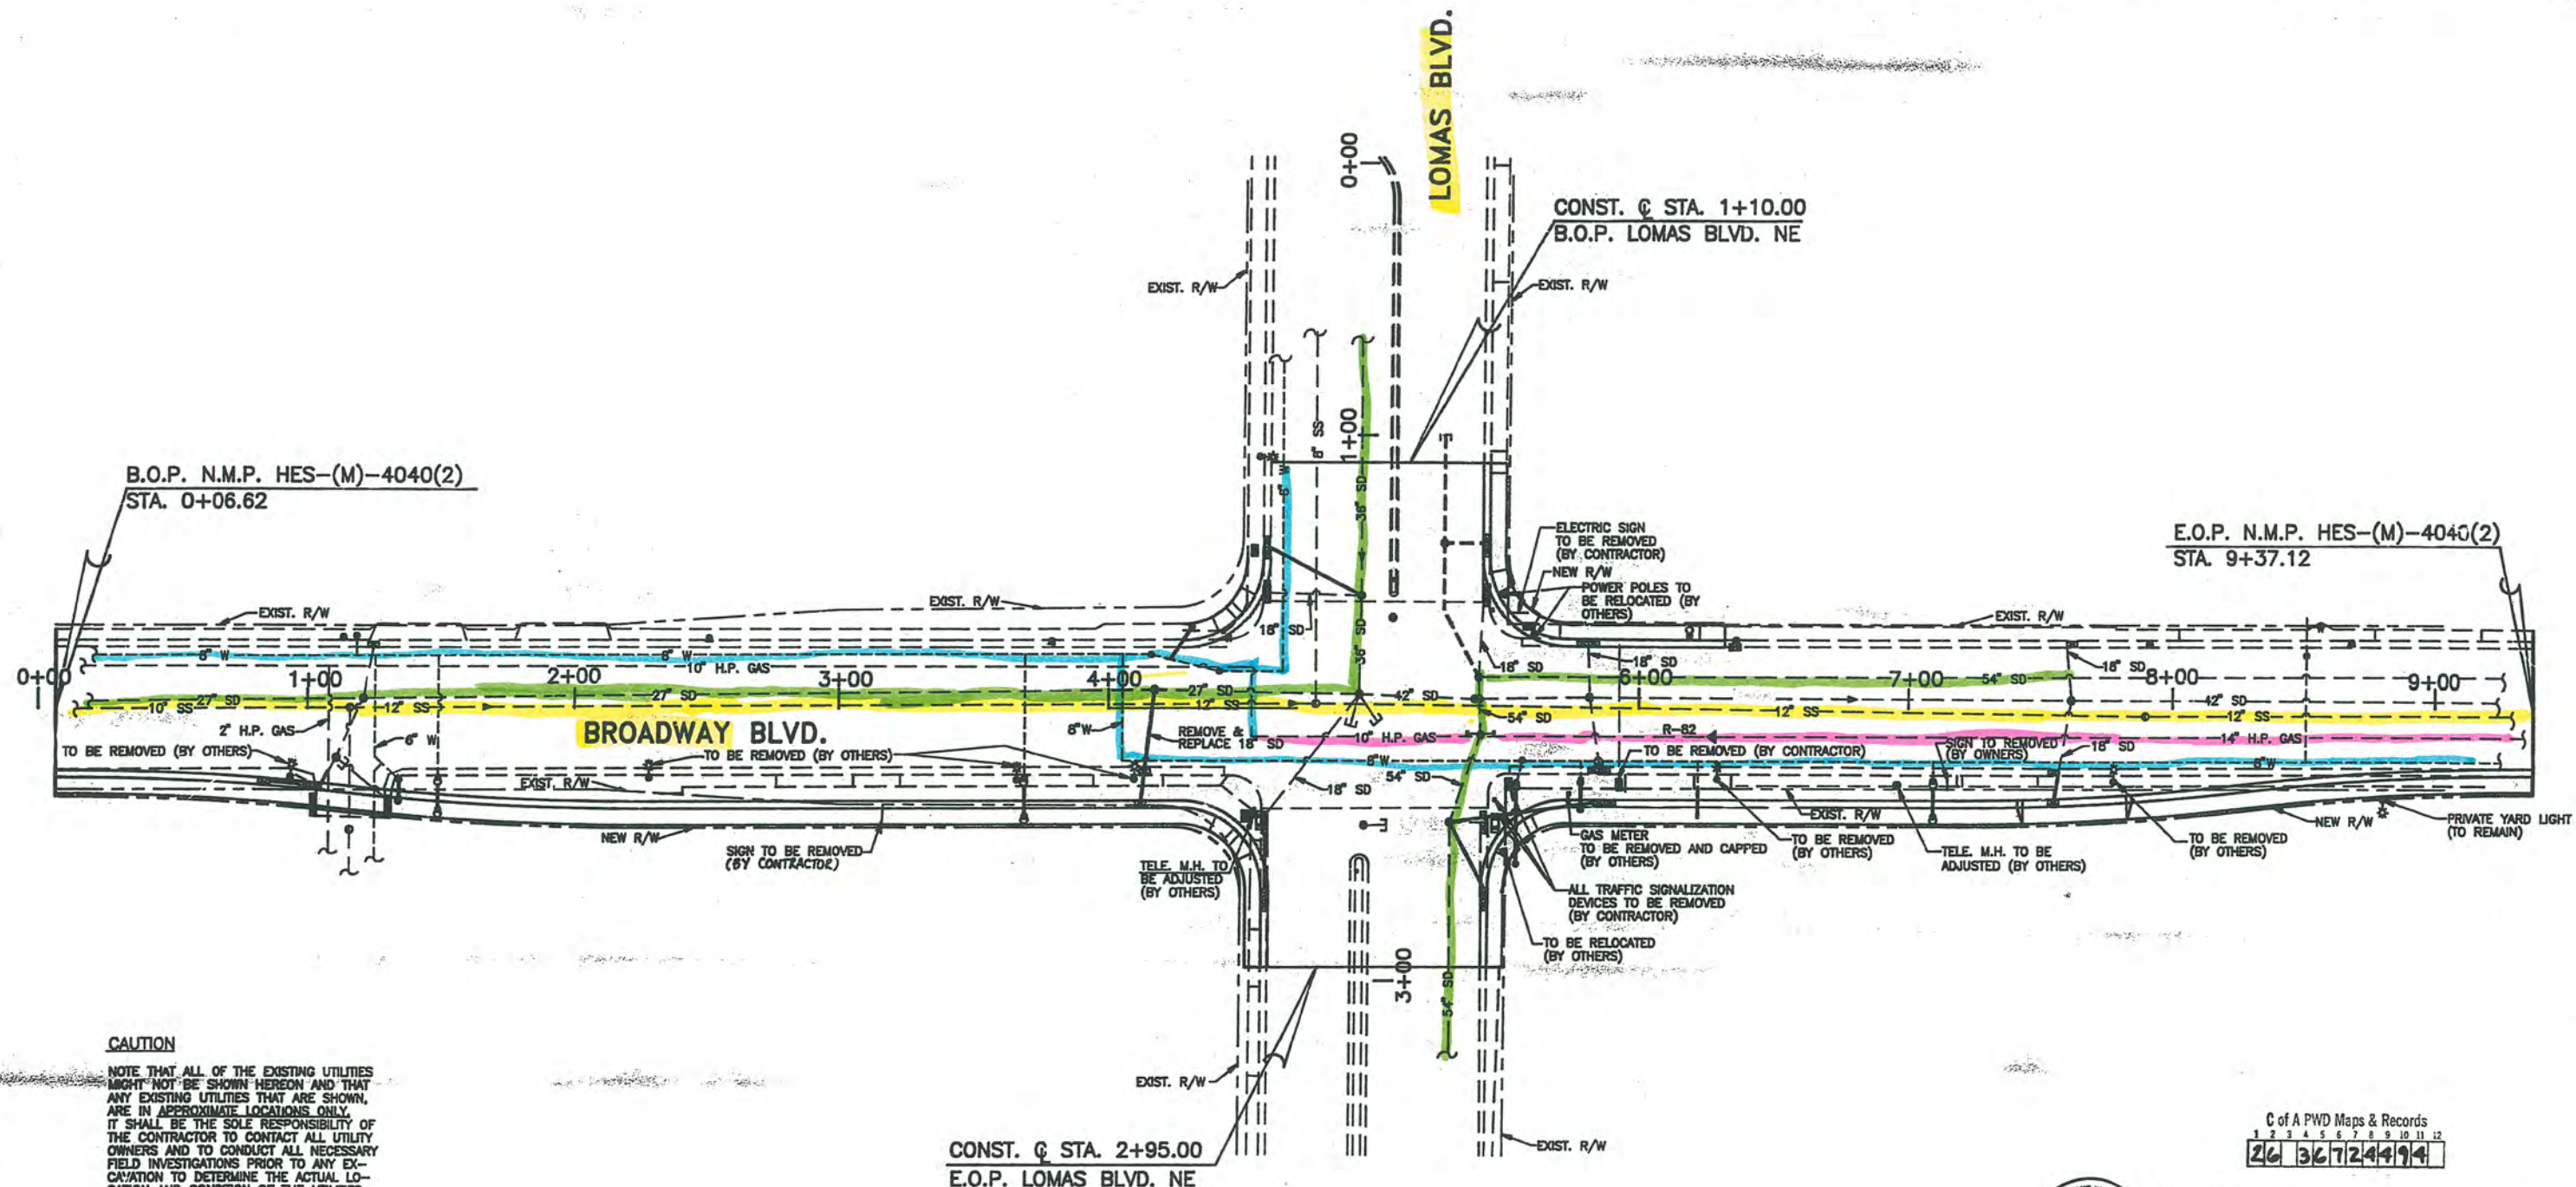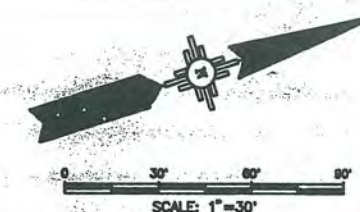

CAUTION

NOTE THAT ALL OF THE EXISTING UTILITIES MIGHT NOT BE SHOWN HEREON AND THAT ANY EXISTING UTILITIES THAT ARE SHOWN, ARE IN APPROXIMATE LOCATIONS ONLY. IT SHALL BE THE SOLE RESPONSIBILITY OF THE CONTRACTOR TO CONTACT ALL UTILITY OWNERS AND TO CONDUCT ALL NECESSARY FIELD INVESTIGATIONS PRIOR TO ANY EXCAVATION TO DETERMINE THE ACTUAL LOCATION AND CONDITION OF THE UTILITIES AND OTHER IMPROVEMENTS.

LEGEND

• LIGHT POLE	○ WATER METER
• POWER POLE	• WATER VALVE
• FIRE HYDRANT	• S.A.S. MANHOLE
• SIGNAL BASE	• STORM SEWER MANHOLE
• SIGNAL PULL BOX	• STORM SEWER DROP INLET
• SIGNAL CONTROL BOX	• TELEPHONE MANHOLE
• GAS METER	• ELECTRIC PULL BOX

UTILITY OWNERS

WATER/SEWER	CITY OF ALBUQUERQUE	(505)857-8200
ELECTRICITY	PUBLIC SERVICE OF NM	(505)748-4947
GAS	GAS CO. OF NM	(505)889-2538
CABLE	JONES INTERCABLE	(505)781-6200
TELEPHONE	AT&T	(505)842-2855
	U.S. WEST	(505)245-6736

NOTES:

- SEE SHEET 4-1 FOR WATER SHUT-OFF PLAN.
- SEE SHEET 7-1 FOR LIGHTING PLAN.
- SEE SHEET 8-2 FOR TRAFFIC SIGNALIZATION.
- SEE SHEET 9-1 THRU 9-3 FOR STRUCTURE PLACEMENTS.
- A.T. & T. HAS NO COMMUNICATION CABLES IN THE INTERSECTION.
- JONE'S INTERCABLE HAS NO CABLES IN THE INTERSECTION.

APPROVALS	ENGINEER	DATE
DRC CHAIRMAN	<i>Roger A. Dean</i>	3-13-92
TRANSPORTATION	<i>R. J. Jansky</i>	8-26-91
HYDROLOGY	<i>Steve Boley</i>	8/23/91
WATER	<i>W. D. Dean</i>	8-30-91
WASTE WATER	<i>W. D. Dean</i>	"

C of A PWD Maps & Records

26 36724494

3			
2			
1			
NO.	DESCRIPTION	DATE	BY


REVISIONS (OR NOTICES)

NEW MEXICO
STATE HIGHWAY DEPARTMENT

EXISTING UTILITIES

GMA, INC.
5700 HARPER DR. NE., STE. 240

BROADWAY & LEWIS

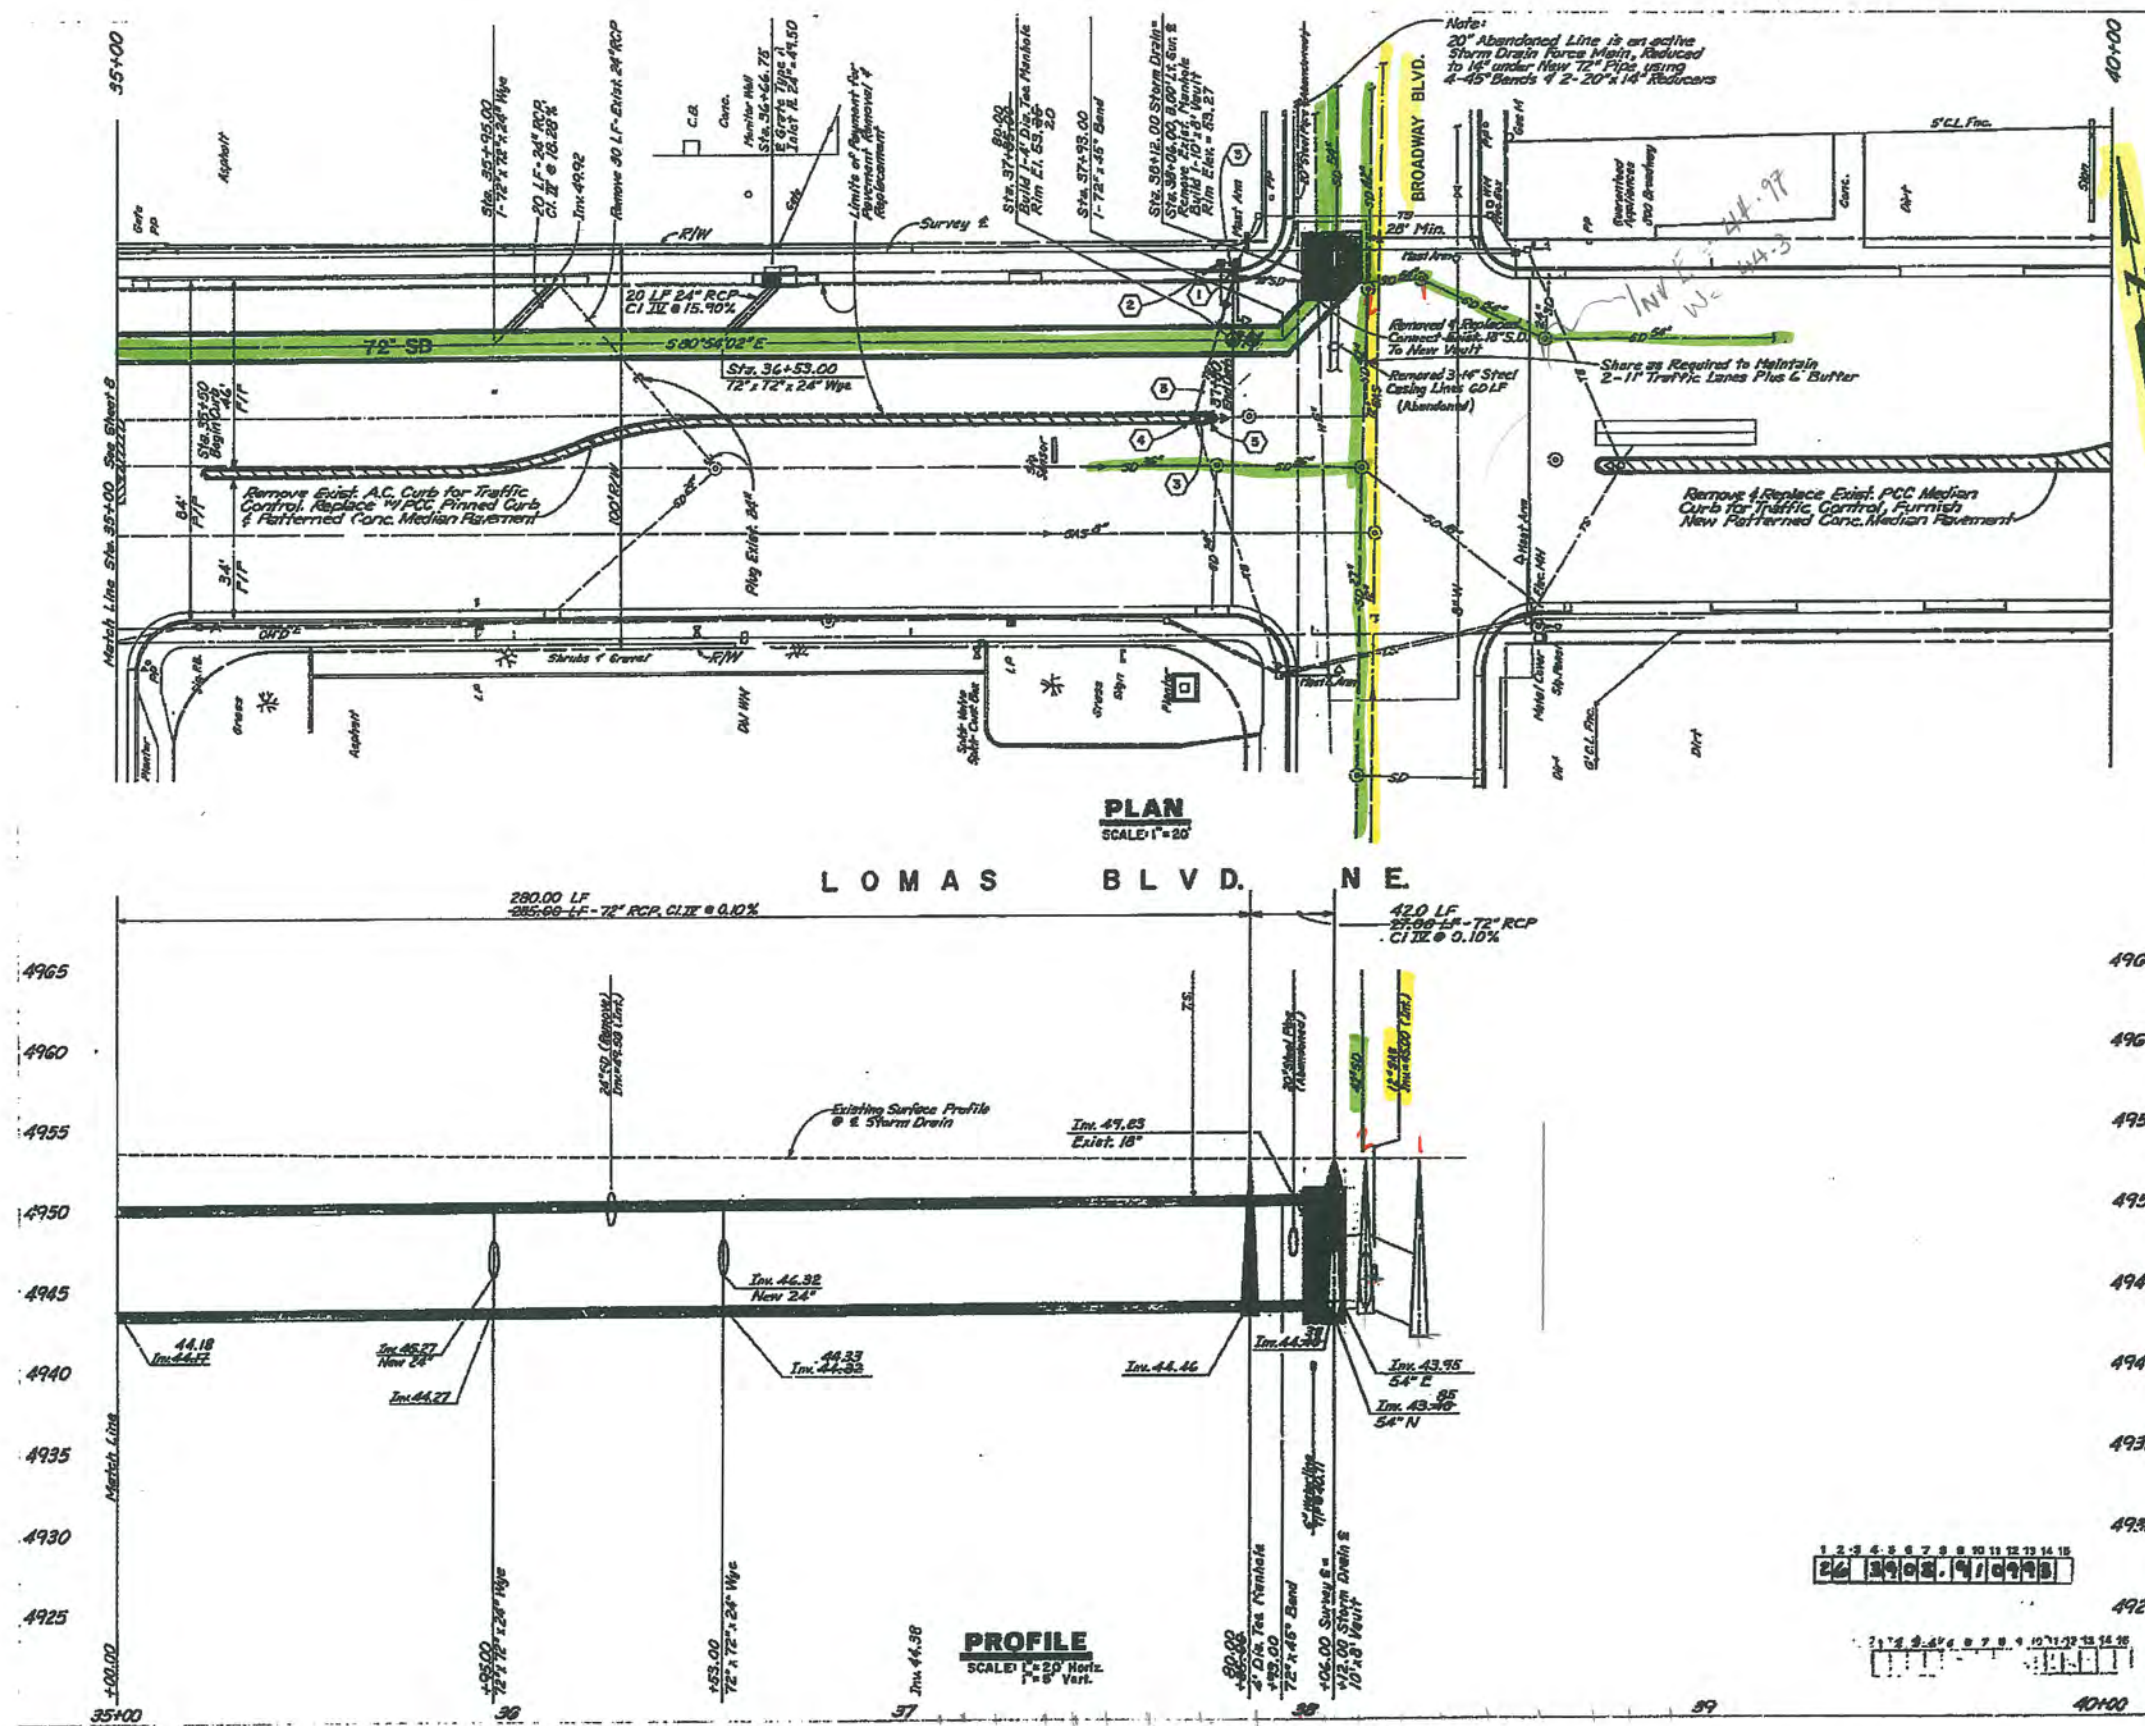

- ### KEYED NOTES
- (1) REPLACE EXISTING MA FOUNDATION WITH FULL BOX.
 - (2) INSTALL NEW MA FOUNDATION, TYPE II.
 - (3) REPLACE EXISTING CONDUIT WITH NEW 1" PVC. INSTALL 1 - 20MCB, 1 - SHOC, 1 - FIDING TERM WHICE, 1 - JASING BARE COPPER GROUND.
 - (4) REPLACE EXISTING SP FOUNDATION WITH FULL BOX.
 - (5) INSTALL NEW SP FOUNDATION, TYPE II.

AS BUILT INFORMATION
NEW CONCEPTS
NEW CONCEPTS 11-91
I. FRANCO 1-92
NEW CONCEPTS 7-92
A.A. #2 11-9-92
MICRO-FILM INFORMATION

AKA: MARYS
AGE SEX, 2-YEAR
STANDARD CITY OF ALBUQUERQUE DEER SET IN PIER-
WALK LOCATED AT THE NORTHWEST CORNER OF IOWAS
BOULEVARD, N.W., AND 4TH STREET, N.W.

INFORMATION	DATE
FIELD NOTES	
BY	

SURVEY	NO
--------	----


DATE	BY	REMARKS
1749-81		Revised Addendum No. 1
		REVISIONS
		DESIGN
		DATE MAY 1991
		DRAWN BY T6, JCS
		CHECKED BY T6, JCS

John D. Andrews
RECORD DRAWING
RECORD DRAWING PREPARED
FROM INFORMATION FURNISHED BY
THE CITY OF ALBUQUERQUE.

CITY OF ALBUQUERQUE PUBLIC WORKS DEPARTMENT ENGINEERING GROUP			
LOMAS BOULEVARD STORM DRAIN - PHASE II PLAN & PROFILE-STA. 35+00 TO STA. 40+00			
DATE: 12-1-79	SHEET NO. 1		
DESIGNER: [Signature]	DATE: 9-2-79	WATER	35+00
TRANSPORTATION: [Signature]	DATE: 9-2-79	WASTE WATER	N/A
HYDROLOGY: [Signature]	DATE: 9-2-79	COMBINATION	N/A
INVESTING: [Signature]	MAP NO. 3903.91	J-14, J-15	9 45


BROADWAY & LOMAS

PLAN	CHECKED	DATE
NOTE BOOK	ALIGNED CHECKED	
NO. 1	RT. OF WAY CHECKED	

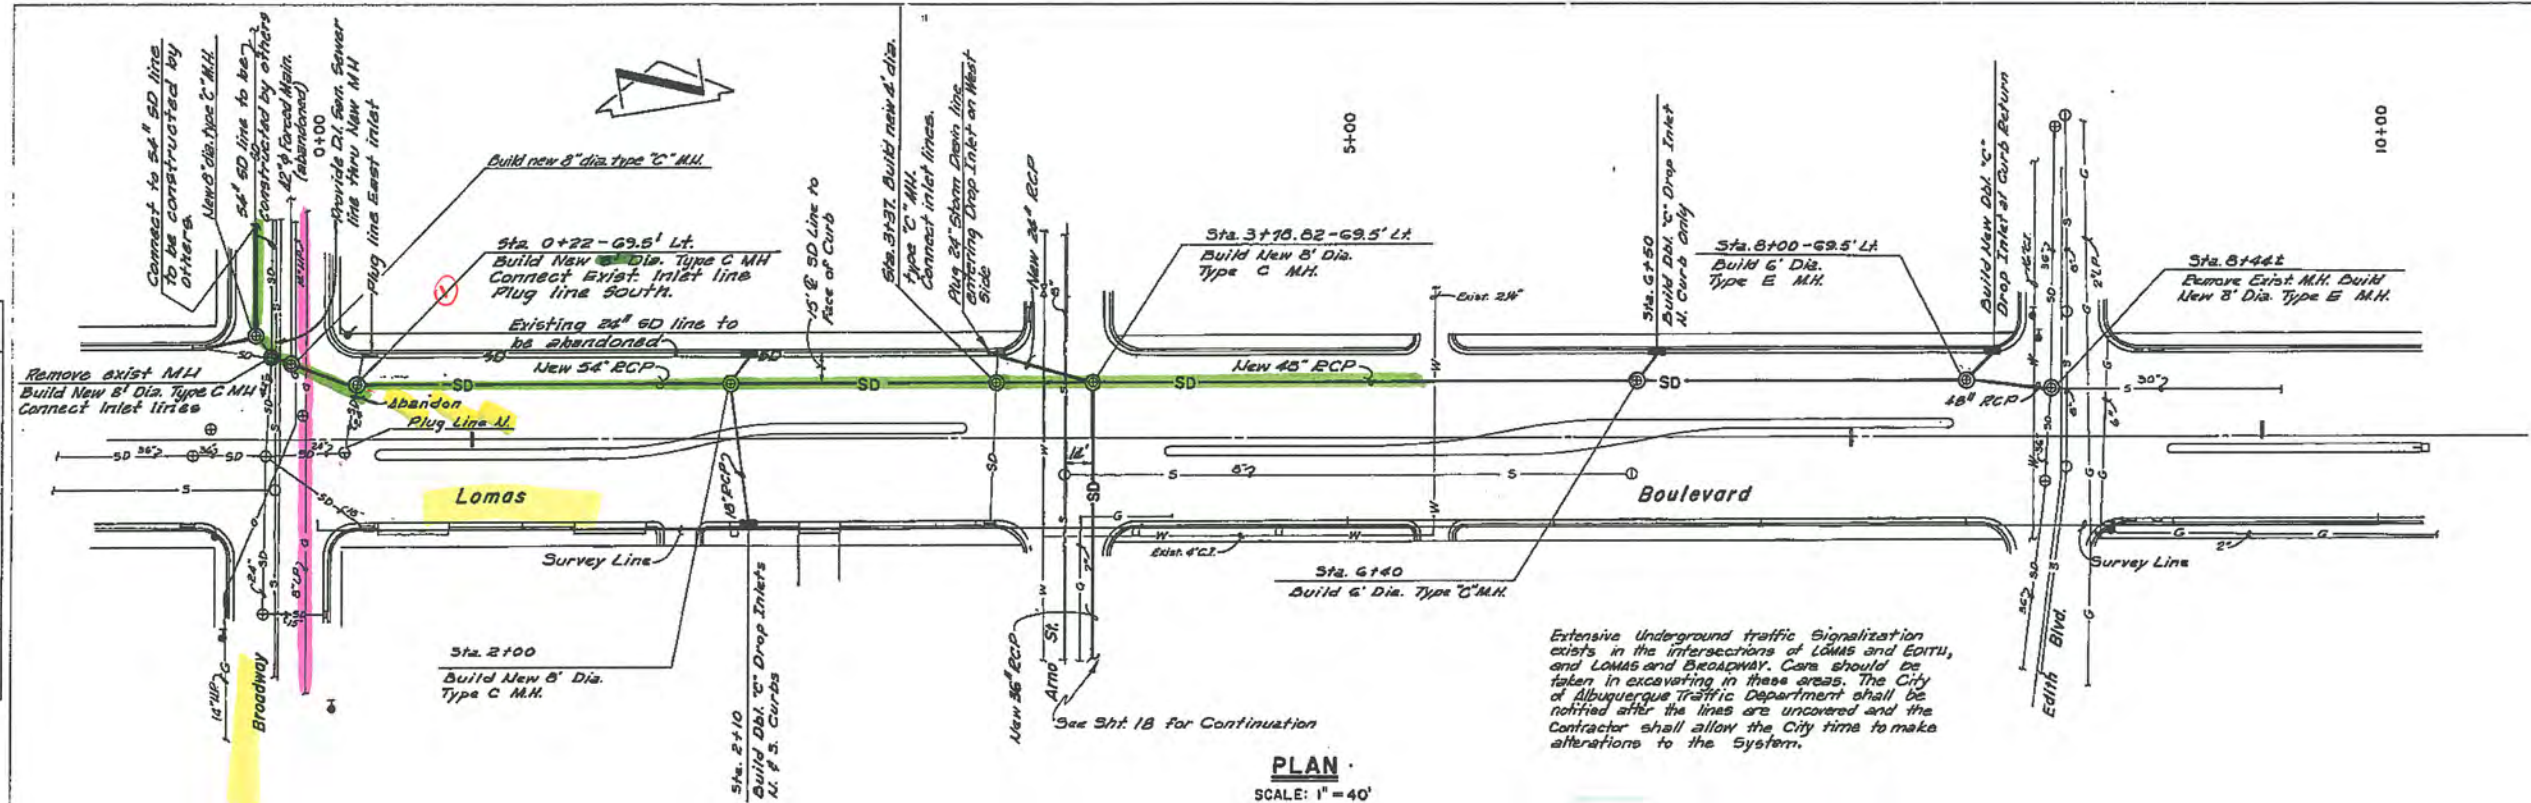

PLAN
SCALE: 1" = 40'



PROFILE	CHECKED	DATE
NOTE BOOK	STRUCTURE NOTATION CHVD	
NO. 1		

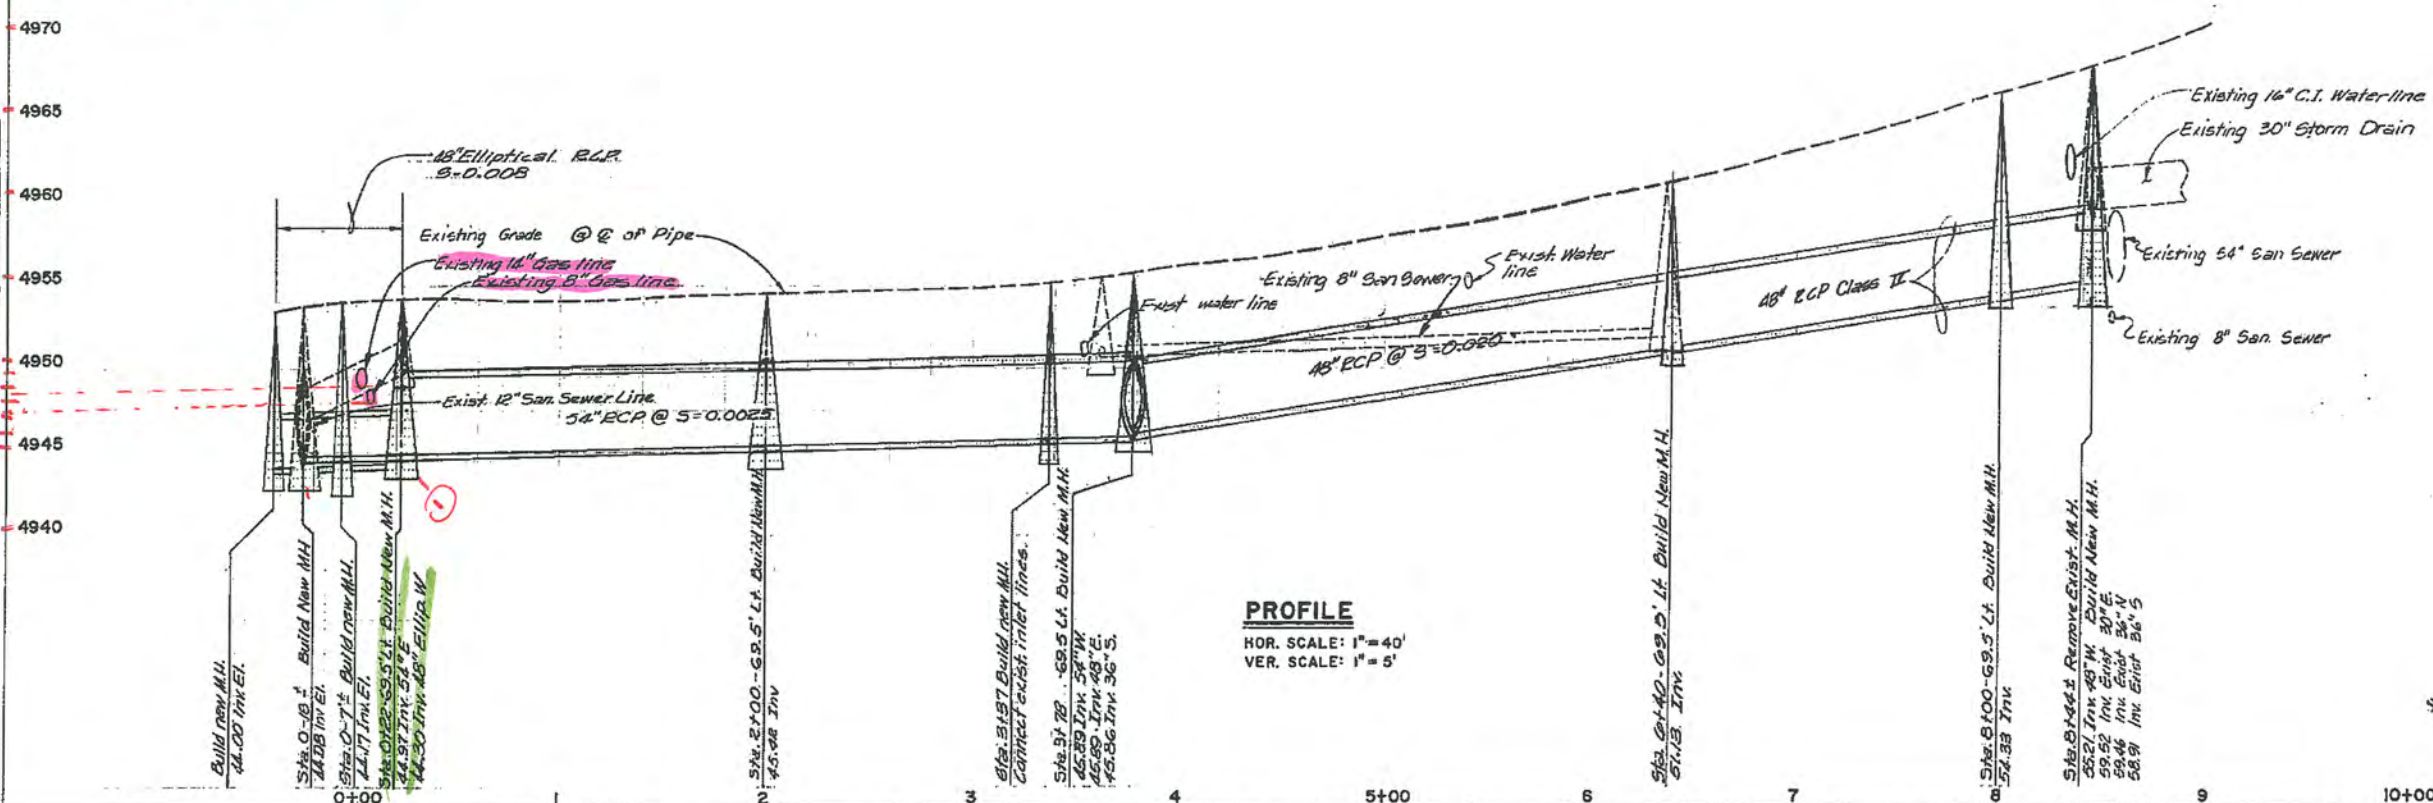

PROFILE
HOR. SCALE: 1" = 40'
VER. SCALE: 1" = 5'

10-002-2474 AS BUILT

SCANNED BY: JASON

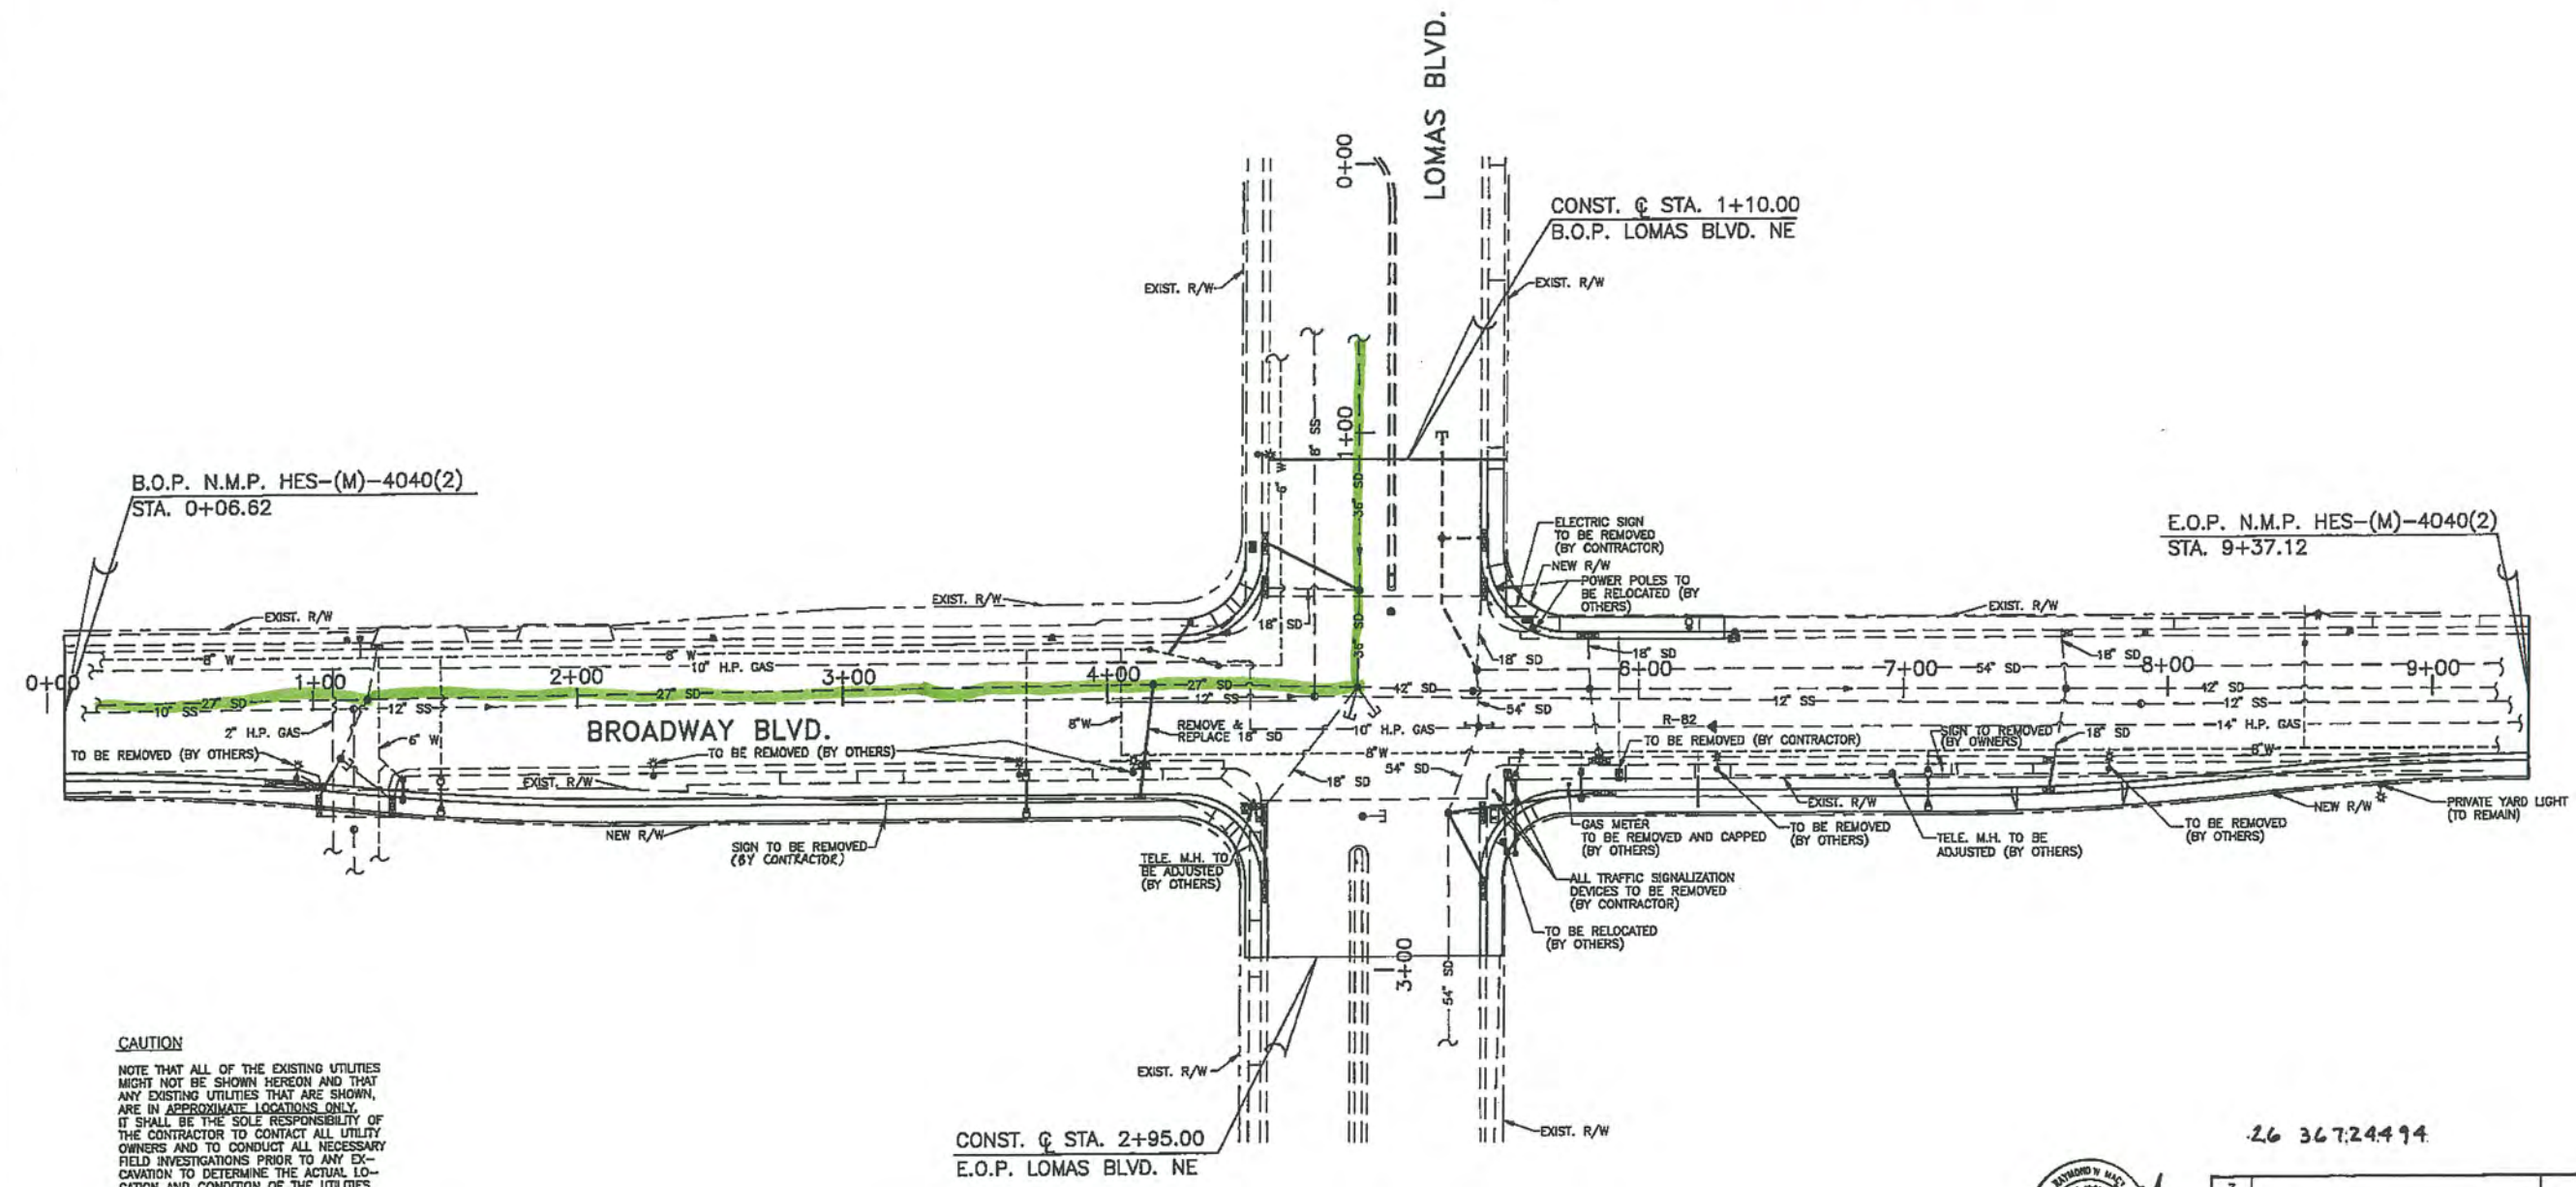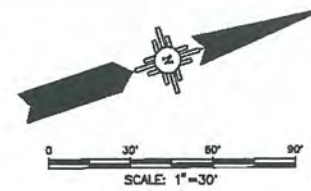

CAUTION

NOTE THAT ALL OF THE EXISTING UTILITIES MIGHT NOT BE SHOWN HEREON AND THAT ANY EXISTING UTILITIES THAT ARE SHOWN, ARE IN APPROXIMATE LOCATIONS ONLY. IT SHALL BE THE SOLE RESPONSIBILITY OF THE CONTRACTOR TO CONTACT ALL UTILITY OWNERS AND TO CONDUCT ALL NECESSARY FIELD INVESTIGATIONS PRIOR TO ANY EXCAVATION AND CONDITION OF THE UTILITIES AND OTHER IMPROVEMENTS.

LEGEND			
☉	LIGHT POLE	○	WATER METER
⚡	POWER POLE	•	WATER VALVE
⚙	FIRE HYDRANT	○	S.A.S. MANHOLE
•	SIGNAL BASE	○	STORM SEWER MANHOLE
■	SIGNAL PULL BOX	○	STORM SEWER DROP INLET
□	SIGNAL CONTROL BOX	○	TELEPHONE MANHOLE
•	GAS METER	■	ELECTRIC PULL BOX

UTILITY OWNERS			
WATER/SEWER	CITY OF ALBUQUERQUE	(505)857-8200	
ELECTRICITY	PUBLIC SERVICE OF NM	(505)748-4947	
GAS	GAS CO. OF NM	(505)889-2538	
CABLE	JONES INTERCABLE	(505)761-6200	
TELEPHONE	AT&T	(505)842-2855	
	U.S. WEST	(505)245-6736	

- NOTES:**
1. SEE SHEET 4-1 FOR WATER SHUT-OFF PLAN.
 2. SEE SHEET 7-1 FOR LIGHTING PLAN.
 3. SEE SHEET 8-2 FOR TRAFFIC SIGNALIZATION.
 4. SEE SHEET 9-1 THRU 9-3 FOR STRUCTURE PLACEMENTS.
 5. A.T. & T. HAS NO COMMUNICATION CABLES IN THE INTERSECTION.
 6. JONES INTERCABLE HAS NO CABLES IN THE INTERSECTION.

APPROVALS	ENGINEER	DATE
DRC CHAIRMAN	<i>Roger Khan</i>	2-13-92
TRANSPORTATION	<i>R. J. Lousie</i>	8-26-91
HYDROLOGY	<i>Steve Boring</i>	8-23-91
WATER	<i>N. D. L.</i>	8-30-91
WASTE WATER	<i>N. D. L.</i>	"



26 367,244.94

3			
2			
1			
NO.	DESCRIPTION	DATE	BY
REVISIONS (OR NOTICES)			
NEW MEXICO			
STATE HIGHWAY DEPARTMENT			
EXISTING UTILITIES			
GMA, INC. 5700 HARPER DR. NE., STE. 240 ALBUQUERQUE, NM 87108			

FILENAME: EXRELUT
PROJECT NAME: LOMAS/BROADWAY
PROJECT NO.: 890010
DATE: 8/17/91
DRAWN BY: B.J.G.
DESIGNED BY: RM