


C1 DRAINAGE STORM INLET DOUBLE "C"

DRAINAGE STORM INLET CENTER SUPPORT ASSEMBLY
N.T.S.

C5 DRAINAGE STORM INLET FRAME

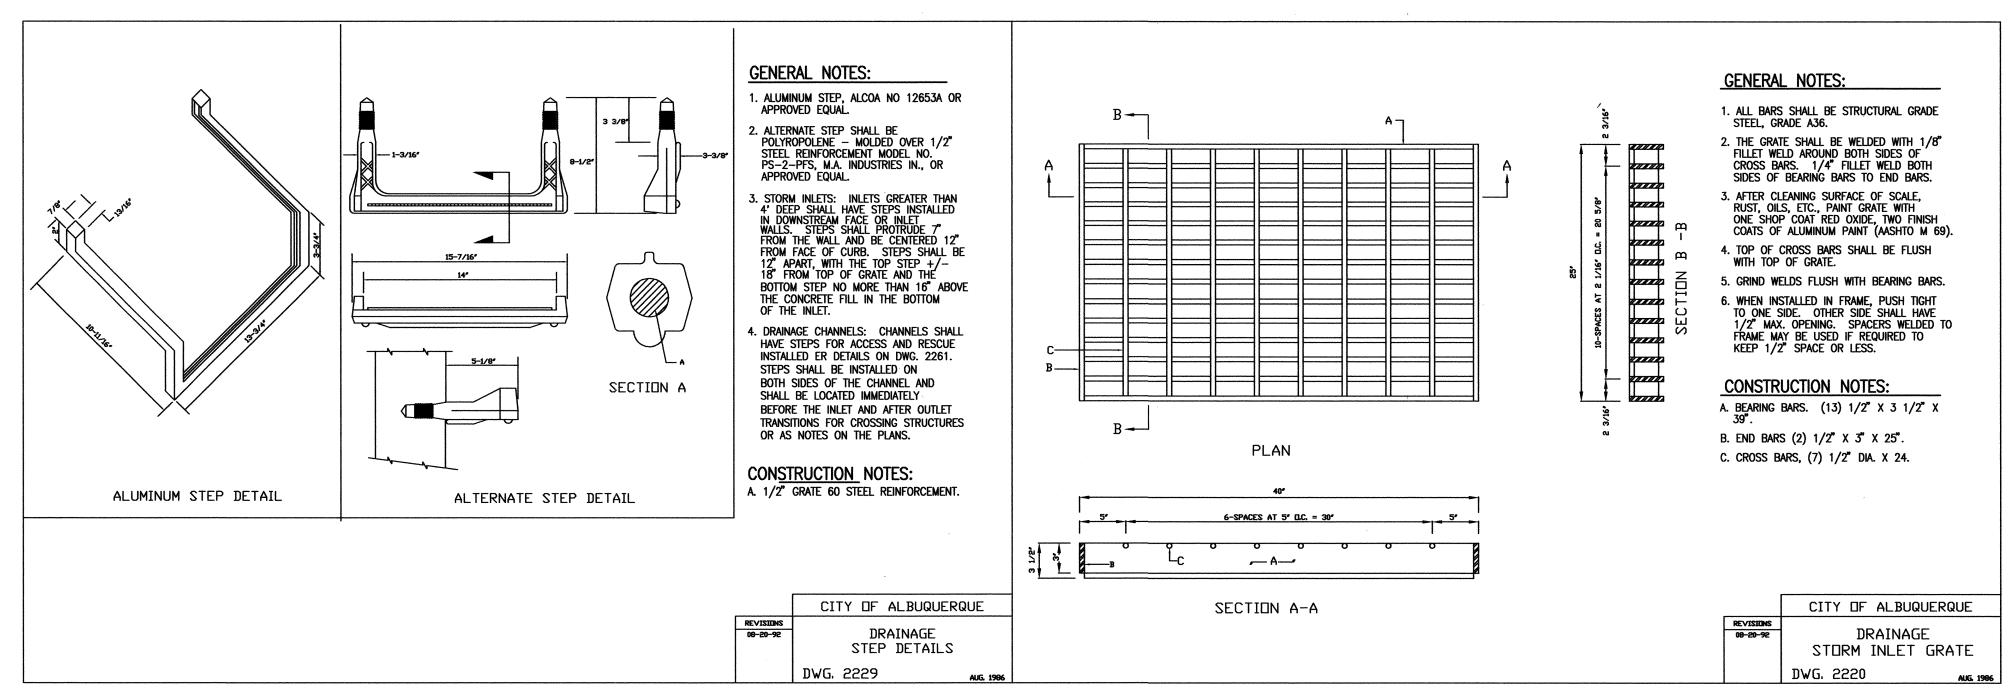


DRAINAGE STEP DETAILS

N.T.S.

DRAINAGE STORM INLET

RECORD DRAWING

HIGH MESA Consulting Group

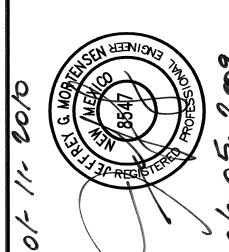

DRAINAGE PLAN IMPROVEMENTS PHASE 2-B BUQUERQUE HIGH SCHOOL

PROJECT No. 2007.183.7
DESIGNED BY G.R.B.

DRAWN BY J.Y.R.

APPROVED BY J.G.M.

SHEET TITLE

STORM INLET

SECTIONS AND

DETAILS C-308

SHEET 8 OF 14