


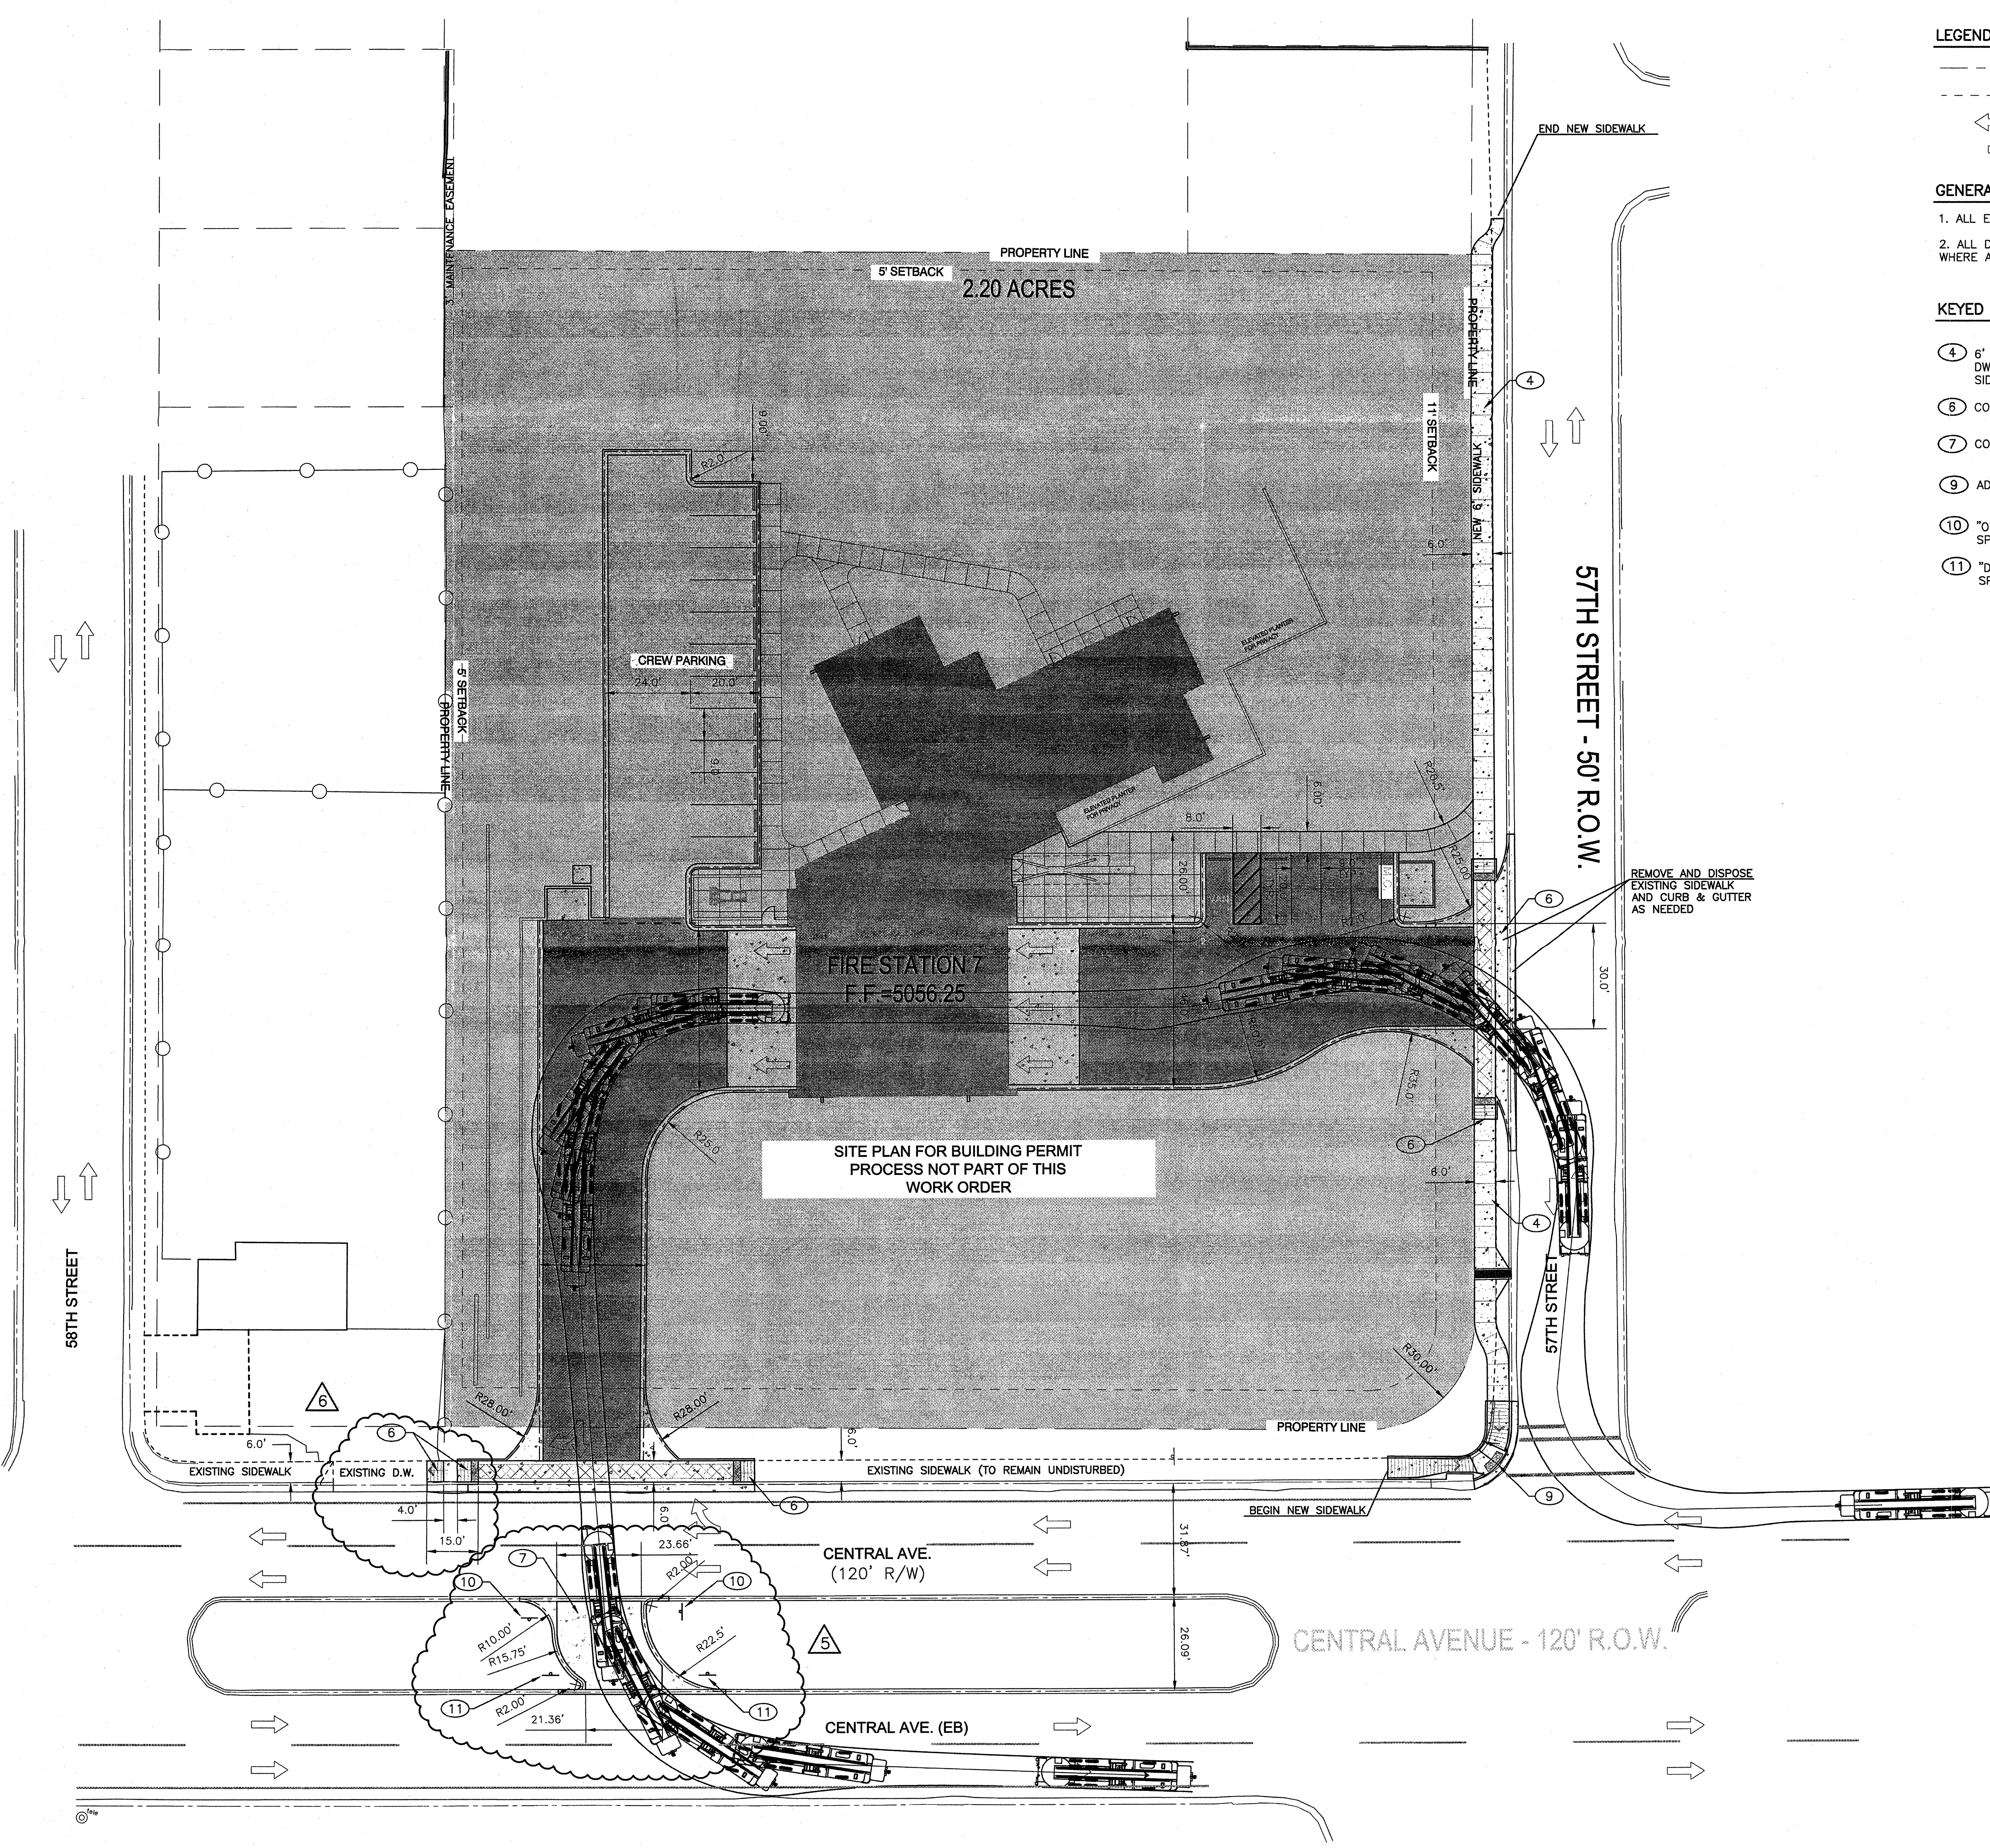

LEGEND


--- PROPERTY LINE
--- SETBACK LINE
← TRAFFIC FLOW
→

GENERAL NOTES

1. ALL EXISTING UTILITIES MAY NOT BE SHOWN.
2. ALL DIMENSIONS ARE THE FLOWLINE OF CURB AND GUTTER WHERE APPLICABLE.

KEYED NOTED

④ 6" WIDE CONCRETE SIDEWALK. SEE TYPICAL SECTION DWG C-501. REMOVE AND DISPOSE OF EXISTING CONCRETE SIDEWALK.
⑥ CONCRETE DRIVEWAY AND RAMPS. SEE DETAIL DWG C-501
⑦ CONCRETE MEDIAN CROSSOVER. SEE DETAILS DWG C-501
⑨ ADA RAMP PER COA STD. DWG. 2441
⑩ "OFFICIAL VEHICLES ONLY" - R5-11. PER MUTCD CODES AND SPECIFICATIONS.
⑪ "DO NOT ENTER" - R5-1. PER MUTCD CODES AND SPECIFICATIONS.

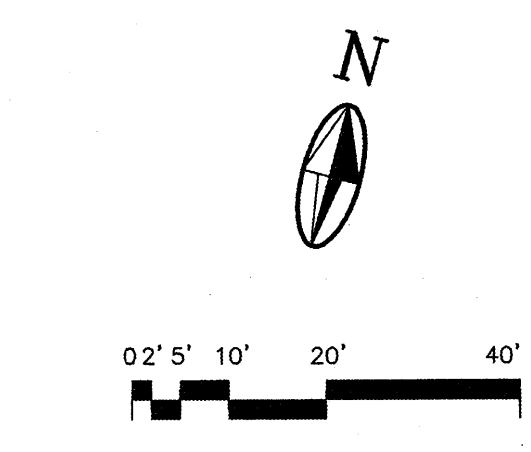


MOLZENCORBIN
ENGINEERS | ARCHITECTS | PLANNERS

Dekker/Perich/Sabatini architects • interiors • landscape • planning • engineering 7001 Jefferson NE, Suite 100 Albuquerque, NM 87109 505.781.9700 fax 505.422.2222	
CITY OF ALBUQUERQUE CAPITAL IMPLEMENTATION PROGRAM	
PROJECT TITLE: FIRE STATION 7 ALBUQUERQUE, NEW MEXICO	
DRAWING TITLE: PUBLIC ROADWAY PLAN	
Design Review Committee	City Engineer Approval
Last Design Update	
City Project No. 8006.91	Zone Map No. K-11
DWG. C-103	Sheet 27

SURVEY INFORMATION		FIELD NOTES		BENCH MARKS		AS BUILT INFORMATION	
NO.	BY	DATE	DATE	CAP. NO.	DATE	NO.	DATE
				N=48492.273, E=506010.213, EL=5076.70			
				CAP. 5, K10			
				N=484902.150, E=502747.375			

REVISIONS		DESIGN	
NO.	DATE	DESIGNED BY	CHECKED BY
1	01.03.12	CWG	CWG
2	01.03.12	CWG	CWG
3	01.03.12	CWG	CWG
4	01.03.12	CWG	CWG
5	01.03.12	CWG	CWG
6	01.03.12	CWG	CWG
7	01.03.12	CWG	CWG
8	01.03.12	CWG	CWG
9	01.03.12	CWG	CWG
10	01.03.12	CWG	CWG
11	01.03.12	CWG	CWG

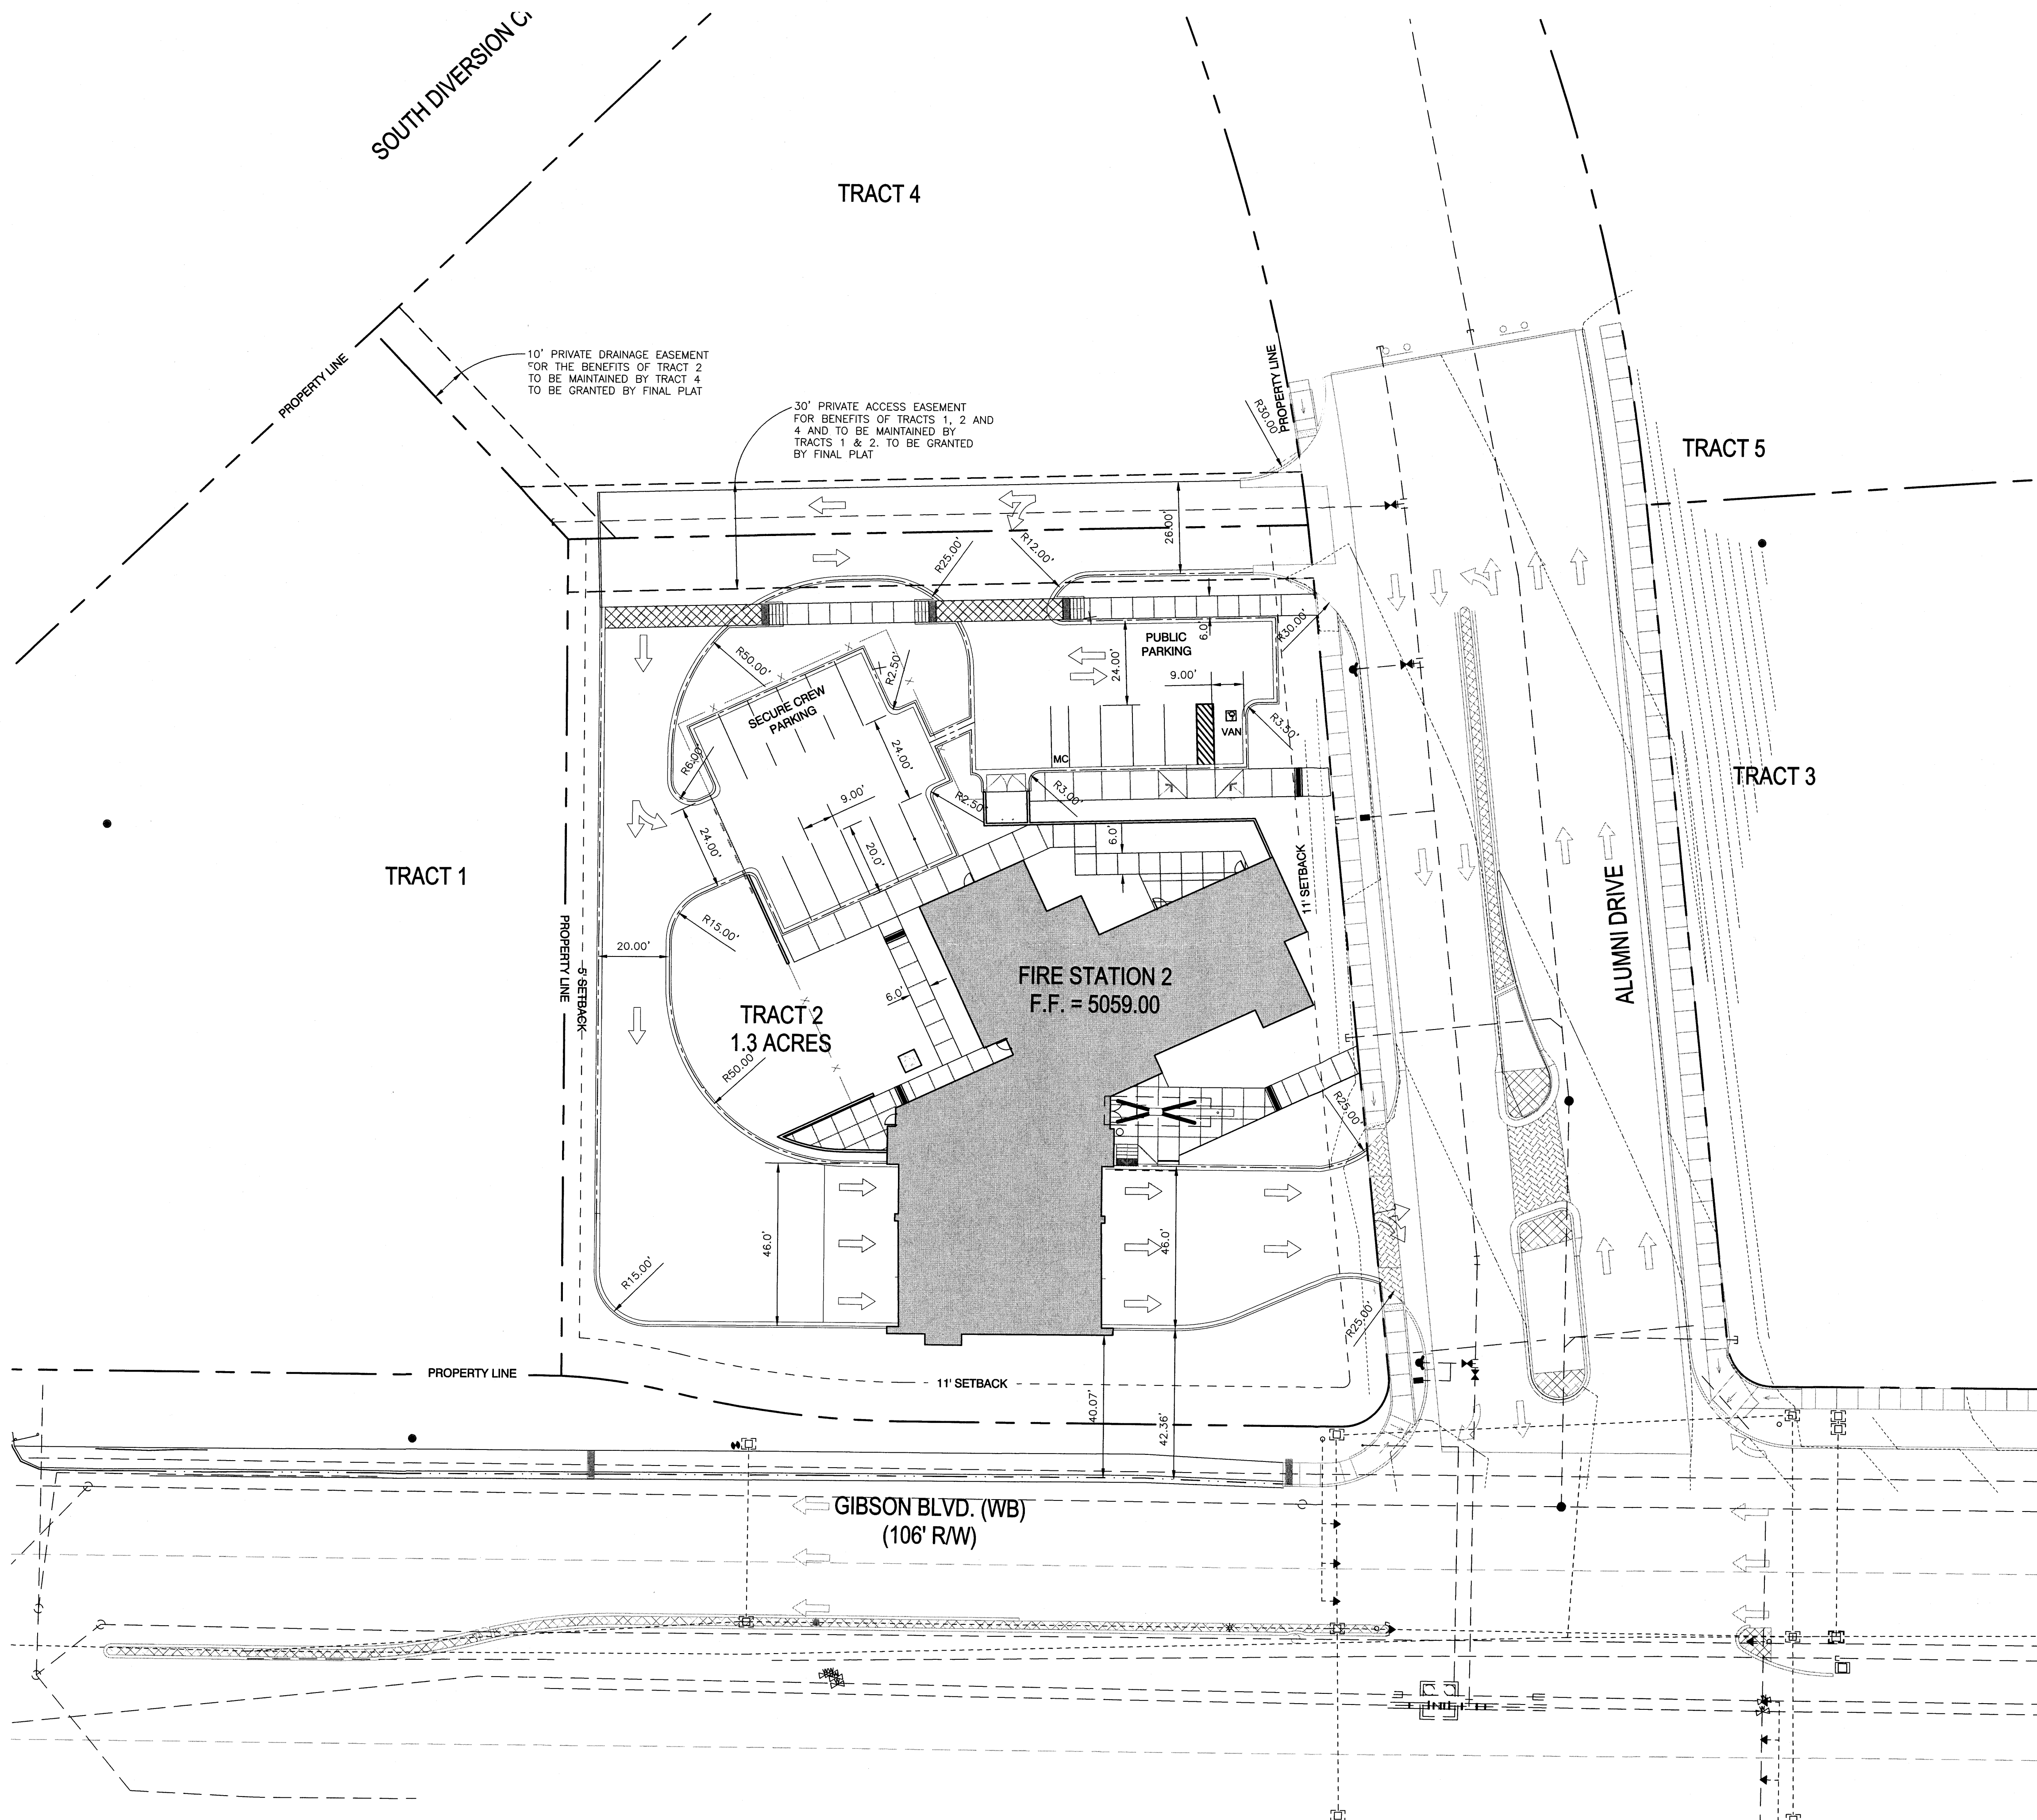

LEGEND

— PROPERTY LINE



- - - SETBACK LINE

← TRAFFIC FLOW (FOR INFORMATION ONLY)

GENERAL NOTES

1. ALL EXISTING UTILITIES MAY NOT BE SHOWN.

2. ALL DIMENSIONS ARE THE FLOWLINE OF CURB AND GUTTER WHERE APPLICABLE.

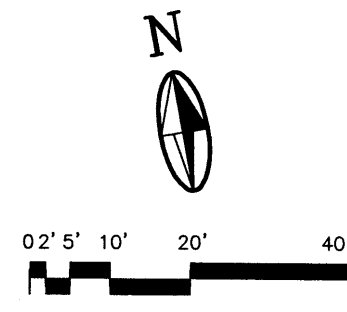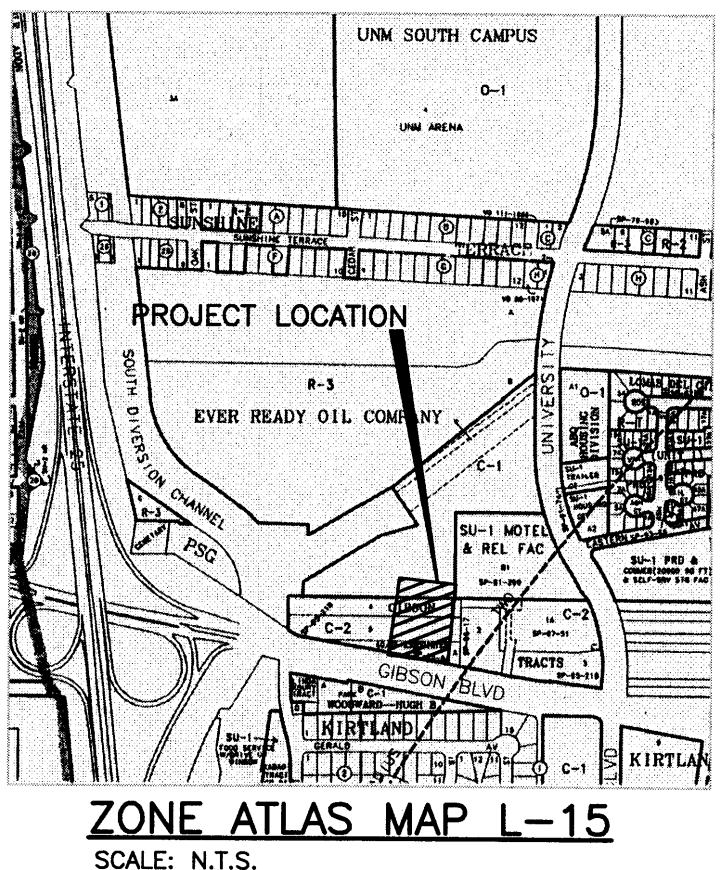

MOLZENCORBIN
ENGINEERS | ARCHITECTS | PLANNERS

Dekker/Perich/Sabatini
architecture • interiors • landscape • planning • engineering
7801 Jefferson NE, Suite 100 Albuquerque, NM 87109
505 761-9700 fax 761-4222


CITY OF ALBUQUERQUE
CAPITAL IMPLEMENTATION PROGRAM

PROJECT TITLE:
**FIRE STATION 2
ALBUQUERQUE, NEW MEXICO**



DRAWING TITLE:
TRAFFIC CIRCULATION PLAN

Design Review Committee	City Engineer Approval	Last Design Update		Mo./Day/Yr.	Mo./Day/Yr.
City Project No. 8006.91	Zone Map No. L-15-Z	DWG. C-103	Sheet	Of	

AS BUILT INFORMATION			BENCH MARKS			SURVEY INFORMATION			SEAL		
CONTRACTOR	REVISIONS BY	DATE	CAP. 1-25-30	DATE	NO.	FIELD NOTES	BY	DATE			
REVISIONS BY	DATE	NO.	E-1524652.518	E-5041.30	NO.	BY	DATE	DATE			
REVISIONS BY	DATE	NO.			NO.	BY	DATE	DATE			
REVISIONS BY	DATE	NO.			NO.	BY	DATE	DATE			
REVISIONS BY	DATE	NO.			NO.	BY	DATE	DATE			
REVISIONS BY	DATE	NO.			NO.	BY	DATE	DATE			
REVISIONS BY	DATE	NO.			NO.	BY	DATE	DATE			
REVISIONS BY	DATE	NO.			NO.	BY	DATE	DATE			
REVISIONS BY	DATE	NO.			NO.	BY	DATE	DATE			
REVISIONS BY	DATE	NO.			NO.	BY	DATE	DATE			

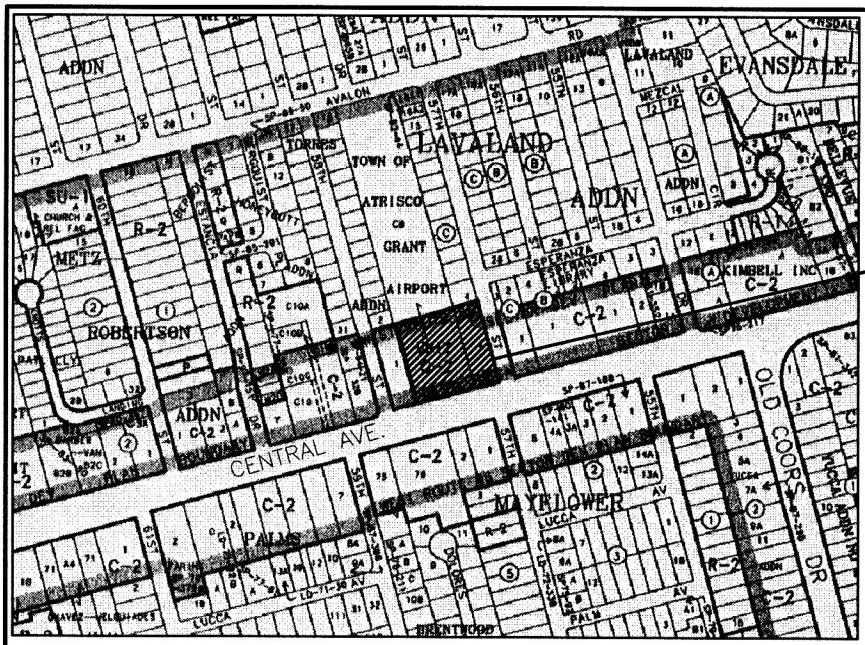

VICINITY MAP
ZONE ATLAS MAP K-11
N.T.S.

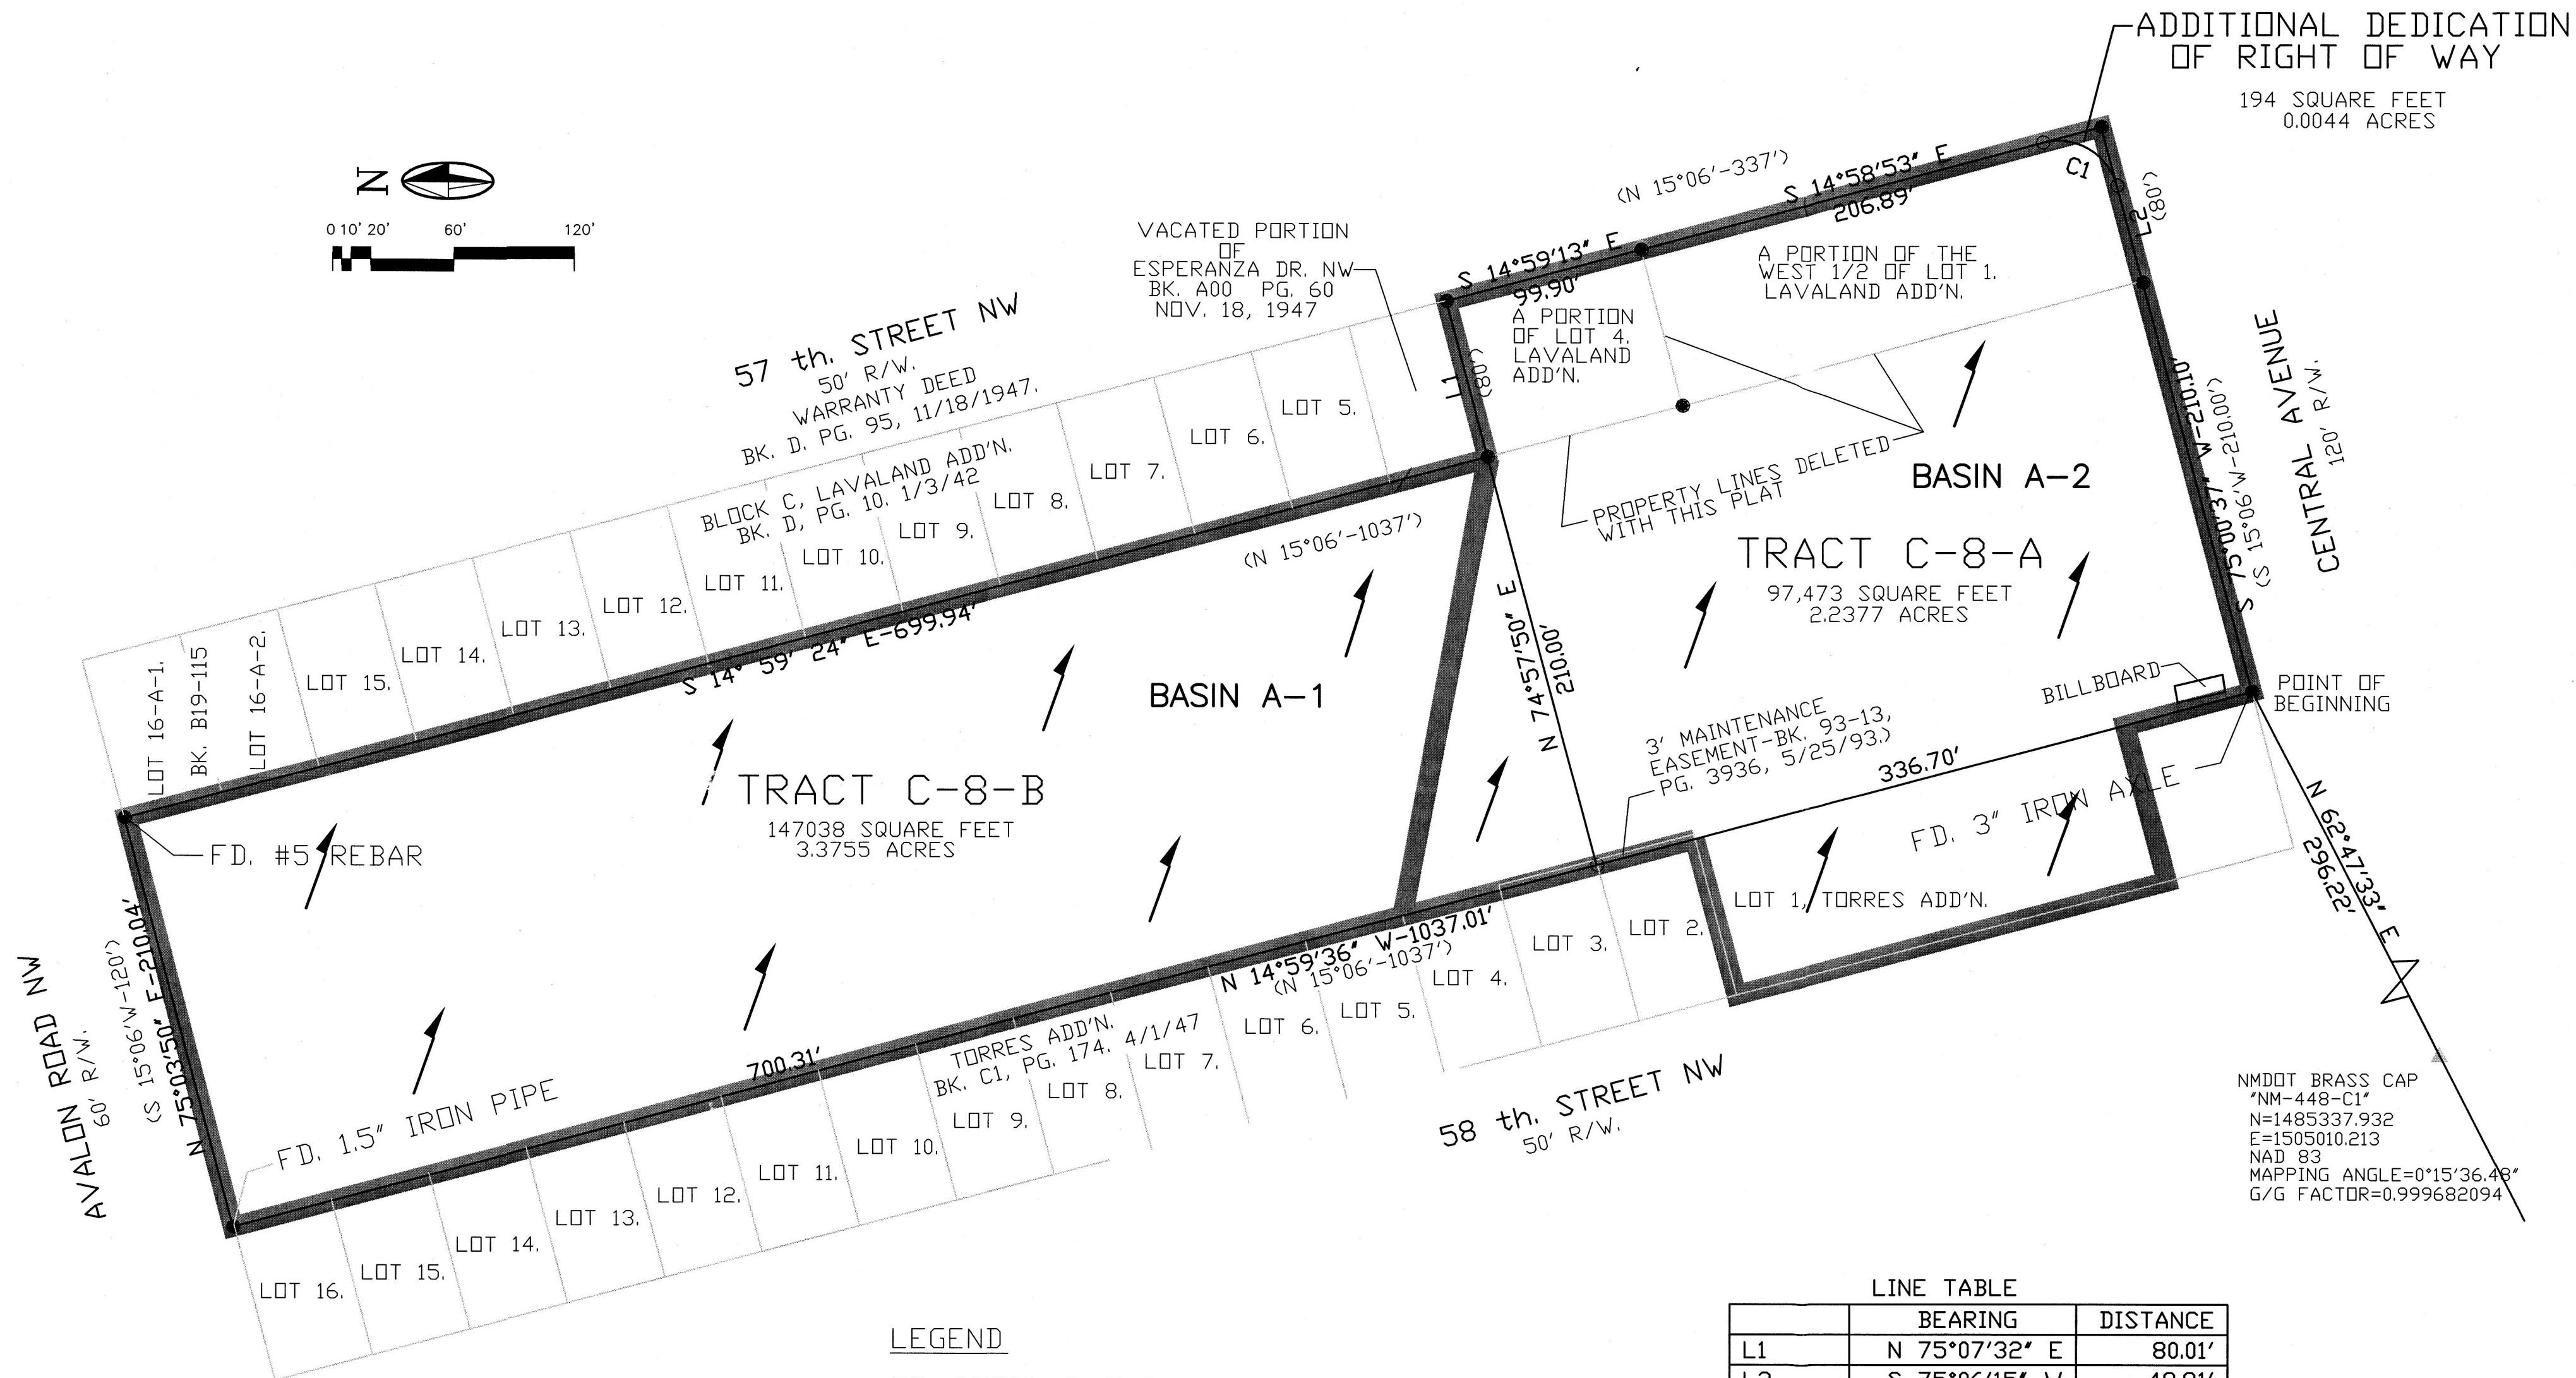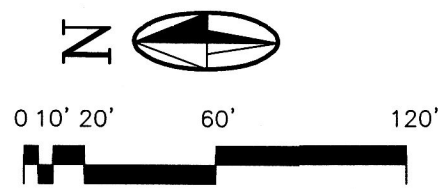

LEGEND

- FD. STEEL BATHEY MARKER STAMPED " CARTESIAN SURVEYS- LS 14271" OR AS NOTED.
- SET NO. 5 REBAR WITH CAP STAMPED "PS 7924".

LINE TABLE

	BEARING	DISTANCE
L1	N 75°07'32" E	80.01'
L2	S 75°06'15" W	49.81'

CURVE TABLE

	ARC	DELTA	RADIUS	TANGENT	CH. BRG.	CH. DIST.
C1	47.17	90°05'08"	30.00'	30.04'	S30°03'41"W	42.46'

LEGEND

- BASIN A-1
- DIRECTION OF FLOW

CITY OF ALBUQUERQUE FIRE STATION NO. 7

DRAINAGE ANALYSIS

INTRODUCTION

PURPOSE AND SITE LOCATION

Fire Station No. 7 will be located at the NW corner of Central Ave and 57th St on a 2.24 acre site of predominately undeveloped property. The City of Albuquerque owns the development property.

The existing stormwater discharge flows across the property generally from NW to SE. Off-site flows are generally from the north to the south. Flows from the property enter into 57th St. or Central Ave. and eventually into a 24-inch storm drain located within the westbound lanes of Central Ave.

CRITERIA

The proposed grading and drainage for the development of this site are based on the criteria in the City of Albuquerque Development Process Manual (DPM) Chapter 22. Flow calculations are based on the 100-yr, 6-hr design storm. The area of study was divided into two basins; Basin A-1 is a 3.32-ac off-site basin located to the north of the proposed site and Basin A-2 is the 2.24-acre Fire Station No. 7 site.

The off-site and on-site flows will be collected through grading and culverts and routed through a pond. The initial 0.44-in rainfall on the property will be retained in the pond at the request of the City of Albuquerque for storm water treatment purposes. Discharge from the pond will be into the 15-inch storm drain in 57th St which discharges into the 24-inch storm drain in Central Ave.

EXISTING CONDITIONS

The 2.24 acre Fire Station No. 7 site and the 3.32-acre contributing adjacent basin are primarily undeveloped. Basins adjacent to these two basins are fully developed and discharge to adjacent roadways and do not flow through the proposed development. The existing drainage flow for the subject basins travel from north and northwest to south and southeast to 57th St and Central Ave. The discharge from the site enters into the COA operated and maintained storm drainage system in Central Ave.

DEVELOPED CONDITIONS


Off-site flows are maintained with the undeveloped existing conditions in this analysis. The on-site flows have been calculated with fully developed conditions from the proposed site plan. The drainage pond proposed for the southeast quadrant of the site has been sized to retain approximately 0.44-in of the initial storm flows. A 12-inch storm drain connected to the existing 15-inch storm drain in 57th St is used for the pond discharge. The initial 0.44-inch volume will be retained and filtered through a gravel pond bottom as a treatment method.


EXISTING CONDITIONS							VOL (ac ft)
DESCRIPTION		LAND TREATMENT				FLOW (cfs)	
Basin	Areas (ac)	A	B	C	D	Q 100-6	V 100-6
A-1	3.32	0	0	100	0	9.63	.275
A-2	2.24	0	0	100	0	6.30	.180

DEVELOPED CONDITIONS							
DESCRIPTION		LAND TREATMENT				FLOW (cfs)	VOL (ac ft)
Basin	Areas (ac)	A	B	C	D	Q 100-6	V 100-6
A-1	3.32	0	0	100	0	9.63	.275
A-2	2.24	0	0	60	40	7.56	.251

MOLZENCORBIN

CITY OF ALBUQUERQUE PUBLIC WORKS DEPARTMENT ENGINEERING DEVELOPMENT GROUP			
TITLE: FIRE STATION 7 ALBUQUERQUE, NEW MEXICO GRADING AND DRAINAGE			
Design Review Committee	City Engineer Approval	Last Design Update	Mo./Day/Yr.
City Project No. 8006.91	Zone Map No. K-11	DWG. C-101A	Sheet 6 Of 13

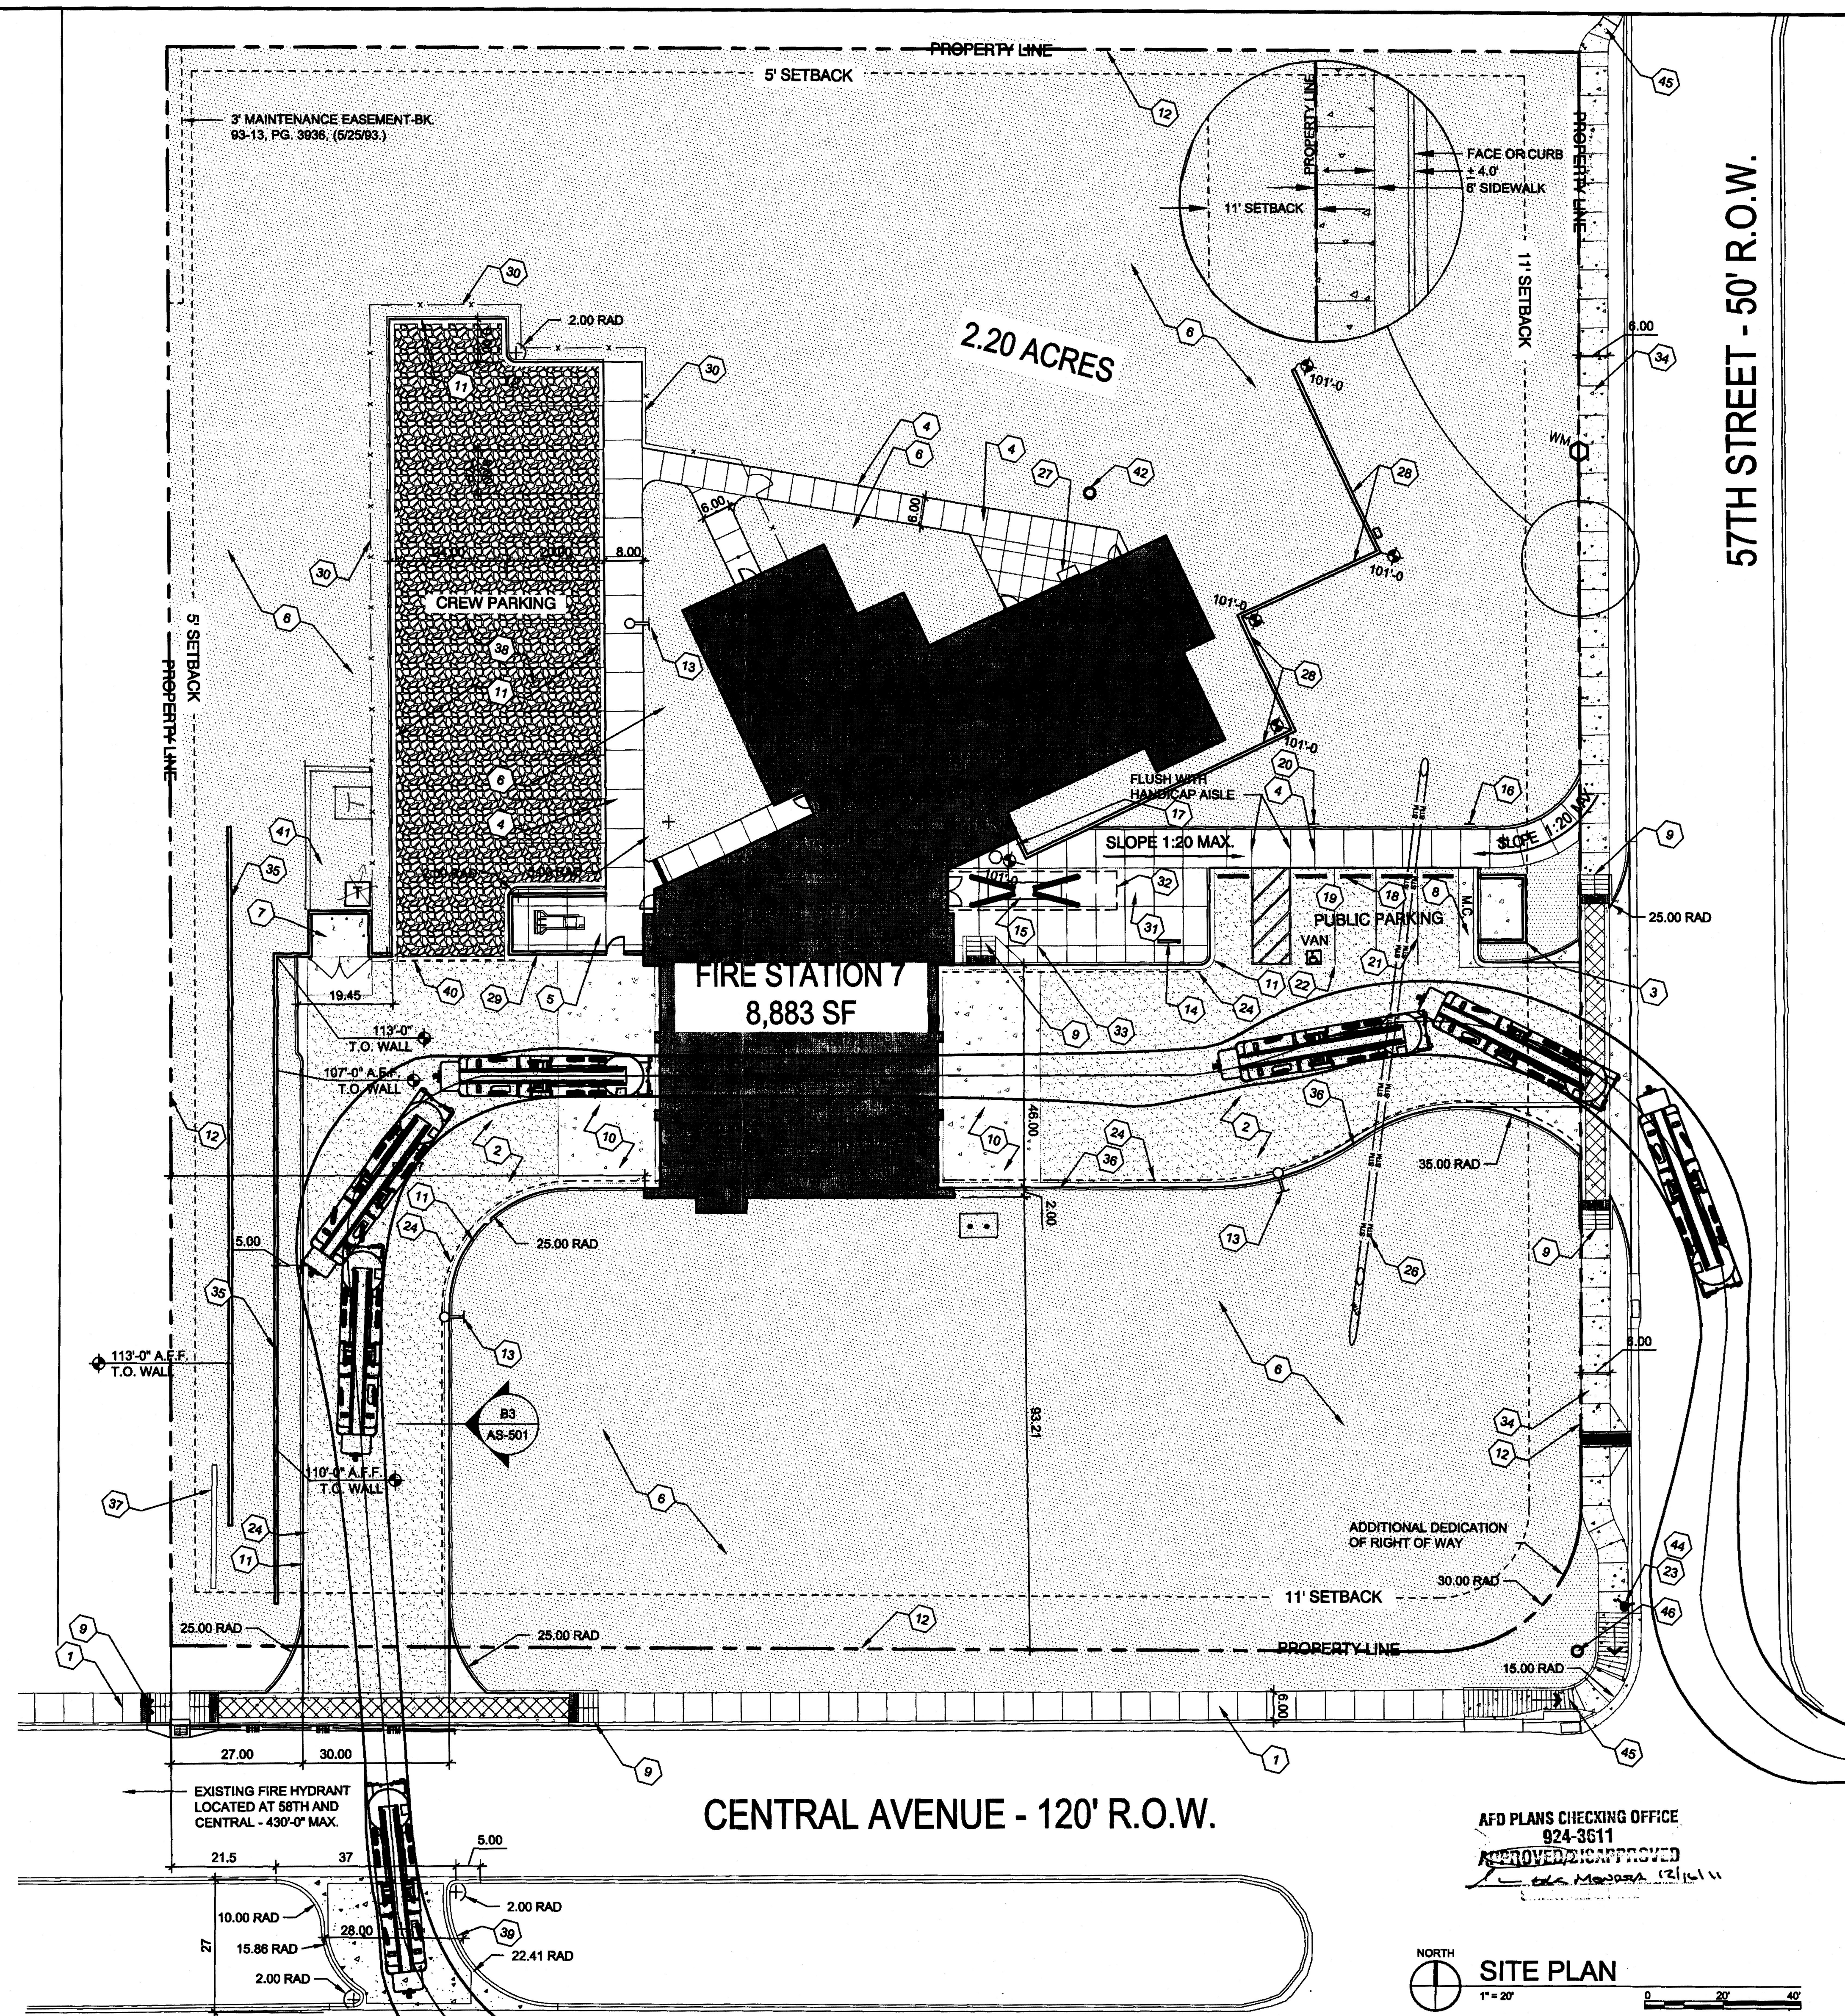

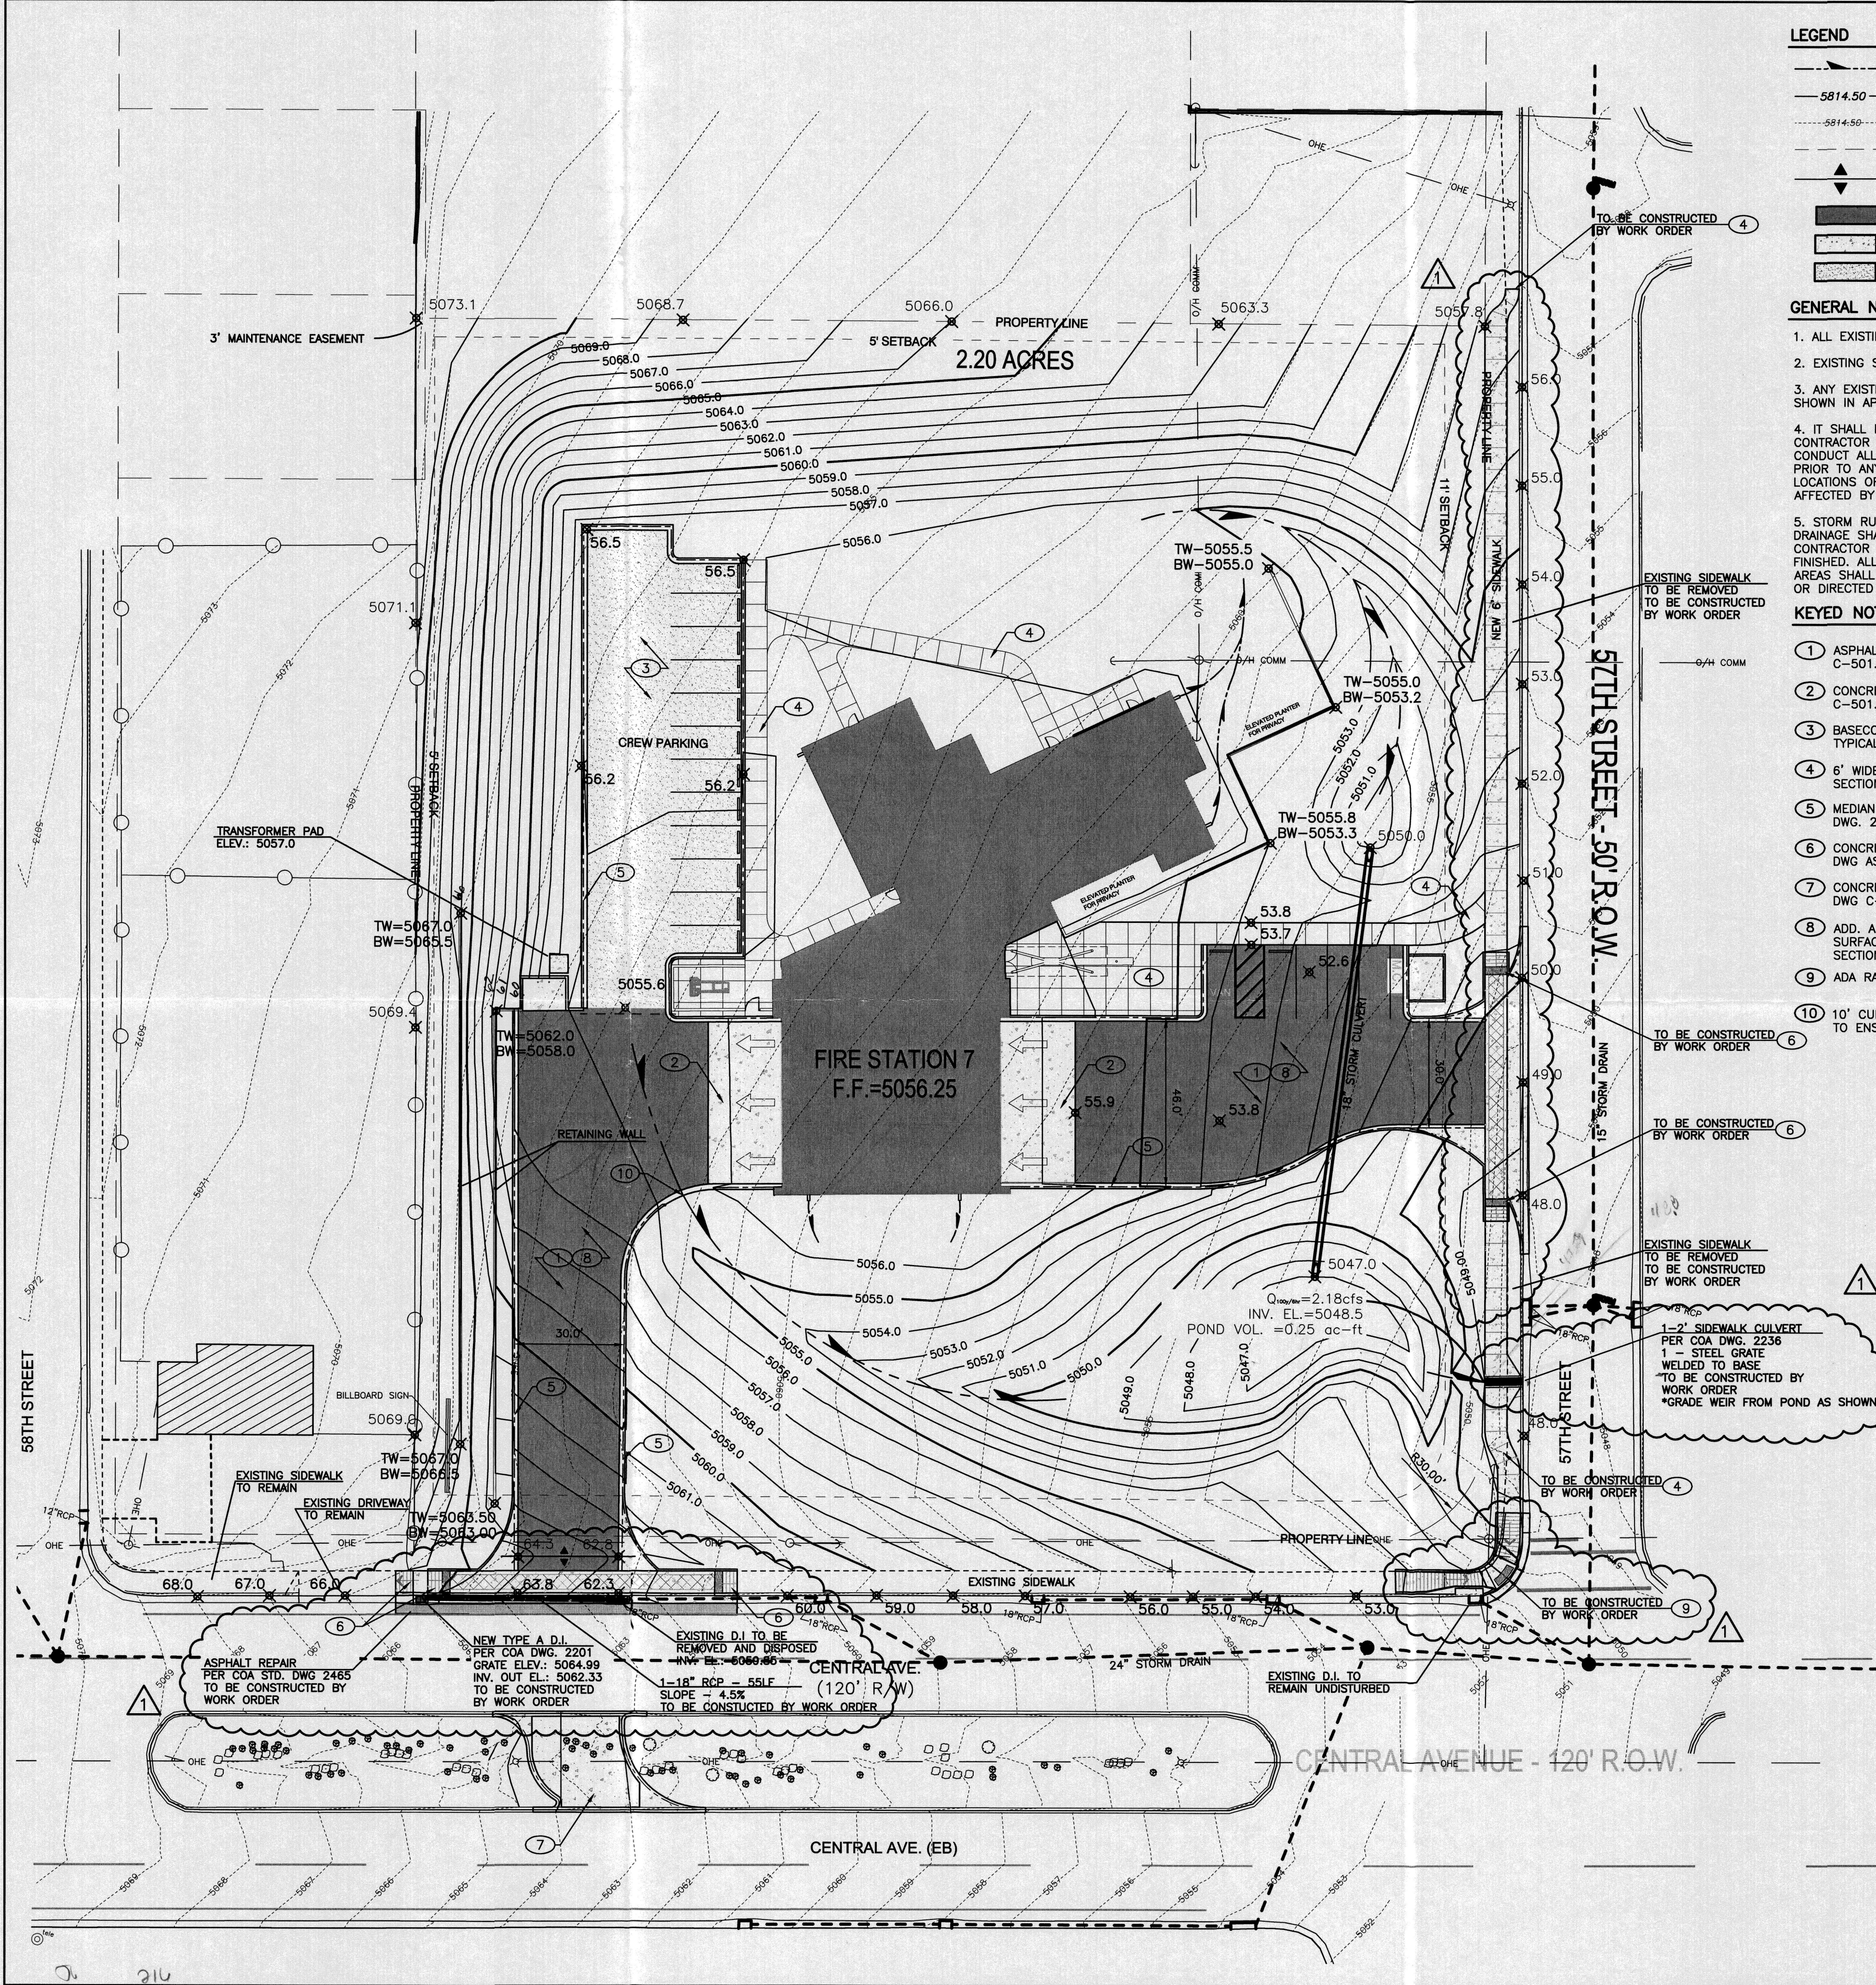

- LEGEND**
- GRADED FLOWLINE
 - NEW TOPOGRAPHIC CONTOUR
 - EXISTING TOPOGRAPHIC CONTOUR
 - MISC. PROPERTY LINE
 - GRADE BREAK (RIDGE)
 - NEW ASPHALT
 - CONCRETE PAVEMENT
 - BASECOURSE PAVEMENT

- GENERAL NOTES**
- ALL EXISTING UTILITIES MAY NOT BE SHOWN.
 - EXISTING SERVICE CONNECTIONS ARE NOT SHOWN.
 - ANY EXISTING UTILITIES THAT ARE SHOWN ARE SHOWN IN APPROXIMATE LOCATION ONLY.
 - IT SHALL BE THE RESPONSIBILITY OF THE CONTRACTOR TO CONTACT ALL UTILITY OWNERS AND CONDUCT ALL NECESSARY FIELD INVESTIGATIONS PRIOR TO ANY EXCAVATIONS TO DETERMINE ACTUAL LOCATIONS OF EXISTING UTILITIES THAT MAY BE AFFECTED BY NEW CONSTRUCTION.
 - STORM RUN-OFF CONVEYANCE AND PROPER DRAINAGE SHALL BE THE RESPONSIBILITY OF CONTRACTOR DURING CONSTRUCTION AND WHEN FINISHED. ALL ROOF DRAINS, CULVERTS AND SLOPED AREAS SHALL DRAIN PROPERLY AS SHOWN ON PLAN OR DIRECTED BY ENGINEER.
- KEYED NOTES**
- ASPHALT SURFACE. SEE TYPICAL SECTION DWG C-501.
 - CONCRETE APRON. SEE TYPICAL SECTION DWG C-501.
 - BASECOURSE PAVEMENT PARKING AREA. SEE TYPICAL SECTION DWG C-501.
 - 6' WIDE CONCRETE SIDEWALK. SEE TYPICAL SECTION DWG C-501.
 - MEDIAN CURB AND GUTTER. PER COA STD. DWG. 2415B.
 - CONCRETE DRIVEWAY AND RAMPS. SEE DETAIL DWG AS-501.
 - CONCRETE MEDIAN CROSSOVER. SEE DETAILS DWG C-501.
 - ADD. ALT. #2 - CONCRETE PAVEMENT SURFACE IN LIEU OF ASPHALT. SEE TYPICAL SECTION DWG C-501.
 - ADA RAMP PER COA STD. DWG. 2441.
 - 10' CURB CUT TO ALLOW DRAINAGE IN TO POND. CONTRACTOR TO ENSURE CENTER OF CURB IS THE LOW POINT.

HYDROLOGY ANALYSIS

CITY OF ALBUQUERQUE FIRE STATION NO. 7

DRAINAGE ANALYSIS

INTRODUCTION

PURPOSE AND SITE LOCATION

Fire Station No. 7 will be located at the NW corner of Central Ave and 57th St on a 2.24 acre site of predominately undeveloped property. The City of Albuquerque owns the development property.

The existing stormwater discharge flows across the property generally from NW to SE. Off-site flows are generally from the north to the south. Flows from the property enter into 57th St. or Central Ave. and eventually into a 24-inch storm drain located within the westbound lanes of Central Ave.

CRITERIA

The proposed grading and drainage for the development of this site are based on the criteria in the City of Albuquerque Development Process Manual (DPM) Chapter 22. Flow calculations are based on the 100-yr, 6-hr design storm. The area of study was divided into one basin; Basin A-2 is the 2.24-acre Fire Station No. 7 site.

The off-site and on-site flows will be collected through grading and culverts and routed through to a pond. The water collected in the pond will then be discharged over a weir and through a sidewalk culvert into the street where it will be collected by existing curb inlets located on 57th Street.

EXISTING CONDITIONS

The 2.24 acre Fire Station No. 7 site is primarily undeveloped. Basins adjacent to these two basins are fully developed and discharge to adjacent roadways and do not flow through the proposed development. The existing drainage flow for the subject basins travel from north and northwest to south and southeast to 57th St and Central Ave. The discharge from the site enters into the COA operated and maintained storm drainage system in Central Ave.

DEVELOPED CONDITIONS

Off-site flows are maintained with the undeveloped existing conditions in this analysis. The on-site flows have been calculated with fully developed conditions from the proposed site plan. The drainage pond proposed for the southeast quadrant of the site has been sized to retain 100% of the flows on the on-site. The pond will then utilize a weir discharge, calculated to be 2.18cfs, through a sidewalk culvert discharging to 57th Street where existing curb inlets will catch the flow.

EXISTING CONDITIONS		LAND TREATMENT				FLOW (cfs)		VOL (ac ft)	
Basin	Areas (ac)	A	B	C	D	Q 100-6	V 100-6		
A-2	2.24	0	0	100	0	6.30	.180		

DEVELOPED CONDITIONS		LAND TREATMENT				FLOW (cfs)		VOL (ac ft)	
Basin	Areas (ac)	A	B	C	D	Q 100-6	V 100-6		
A-2	2.24	0	0	60	40	7.56	.251		



RECEIVED
JAN 10 2012
HYDROLOGICAL SECTION

Dekker/Perich/Sabatini
architects - interiors - landscape - planning - engineering
7841 Jefferson NE, Suite 100
Albuquerque, NM 87119
505 761-0700
fax 761-4222

CITY OF ALBUQUERQUE
CAPITAL IMPLEMENTATION PROGRAM

PROJECT TITLE: **FIRE STATION 7**
ALBUQUERQUE, NEW MEXICO

DRAWING TITLE: **GRADING AND DRAINAGE**

Design Review Committee	City Engineer Approval	Mo./Day/Yr.	Mo./Day/Yr.


City Project No. **8006.91** Zone Map No. **K-11** DWG. **C-101** Sheet **Of**

AS BUILT INFORMATION		BENCH MARKS		SURVEY INFORMATION		FIELD NOTES		SEAL		REVISIONS		DESIGN		DRAWN BY		CHECKED BY		
DATE	DATE	NO.	DATE	NO.	DATE	NO.	DATE	NO.	DATE	NO.	DATE	NO.	DATE	NO.	DATE	NO.	DATE	NO.

DRAINAGE CERTIFICATION

I, JOHN M. PROVINE, NMPE 10997, OF THE FIRM MOLZEN CORBIN, HEREBY CERTIFY THAT THIS PROJECT HAS BEEN GRADED AND WILL DRAIN IN SUBSTANTIAL COMPLIANCE WITH AND IN ACCORDANCE WITH THE DESIGN INTENT OF THE APPROVED PLAN DATED 1/12/12. THE RECORD INFORMATION EDITED ONTO THE ORIGINAL DESIGN DOCUMENT HAS BEEN OBTAINED BY MICHAEL E. BEYER, NMPS 7459, OF THE FIRM BEAR COMPANY AND ASSOCIATES. I FURTHER CERTIFY THAT I HAVE PERSONALLY VISITED THE PROJECT SITE ON 11/21/12 AND HAVE DETERMINED BY VISUAL INSPECTION THAT THE SURVEY DATA PROVIDED IS REPRESENTATIVE OF ACTUAL SITE CONDITIONS AND IS TRUE AND CORRECT TO THE BEST OF MY KNOWLEDGE AND BELIEF. THIS CERTIFICATION IS SUBMITTED IN SUPPORT OF A REQUEST FOR CERTIFICATE OF OCCUPANCY 5701 CENTRAL NW - FIRE STATION NO. 7.

THE RECORD INFORMATION PRESENTED HEREON IS NOT NECESSARILY COMPLETE AND INTENDED ONLY TO VERIFY SUBSTANTIAL COMPLIANCE OF THE GRADING AND DRAINAGE ASPECTS OF THIS PROJECT. THOSE RELYING ON THIS RECORD DOCUMENT ARE ADVISED TO OBTAIN INDEPENDENT VERIFICATION OF ITS ACCURACY BEFORE RELYING ON ANY OTHER PURPOSE.

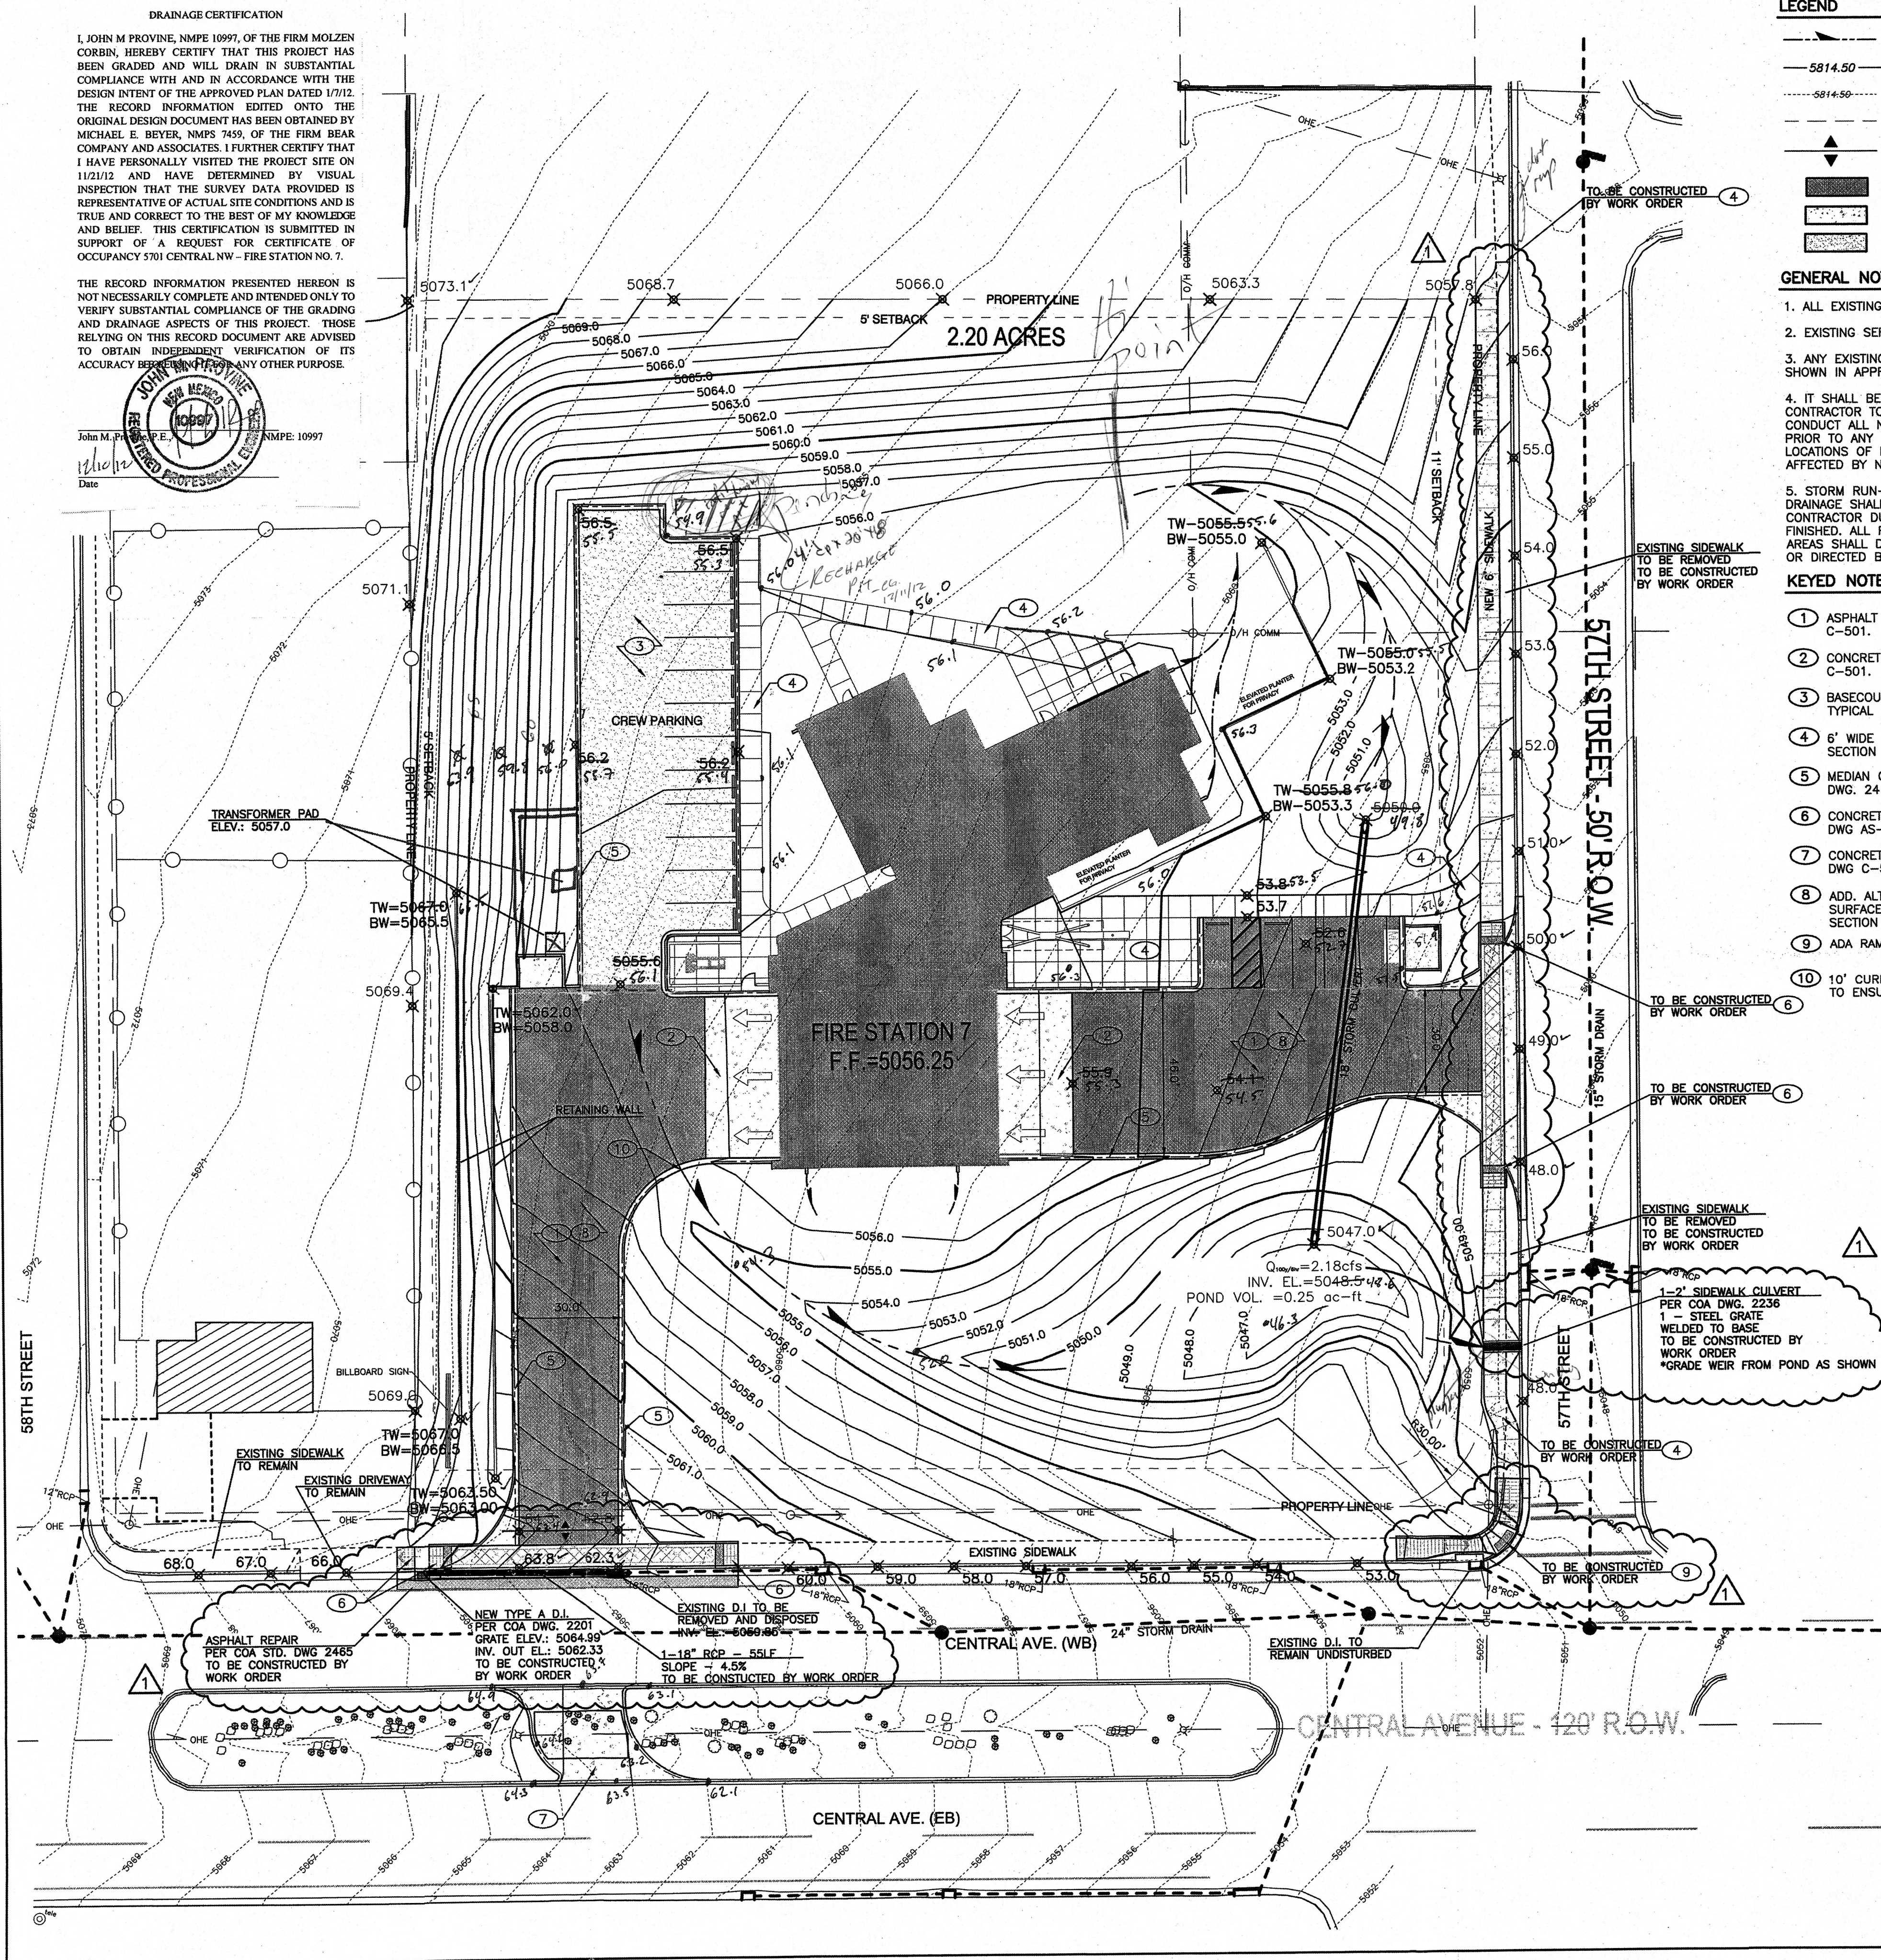

LEGEND

- GRADED FLOWLINE
- NEW TOPOGRAPHIC CONTOUR
- EXISTING TOPOGRAPHIC CONTOUR
- MISC. PROPERTY LINE
- GRADE BREAK (RIDGE)
- NEW ASPHALT
- CONCRETE PAVEMENT
- BASECOURSE PAVEMENT

GENERAL NOTES

- ALL EXISTING UTILITIES MAY NOT BE SHOWN.
- EXISTING SERVICE CONNECTIONS ARE NOT SHOWN.
- ANY EXISTING UTILITIES THAT ARE SHOWN ARE SHOWN IN APPROXIMATE LOCATION ONLY.
- IT SHALL BE THE RESPONSIBILITY OF THE CONTRACTOR TO CONTACT ALL UTILITY OWNERS AND CONDUCT ALL NECESSARY FIELD INVESTIGATIONS PRIOR TO ANY EXCAVATIONS TO DETERMINE ACTUAL LOCATIONS OF EXISTING UTILITIES THAT MAY BE AFFECTED BY NEW CONSTRUCTION.
- STORM RUN-OFF CONVEYANCE AND PROPER DRAINAGE SHALL BE THE RESPONSIBILITY OF CONTRACTOR DURING CONSTRUCTION AND WHEN FINISHED. ALL ROOF DRAINS, CULVERTS AND SLOPED AREAS SHALL DRAIN PROPERLY AS SHOWN ON PLAN OR DIRECTED BY ENGINEER.

KEYED NOTES

- ASPHALT SURFACE. SEE TYPICAL SECTION DWG C-501.
- CONCRETE APRON. SEE TYPICAL SECTION DWG C-501.
- BASECOURSE PAVEMENT PARKING AREA. SEE TYPICAL SECTION DWG C-501.
- 6' WIDE CONCRETE SIDEWALK. SEE TYPICAL SECTION DWG C-501.
- MEDIAN CURB AND GUTTER. PER COA STD. DWG. 2415B.
- CONCRETE DRIVEWAY AND RAMPS. SEE DETAIL DWG AS-501.
- CONCRETE MEDIAN CROSSOVER. SEE DETAILS DWG C-501.
- ADD. ALT. #2 - CONCRETE PAVEMENT SURFACE IN LIEU OF ASPHALT. SEE TYPICAL SECTION DWG C-501.
- ADA RAMP PER COA STD. DWG. 2441.
- 10' CURB CUT TO ALLOW DRAINAGE IN TO POND. CONTRACTOR TO ENSURE CENTER OF CURB IS THE LOW POINT.

HYDROLOGY ANALYSIS

CITY OF ALBUQUERQUE FIRE STATION NO. 7

DRAINAGE ANALYSIS

INTRODUCTION

PURPOSE AND SITE LOCATION

Fire Station No. 7 will be located at the NW corner of Central Ave and 57th St on a 2.24 acre site of predominately undeveloped property. The City of Albuquerque owns the development property.

The existing stormwater discharge flows across the property generally from NW to SE. Off-site flows are generally from the north to the south. Flows from the property enter into 57th St. or Central Ave. and eventually into a 24-inch storm drain located within the westbound lanes of Central Ave.

CRITERIA

The proposed grading and drainage for the development of this site are based on the criteria in the City of Albuquerque Development Process Manual (DPM) Chapter 22. Flow calculations are based on the 100-yr, 6-hr design storm. The area of study was divided into one basin; Basin A-2 is the 2.24-acre Fire Station No. 7 site.

The off-site and on-site flows will be collected through grading and culverts and routed through to a pond. The water collected in the pond will then be discharged over a weir and through a sidewalk culvert into the street where it will be collected by existing curb inlets located on 57th Street.

EXISTING CONDITIONS


The 2.24 acre Fire Station No. 7 site is primarily undeveloped. Basins adjacent to these two basins are fully developed and discharge to adjacent roadways and do not flow through the proposed development. The existing drainage flow for the subject basins travel from north and northwest to south and southeast to 57th St and Central Ave. The discharge from the site enters into the COA operated and maintained storm drainage system in Central Ave.

DEVELOPED CONDITIONS

Off-site flows are maintained with the undeveloped existing conditions in this analysis. The on-site flows have been calculated with fully developed conditions from the proposed site plan. The drainage pond proposed for the southeast quadrant of the site has been sized to retain 100% of the flows on the on-site. The pond will then utilize a weir discharge, calculated to be 2.18cfs, through a sidewalk culvert discharging to 57th Street where existing curb inlets will catch the flow.

EXISTING CONDITIONS		LAND TREATMENT				FLOW (cfs)		VOL (ac ft)	
Basin	Area (ac)	A	B	C	D	Q 100-6	V 100-6		
A-2	2.24	0	0	100	0	6.30	1.80		

DEVELOPED CONDITIONS		LAND TREATMENT				FLOW (cfs)		VOL (ac ft)	
Basin	Area (ac)	A	B	C	D	Q 100-6	V 100-6		
A-2	2.24	0	0	60	40	7.56	.251		

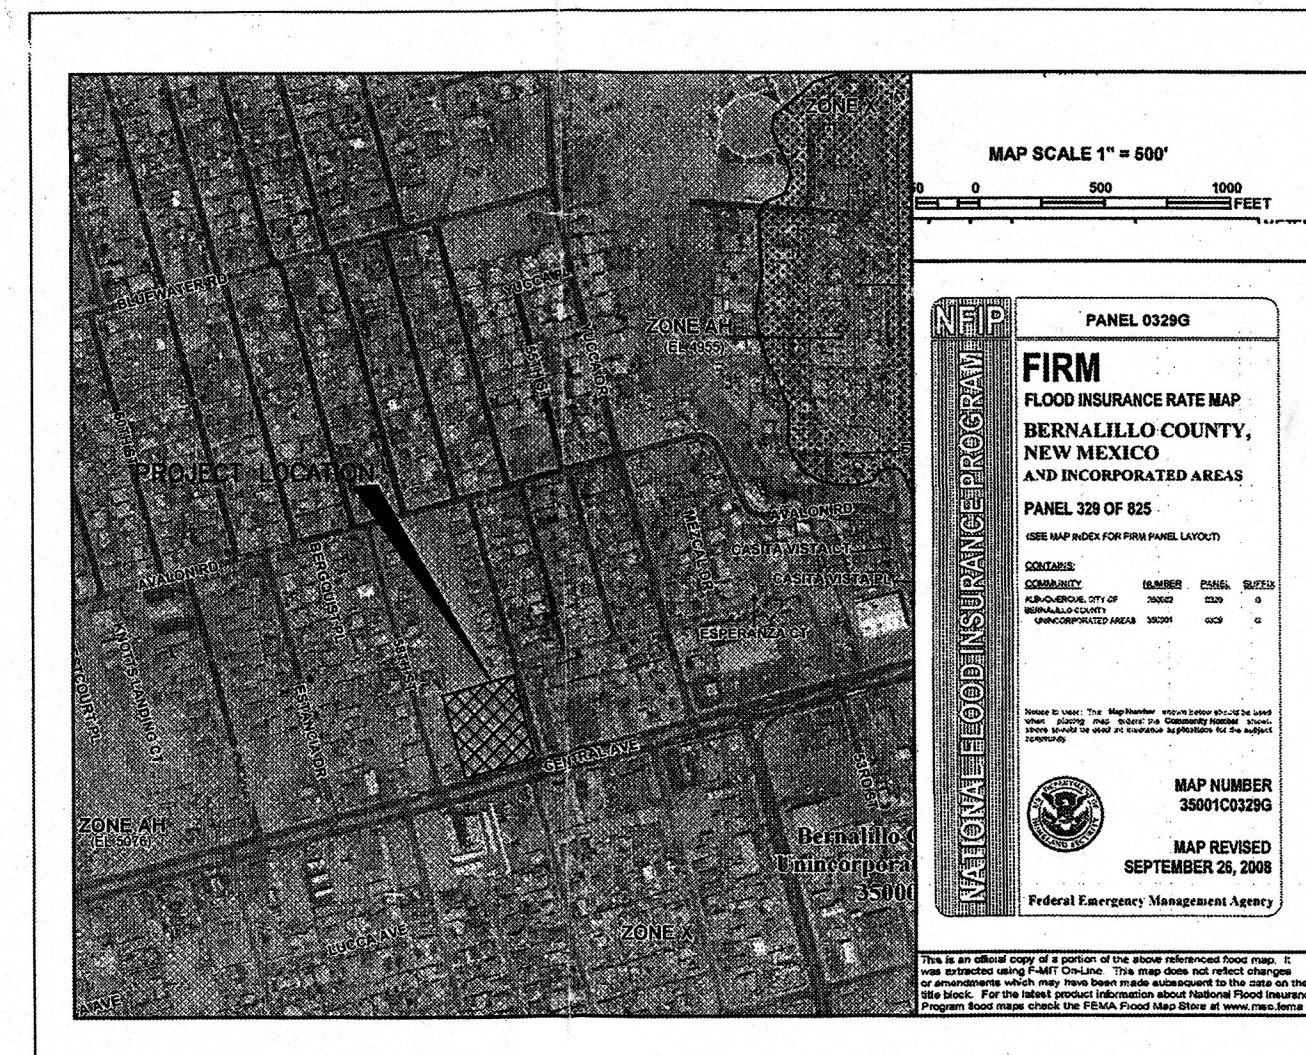

Dekker/Perich/Sabatini
architects • interior • landscape • planning • engineering
7801 Jefferson NE, Suite 100
Albuquerque, NM 87109
505 761-9700
fax 505 761-4323

CITY OF ALBUQUERQUE
CAPITAL IMPLEMENTATION PROGRAM
PROJECT TITLE: FIRE STATION 7
ALBUQUERQUE, NEW MEXICO

DRAWING TITLE: GRADING AND DRAINAGE

Design Review Committee	City Engineer Approval	Mo./Day/Yr.	Mo./Day/Yr.

City Project No.	Zone Map No.	DWG.	Sheet	Of
8006.91	K-11	C-101		

© COPYRIGHT MCA JOB # HERE

RECEIVED
DEC 10 2012
LAND DEVELOPMENT SECTION